


PROJECT NAME :
AMARA STUDIOS

DEVELOPER NAME :
M/S JITENDRA SINGH

ARCHITECTS :
4 INSIDE
ARCHITECTURE N INTERIORS
Plot no. 72, S.P. Marg, C-Scheme
jaipur, rajasthan, India
cont: +91 9950595991, 91 9982812777
e.mail: jeets.arch@gmail.com

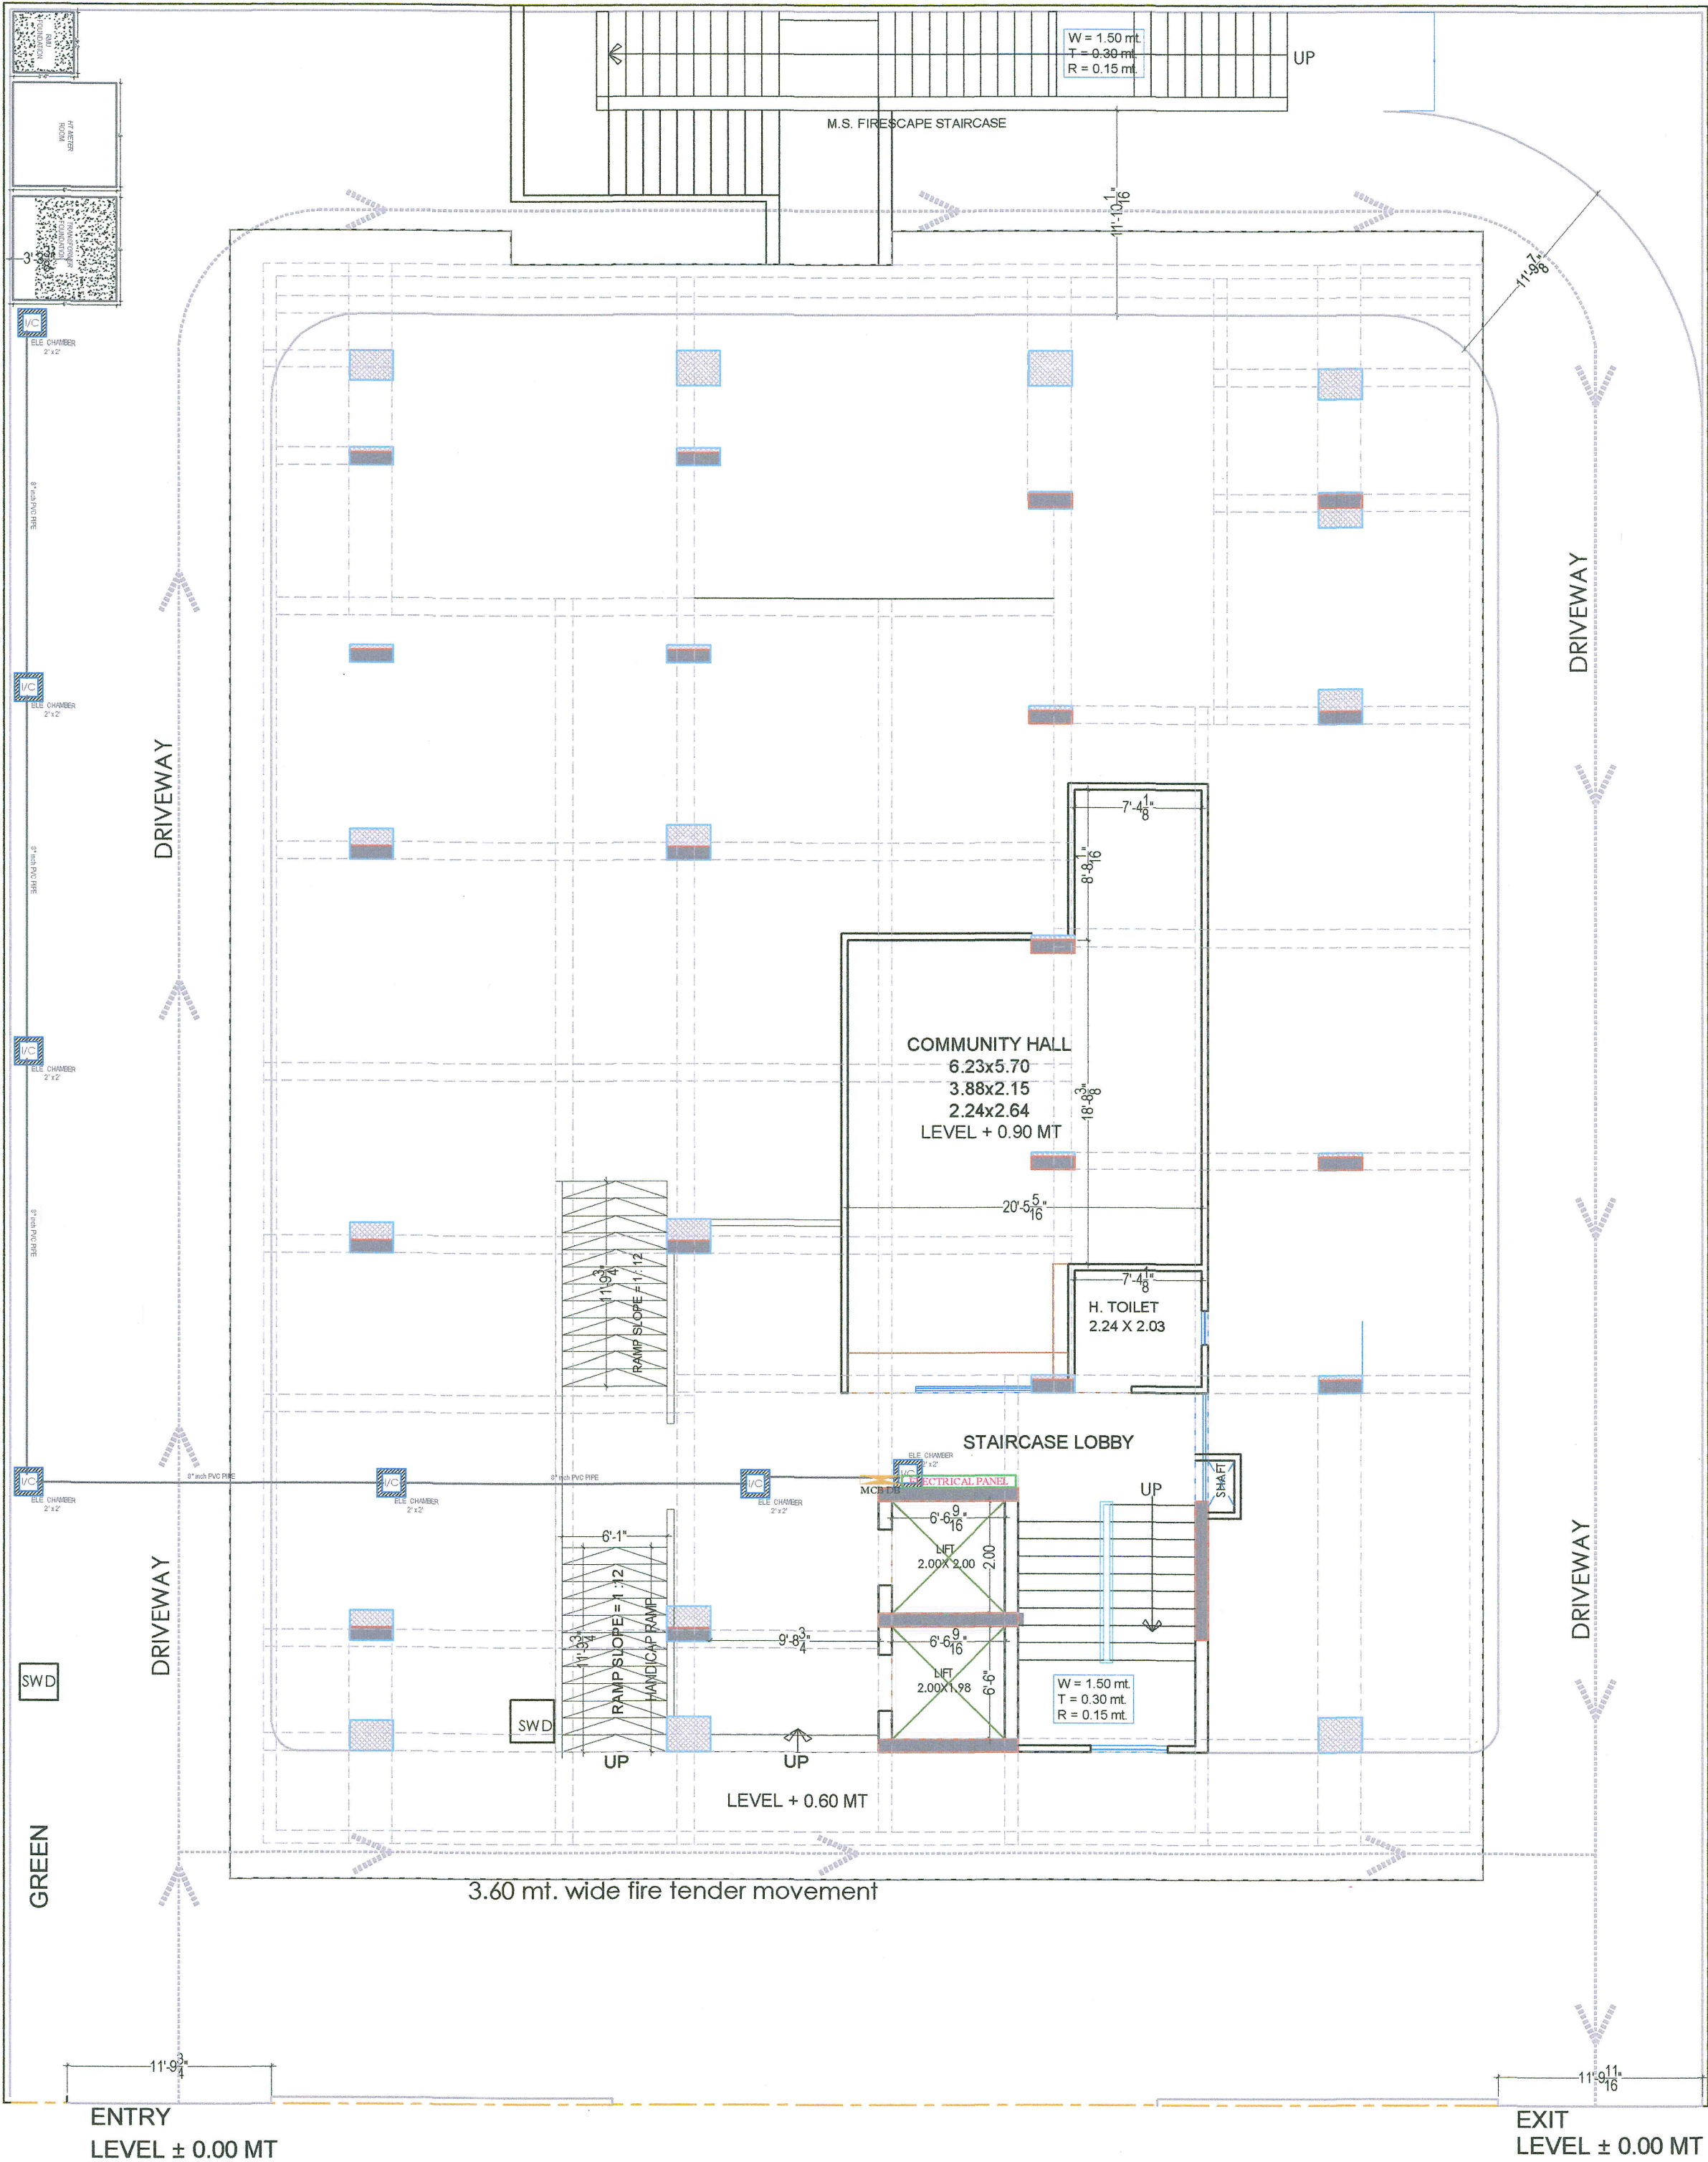

LEGENDS:			
Mounting Height	ID	Symbol	Description
CEILING	FAN4W		CEILING FAN 4W
CEILING	FAN3W		CEILING FAN 3W
CEILING	CH		CHANDLIER
+93"	TLW		1x1 1/2" Toggle Light
+93"	BULB		1x1 1/2" Bulb 20W
+93"	GL		WALL BRACKET AS DESIGN FOR QUARTER LIGHT
+78"	ML		12x2 Led Mirror Light
CEILING	DL		1x1 1/2" Down Light 20W (Surface Mounting)
VENTILATOR	CR		CEILING ROSE
VENTILATOR	EXP		1" DIA. FRESH AIR FAN
+24"	2WGB		2W SWITCH BOARD
+42"	SB		SWITCH BOARD/6A SOCKET & SWITCH
+24"	TEL		TELEPHONE POINT
+24"	LP TEL		6A PLUG POINT FOR TELEPHONE POINT
+48"	TV		TV COAXIAL POINT
+48"	LP TV		6A PLUG POINT FOR TV
+24"	LP		6A PLUG POINT FOR SIDE TABLE
+72"	LP CH		6A PLUG POINT FOR CHAIR
+12"	LP PC		6A PLUG FOR COMPUTER POINT
+93"	SAC		1x1 1/2" AC INDOOR UNIT
+42"	PP-MDC		16A POWER POINT FOR MIXER
+42"	PP-MD2		16A POWER POINT FOR MICROWAVE
+78"	PP-G		16A POWER POINT FOR GREYER
+54"	PP-F		16A POWER POINT FOR Fridge
+78"	PP-WP		16A POWER POINT FOR WATER PUMP
+48"	PP-WM		16A POWER POINT FOR WASHING MACHINE
+12"	PP-INV		16A POWER POINT FOR INVERTER
+93"	PP-AC		25A SWITCHES FOR AC
			CHAMBER (X 2)
+18"			6A SOCKET (6A) 1/2" DIA. 1/2" DIA. TELEPHONE/PLAN
+60"	MCD-DB		MCD DISTRIBUTION BOARD
			CAMERA
			WALL FAN
BSS			6A SIS FAN REGULATOR, TL SWITCH
BAC			6A SIS 25 A AC

PROJECT:
PROPOSED STUDIO APARTMENT ON PLOT NO. - G-13-E, IN SCHEME - WEST WAY HEIGHTS, JAIPUR.

NAME OF DRAWING:
STILT FLOOR ELECTRICAL ROUTE LAYOUT (TRANSFORMER, RMU, METER PANEL, ELECTRICAL CABLE)

DRAWING WORKING DRAWING	NORTH:
PROJECT NO.:	DATE: 07-01-2025
SCALE: NTS	REV NO.: R-0
DRAWING NO.:	
PROJECT	CATEGORY
BOOK	FLOOR
TYPE	NAME

PROJECT NAME :


AMARA STUDIOS

DEVELOPER NAME :

M/S JITENDRA SINGH

ARCHITECTS :

4 INSIDE
ARCHITECTURE N INTERIORS
Plot no. 72, S.P. Marg, C-Scheme
jaipur, rajasthan, India
cont: +91 9950595991, 91 9982812777
e.mail: jeets.arch@gmail.com

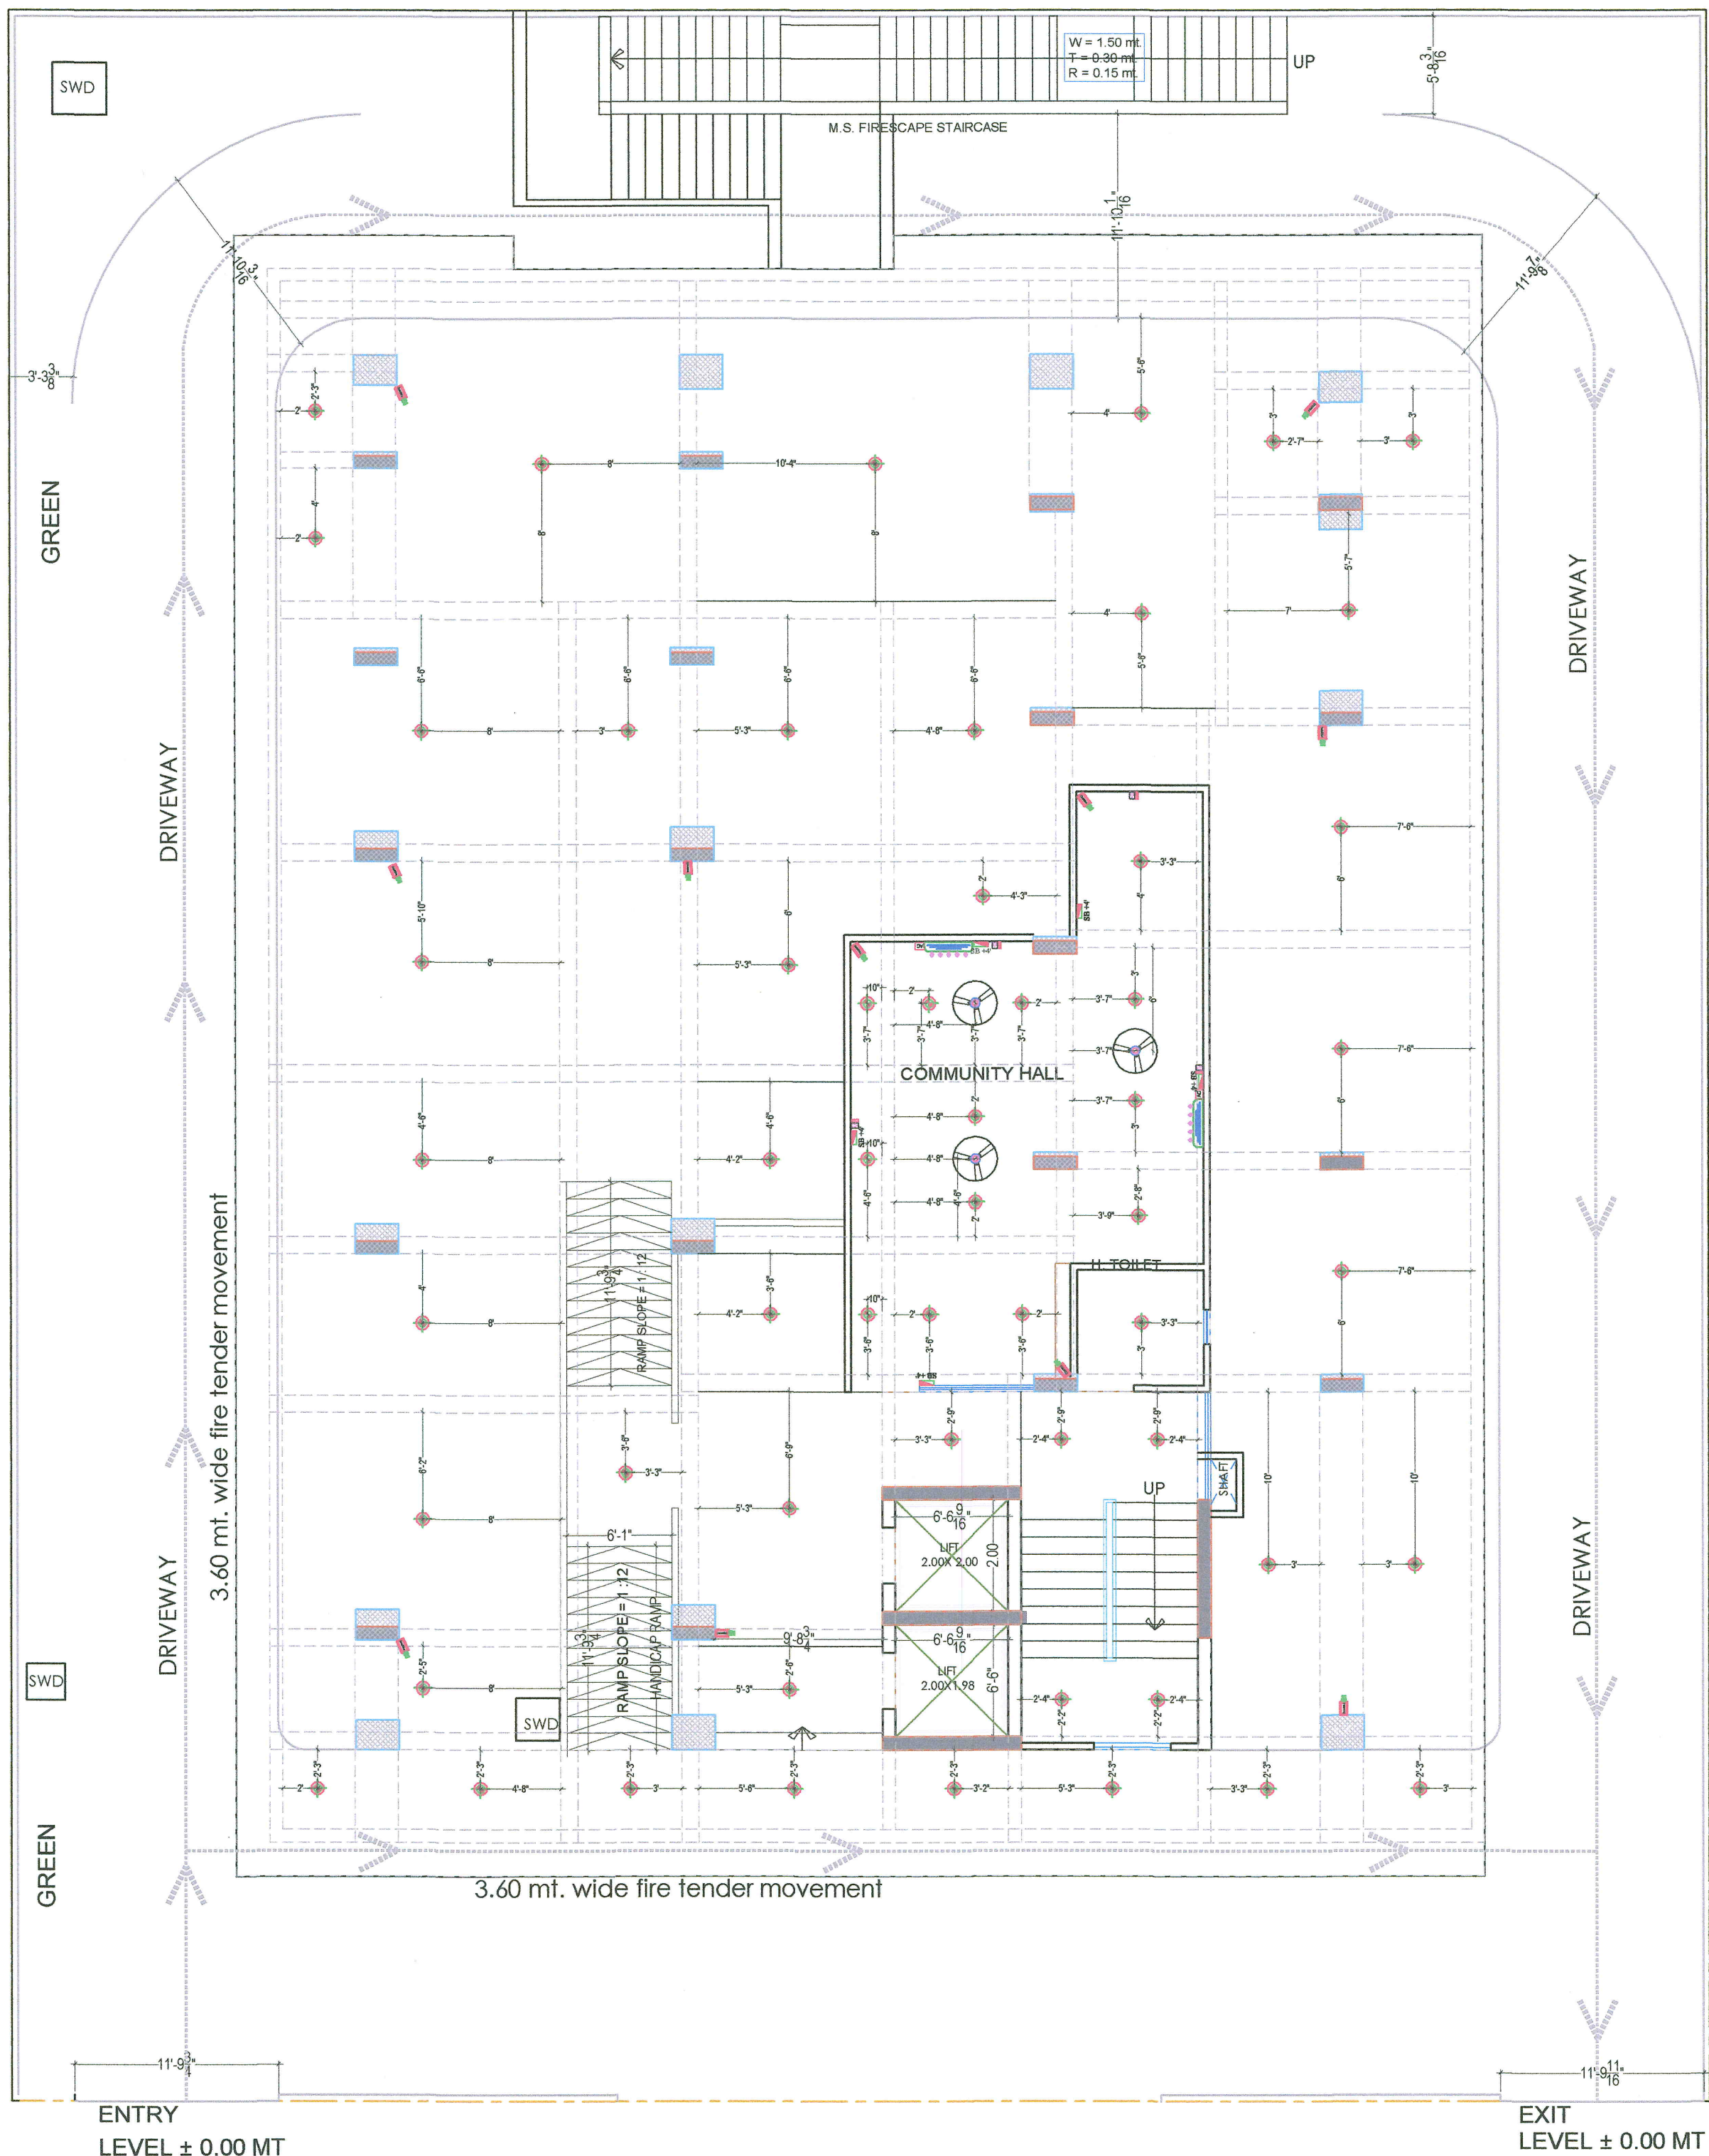

LEGENDS:			
Meaning	ID	Symbol	Description
CEILING FAN 4P	CEILING FAN 4P		CEILING FAN 4P
CEILING FAN 3P	CEILING FAN 3P		CEILING FAN 3P
CHANCELLER	CHANCELLER		CHANCELLER
1st Wall Tube Light	1st Wall Tube Light		1st Wall Tube Light
1st Bath 20W	1st Bath 20W		1st Bath 20W
WALL BRACKETS AS DESIGN FOR GANESH LIGHT	WALL BRACKETS AS DESIGN FOR GANESH LIGHT		WALL BRACKETS AS DESIGN FOR GANESH LIGHT
1200 Led Mirror Light	1200 Led Mirror Light		1200 Led Mirror Light
1st 6" Down Light 20W (Surface Mounting)	1st 6" Down Light 20W (Surface Mounting)		1st 6" Down Light 20W (Surface Mounting)
CEILING 3000	CEILING 3000		CEILING 3000
9" DIA. FRESH AIR FAN	9" DIA. FRESH AIR FAN		9" DIA. FRESH AIR FAN
2W SWITCH BOARD	2W SWITCH BOARD		2W SWITCH BOARD
SWITCH BOARD (GA SOCKET & SWITCH)	SWITCH BOARD (GA SOCKET & SWITCH)		SWITCH BOARD (GA SOCKET & SWITCH)
TELEPHONE POINT	TELEPHONE POINT		TELEPHONE POINT
6A PLUG POINT FOR TELEPHONE	6A PLUG POINT FOR TELEPHONE		6A PLUG POINT FOR TELEPHONE
TV COAXIAL POINT	TV COAXIAL POINT		TV COAXIAL POINT
6A PLUG POINT FOR TV	6A PLUG POINT FOR TV		6A PLUG POINT FOR TV
6A PLUG POINT FOR BEDTABLE	6A PLUG POINT FOR BEDTABLE		6A PLUG POINT FOR BEDTABLE
6A PLUG POINT FOR CHAIR	6A PLUG POINT FOR CHAIR		6A PLUG POINT FOR CHAIR
6A PLUG FOR COMPUTER POINT	6A PLUG FOR COMPUTER POINT		6A PLUG FOR COMPUTER POINT
SPLIT AC INDOOR UNIT	SPLIT AC INDOOR UNIT		SPLIT AC INDOOR UNIT
16A POWER POINT FOR MIXER	16A POWER POINT FOR MIXER		16A POWER POINT FOR MIXER
16A POWER POINT FOR Fridge	16A POWER POINT FOR Fridge		16A POWER POINT FOR Fridge
16A POWER POINT FOR WASHING MACHINE	16A POWER POINT FOR WASHING MACHINE		16A POWER POINT FOR WASHING MACHINE
16A POWER POINT FOR WASHING MACHINE	16A POWER POINT FOR WASHING MACHINE		16A POWER POINT FOR WASHING MACHINE
25A SWITCHES FOR AC	25A SWITCHES FOR AC		25A SWITCHES FOR AC
CHAMBER (2 X 2)	CHAMBER (2 X 2)		CHAMBER (2 X 2)
6A 3P05 SOCKET + 16A 3P05 SOCKET + 16A 3P05 SOCKET	6A 3P05 SOCKET + 16A 3P05 SOCKET + 16A 3P05 SOCKET		6A 3P05 SOCKET + 16A 3P05 SOCKET + 16A 3P05 SOCKET
MCB DB	MCB DB		MCB DB
CAMERA	CAMERA		CAMERA
WALL FAN	WALL FAN		WALL FAN
BSB	BSB		6A 3P05 FAN REGULATOR TL SWITCH
BAC	BAC		6A 3P05 A/C

PROPOSED STUDIO APARTMENT ON PLOT NO. - G-13-E, IN SCHEME - WEST WAY HEIGHTS, JAIPUR.

STILT FLOOR
CEILING ELECTRICAL LAYOUT,
ELECTRICAL POINT DRAWING,
CAMERA POINT DRAWING

DRAWING		NORTH:				
WORKING DRAWING						
PROJECT NO. :		DATE :				
		07-01-2025				
SCALE :		REV. NO. :				
NTS		R-0				
DRAWING NO. :						
<div></div>	<div></div>	<div></div>	<div></div>	<div></div>	<div></div>	<div></div>
PROJECT	CATEGORY	BLOCK	FLOOR	TYPE	NUM	
A-01						

STILT FLOOR CEILING ELECTRICAL LAYOUT, ELECTRICAL POINT DRAWING, CAMERA POINT DRAWING

AMARA STUDIOS

M/S JITENDRA SINGH

4 INSIDE

ARCHITECTURE N INTERIORS
Plot no. 72, S.P. Marg , C- Scheme
jaipur, rajasthan, India
cont: +91 9950595991 , 91 9982812777
e.mail: jeets.arch@gmail.com

LEGENDS:			
Mounting Height	ID	Symbol	Description
CEILING	FAN4M		CEILING FAN 4M
CEILING	FAN3M		CEILING FAN 3M
CEILING	CH		CHANDLER
+93"	TLW		LED Wall Tube Light
+93"	BULS		LED Bulb 20W
+93"	GL		WALL BRACKET AS DESIGN FOR GARNISH LIGHT
+78"	ML		12x2 LED Mirror Light
CEILING	DL		6" Ø Down Light 20W (Surface Mount)
VENTILATOR HT	CL		CEILING ROOF
VENTILATOR HT	EXF		2" DIA FRESH AIR FAN
+24"	2W6B		2W6B SWITCH BOARD
+42"	SB		SWITCH BOARD/AS SOCIETY & SERVICE
+24"	TL		TELEPHONE POINT
+24"	LP TEL		6A PLUG POINT FOR TELEPHONE
+48"	TV		TV COAXIAL POINT
+48"	FTV		6A PLUG POINT FOR TV
+24"	LP		6A PLUG POINT FOR SIDE TABLE
+72"	LP OH		6A PLUG POINT FOR CHAIR
+12"	LP PC		6A PLUG FOR COMPUTER POINT
+93"	SAC		SPLIT AC INDOOR UNIT
+42"	PP-MK		16A POWER POINT FOR MIXER
+42"	PP-MG		16A POWER POINT FOR MICROWAVE
+78"	PP-G		16A POWER POINT FOR GETTER
+54"	PP-F		16A POWER POINT FOR Fridge
+78"	PP-W		16A POWER POINT FOR WATER PURIFIER
+48"	PP-VM		16A POWER POINT FOR VENDING MACHINE
+12"	PP-INV		16A POWER POINT FOR INVERTER
+93"	PP-AC		25A SWITCH BOARD FOR AC
			CEMAREZ (X 2)
+18"			16A PINCH SOCKET + HOSE
+60"	MCS DB		MCS DISTRIBUTION BOARD
			CAMERA
			WALL PAN

PROPOSED STUDIO APARTMENT ON
PLOT NO. - G-13-E, IN SCHEME - WEST
WAY HEIGHTS, JAIPUR.

**TYPICAL FLOOR
ELECTRICAL LAYOUT G+7TH
(ELECTRICAL POINT,
CEILING POINT,TV)**

DRAWING		NORTH:	
WORKING DRAWING			
PROJECT NO.:		DATE:	
		07-01-2025	
SCALE:		REV. NO.:	
NTS		R-0	
DRAWING NO.:			
<input type="text"/>	<input type="text"/>	<input type="text"/>	<input type="text"/>
PROJECT	CATEGORY	BLOCK	FLOOR
A-01			

**TYPICAL FLOOR ELECTRICAL LAYOUT (GROUND TO 7TH.)
(ELECTRICAL POINT,CEILING POINT,TV, TELEPHON & AC)**

PROJECT NAME :

AMARA STUDIOS

DEVELOPER NAME :

M/S JITENDRA SINGH

ARCHITECTS :

4 INSIDE


ARCHITECTURE N INTERIORS

Plot no. 72, S.P. Marg , C-Scheme

jaipur, rajasthan, India

cont: +91 9950595991 , 91 9982812777
e mail: joets.arch@gmail.com

e.mail: jeets.arch@gmail.com

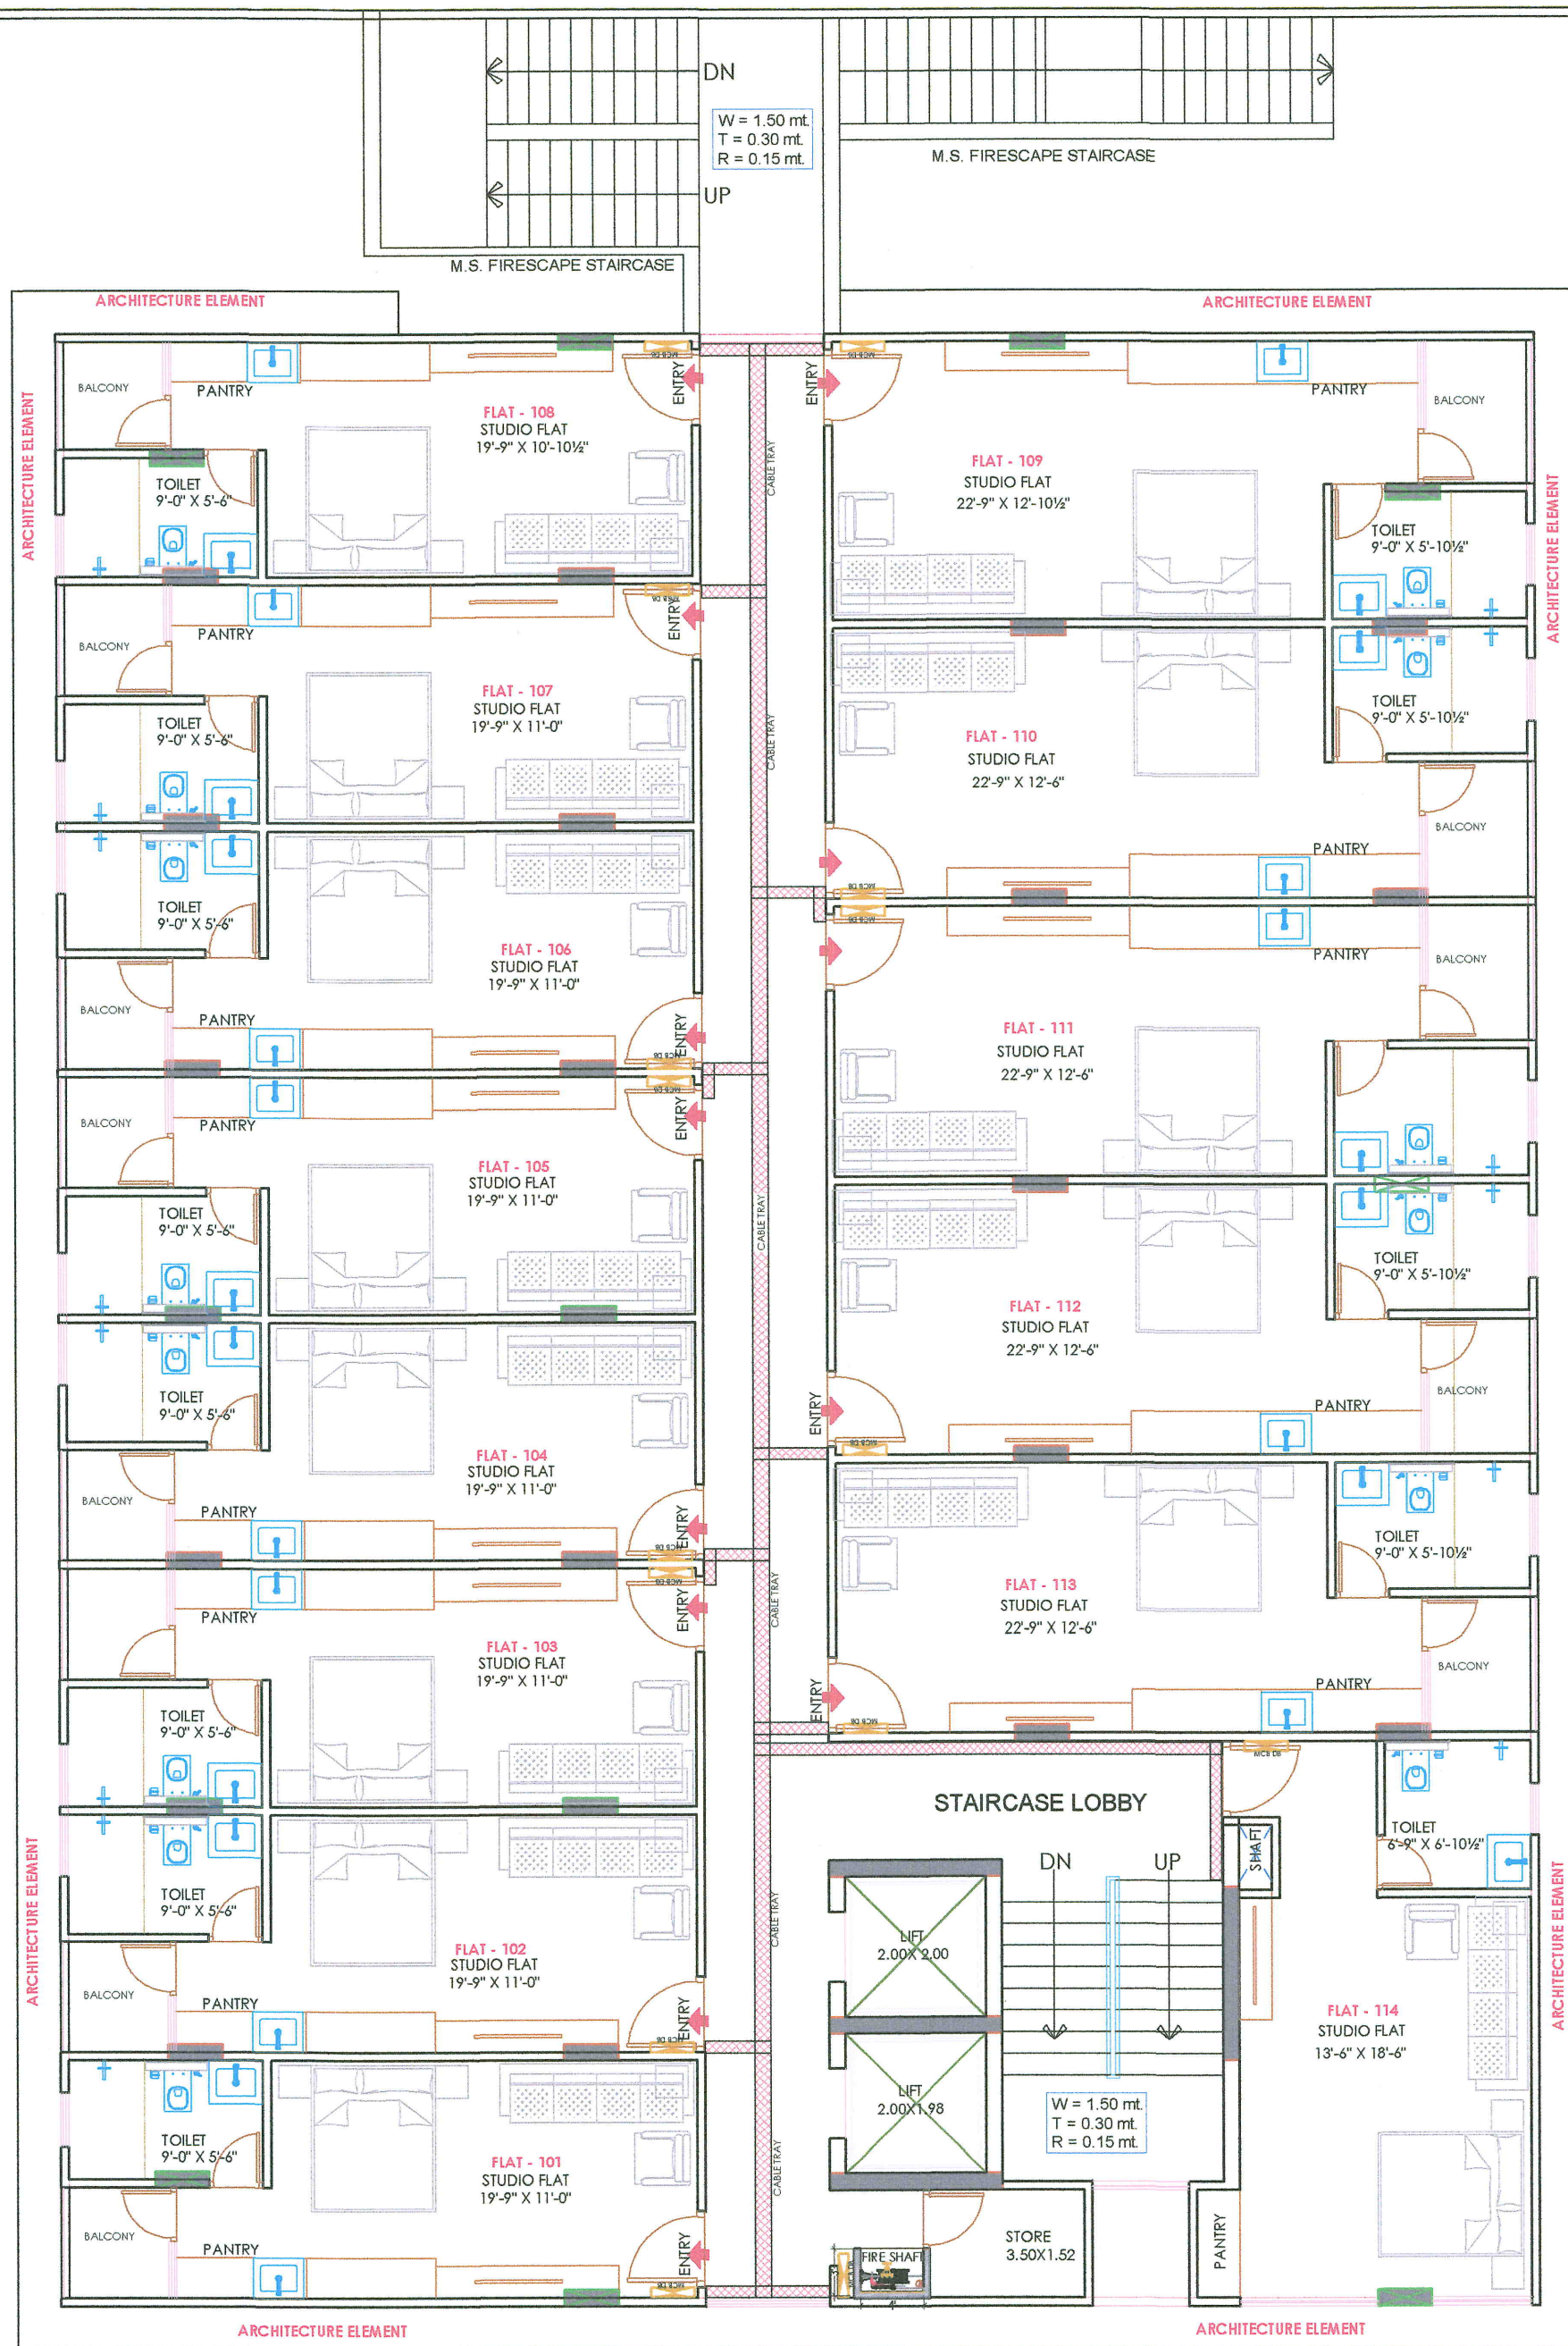

← 24.0 MT. MAIN WIDE ROAD →

Er. Sanjeev Sharma
B.E. (Electrical)

**TYPICAL FLOOR ELECTRICAL LAYOUT(GROUND TO 7TH.)
(ELECTRICAL CABLES,ELECTRICAL DB, ELECTRICAL SHAFT, CABLE TRAY)**

LEGENDS:

Mounting Height	ID	Symbol	Description
CEILING	FAN49		CEILING FAN 49"
CEILING	FAN30		CEILING FAN 30"
CEILING	CH1		CHandelier
+93"	TLW		Let Wall Tube Light
+93"	BSL		1-60 Bath 20W
+93"	GL		WALL BRACKETED AN DESIGN FOR CHAIRMAN LIGHT
+78"	ML		12x12 Led Mirror Light
CEILING	DL		Led 6 Down Light 20W (Surfex Mount)
VENTILATOR HT	GR		CEILING ROSE
VENTILATOR HT	EXG		P DIA FRESH AIR FAN
+24"	2wB		2-WIRELESS BOARD
+42"	SB		SWITCH BOARD(6A SOCKET & SWITCH)
+24"	TSL		TELEPHONE POINT
+24"	LPTEL		6A PLUG POINT FOR TELEPHONE
+68"	TV		TV COAXIAL POINT
+68"	LPTV		6A PLUG POINT FOR TV
+24"	HT		6A PLUG POINT FOR SIDE TABLE
+72"	LC-CH		6A PLUG POINT FOR CABLETV
+12"	LP PC		6A PLUG FOR COMPUTER POINT
+93"	SAC		SPILT AC INDOOR UNIT
+42"	PM-MEX		16A POWER POINT FOR MEXER
+42"	PM-MAG		16A POWER POINT FOR MAGNETRON
+78"	PM-OT		16A POWER POINT FOR OTHER
+54"	PM-FR		16A POWER POINT FOR FREEZER
+78"	PM-FW		16A POWER POINT FOR WASHING MACHINE
+48"	PM-WM		16A POWER POINT FOR WASHING MACHINE
+12"	PM-DIV		16A POWER POINT FOR DIVERTER
+93"	PM-AC		25A SWITCHBOARD FOR AC
			IC CARD (COMBID 2 X 2)
+18"			GAS VALVE SOCKET + 1/2" GAS VALVE CO. TELEFERRON
+60"	MCB DB		MCB DISTRIBUTION BOARD
			CAMERA
			WALL FAN
BSB	6A 9S FAN REGULATOR, LT, SWITCH		
BAC	6A 9S 2S A AC		

PROJECT:

PROPOSED STUDIO APARTMENT ON
PLOT NO. - G-13-E, IN SCHEME - WEST
WAY HEIGHTS, JAIPUR.

NAME OF DRAWING:

**TYPICAL FLOOR ELECTRICAL
LAYOUT (GROUND TO 7TH.)
(ELECTRICAL CABLES,
ELECTRICAL DB,
ELECTRICAL SHAFT, CABLE TRAY)**

DRAWING	NORTH:				
WORKING DRAWING					
PROJECT NO. :	DATE:				
	07-01-2025				
SCALE:	REV/NO. :				
NTS	R-0				
DRAWING NO. :					
☐ PROJECT	☐ CATEGORY	☐ BLOCK	☐ FLOOR	☐ TYPE	☐ NUMBER
A-01					

PROJECT NAME :

AMARA STUDIOS

DEVELOPER NAME :

M/S JITENDRA SINGH

ARCHITECTS :

4 INSIDE

ARCHITECTURE N INTERIORS

Plot no. 72, S.P. Marg, C-Scheme

jaipur, rajasthan, India

cont: +91 9950595991, 91 9982812777

e.mail: jeets.arch@gmail.com

LEGENDS:

Mounting Height	ID	Symbol	Description
CEILING	FAN48"		CEILING FAN 48"
CEILING	FAN30"		CEILING FAN 30"
CEILING	CHI		CHANDELIER
+93"	TLW		1 Led Wall Tube Light
+93"	BULB		1 Led Bulb 20W
+93"	GL		WALL BRACKETS AS DESIGN FOR GANESH LIGHT
+78"	ML		1x2 Led Mirror Light
CEILING	DL		1 Led 6" Down Lighter 20W (Surface Mounted)
VENTILATOR HT.	CR		CEILING ROSE
VENTILATOR HT.	EXF		9" DIA FRESH AIR FAN
+24"	2wSB		2w SWITCH BOARD
+42"	SB		SWITCH BOARD(6A SOCKET & SWITCH)
+24"	TEL		TELEPHONE POINT
+24"	LP TEL		6 A PLUG POINT FOR TELEPHONE
+48"	TV		TV COAXIAL POINT
+48"	LP TV		6 A PLUG POINT FOR TV
+24"	LP		6 A PLUG POINT FOR SIDE TABLE
+72"	LP-CH		6 A PLUG POINT FOR CHIMNEY
+12"	LP-PC		6 A PLUG FOR COMPUTER POINT
+93"	SAC		SPLIT AC INDOOR UNIT
+42"	PP-MIX		16 A POWER POINT FOR MIXER
+42"	PP-MIC		16 A POWER POINT FOR MICROWAVE
+78"	PP-G		16 A POWER POINT FOR GEYSER
+54"	PP-F		16 A POWER POINT FOR FRIDGE
+78"	PP-WP		16 A POWER POINT FOR WATER PURIFIER
+48"	PP-WM		16 A POWER POINT FOR WASHING MACHINE
+12"	PP-INV.		16 A POWER POINT FOR INVERTER
+93"	PP-AC		25A SWITCH/ICB FOR AC
			CHAMBER(2' X 2')
+18"			6A 2 NOS. SOCKET + 1 NOS. 16A SWITCH, TELEPHONE/JAN
+60"	MCB DB		MCB DISTRIBUTION BOARD
			CAMERA
			WALL FAN

BSB 6A S/S, FAN REGULATOR, TL SWITCH

BAC 6A S/S, 25 AAC

PROJECT:

PROPOSED STUDIO APARTMENT ON PLOT NO. - G-13-E, IN SCHEME - WEST WAY HEIGHTS, JAIPUR.

NAME OF DRAWING:

SINGLE LINE DIAGRAM(SLD)

DRAWING	NORTH:
WORKING DRAWING	
PROJECT NO.:	DATE:
	07-01-2025
SCALE:	REV NO.:
NTS	R-0
DRAWING NO.:	
PROJECT	CATEGORY
	BLOCK
	FLOOR
	TYPE
	NUMBER
A-01	

