


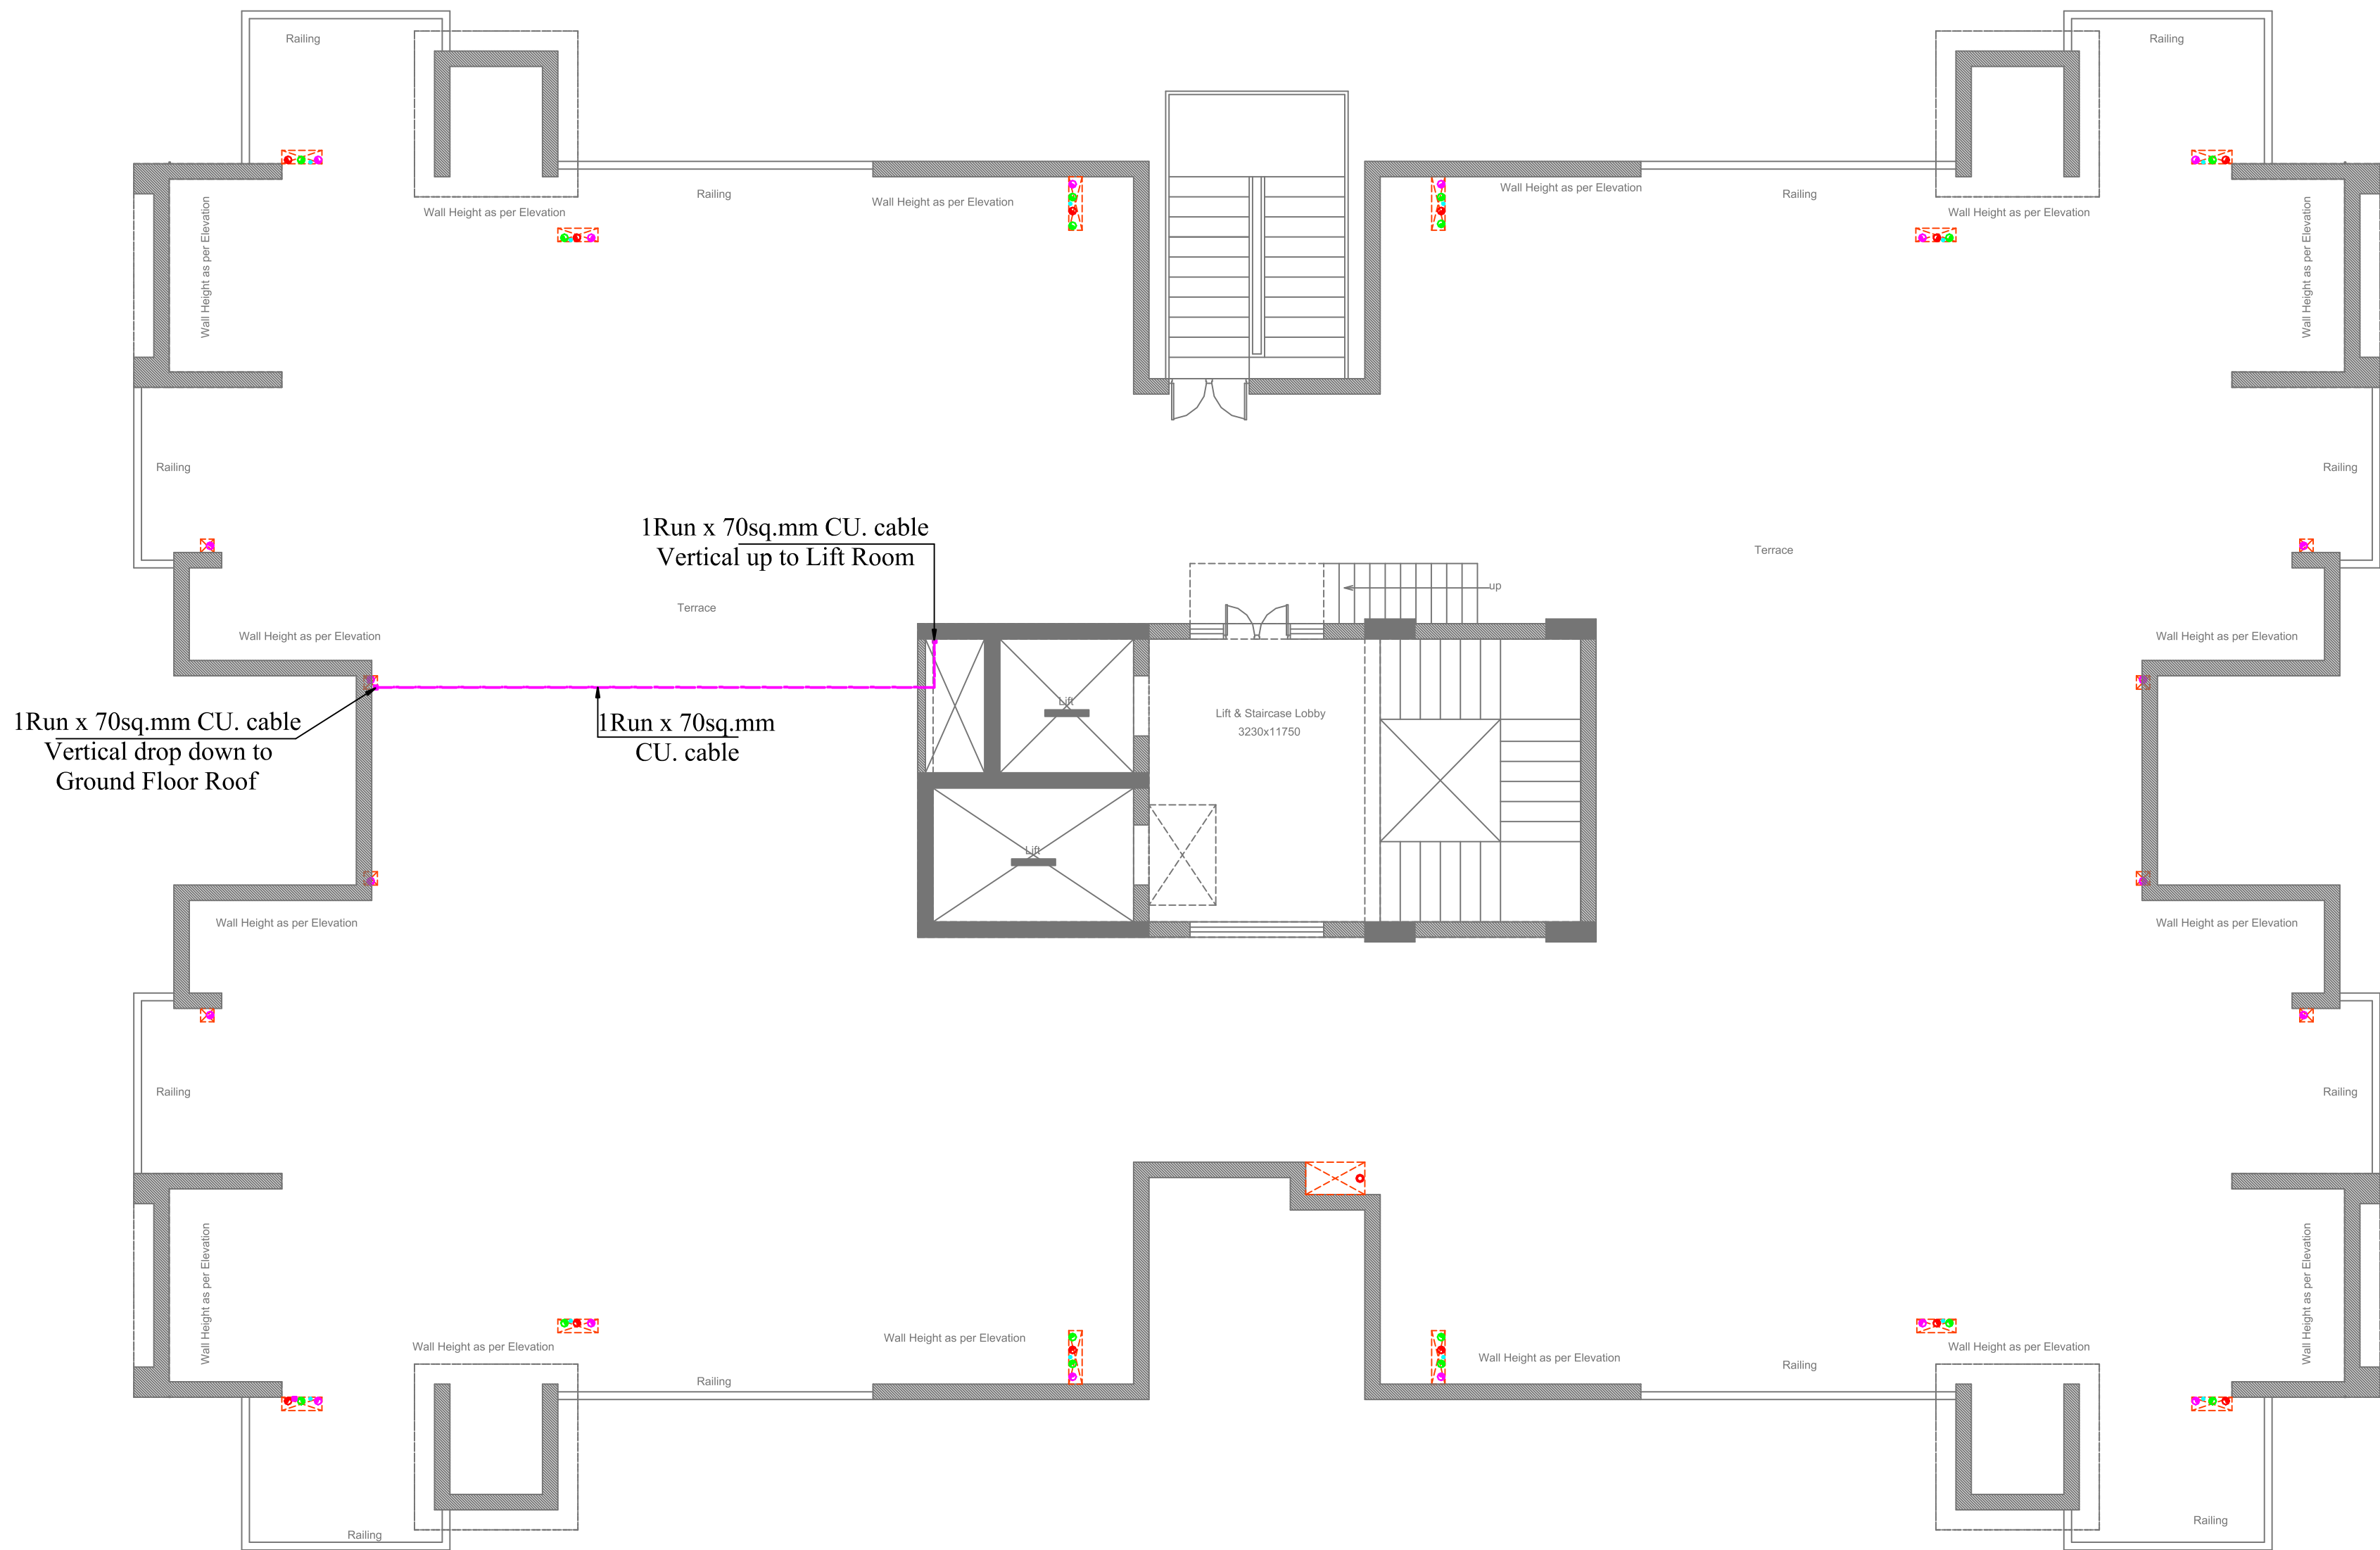

Terrace Floor Plan (BLOCK-A)

<div><div>Space wizard</div><div>SPACE WIZARD ARCHITECTS PVT. LTD. 301, apcon chamber, 1st kothi commercial complex, tonk road, jaipur. PH_NO. - 0141-2740520, 9413340890,91, e-mail: studio.swa@gmail.com website: www.spacewizard.in</div></div> <div>THIS DRAWING IS THE PROPERTY OF SPACE WIZARD ARCHITECTS PVT. LTD. IT SHALL NOT BE COPIED OR USED WITHOUT THEIR WRITTEN PERMISSION NOR MADE KNOWN TO A THIRD PARTY. THE INFORMATION IS ISSUED ON THE UNDERSTANDING THAT NO PART THEREOF SHALL BE DUPLICATED FOR THE PURPOSE OTHER THAN THE EXPRESSED PURPOSE.</div>	SERVICES CONS.	VIPUL CONSULTING, F 9 / 440 , Keshav Marg Chitrakut Scheme,Jaipur PH:91-0-93146-10438, 0141-2740946 Mail:vipul8599@yahoo.com REV. NO. 000 DATE: 22-1-16	GENERAL NOTES	S.N.	DATE	DETAILS	SCALE	CLIENT: Rajasthan Housing Board	
	STRUCTURAL CONS.		1. ALL DIMENSION ON THIS DRAWING ARE IN MM 2. ONLY WRITTEN DIMENSIONS ARE TO BE FOLLOWED .DRAWING SHOULD NOT BE SCALED UNDER ANY CIRCUMSTANCES. 3. ALL MEASUREMENTS MUST BE CHECKED AND VERIFIED BY THE CONTRACTORS PRIOR TO EXECUTION OF WORK AT THE SITE. 4. THIS DRAWING IS TO BE READ IN CONJUNCTION WITH ALL RELEVANT STRUCTURAL, SERVICES & FACILITY PLANNING DRAWINGS. 5. ARCHITECTURAL DRAWINGS ARE TO BE FOLLOWED FOR THE LOCATION OF ALL STRUCTURAL MEMBERS & MASONRY WALLS. 6. ANY DISCREPANCIES BETWEEN ARCHITECTURAL, STRUCTURAL AND SERVICES DRAWINGS MUST BE BROUGHT TO THE NOTICE OF THE ARCHITECTS IMMEDIATELY & PRIOR TO EXECUTION AT SITE. 7. CO-ORDINATION WITH SERVICES SUCH AS HVAC, PLUMBING & ELECTRICAL, ETC. IS THE RESPONSIBILITY OF THE CONTRACTORS. 8. ALL MASONRY WALLS SHOULD BE ALIGNED WITH THE COLUMNS AS INDICATED ON THE PLAN, IRRESPECTIVE OF THE POSITION AS CALCULATED WITH THE DIMENSIONING.	R0			NORTH 	PROJECT: HIG, New Sanganer Road, Mansarovar, Jaipur.	DATE : 22-1-16
				R1					PROJECT NO. :
				R2					SWAPL / 2013 /104
				R3					DRG. NO. : SF/GL/1
				R4			DRN. VIJESH	DRAWING: BLOCK-A TERRACE FLOOR LIGHTNING ARRESTER CABLE ROUTE PLAN	
				R5			CHD. SANJAY		
				R6			APPD. VIPUL AGARWAL		