


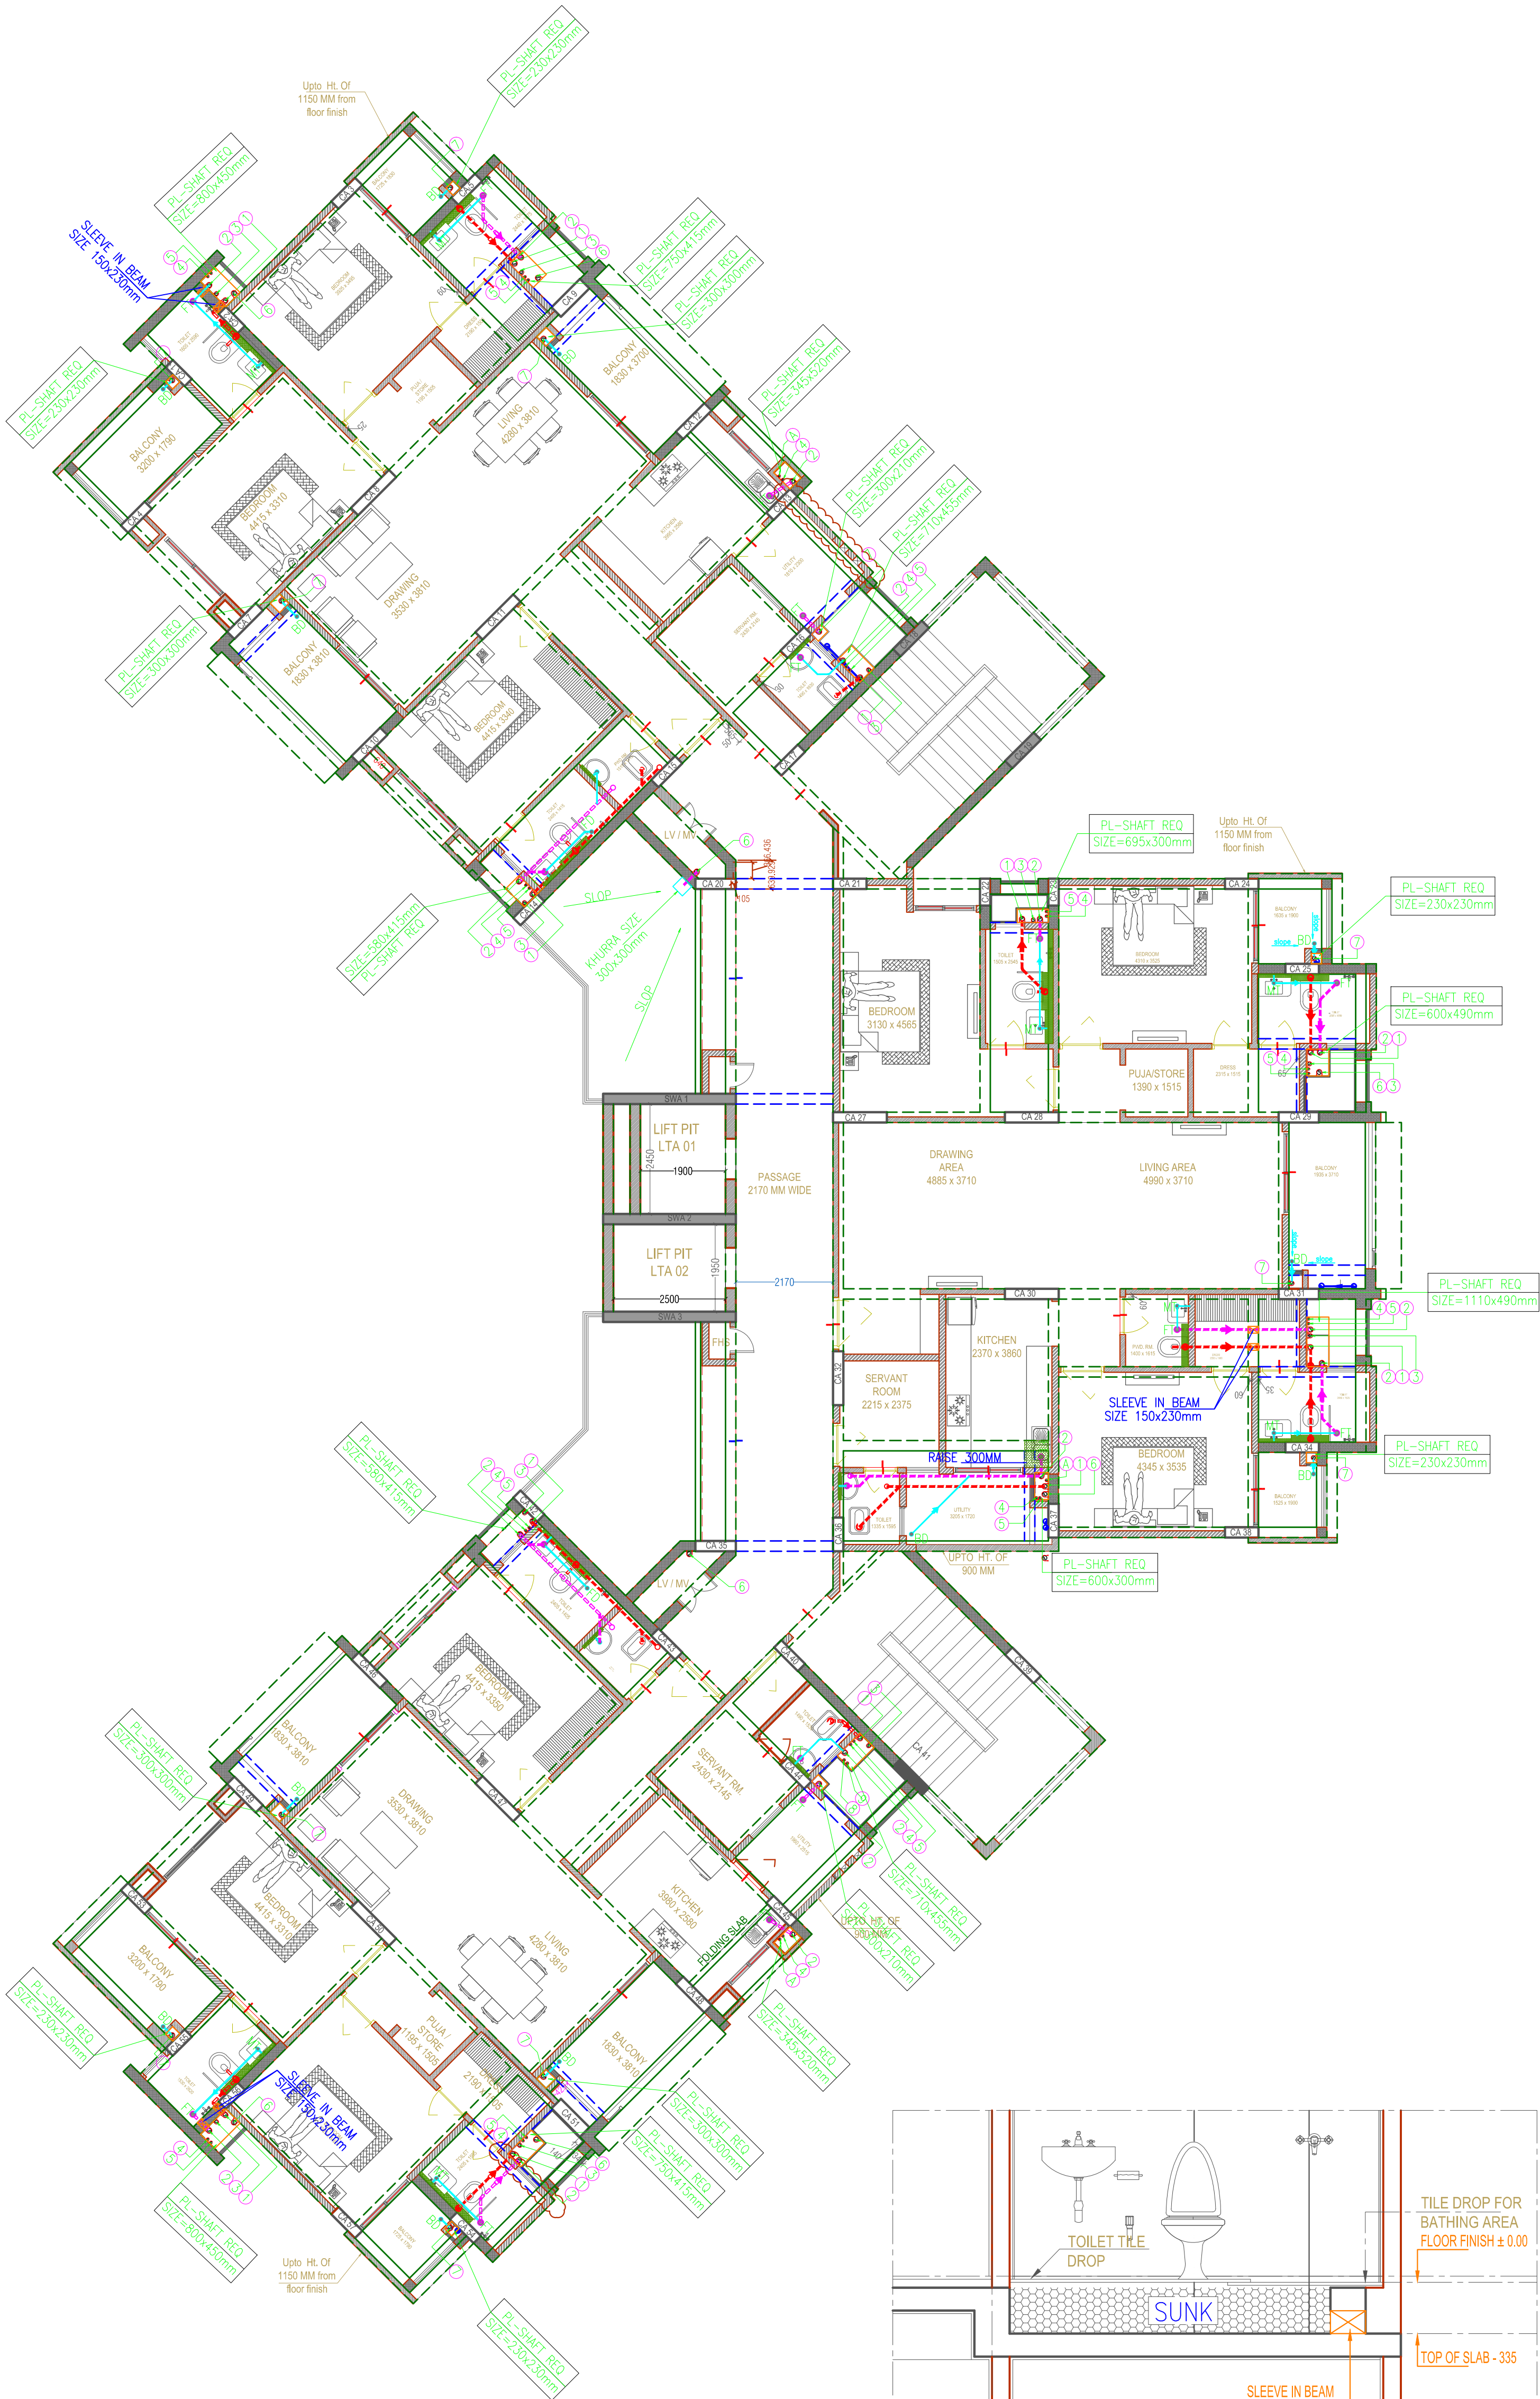

PLUMBING LEGEND:-	
(1)	110 OD Upvc SOIL PIPE
(2)	110 OD Upvc WASTE PIPE
(3)	75ø A/S PIPE
(4)	C.W.S DOWN TAKE PIPE
(5)	F.W.S DOWN TAKE PIPE
(6)	110 OD RAIN WATER PIPE FOR (TERRACE)
(7)	90 OD RAIN WATER PIPE FOR (BALCONY)
(8)	C.W.S RISER PIPE
(9)	F.W.S RISER PIPE
(A)	SOLAR HOT WATER SUPPLY

- PLUMBING NOTES:-
- WASH BASIN TO MULTI TRAP (MT) 40ø WASTE PIPE
 - MULTI TRAP TO FLOOR TRAP 50 Od WASTE PIPE
 - FLOOR DRAIN TO FLOOR TRAP 63 Od WASTE PIPE
 - KITCHEN SINK TO FLOOR TRAP (FT) 40 Od WASTE PIPE
 - BALCONY DRAIN TO VERTICAL 63 Od WASTE PIPE
 - 110 OD Upvc PIPE USED FOR SOIL & WASTE.

FT	FLOOR TRAP 110X110mm
MT	MULTI TRAP 110X50mm
FD	FLOOR DRAIN 110X63mm
BD	BALCONY DRAIN 110X63mm
LEDGEWALL FOR W.C & WB	

PROJECT:
CEDAR LUXURIA
PATRAKAR COLONY, JAIPUR

CLIENT :
CEDAR
JAIPUR


ARCHITECT :
maarchitects
Jaipur - Bangalore - Hyderabad
maithel & associates architects pvt. ltd.
Plot No. -1, Lal Kothi Scheme, Jaipur-302001
Tel : 91 141 4299999
Fax : 91 141 2741664
email - studio@maarchitects.in,
web - www.maarchitects.in

STRUCTURAL CONSULTANTS
SG STRUCTURES
A-36, 1ST FLOOR, SUNDER SINGH BANDARI NAGAR,
SWEI FARM, NEW SANGANER ROAD, JAIPUR-302019
E-mail- sg.structures@gmail.com
Tel: 09772202219, 0141-2297076

MEP CONSULTANTS
SRAJAN ASSOCIATES
C-35A, NAKSHTRA PRIDE, LAJPAT MARG,
C-SCHEME, JAIPUR
snajaipur@hotmail.com

PLUMBING & FIRE CONSULTANTS:
BEHERA & ASSOCIATES
F-623A, LADO SARAI, BEHIND CNG STATION
NEW DELHI - 110030
Ph: 011-40583839, 09811911853
Email: behera.associates@gmail.com

No.	ISSUED FOR :	DATE :	CKD:
DRAWING TITLE : PLUMBING DRAWING BLOCK - A TYP. FLOOR PLAN			
DRAWN BY :	SONU	NORTH:	
CHECKED BY :	SOMNATH	SCALE :	
DATE :	03-01-15	SCALE :	NTS
PROJECT NO. :	GH-2030	DRAWING NO. :	PL - BA - TA- 301

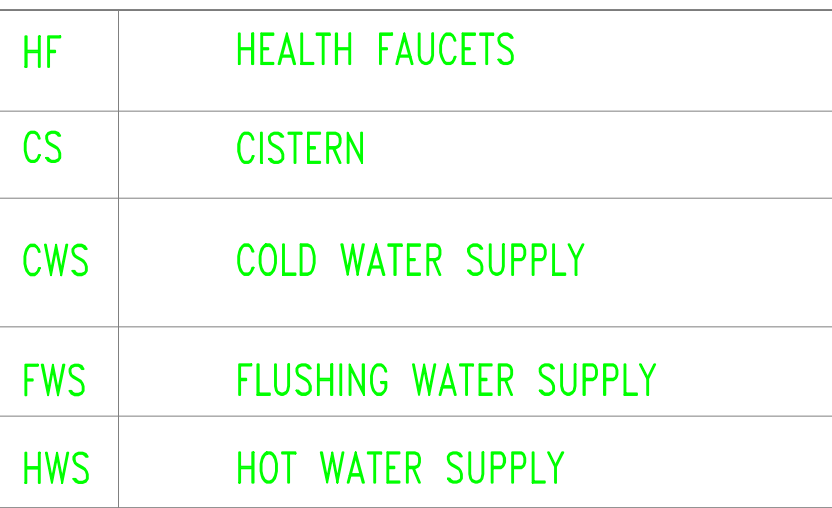

PLUMBING LEGEND:-	
(1)	110 OD Upvc SOIL PIPE
(2)	110 OD Upvc WASTE PIPE
(3)	75 ϕ A/S PIPE
(4)	C.W.S DOWN TAKE PIPE
(5)	F.W.S DOWN TAKE PIPE
(6)	110 OD RAIN WATER PIPE FOR (TERRACE)
(7)	90 OD RAIN WATER PIPE FOR (BALCONY)
(8)	C.W.S RISER PIPE
(9)	F.W.S RISER PIPE
(A)	SOLAR HOT WATER SUPPLY

PLUMBING NOTES:-

- | | |
|----|--|
| 1. | WASH BASIN TO MULTI TRAP (MT) 40Ø WASTE PIPE |
| 2. | MULTI TRAP TO FLOOR TRAP 50 Od WASTE PIPE |
| 3. | FLOOR DRAIN TO FLOOR TRAP 63 Od WASTE PIPE |
| 4. | KITCHEN SINK TO FLOOR TRAP (FT) 40 Od WASTE PIPE |
| 5. | BALCONY DRAIN TO VERTICAL 63 Od WASTE PIPE |
| 6. | 110 OD UPVC PIPE USED FOR SOIL & WASTE. |

	FT FLOOR TRAP 110X110mm
	MT MULTI TRAP 110X50mm
	FD FLOOR DRAIN 110X63mm
	BD BALCONY DRAIN 110X63mm
	LEDGEWALL FOR W.C & WB

CLIENT :

CEDAR LUXURIA
PATRAKAR COLONY, JAIPUR

PROJECT:

CEDAR
JAIPUR

ARCHITECT :

m | a | a r c h i t e c t s


Jaipur - Bangalore - Hyderabad
maithel & associates architects pvt. ltd.
Plot No. -1, Lal Kothi Scheme, Jaipur-302001
Tel : 91 141 4299999
Fax : 91 141 2741664
email - studio@maarchitects.in,
web - www.maarchitects.in

MEP CONSULTANTS

SRAJAN ASSOCIATES

C-35A, NAKSHTRA PRIDE, LAJPAT MARG,
C-SCHEME, JAIPUR
snajaipur@hotmail.com

PLUMBING & FIRE CONSULTANTS:

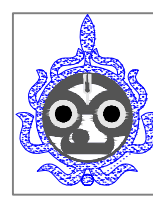

BEHERA & ASSOCIATES
F-623A, LADO SARAI, BEHIND CNG STATION
NEW DELHI - 110030
Ph: 011-40583839, 09811911853
Email: behera.associates@gmail.com

DRAWING TITLE :

PLUMBING DRAWING
BLOCK - B
TYP FLOOR PLAN

DRAWN BY : SONU

NORTH:

CHECKED BY : SOMNATH

DATE : 30-12-2014

SCALE : 1 : 125

PROJECT NO.: GH-2030

DRAWING NO. :
PL - BA - 201

PLUMBING LEGEND:-	
(1)	110 OD Upvc SOIL PIPE
(2)	110 OD Upvc WASTE PIPE
(3)	75# A/S PIPE
(4)	C.W.S DOWN TAKE PIPE
(5)	F.W.S DOWN TAKE PIPE
(6)	110 OD RAIN WATER PIPE FOR (TERRACE)
(7)	90 OD RAIN WATER PIPE FOR (BALCONY)
(8)	C.W.S RISER PIPE
(9)	F.W.S RISER PIPE
(A)	SOLAR HOT WATER SUPPLY
PLUMBING NOTES:-	
1. WASH BASIN TO MULTI TRAP (MT) 40# WASTE PIPE	
2. MULTI TRAP TO FLOOR TRAP 50 Od WASTE PIPE	
3. FLOOR DRAIN TO FLOOR TRAP 63 Od WASTE PIPE	
4. KITCHEN SINK TO FLOOR TRAP (FT) 40 Od WASTE PIPE	
BALCONY DRAIN TO VERTICAL 63 Od WASTE PIPE	
6. 110 OD Upvc PIPE USED FOR SOIL & WASTE.	
Ⓜ	FT FLOOR TRAP 110X110mm
Ⓜ	MT MULTI TRAP 110X50mm
Ⓜ	FD FLOOR DRAIN 110X63mm
Ⓜ	BD BALCONY DRAIN 110X63mm
LEDGEWALL FOR W.C & WB	

PROJECT:

CEDAR LUXURIA
PATRAKAR COLONY, JAIPUR

CLIENT :

CEDAR
JAIPUR

ARCHITECT :


maarchitects
Jaipur - Bangalore - Hyderabad
maithel & associates architects pvt. ltd.
Plot No. -1, Lal Kothi Scheme, Jaipur-302001
Tel : 91 141 4299999
Fax : 91 141 2741664
email - studio@maarchitects.in,
web - www.maarchitects.in

MEP CONSULTANTS

SRAJAN ASSOCIATES

C-35A, NAKSHTRA PRIDE, LAJPAT MARG,
C-SCHEME, JAIPUR
snajaipur@hotmail.com

PLUMBING & FIRE CONSULTANTS:

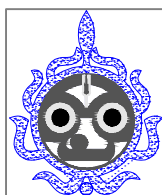 **BEHERA & ASSOCIATES**
F-623A, LADO SARAI, BEHIND CNG STATION
NEW DELHI - 110030
Ph: 011-40583839, 09811911853
Email: behera.associates@gmail.com

No.	ISSUED FOR :	DATE :	CKD:
-----	--------------	--------	------

DRAWING TITLE :
PLUMBING DRAWING
BLOCK - C
TYP. FLOOR PLAN


DRAWN BY :
SONU

CHECKED BY :
SOMNATH

DATE :
02-01-2015


PROJECT NO. :
GH-2030

NORTH:

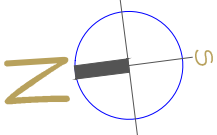

SCALE :
NTS

DRAWING NO. :
PL - BA - 201

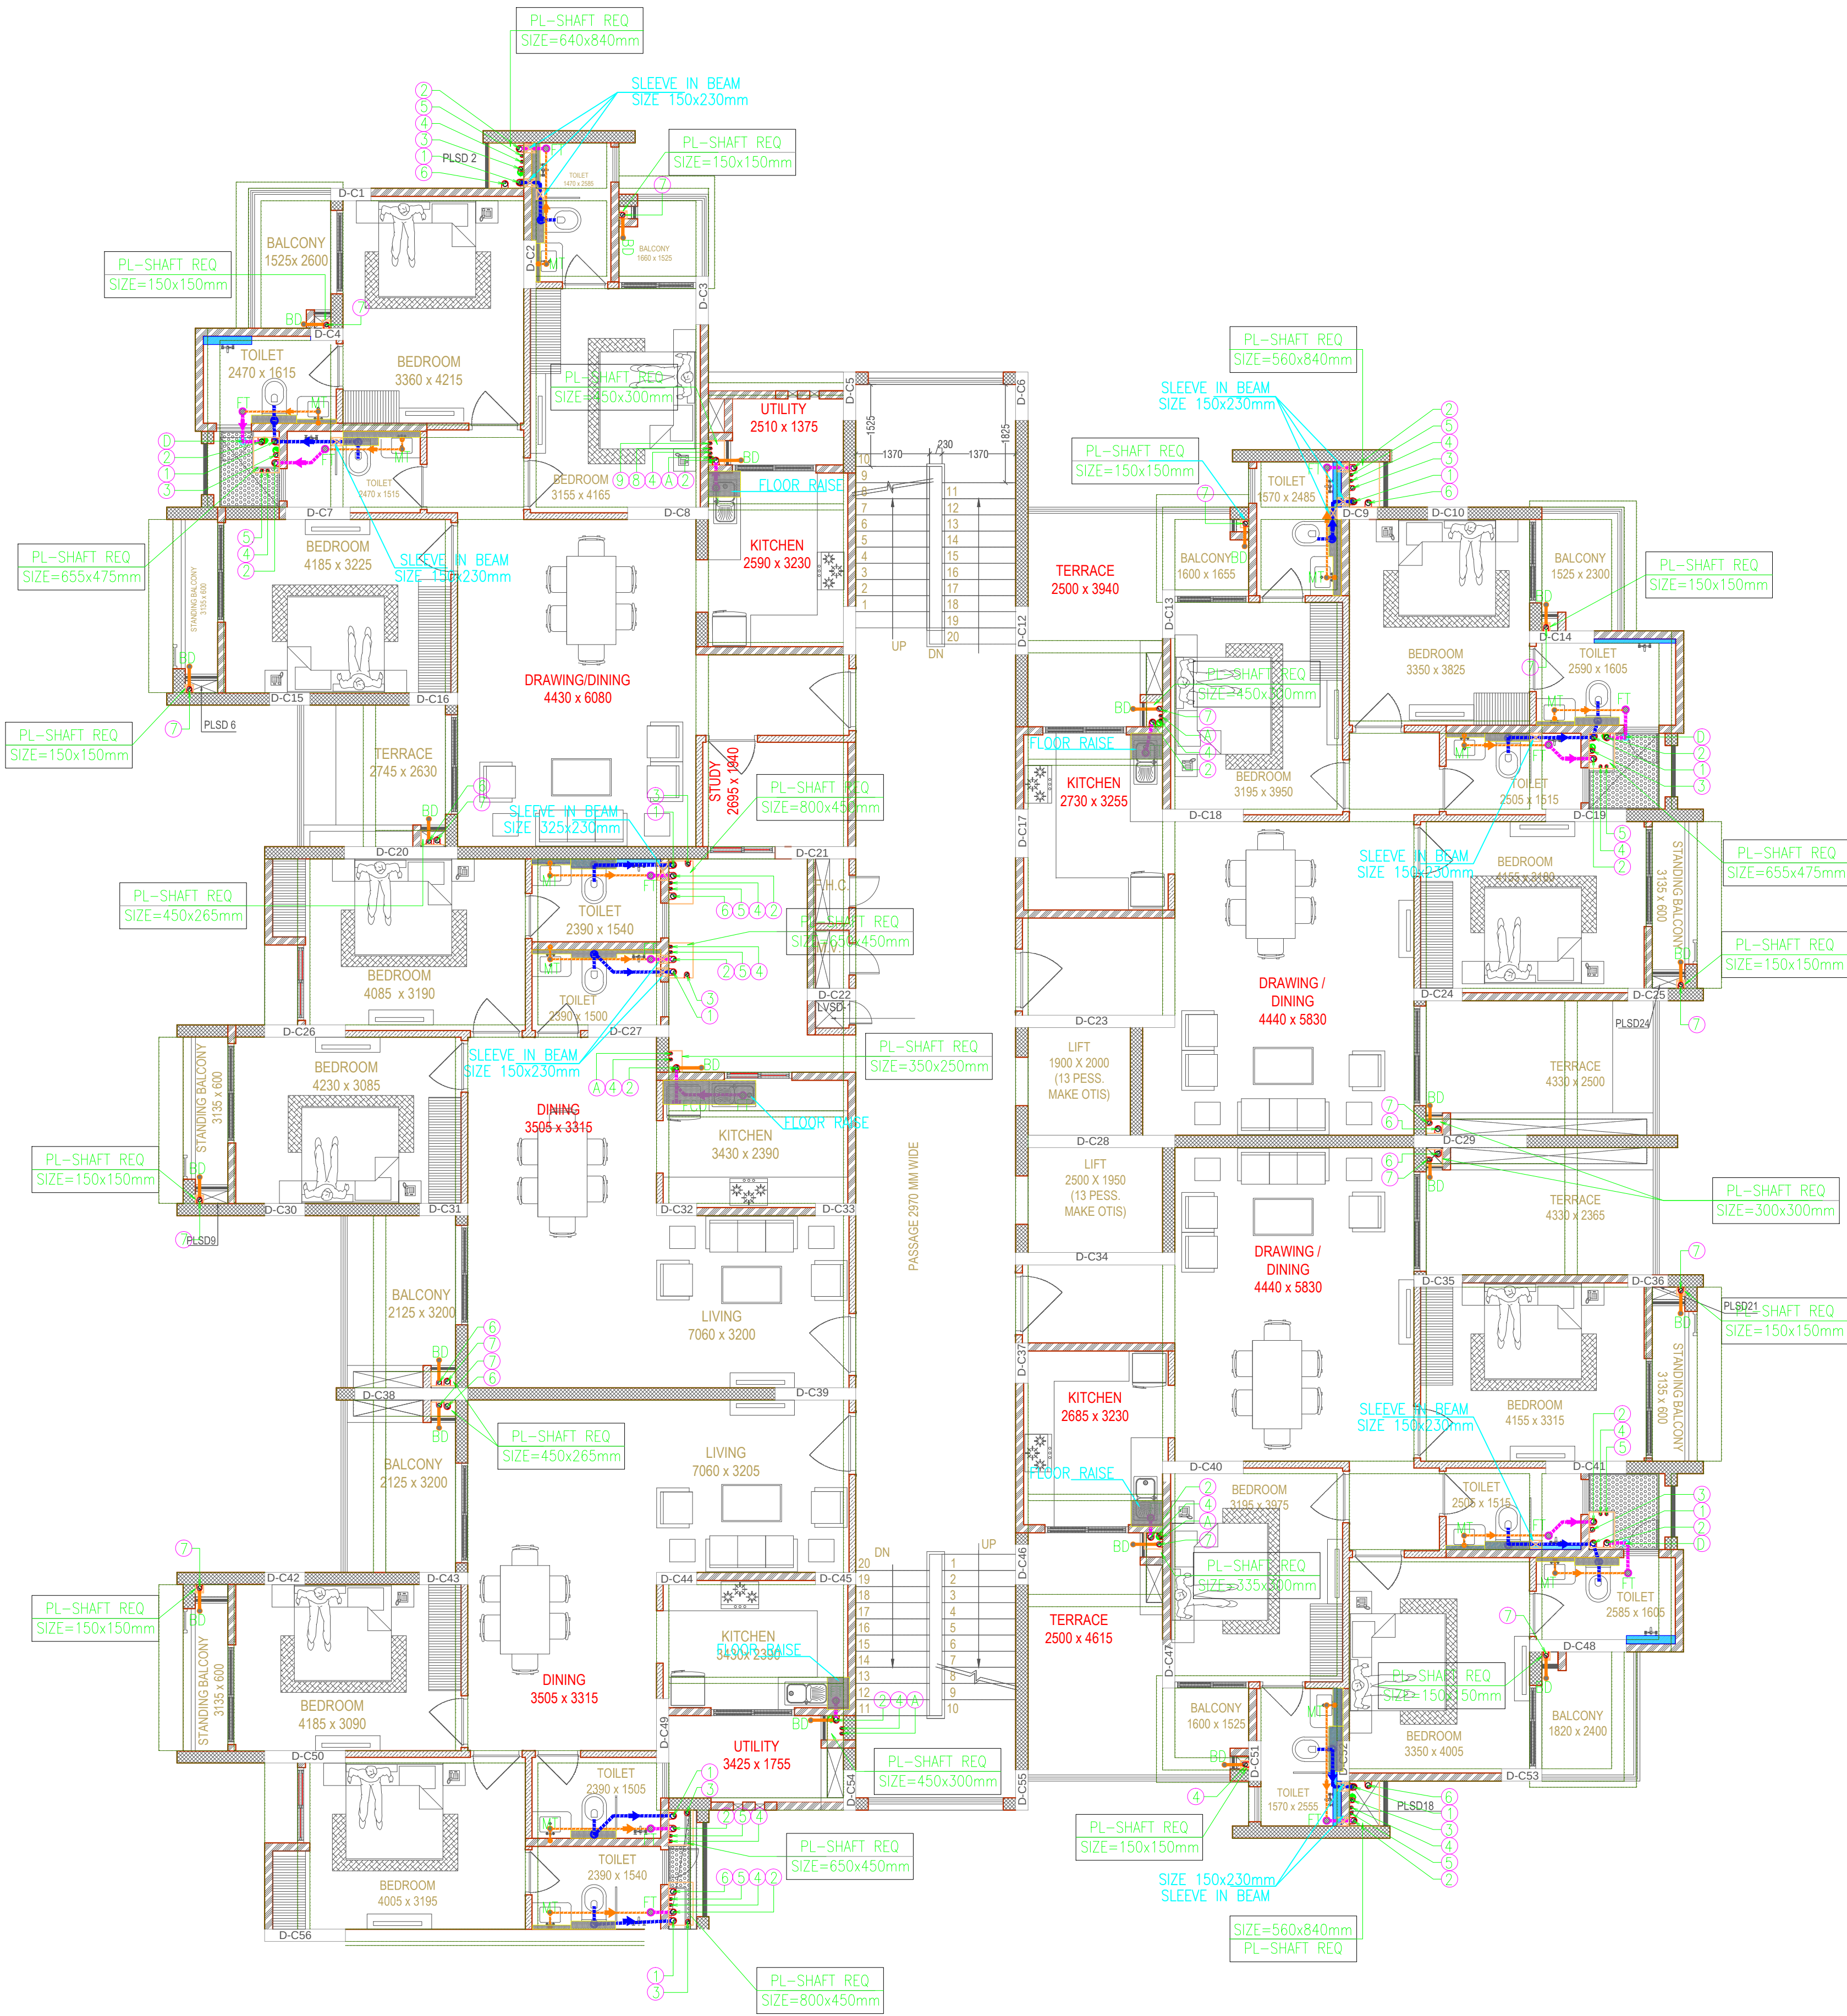

PLUMBING LEGEND:-

- (1) 110 OD Upvc SOIL PIPE
- (2) 110 OD Upvc WASTE PIPE
- (3) 75Ø A/S PIPE
- (4) C.W.S DOWN TAKE PIPE
- (5) F.W.S DOWN TAKE PIPE
- (6) 110 OD RAIN WATER PIPE FOR (TERRACE)
- (7) 90 OD RAIN WATER PIPE FOR (BALCONY)
- (8) C.W.S RISER PIPE
- (9) F.W.S RISER PIPE
- (A) SOLAR HOT WATER SUPPLY

PLUMBING NOTES:-

1. WASH BASIN TO MULTI TRAP (MT) 40Ø WASTE PIPE
2. MULTI TRAP TO FLOOR TRAP 50 Od WASTE PIPE
3. FLOOR DRAIN TO FLOOR TRAP 63 Od WASTE PIPE
4. KITCHEN SINK TO FLOOR TRAP (FT) 40 Od WASTE PIPE
5. BALCONY DRAIN TO VERTICAL 63 Od WASTE PIPE
6. 110 OD Upvc PIPE USED FOR SOIL & WASTE.

- | | |
|----|------------------------|
| FT | FLOOR TRAP 110X110mm |
| MT | MULTI TRAP 110X50mm |
| FD | FLOOR DRAIN 110X63mm |
| BD | BALCONY DRAIN 110X63mm |
| | LEDGEWALL FOR W.C & WB |

PROJECT:

CEDAR LUXURIA
PATRAKAR COLONY, JAIPUR

CLIENT :

CEDAR
JAIPUR


ARCHITECT :

m|a architects
Jaipur - Bangalore - Hyderabad
maithel & associates architects pvt. ltd.
Plot No. -1, Lal Kothi Scheme, Jaipur-302001
Tel : 91 141 4299999
Fax : 91 141 2741664
email - studio@maarchitects.in,
web - www.maarchitects.in

MEP CONSULTANTS

SRAJAN ASSOCIATES
C-35A, NAKSHTRA PRIDE, LAJPAT MARG,
C-SCHEME, JAIPUR
snajajipur@hotmail.com

PLUMBING & FIRE CONSULTANTS:

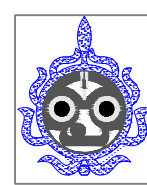


BEHERA & ASSOCIATES
F-623A, LADO SARAI, BEHIND CNG STATION
NEW DELHI - 110030
Ph: 011-40583839, 09811911853
Email: behera.associates@gmail.com

No. ISSUED FOR : DATE : CKD:

DRAWING TITLE :
PLUMBING DRAWING
BLOCK - D
TYP. FLOOR PLAN

DRAWN BY : SONU
CHECKED BY : SOMNATH

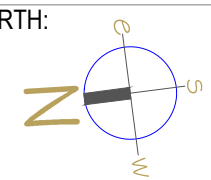


DATE : 28-12-2014


SCALE : NTS

PROJECT NO. :


DRAWING NO. :
PL - BA - 201

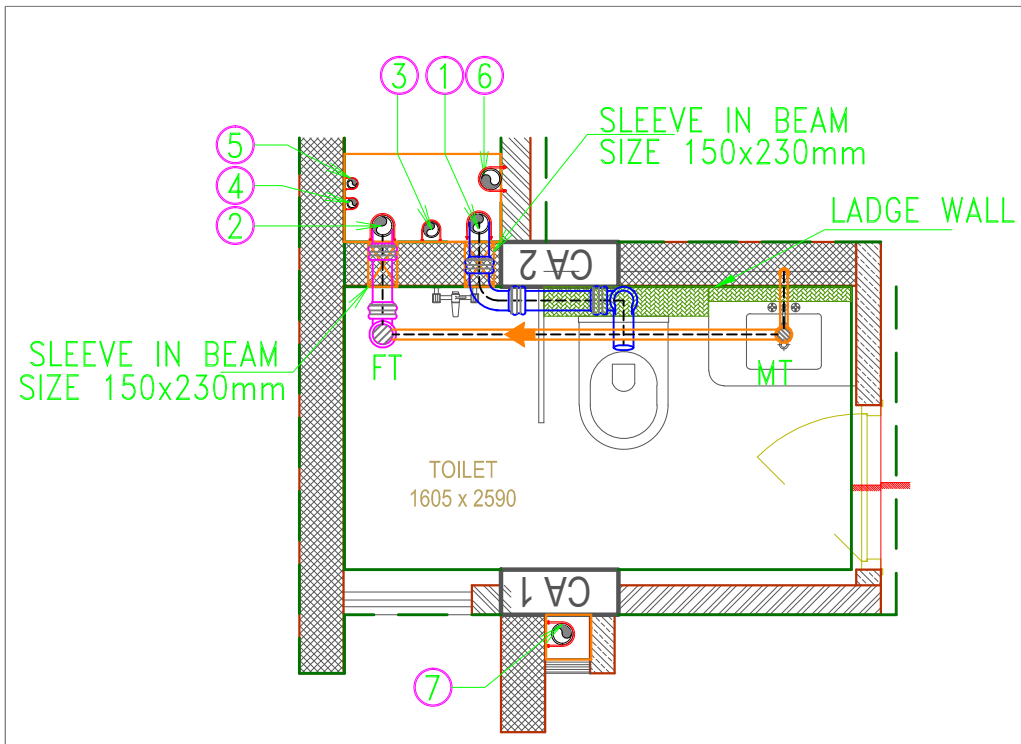


TYP. FLOOR-TOILET-01 DETAIL DRAINAGE LAYOUT

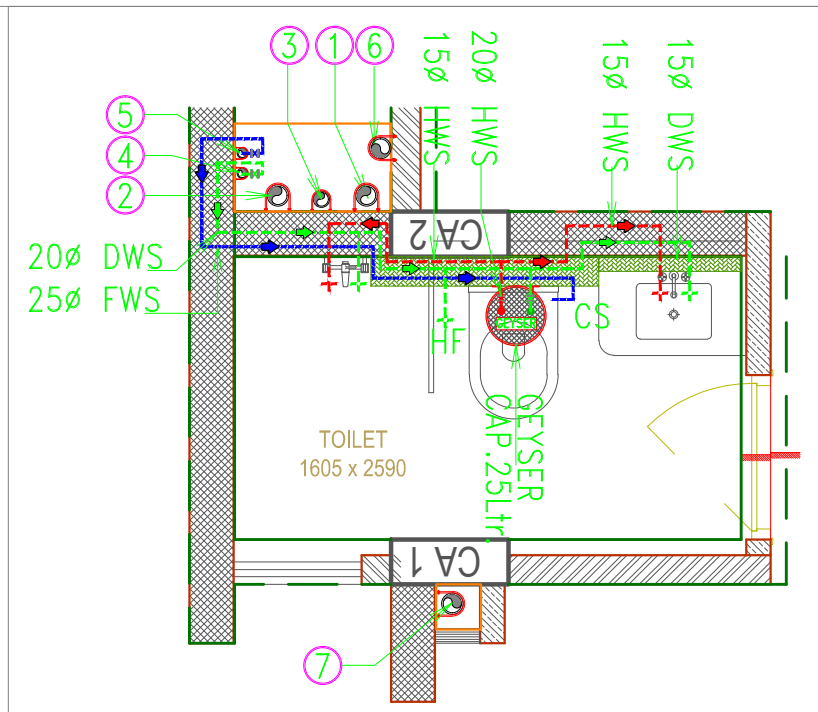


TYP. FLOOR-TOILET-01 DETAIL WATER SUPPLY

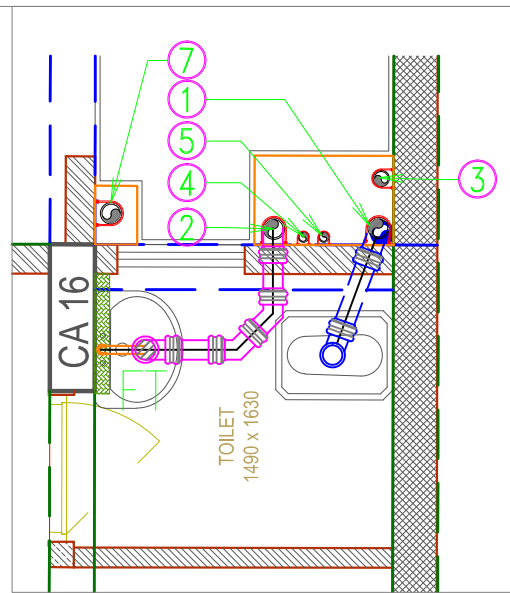


TYP. FLOOR-TOILET-02 DETAIL DRAINAGE LAYOUT

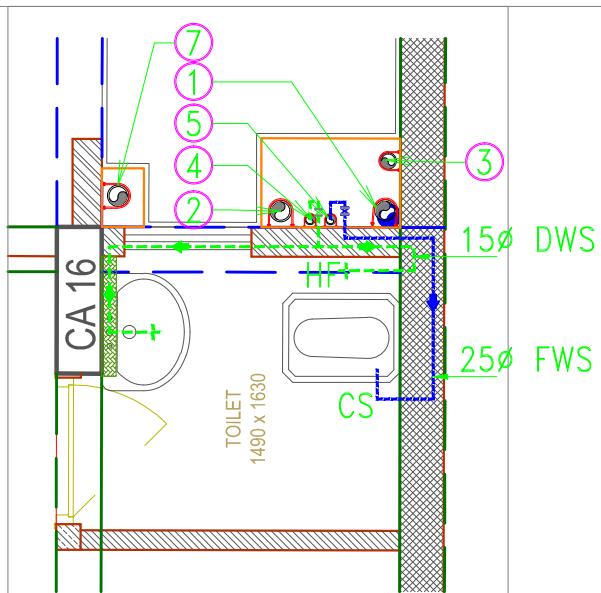


TYP. FLOOR-TOILET-02 DETAIL WATER SUPPLY

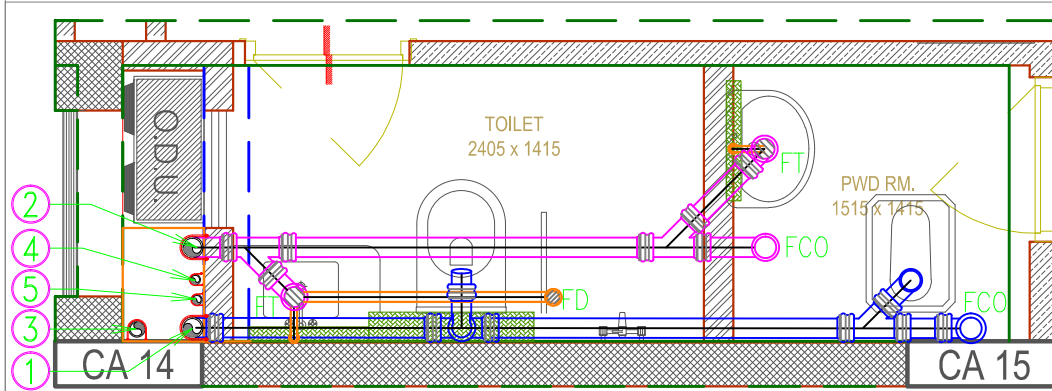


TYP. FLOOR-TOILET-03 DETAIL DRAINAGE LAYOUT

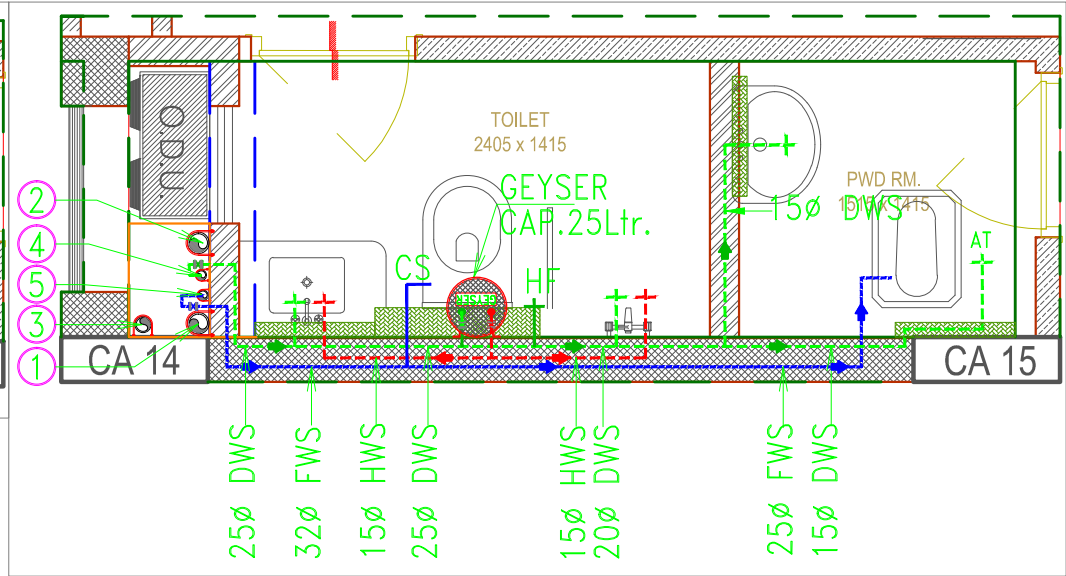


TYP. FLOOR-TOILET-03 DETAIL WATER SUPPLY

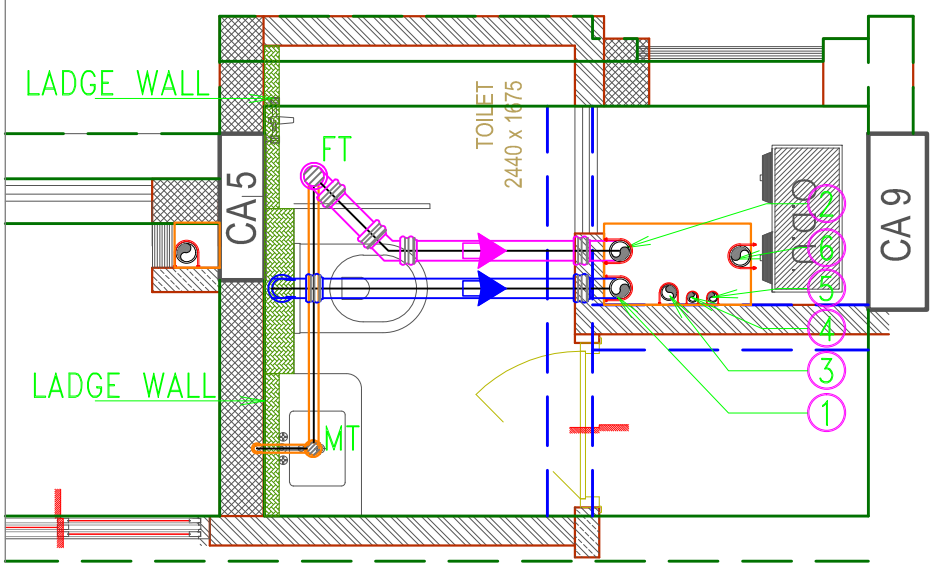


TYP. FLOOR-TOILET-04 DETAIL DRAINAGE LAYOUT

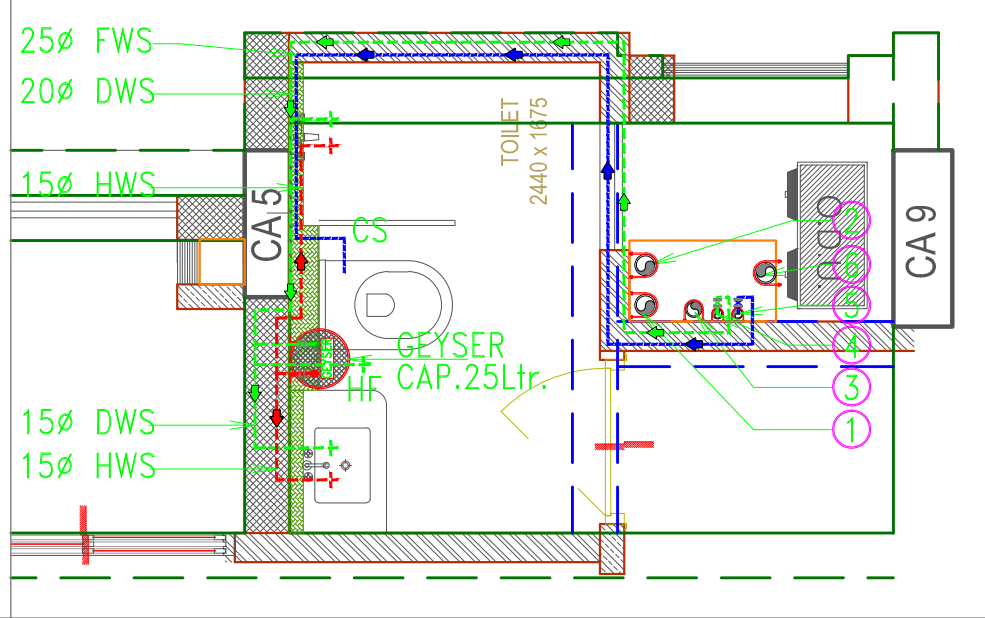

TYP. FLOOR-TOILET-04 DETAIL WATER SUPPLY

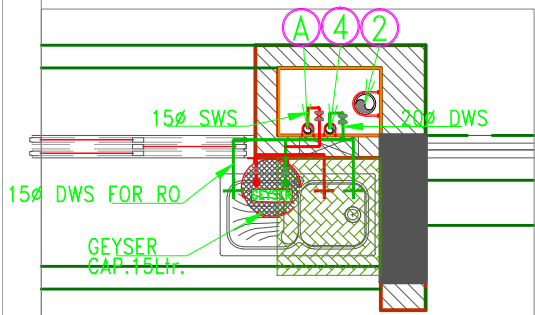


TYP. FLOOR-KITCHEN-01 DETAIL DRAINAGE LAYOUT

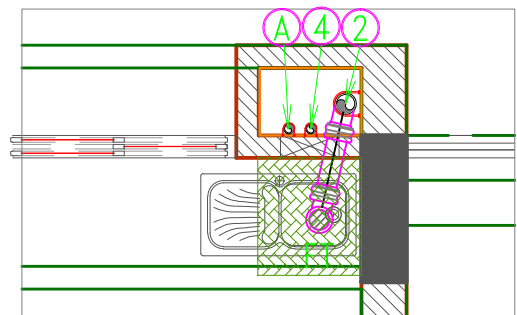

TYP. FLOOR-KITCHEN-01 DETAIL WATER SUPPLY

HF	HEALTH FAUCETS
CS	CISTERN
CWS	COLD WATER SUPPLY
FWS	FLUSHING WATER SUPPLY
HWS	HOT WATER SUPPLY

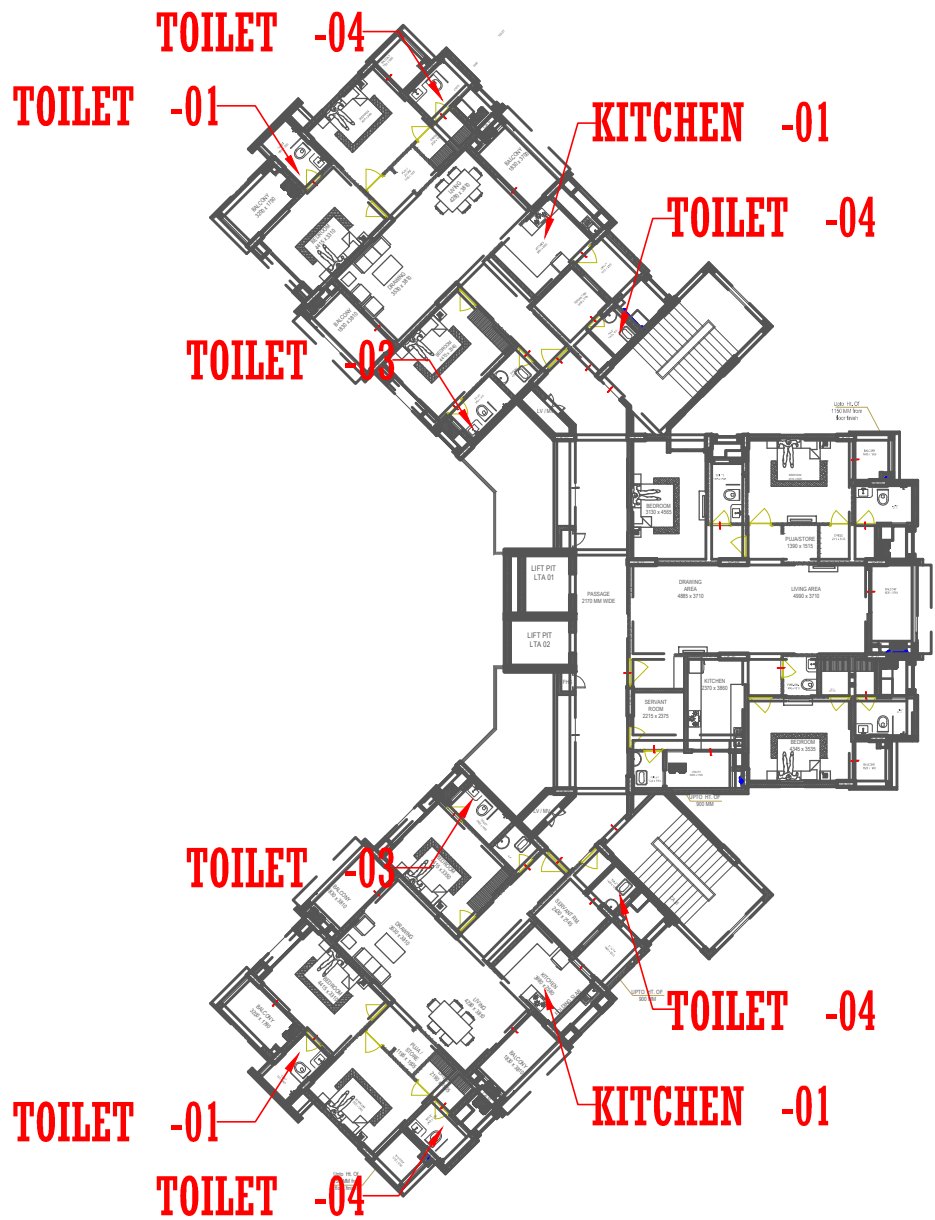

PLUMBING LEGEND:-

(1)	110 OD Upvc SOIL PIPE
(2)	110 OD Upvc WASTE PIPE
(3)	75ø A/S PIPE
(4)	C.W.S DOWN TAKE PIPE
(5)	F.W.S DOWN TAKE PIPE
(6)	110 OD RAIN WATER PIPE FOR (TERRACE)
(7)	90 OD RAIN WATER PIPE FOR (BALCONY)
(8)	C.W.S RISER PIPE
(9)	F.W.S RISER PIPE
(A)	SOLAR HOT WATER SUPPLY

PLUMBING NOTES:-

- WASH BASIN TO MULTI TRAP (MT) 40ø WASTE PIPE
- MULTI TRAP TO FLOOR TRAP 50 Od WASTE PIPE
- FLOOR DRAIN TO FLOOR TRAP 63 Od WASTE PIPE
- KITCHEN SINK TO FLOOR TRAP (FT) 40 Od WASTE PIPE
- BALCONY DRAIN TO VERTICAL 63 Od WASTE PIPE
- 110 OD Upvc PIPE USED FOR SOIL & WASTE.

FT	FLOOR TRAP 110X110mm
MT	MULTI TRAP 110X50mm
FD	FLOOR DRAIN 110X63mm
BD	BALCONY DRAIN 110X63mm
LD	LEDGEWALL FOR W.C & WB

PROJECT:

CEDAR LUXURIA
PATRAKAR COLONY, JAIPUR

CLIENT:

CEDAR
JAIPUR

ARCHITECT:

m | a | architects
Jaipur - Bangalore - Hyderabad
maithel & associates architects pvt. ltd.
Plot No. -1, Lal Kothi Scheme, Jaipur-302001
Tel : 91 141 4299999
Fax : 91 141 2741664
email - studio@maarchitects.in,
web - www.maarchitects.in

MEP CONSULTANTS


SRAJAN ASSOCIATES
C-35A, NAKSHTRA PRIDE, LAJPAT MARG,
C-SCHEME, JAIPUR
snajaipur@hotmail.com

PLUMBING & FIRE CONSULTANTS:


BEHERA & ASSOCIATES
F-623A, LADO SARAI, BEHIND CNG STATION
NEW DELHI - 110030
Ph: 011-40583839, 09811911853
Email: behera.associates@gmail.com

No.	ISSUED FOR :	DATE :	CKD:
DRAWING TITLE :			
PLUMBING DRAWING BLOCK - A TYP. TOILET DETAIL			
DRAWN BY :	SONU	NORTH:	
CHECKED BY :	SOMNATH		
DATE :	03-01-2015	SCALE :	A3 1:50
PROJECT NO. :	GH-2030	DRAWING NO. :	PL - BA - 201


PRODUCED BY AN AUTODESK EDUCATIONAL PRODUCT

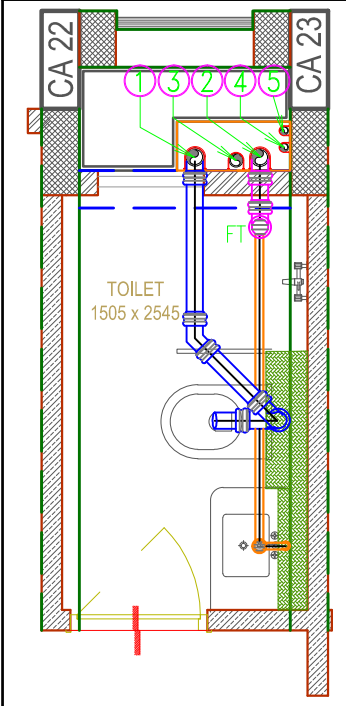


TYP. FLOOR-TOILET-01 DETAIL DRAINAGE LAYOUT

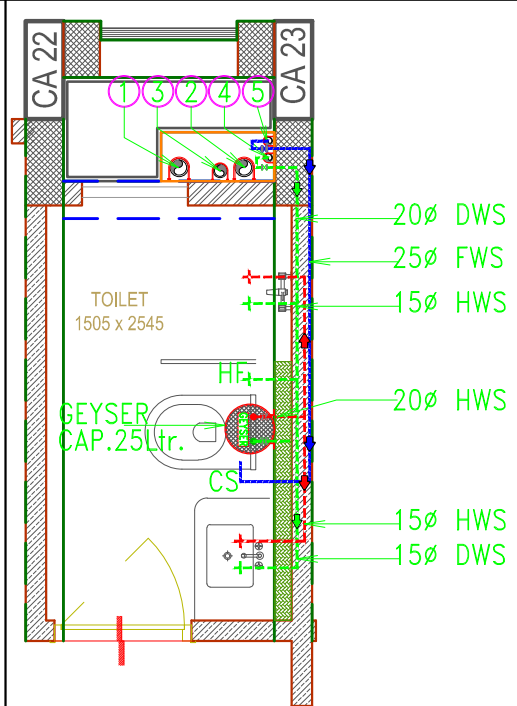

TYP. FLOOR-TOILET-01 DETAIL WATER SUPPLY

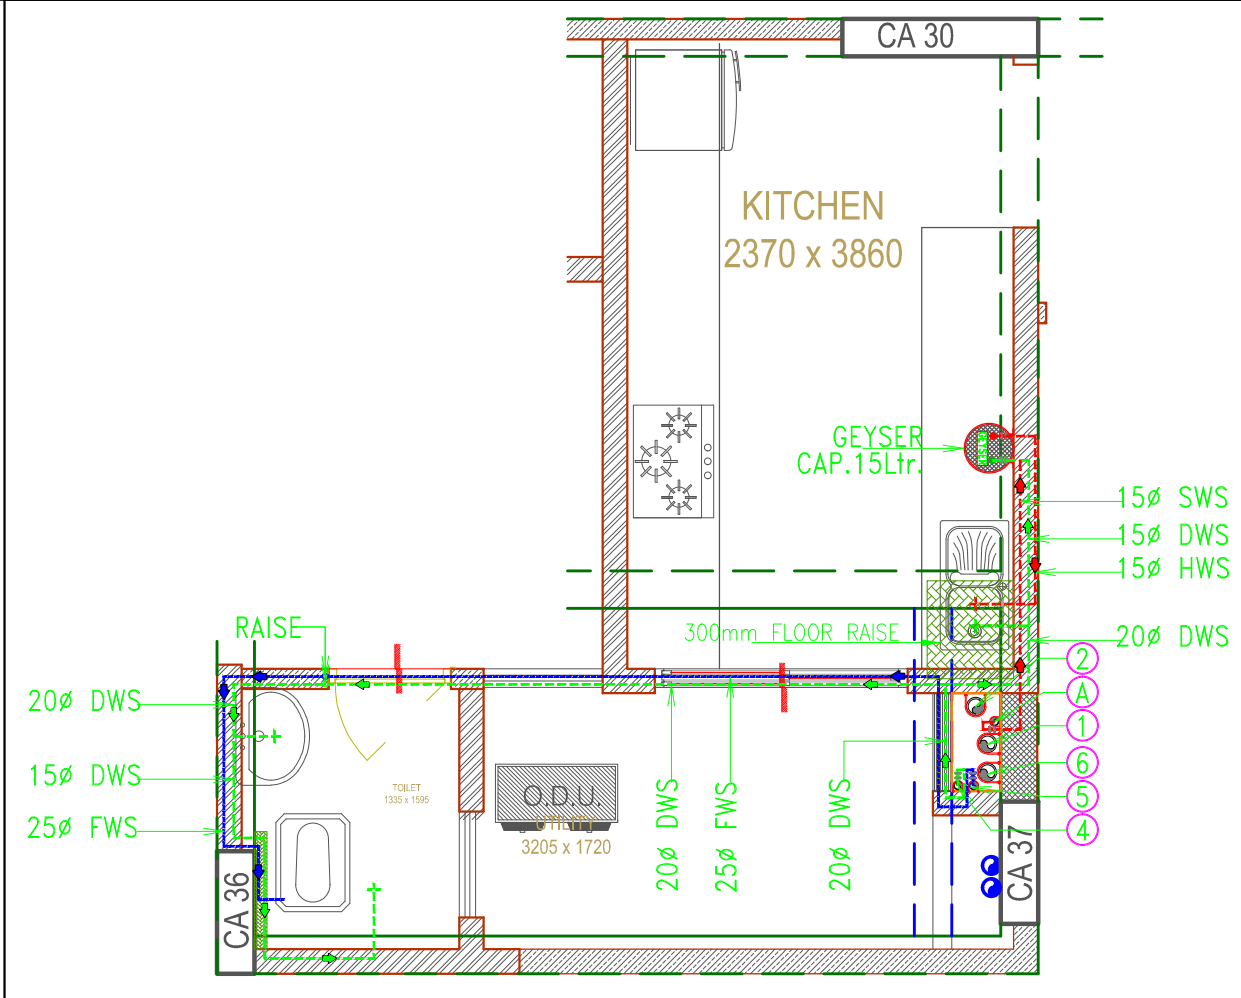

TYP. FLOOR-TOILET -KITCHEN -02 DETAIL WATER SUPPLY

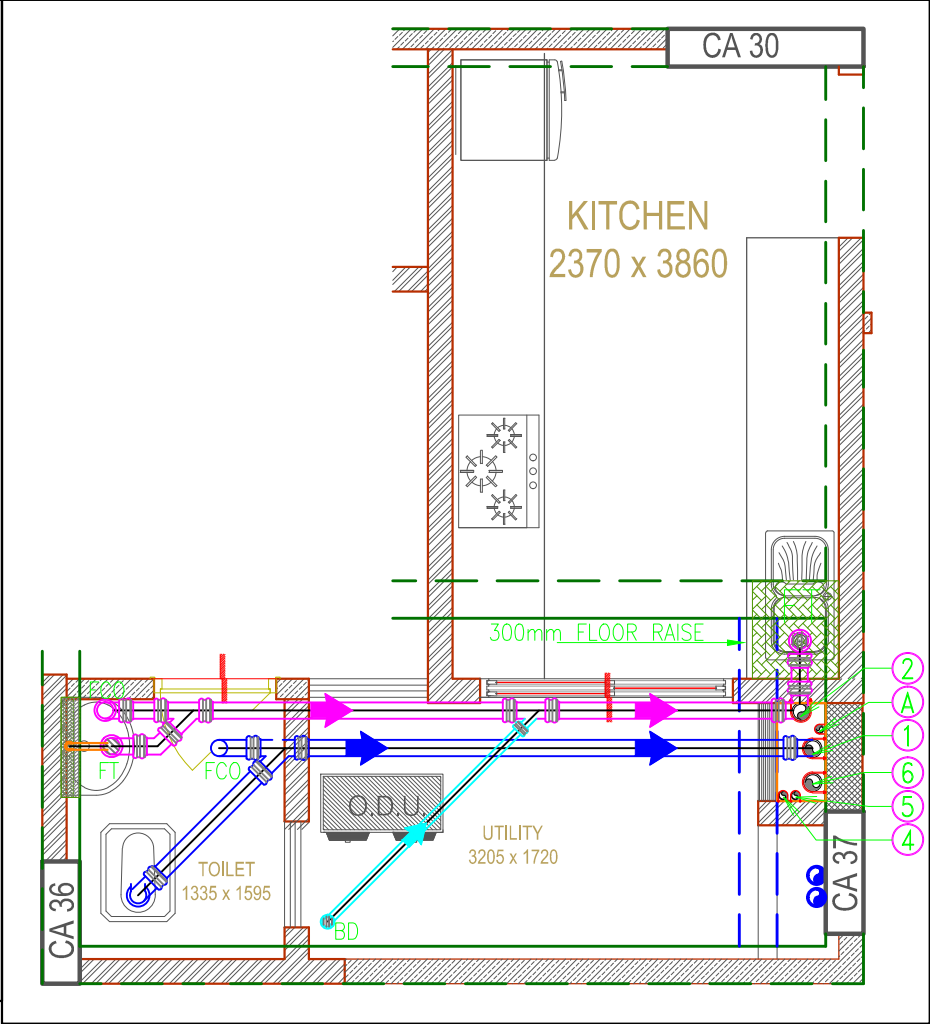

TYP. FLOOR-TOILET -KITCHEN -02 DETAIL DRAINAGE LAYOUT

PLUMBING LEGEND:-	
(1)	110 OD Upvc SOIL PIPE
(2)	110 OD Upvc WASTE PIPE
(3)	75ø A/S PIPE
(4)	C.W.S DOWN TAKE PIPE
(5)	F.W.S DOWN TAKE PIPE
(6)	110 OD RAIN WATER PIPE FOR (TERRACE)
(7)	90 OD RAIN WATER PIPE FOR (BALCONY)
(8)	C.W.S RISER PIPE
(9)	F.W.S RISER PIPE
(A)	SOLAR HOT WATER SUPPLY

PLUMBING NOTES:-	
1.	WASH BASIN TO MULTI TRAP (MT) 40ø WASTE PIPE
2.	MULTI TRAP TO FLOOR TRAP 50 Od WASTE PIPE
3.	FLOOR DRAIN TO FLOOR TRAP 63 Od WASTE PIPE
4.	KITCHEN SINK TO FLOOR TRAP (FT) 40 Od WASTE PIPE
5.	BALCONY DRAIN TO VERTICAL 63 Od WASTE PIPE
6.	110 OD Upvc PIPE USED FOR SOIL & WASTE.

FT	FLOOR TRAP 110X110mm
MT	MULTI TRAP 110X50mm
FD	FLOOR DRAIN 110X63mm
BD	BALCONY DRAIN 110X63mm
LEDGEWALL FOR W.C & WB	

PROJECT:

CEDAR LUXURIA
PATRAKAR COLONY, JAIPUR

CLIENT :

CEDAR
JAIPUR

ARCHITECT :


m|a|architects
Jaipur - Bangalore - Hyderabad
maithel & associates architects pvt. ltd.
Plot No. -1, Lal Kothi Scheme, Jaipur-302001
Tel : 91 141 4299999
Fax : 91 141 2741664
email - studio@maarchitects.in,
web - www.maarchitects.in



MEP CONSULTANTS

SRAJAN ASSOCIATES
C-35A, NAKSHTRA PRIDE, LAJPAT MARG,
C-SCHEME, JAIPUR
snajaipur@hotmail.com


PLUMBING & FIRE CONSULTANTS:

 **BEHERA & ASSOCIATES**
F-623A, LADO SARAI, BEHIND CNG STATION
NEW DELHI - 110030
Ph: 011-40583839, 09811911853
Email: behera.associates@gmail.com

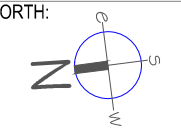
No.	ISSUED FOR :	DATE :	CKD:
DRAWING TITLE : PLUMBING DRAWING BLOCK - A TYP. TOILET DETAIL			
DRAWN BY :	SONU	NORTH: 	
CHECKED BY :	SOMNATH		
DATE :	03-01-2015	SCALE :	A3 1:60
PROJECT NO. :	GH-2030	DRAWING NO. :	PL - BA - 201

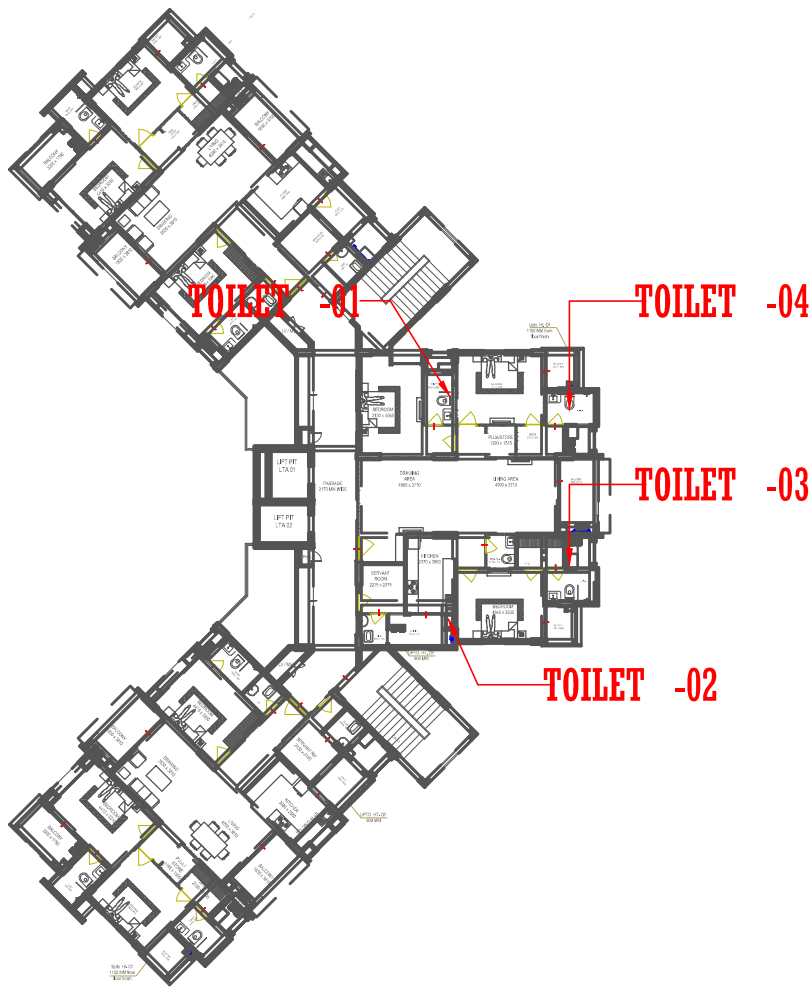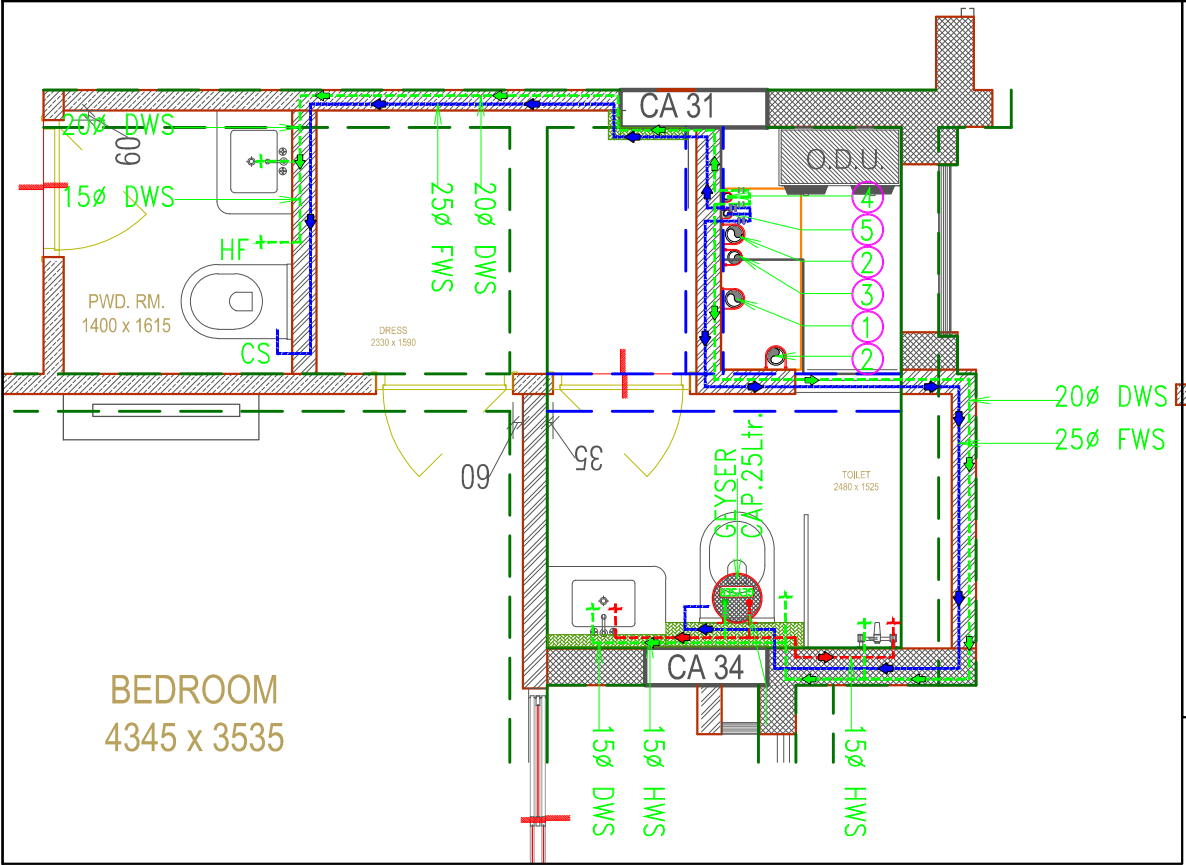


TYP. FLOOR-TOILET-03 DETAIL WATER SUPPLY

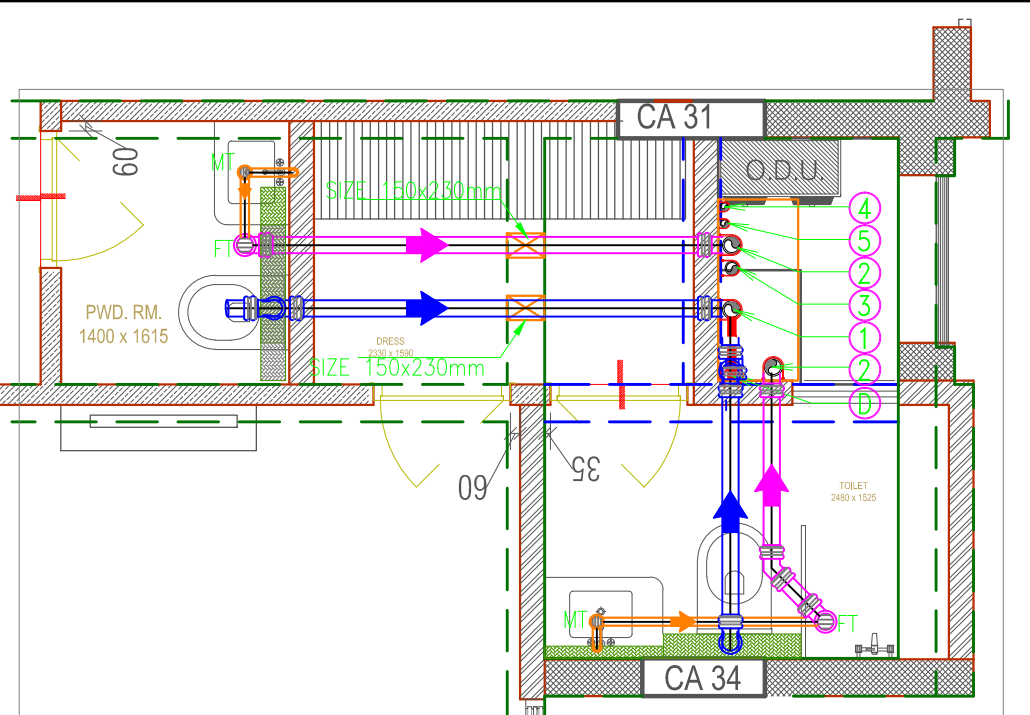

TYP. FLOOR-TOILET-03 DETAIL DRAINAGE LAYOUT




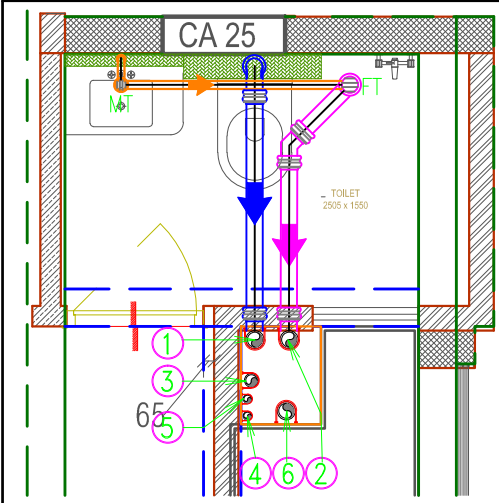


TYP. FLOOR-TOILET-04 DETAIL DRAINAGE LAYOUT

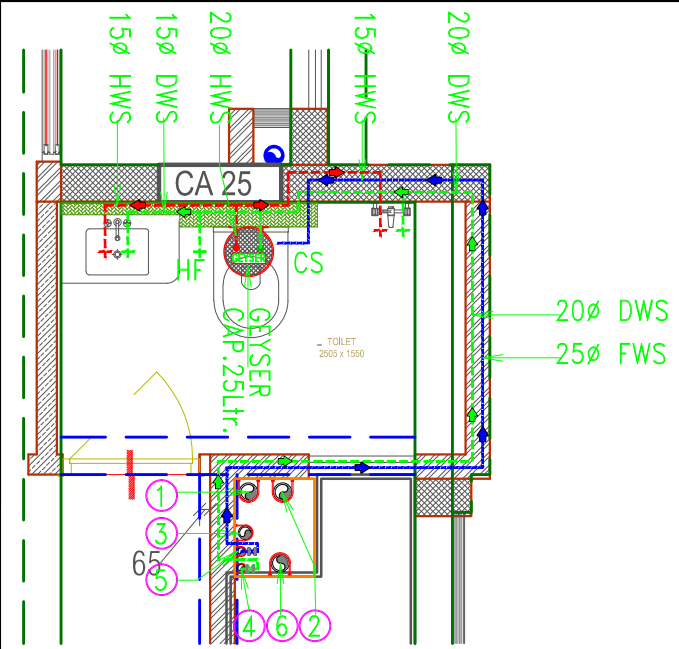

TYP. FLOOR-TOILET-04 DETAIL DRAINAGE LAYOUT

PRODUCED BY AN AUTODESK EDUCATIONAL PRODUCT

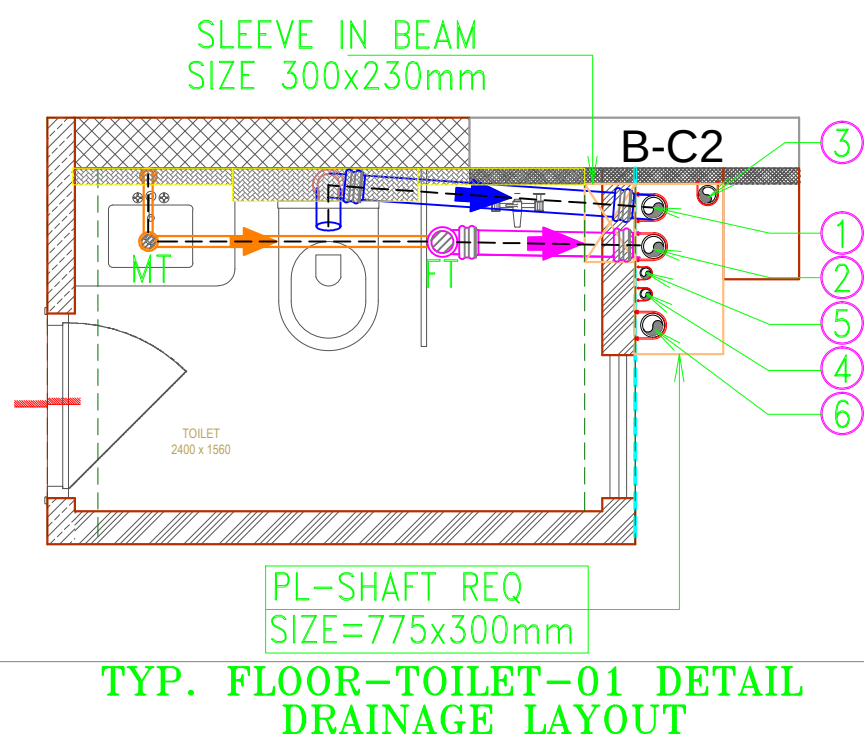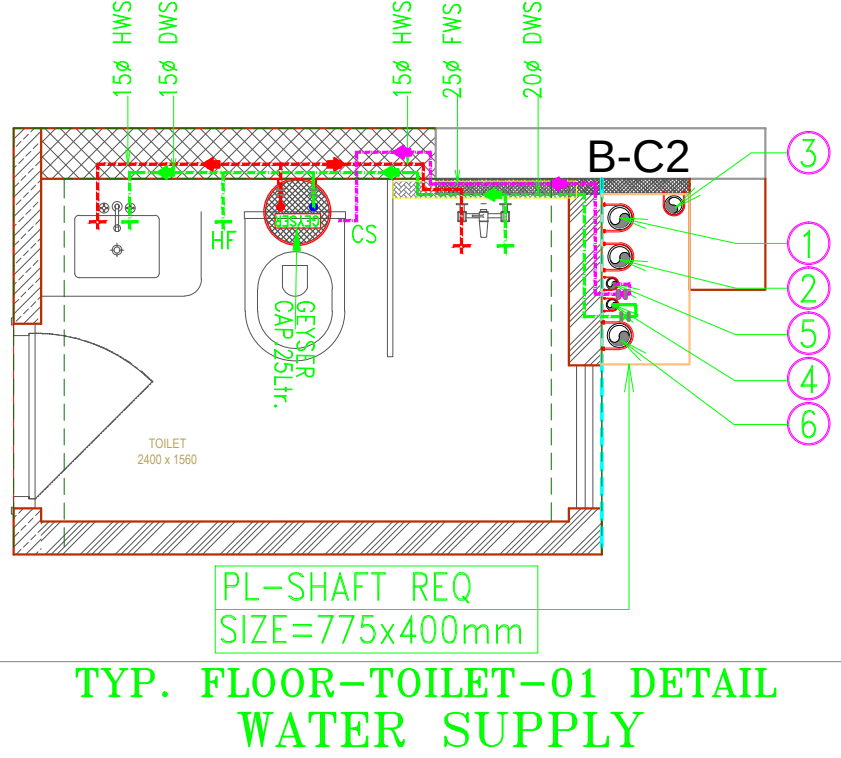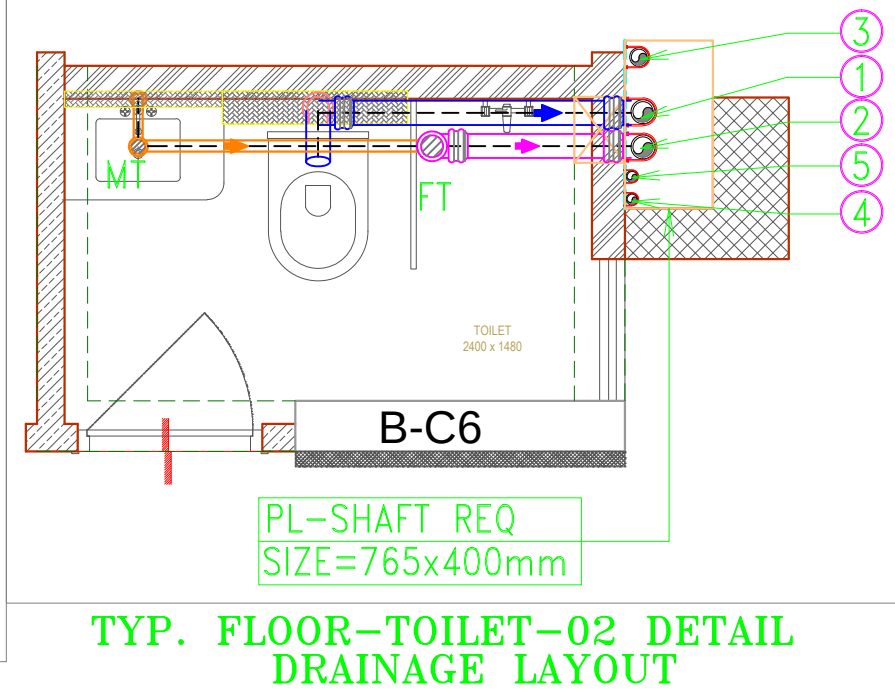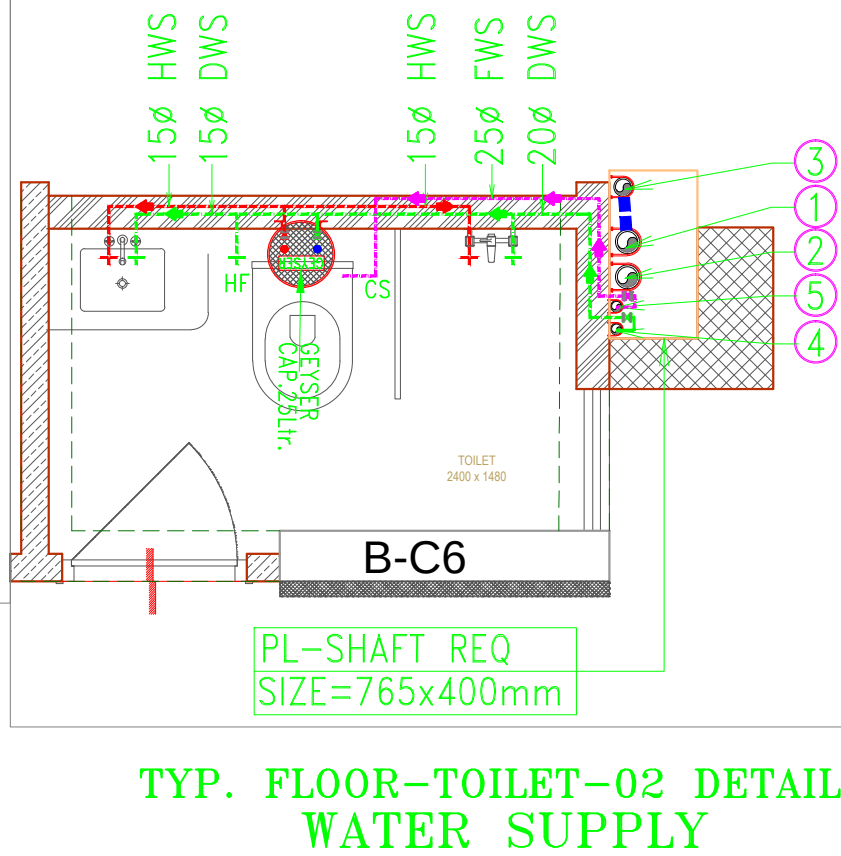

PLUMBING LEGEND:-	
(1)	110 OD Upvc SOIL PIPE
(2)	110 OD Upvc WASTE PIPE
(3)	75Ø A/S PIPE
(4)	C.W.S DOWN TAKE PIPE
(5)	F.W.S DOWN TAKE PIPE
(6)	110 OD RAIN WATER PIPE FOR (TERRACE)
(7)	90 OD RAIN WATER PIPE FOR (BALCONY)
(8)	C.W.S RISER PIPE
(9)	F.W.S RISER PIPE
(A)	SOLAR HOT WATER SUPPLY
PLUMBING NOTES:-	
1.	WASH BASIN TO MULTI TRAP (MT) 40Ø WASTE PIPE
2.	MULTI TRAP TO FLOOR TRAP 50 Od WASTE PIPE
3.	FLOOR DRAIN TO FLOOR TRAP 63 Od WASTE PIPE
4.	KITCHEN SINK TO FLOOR TRAP (FT) 40 Od WASTE PIPE
5.	BALCONY DRAIN TO VERTICAL 63 Od WASTE PIPE
6.	110 OD Upvc PIPE USED FOR SOIL & WASTE.
III	FT FLOOR TRAP 110X110mm
III	MT MULTI TRAP 110X50mm
III	FD FLOOR DRAIN 110X63mm
III	BD BALCONY DRAIN 110X63mm
III	LEDGEWALL FOR W.C & WB

PROJECT:
CEDAR LUXURIA
PATRAKAR COLONY, JAIPUR

CLIENT:
CEDAR
JAIPUR



ARCHITECT :
m|a architects
Jaipur - Bangalore - Hyderabad
maithel & associates architects pvt. ltd.
Plot No. -1, Lal Kothi Scheme, Jaipur-302001
Tel : 91 141 4299999
Fax : 91 141 2741664
email - studio@maarchitects.in,
web - www.maarchitects.in

MEP CONSULTANTS
SRAJAN ASSOCIATES
C-35A, NAKSHTRA PRIDE, LAJPAT MARG,
C-SCHEME, JAIPUR
snajaipur@hotmail.com




PLUMBING & FIRE CONSULTANTS:
 **BEHERA & ASSOCIATES**
F-623A, LADO SARAI, BEHIND CNG STATION
NEW DELHI - 110030
Ph: 011-40583839, 09811911853
Email: behera.associates@gmail.com


DRAWING TITLE :
PLUMBING DRAWING
BLOCK - B
TYP.TOILET DETAIL

DRAWN BY :	SONU	NORTH:
CHECKED BY :	SOMNATH	
DATE :	30-12-2014	SCALE : 1 : 125
PROJECT NO. :	GH-2030	DRAWING NO. : PL - BA - 201

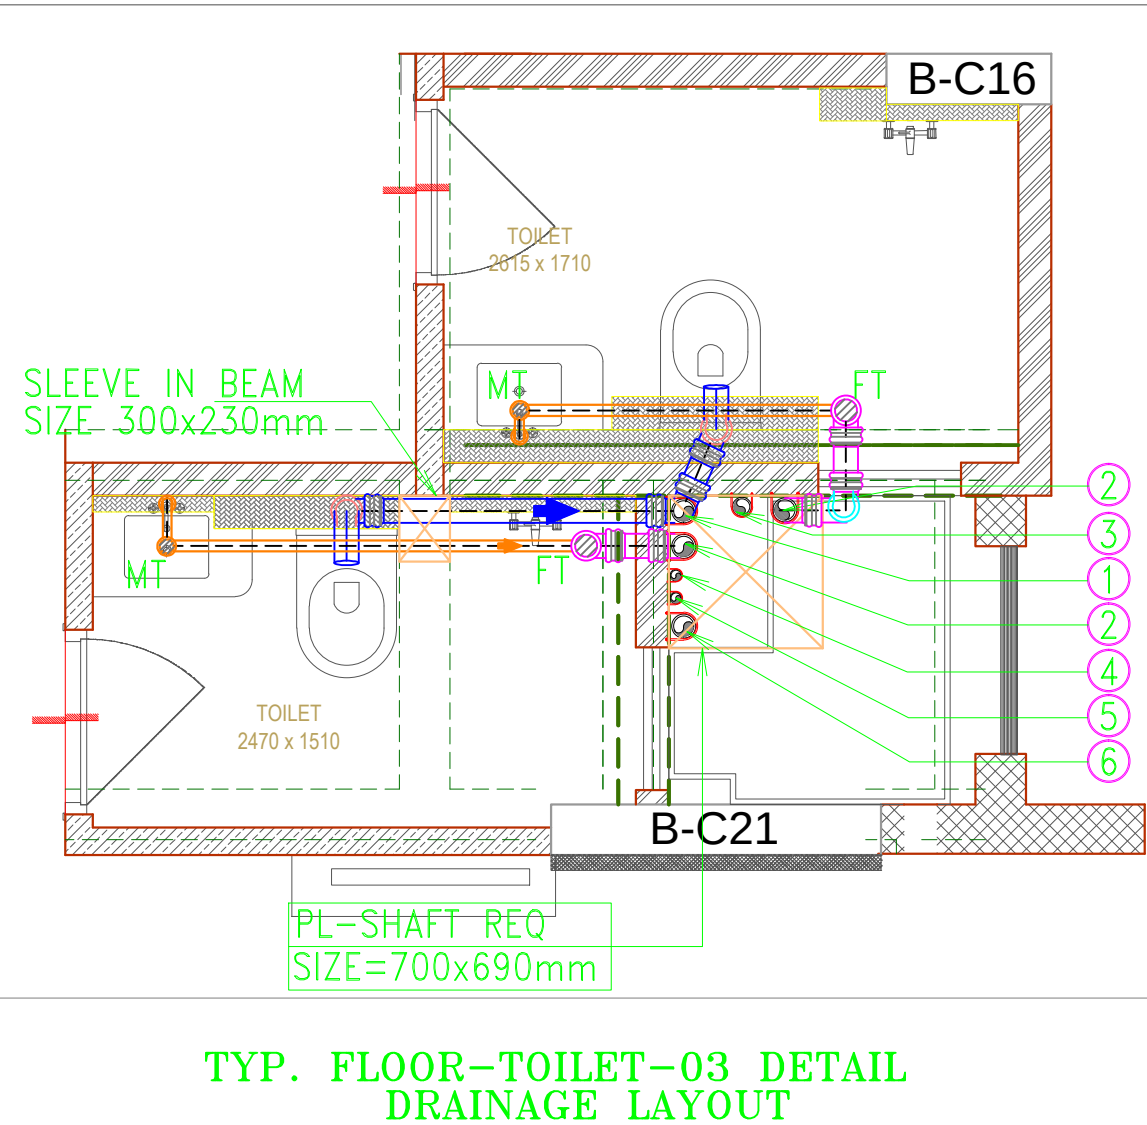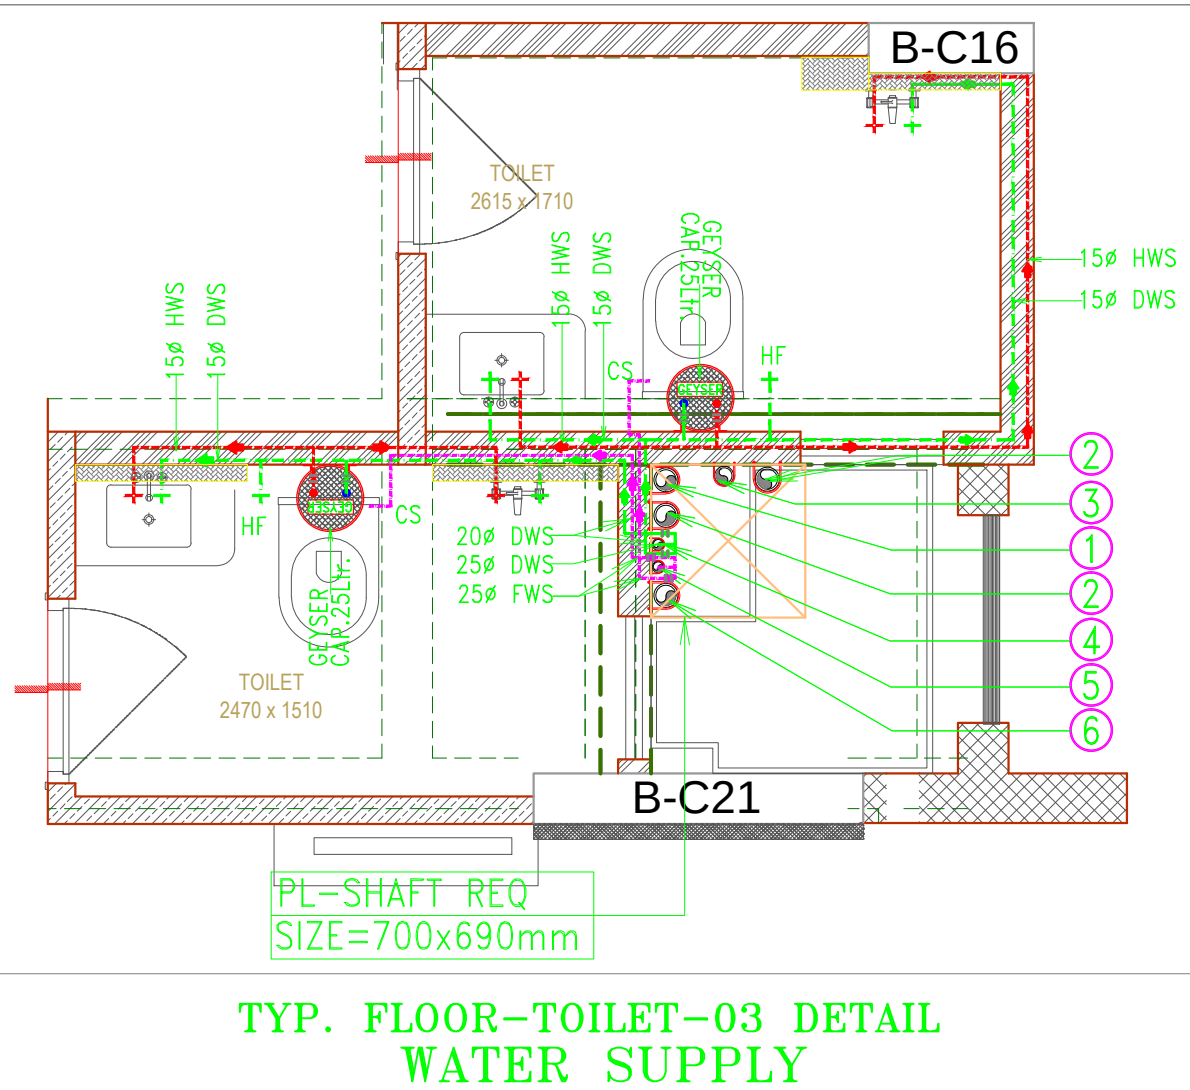


HF	HEALTH FAUCETS
CS	CISTERN
CWS	COLD WATER SUPPLY
FWS	FLUSHING WATER SUPPLY
HWS	HOT WATER SUPPLY

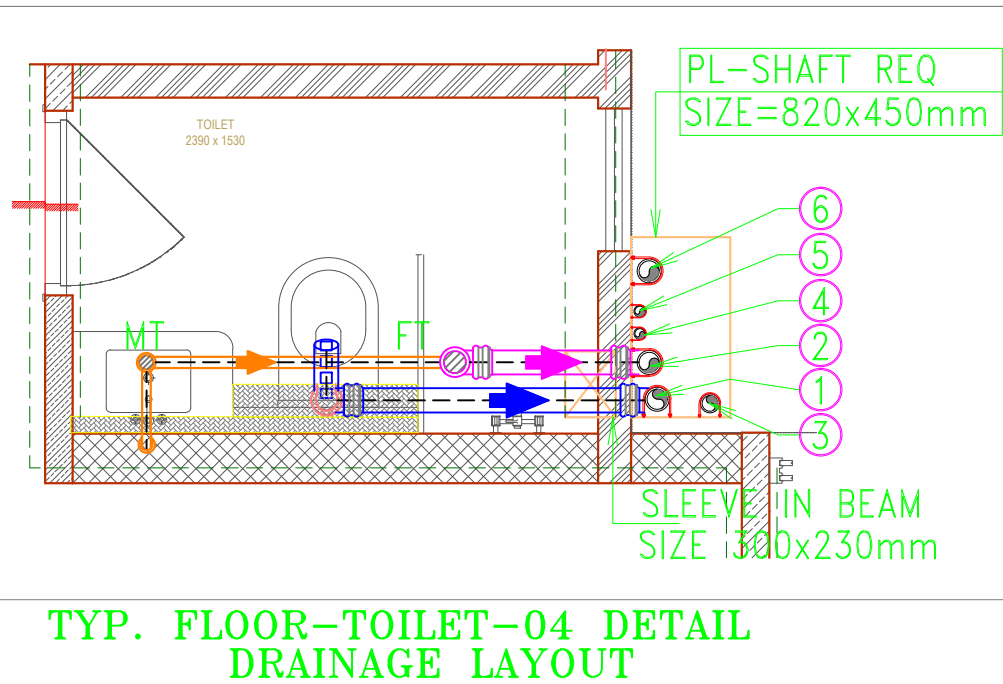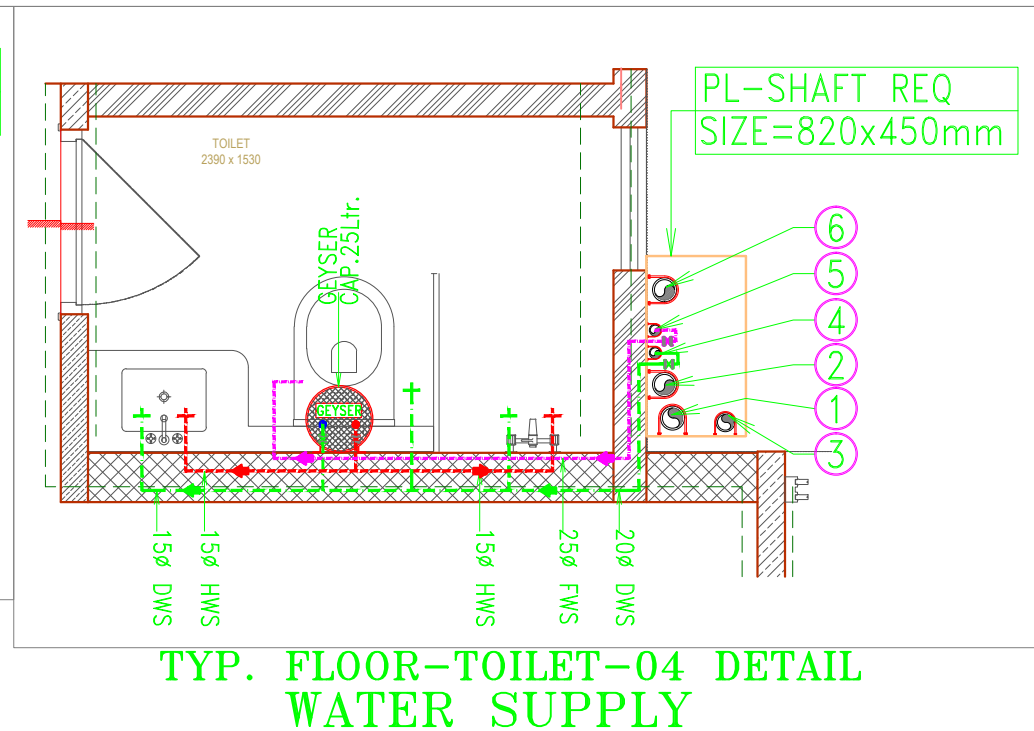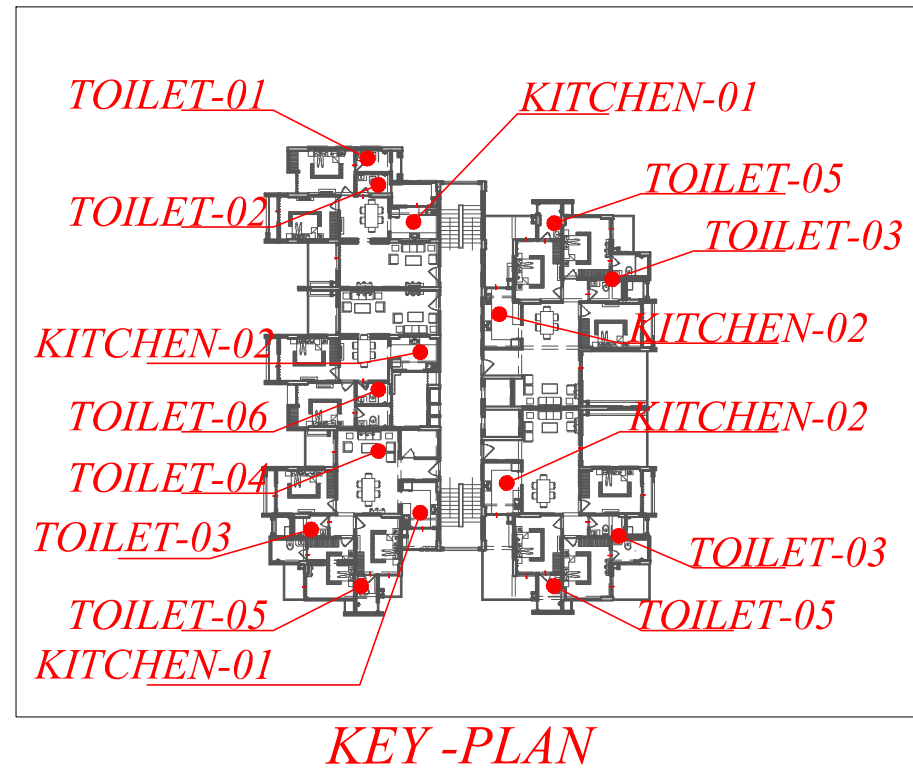


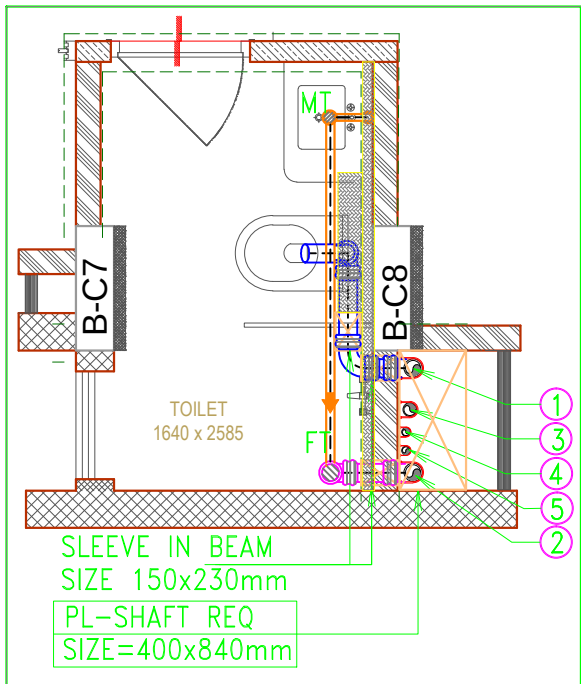


TYP. FLOOR-TOILET-05 DETAIL DRAINAGE LAYOUT

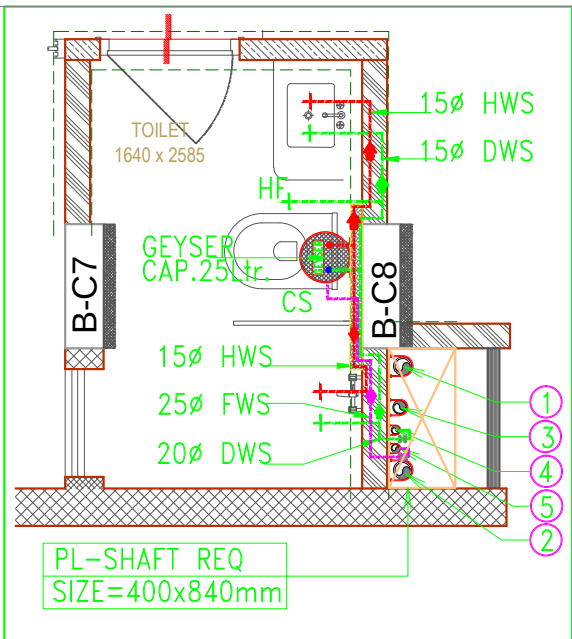


TYP. FLOOR-TOILET-05 DETAIL WATER SUPPLY

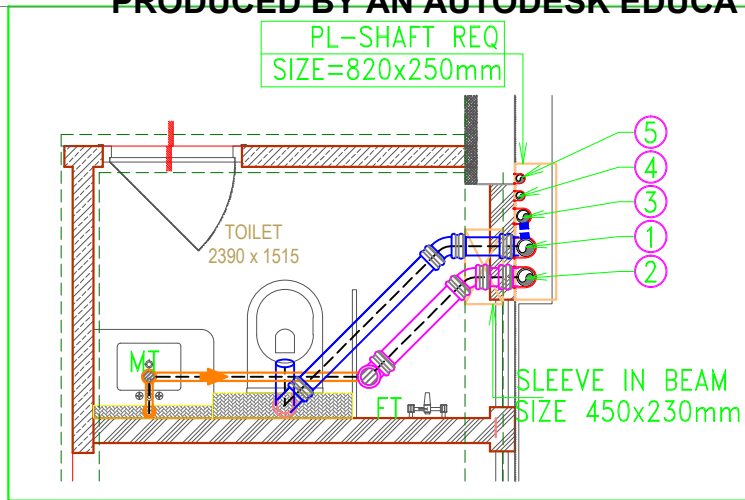


TYP. FLOOR-TOILET-06 DETAIL DRAINAGE LAYOUT

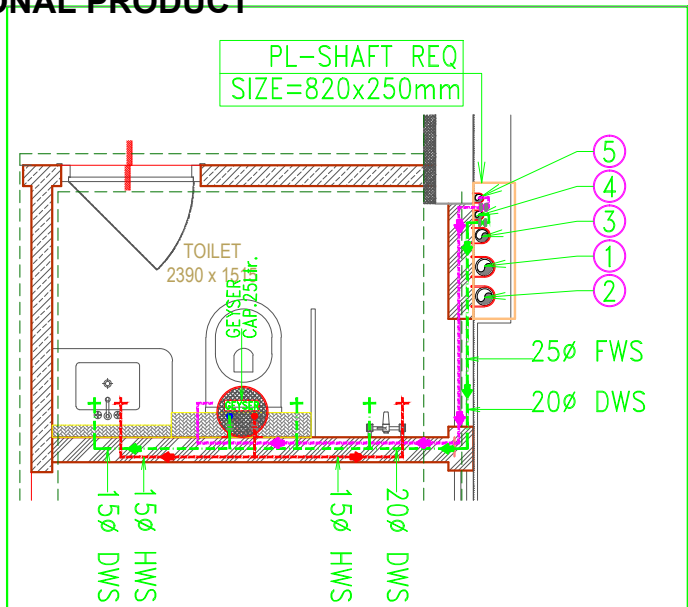


TYP. FLOOR-TOILET-06 DETAIL WATER SUPPLY

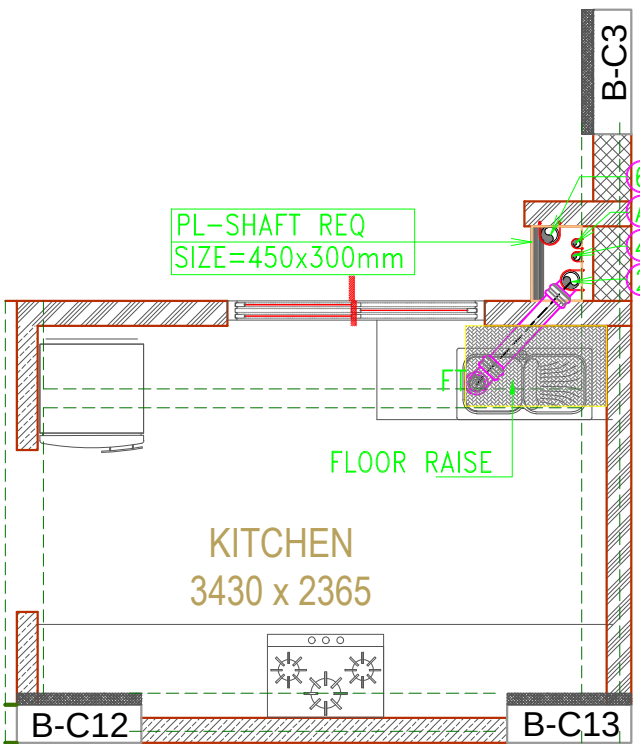


TYP. FLOOR-KITCHEN-01 DETAIL DRAINAGE LAYOUT

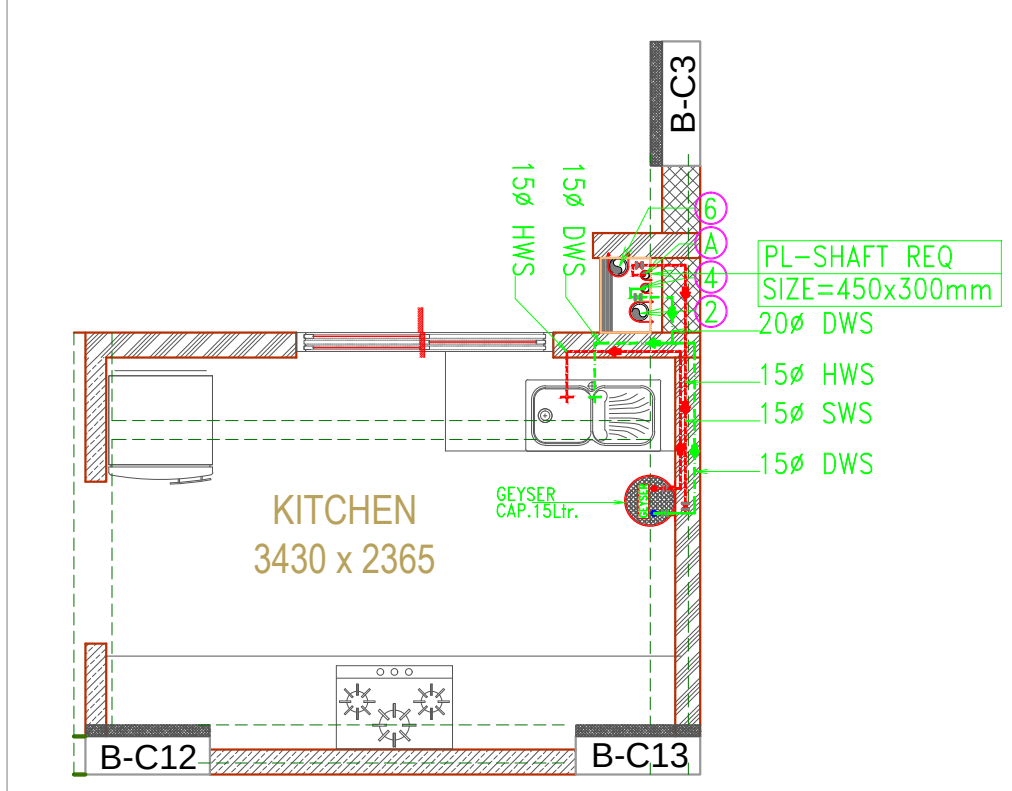


TYP. FLOOR-KITCHEN-01 DETAIL WATER SUPPLY

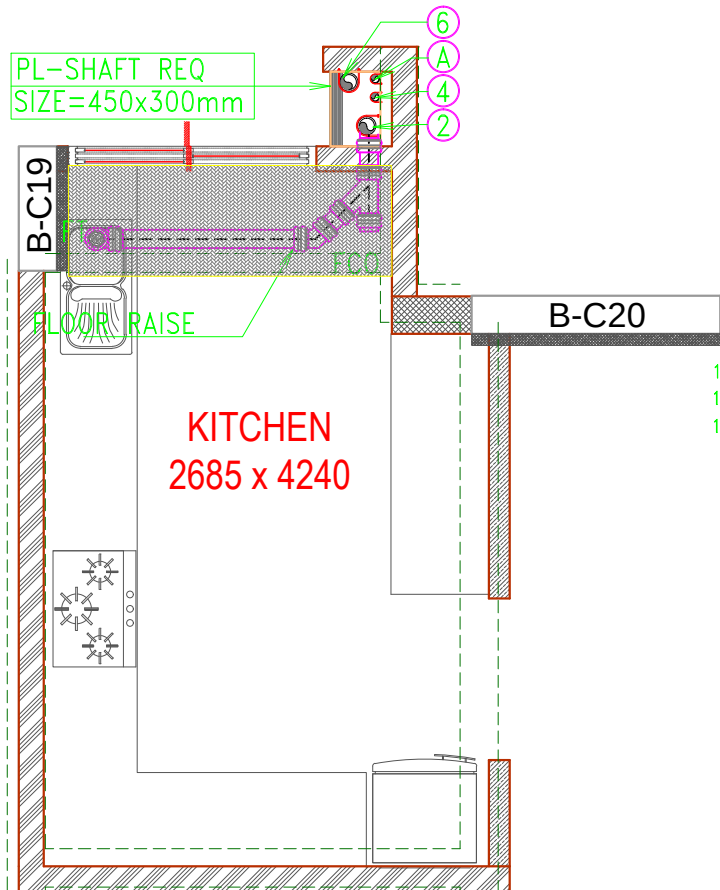

TYP. FLOOR-KITCHEN-02 DETAIL DRAINAGE LAYOUT

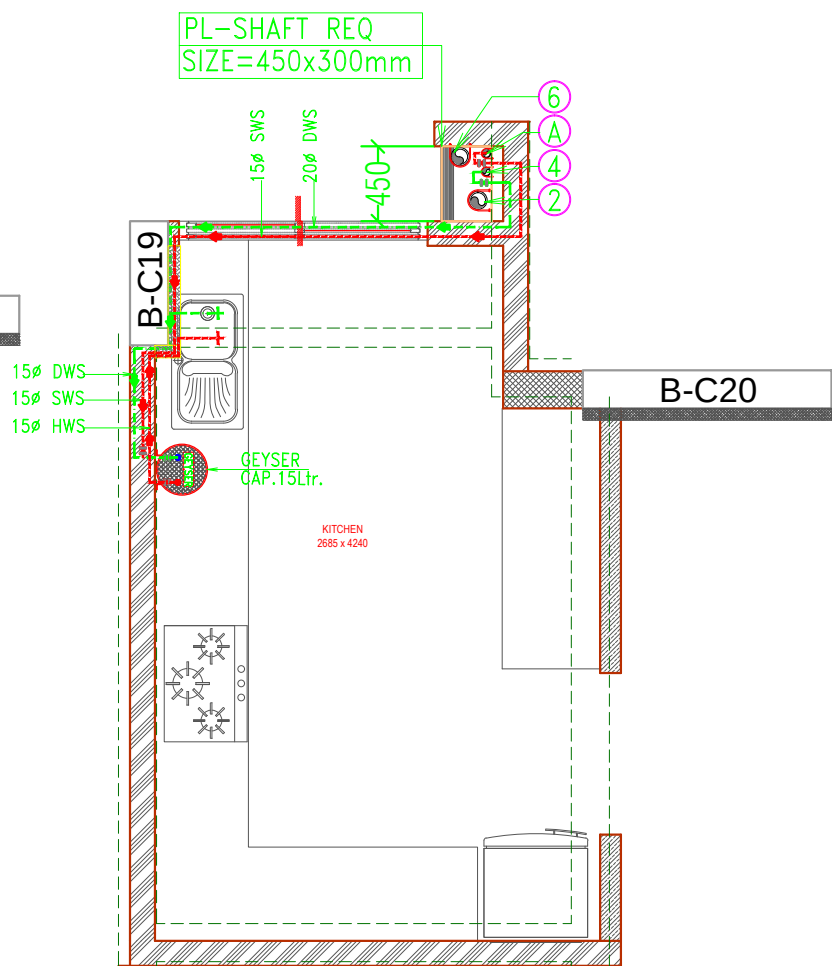

TYP. FLOOR-KITCHEN-02 DETAIL WATER SUPPLY

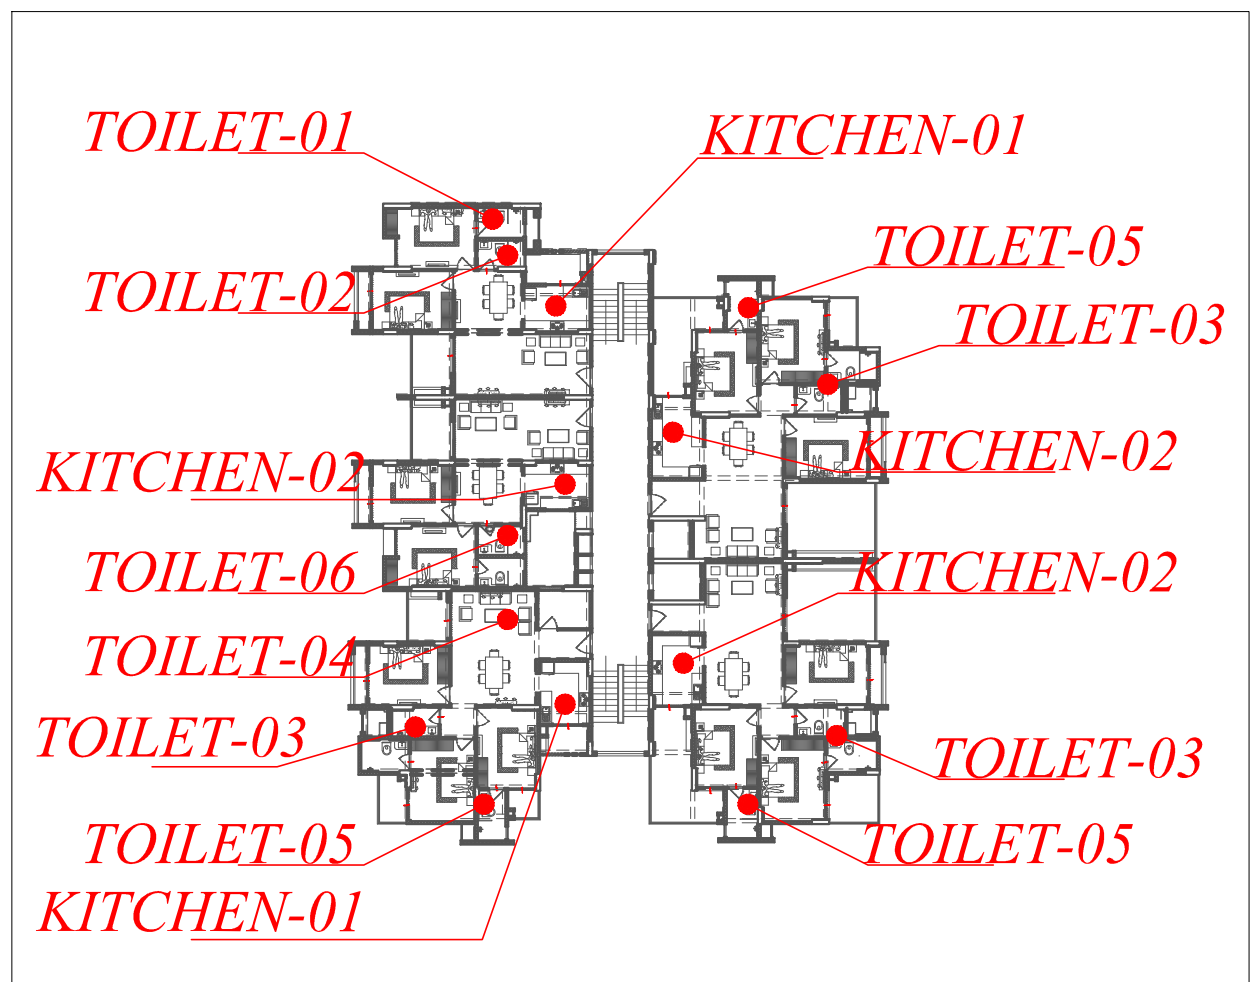

KEY-PLAN

PLUMBING LEGEND:-	
(1)	110 OD Upvc SOIL PIPE
(2)	110 OD Upvc WASTE PIPE
(3)	75ø A/S PIPE
(4)	C.W.S DOWN TAKE PIPE
(5)	F.W.S DOWN TAKE PIPE
(6)	110 OD RAIN WATER PIPE FOR (TERRACE)
(7)	90 OD RAIN WATER PIPE FOR (BALCONY)
(8)	C.W.S RISER PIPE
(9)	F.W.S RISER PIPE
(A)	SOLAR HOT WATER SUPPLY
PLUMBING NOTES:-	
1.	WASH BASIN TO MULTI TRAP (MT) 40ø WASTE PIPE
2.	MULTI TRAP TO FLOOR TRAP 50 Od WASTE PIPE
3.	FLOOR DRAIN TO FLOOR TRAP 63 Od WASTE PIPE
4.	KITCHEN SINK TO FLOOR TRAP (FT) 40 Od WASTE PIPE
5.	BALCONY DRAIN TO VERTICAL 63 Od WASTE PIPE
6.	110 OD Upvc PIPE USED FOR SOIL & WASTE.
Ⓜ	FT FLOOR TRAP 110X110mm
Ⓜ	MT MULTI TRAP 110X50mm
Ⓜ	FD FLOOR DRAIN 110X63mm
Ⓜ	BD BALCONY DRAIN 110X63mm
—	LEDGEWALL FOR W.C & WB
HF	HEALTH FAUCETS
CS	CISTERN
CWS	COLD WATER SUPPLY
FWS	FLUSHING WATER SUPPLY
HWS	HOT WATER SUPPLY

PROJECT:

CEDAR LUXURIA
PATRAKAR COLONY, JAIPUR

CLIENT :

CEDAR
JAIPUR

ARCHITECT :

m|a|architects
Jaipur - Bangalore - Hyderabad
maithel & associates architects pvt. ltd.
Plot No. -1, Lal Kothi Scheme, Jaipur-302001
Tel : 91 141 4299999
Fax : 91 141 2741664
email - studio@maarchitects.in,
web - www.maarchitects.in

MEP CONSULTANTS

SRAJAN ASSOCIATES
C-35A, NAKSHTRA PRIDE, LAJPAT MARG,
C-SCHEME, JAIPUR
snajaipur@hotmail.com

PLUMBING & FIRE CONSULTANTS:

BEHERA & ASSOCIATES
F-623A, LADO SARAI, BEHIND CNG STATION
NEW DELHI - 110030
Ph: 011-40583639, 09811911853
Email: behera.associates@gmail.com

DRAWING TITLE :

PLUMBING DRAWING
BLOCK - B
TYP. TOILET DETAIL

DRAWN BY :

SONU

CHECKED BY :

SOMNATH

DATE :


30-12-2014

PROJECT NO. :


GH-2030

DRAWING NO. :


PL - BA - 201

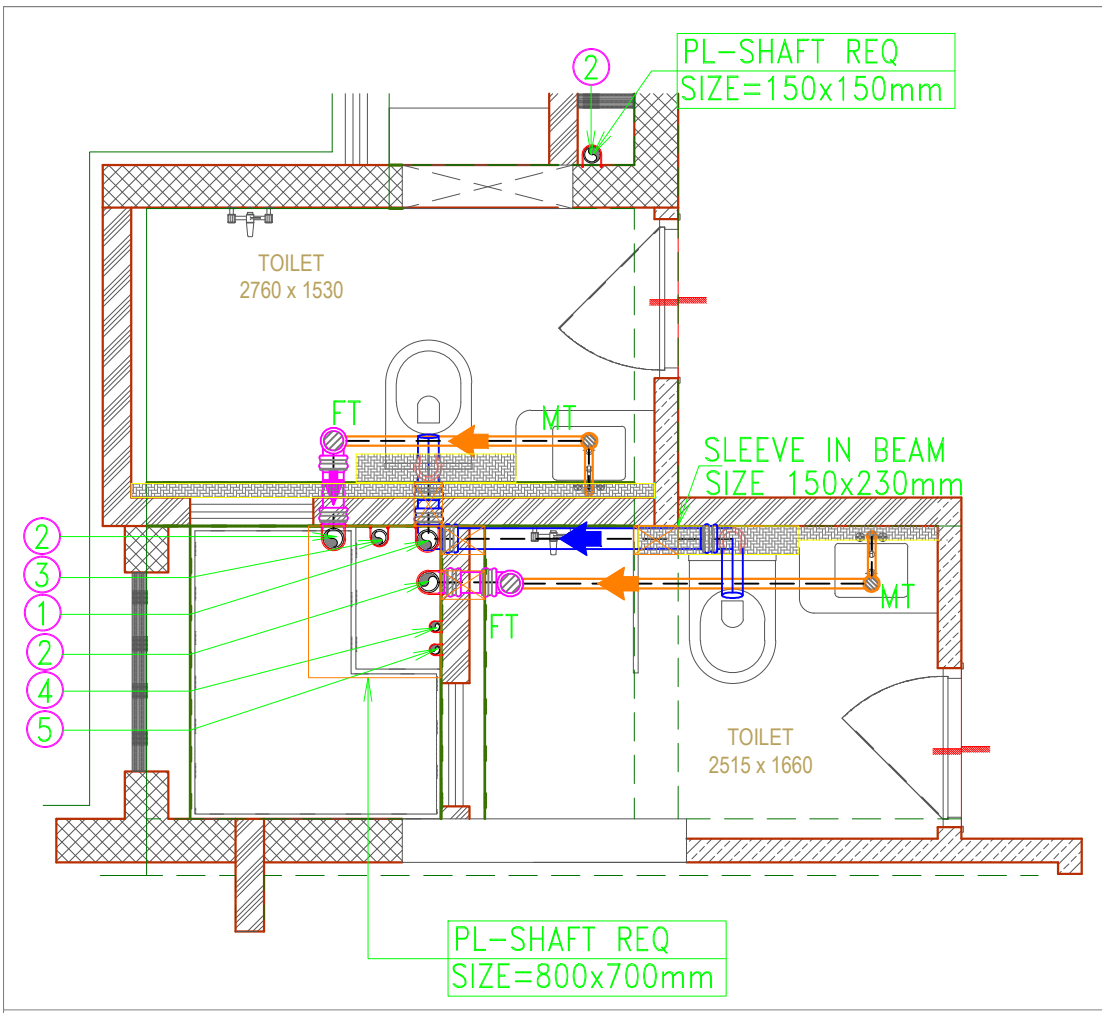


TYP. FLOOR-TOILET-01 DETAIL DRAINAGE LAYOUT

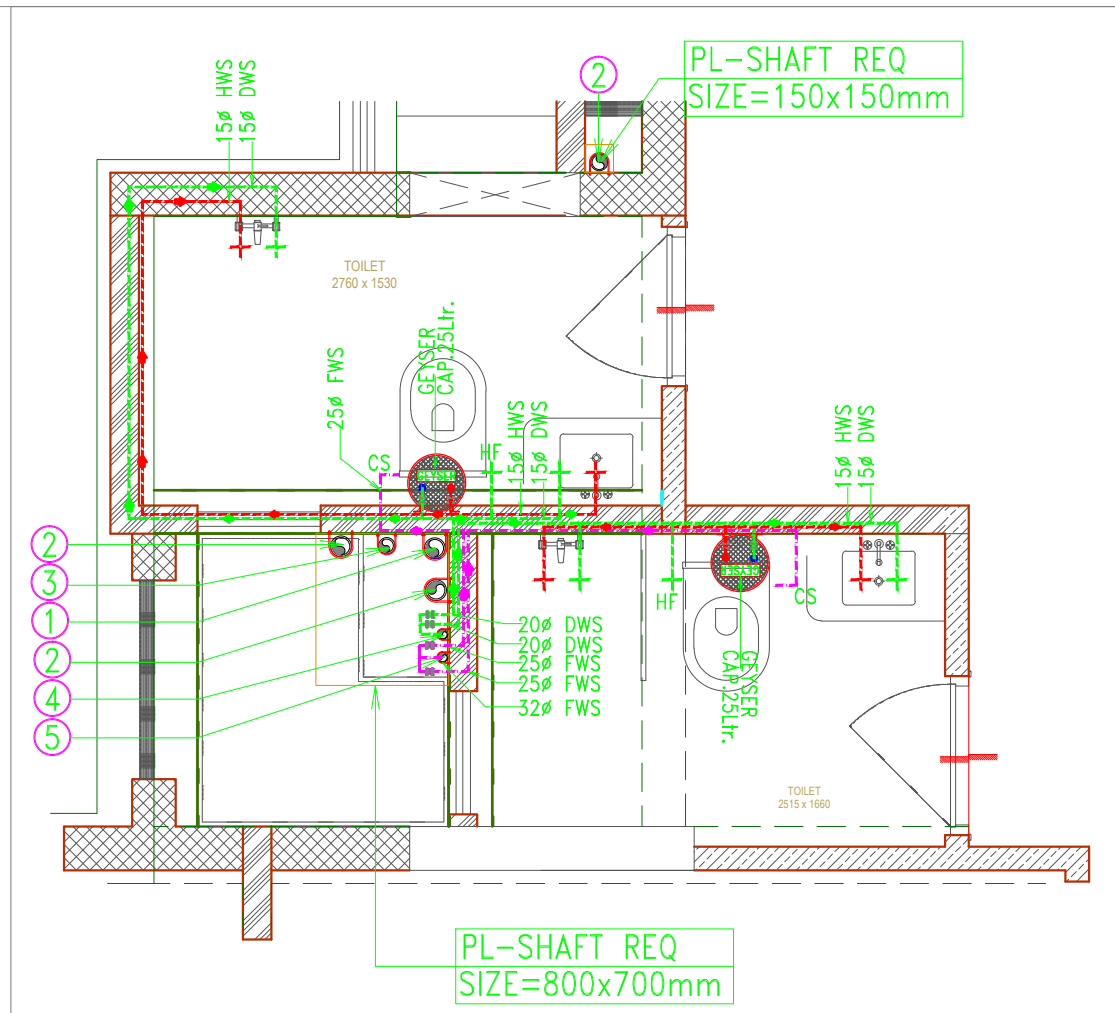


TYP. FLOOR-TOILET-01 DETAIL WATER SUPPLY

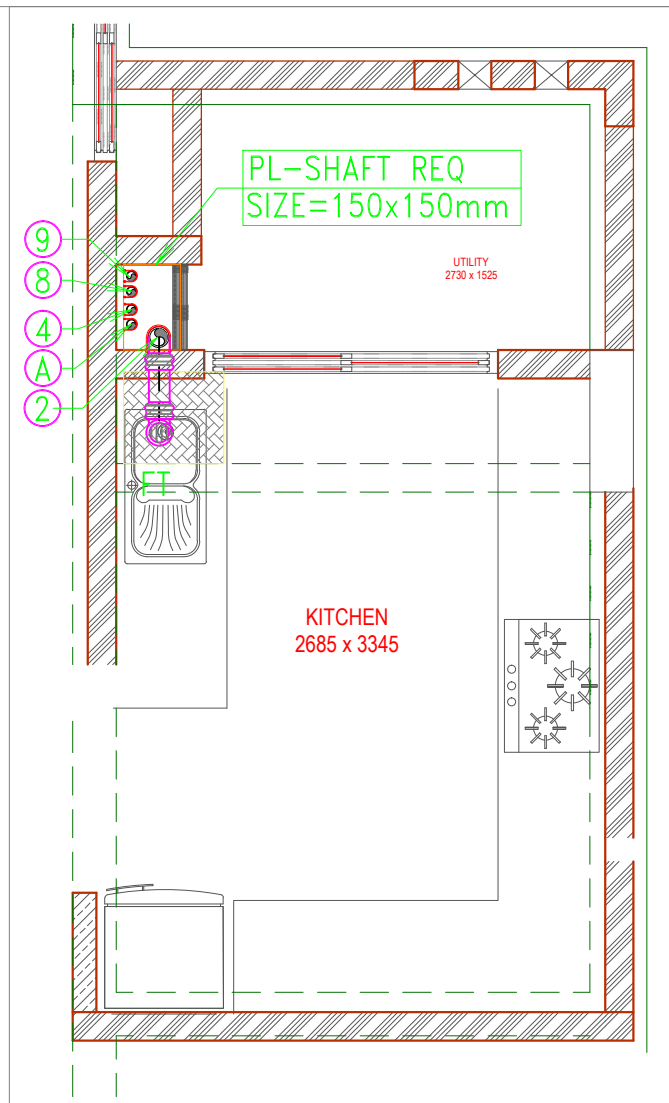


TYP. FLOOR-KITCHEN-01 DETAIL DRAINAGE LAYOUT

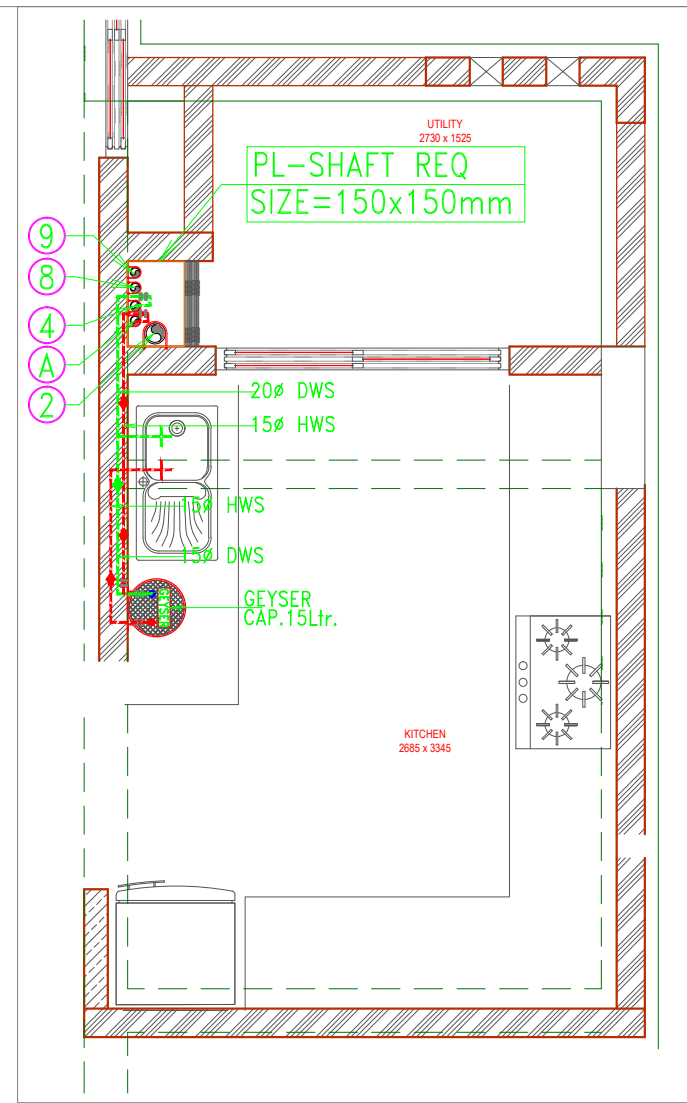


TYP. FLOOR-KITCHEN-01 DETAIL WATER SUPPLY

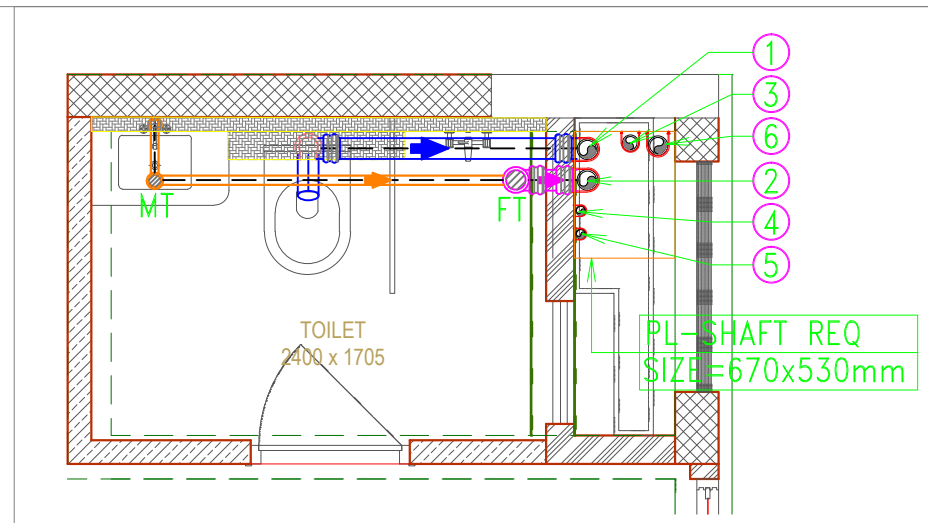


TYP. FLOOR-TOILET-02 DETAIL DRAINAGE LAYOUT

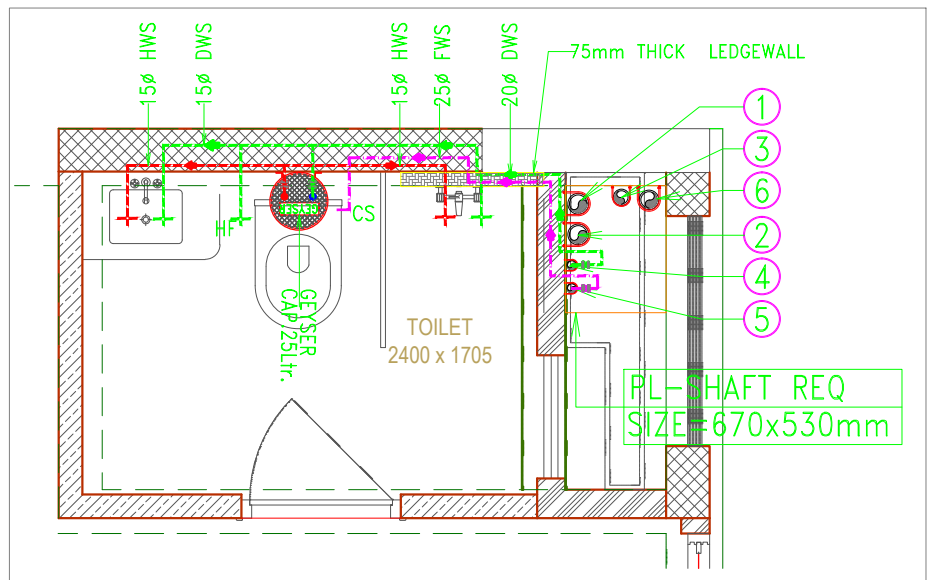


TYP. FLOOR-TOILET-02 DETAIL WATER SUPPLY

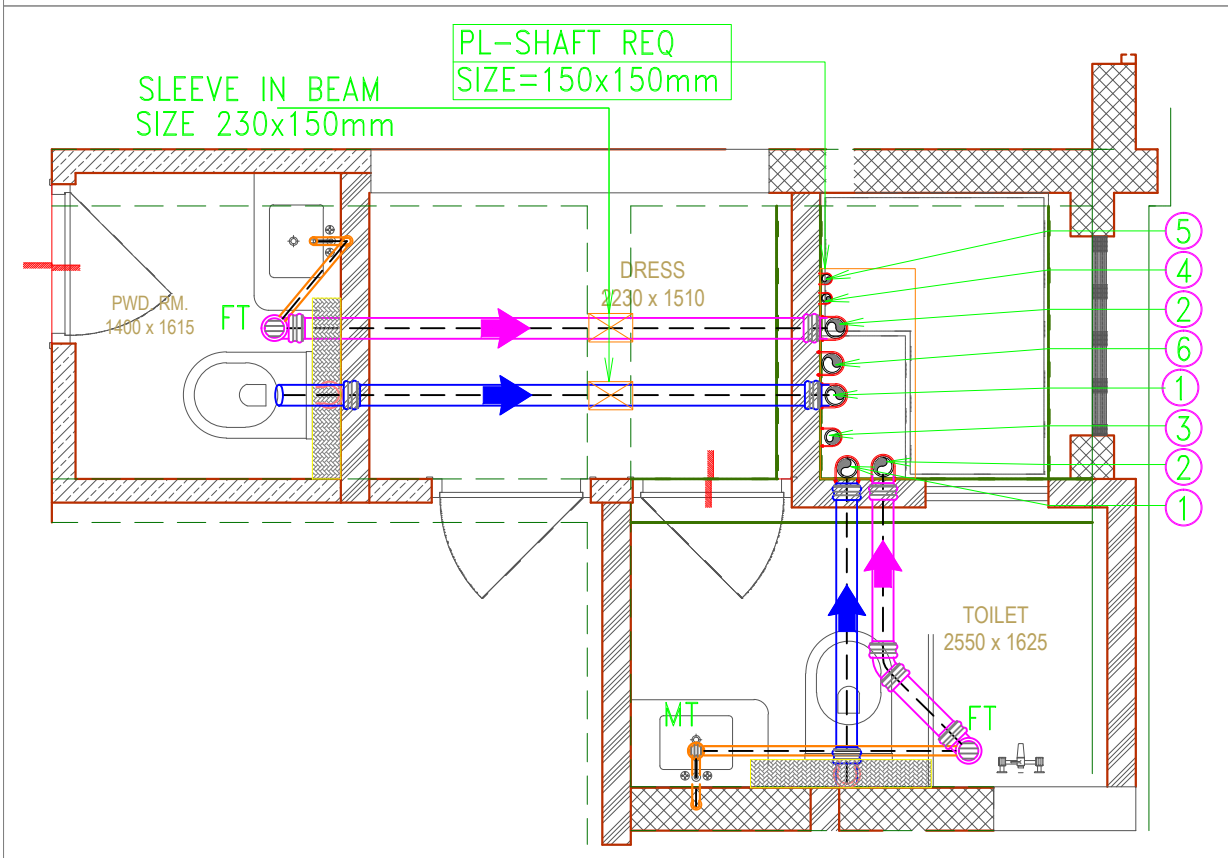


TYP. FLOOR-TOILET-03 DETAIL DRAINAGE LAYOUT

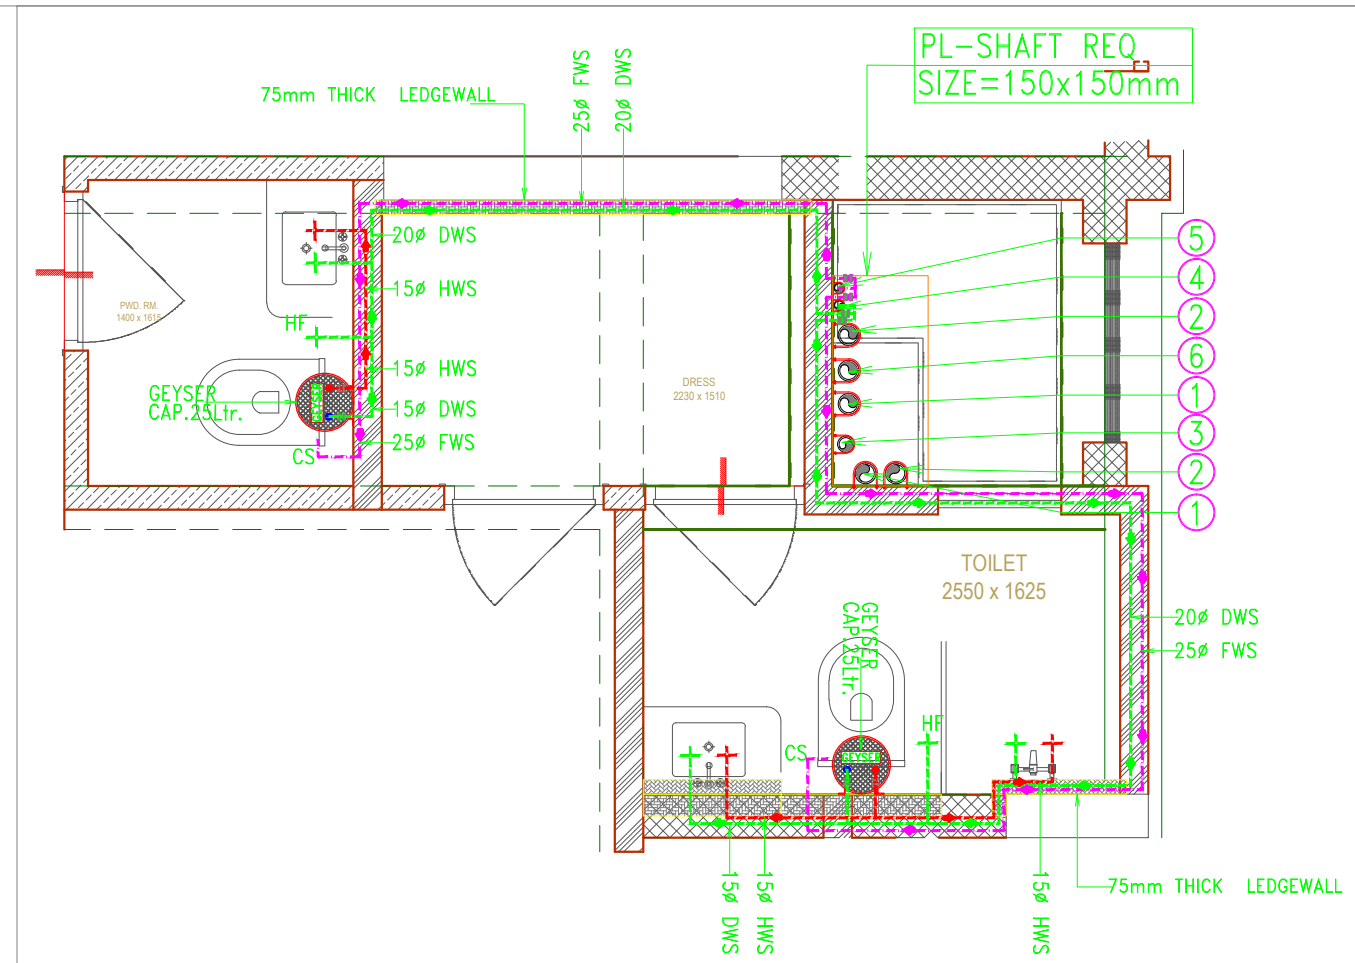

TYP. FLOOR-TOILET-03 DETAIL WATER SUPPLY

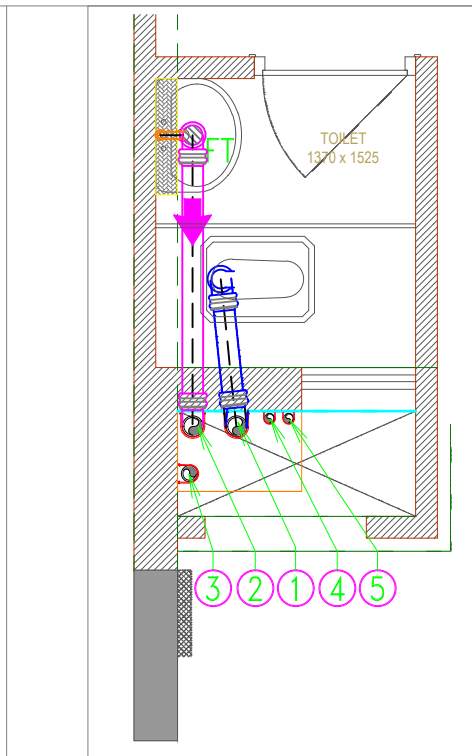


TYP. FLOOR-TOILET-04 DETAIL DRAINAGE LAYOUT

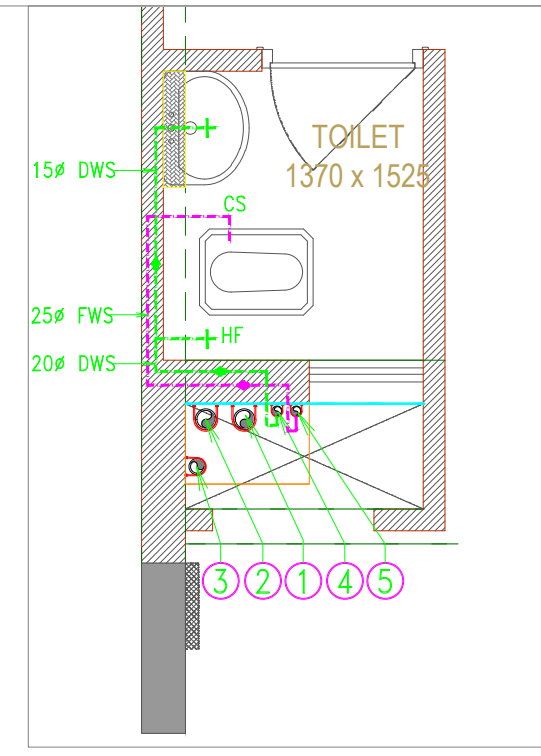


TYP. FLOOR-TOILET-04 DETAIL WATER SUPPLY


HF	HEALTH FAUCETS
CS	CISTERN
CWS	COLD WATER SUPPLY
FWS	FLUSHING WATER SUPPLY
HWS	HOT WATER SUPPLY

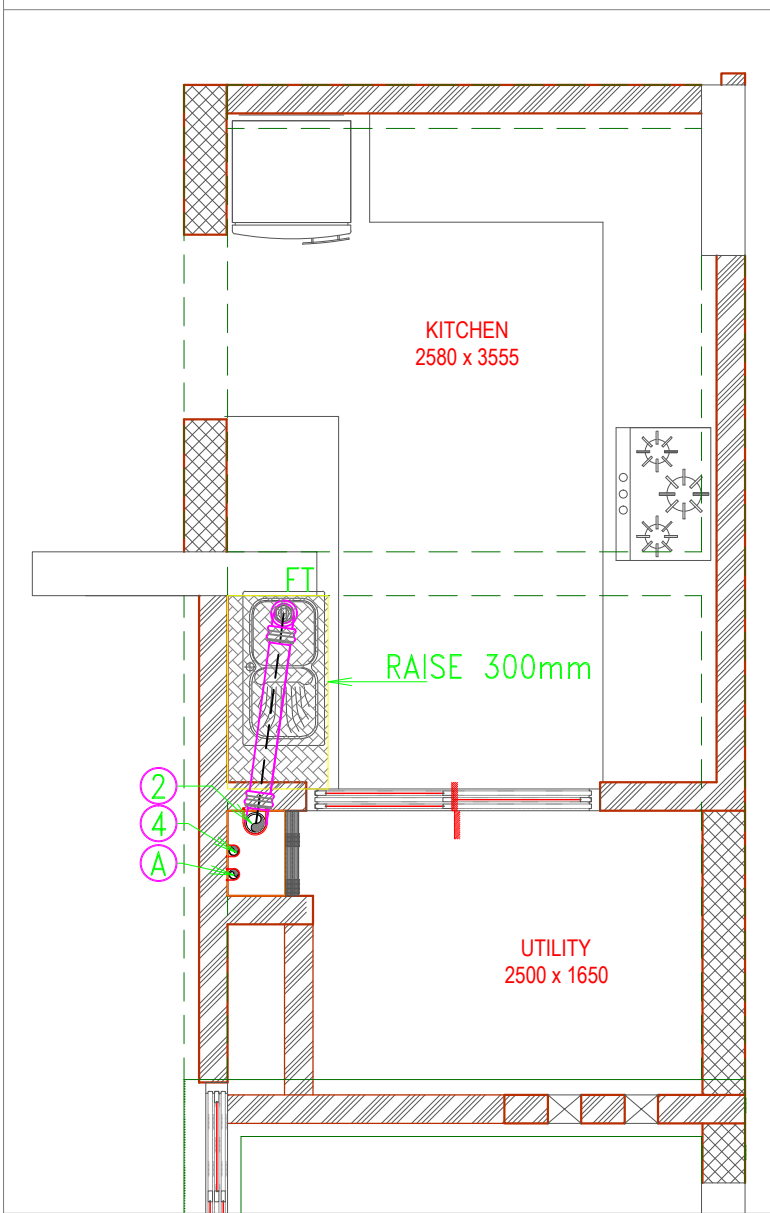

TYP. FLOOR-KITCHEN-01 DETAIL DRAINAGE LAYOUT

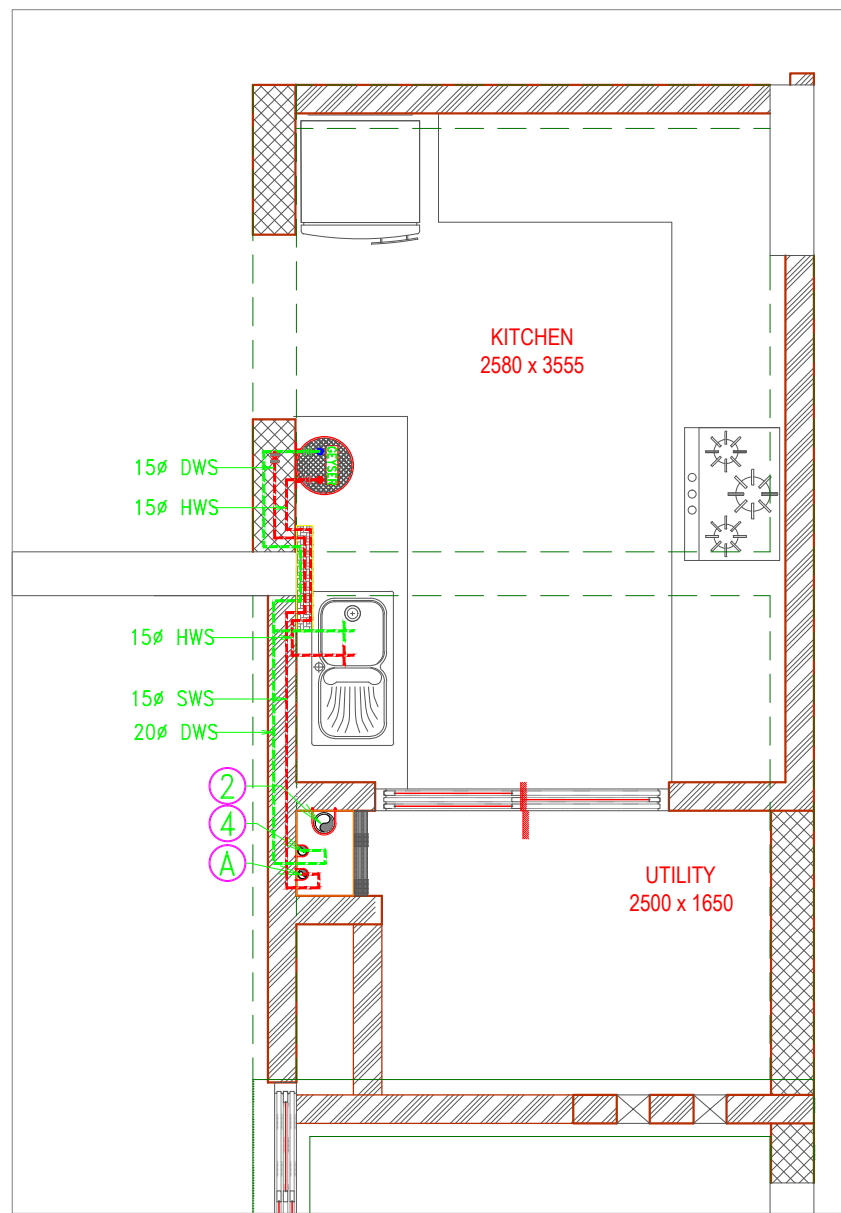

TYP. FLOOR-KITCHEN-01 DETAIL WATER SUPPLY

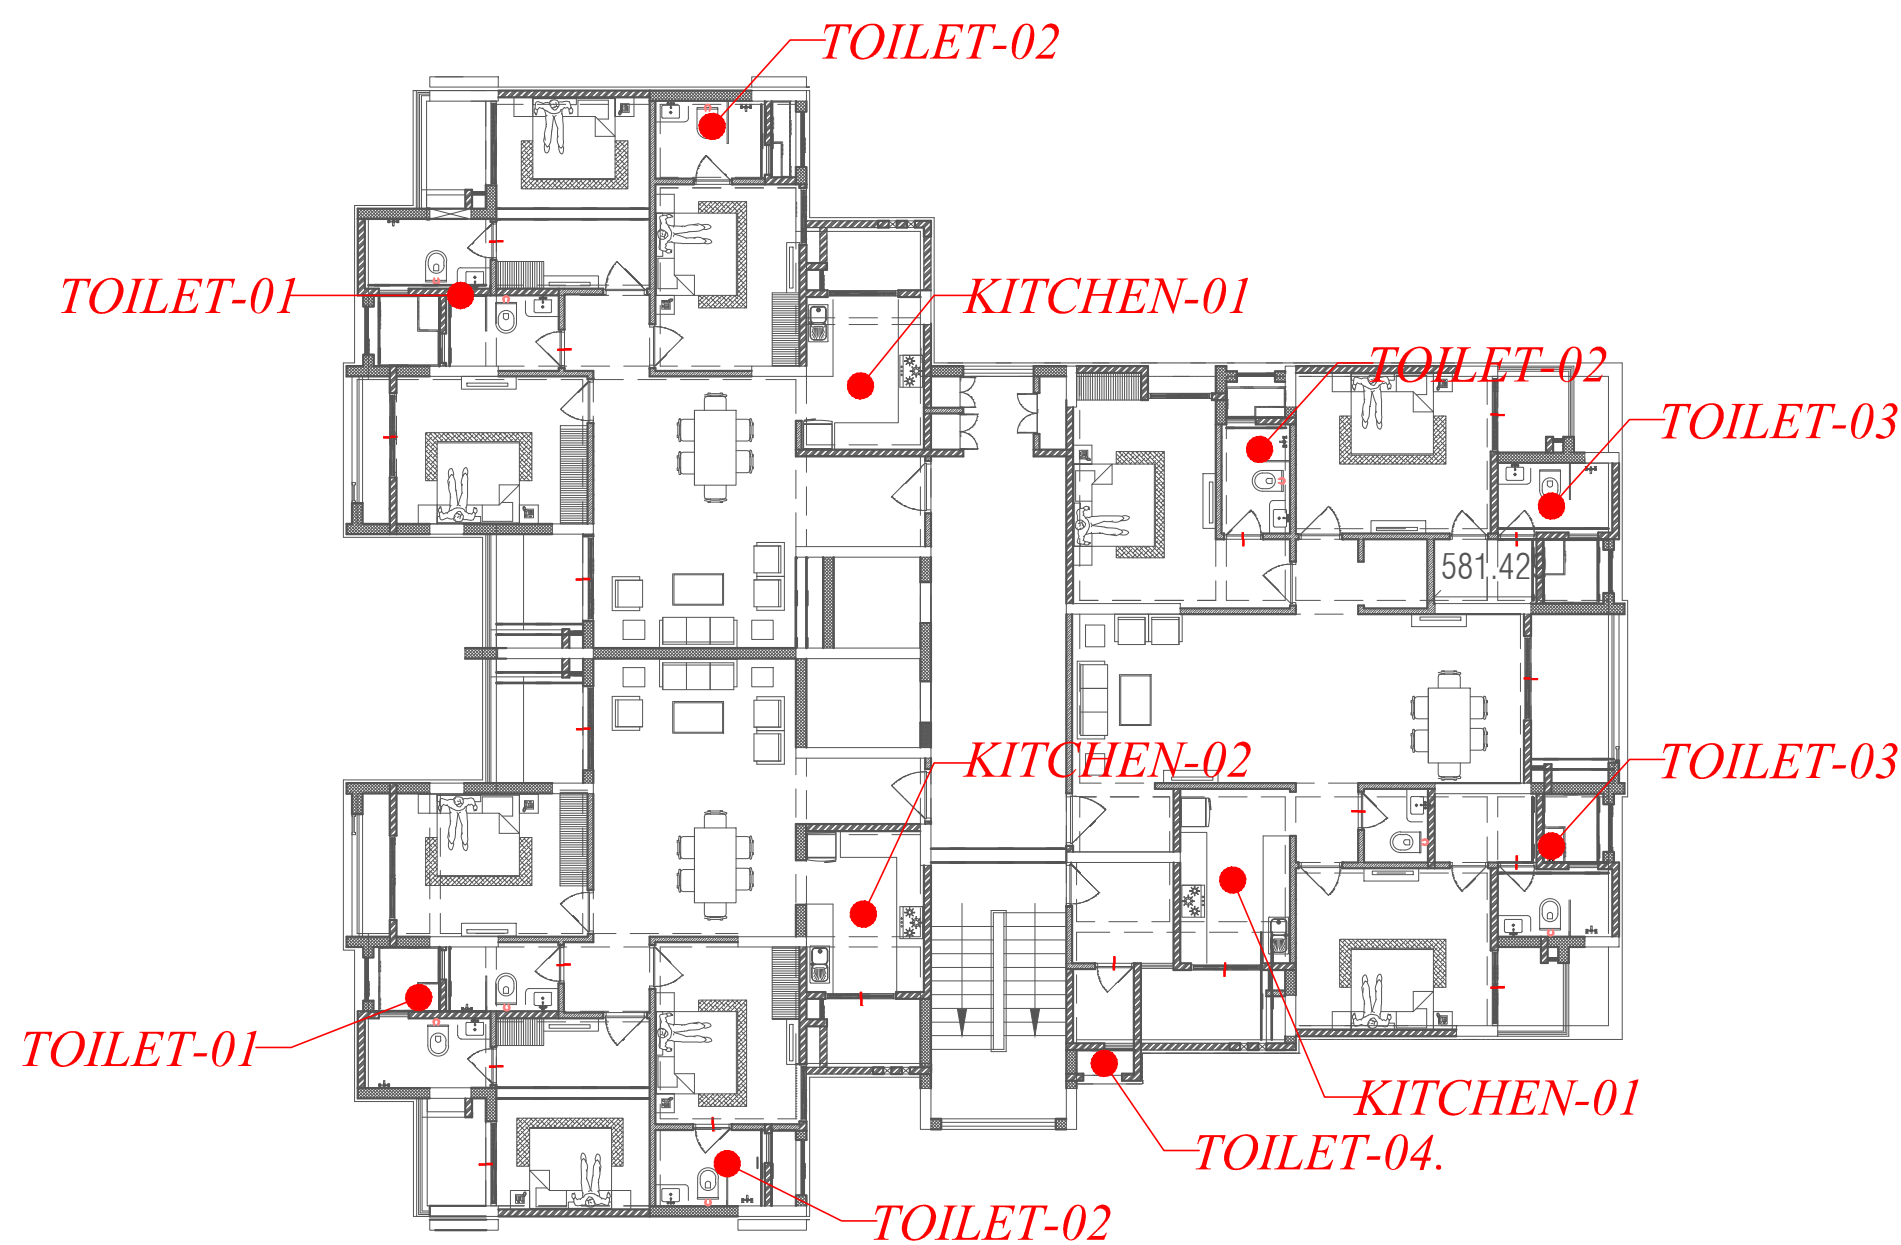

KEY-PLAN

PLUMBING LEGEND:-	
(1)	110 OD Upvc SOIL PIPE
(2)	110 OD Upvc WASTE PIPE
(3)	75ø A/S PIPE
(4)	C.W.S DOWN TAKE PIPE
(5)	F.W.S DOWN TAKE PIPE
(6)	110 OD RAIN WATER PIPE FOR (TERRACE)
(7)	90 OD RAIN WATER PIPE FOR (BALCONY)
(8)	C.W.S RISER PIPE
(9)	F.W.S RISER PIPE
(A)	SOLAR HOT WATER SUPPLY

PLUMBING NOTES:-	
1.	WASH BASIN TO MULTI TRAP (MT) 40ø WASTE PIPE
2.	MULTI TRAP TO FLOOR TRAP 50 Od WASTE PIPE
3.	FLOOR DRAIN TO FLOOR TRAP 63 Od WASTE PIPE
4.	KITCHEN SINK TO FLOOR TRAP (FT) 40 Od WASTE PIPE
5.	BALCONY DRAIN TO VERTICAL 63 Od WASTE PIPE
6.	110 OD Upvc PIPE USED FOR SOIL & WASTE.


Ⓜ	FT FLOOR TRAP 110X110mm
Ⓜ	MT MULTI TRAP 110X50mm
Ⓜ	FD FLOOR DRAIN 110X63mm
Ⓜ	BD BALCONY DRAIN 110X63mm
—	LEDGEWALL FOR W.C & W.B


PROJECT:
CEDAR LUXURIA
PATRAKAR COLONY, JAIPUR


CLIENT:
CEDAR
JAIPUR

ARCHITECT:
m|a|architects
Jaipur - Bangalore - Hyderabad
maithel & associates architects pvt. ltd.
Plot No. -1, Lal Kothi Scheme, Jaipur-302001
Tel : 91 141 4299999
Fax : 91 141 2741664
email - studio@maarchitects.in,
web - www.maarchitects.in


MEP CONSULTANTS
SRAJAN ASSOCIATES
C-35A, NAKSHTRA PRIDE, LAJPAT MARG,
C-SCHEME, JAIPUR
snajaipur@hotmail.com

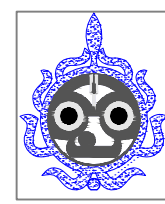PLUMBING & FIRE CONSULTANTS:
**BEHERA & ASSOCIATES**
F-623A, LADO SARAI, BEHIND CNG STATION
NEW DELHI - 110030
Ph: 011-40583839, 09811911853
Email: behera.associates@gmail.com

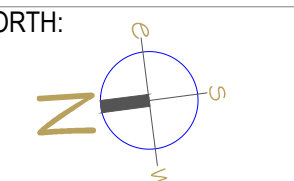
No.	ISSUED FOR :	DATE :	CKD:
DRAWING TITLE : PLUMBING DRAWING BLOCK - C TYP. TOILET DETAIL			
DRAWN BY :	SONU	NORTH:	
CHECKED BY :	SOMNATH	SCALE :	
DATE :	28-10-2014	SCALE :	1 : 125
PROJECT NO. :	GH-2030	DRAWING NO. :	PL - BA - 201

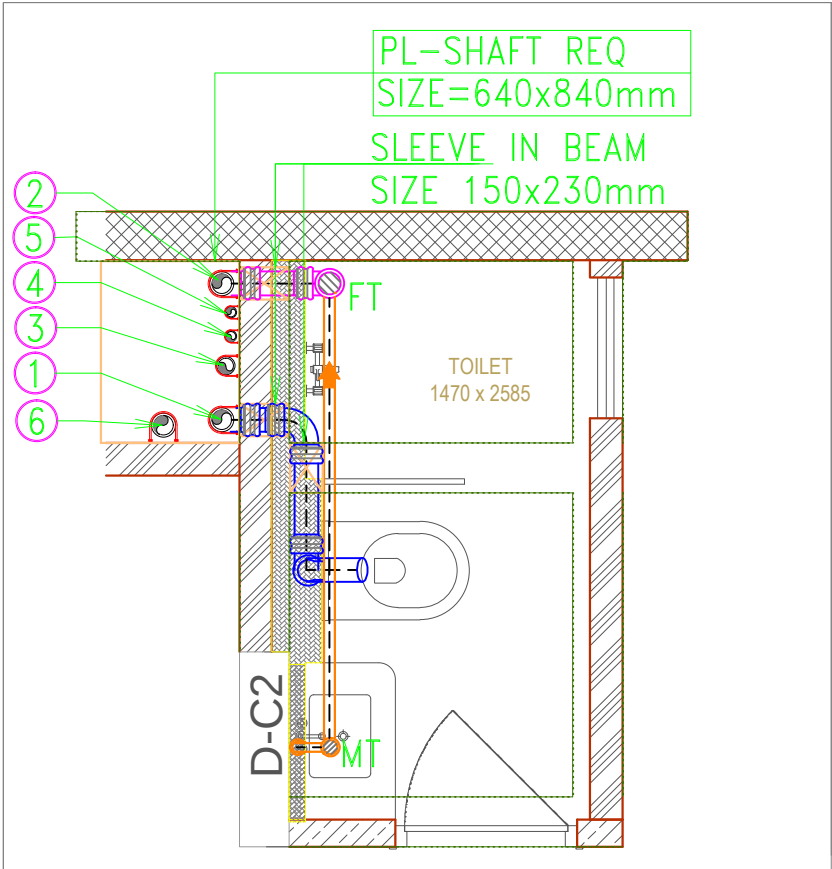


TYP. FLOOR-TOILET-01 DETAIL DRAINAGE LAYOUT

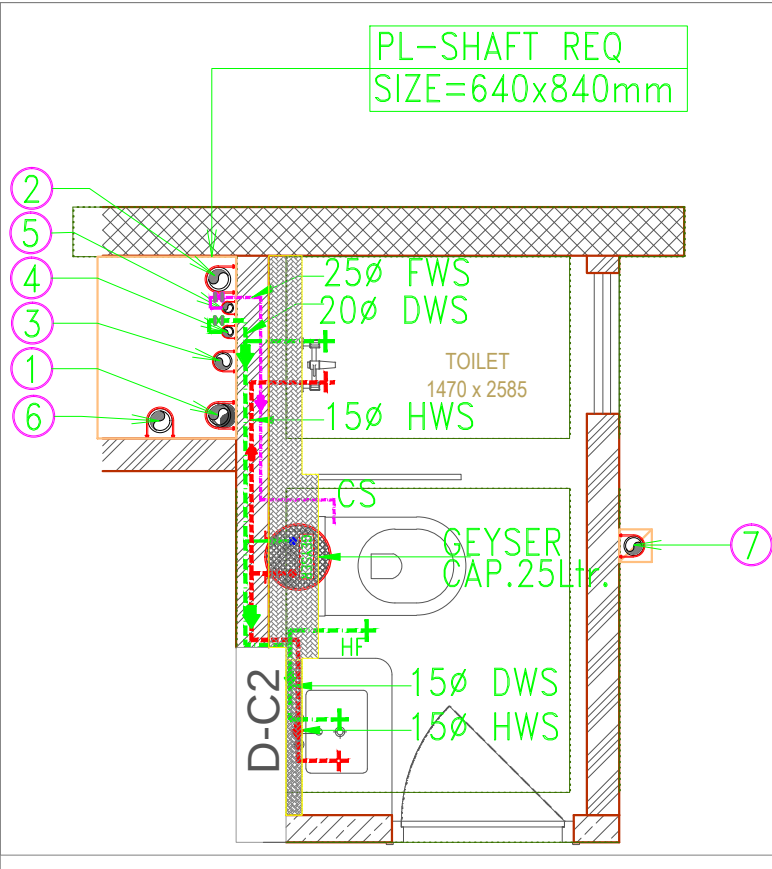


TYP. FLOOR-TOILET-01 DETAIL WATER SUPPLY

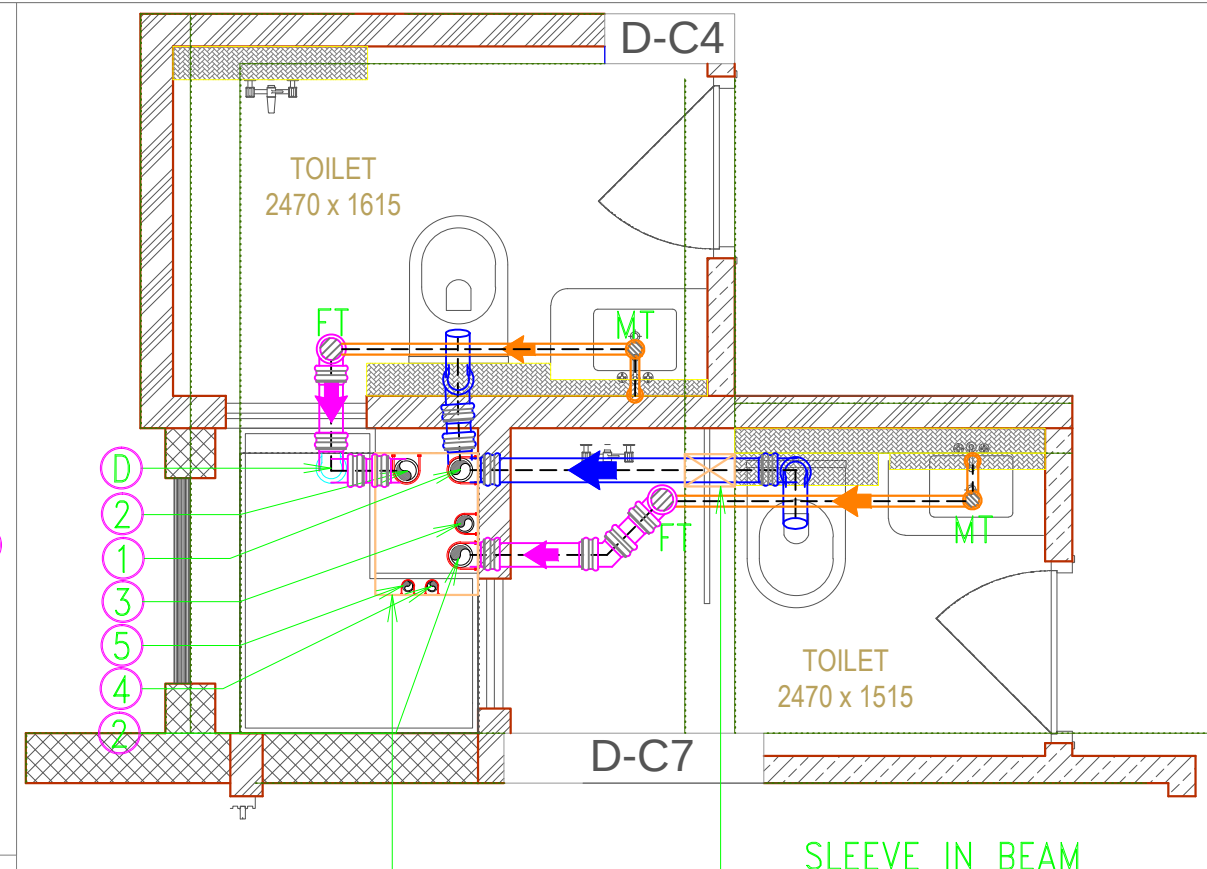


TYP. FLOOR-TOILET-02 DETAIL DRAINAGE LAYOUT

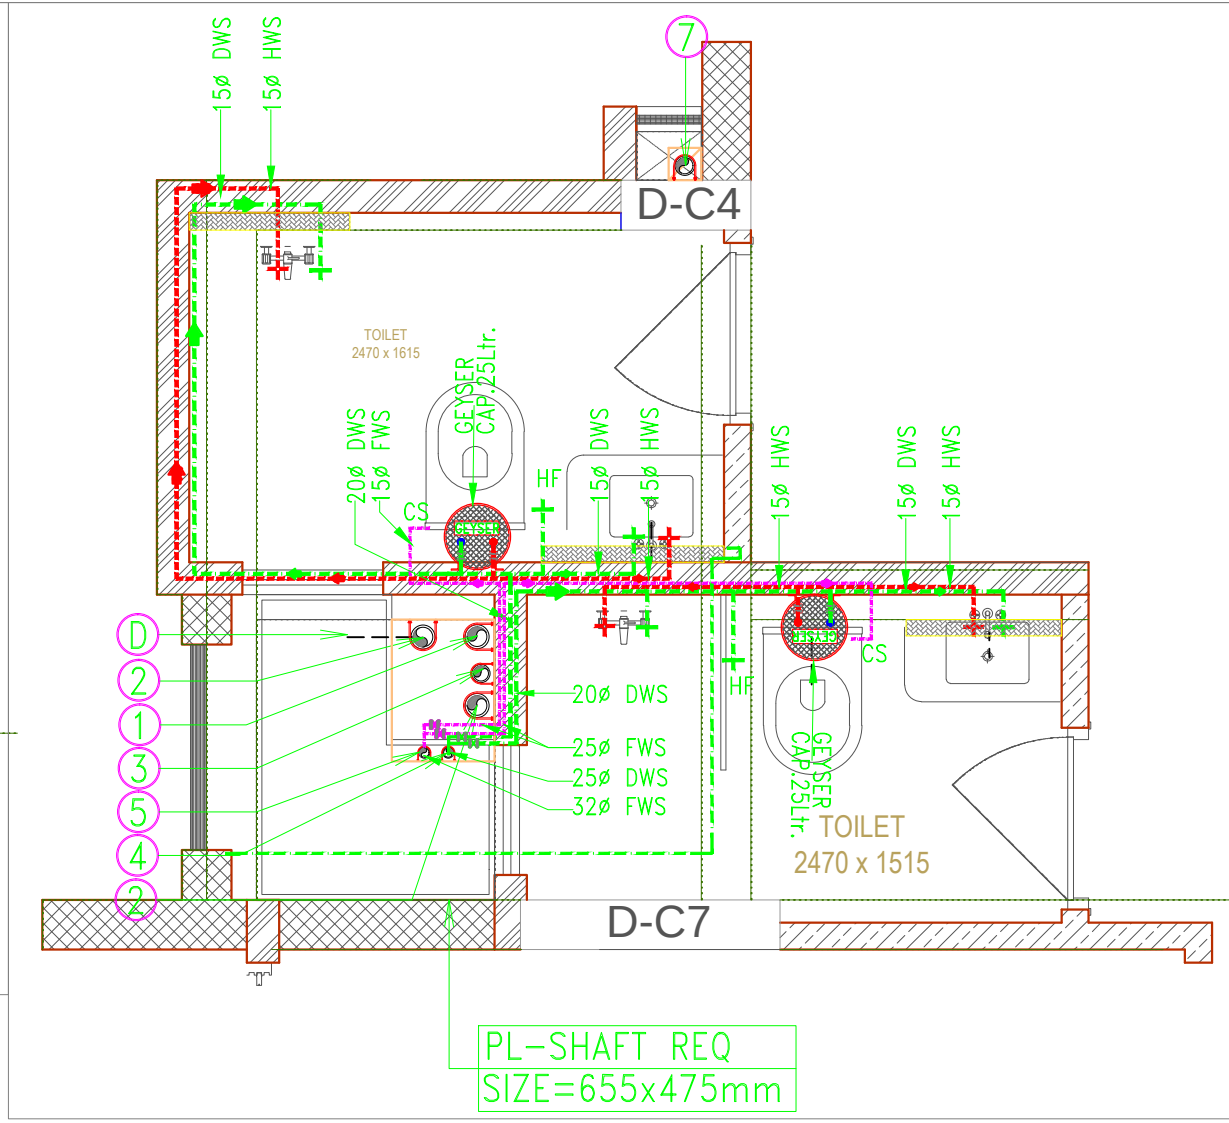


TYP. FLOOR-TOILET-02 DETAIL WATER SUPPLY

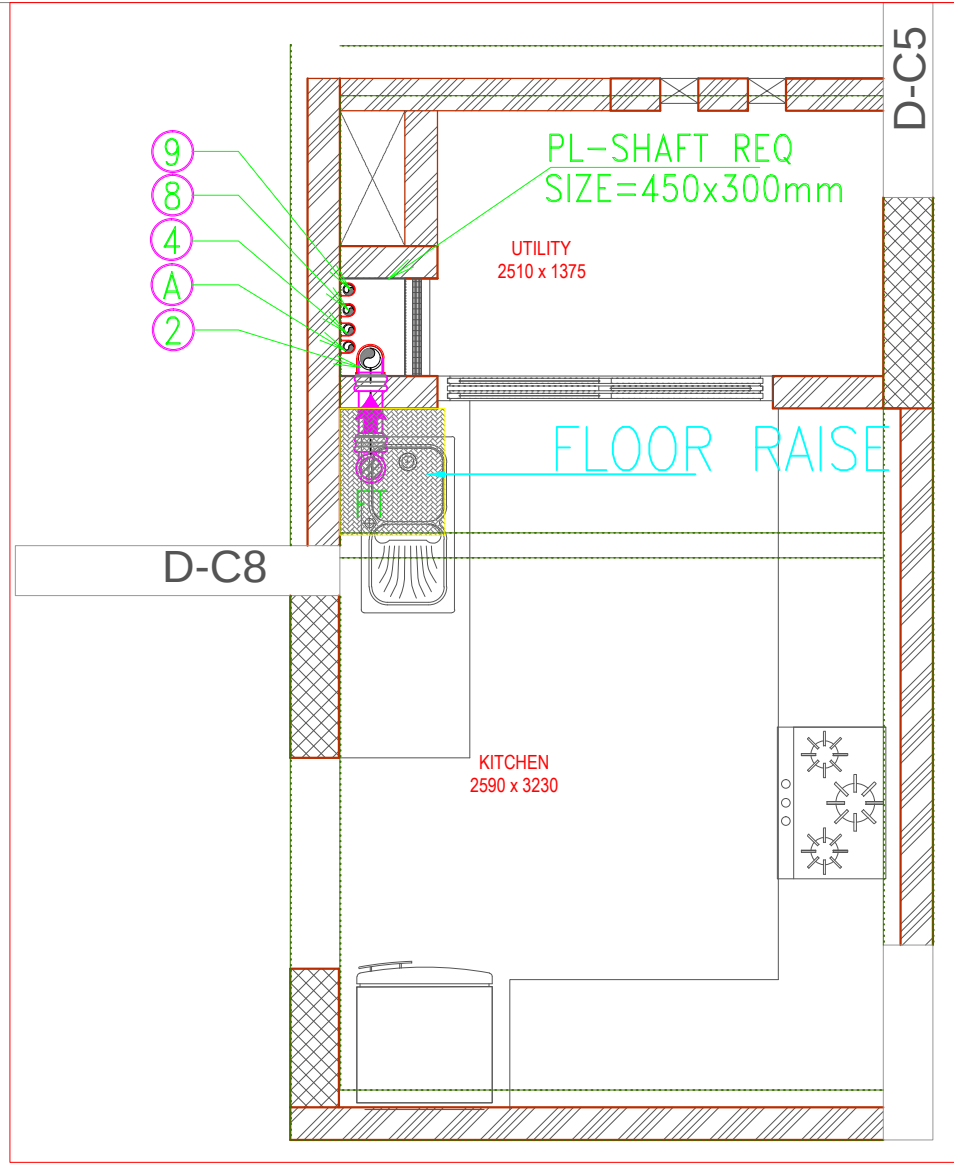


TYP. FLOOR-KITCHEN-02 DETAIL DRAINAGE LAYOUT

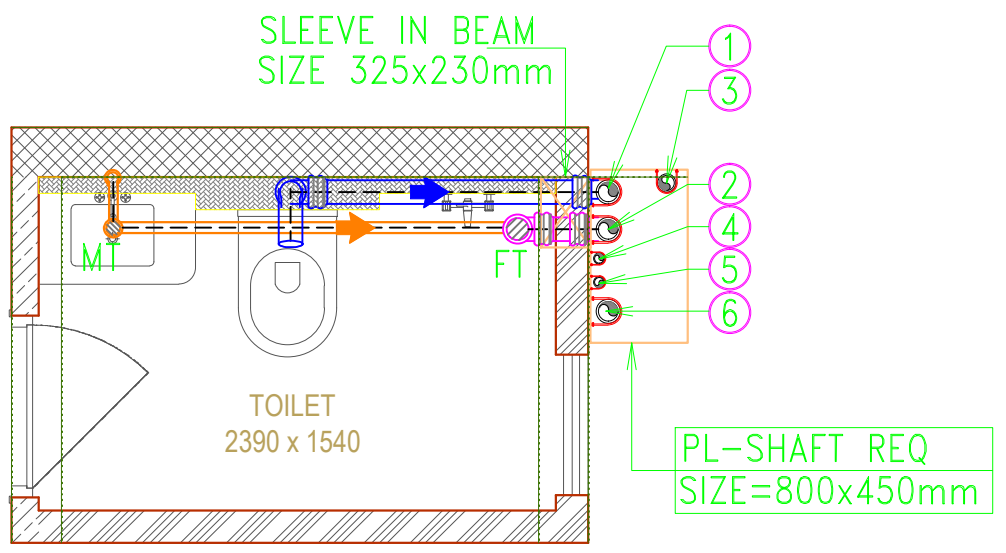


TYP. FLOOR-TOILET-03 DETAIL DRAINAGE LAYOUT

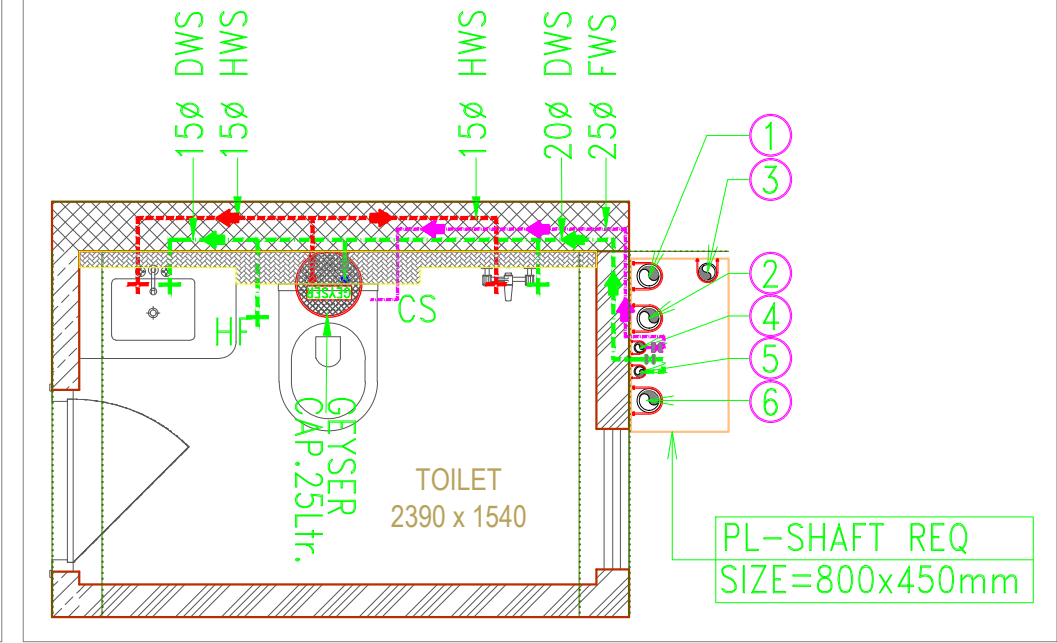


TYP. FLOOR-TOILET-03 DETAIL WATER SUPPLY

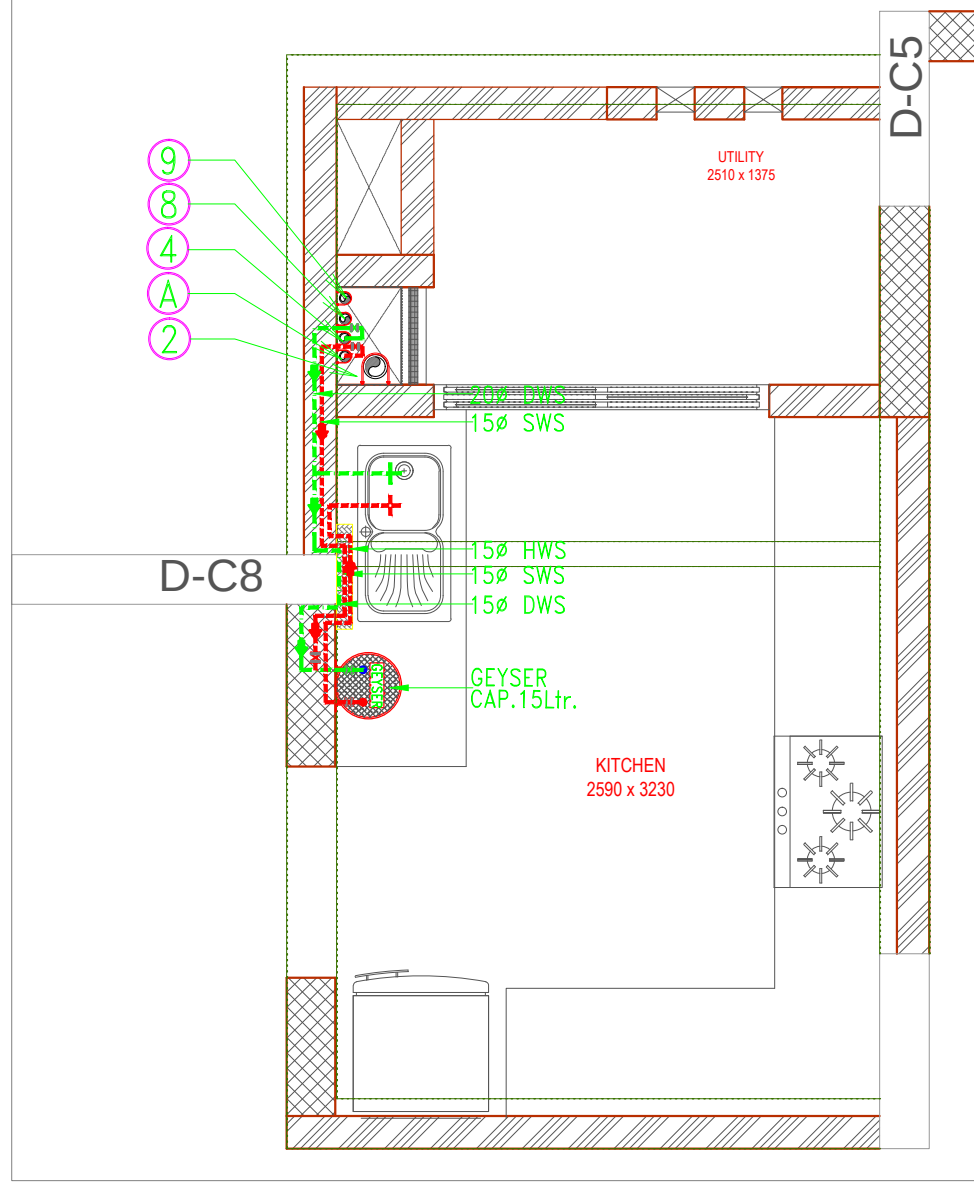


TYP. FLOOR-KITCHEN-02 DETAIL WATER SUPPLY

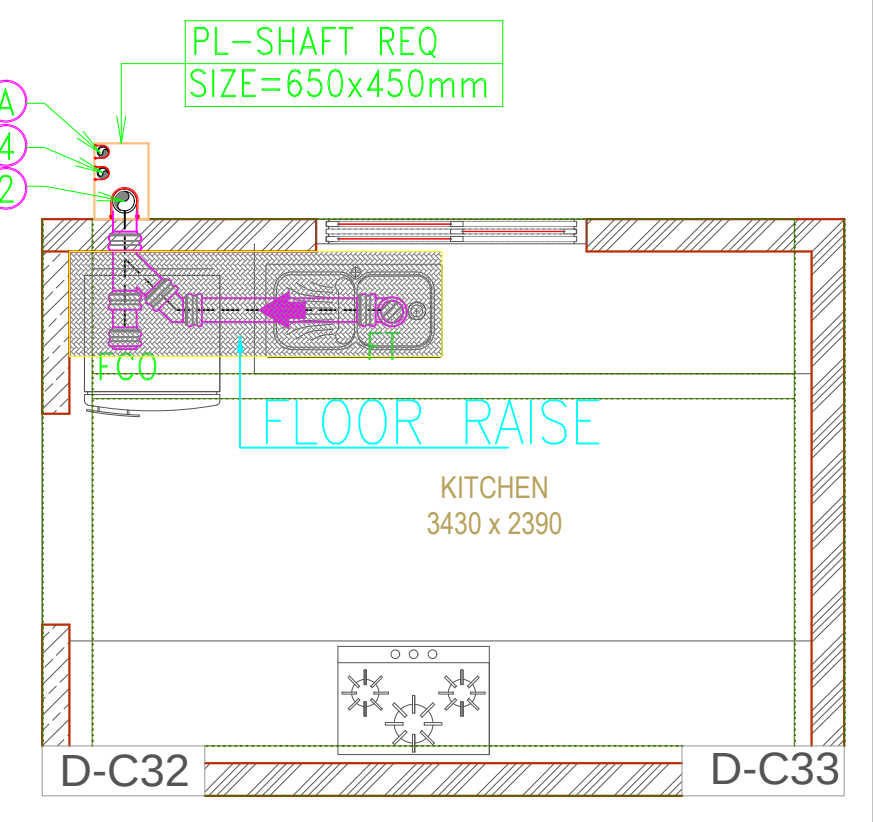


TYP. FLOOR-KITCHEN-01 DETAIL DRAINAGE LAYOUT

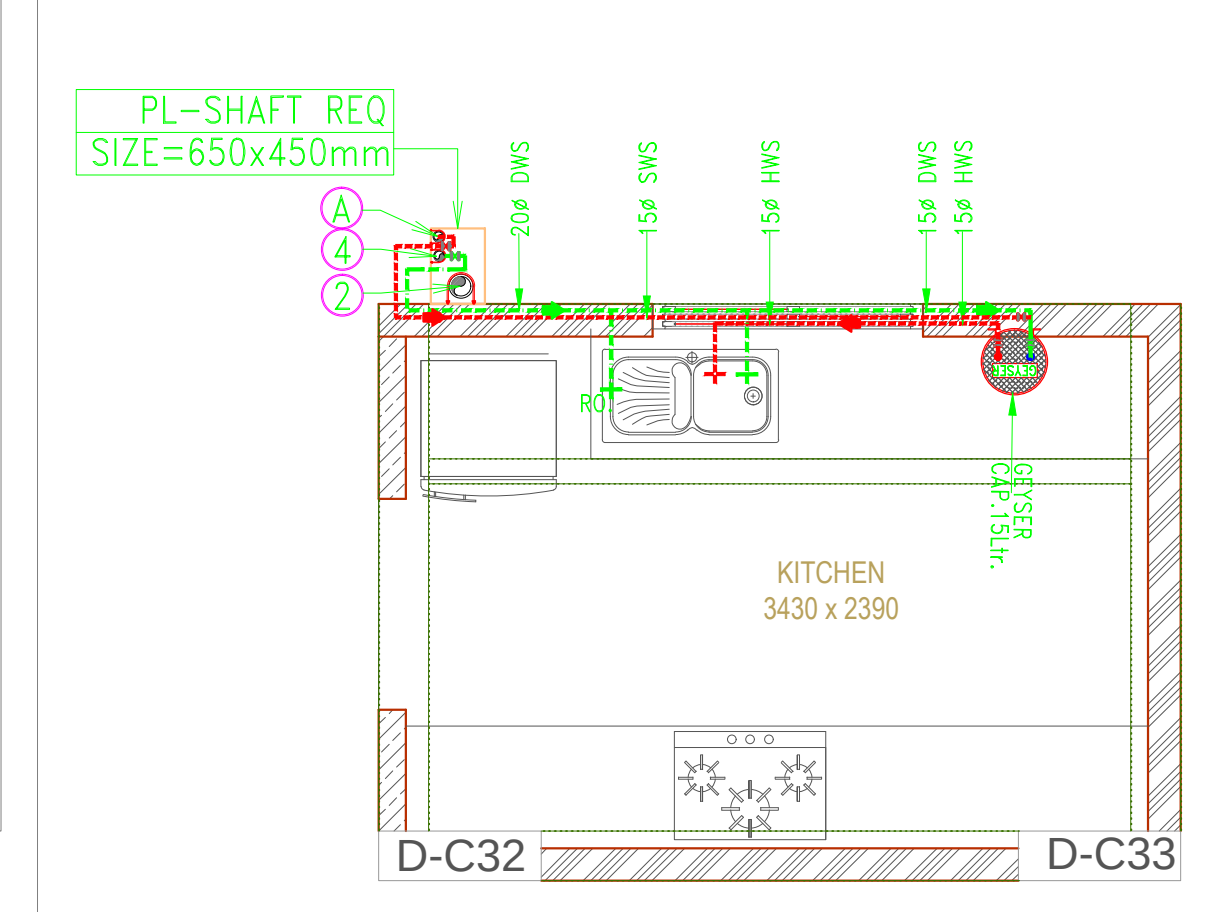


TYP. FLOOR-KITCHEN-01 DETAIL WATER SUPPLY

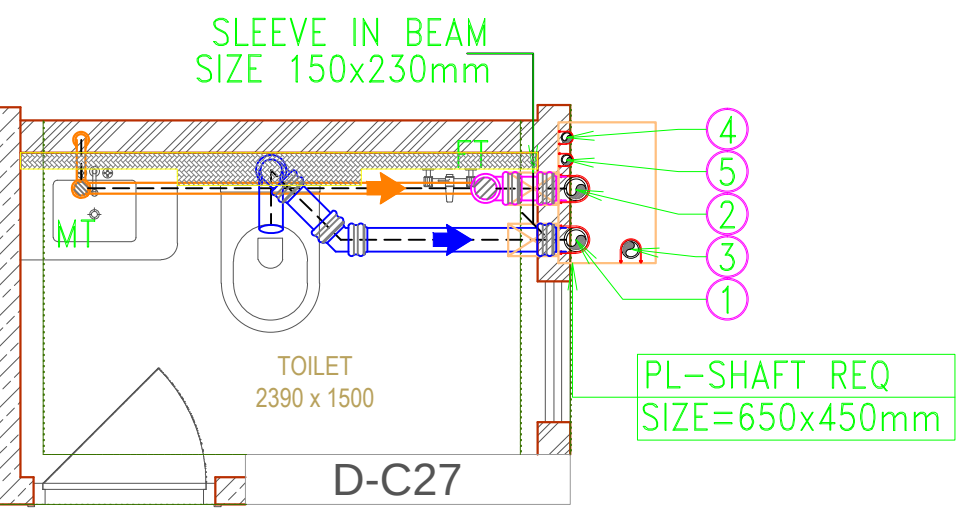

TYP. FLOOR-TOILET-04 DETAIL DRAINAGE LAYOUT

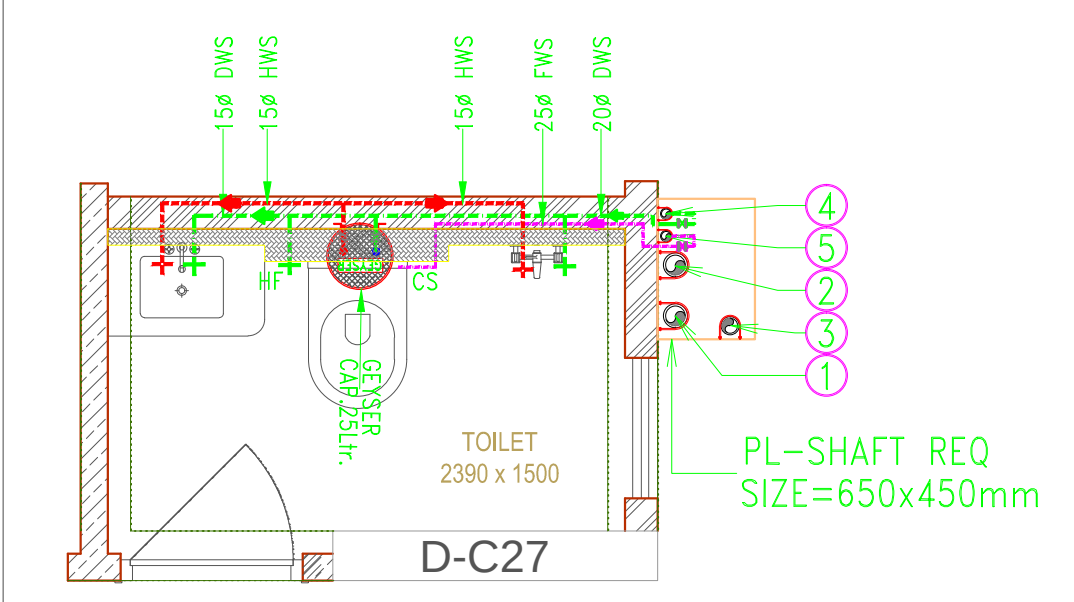

TYP. FLOOR-TOILET-04 DETAIL WATER SUPPLY

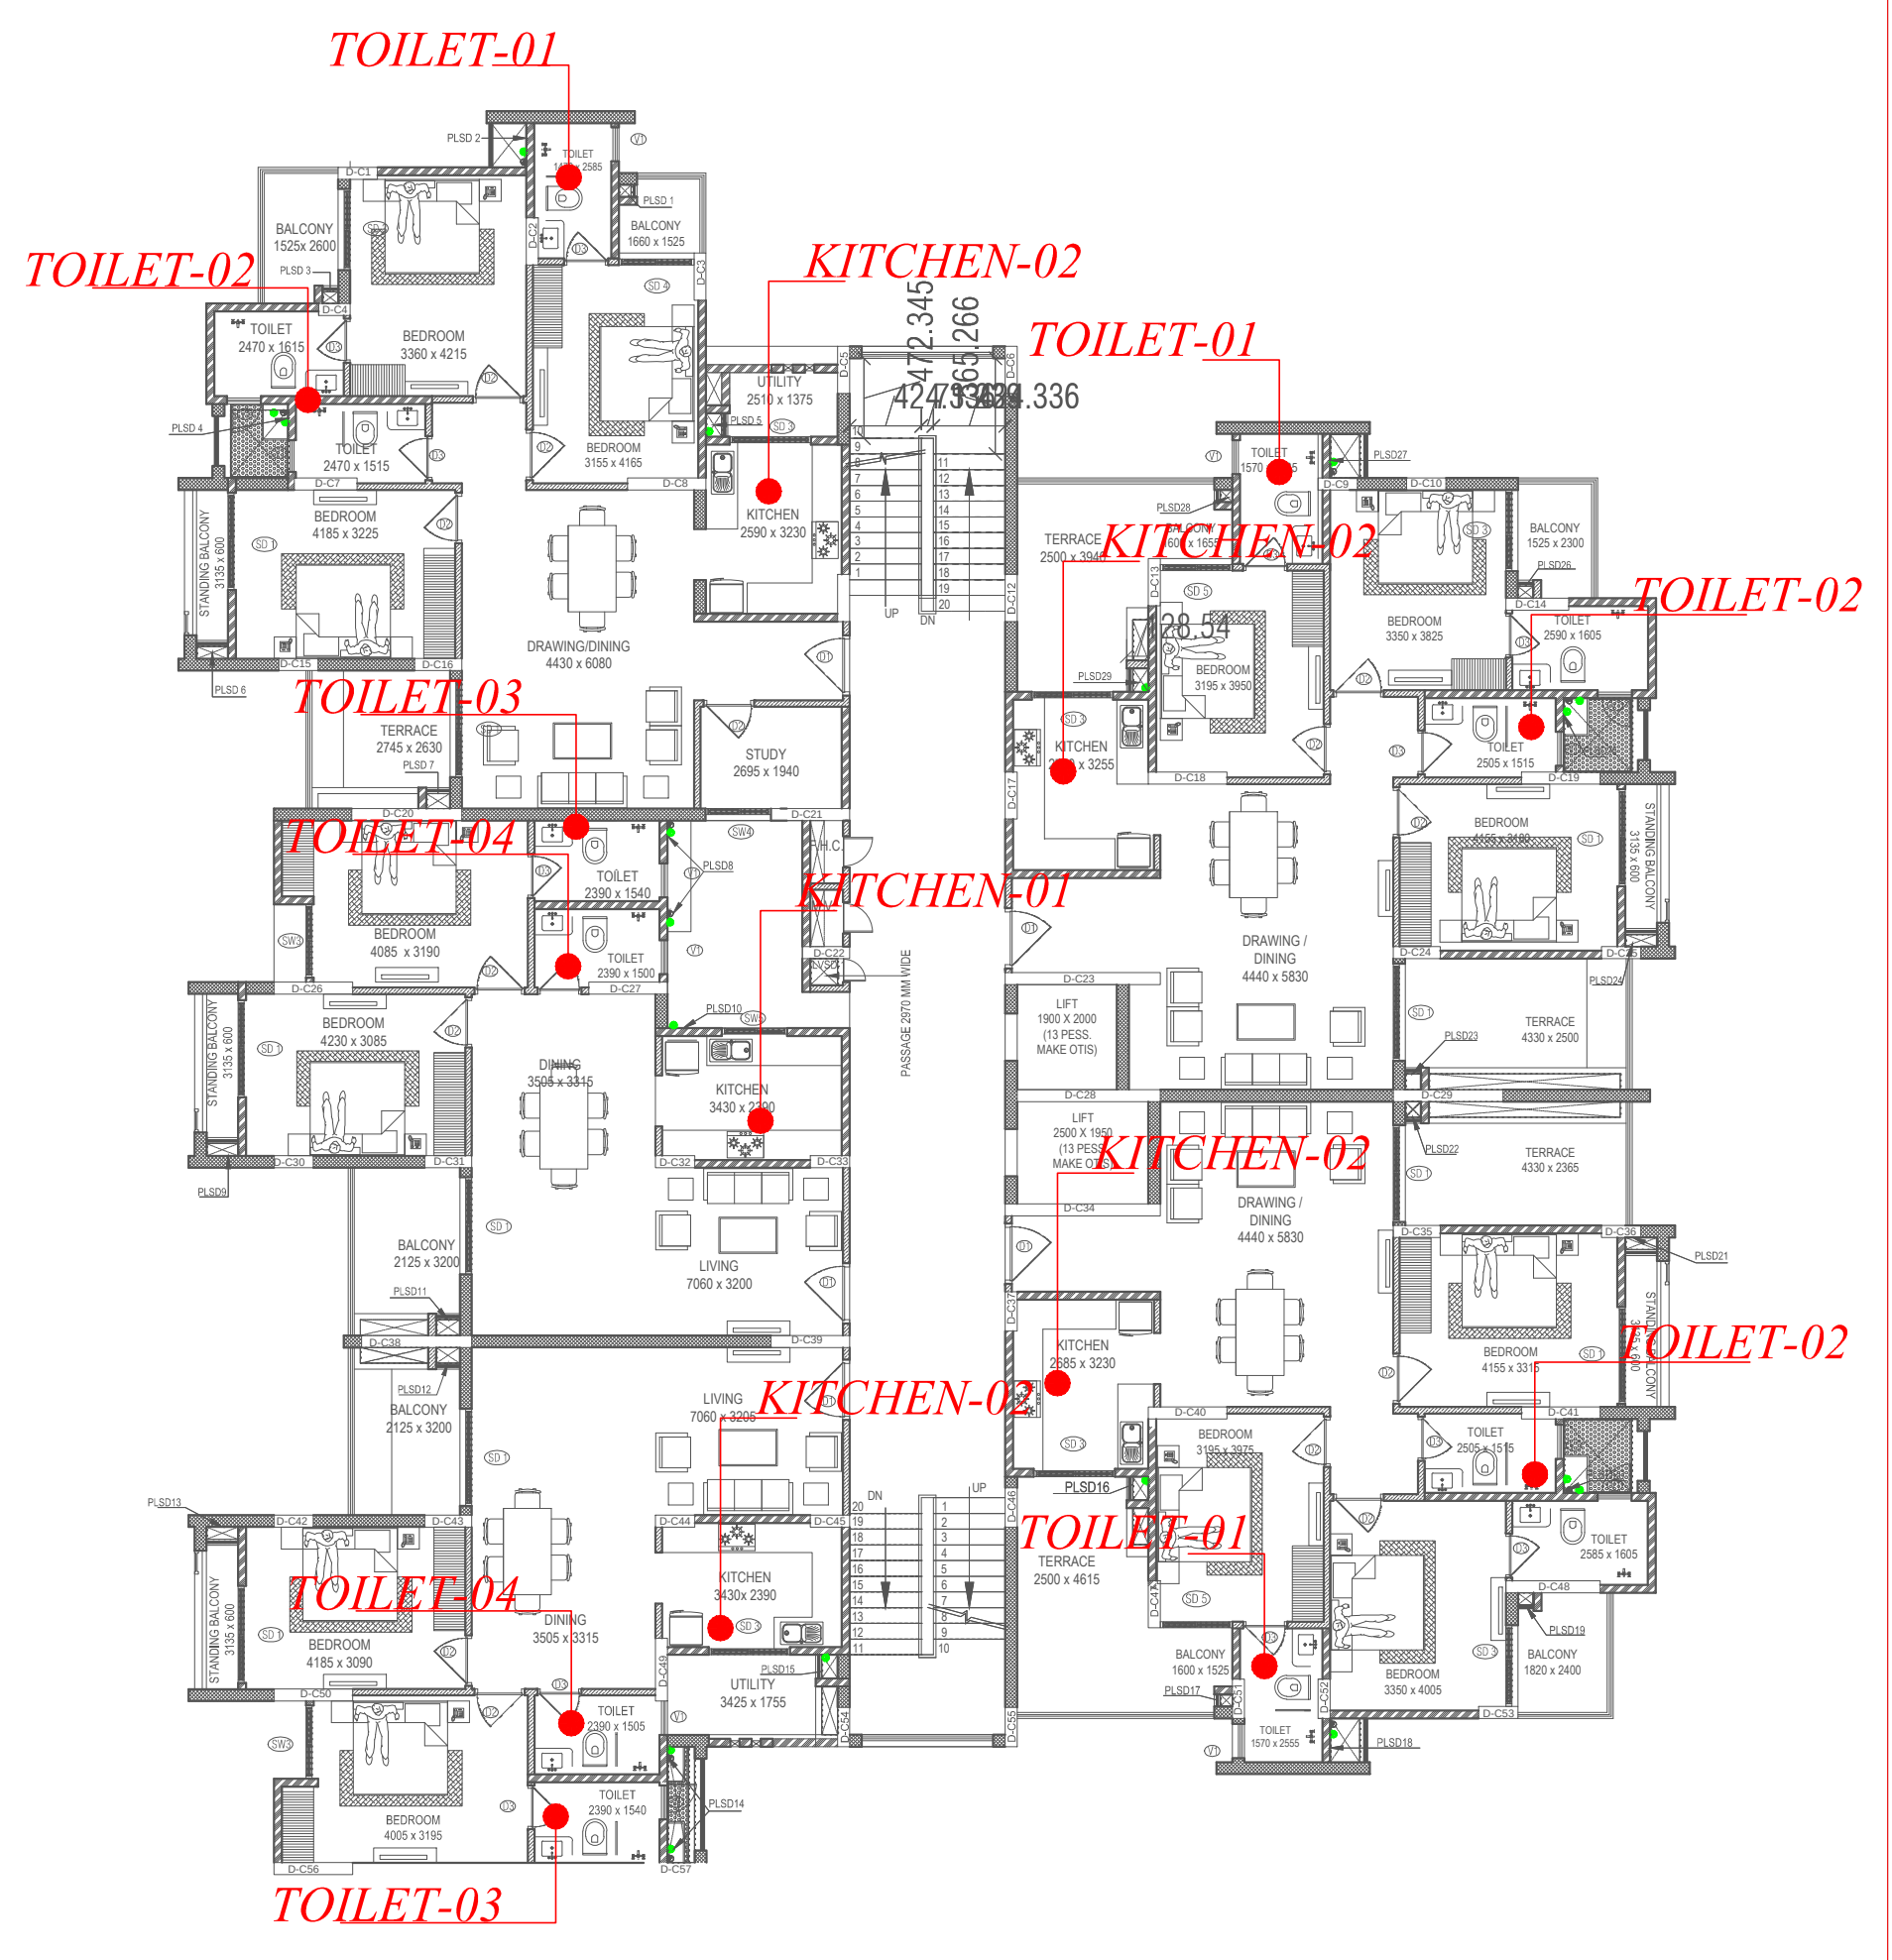

KEY-PLAN

PLUMBING LEGEND:-	
(1)	110 OD Upvc SOIL PIPE
(2)	110 OD Upvc WASTE PIPE
(3)	75Ø A/S PIPE
(4)	C.W.S DOWN TAKE PIPE
(5)	F.W.S DOWN TAKE PIPE
(6)	110 OD RAIN WATER PIPE FOR (TERRACE)
(7)	90 OD RAIN WATER PIPE FOR (BALCONY)
(8)	C.W.S RISER PIPE
(9)	F.W.S RISER PIPE
(A)	SOLAR HOT WATER SUPPLY

PLUMBING NOTES:-	
1.	WASH BASIN TO MULTI TRAP (MT) 40Ø WASTE PIPE
2.	MULTI TRAP TO FLOOR TRAP 50 Ød WASTE PIPE
3.	FLOOR DRAIN TO FLOOR TRAP 63 Ød WASTE PIPE
4.	KITCHEN SINK TO FLOOR TRAP (FT) 40 Ød WASTE PIPE
5.	BALCONY DRAIN TO VERTICAL 63 Ød WASTE PIPE
6.	110 OD Upvc PIPE USED FOR SOIL & WASTE.

FT	FLOOR TRAP 110X110mm
MT	MULTI TRAP 110X50mm
FD	FLOOR DRAIN 110X63mm
BD	BALCONY DRAIN 110X63mm
LEDGEWALL FOR W.C & WB	

PROJECT:

CEDAR LUXURIA
PATRAKAR COLONY, JAIPUR

CLIENT:

CEDAR
JAIPUR


ARCHITECT:

ma|architects
Jaipur - Bangalore - Hyderabad
maithel & associates architects pvt. ltd.
Plot No. -1, Lal Kothi Scheme, Jaipur-302001
Tel : 91 141 4299999
Fax : 91 141 2741664
email - studio@maarchitects.in,
web - www.maarchitects.in

MEP CONSULTANTS

SRAJAN ASSOCIATES
C-35A, NAKSHTRA PRIDE, LAJPAT MARG,
C-SCHEME, JAIPUR
snajaipur@hotmail.com

PLUMBING & FIRE CONSULTANTS:

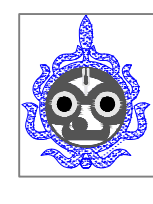 **BEHERA & ASSOCIATES**
F-623A, LADO SARAI, BEHIND CNG STATION
NEW DELHI - 110030
Ph: 011-40583839, 09811911853
Email: behera.associates@gmail.com

No.	ISSUED FOR :	DATE :	CKD:
-----	--------------	--------	------

DRAWING TITLE :
PLUMBING DRAWING
BLOCK - D
TYPICAL TOILET DETAIL

DRAWN BY :	SONU	NORTH:	
CHECKED BY :	SOMNATH		
DATE :	29-12-2014	SCALE :	1 : 125
PROJECT NO. :	GH-2030	DRAWING NO. :	PL - BA - 201

