




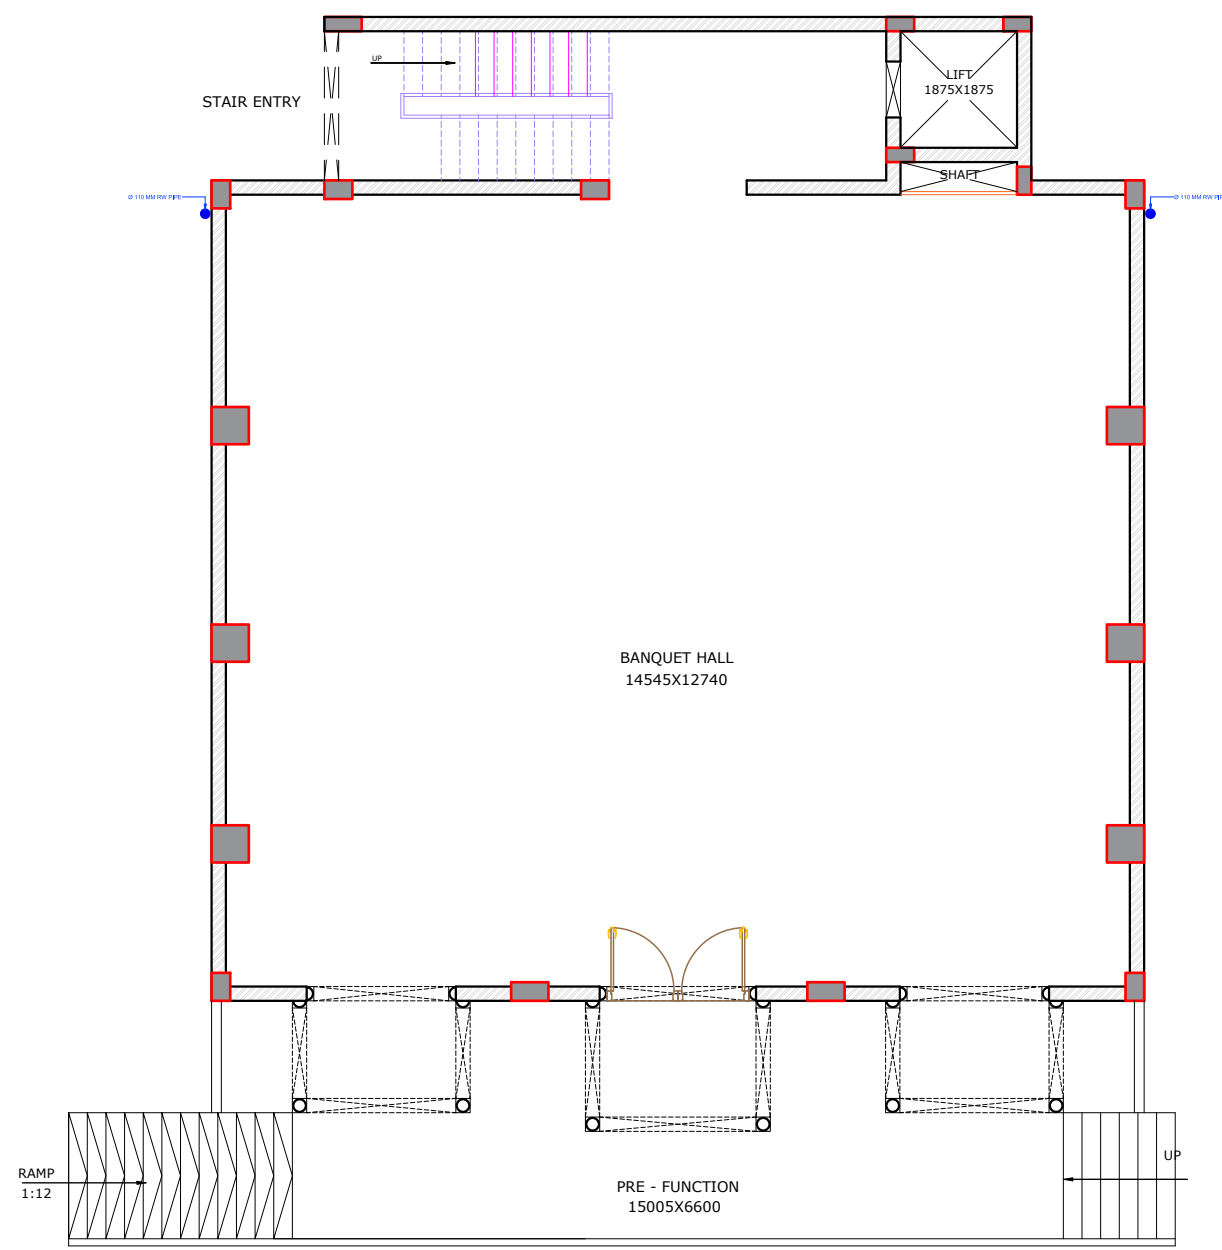


GROUND FLOOR PLAN
PLUMBING LAYOUT

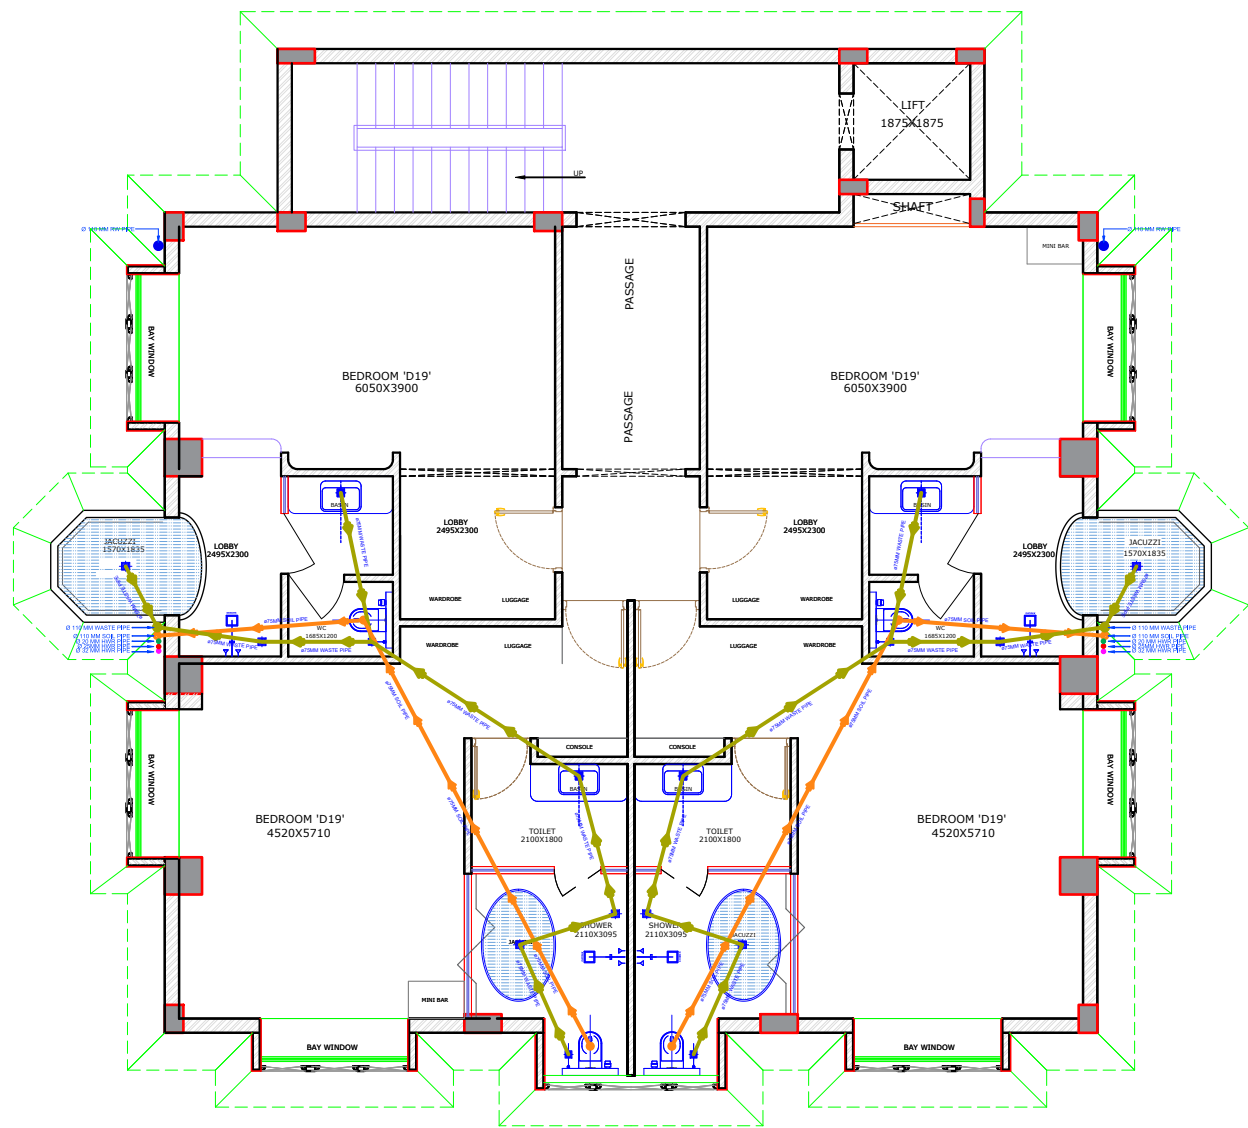


FIRST FLOOR PLAN
PLUMBING LAYOUT

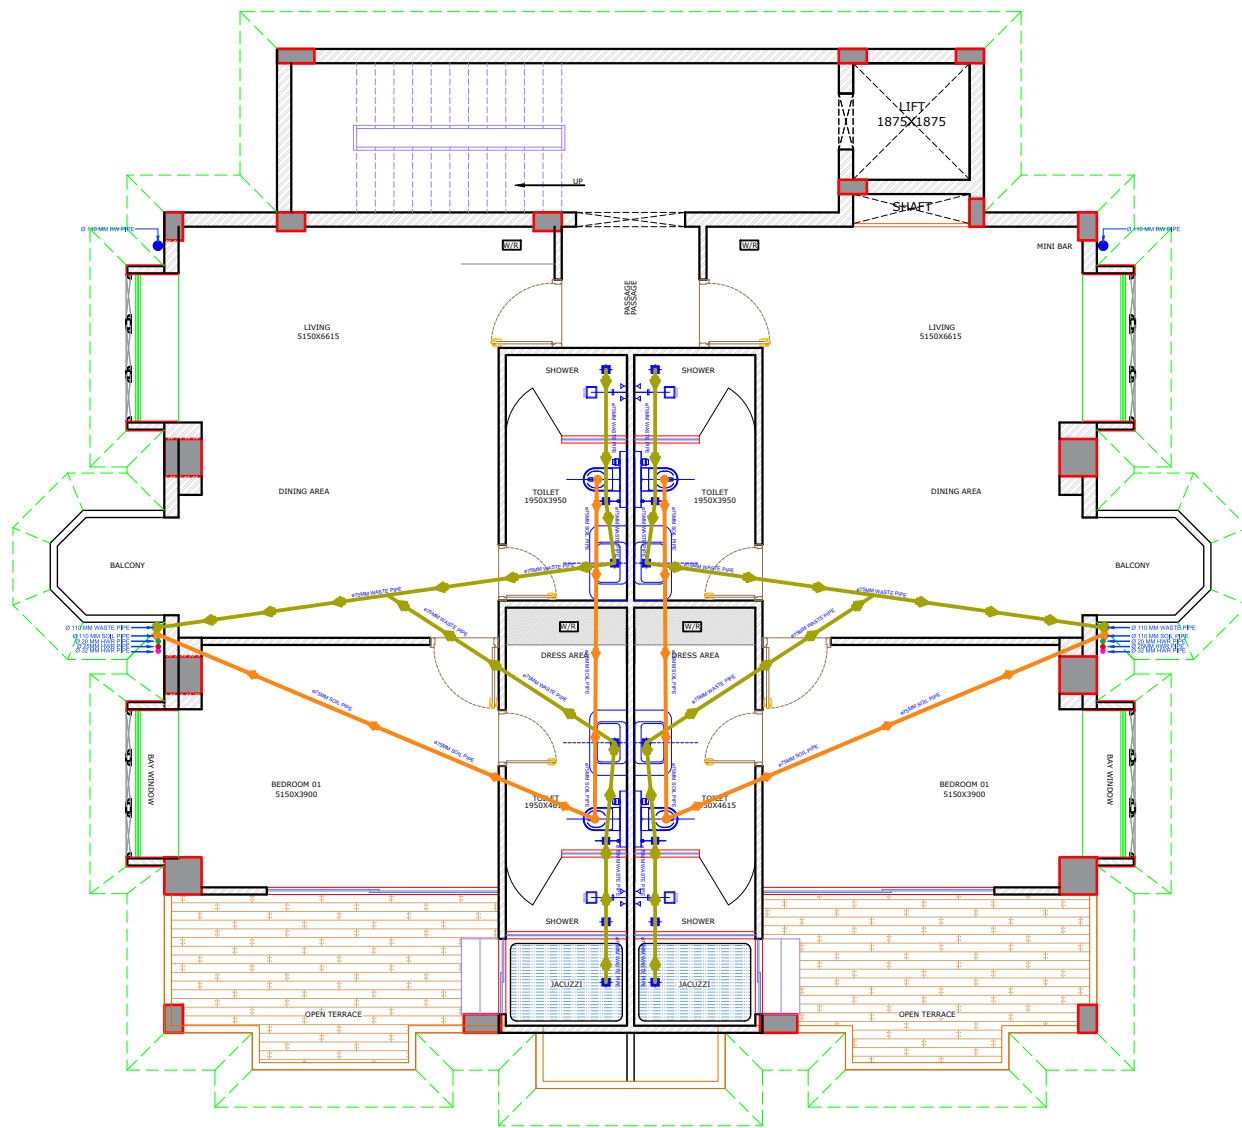


SECOND FLOOR PLAN
PLUMBING LAYOUT

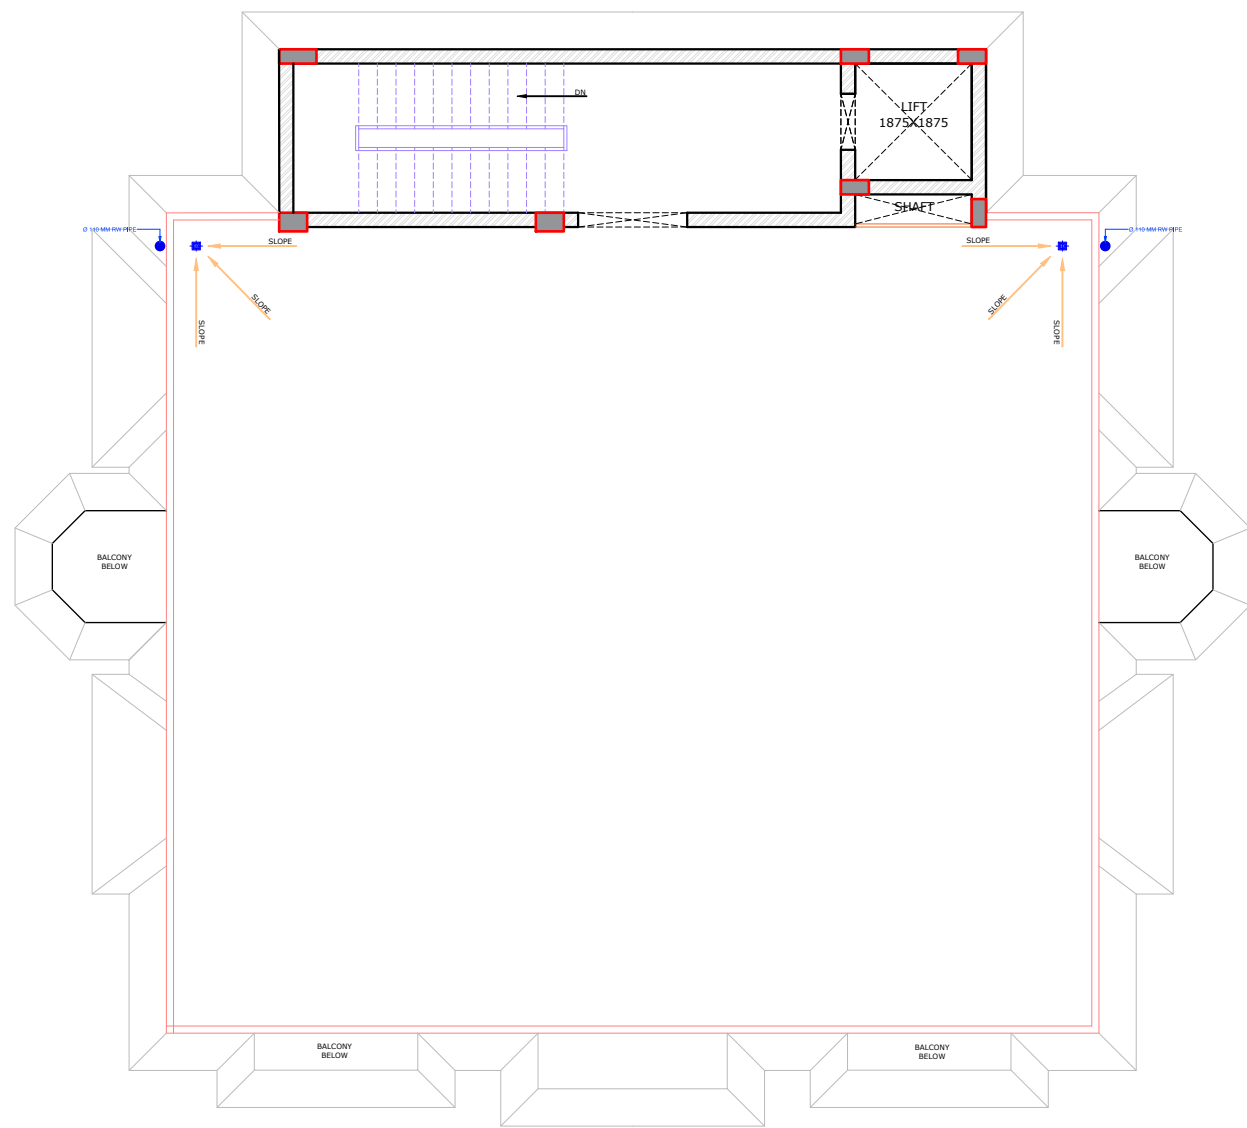


TERRACE FLOOR PLAN
PLUMBING LAYOUT

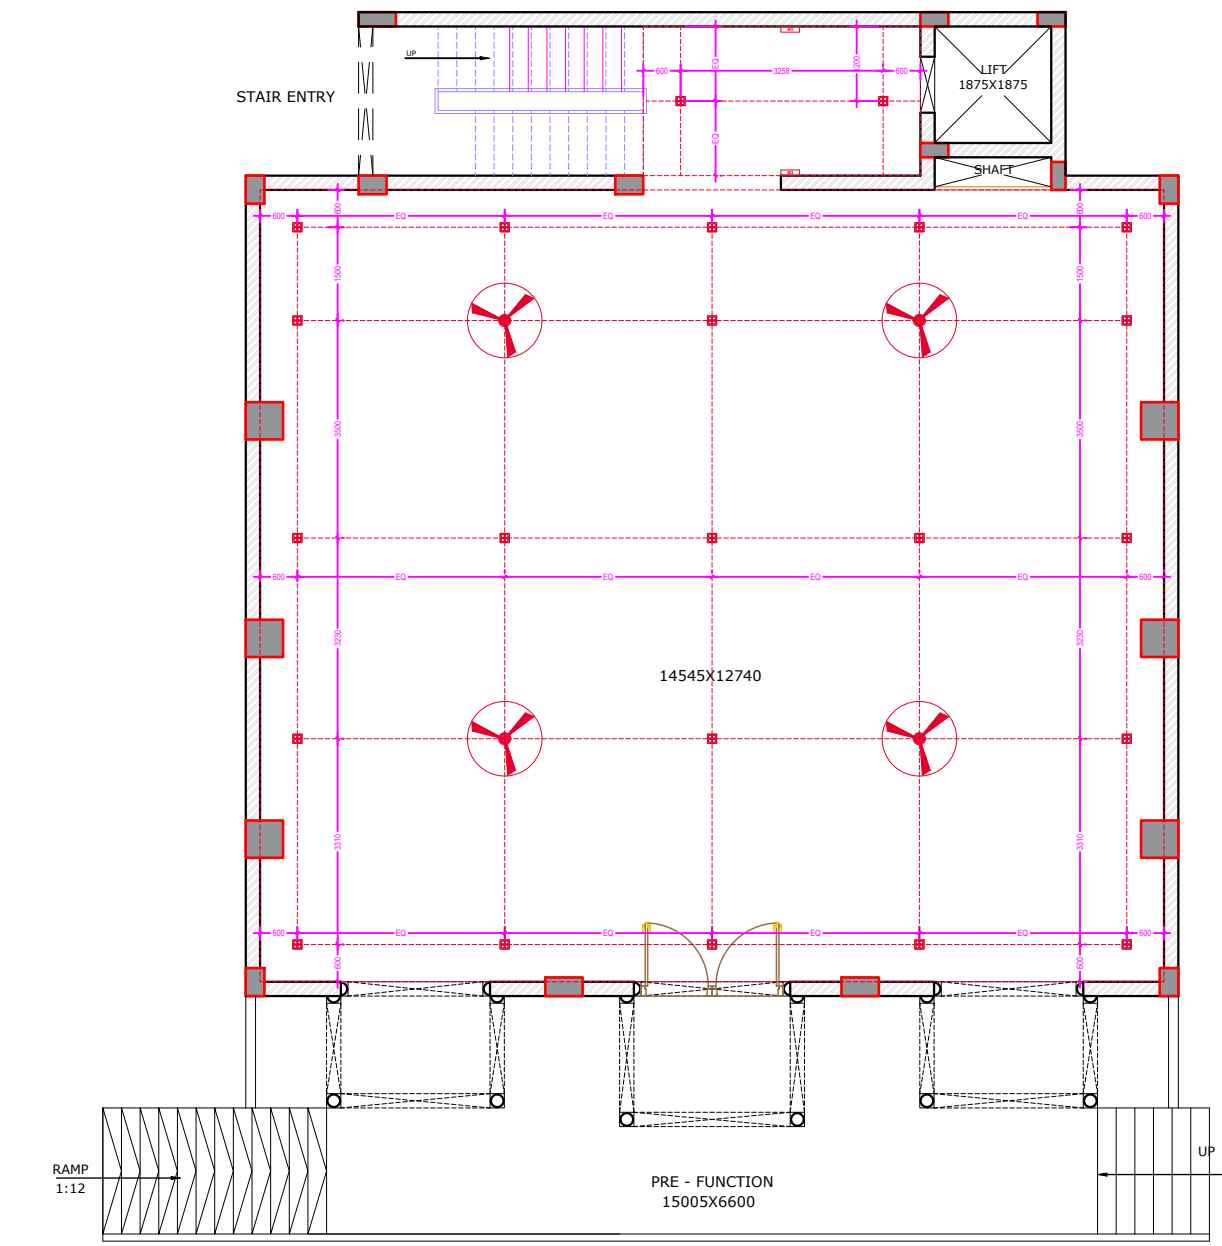

GROUND FLOOR
ELECTRICAL PLAN

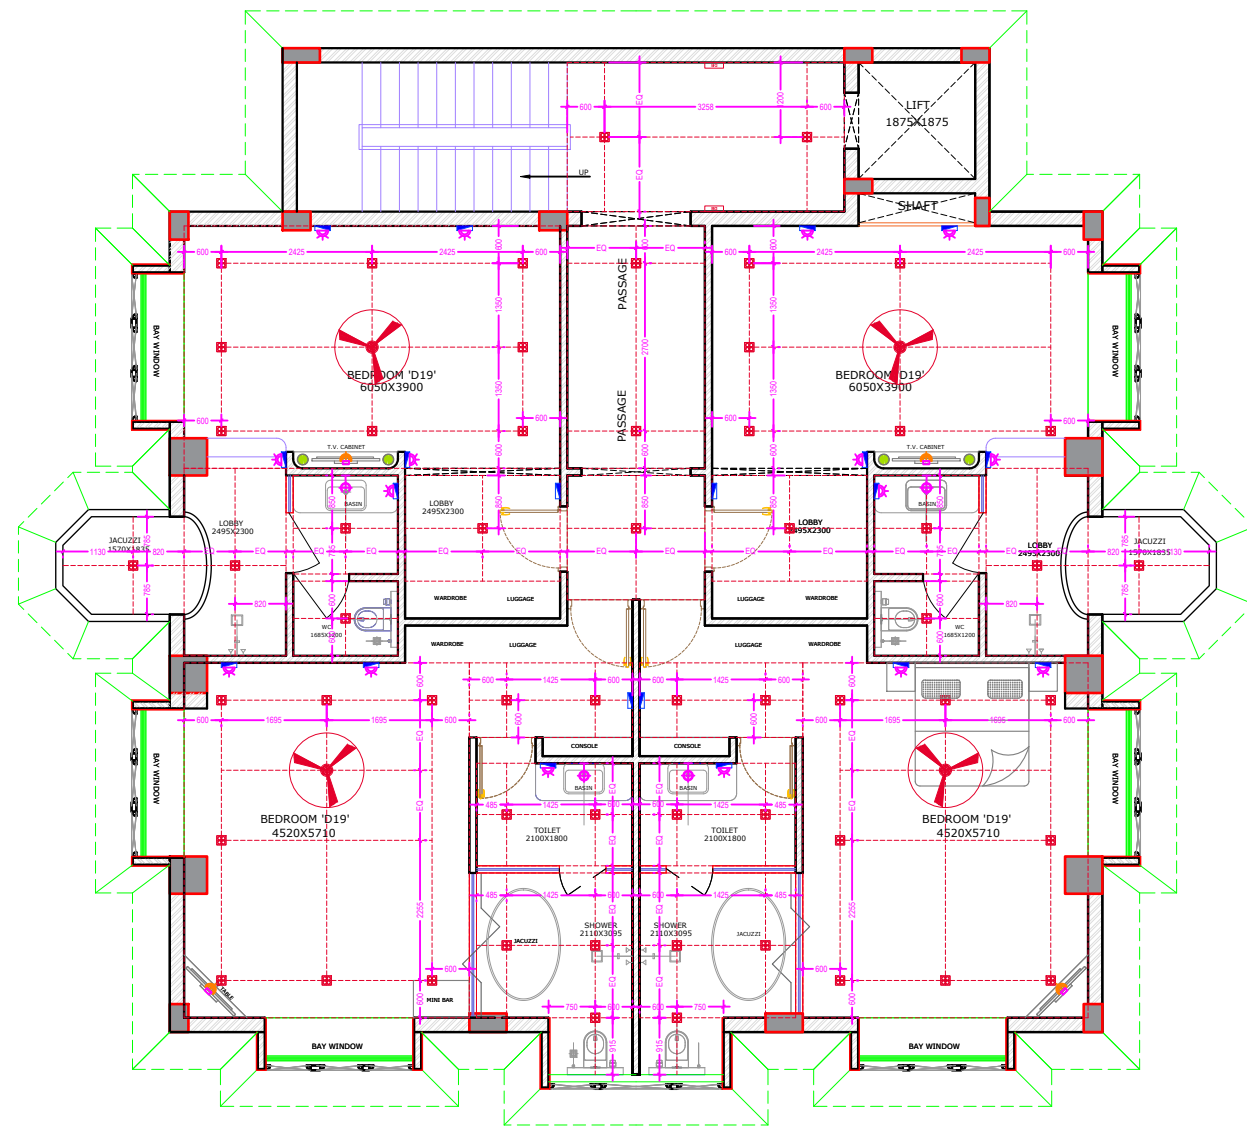

FIRST FLOOR
ELECTRICAL PLAN

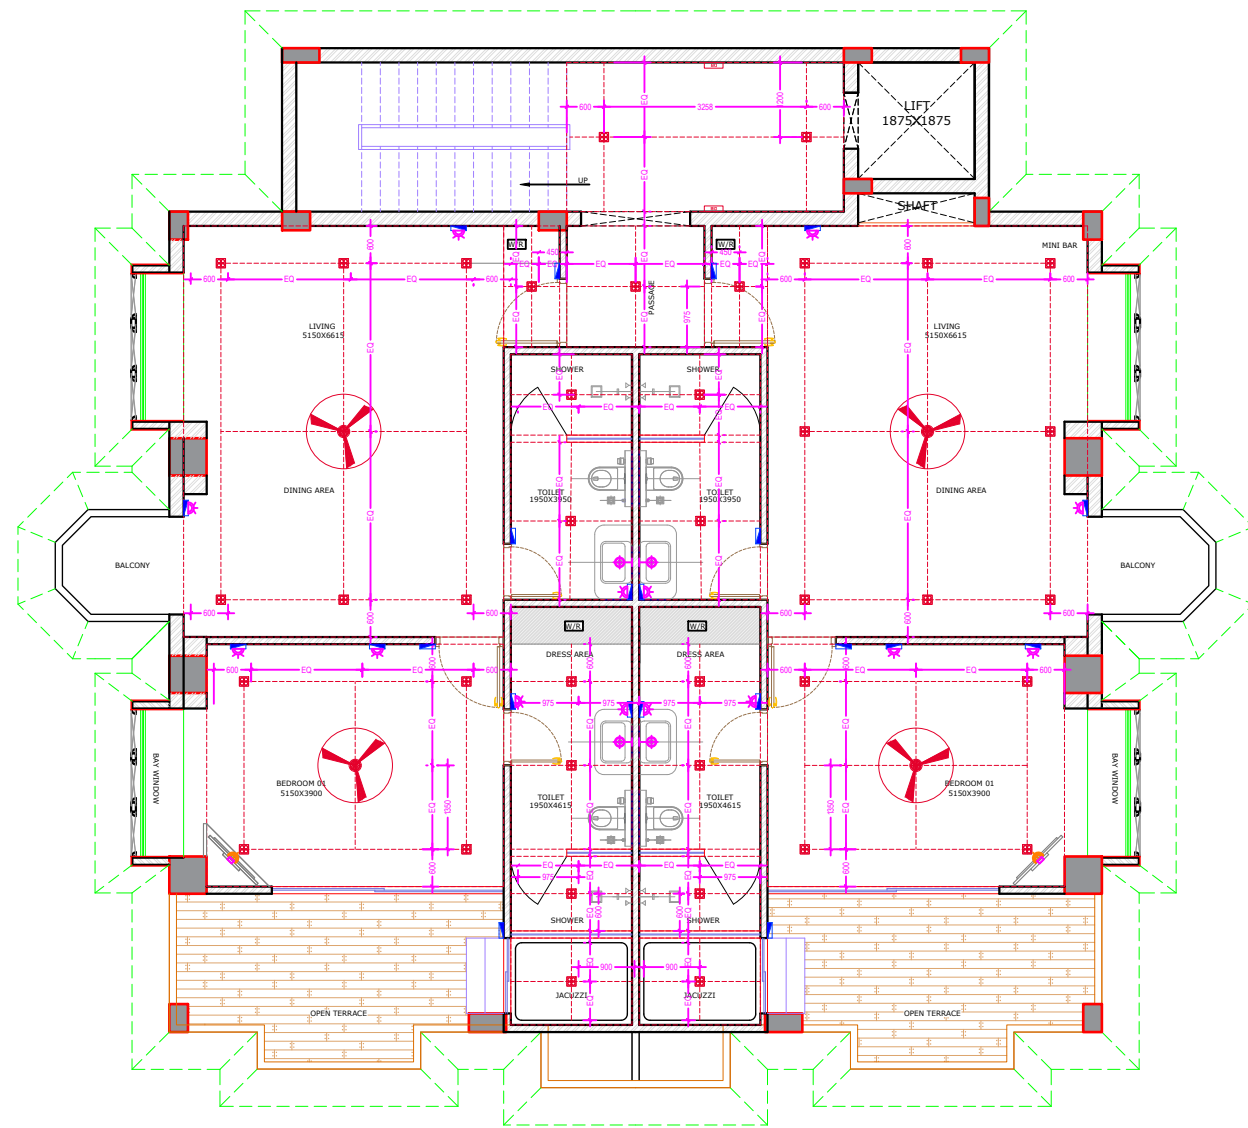

SECOND FLOOR
ELECTRICAL PLAN

PLUMBING LEGEND :-

SYMBOL	DESCRIPTION
	uPVC WASTE PIPE
	uPVC SOIL PIPE
	uPVC RAIN WATER PIPE
	CPVC DOMESTIC WATER SUPPLY PIPE
	CPVC HOT WATER SUPPLY PIPE
	CPVC HOT WATER RETURN PIPE
	FLOOR TRAP
	NAHANI TRAP
	RAIN WATER CHAMBER/MANHOLE

ELECTRICAL LEGEND

1		10 AMP. SOCKET
2		6 AMP. SOCKET
3		T.V. POINT (2-0'')
5		WALL LAMP
6		AC @ 7'4" BOTTOM
7		STAIR LIGHT
8		CEILING LIGHT
9		FAN @ CEILING
10		SWITCH @ 7'4" ABOVE FINISHED FLOOR
11		DISTRIBUTION BOARD @ 6'4" BOTTOM
12		EXHAUST
13		INTERMATE
14		VIDEO DOOR PHONE (VDP)
15		CAMERA
16		BELL BURER
17		VIDEO DOOR PHONE SCREEN (VPS)

Dr. Ravi Kant Pareek
M. Tech (Civil)
Ph.d (Environment)

DRAWING TITLE

SITE 'A'
BLOCK A
**PLUMBING &
ELECTRICAL
LAYOUT**

NAME OF SOCIETY

NIJI KHATEDAR

NAME OF SCHEME

RESORT

MEP SERVICES CONSULTANT
AMP INFRA SERVICES
VILLA NO. 16, SHUBHASIS GEETA
JAISINGHPURA, BHANKROTA &
CHIMANPURA, JAIPUR 302026
EMAIL ID- ampinfrajpr@gmail.com
CONTACT NO. :- 9462866389


STRUCTURE AT WEB CONSULTANTS
LG-21, CROWN PLAZA, NURSERY CIRCLE, VAISHALI NAGAR
JAIPUR, RAJASTHAN
CONTACT NO. :- 9782085656, 7014216243
EMAIL: DUPLV1@gmail.com

SAURABH YADAV

ORIGINATORS
ARCHITECT
F-4, 85 VIVEK VIHAR
NEW SANGANER RD., SODALA
JAIPUR- 320019, RAJASTHAN
9829191691
saurabh.arch@gmail.com

SCALE 1:200

NORTH POINT

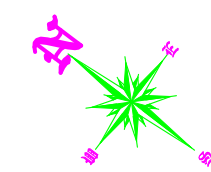

AR. SAURABH YADAV
C.O.A. No. CA/2003/2977

OWNER

ARCHITECT