


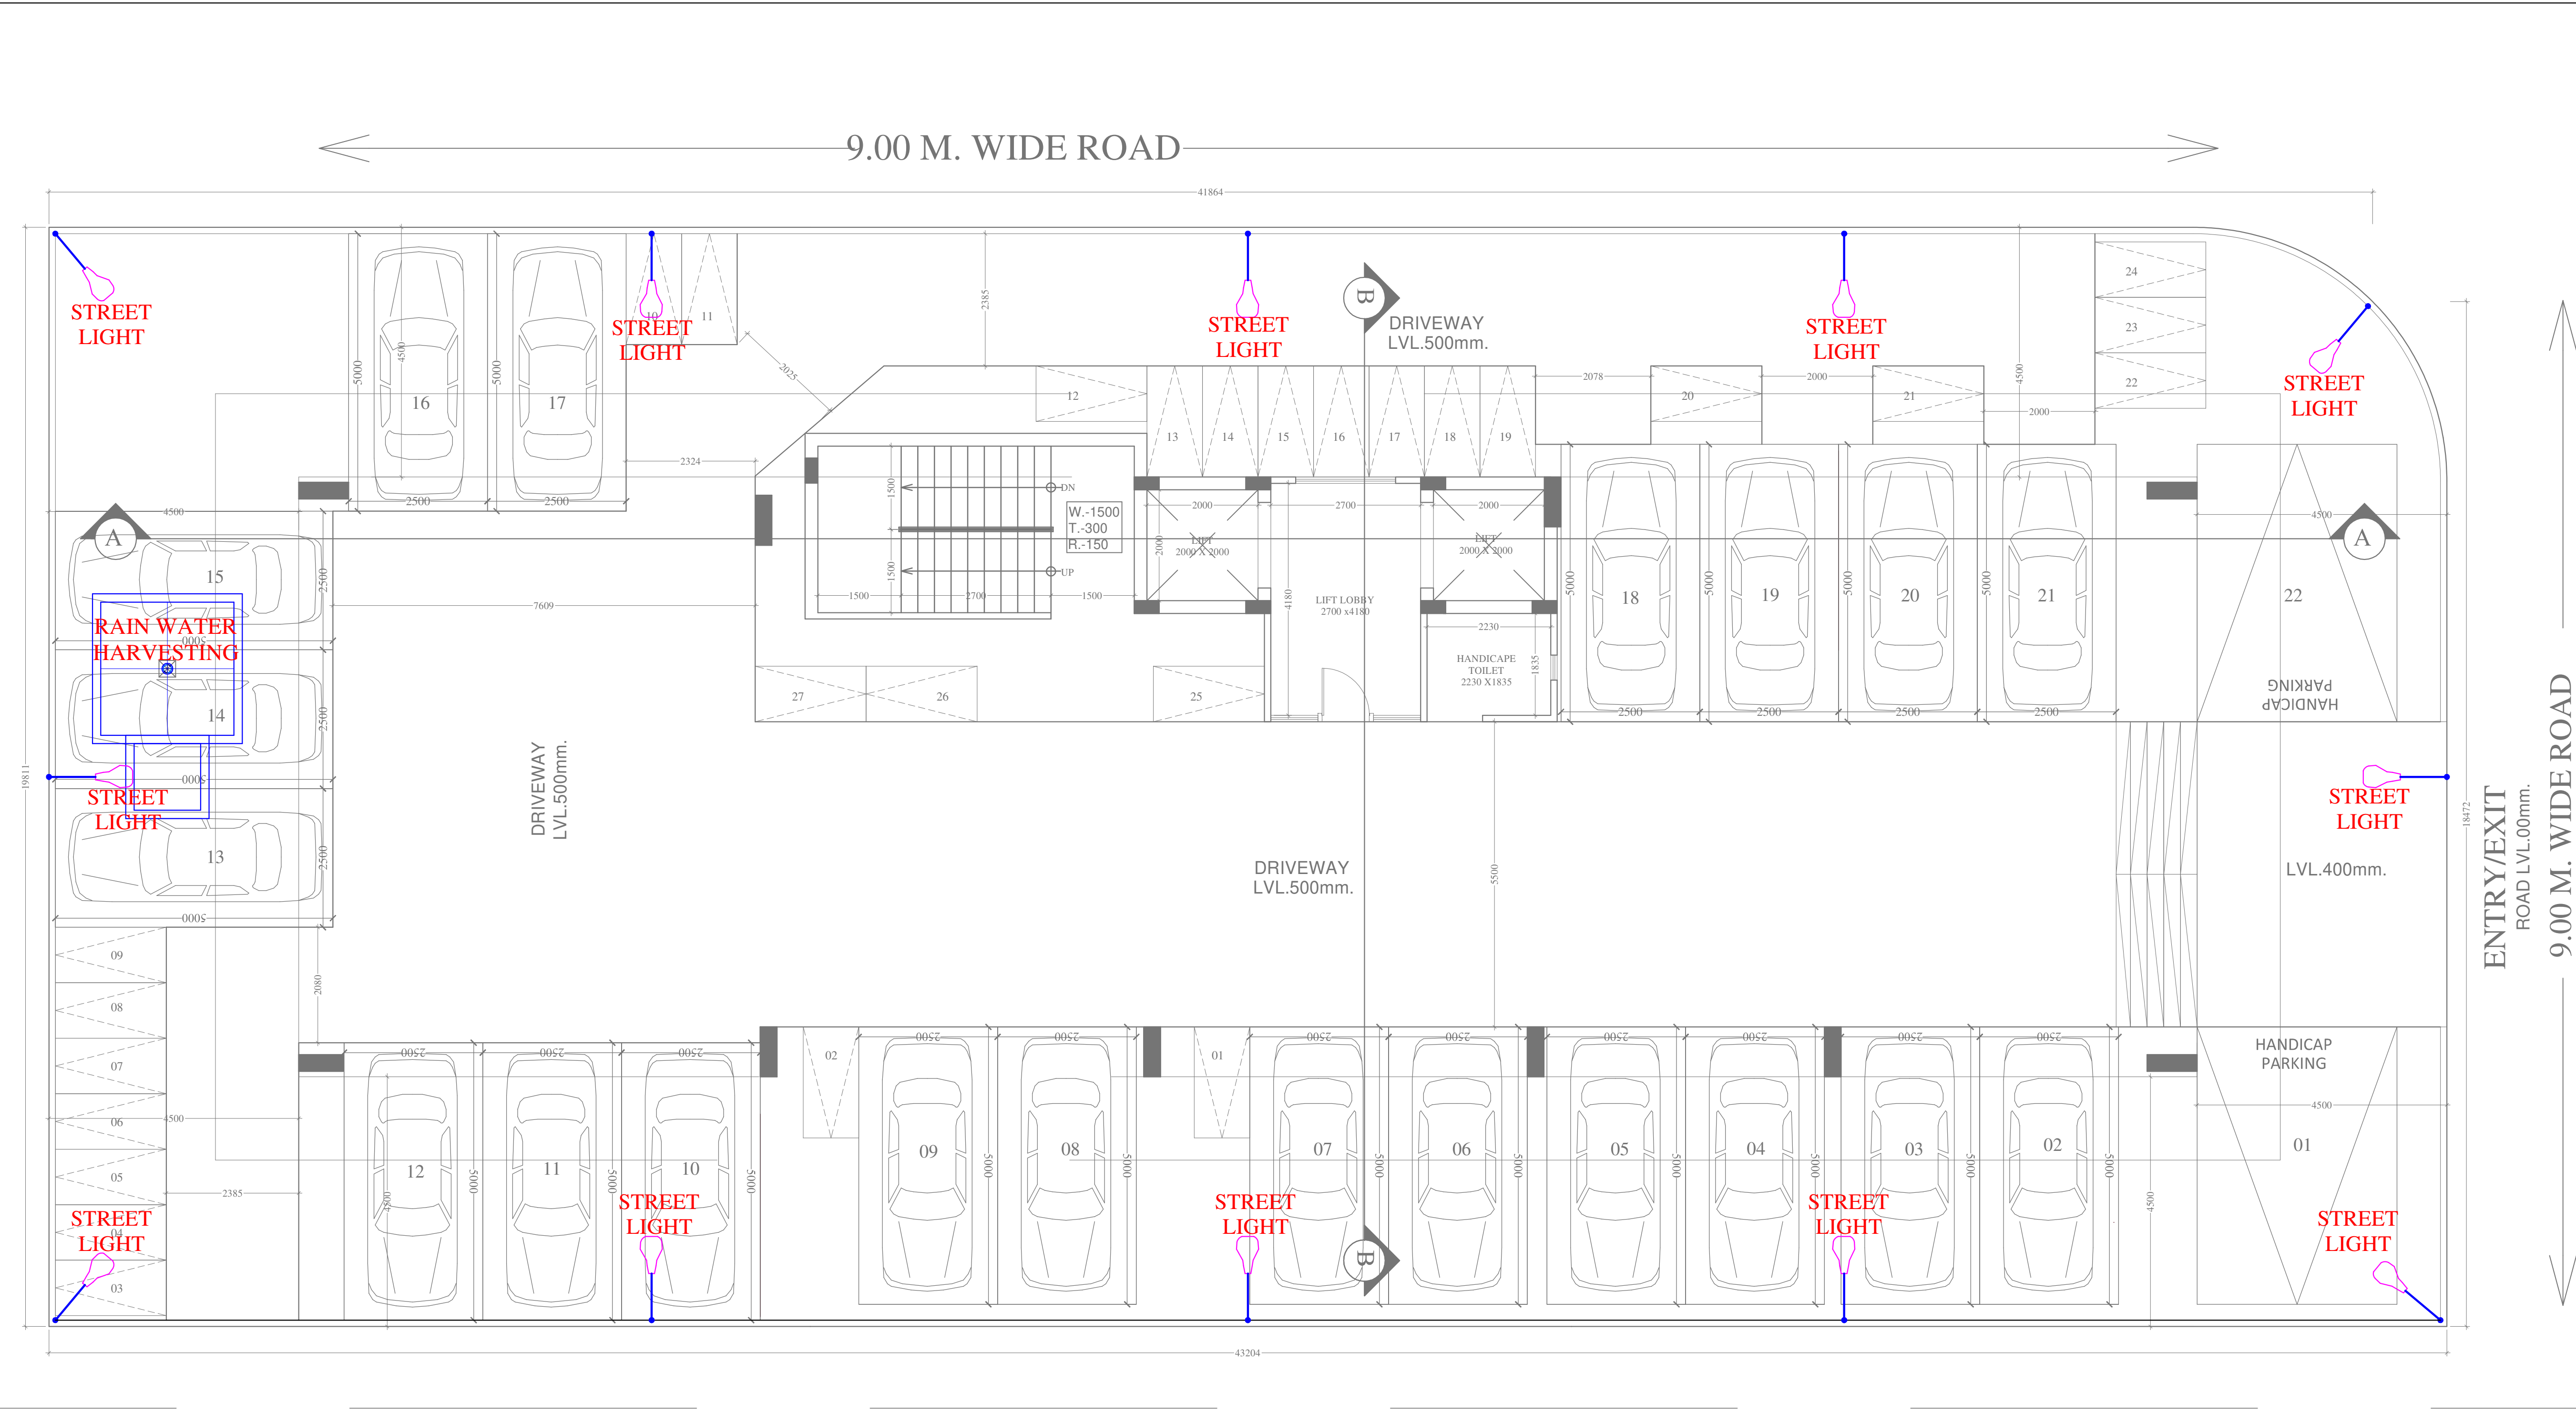


STILT FLOOR PLAN

Vipul
VIPUL AGARWAL
M.E.P. CONSULTANT
B.E. ELECTRICAL

PROJECT NAME :-

CITY HOME TURBAN RESIDENCY PHASE II

 LEGENDS:

Qty.	I D	Symbol	Description
12	PL		STREET LIGHT

SERVICE CONSULTANT


ASHI ASSOCIATES
F 9 / 440 , Keshav Marg Chitrakut Scheme,Jaipur
PH:91-0-93146-10438 ,0141-2440946, Mail:vipul8599@yahoo.com

SUBMISSION DRAWINGS

STILT FLOOR
EXTERNAL STREET LIGHT PLAN

SCALE:- 1= 100

NORTH :

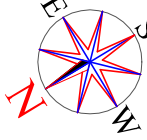

PROJECT:-

RESIDENTIAL RECONSTITUTION
PLOT NO. C17 1st EP, C17 1st WP, C17
MAA KARNI NAGAR SCHEME
(Bhairav G.N.S.S)

ARCHITECTS:-

GRAPHITE DESIGN STUDIO
ARCHITECTS, INTERIOR DESIGNERS, PLANNERS
PLOT NO 68, JANAK PURI-I, IMLIWALA PAHTAK, JAIPUR-302005
CONTACT NO. -+91-9928334414, 0141-2594414
email: akshi@graphitedesignstudio.com


OWNER

ARCHITECTS


Lightning
Arrester

Model: Stormaster –
ESE - 30 (Level
2/Medium Protection)
(Protection radius - 25M,
Mast Height -2 Mtr)

EARTHING DETAILS			
01		50MM PIPE(2METER)	3WAY HT RMU BODY EARTH
01		50MM PIPE(2METER)	CT CHECK METER BOX BODY EARTH
02		50MM PIPE(2METER)	TRANSFORMER BODY EARTH
02		80MM PIPE(3METER)	TRANSFORMER NEUTRAL EARTH
02		50MM PIPE(2METER)	DG SET BODY EARTH
02		80MM PIPE(3METER)	DG SET NEUTRAL EARTH
02		50MM PIPE(2METER)	LIGHTNING ARRESTER BODY EARTH
02		50MM PIPE(2METER)	ELECTRIC PANEL BODY EARTH
01		50MM PIPE(2METER)	TELEPHONE EXCH. BODY EARTH
04		50MM PIPE(2METER)	LIFT PANEL BODY EARTH
NOTES: 1. ALL NEUTRAL EARTHS TO BE CONNECTED 50 X 3 GI EARTH STRIP FROM EARTH PIT TO EQUIPMENT. 2. ALL BODY EARTHS TO BE CONNECTED 25 X 3 GI EARTH STRIP FROM EARTH PIT TO EQUIPMENT.			

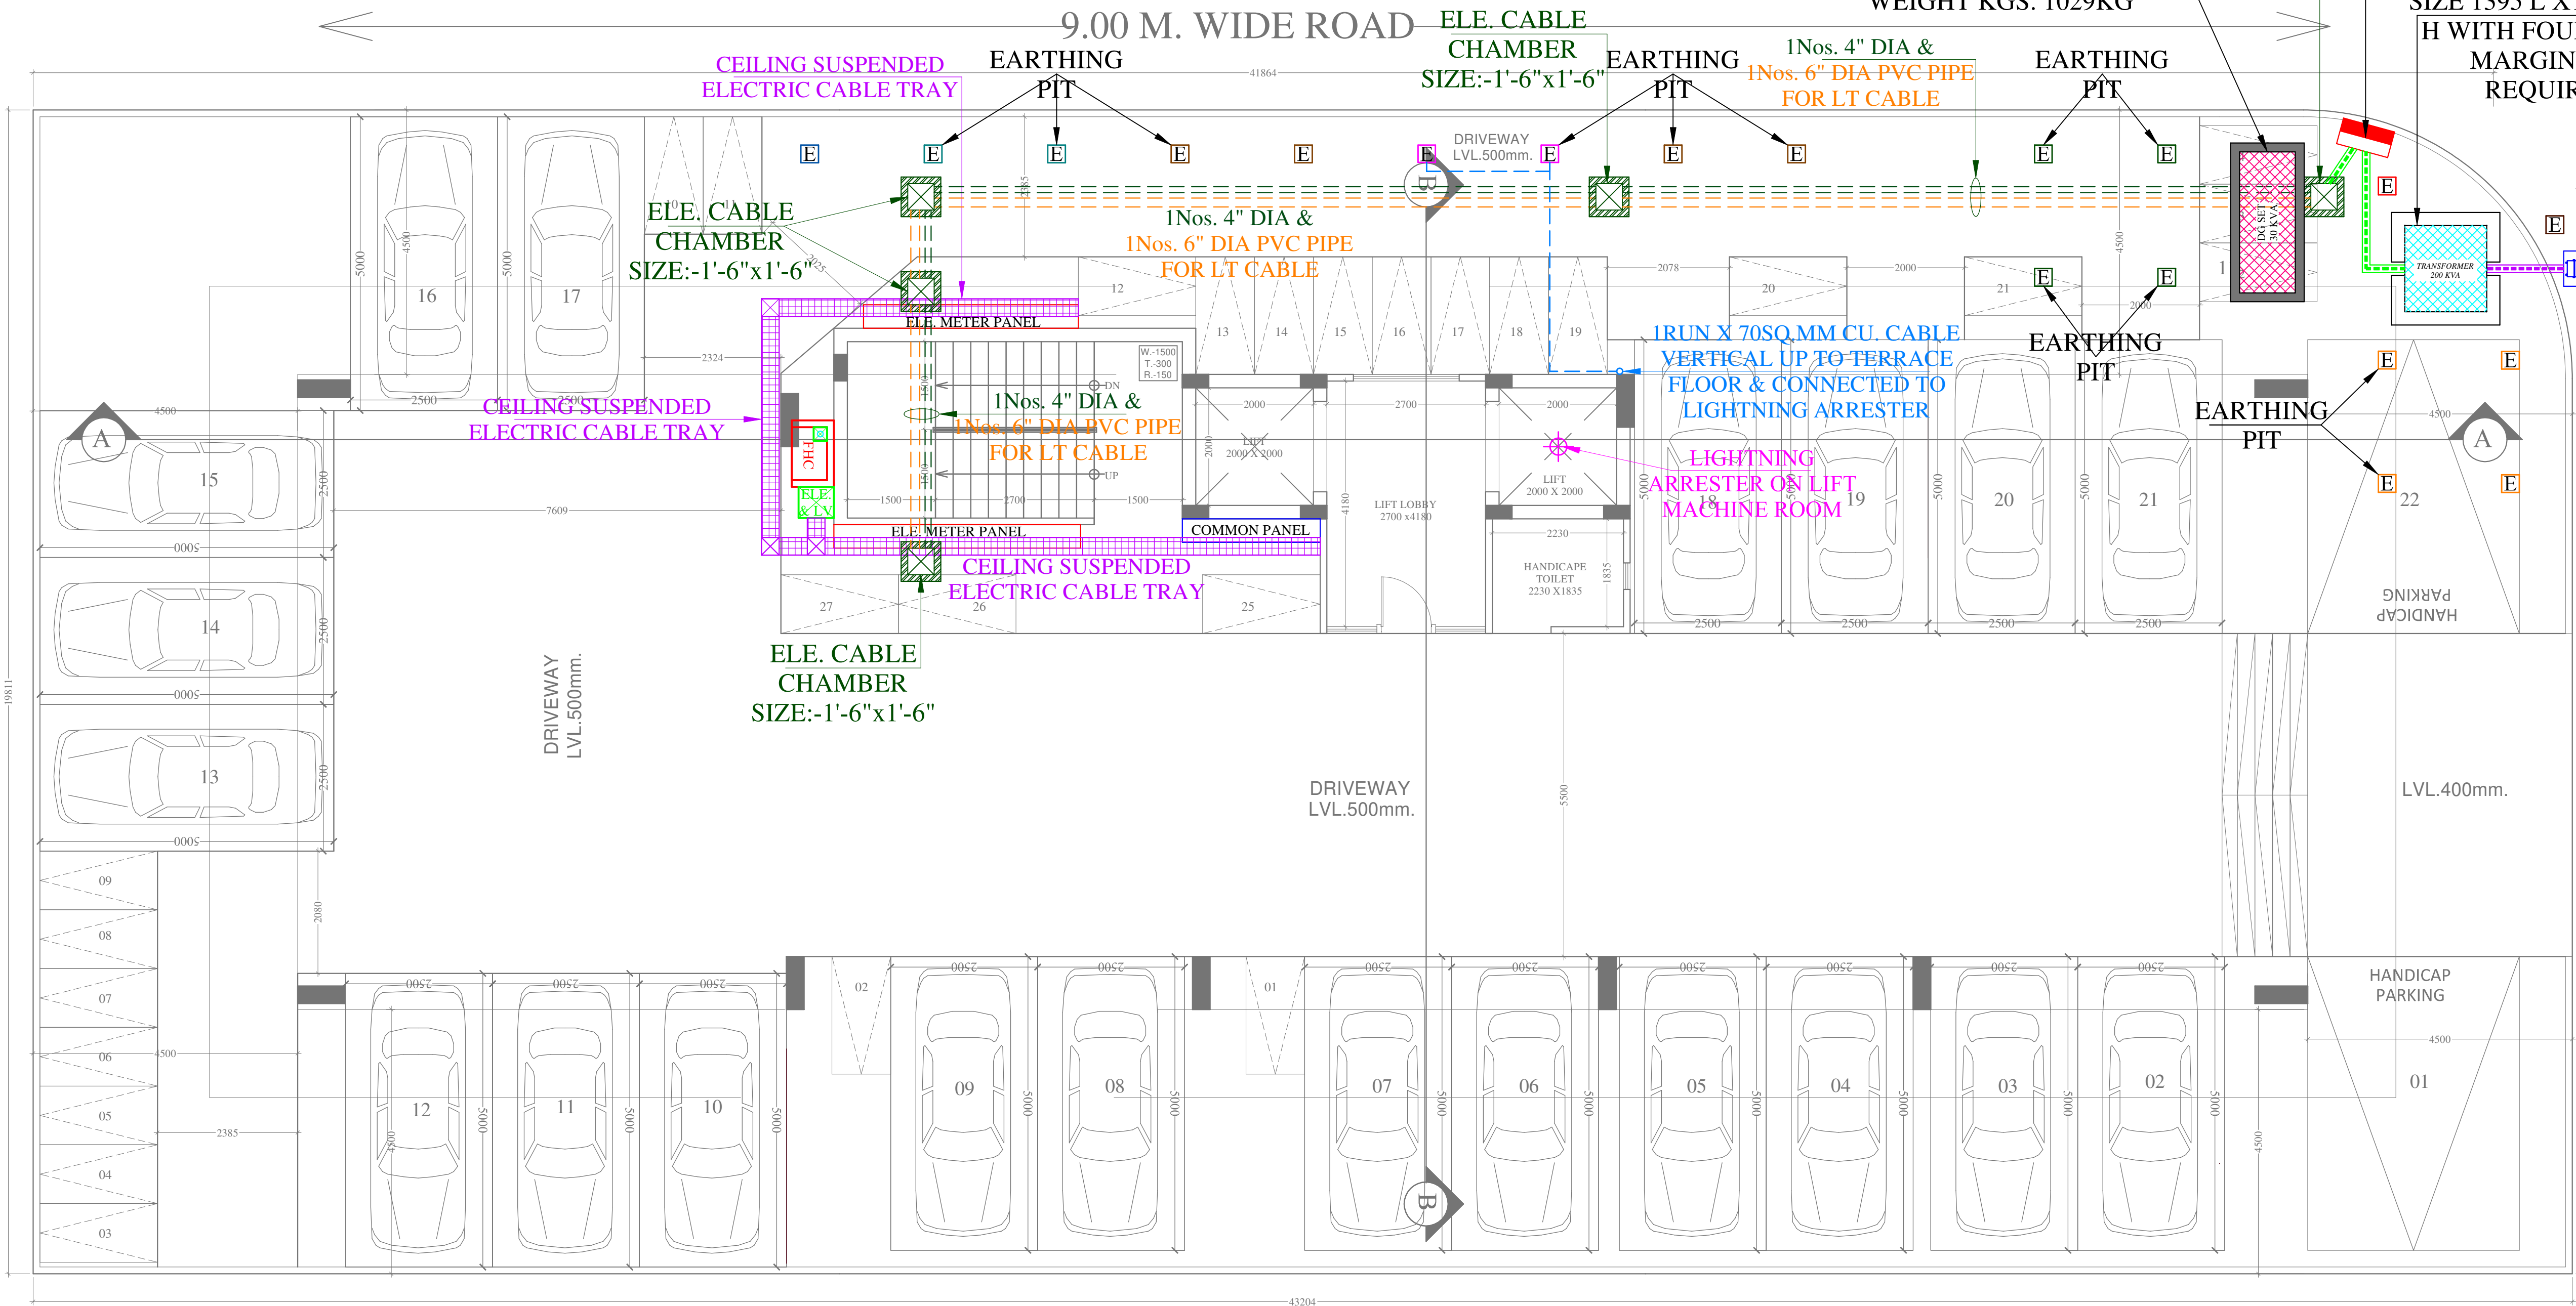

STILT FLOOR PLAN

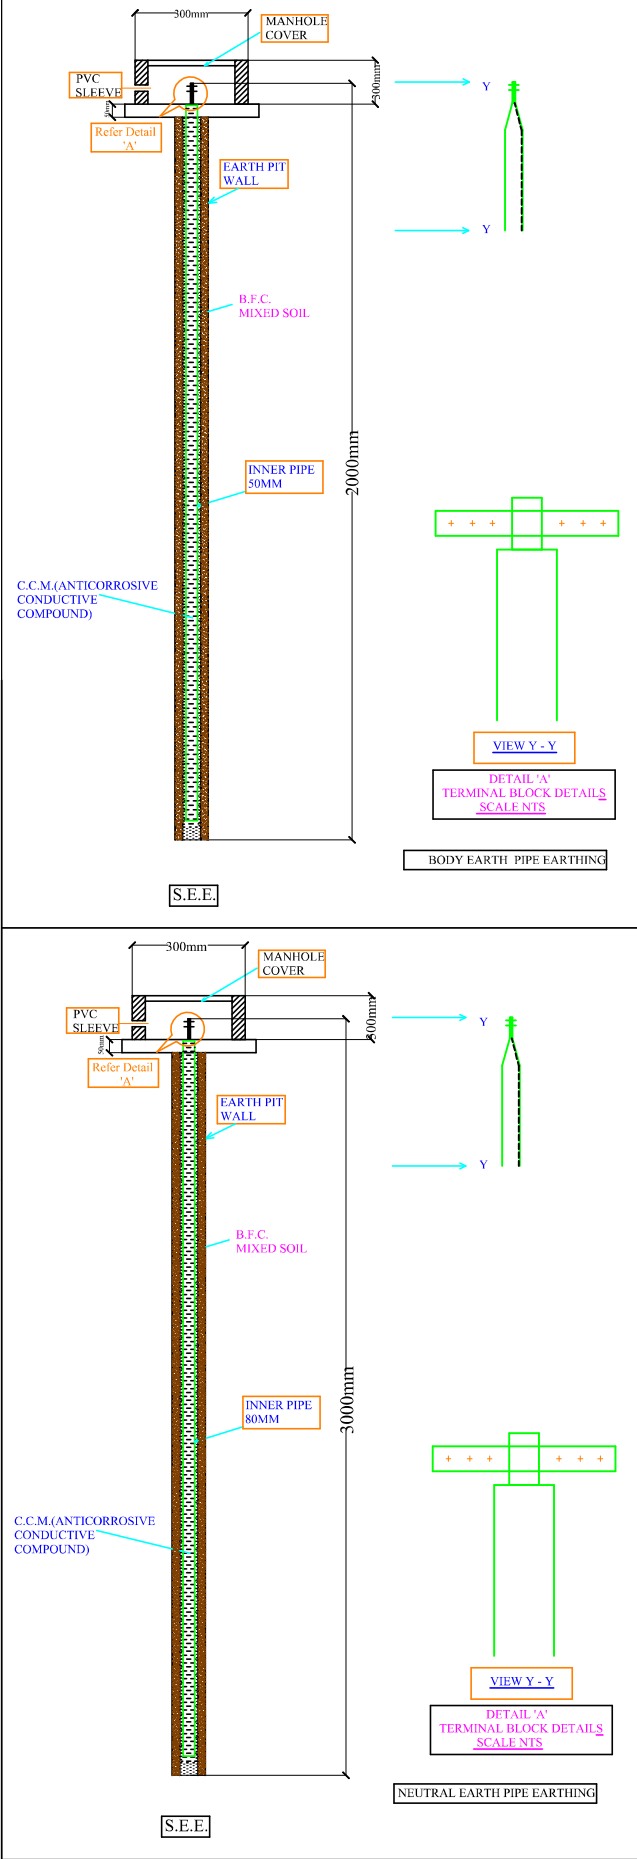

Vipul
VIPUL AGARWAL
M.E.P. CONSULTANT
B.E. ELECTRICAL

SERVICE CONSULTANT	
ASHI ASSOCIATES F/9/440, Keshav Marg Chitrakut Scheme Jaipur PH:91-0-93146-10438, 0141-2440946, Mail: vipul8599@yahoo.com	
PROJECT NAME :-	
CITY HOME TURBAN RESIDENCY PHASE II	
SUBMISSION DRAWINGS	
STILT FLOOR ELE. SUB-STATION, CABLE ROUTE & LIGHTNING ARRESTER PLAN	
SCALE: 1= 100	NORTH :
PROJECT:- RESIDENTIAL RECONSTITUTION PLOT NO. C17 1st EP, C17 1st WP, C17 MAA KARNI NAGAR SCHEME (Bhairav G.N.S.S)	
ARCHITECTS:- GRAPHITE DESIGN STUDIO ARCHITECTS, INTERIOR DESIGNERS, PLANNERS PLOT NO 68, JANAK PURI-II, IMLI WALA PAHTAK, JAIPUR-302005 CONTACT NO. +91-9928334114, 0141-2594414 email: akshil@graphitedesignstudio.com	

OWNER

ARCHITECTS

Vipul
VIPUL AGARWAL
M.E.P. CONSULTANT
B.E. ELECTRICAL

LEGENDS:

Mounting Height	No.	LD	Symbol	Description
+90"		TL C1		Led CEILING Tube Light Make: Sylla Led Cat no.: SSK-T5-20W
+42"		SB		SWITCH BOARD
CEILING		DL		Led 6" Down Lighter 20W (Surface Mounted) Make: Sylla Led Cat no.: SDL-15W GLD 6.5K/4K

SERVICES CONSULTANT:
ASHI ASSOCIATES
F9/440, Keshav Marg Chitrakut Scheme Jaipur
PH: 91-0-93146-10438, 0141-2440946 Mail: vipul8599@yahoo.com

DRAWN. BY:-

CHKD. BY:-

MOHIT

SANJAY

APPD. BY:-

VIPUL AGARWAL

PROJECT NAME :-


CITY HOME TURBAN RESIDENCY PHASE II

SUBMISSION DRAWINGS

STILT FLOOR ELECTRICAL POINT
MARKED PLAN PLAN

SCALE:- 1= 100

NORTH :

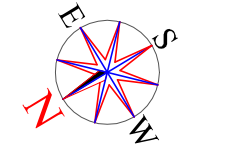


PROJECT:-
RESIDENTIAL RECONSTITUTION
PLOT NO. C17 1st EP, C17 1st WP, C17
MAA KARNI NAGAR SCHEME
(Bhairav G.N.S.S)

ARCHITECTS:-


GRAPHITE DESIGN STUDIO
ARCHITECTS, INTERIOR DESIGNERS, PLANNERS
PLOT NO 68, JANAK PURI-I, IMLIWALA PAHTAK, JAIPUR-302005
CONTACT NO. +91-9928334414, 0141-2594414
email: akshit@graphitedesignstudio.com

OWNER

ARCHITECTS

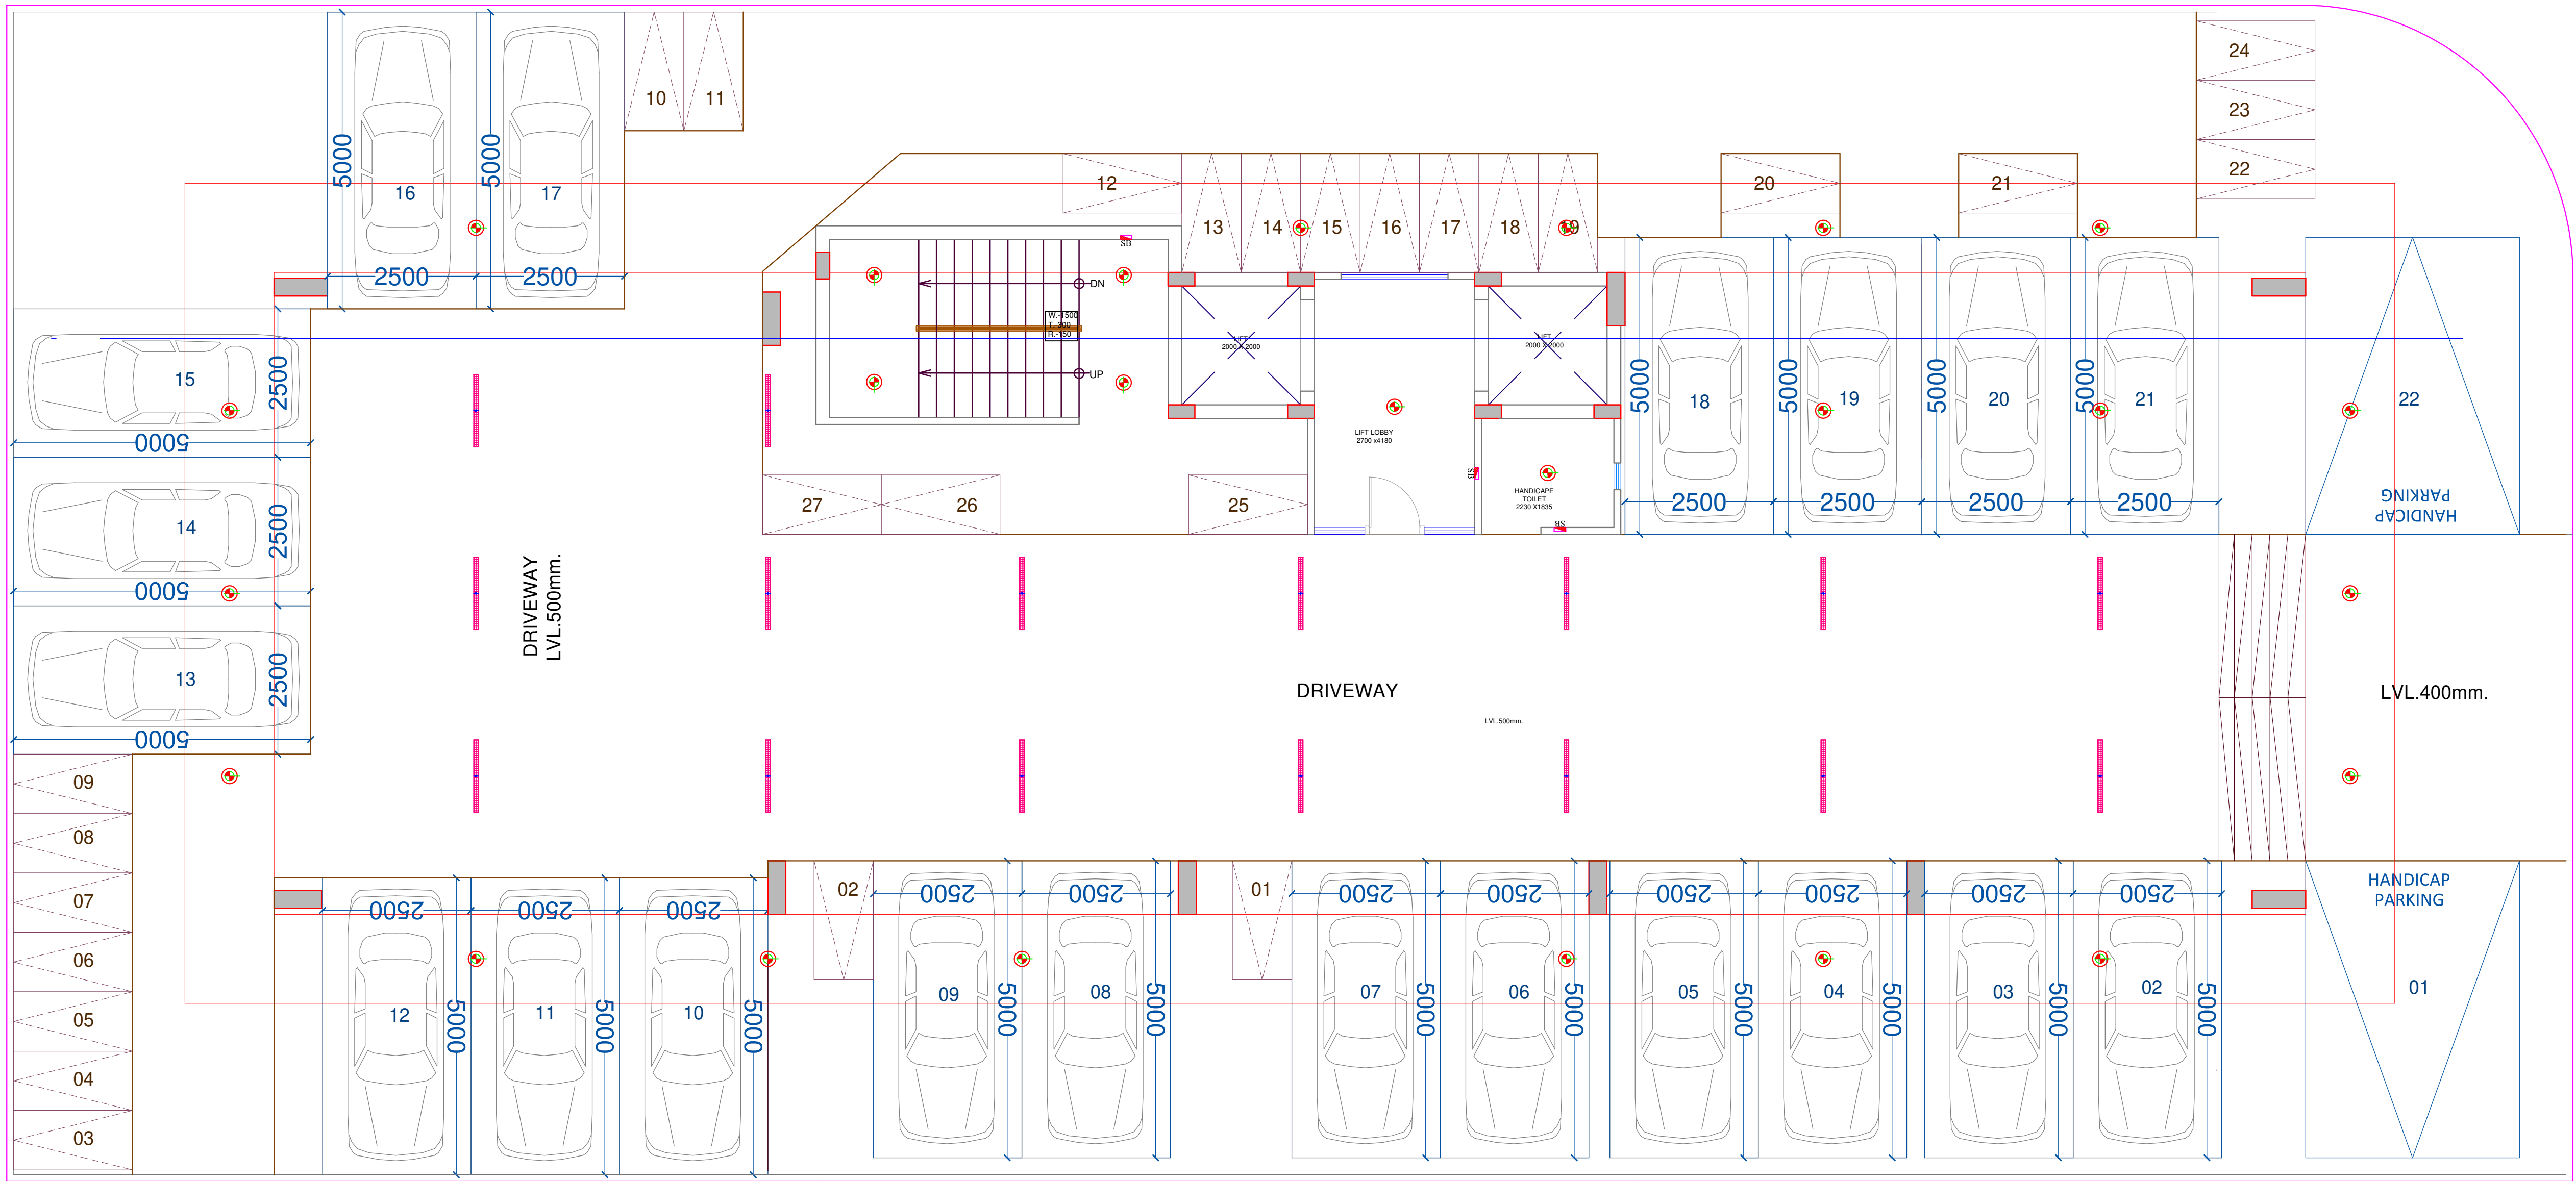

STILT FLOOR PLAN

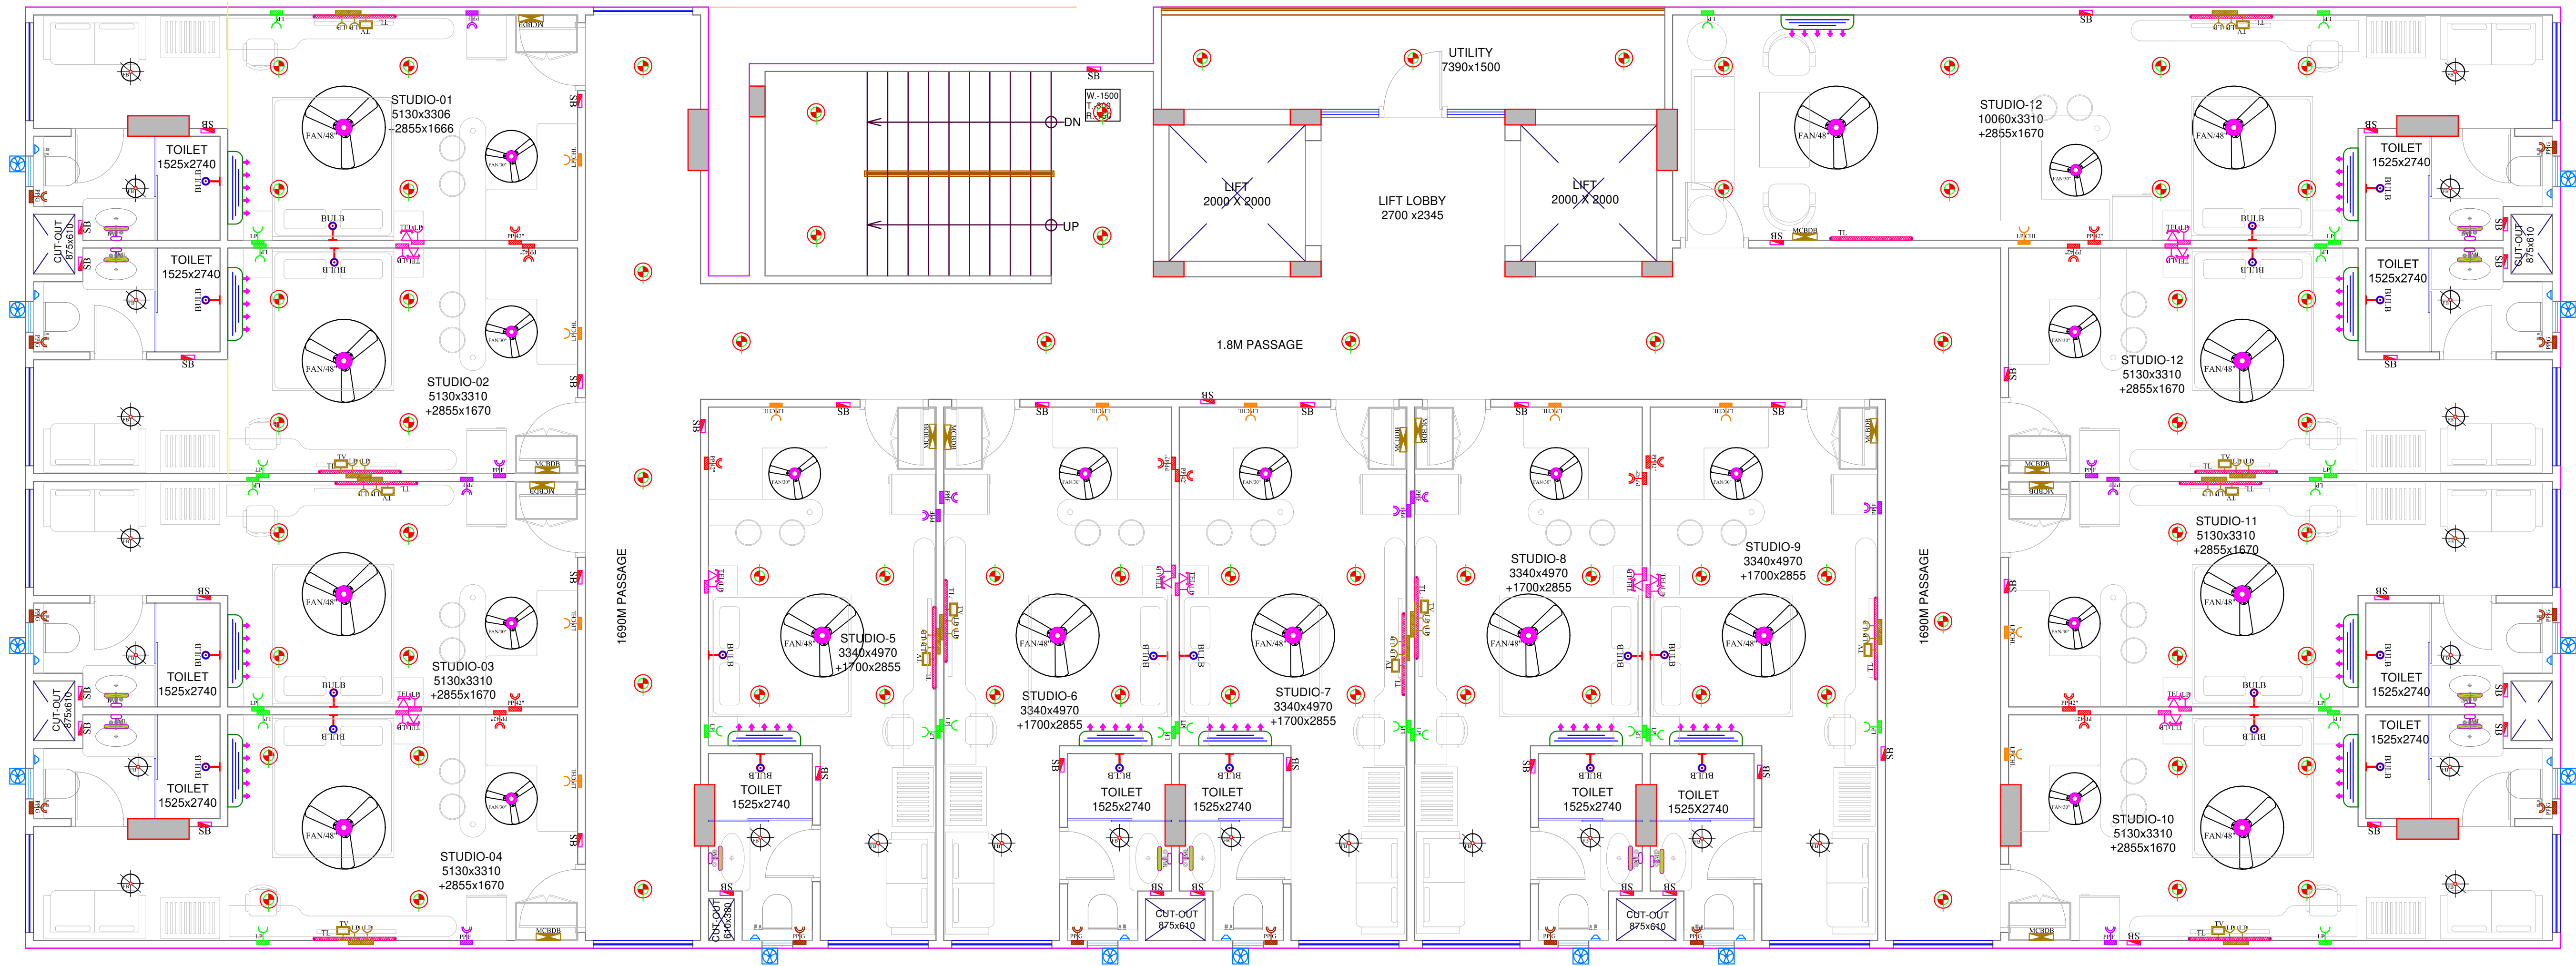

TYPICAL FLOOR PLAN
(1st to 6th floor plan)

SHEET NO. 02

LEGENDS:

Meaning	Height	No.	LD	Symbol	Description
CEILING				FAN48"	CEILING FAN 48"
CEILING				FAN30"	CEILING FAN 30"
CEILING				FB	FAN BOX
+90"				TL/W	LED Wall Tube Light Make: Soka Led Cat no: SKC-TL-20W
+90"				BULB	LED Bulb 20W Make: Soka Led Cat no: SKC-20W 5.7K/OK
+90"				GL	WALL BRACKETS AS DESIGN FOR GANESHA LIGHT
+78"				ML	1522 Led Mirror Light Make: Soka Led Cat no: PPL-1522
CEILING				DL	LED P Down Lighter 20W (Surface Mounted) Make: Soka Led Cat no: SML-15W GLD & SKIK
VENTILATOR				CR	CEILING ROSE
VENTILATOR				EXP	12" DIA FRESH AIR FAN
+42"				SB	SWITCH BOARD
+24"				TEL	TELEPHONE POINT
+24"				LP TEL	6 A PLUG POINT FOR TELEPHONE
+48"				TV	TV COAXIAL PORT
+48"				LP TV	6 A PLUG POINT FOR TV
+24"				LP	6 A PLUG POINT FOR SIDE TABLE
+72"				LP CH	6 A PLUG POINT FOR CHIMNEY
+90"				SAC	SPLIT AC INDOOR UNIT
+42"				PP-42"	16 A POWER POINT
+78"				PP-G	16 A POWER POINT FOR GEYSER
+54"				PP-F	16 A POWER POINT FOR FRIDGE
+48"				MCB DB	MCB DISTRIBUTION BOARD

SERVICES CONSULTANT:
ASHI ASSOCIATES
P9/440, Keshav Marg Chitrakut Scheme, Jaipur
PH: 91-0-93146-10438, 0141-2440946. Mail: vipul8599@yahoo.com

DRAWN. BY:- CHKD. BY:-

MOHIT SANJAY

APPD. BY:- VIPUL AGARWAL


PROJECT NAME :-

CITY HOME TURBAN RESIDENCY PHASE II

SUBMISSION DRAWINGS

TYPICAL FLOOR ELECTRICAL POINT
MARKED PLAN


SCALE:- 1= 100

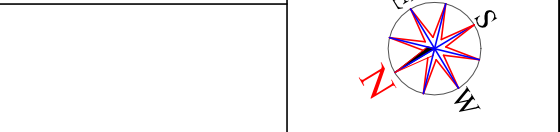

PROJECT:-
RESIDENTIAL RECONSTITUTION
PLOT NO. C17 1st EP, C17 1st WP, C17
MAA KARNI NAGAR SCHEME
(Bhairav G.N.S.S.)

ARCHITECTS:-
GRAPHITE DESIGN STUDIO
ARCHITECTS, INTERIOR DESIGNERS, PLANNERS
PLOT NO 68, JANAK PURI-I, MILI WALA PAHTAK, JAIPUR-302005
CONTACT NO. +91-9928334414, 0141-2594414
email: akshi@graphitedesignstudio.com

OWNER ARCHITECTS

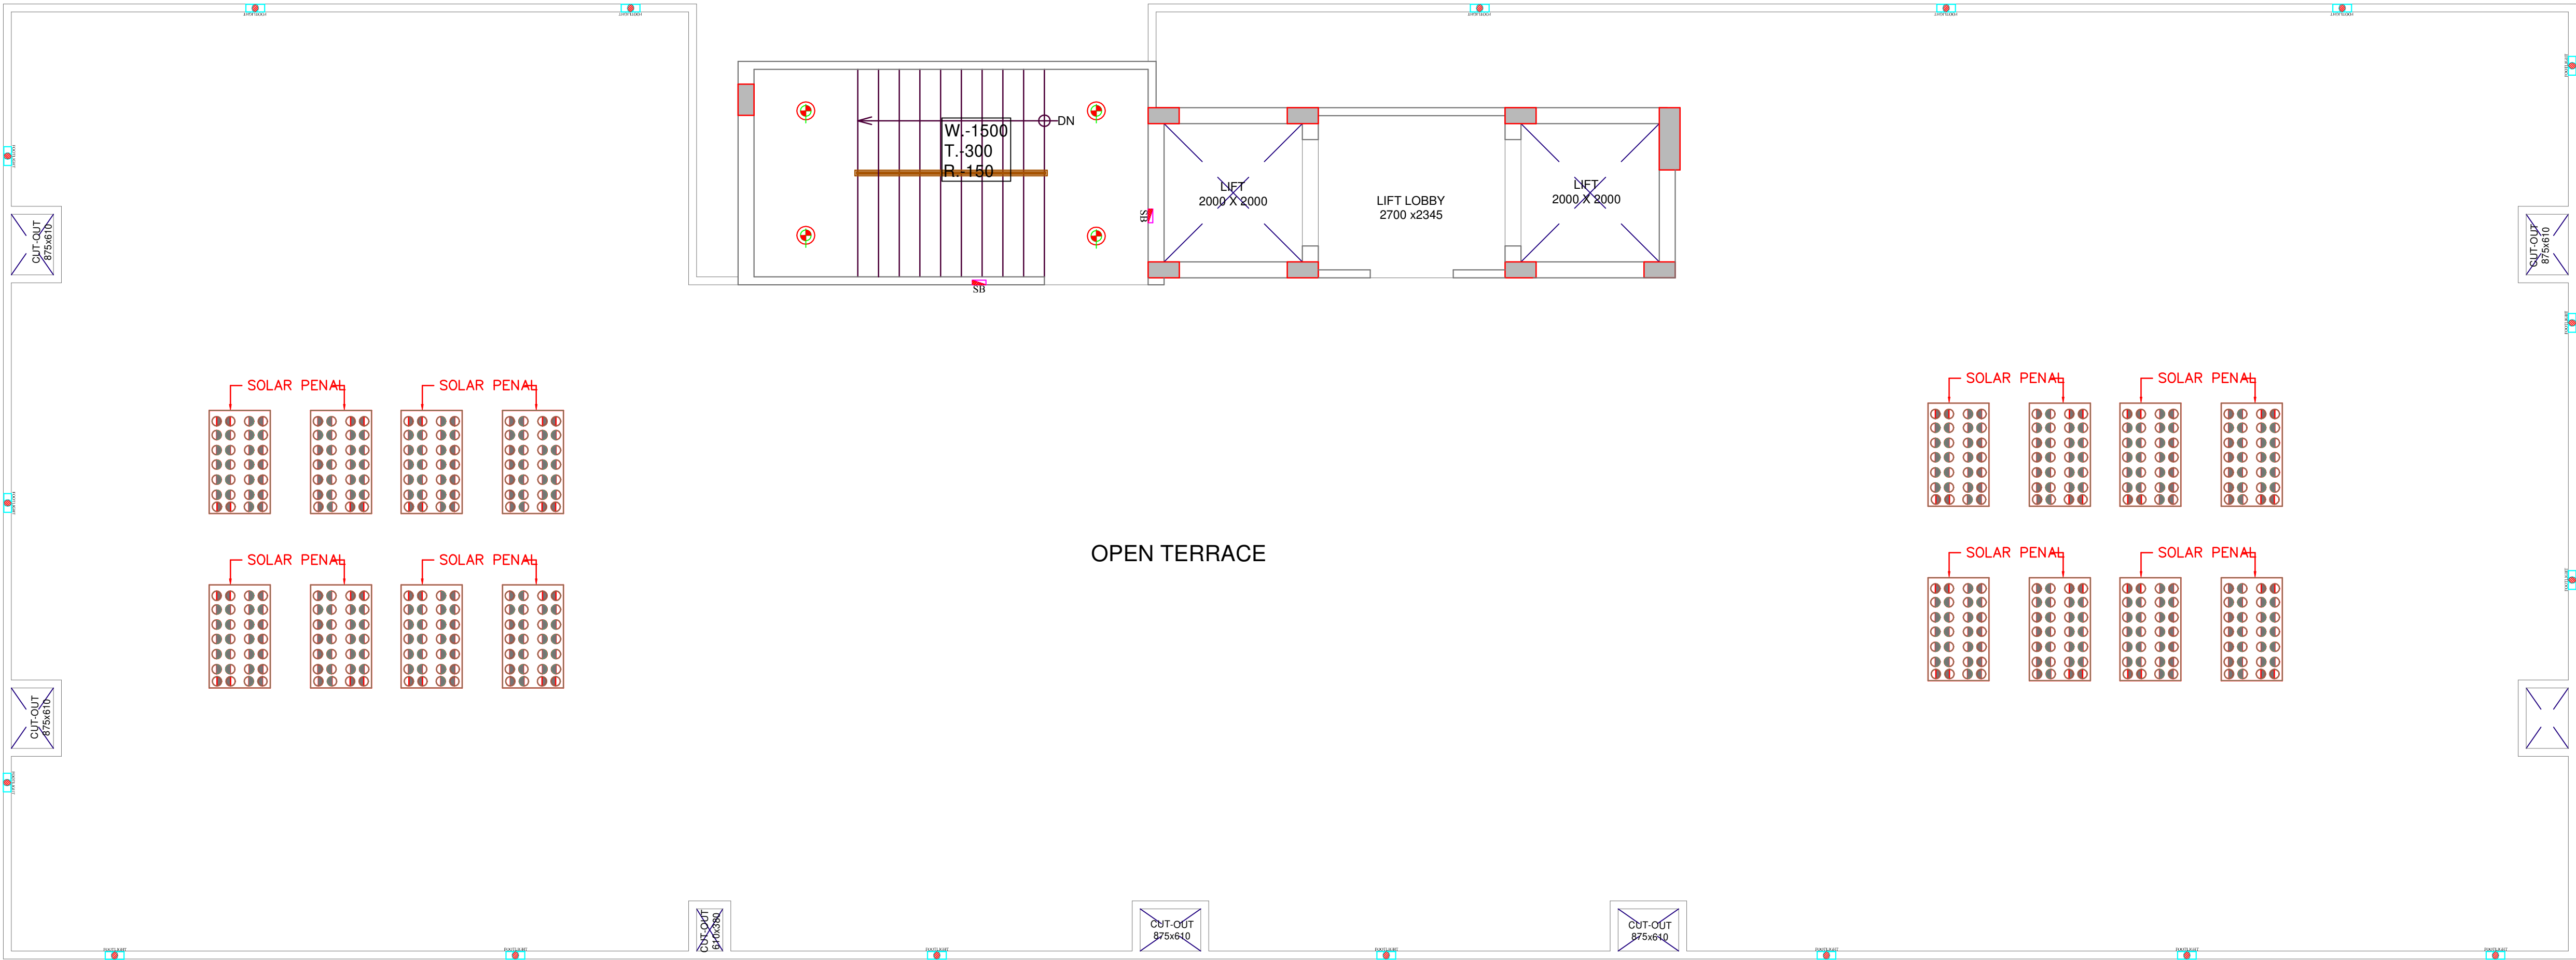

TERRACE FLOOR PLAN

LEGENDS:				
Mounting Height	No.	I D	Symbol	Description
CEILING		DL		Led 6" Down Lighter 20W (Surface Mounted) Make:- Syska Led Cat no:- SDL-15W GLD 6.5K4K
+18"		FL		FOOT LIGHT
+42"		SB		SWITCH BOARD

SERVICES CONSULTANT:
ASHI ASSOCIATES
F9/440,Keshav Marg Chitrakut Scheme,Jaipur
PH:91-0-93146-10438 ,0141-2440946 Mail:vipul8599@yahoo.com

DRAWN. BY:-
MOHIT

CHKD. BY:-
SANJAY

APPD. BY:- VIPUL AGARWAL

PROJECT NAME :-

CITY HOME TURBAN RESIDENCY PHASE II

SUBMISSION DRAWINGS

TERRACE FLOOR ELECTRICAL
POINT MARKED PLAN

SCALE:- 1= 100

NORTH :

PROJECT:-
RESIDENTIALRECONSTITUTION
PLOT NO. C17 1st EP, C17 1st WP,
C17
MAA KARNI NAGAR SCHEME
(Bhairav G.N.S.S)

ARCHITECTS:-
GRAPHITE DESIGN STUDIO
ARCHITECTS, INTERIOR DESIGNERS, PLANNERS
PLOT NO 68, JANAK PURI-I, IMLIWALA PAHTAK, JAIPUR-302005
CONTACT NO. +91-9928334414, 0141-2594414
email: akshit@graphitedesignstudio.com

OWNER	ARCHITECTS
-------	------------

39 NOS. STUDIO FLATS ENERGY METER