


PROJECT NAME :

AMARA STUDIOS

DEVELOPER NAME :

M/S JITENDRA SINGH

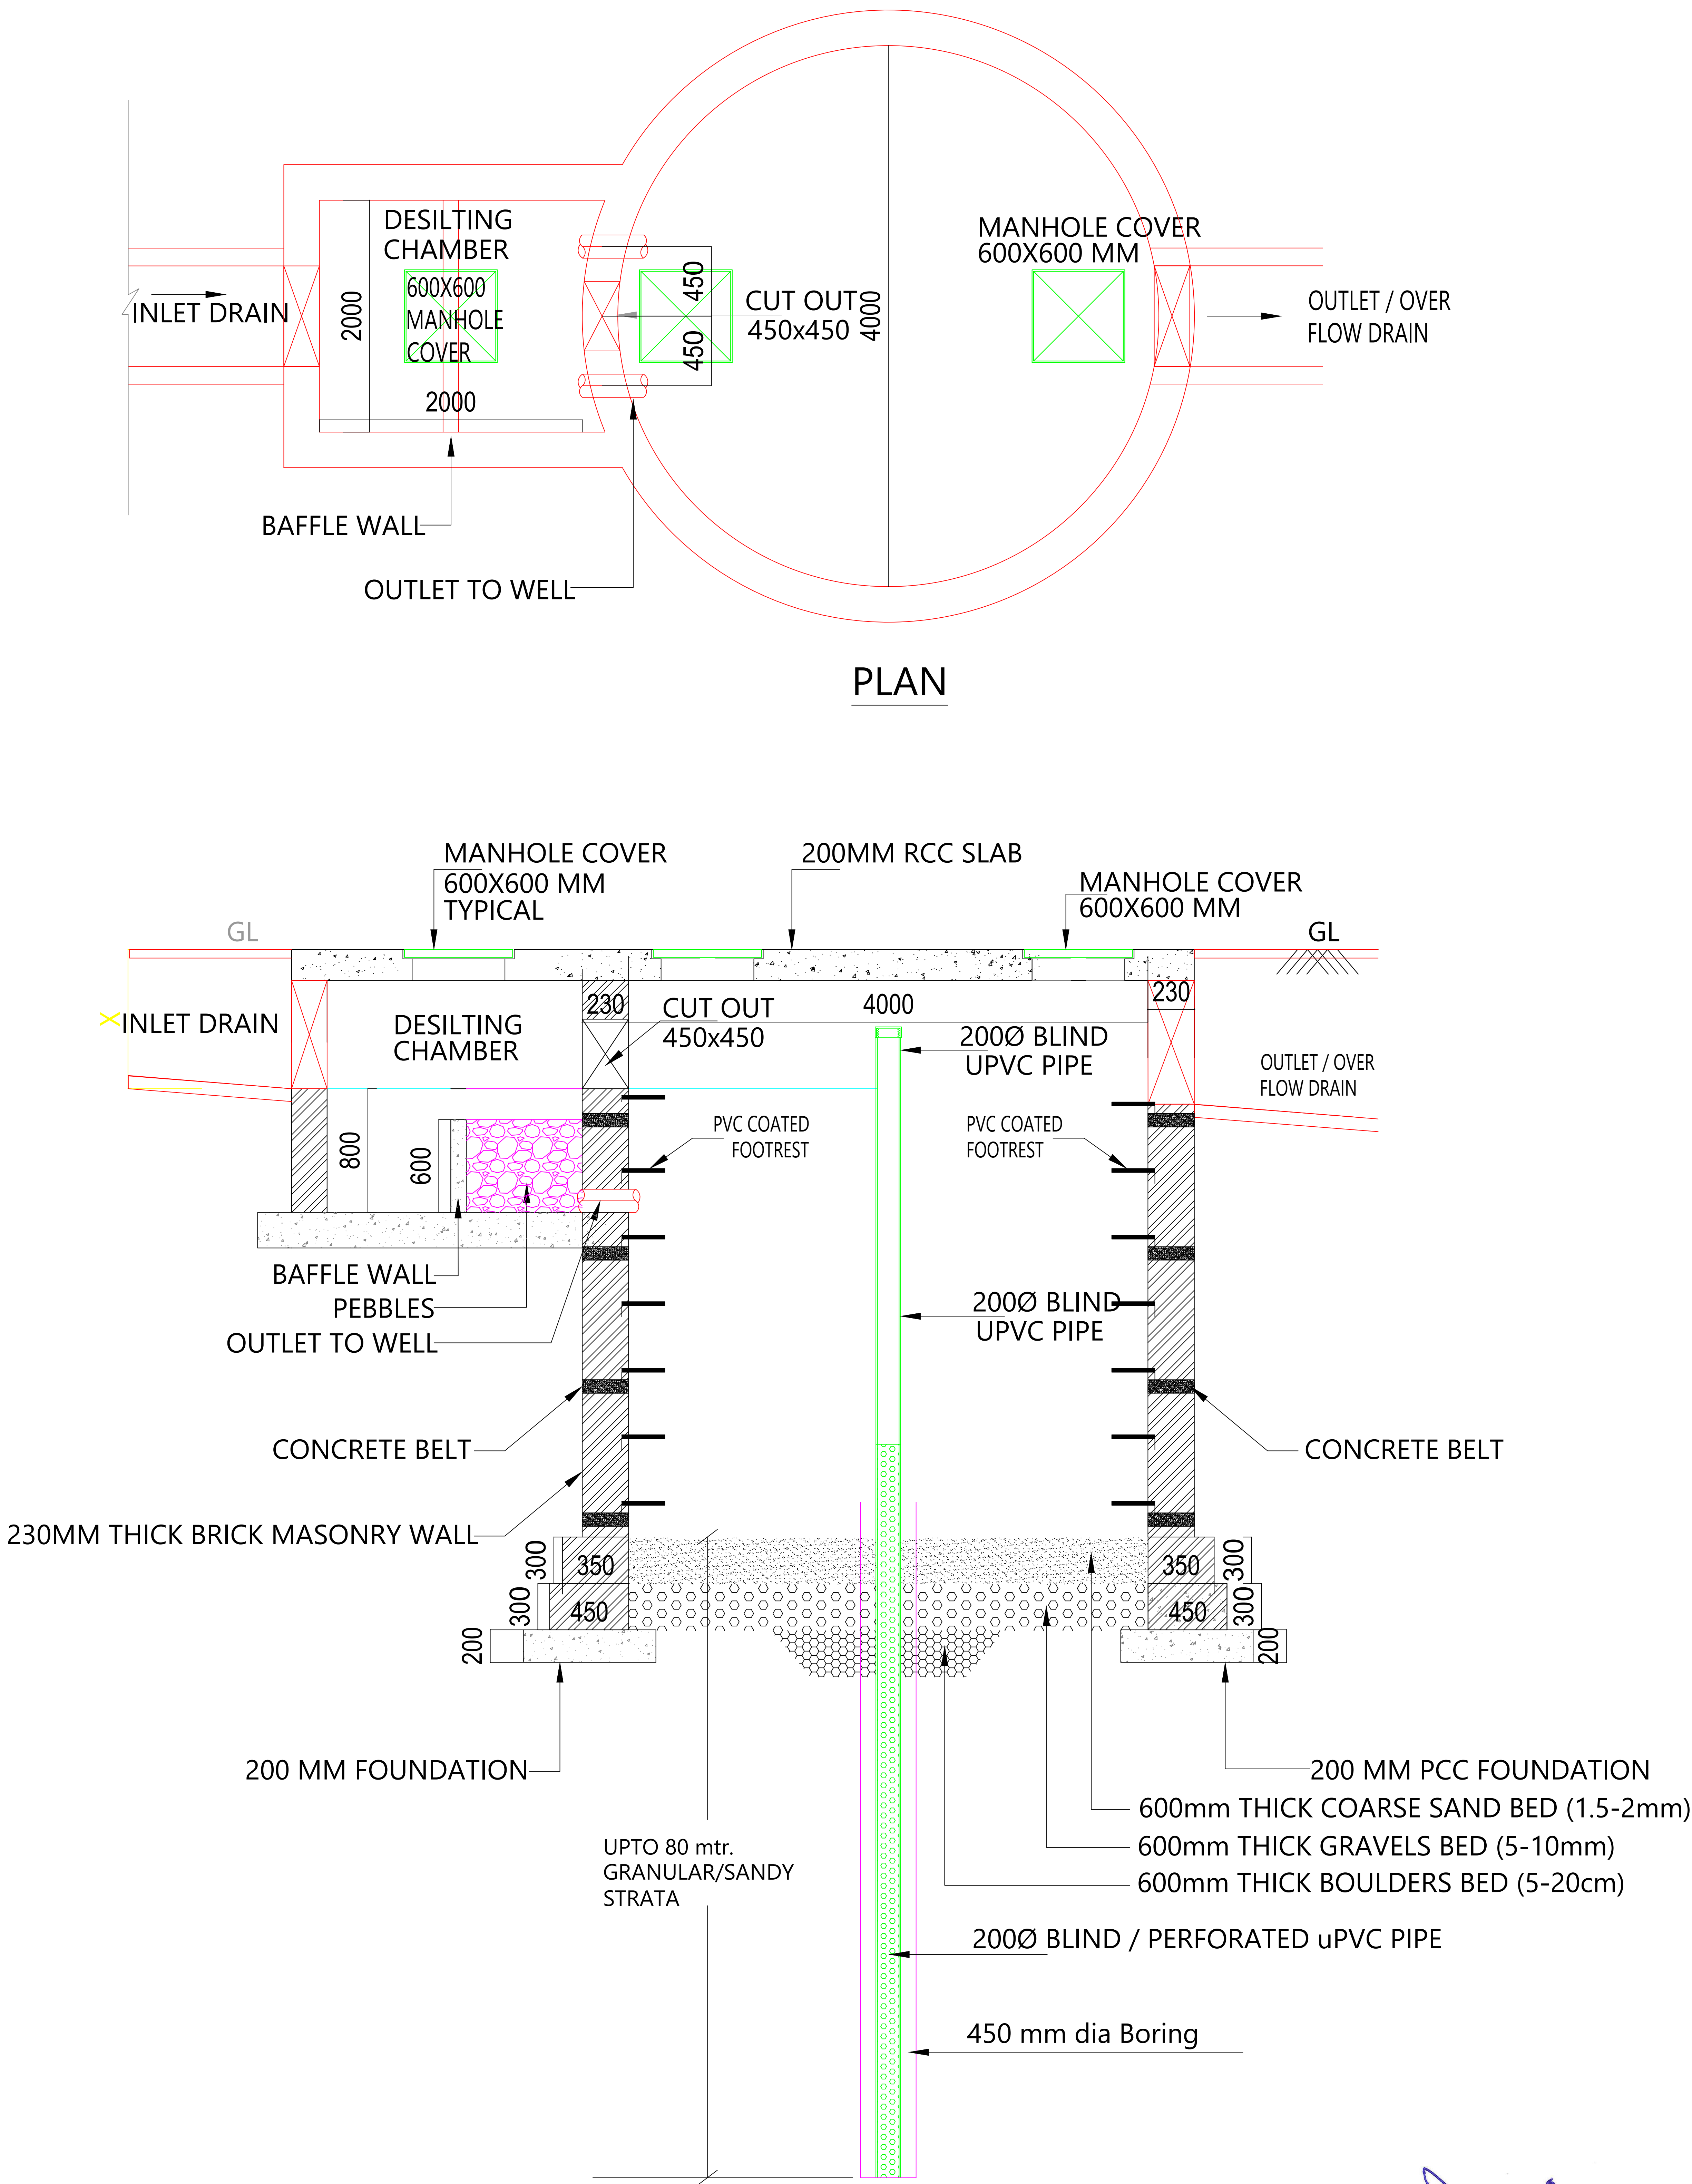

LEGEND:-

①	SOIL PIPE	
②	WASTE PIPE	
③	VENT PIPE	
④	COLD WATER SUPPLY (CWS)	
⑤	HOT WATER SUPPLY (HWS)	
	RAIN WATER PIPE	
SW	SEWER LINE- EXTERNAL	
RW	STORM WATER DRAINAGE PIPE	
	SEWERAGE MANHOLE (2' x 2')	M.H.
	STORM WATER MANHOLE (2' x 2')	M.H.
GT	GULLY TRAP	
BV	BALL VALVE	
FT	FLOOR TRAP	
FD	FLOOR FLOOR DRAIN	
	RAIN WATER COLLECTION CHAMBER 450X450MM	
	KHURRA	

S No. DATE REVISION DESCRIPTION

- GENERAL NOTES:
- All dimension on this drawing are in MMS System Only written dimensions are to be followed. Drawing should not be scaled.
 - All measurements must be checked and verified by the contractors prior to execution of work at the site.
 - This drawing is to be read in conjunction with all relevant structural, services & facility drawings.
 - Architectural drawings are to be followed for the location of all structural members & masonry walls. For sizes & reinforcement details of structural members, relevant structural drawings are to be referred.
 - Any discrepancies between architectural, structural and services drawings must be brought to the notice of the architect immediately & prior to execution of work. Coordination with services such as HVAC, plumbing & electrical, etc. is the responsibility of the contractor.
 - All masonry walls should be aligned with the columns as indicated on the plan. In case of any discrepancy, the contractor shall be responsible for the same.
 - For details, refer relevant large scale detail drawings, as indicated.

PROJECT:

PROPOSED STUDIO APARTMENT ON PLOT NO. - G-13-E, IN SCHEME - WEST WAY HEIGHTS, JAIPUR.

NAME OF DRAWING:

RAIN WATER HARVESTING PIT SECTION DETAILS PLAN

DRAWING WORKING DRAWING

NORTH:



PROJECT NO. :

DATE :

07-01-2025

SCALE :

NTS

REV NO. :

R-0

DRAWING NO. :

PROJECT	CATEGORY	BLOCK	FLOOR	TYPE	NUMBER
---------	----------	-------	-------	------	--------

A-201

RAIN WATER HARVESTING/ RECHARGING

NOTES:

- ALL DIMENSIONS ARE IN MM. AND INDICATIVE ONLY. SUITABLE AMENDMENTS MAY BE DONE AS PER ACTUAL SITE CONDITIONS.
- THE DIMENSION OF STRUCTURAL ELEMENTS (FOUNDATION, WALL, SLAB ETC.) ARE ONLY INDICATIVE. THESE SHALL BE AS PER STRUCTURAL DRAWINGS.
- THE DIMENSION 'X' SHALL BE CALCULATED ON THE BASIS OF INVERT OF UPSTREAM DRAIN

Er. SANJEEV SHARMA
B.E (Electrical)

PROJECT NAME :

AMARA STUDIOS

DEVELOPER NAME :

M/S JITENDRA SINGH

ARCHITECTS :

4 INSIDE

ARCHITECTURE N INTERIORS
Plot no. 72, S.P. Marg , C- Scheme
jaipur, rajasthan, India
cont: +91 9950595991 , 91 9982812777
e.mail: jeefs.arch@gmail.com

LEGEND:-

①	SOIL PIPE	
②	WASTE PIPE	
③	VENT PIPE	
④	COLD WATER SUPPLY (CWS)	
⑤	HOT WATER SUPPLY (HWS)	
	RAIN WATER PIPE	
SW	SEWER LINE- EXTERNAL	
RW	STORM WATER DRAINAGE PIPE	
	SEWERAGE MANHOLE (2' x 2')	M.H.
	STORM WATER MANHOLE (2' x 2')	M.H.
GT	GULLY TRAP	
BV	BALL VALVE	
FT	FLOOR TRAP	
FD	FLOOR FLOOR DRAIN	
	RAIN WATER COLLECTION CHAMBER 450X450MM	
	KHURRA	

PROJECT:

PROPOSED STUDIO APARTMENT ON
PLOT NO. - G-13-E, IN SCHEME - WEST
WAY HEIGHTS, JAIPUR.

NAME OF DRAWING:

STILT FLOOR (WATER SUPPLY,
RAINWATER HARVESTING,
SANITATION & COMMON
PLUMBING) DRAWING

DRAWING

WORKING DRAWING

PROJECT NO. :

SCALE :
NTS

DRAWING NO. :

PROJECT CATEGORY BLOCK FLOOR TYPE NUMBER

A-01

NORTH:




DATE:

07-01-2025

REV NO. :

R-0

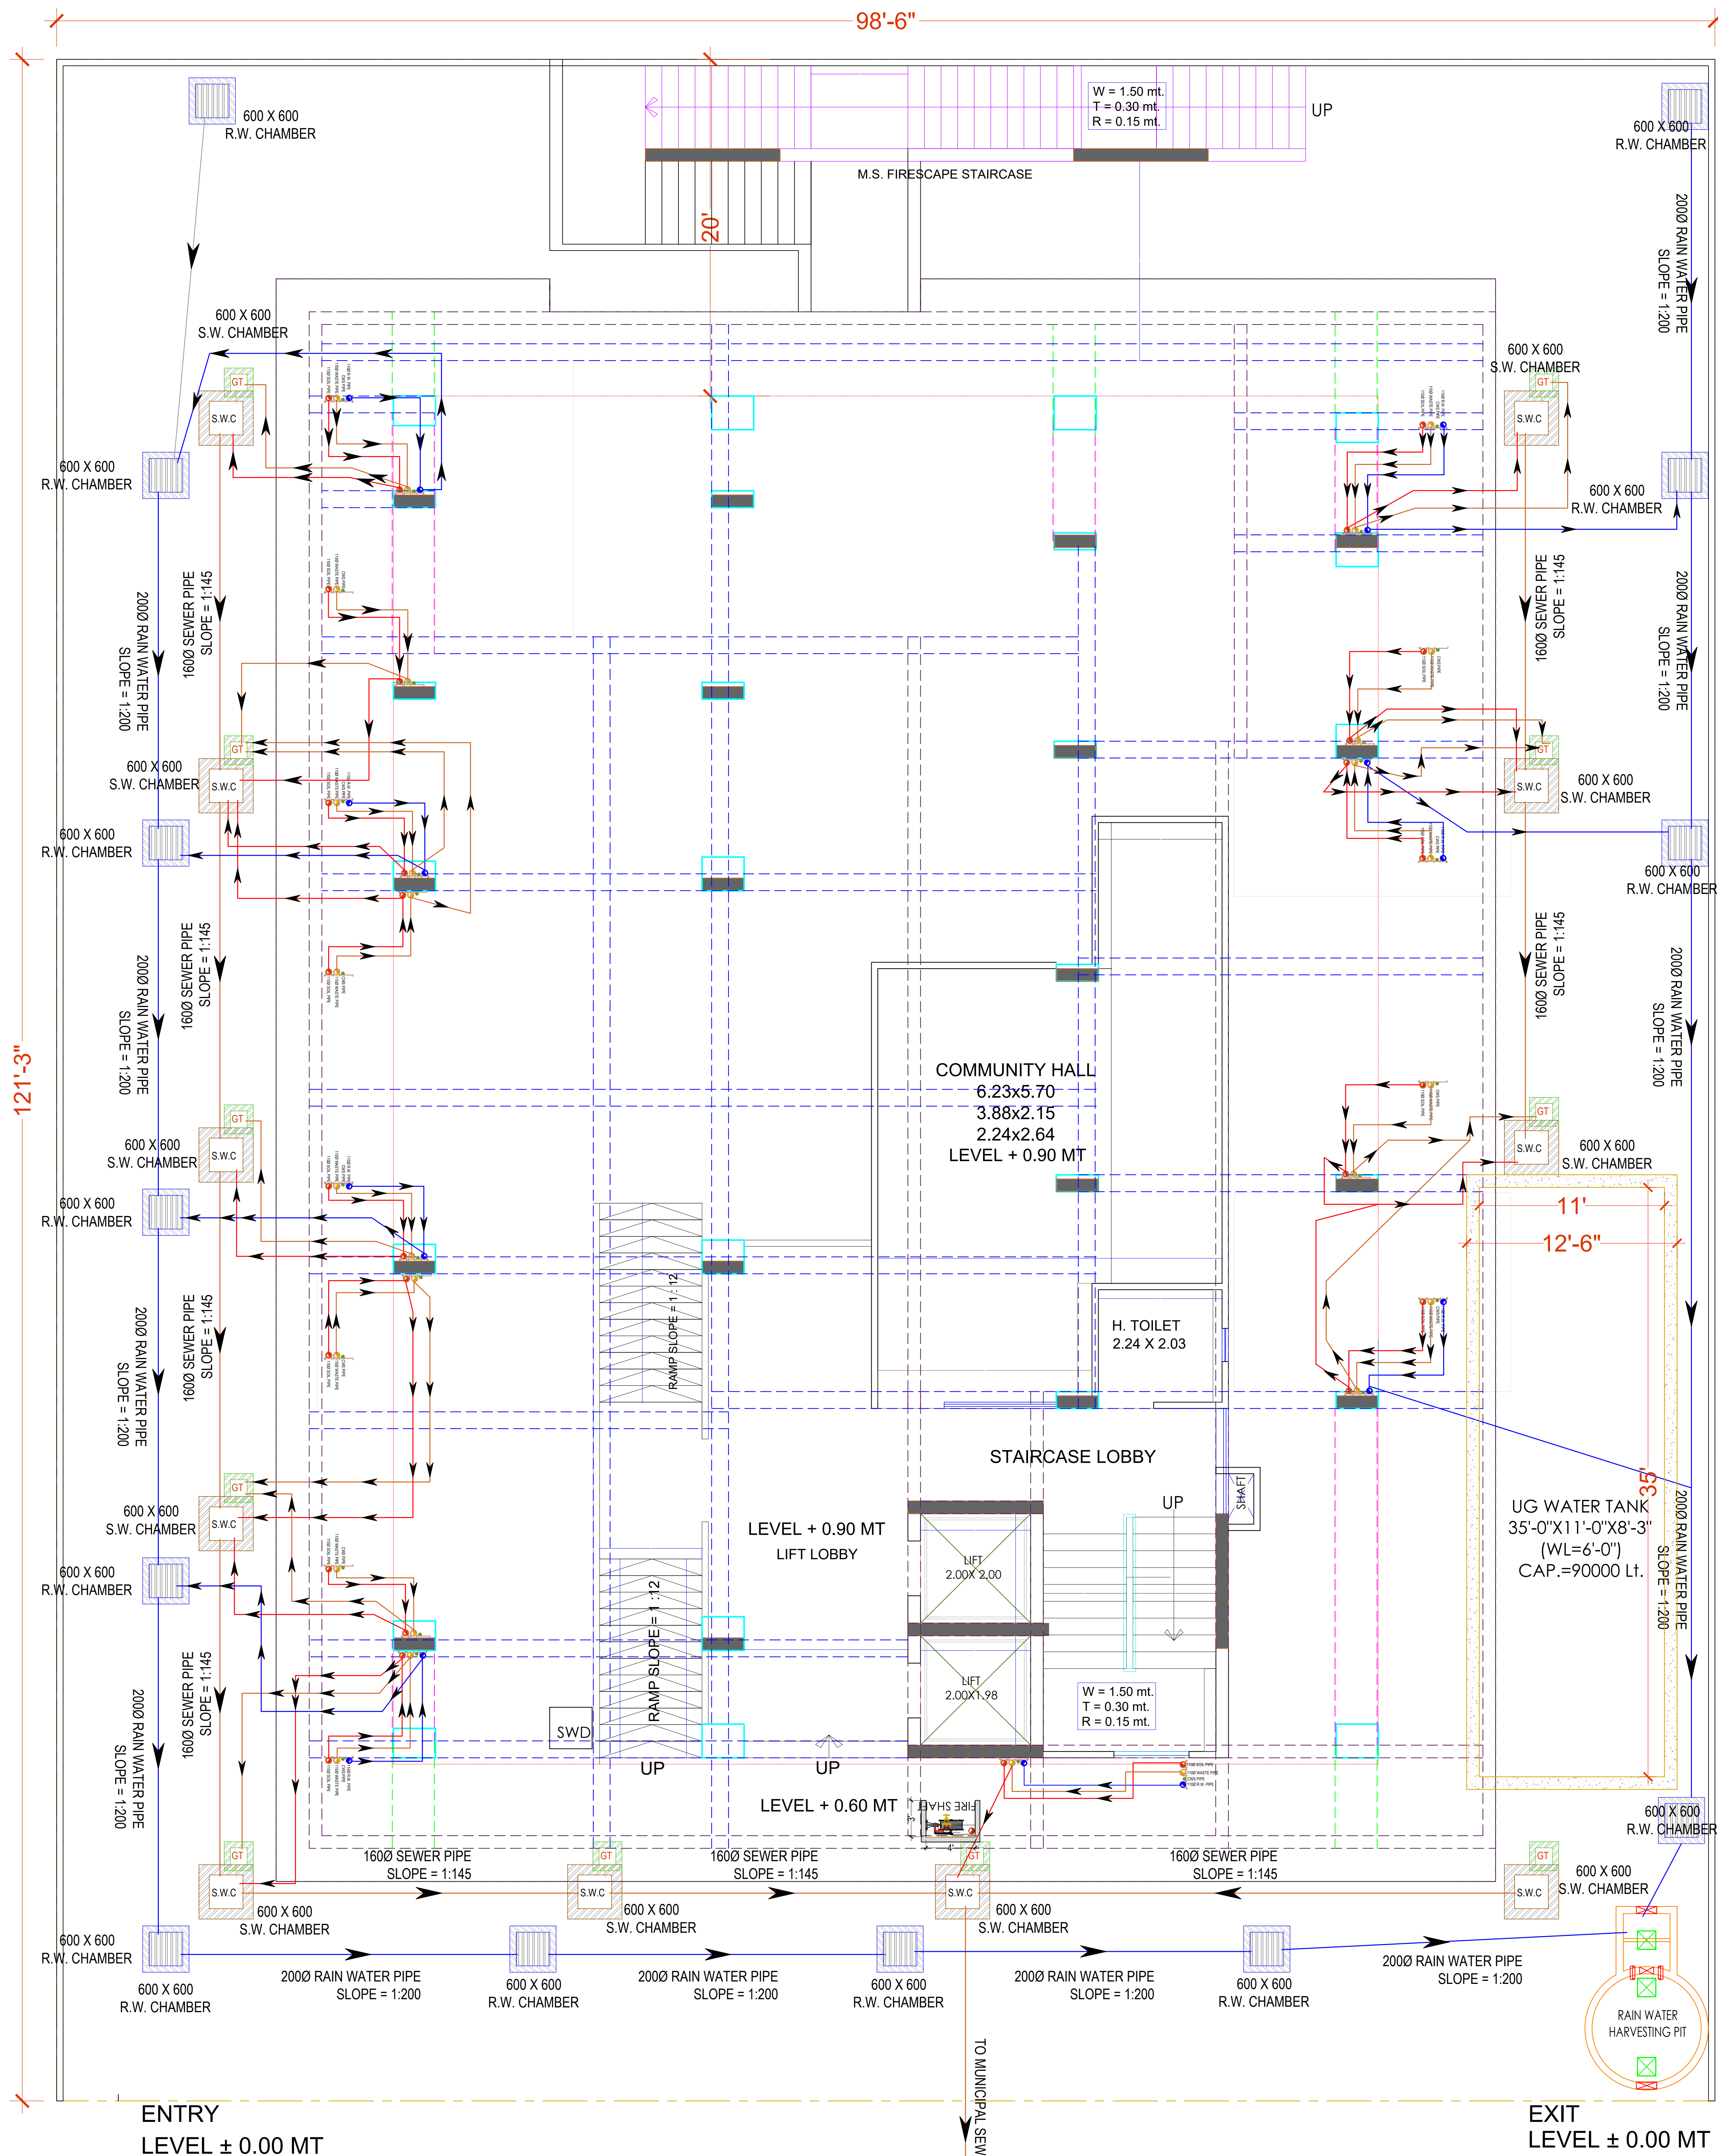

STILT FLOOR PLAN

WATER SUPPLY, RAINWATER HARVESTING,
SANITATION & COMMON PLUMBING DRAWING

Er. SANJEEV SHARMA
B.E (Electrical)

PROJECT NAME :

AMARA STUDIOS

DEVELOPER NAME :

M/S JITENDRA SINGH

ARCHITECTS :

4 INSIDE
ARCHITECTURE N INTERIORS
Plot no. 72, S.P. Marg, C- Scheme
jaipur, rajasthan, India
cont: +91 9950595991, 91 9982812777
e.mail: jeets.arch@gmail.com

LEGEND:-

①	SOIL PIPE	
②	WASTE PIPE	
③	VENT PIPE	
④	COLD WATER SUPPLY (CWS)	
⑤	HOT WATER SUPPLY (HWS)	
	RAIN WATER PIPE	
SW	SEWER LINE- EXTERNAL	
RW	STORM WATER DRAINAGE PIPE	
	SEWERAGE MANHOLE (2'x2')	M.H.
	STORM WATER MANHOLE (2'x2')	M.H.
GT	GULLY TRAP	
BV	BALL VALVE	
FT	FLOOR TRAP	
FD	FLOOR FLOOR DRAIN	
	RAIN WATER COLLECTION CHAMBER 450X450MM	
	KHURRA	

Er. Sanjeev Sharma
Er. Sanjeev Sharma
B.E. (Electrical)


PROJECT:

PROPOSED STUDIO APARTMENT ON
PLOT NO. - G-13-E, IN SCHEME - WEST
WAY HEIGHTS, JAIPUR.

NAME OF DRAWING:

TYPICAL FLOOR
(WATER SUPPLY, RAINWATER,
SANITATION & COMMON
PLUMBING) DRAWING

DRAWING WORKING DRAWING	NORTH:
PROJECT NO.:	DATE: 07-01-2025
SCALE: NTS	REV.NO.: R-0
DRAWING NO.:	
PROJECT	CATEGORY
BUILD	FLOOR
TYPE	NUMBER
A-01	

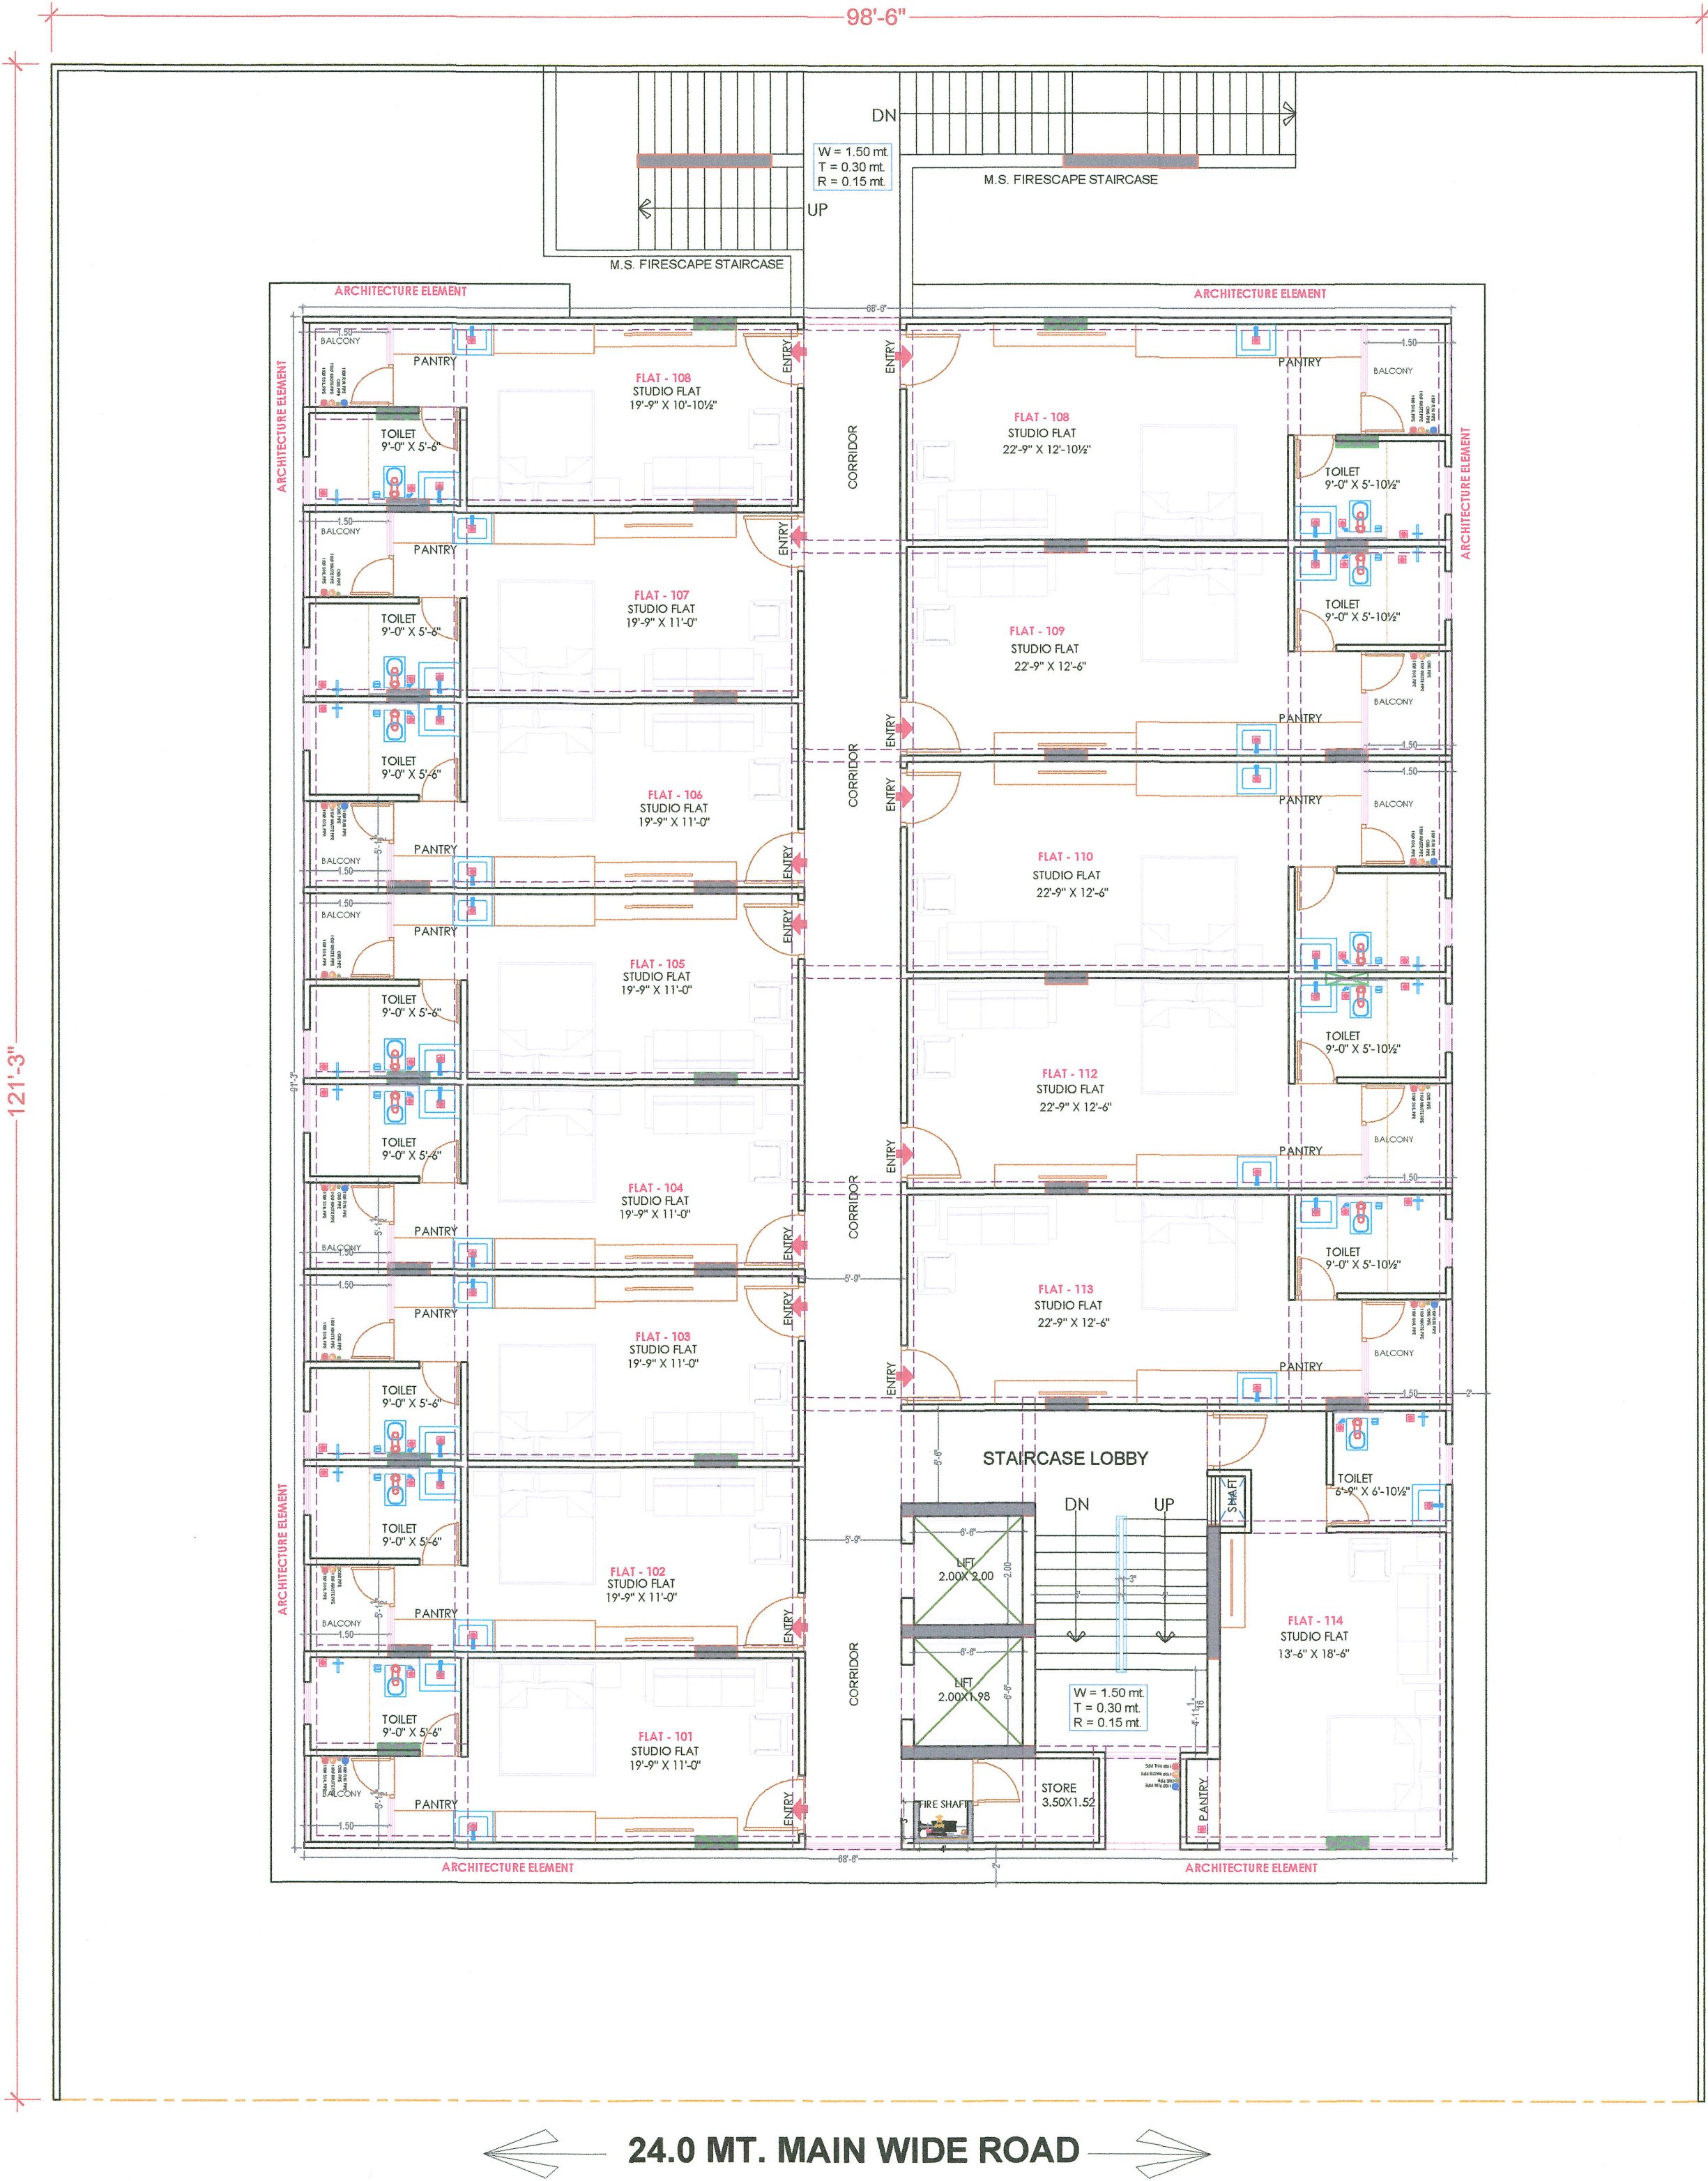

TYPICAL FLOOR (WATER SUPPLY, RAINWATER,
SANITATION & COMMON PLUMBING) DRAWING