



LEGEND:-	
SWP	Ø6" SOIL WASTE PIPE
WWP	Ø6" WASTE WATER PIPE
SWP	Ø4" SOIL WASTE PIPE
WWP	Ø4" WASTE WATER PIPE
RWP	Ø4" RAIN WATER PIPE
VP	Ø3" VENT PIPE
	Ø6" SOIL WASTE WATER PIPE
	Ø6" WASTE WATER PIPE
	Ø6" RAIN WATER PIPE
	Ø4" SOIL WASTE WATER PIPE
	Ø4" WASTE WATER PIPE
	Ø4" RAIN WATER PIPE
	Ø3" VENT PIPE
	CLEAN OUT POINT

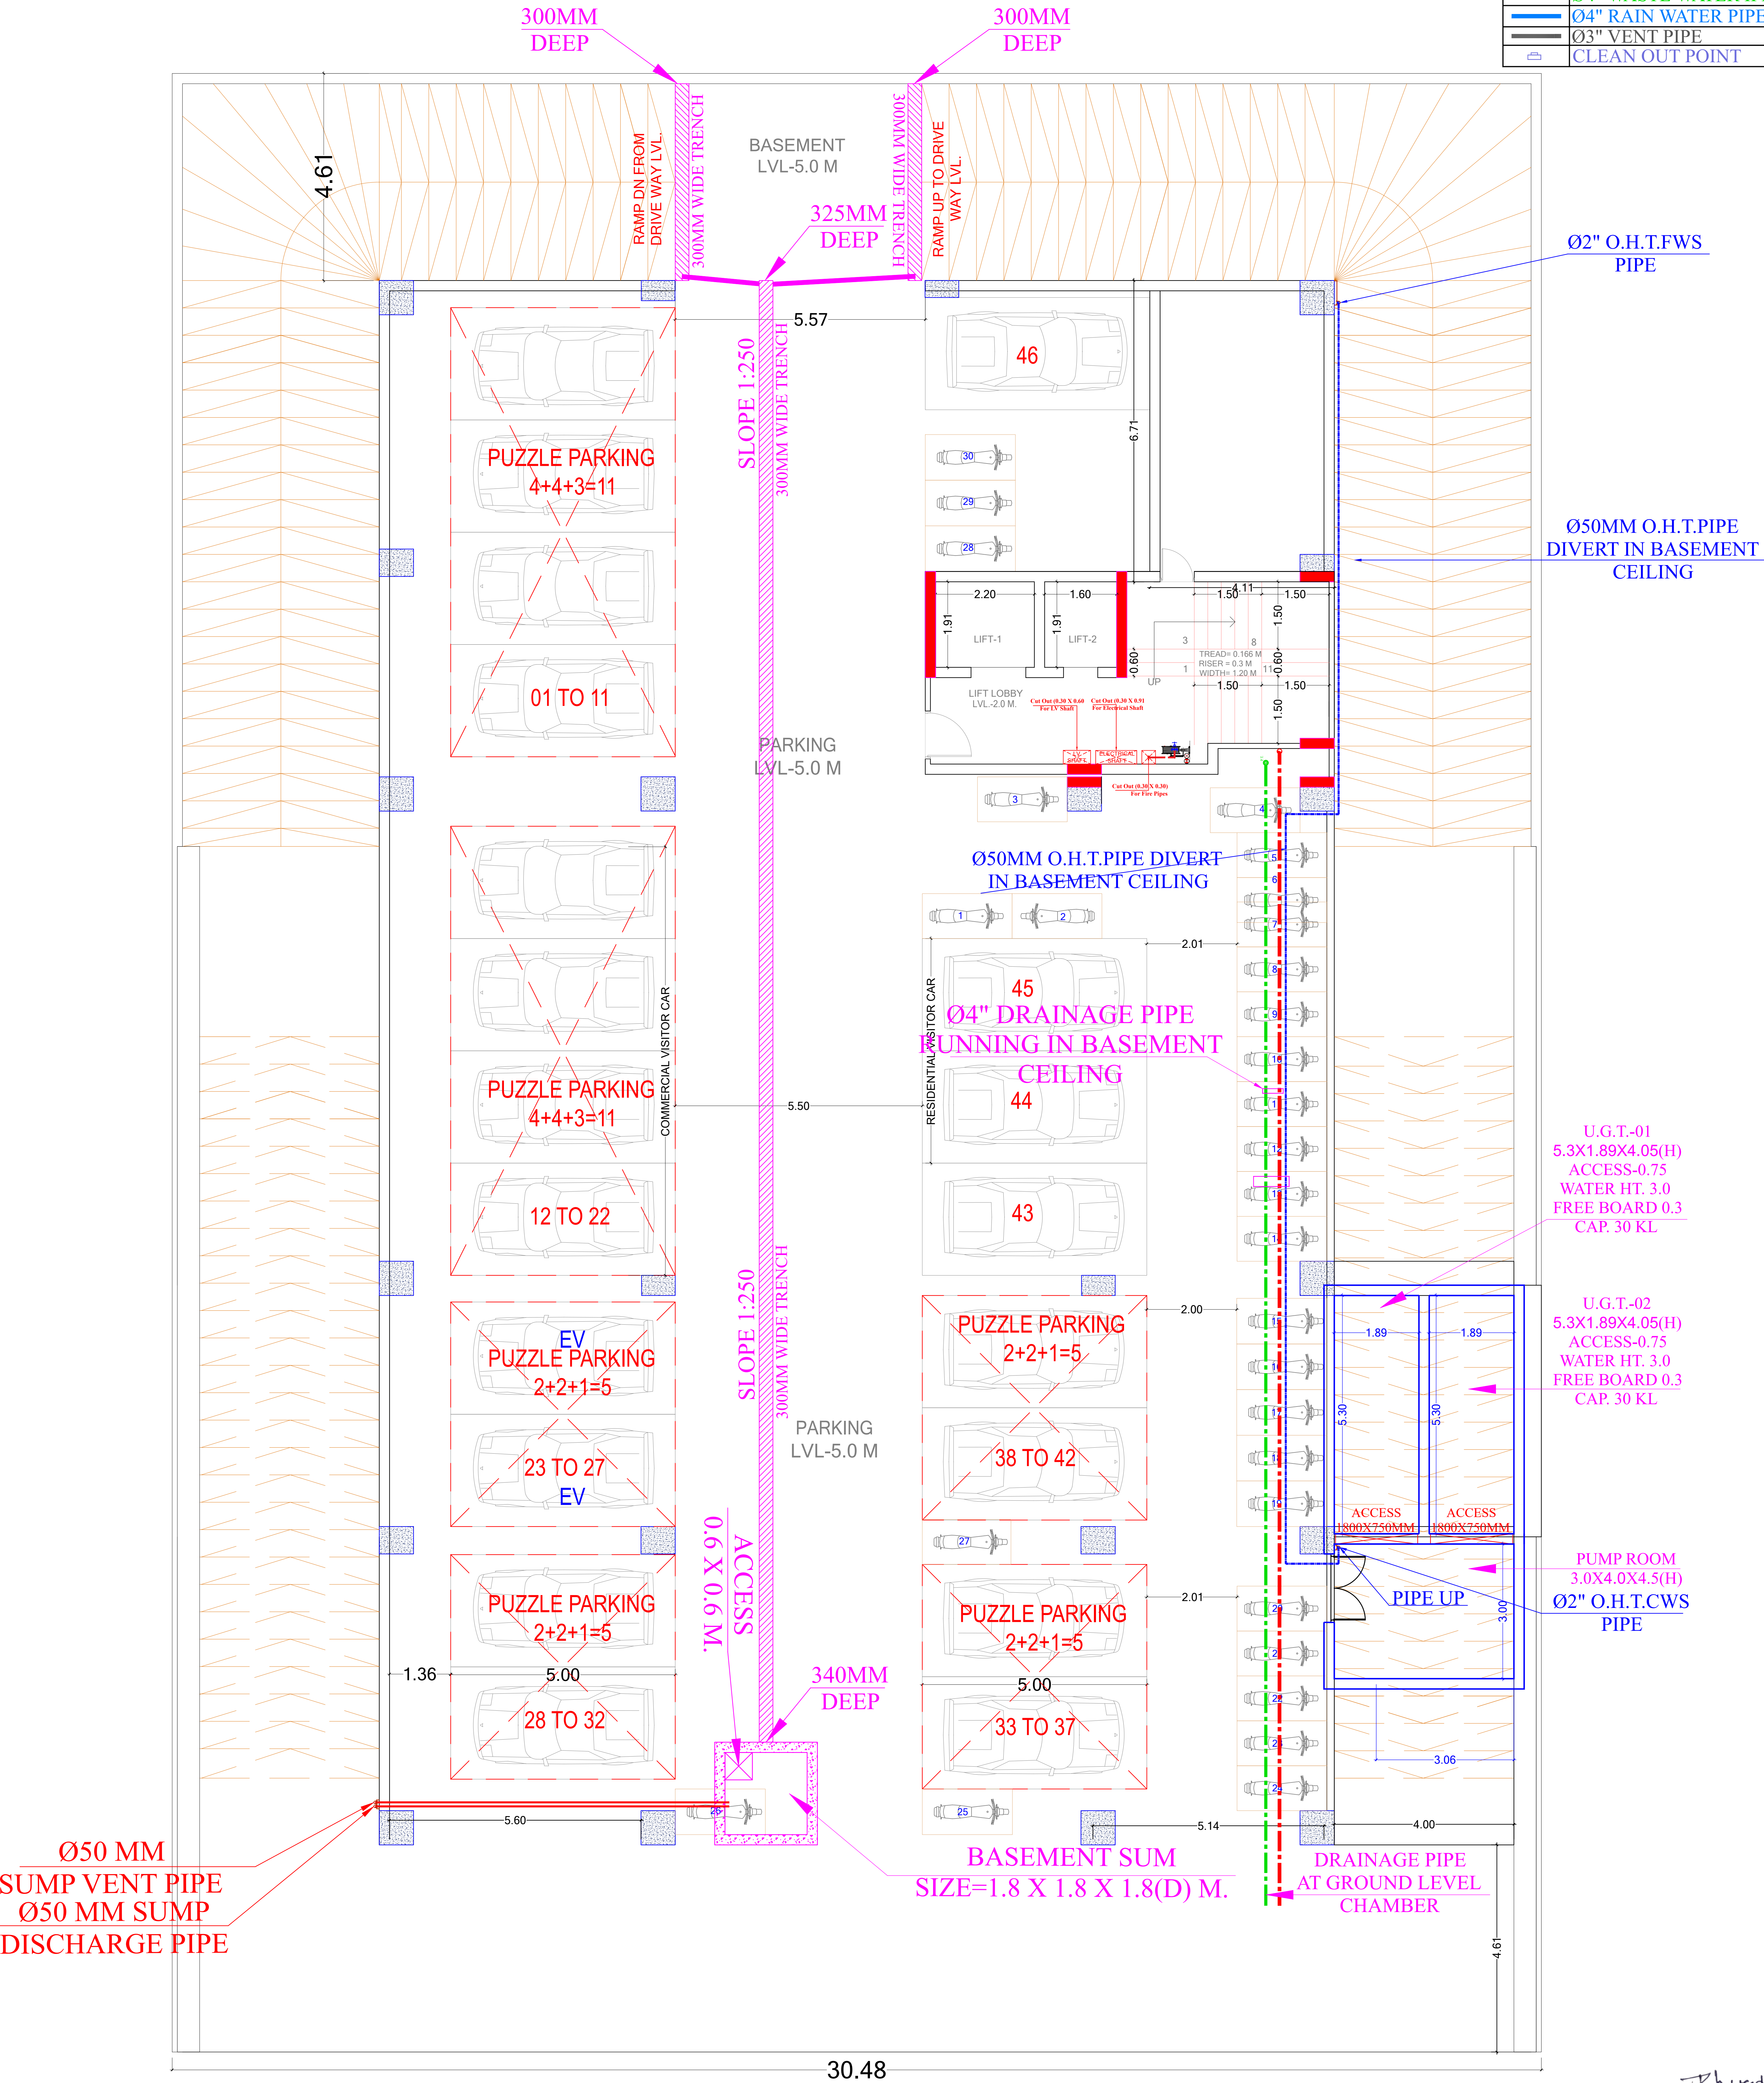

BASEMENT FLOOR PLAN

Bhagawan
BHANWAR LAL YADAV
MEP CONSULTANT
DIP. MECH. (RAC), B.TECH MECH.


REV. NO.	DESCRIPTION TO REVISION	REV. BY	DATE	ARCHITECT	STRUCTURAL CONSULTANT	CLIENT	MEP CONSULTANT	DEALT BY:	CHECKED BY:	DIRECTION:
R-00	DRAINAGE_PLAN	BABU_LAL	28.11.2025	Architect: Tushar Sogani Designs Pvt. Ltd. architects 'n' designers Studio: 400, F-72, 'Suryoday' Subhash Marg Bagadiya Bhawan, C-Scheme, Jaipur-302001 Tel:-91-141-4004560, 4004537 email:studio@tsdplarch.com; website:www.tsdplarch.com		Shubhlakshya Buildsquare LLP	 H.O.: S.R. SPORTS COMPLEX HATOI MOD, SIRSI ROAD, JAIPUR, 302012.B.O.: 401 & 402, RAGHU SAPPHIRE CENTER, CIVIL LINES, JAIPUR, 302006. Mo. No.-9571758110, 7568093164 Email: mepexconsultant@gmail.com teammepex@gmail.com	BABU LAL	AVINASH	
-	-	-	-	-	-	PROJECT NAME				
-	-	-	-	-	-	STM MARKET				
-	-	-	-	-	-	PROJECT ADDRESS				
-	-	-	-	-	-	STM Market				
-	-	-	-	-	-	10/228, Nagar Nigam Road,				
-	-	-	-	-	-	Near Girls School, Sanganer,				
-	-	-	-	-	-	Jaipur-302029, Rajasthan				
-	-	-	-	-	-					
-	-	-	-	-	-					
-										

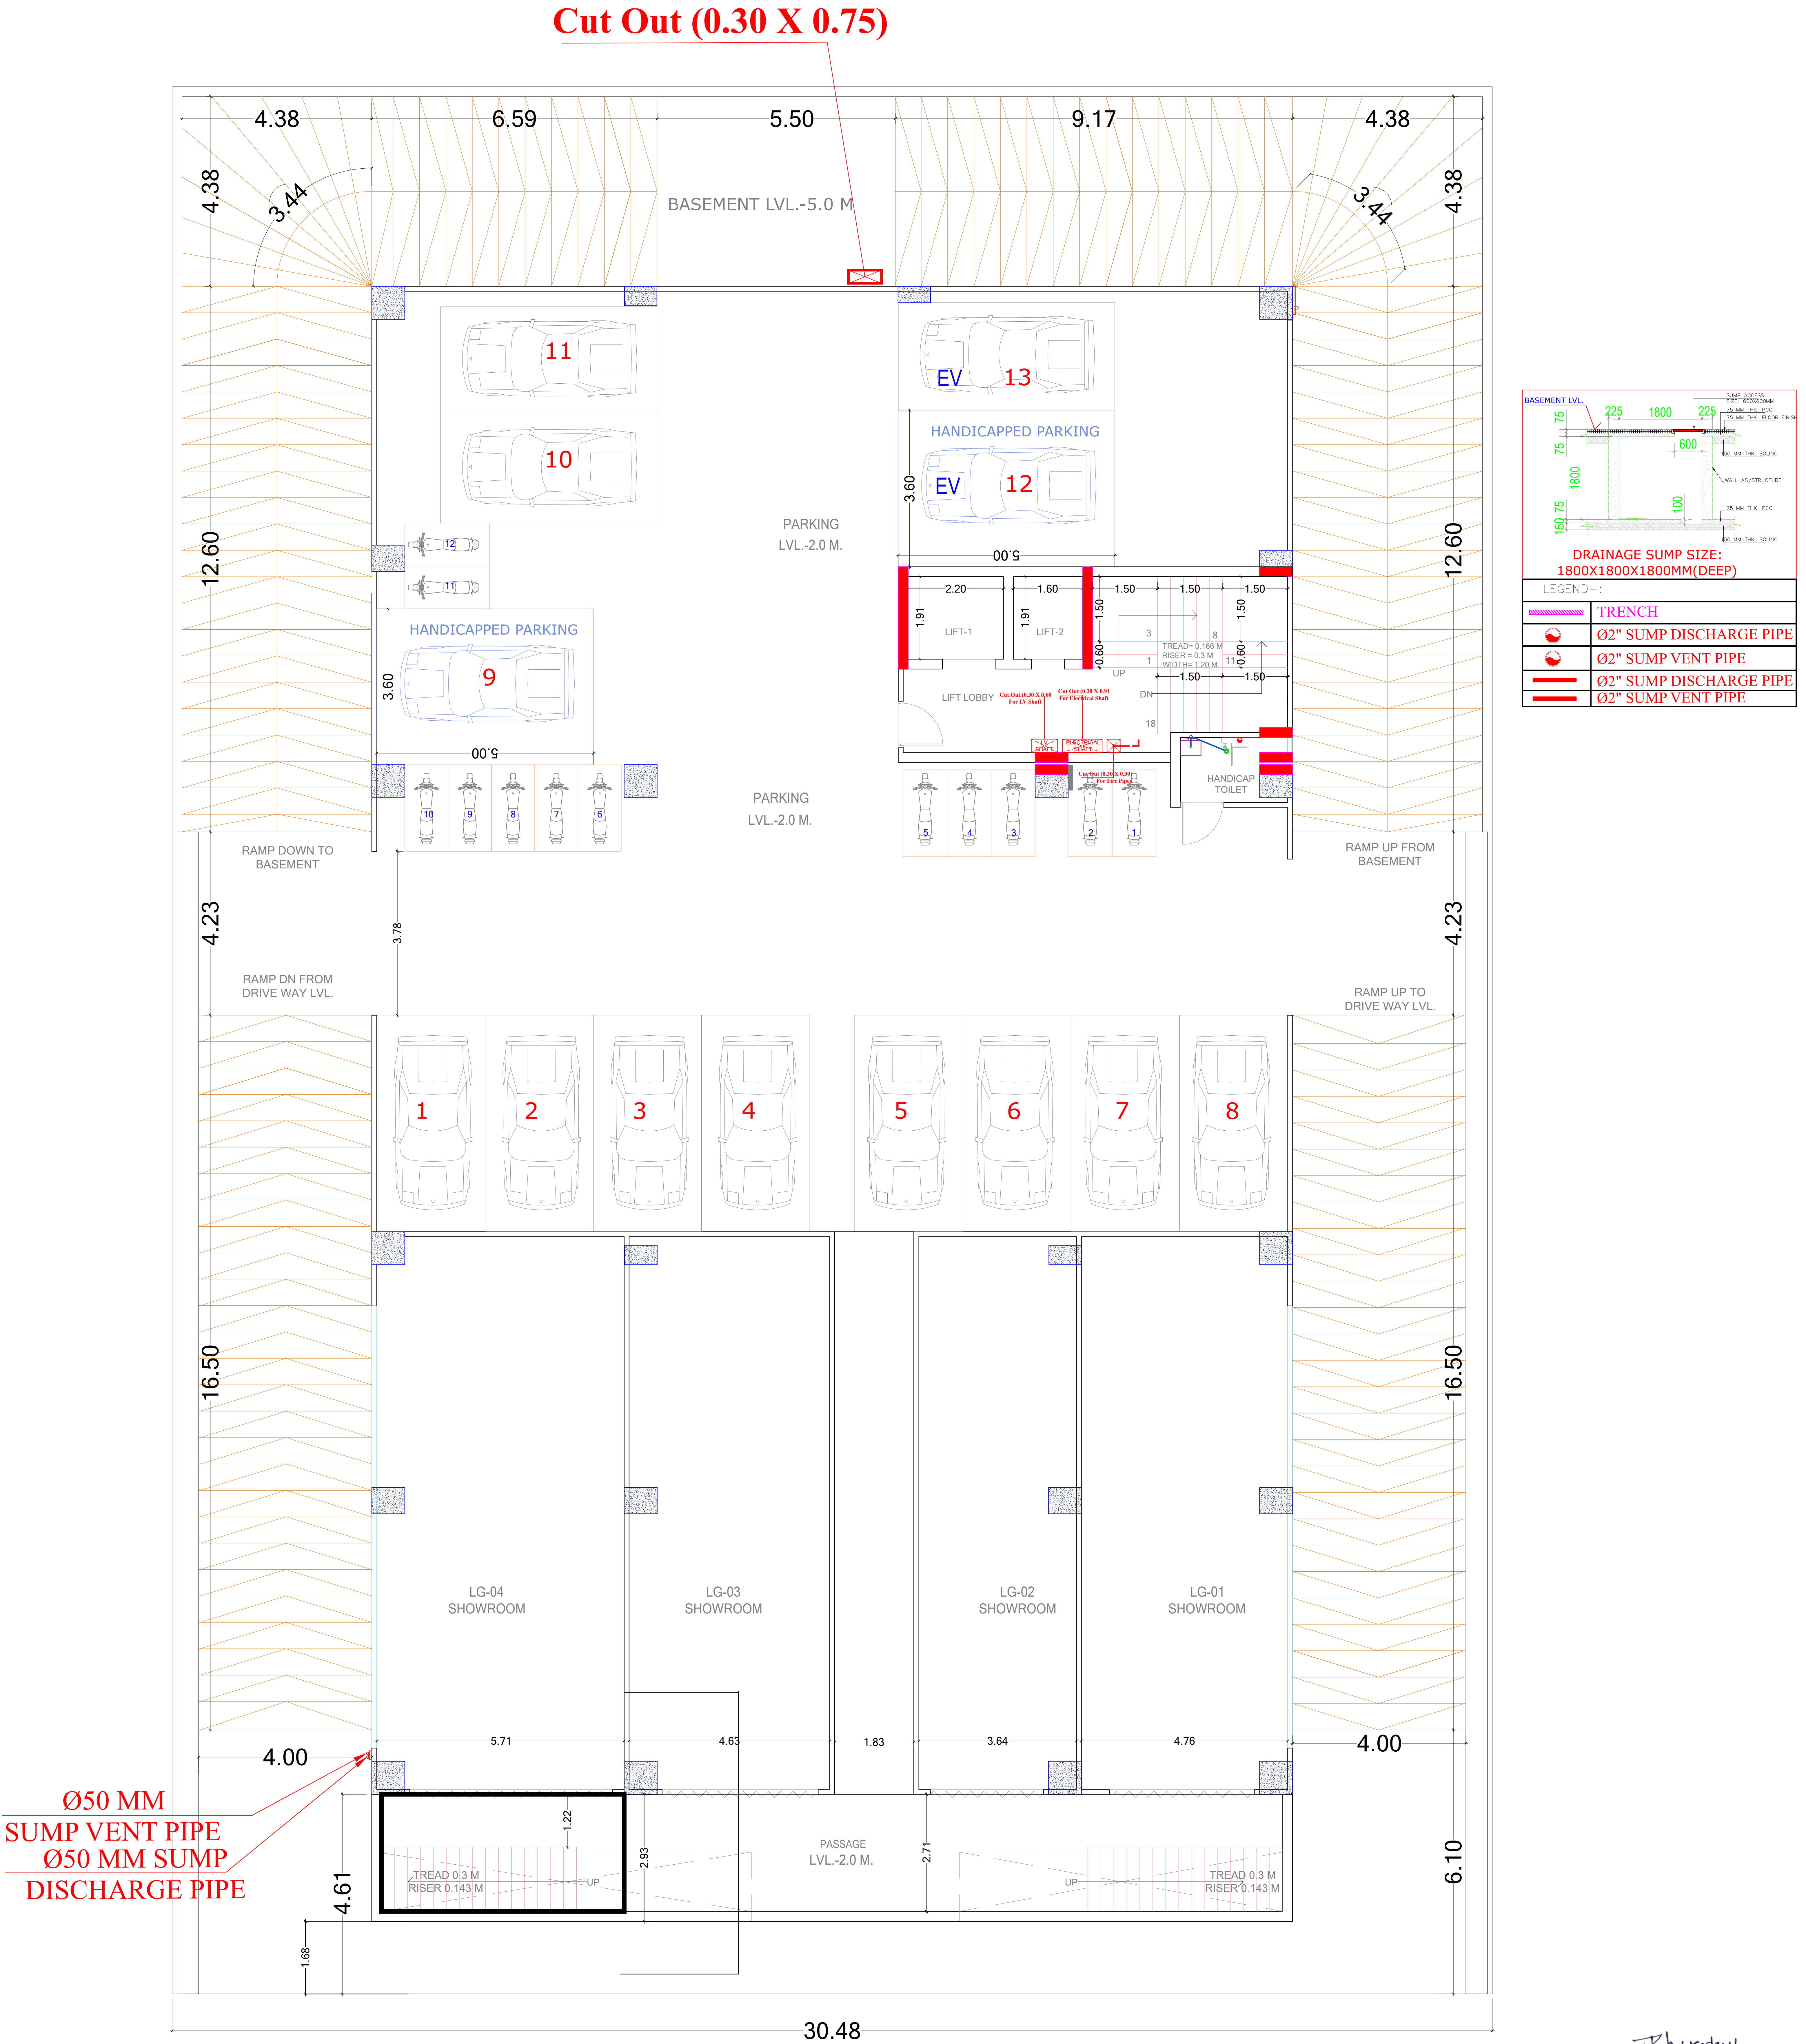


LOWER GROUND FLOOR PLAN

Bhavadan
BHANWAR LAL YADAV
MEP CONSULTANT
DIP. MECH. (RAC), B.TECH MECH.

REV. NO.		DESCRIPTION TO REVISION		REV. BY	DATE
R-00	DRAINAGE_PLAN			BABU_LAL	28.11.2025
-	-	-	-	-	-
-	-	-	-	-	-
-	-	-	-		

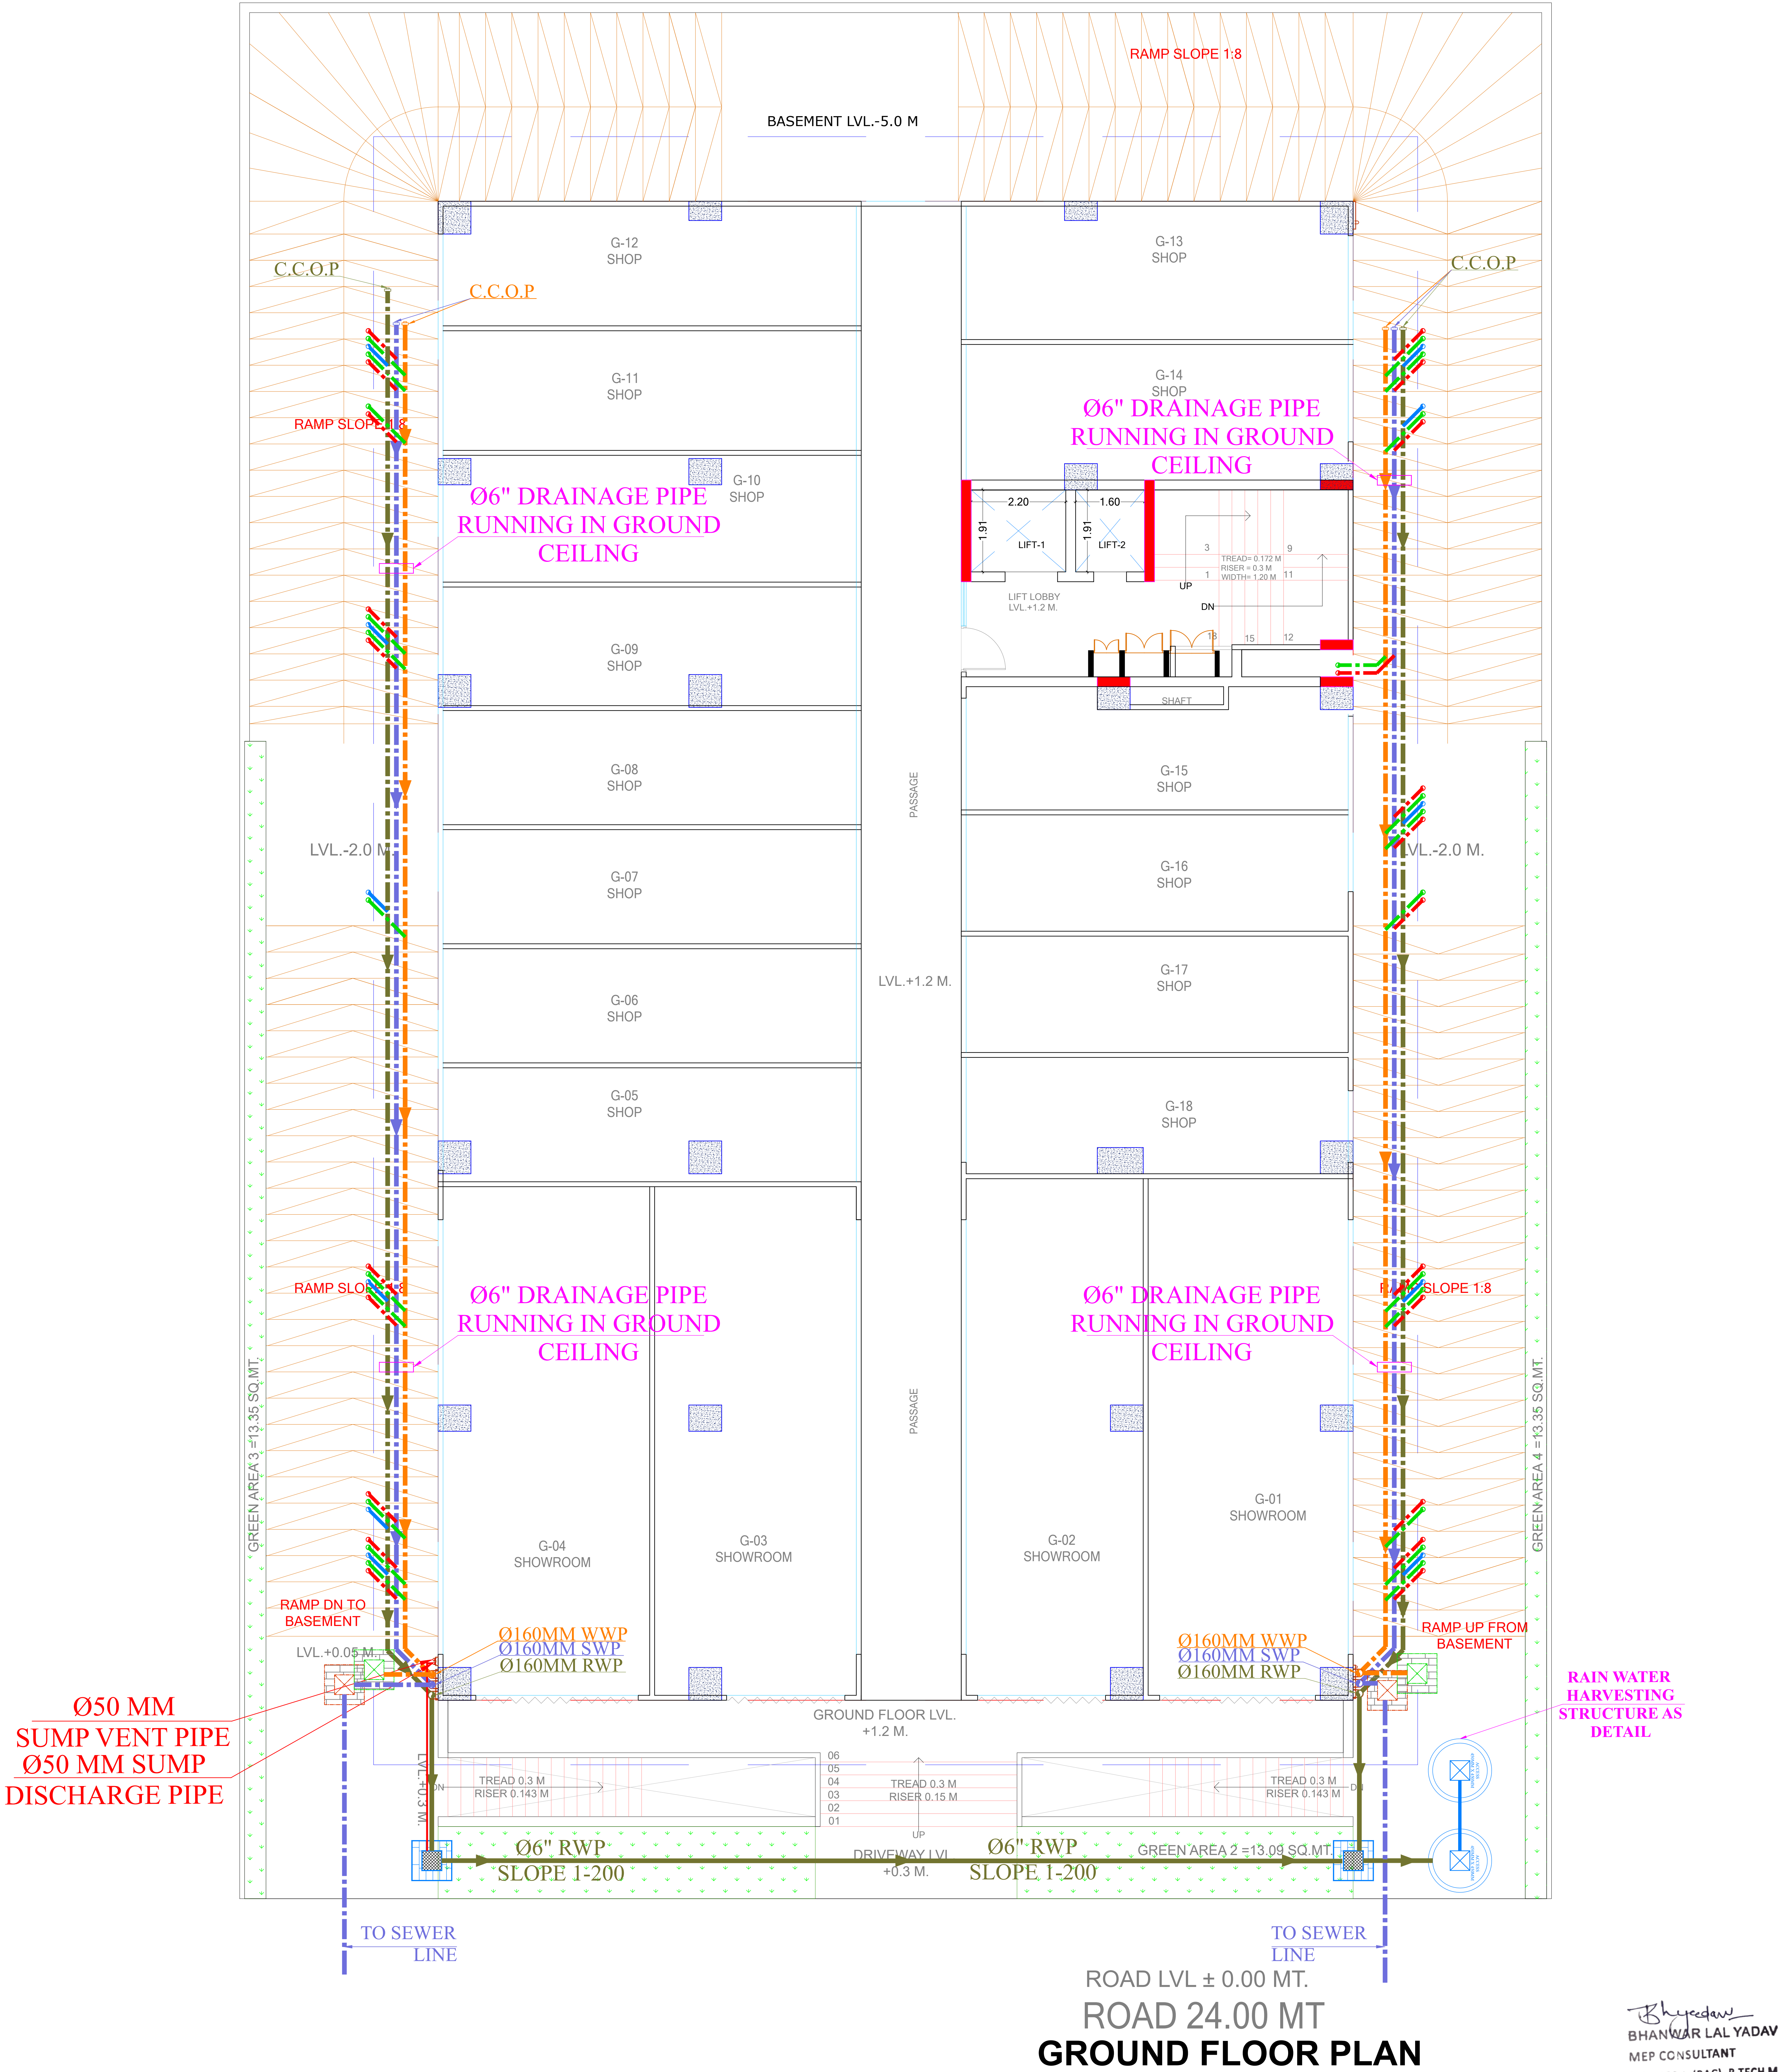

REV. NO.	DESCRIPTION TO REVISION	REV. BY	DATE	ARCHITECT	STRUCTURAL CONSULTANT	CLIENT	ENGINEER	MEP CONSULTANT	DEALT BY:	CHECKED BY:	DIRECTION:	
R-00	DRAINAGE_PLAN	BABU_LAL	28.11.2025	Architect: Tushar Sogani Designs Pvt. Ltd. architects 'n' designers Studio: 400, F-72, "Suryoday" Subhash Marg Bagadaya Bhawan, C-Scheme, Jaipur-302001 Tel:+91-141-4004560, 4004537 email:studio@tsdplarch.com; website:www.tsdplarch.com		Shubhlakshya Buildsquare LLP PROJECT NAME STM MARKET PROJECT ADDRESS STM Market 10/228, Nagar Nigam Road, Near Girls School, Sanganer, Jaipur-302029, Rajasthan	GROUND FLOOR DRAINAGE & RAIN WATER HARVESTING PLAN WORKS/STAMP	 H.O.: S.R. SPORTS COMPLEX HATOLI MOD, SIRSI ROAD, JAIPUR, 302012.B.O.: 401 & 402, RAGHU SAPPHIRE CENTER, CIVIL LINES, JAIPUR, 302006. Mo. No.-9571758110, 7568093164 Email: mepexconsultant@gmail.com teammepex@gmail.com	BABU LAL	AVINASH	 N	
							FOR_RERA_SUBMISSION		DRAWN NO.: MPX/JAP/SHGR/GRF-DR/R-01	SCALE: NTS		SHEET SIZE: A1

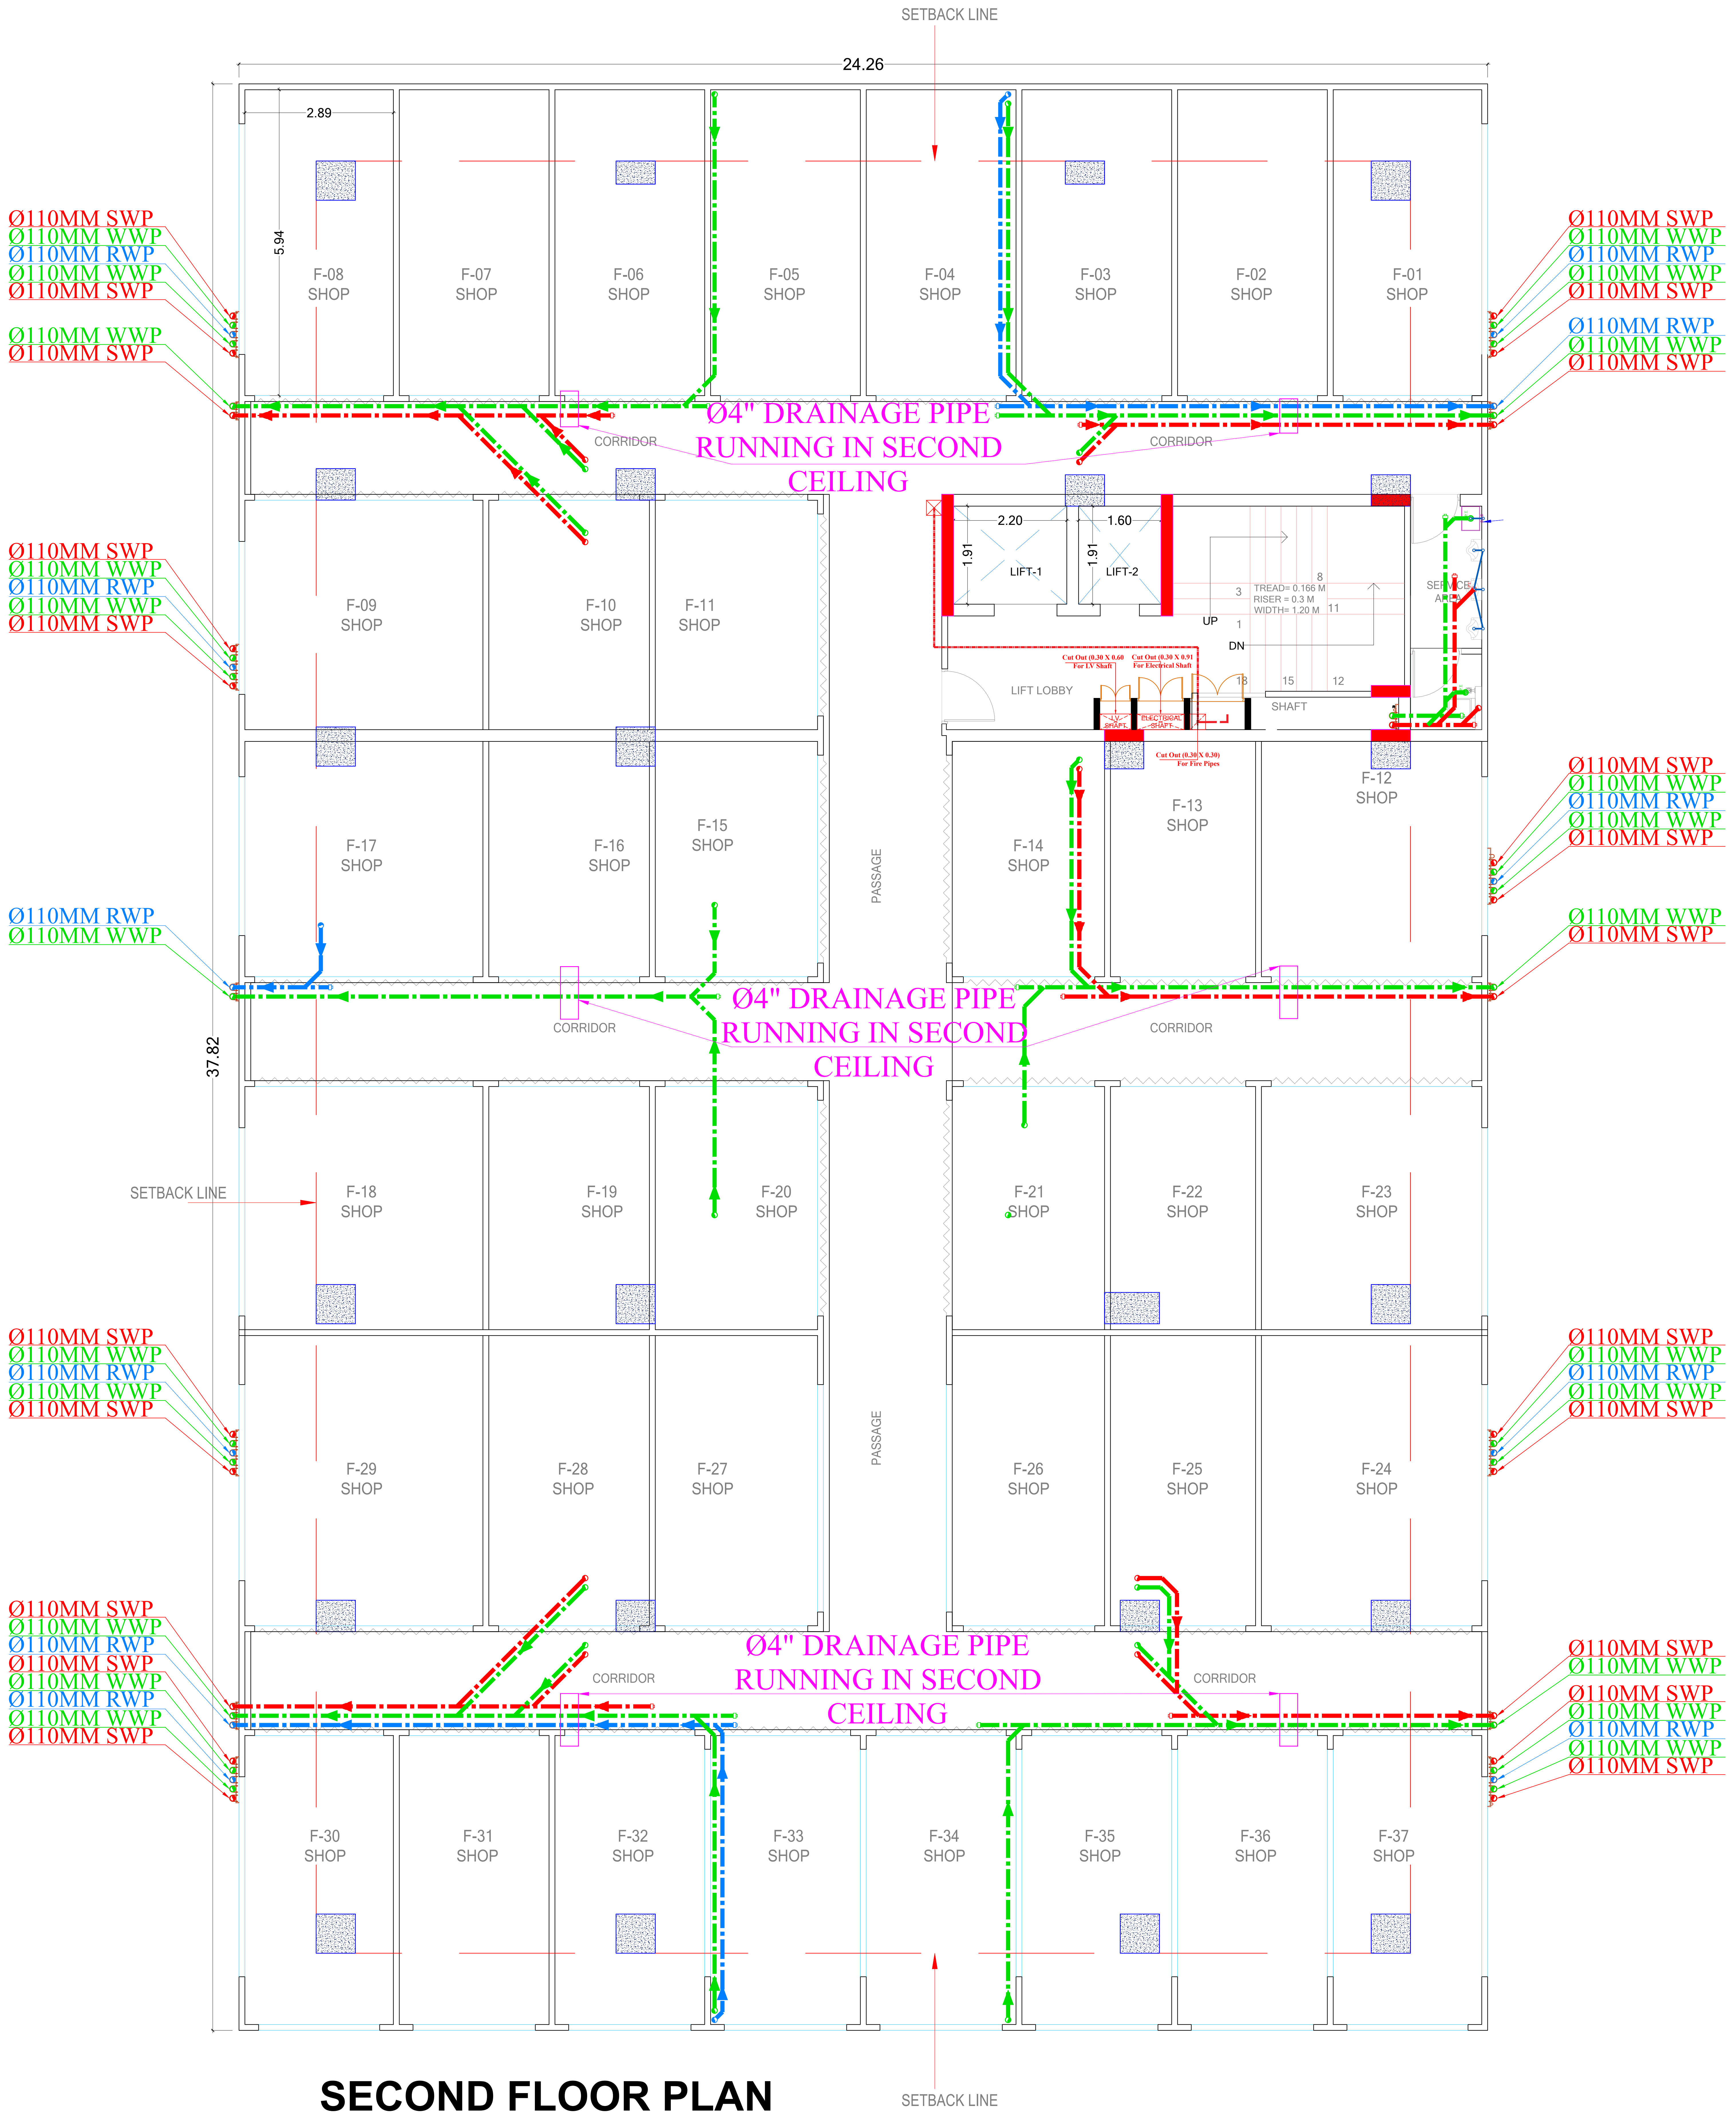

SECOND FLOOR PLAN

Bhupendra
BHANWAR LAL YADAV
MEP CONSULTANT
DIP. MECH. (RAC), B.TECH MECH.

REV. NO.	DESCRIPTION TO REVISION	REV. BY	DATE	ARCHITECT	STRUCTURAL CONSULTANT	CLIENT	MEP ENGINEER	MEP CONSULTANT	DEALT BY:	CHECKED BY:	DIRECTION:	
R-00	DRAINAGE_PLAN	BABU_LAL	28.11.2025	Architect: Tushar Sogani Designs Pvt. Ltd. architects 'n' designers Studio: 400, F-72, 'Suryodaya' Subhash Marg Bagadiya Bhawan, C-Scheme, Jaipur-302001 Tel:+91-141-4004560, 4004537 email:studio@tsdplarch.com; website:www.tsdplarch.com		Shubhlakshya Buildsquare LLP PROJECT NAME STM MARKET PROJECT ADDRESS STM Market 10/228, Nagar Nigam Road, Near Girls School, Sanganer, Jaipur-302029, Rajasthan	SECOND FLOOR DRAINAGE PLAN WORKS/STAMP	 H.O.: S.R. SPORTS COMPLEX HATOJ MOD, SIRSI ROAD, JAIPUR, 302012.B.O.: 401 & 402, RAGHU SAPPHIRE CENTER, CIVIL LINES, JAIPUR, 302006. Mo. No.-9571758110, 7568093164 Email: mepexconsultant@gmail.com teammepex@gmail.com	BABU LAL	AVINASH		
							FOR_RERA_SUBMISSION		DRAWN NO.: MPX/JAP/SHGR-SF-DR/R-01	SCALE: NTS		SHEET SIZE: A1

