



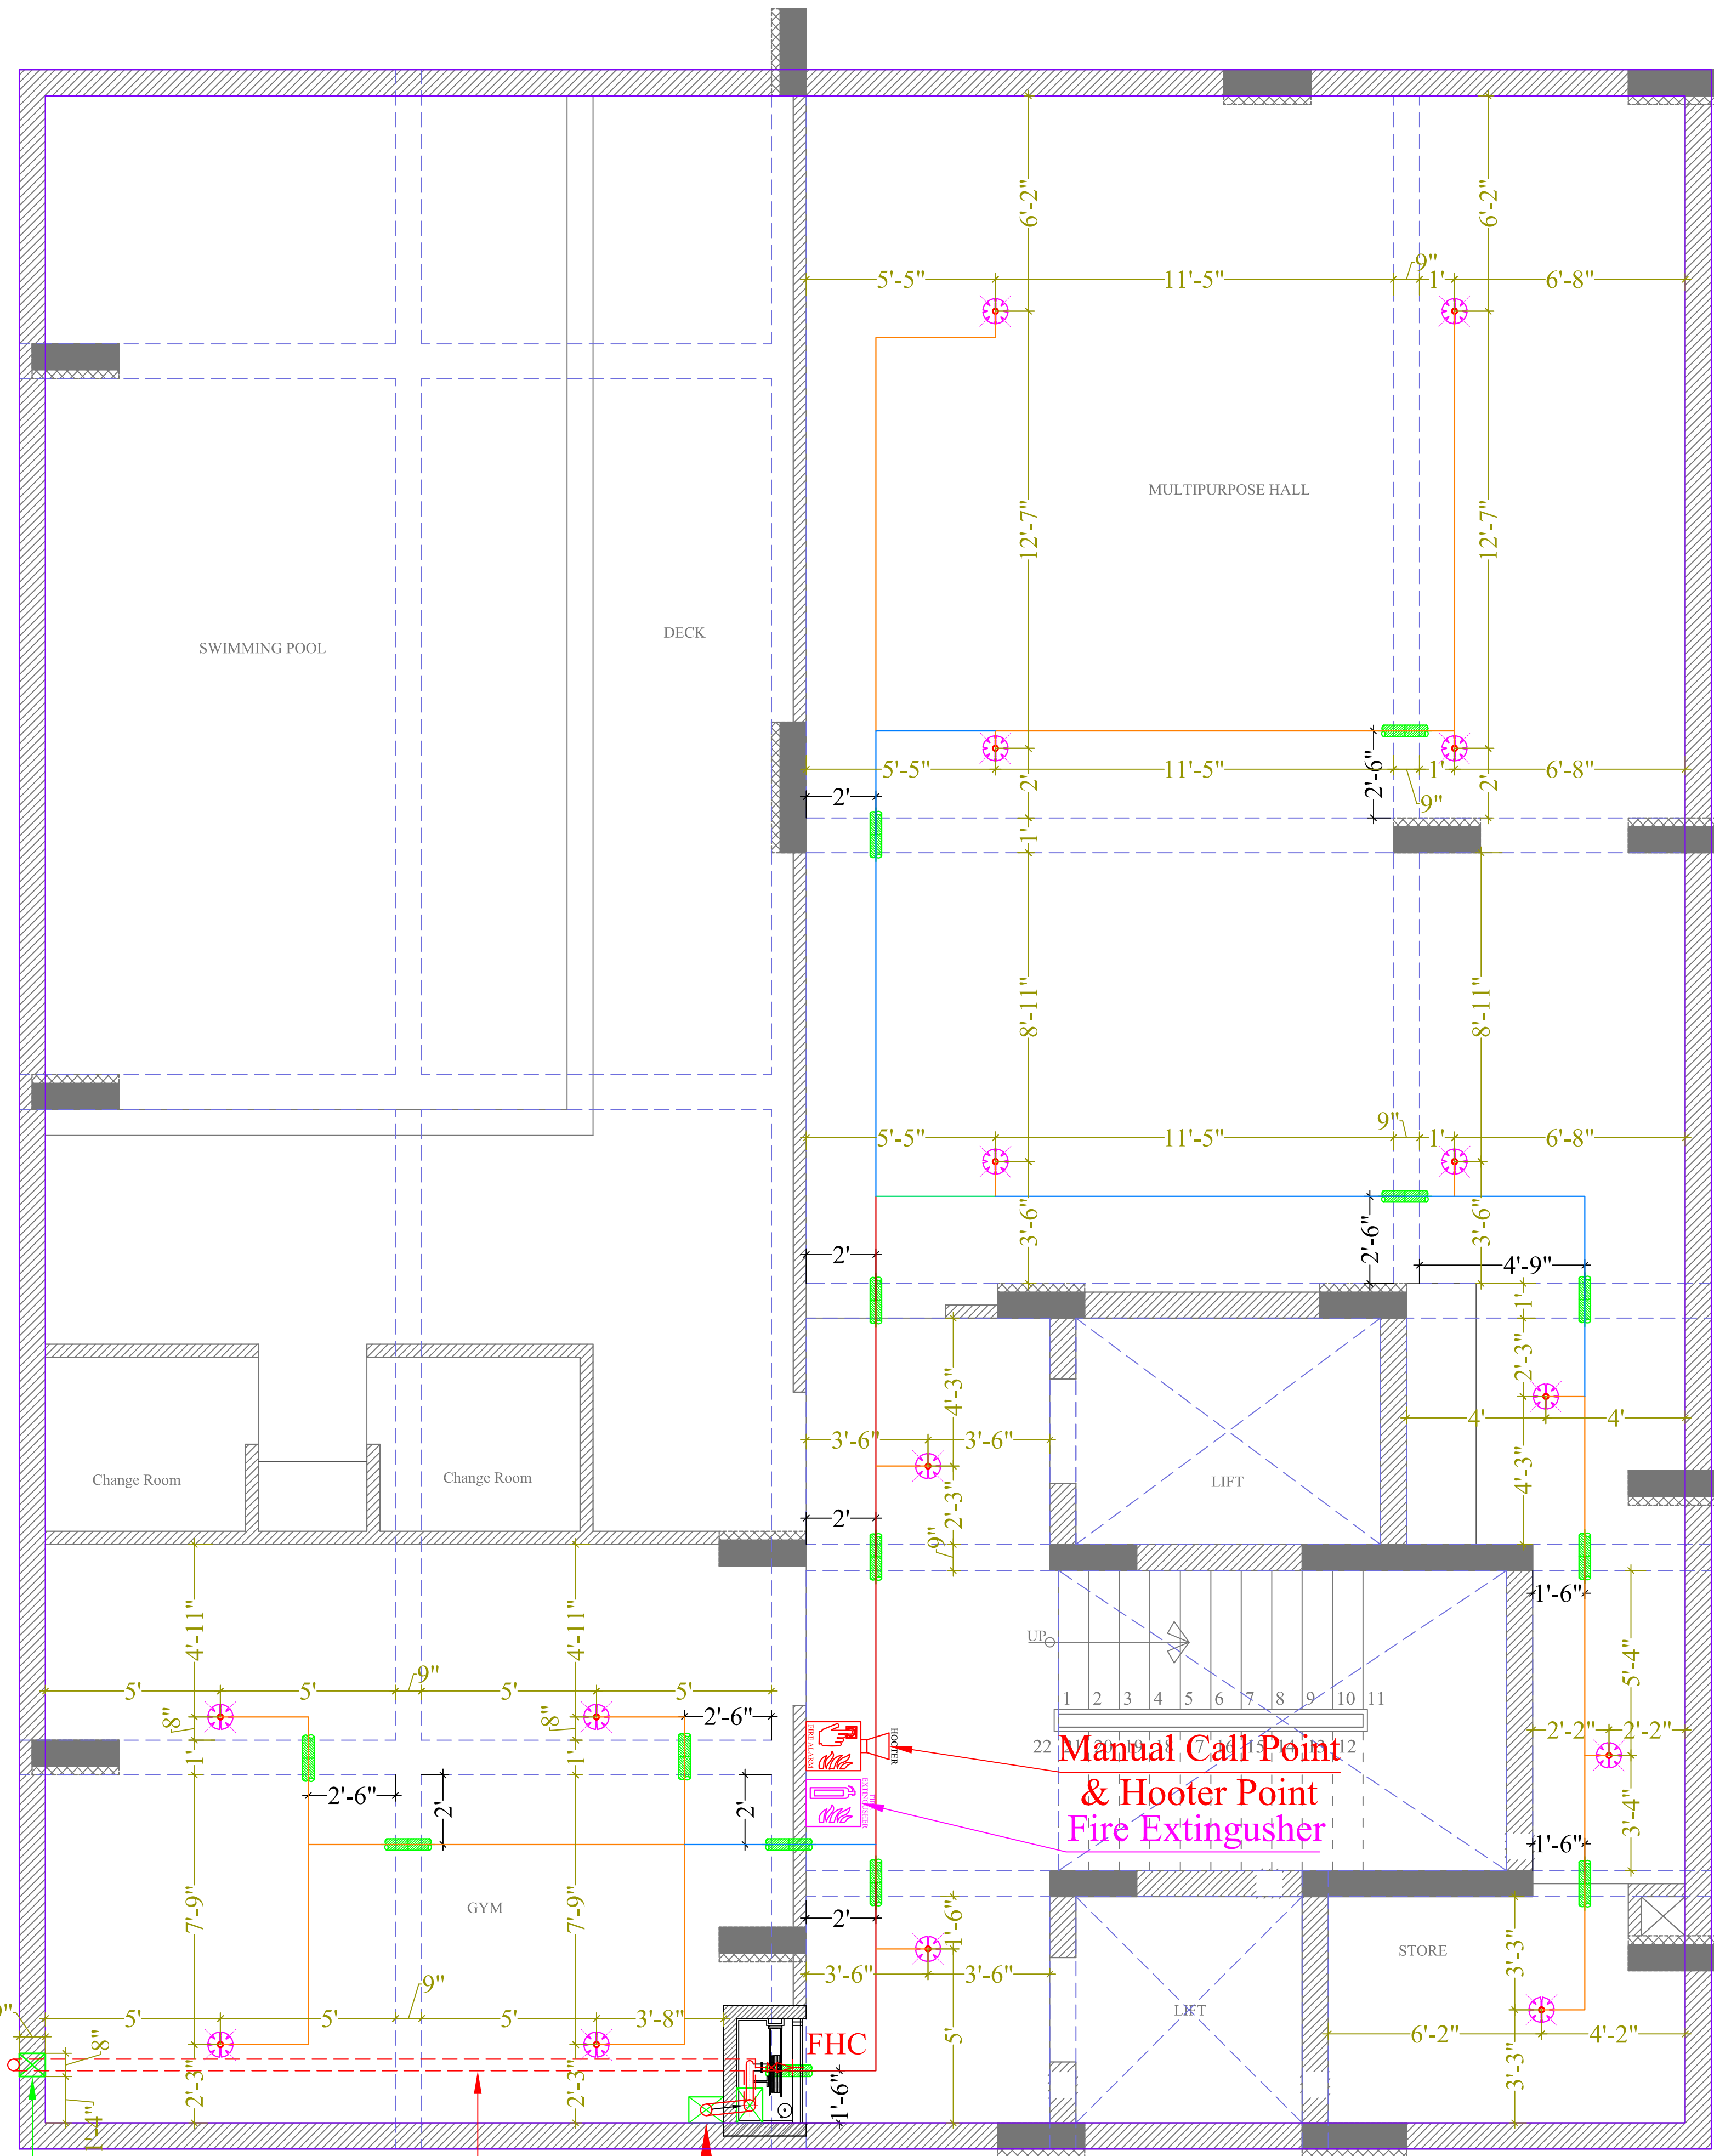

8" X 8" Cut in Basement Retaining Wall For External Fire Hydrant Pipe

Basement Ceiling Suspended 100ØMS Fire Pipe For External Fire Hydrants

12"X9" Cut in Basement Roof For Upper Floor FHC

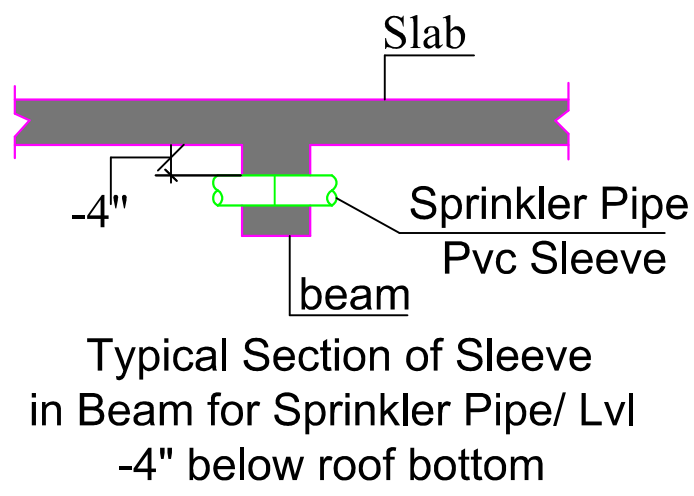

LEGENDS:			
Mounting Ht.	Qty.	Symbol	Description
IN BEAM	14		100MM DIA. PVC SLEEVE FOR SPRINKLER PIPING -4" BELOW ROOF BOTTOM LVL

VIPUL AGARWAL
M.E.P. CONSULTANT
B.E. ELECTRICAL

LEGENDS:			
Mounting Ht.	Qty.	Symbol	Description
CEILING	15		PENDANT SPRINKLER
CEILING	32mtr		25 MM DIA. MS PIPE
CEILING	14mtr		32 MM DIA. MS PIPE
CEILING	01mtr		40 MM DIA. MS PIPE
CEILING	09mtr		50 MM DIA. MS PIPE
	01		CONTROL VALVE

LEGENDS:		
No.	Symbol	Description
01		FIRE EXTINGUISHER
01		MANUAL CALL POINT
01		HOOTER POINT
01		FIRE HOSE CABINET

SERVICES CONSULTANT:
ASHI ASSOCIATES
F 9 / 440 , Keshav Marg Chitrakut Scheme,Jaipur
PH-91-0-93146-10438 ,0141-2440946 Mail:vipul8599@yahoo.com

ARCHITECTS:-
SPACE GRID
C-49, VIDYA APARTMENT, PARAS MARG, BAPU NAGAR, NEAR JANTA STORE CIRCLE, JAIPUR-302015
PH-09314918766,0141-4005506 (O)
Email:-info.spacegrid@gmail.com

PROMOTER:-
ASHISH GUPTA

PROJECT NAME:-
THE MANSION BY AVENUE


PROJECT ADDRESS:-
KHASRA NO- 2533/760, 2536/2479 ,IN VILLAGE- SIRSI, JAIPUR

DRAWING:- BASEMENT FLOOR
FIRE SPRINKLER, MCP,
HOOTER, FIRE EXTINGUISHER
& FIRE SHAFT MARKED PLAN

DRAWN BY:-	CHKD BY:-
PAWAN	SANJAY

APPD.:-
VIPUL AGARWAL

DATE:- 17-06-2025	
REV.:- 00	
SCALE:- N.T.S.	

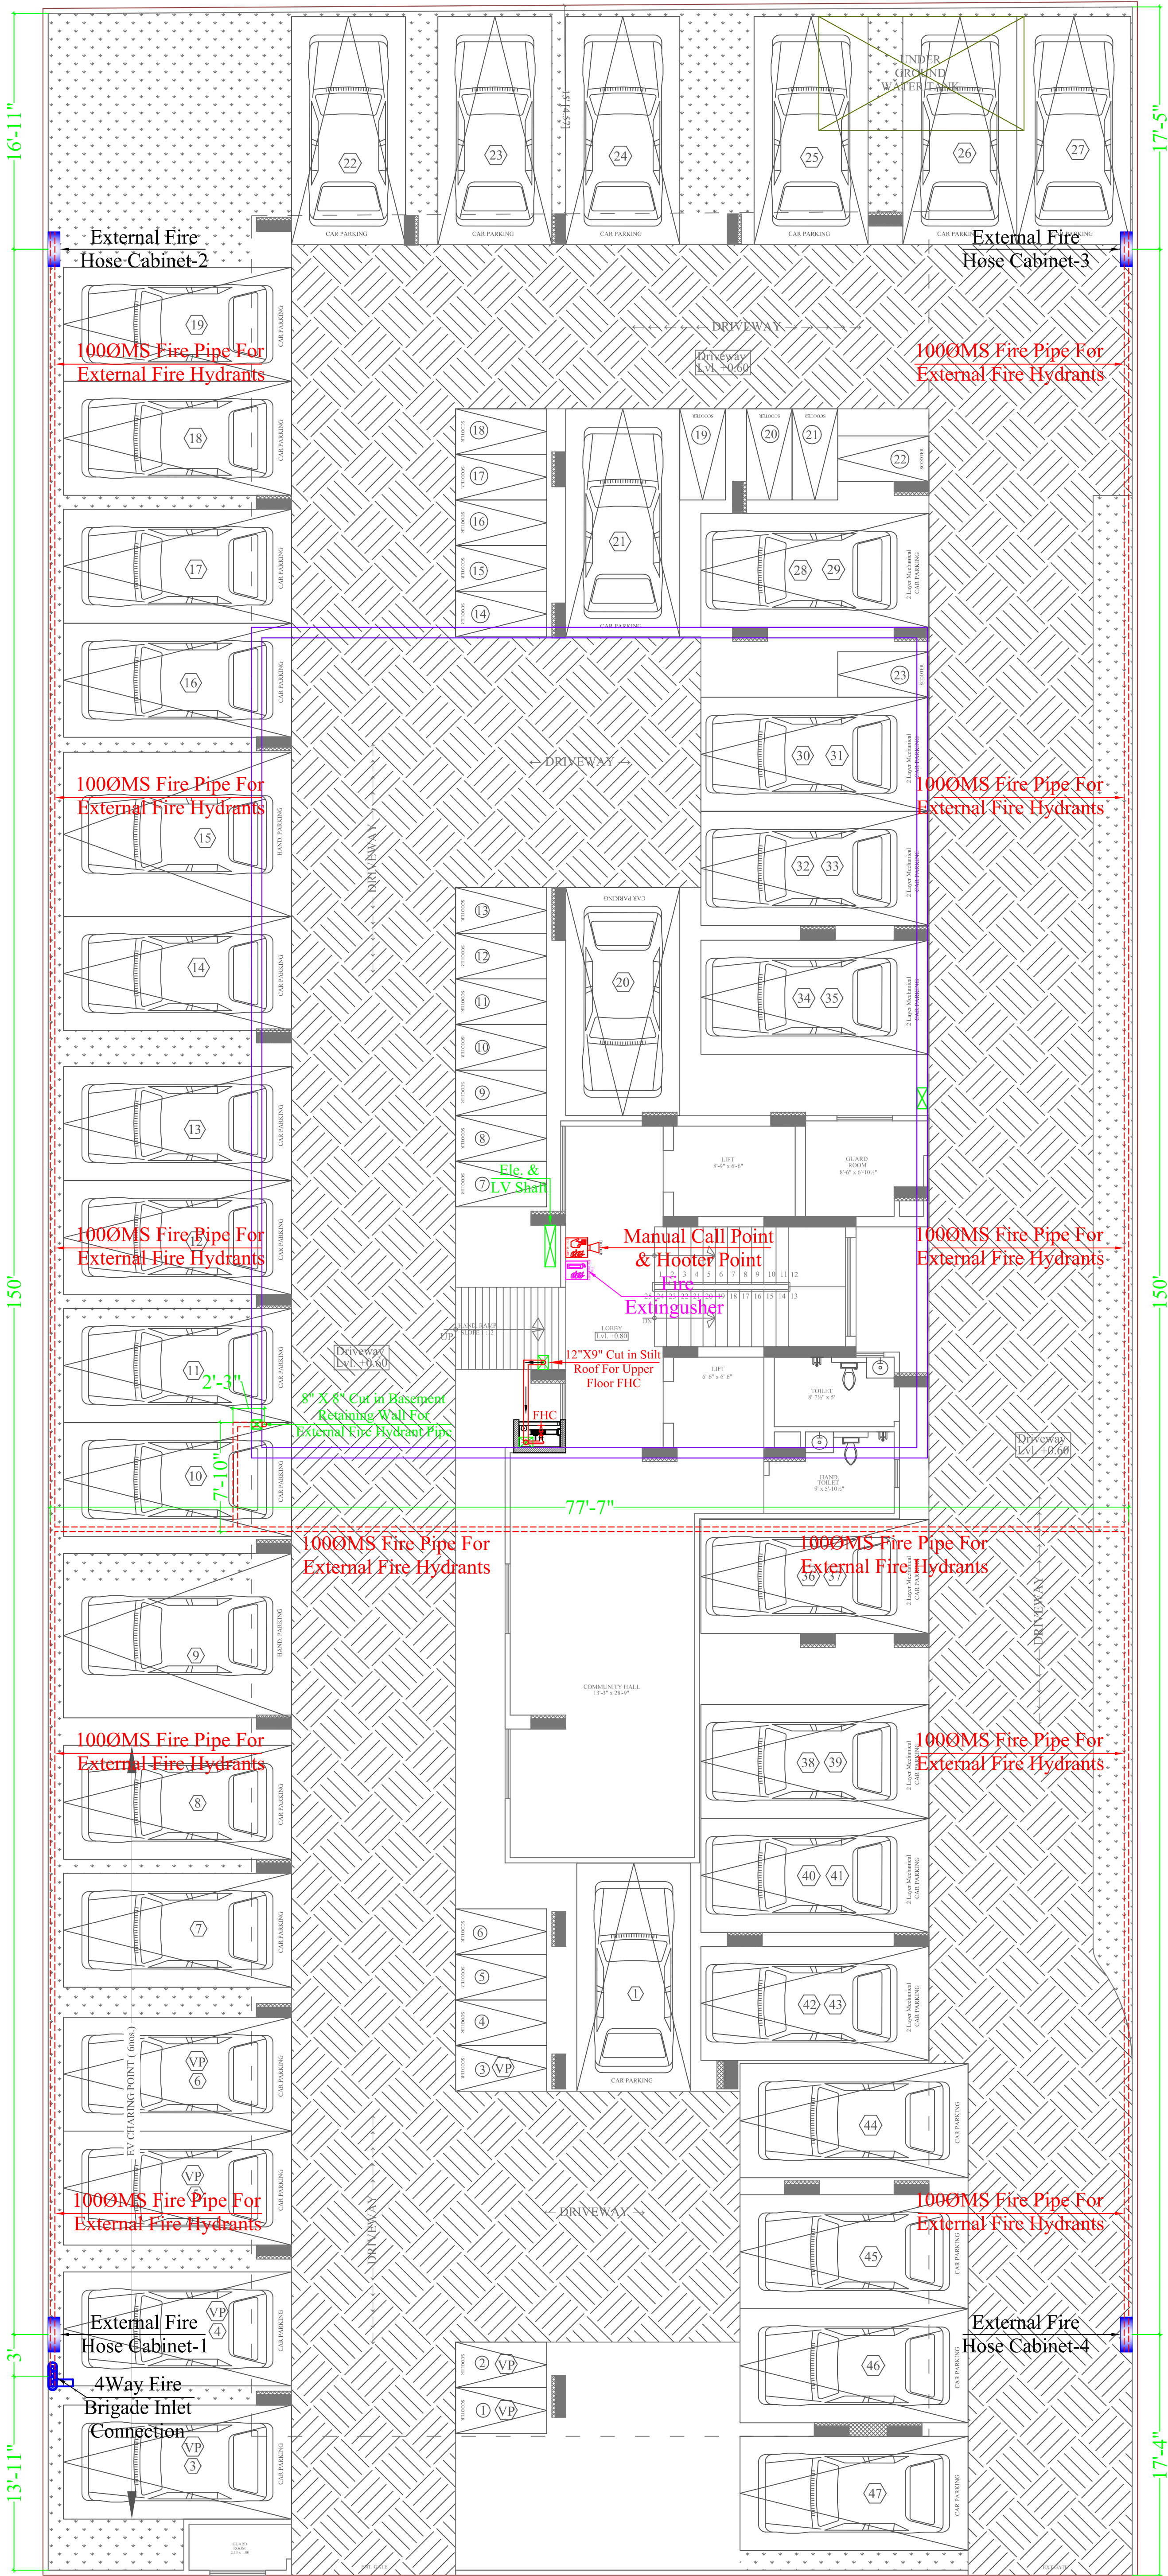

EXTERNAL FIRE HOSE CABINET
TYPICAL DETAIL

EXTERNAL FIRE HYDRANT
TYPICAL DETAIL

ELEVATION-8B

4-WAY FIRE BRIGADE INLET CONNECTION

VIPUL AGARWAL
M.E.P. CONSULTANT
B.E. ELECTRICAL

LEGENDS:

SYMBOL	QTY.	DESCRIPTION
		1000MS FIRE PIPE FOR EXTERNAL FIRE HYDRANTS
	04	EXTERNAL FIRE HOSE CABINET

LEGENDS:

No.	Symbol	Description
01		FIRE EXTINGUISHER
01		MANUAL CALL POINT
01		HOOTER POINT
01		FIRE HOSE CABINET

SERVICES CONSULTANT:
ASHI ASSOCIATES
F 9 / 440 , Keshav Marg Chitrakut Scheme,Jaipur
PH:91-0-93146-10438 ,0141-2440946 Mail:vipul8599@yahoo.com

ARCHITECTS:-
SPACE GRID
C-49, VIDYA APARTMENT, PARAS MARG, BAPU NAGAR, NEAR JANTA STORE CIRCLE, JAIPUR-302015
PH-09314918766,0141-4005506 (O)
Email:-info.spacegrid@gmail.com

PROMOTER:-
ASHISH GUPTA

PROJECT NAME:-
THE MANSION BY AVENUE

PROJECT ADDRESS:-
KHASRA NO- 2533/760, 2536/2479 ,IN VILLAGE- SIRSI, JAIPUR

DRAWING:- STILT FLOOR
MCP, HOOTER, FIRE EXTINGUISHER & FIRE SHAFT MARKED & EXTERNAL FIRE HYDRANT WITH FIRE PIPE ROUTE PLAN

DRAWN BY:-
PAWAN


CHKD BY:-
SANJAY

APPD:-
VIPUL AGARWAL

DATE:-
17-06-2025

REV.:-
00


SCALE:-
N.T.S.

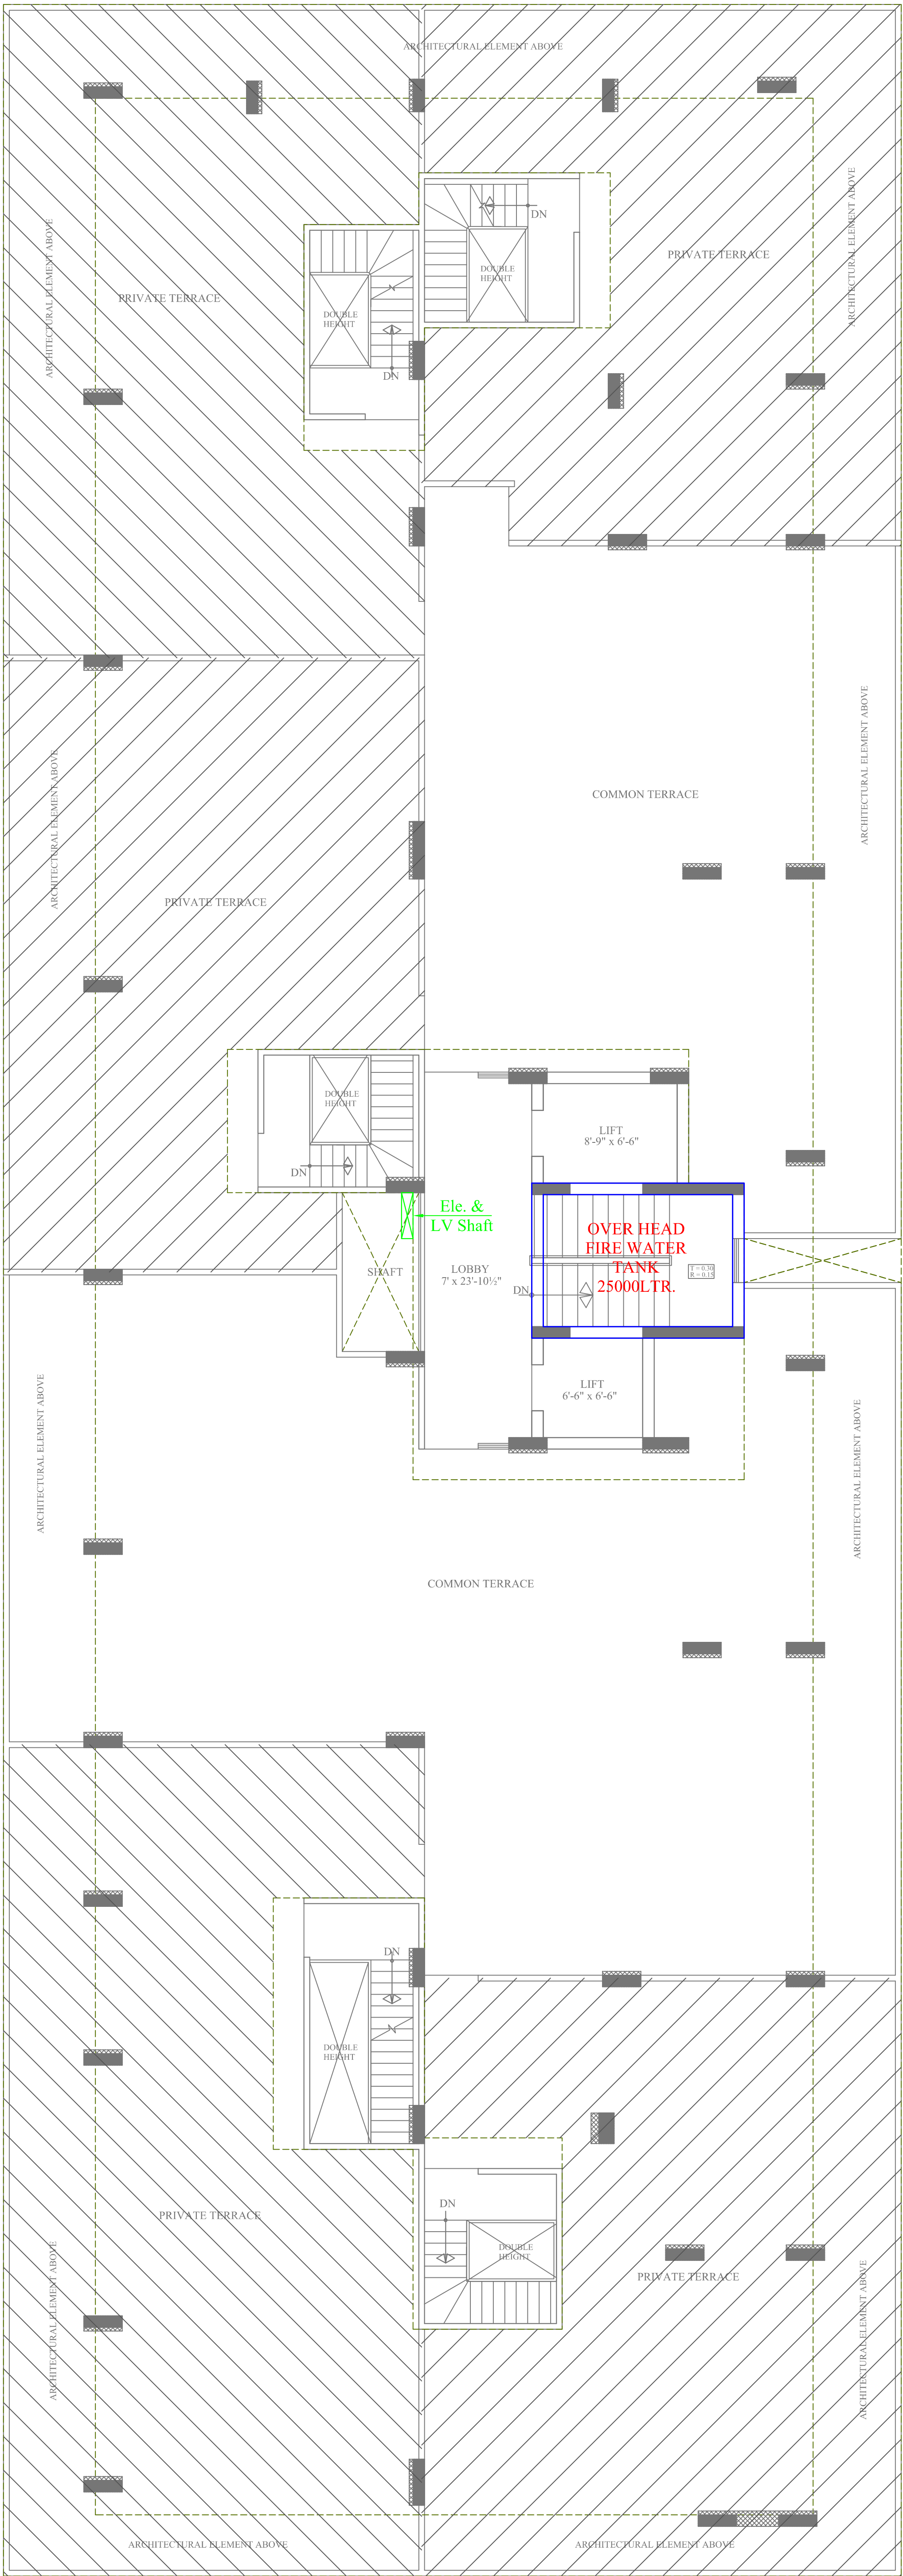

Vipul
VIPUL AGARWAL
M.E.P. CONSULTANT
B.E. ELECTRICAL

SERVICES CONSULTANT:
ASHI ASSOCIATES
F 9 / 440 , Keshav Marg Chitrakut Scheme,Jaipur
PH-91-0-93146-10438 ,0141-2440946 Mail:vipul8599@yahoo.com

 ARCHITECTS:-



SPACE GRID

C-49, VIDYA APARTMENT, PARAS
MARG, BAPU NAGAR, NEAR JANTA
STORE CIRCLE, JAIPUR-302015
PH-09314918766,0141-4005506 (O)
Email:-info.spacegrid@gmail.com

PROMOTER:-

ASHISH GUPTA

PROJECT NAME:-

THE MANSION BY AVENUE

PROJECT ADDRESS:-

**KHASRA NO- 2533/760, 2536/2479
,IN VILLAGE- SIRSI, JAIPUR**

DRAWING:-

**TERRACE FLOOR
O.H. FIRE WATER TANK
MARKED PLAN**

DRAWN BY:-

PAWAN

CHKD BY:-

SANJAY

APPD:-

VIPUL AGARWAL

DATE:-

17-06-2025


REV.:-

00

SCALE:-

N.T.S.



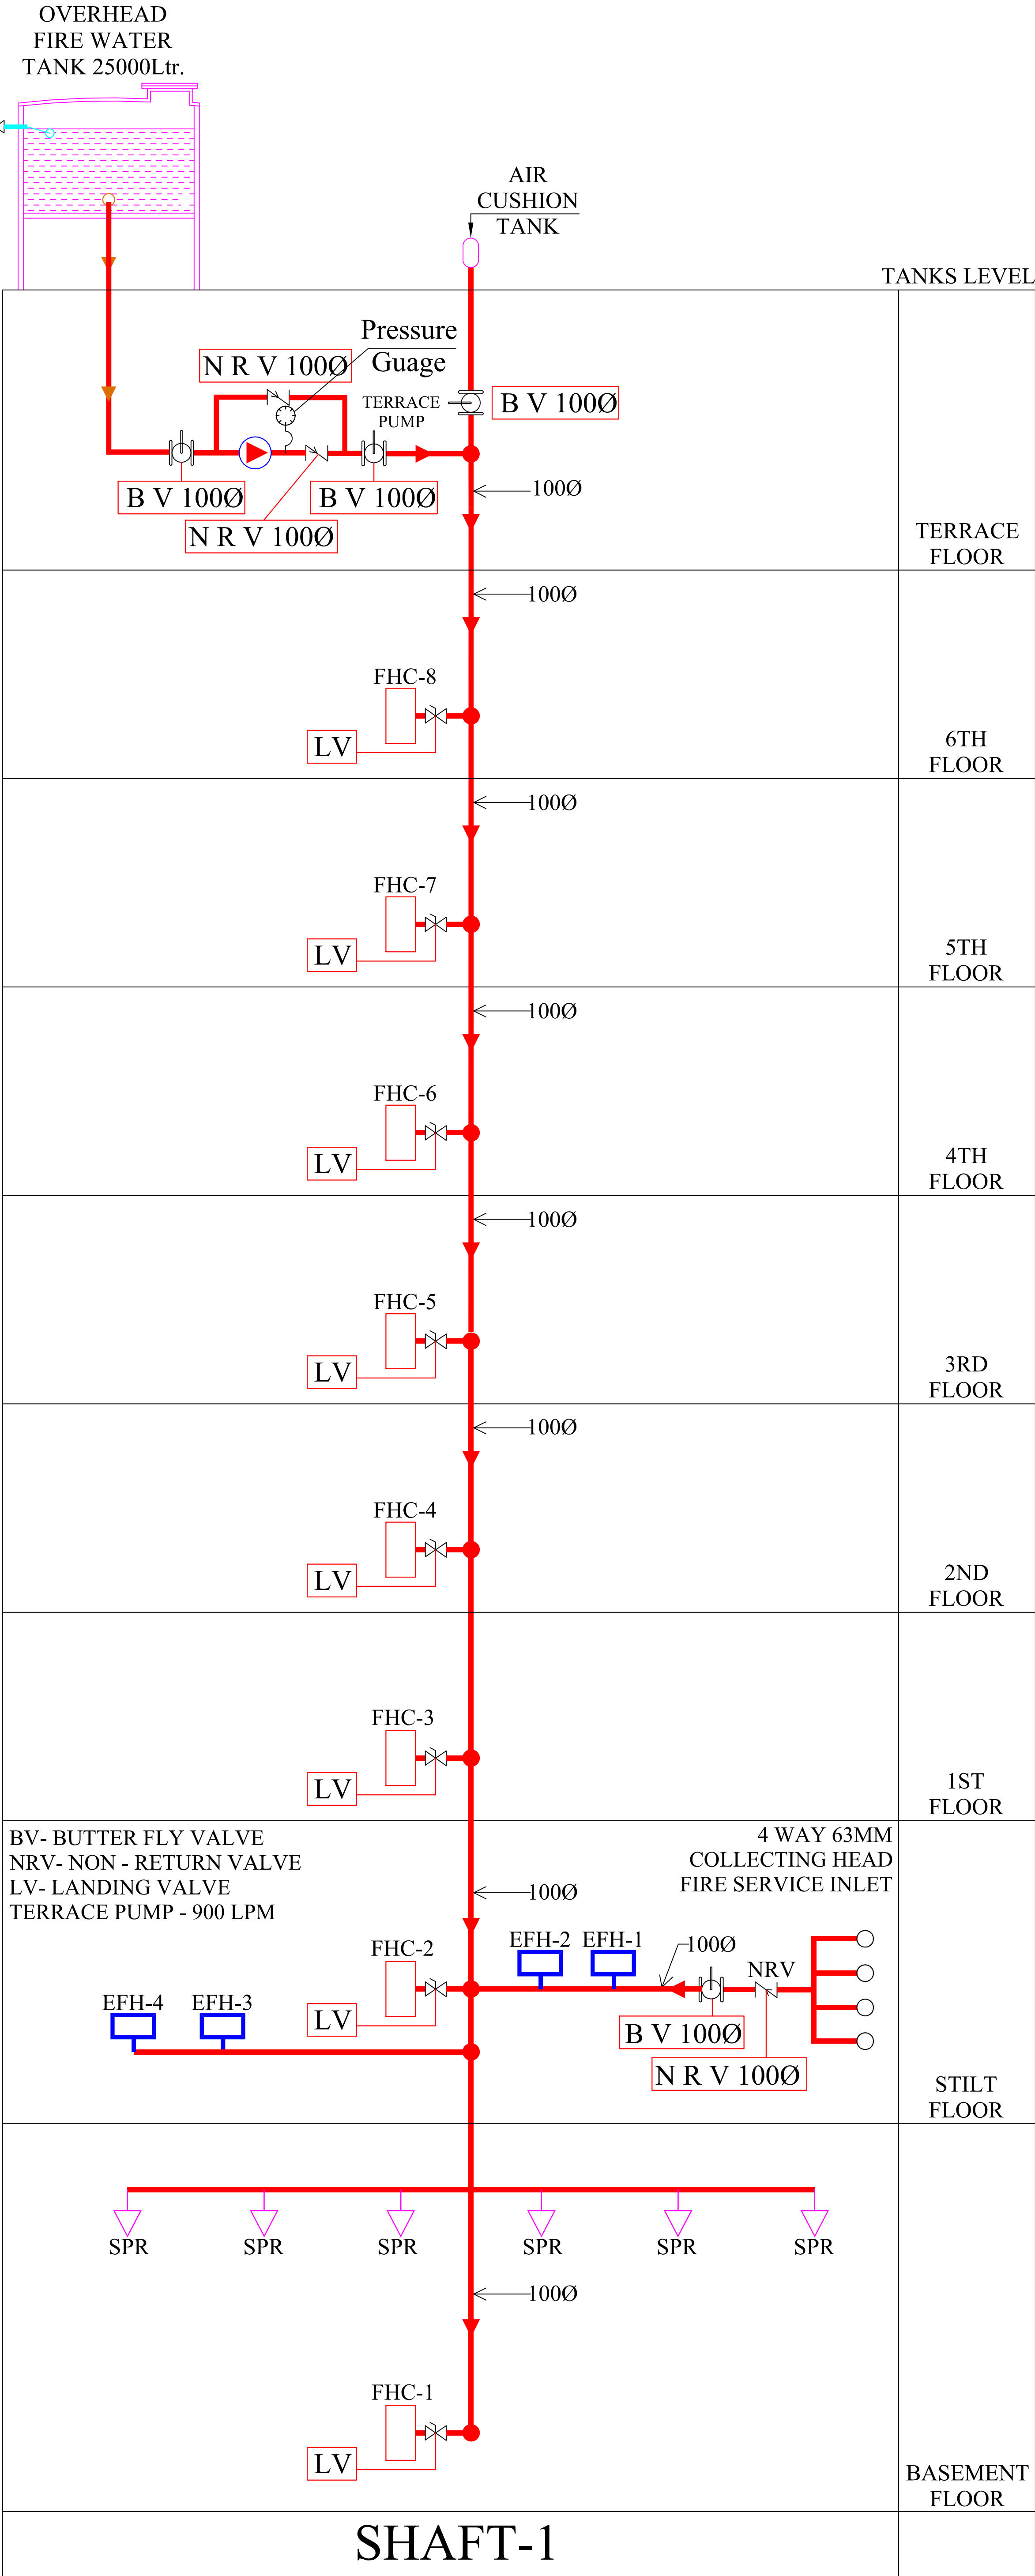

TYPICAL DETAIL OF EXTERNAL FIRE HOSE CABINET (N.T.S.)

TYPICAL DETAIL OF EXTERNAL FIRE HYDRANT (N.T.S.)

ELEVATION-BB

4-WAY FIRE BRIGADE INLET CONNECTION

PLAN
ELEVATION
DETAIL OF FIRE HYDRANT CABINET

VIPUL AGARWAL
M.E.P. CONSULTANT
B.E. ELECTRICAL

S.no.	Symbol	Description	Qty.	Size in mm
1.		Butter fly Valve	04	100Ø
2.		Non Return Valve	03	100Ø
3.		Landing Valve Single headed	12	63Ø
4.		Pressure Guage	01	
5.		FHC	08	
6.		External Fire Hose Cabinet	04	

SERVICES CONSULTANT:
ASHI ASSOCIATES
F9/440,Keshav Marg Chitrakut Scheme,Jaipur
PH:91-0-93146-10438 ,0141-2440946 Mail:vipul8599@yahoo.com

PROMOTER:-
ASHISH GUPTA

PROJECT NAME:-
THE MANSION BY AVENUE

PROJECT ADDRESS:-
KHASRA NO- 2533/760, 2536/2479 ,IN VILLAGE- SIRSI, JAIPUR

DRAWING TITLE:-
FIRE SCHEMATIC LAYOUT

DATE:-
17-06-2025

REV.:-
00