


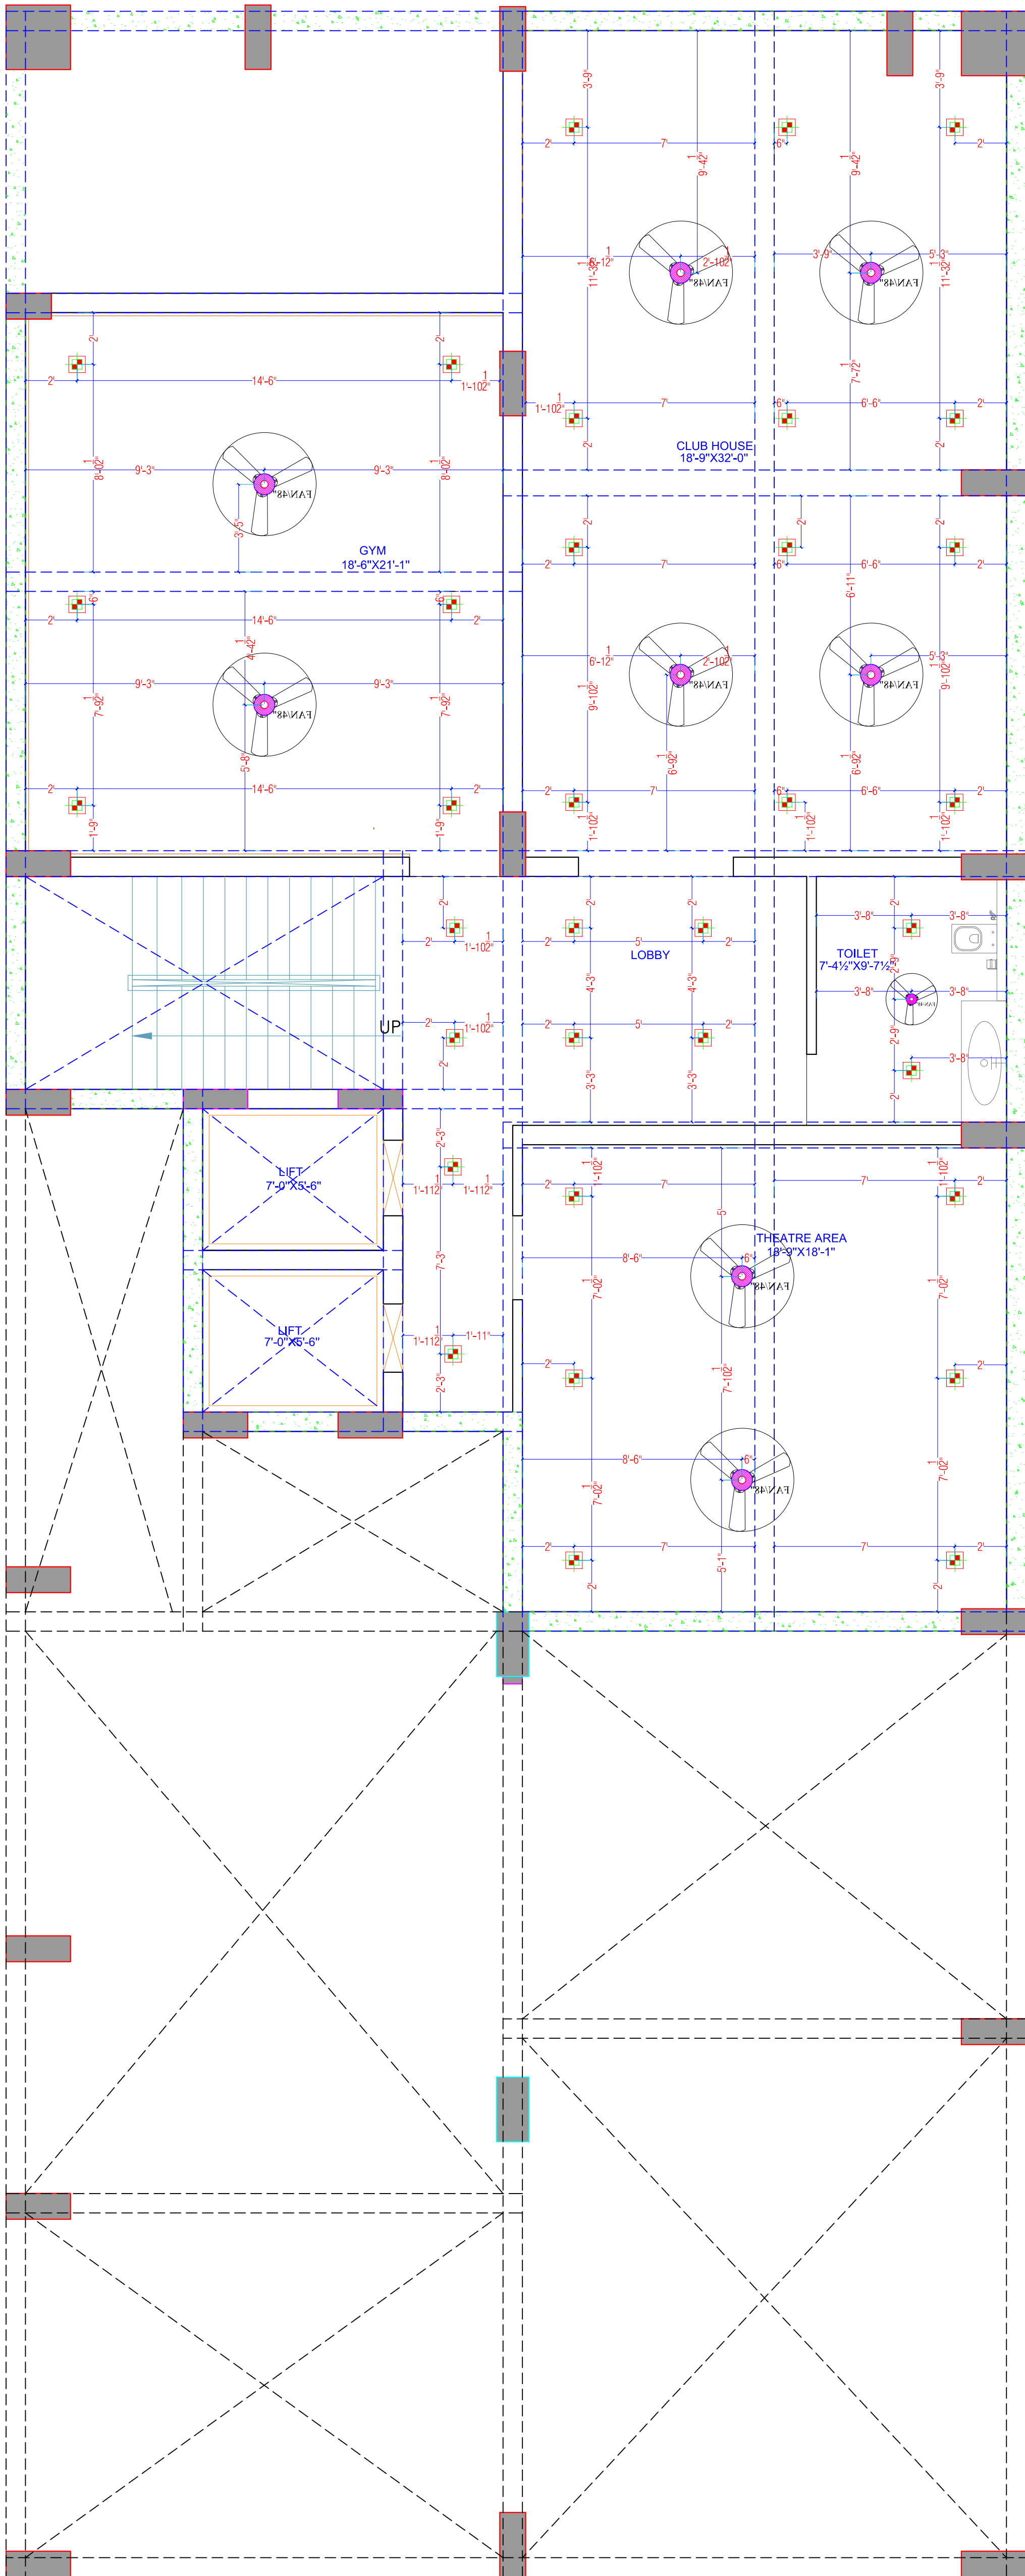

For Shree Salasar Developers
Proprietor

KRISHNA KUMAR
B. Tech. (Mechanical)
M.E.P Consultant

WARNING

1. This drawing is the sole copyright of Architects **VISTAAR** and should be used for the purpose expressly issued.

GENERAL NOTES

1. All dimensions are in feets and inches.
2. Do not scale this drawing follow written dimensions only.
3. This drawing should be read in conjunction with other architectural and structural drawings.
4. Any discripancy in the drawing should be immediately brought to the notice of architect.

PROJECT TITLE

PROJECT:-
TOWN CREST -2
BUILDING AT PLOT-A-6,CHOPRA
ENCLAVE(GANPATPURA),
KIRTI NAGAR,JAIPUR

DRAWING TITLE

BESMANT FLOOR
CEILING ELECTRICAL PLAN

ARCHITECTS :

VISTAAR ARCHITECTS & PLANNERS

Architects :: Interior Designers
B-2/12, Chitrkoot scheme,
main Gandhi Path,Opp mall of jaipur,Jaipur
PH.- 0141-4116461,09001010366

PATH :-

DRN.

DATE

REV.

NORTH


MANOJ
KUMAWAT


19-03-2025

SCALE

JOB NO.

N.T.S

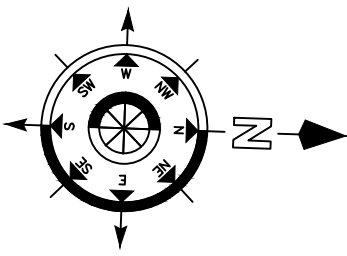

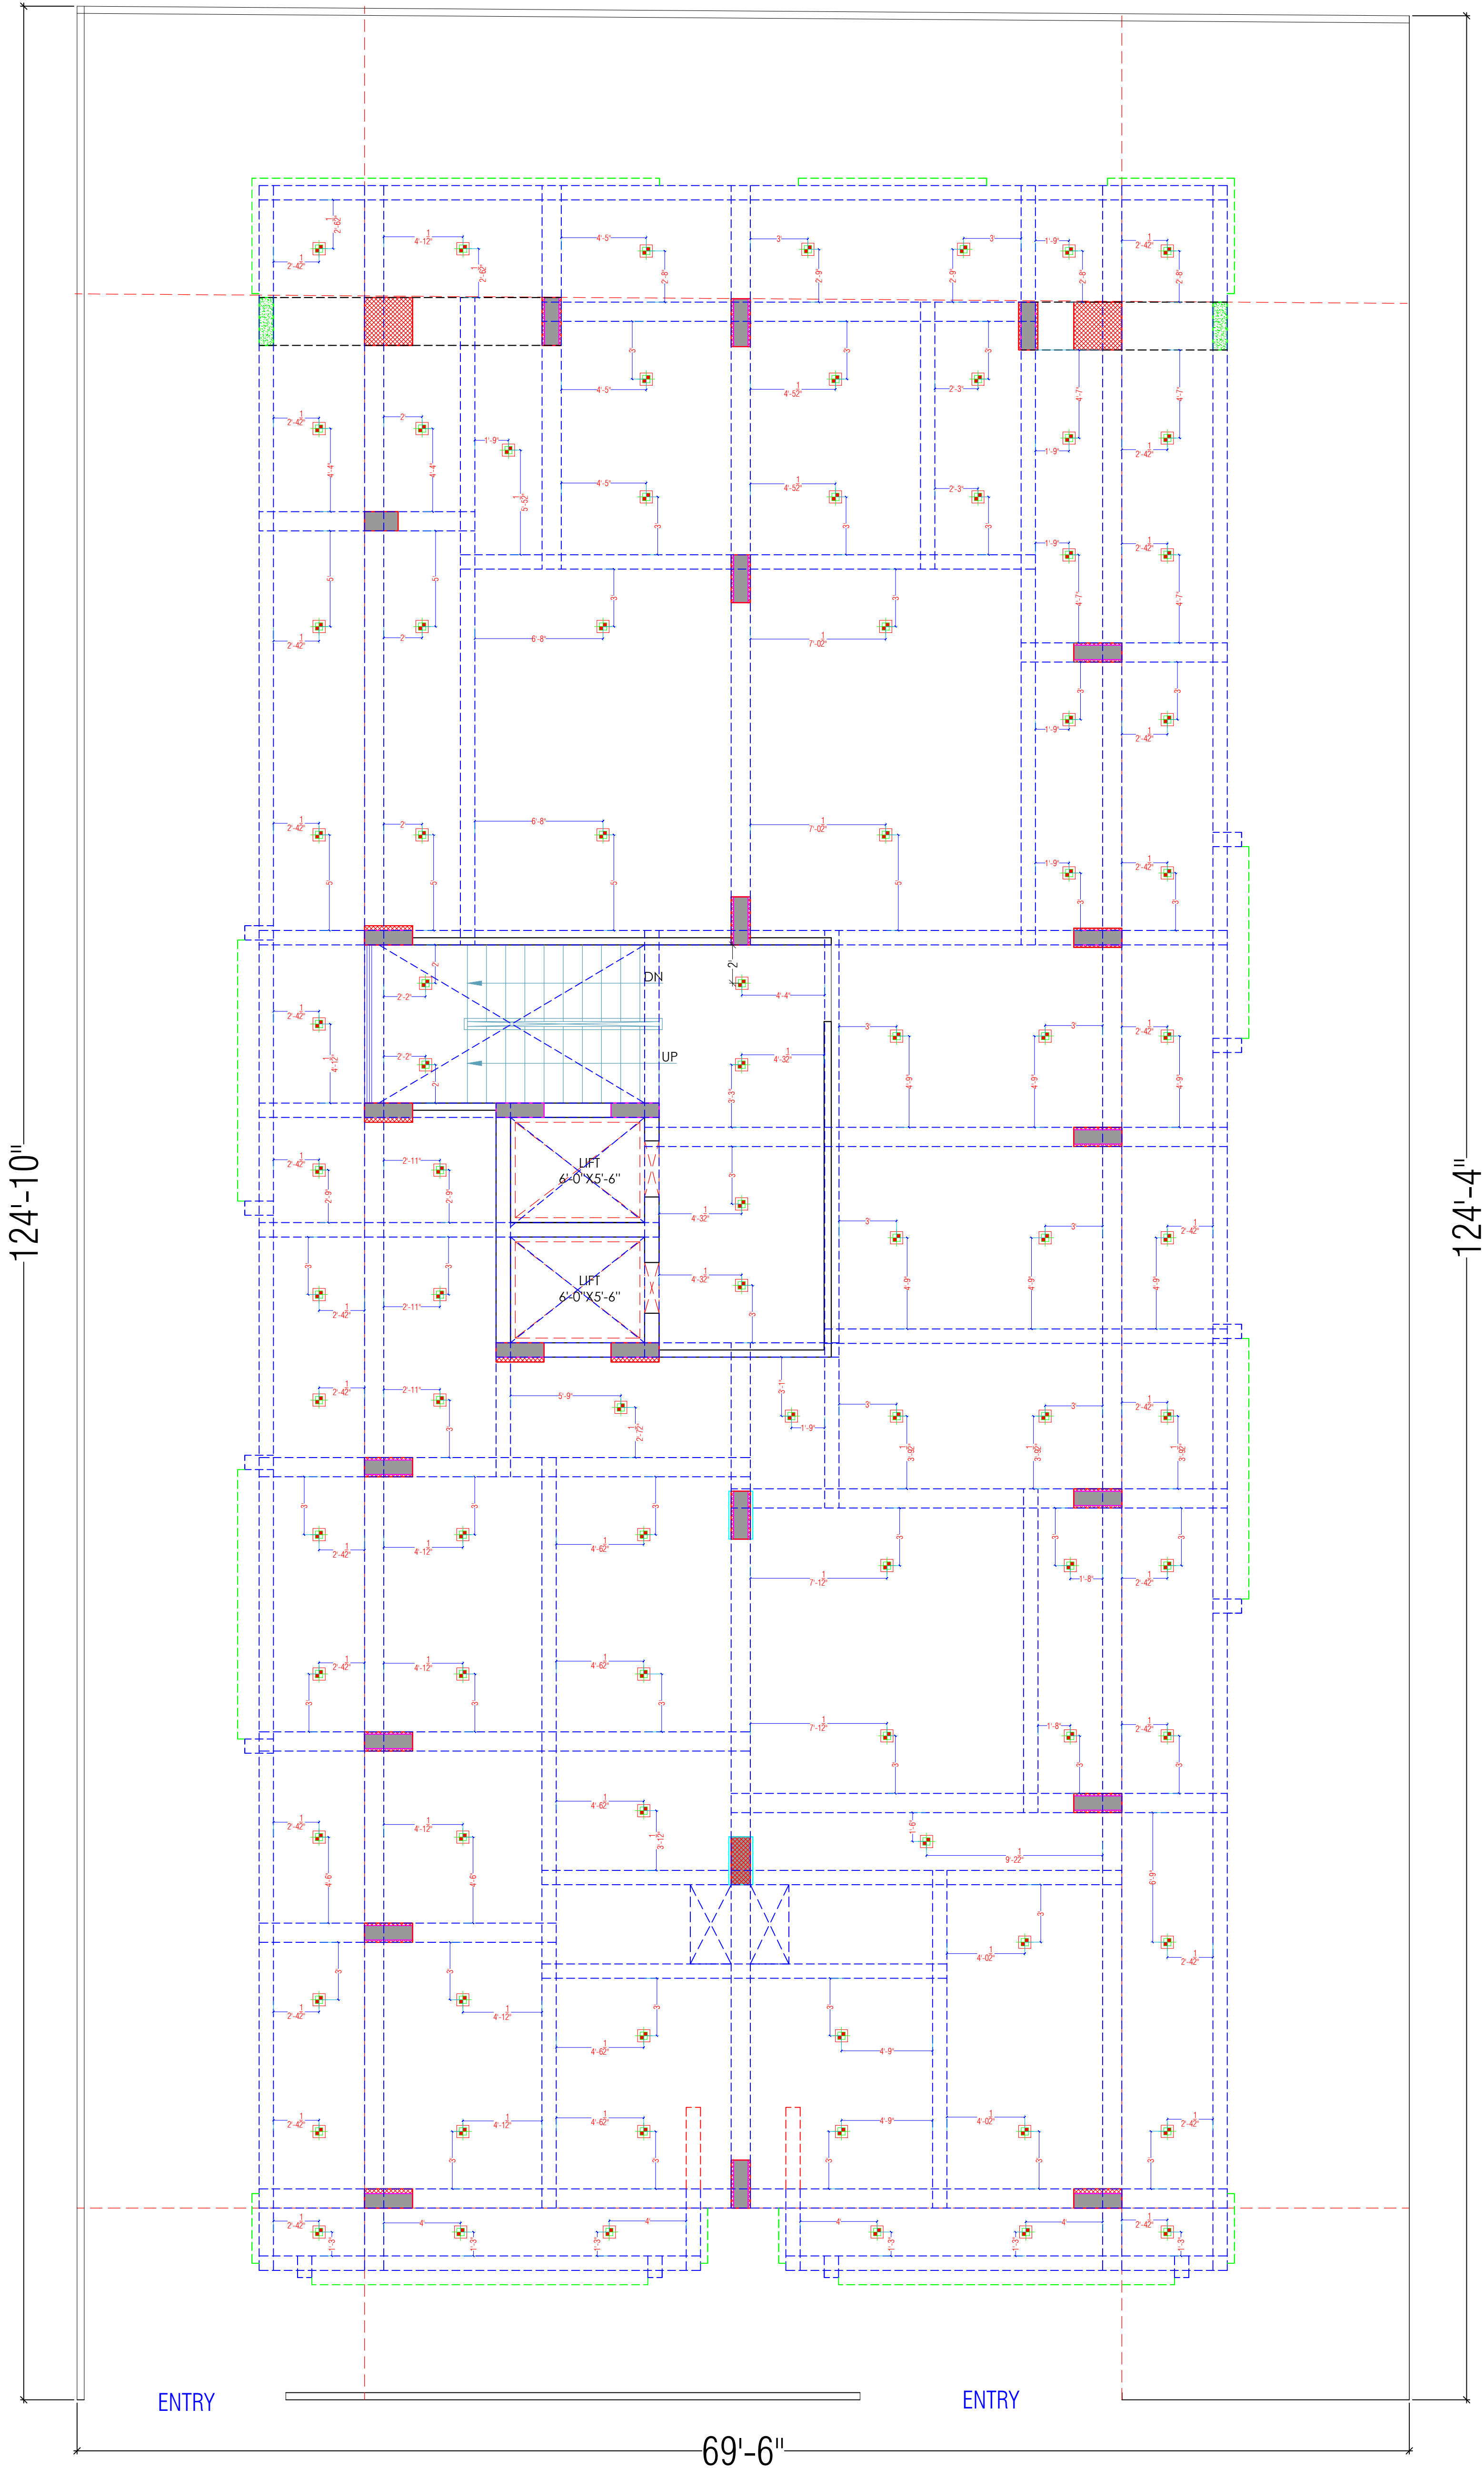

WARNING

1. This drawing is the sole copyright of Architects **VISTAAR** and should be used for the purpose expressly issued.

GENERAL NOTES

1. All dimensions are in feet and inches.
2. Do not scale this drawing follow written dimensions only.
3. This drawing should be read in conjunction with other architectural and structural drawings.
4. Any discrepancy in the drawing should be immediately brought to the notice of architect.

PROJECT TITLE

PROJECT:-
TOWN CREST -2
BUILDING AT PLOT-A-6,CHOPRA
ENCLAVE(GANPATPURA),
KIRTI NAGAR,JAIPUR


DRAWING TITLE

STILT(PARKING)FLOOR
CEILING ELECTRICAL PLAN

ARCHITECTS :

VISTAAR ARCHITECTS & PLANNERS
Architects :: Interior Designers
B-2/12, Chitrkoot scheme,
main Gandhi Path,Opp mall of jaipur,Jaipur
PH. - 0141-4116461,09001010366

PATH :-			
DRN.	DATE	REV.	NORTH
MANOJ KUMAWAT	21-01-2025		
SCALE	JOB NO.		
N.T.S			

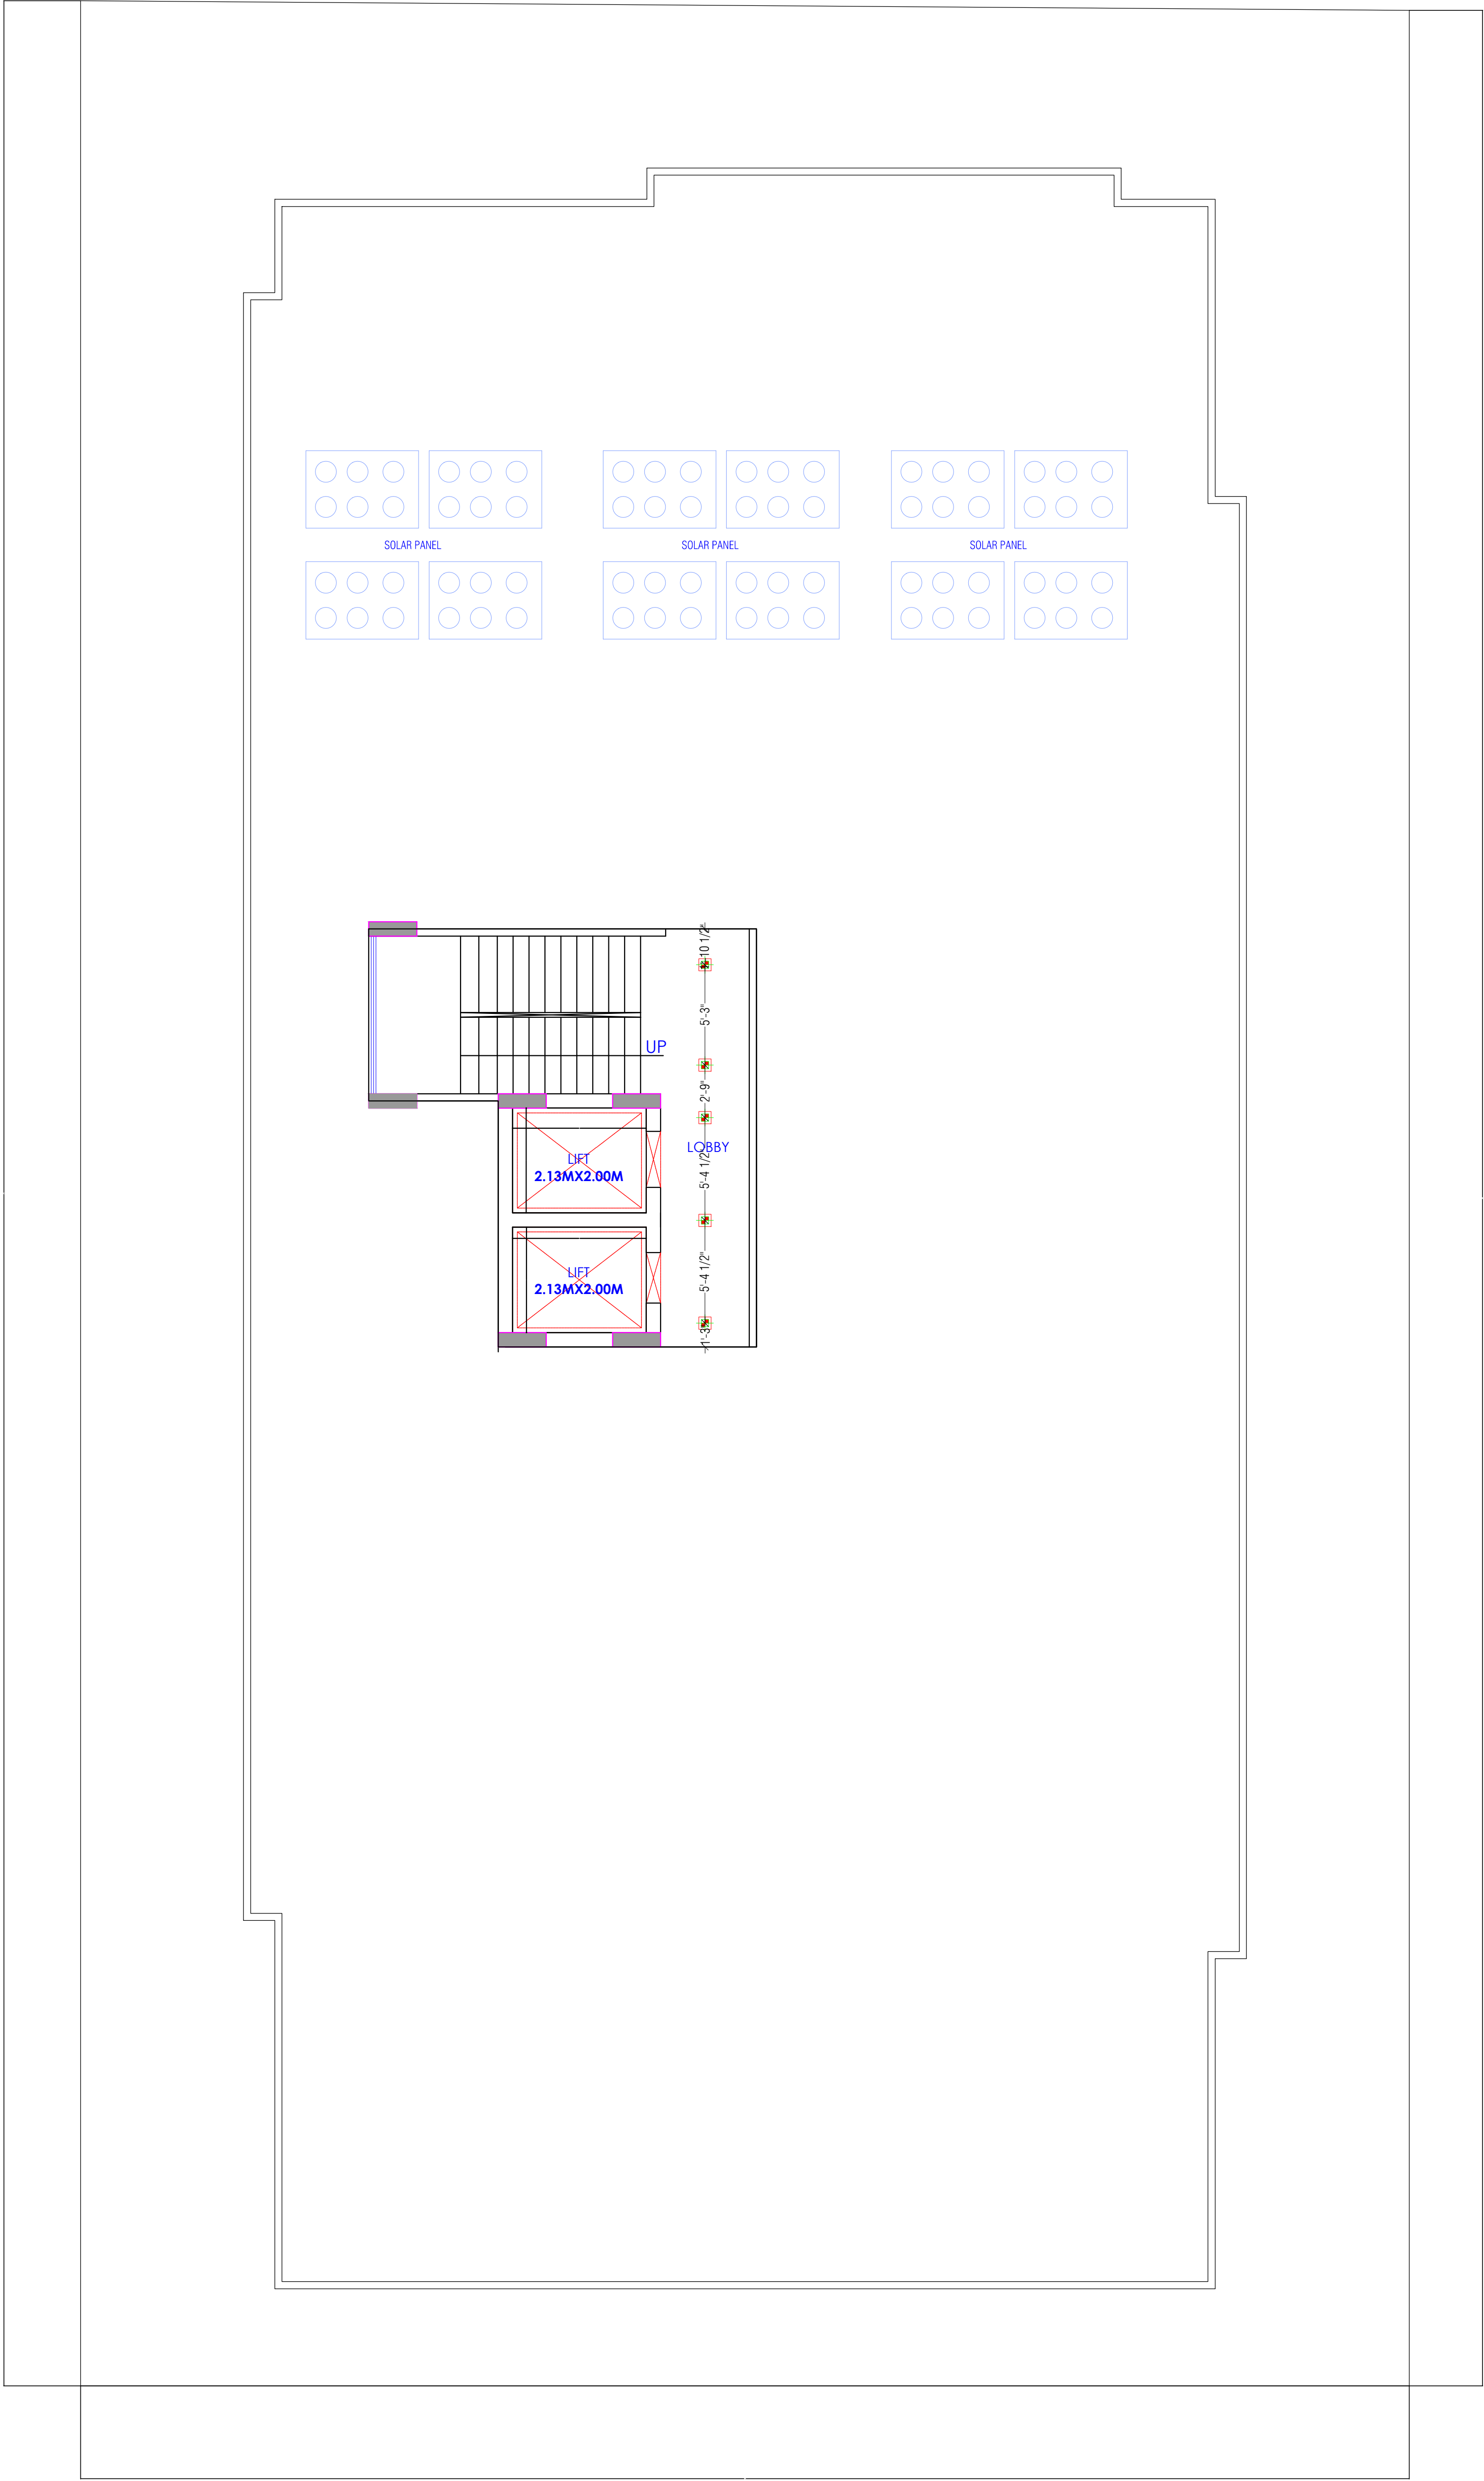

For Shree Salasar Developers
Proprietor

KRISHNA KUMAR
B. Tech. (Mechanical)
M.E.P Consultant

WARNING

1. This drawing is the sole copyright of Architects **VISTAAR** and should be used for the purpose expressly issued.

GENERAL NOTES

- 1. All dimensions are in feet and inches.
- 2. Do not scale this drawing follow written dimensions only.
- 3. This drawing should be read in conjunction with other architectural and structural drawings.
- 4. Any discrepancy in the drawing should be immediately brought to the notice of architect.

PROJECT TITLE

PROJECT:-
TOWN CREST -2
BUILDING AT PLOT-A-6,CHOPRA
ENCLAVE(GANPATPURA),
KIRTI NAGAR,JAIPUR

DRAWING TITLE

TERRACE FLOOR CELING
ELECTRICAL PLAN

ARCHITECTS :

VISTAAR ARCHITECTS & PLANNERS
Architects :: Interior Designers
B-2/12, Chitrkoot scheme,
main Gandhi Path,Opp mall of jaipur,Jaipur
PH.- 0141-4116461,09001010366

PATH :-

DRN.	DATE	REV.	NORTH
MANOJ KUMAWAT	06-03-2025		
SCALE	JOB NO.		
N.T.S			



For Shree Salasar Developers

Proprietor

TERRACE

5th. FLOOR

4th. FLOOR

3rd. FLOOR

2nd. FLOOR

1st. FLOOR

GROUND.
FLOOR

STILT
FLOOR



WARNING

1. This drawing is the sole copyright of Architects
VISTAAR and should be used for the purpose
expressly issued.

GENERAL NOTES

1. All dimensions are in feet and inches.
2. Do not scale this drawing follow written dimensions
only.
3. This drawing should be read in conjunction with other
architectural and structural drawings.
4. Any discrepancy in the drawing should
be immediately brought to the notice of architect.

PROJECT TITLE

PROJECT:-
TOWN CREST -2
BUILDING AT PLOT-A-6,CHOPRA
ENCLAVE(GANPATPURA),
KIRTI NAGAR,JAIPUR

DRAWING TITLE

TELEPHONE
SINGLE LINE DIAGRAM


ARCHITECTS :

**VISTAAR ARCHITECTS &
PLANNERS**

Architects - Interior Designers
B-2/12, Chindokot scheme,
main Gandhi Path,Opp mall of Jaipur,Jaipur
Ph:- 0141-4116461,09001010366

DES.	DATE	REV.	SOUTH
MANU KUMAR	24-08-2024		
SCALE	JOB NO.		
NTS			



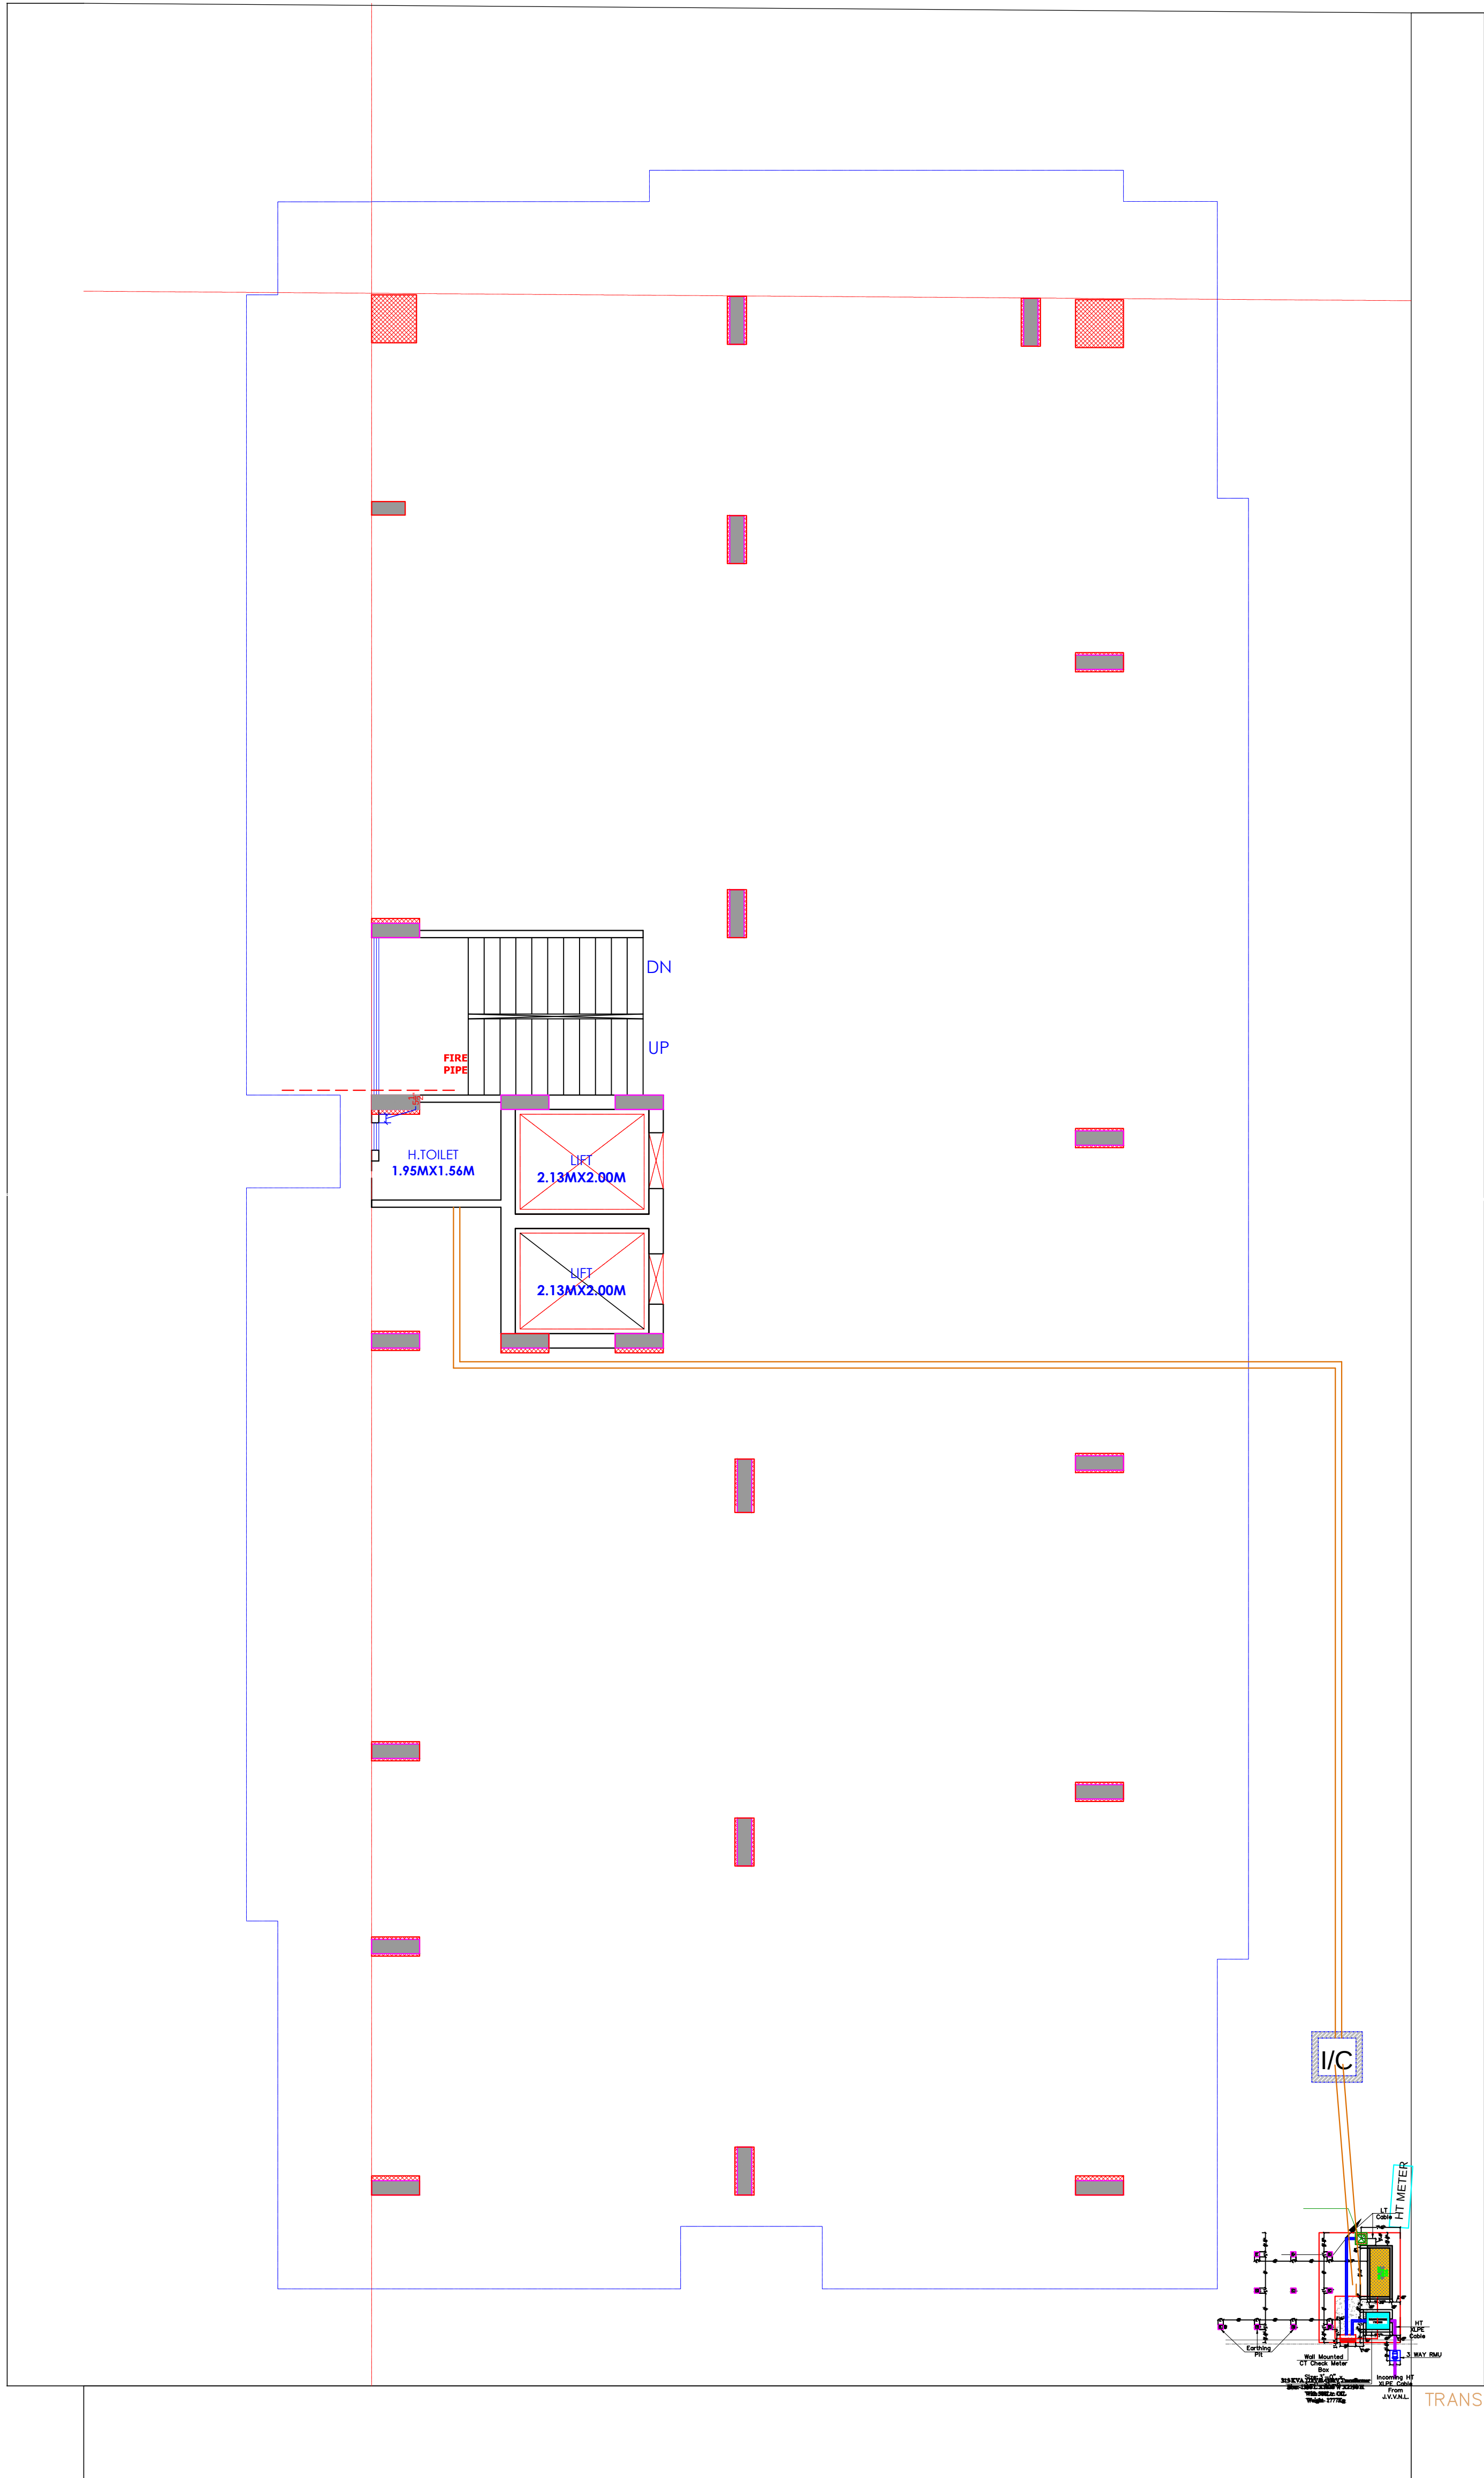

-----ROAD 30'-0" WIDE-----
H.T.LINE 132 KV(SAFETY CORRIDOR)

For Shree Salasar Developers
Proprietor

Krishna
KRISHNA KUMAR
B. Tech. (Mechanical)
M.E.P Consultant

LEGEND

SYMBOL	DESCRIPTION
	DISTRIBUTION BOX
	SWITCH BOARD (8A SOCKET & SWITCHES)
	16A SOCKET WITH SWITCH
	8A POWER SOCKET WITH SWITCH
	CAMERA
	SPLIT AC
	COMPUTER POINT
	TOILET MIRROR LIGHT 1x18W
	WALL BRACKET LED LIGHT
	1 x 14 W MIRROR LIGHT
	900 / 1200 MM SWEEP CEILING FAN
	1 x 72 W CHANDELIER LIGHT
	2 x 5 W CONCEALED FOOT LIGHT
	BSB
	SAC
	TVP
	6A 2 NOS. SOCKET +1 NOS. 16A SWITCH, TV COAXIAL SOCKET @HT 5'-6"
	16A S/S FOR GYSER & 6A S/S FOR RO @HT 5'-6"
	16A S/S FOR MICROWAVE & 6A S/S FOR MIXER @HT 5'-6"
	6A S/S FOR CHIMNEY@HT 5'-6"
	16A S/S FOR FRIDGE@HT 5'-6"
	3 x 1.5 SQMM LIGHT CONTROL CU. WIRE
	3 x 1.5 SQMM 2 WAY LIGHT CONTROL WIRE
	3 x 2.5 SQMM CU. WIRE FOR AC/IDU
	3 x 4.0 SQMM CU. WIRE FOR POWER CIRCUIT
	3 x 2.5 SQMM CU. WIRE FOR LIGHT CIRCUIT
	CAT-6 LAN WIRE RJ-45 JACK TO LAN SWITCH
	CAT-6 TELEPHONE WIRE RJ-11 JACK TO TTB
	RG-6 TV CABLE SETUP BOX TO TV SPLITTER
	CAT-6 CCTV CABLE CCTV CAMERA TO NVR

WARNING

1. This drawing is the sole copyright of Architects VISTAAR and should be used for the purpose expressly issued.

GENERAL NOTES

- All dimensions are in feet and inches.
- Do not scale this drawing follow written dimensions only.
- This drawing should be read in conjunction with other architectural and structural drawings.
- Any discrepancy in the drawing should be immediately brought to the notice of architect.

PROJECT TITLE

PROJECT:-
TOWN CREST -2
BUILDING AT PLOT-A-6,CHOPRA
ENCLAVE(GANPATPURA),
KIRTI NAGAR,JAIPUR


DRAWING TITLE

PROPOSED STILT FLOOR ELECTRIC
SUB-STATION CABLE ROUTE & LIGHTING
AREESTER & EARTHING PLAN

ARCHITECTS :

VISTAAR ARCHITECTS & PLANNERS
Architects :: Interior Designers
B-2/12, Chitrkoot scheme,
main Gandhi Path,Opp mall of jaipur,Jaipur
PH.- 0141-4116461,09001010366

PATH ->	DATE	REV.	NORTH
DRN.	06-03-2025		
MANOJ KUMARWAT			
SCALE	JOB NO.		
N.T.S			

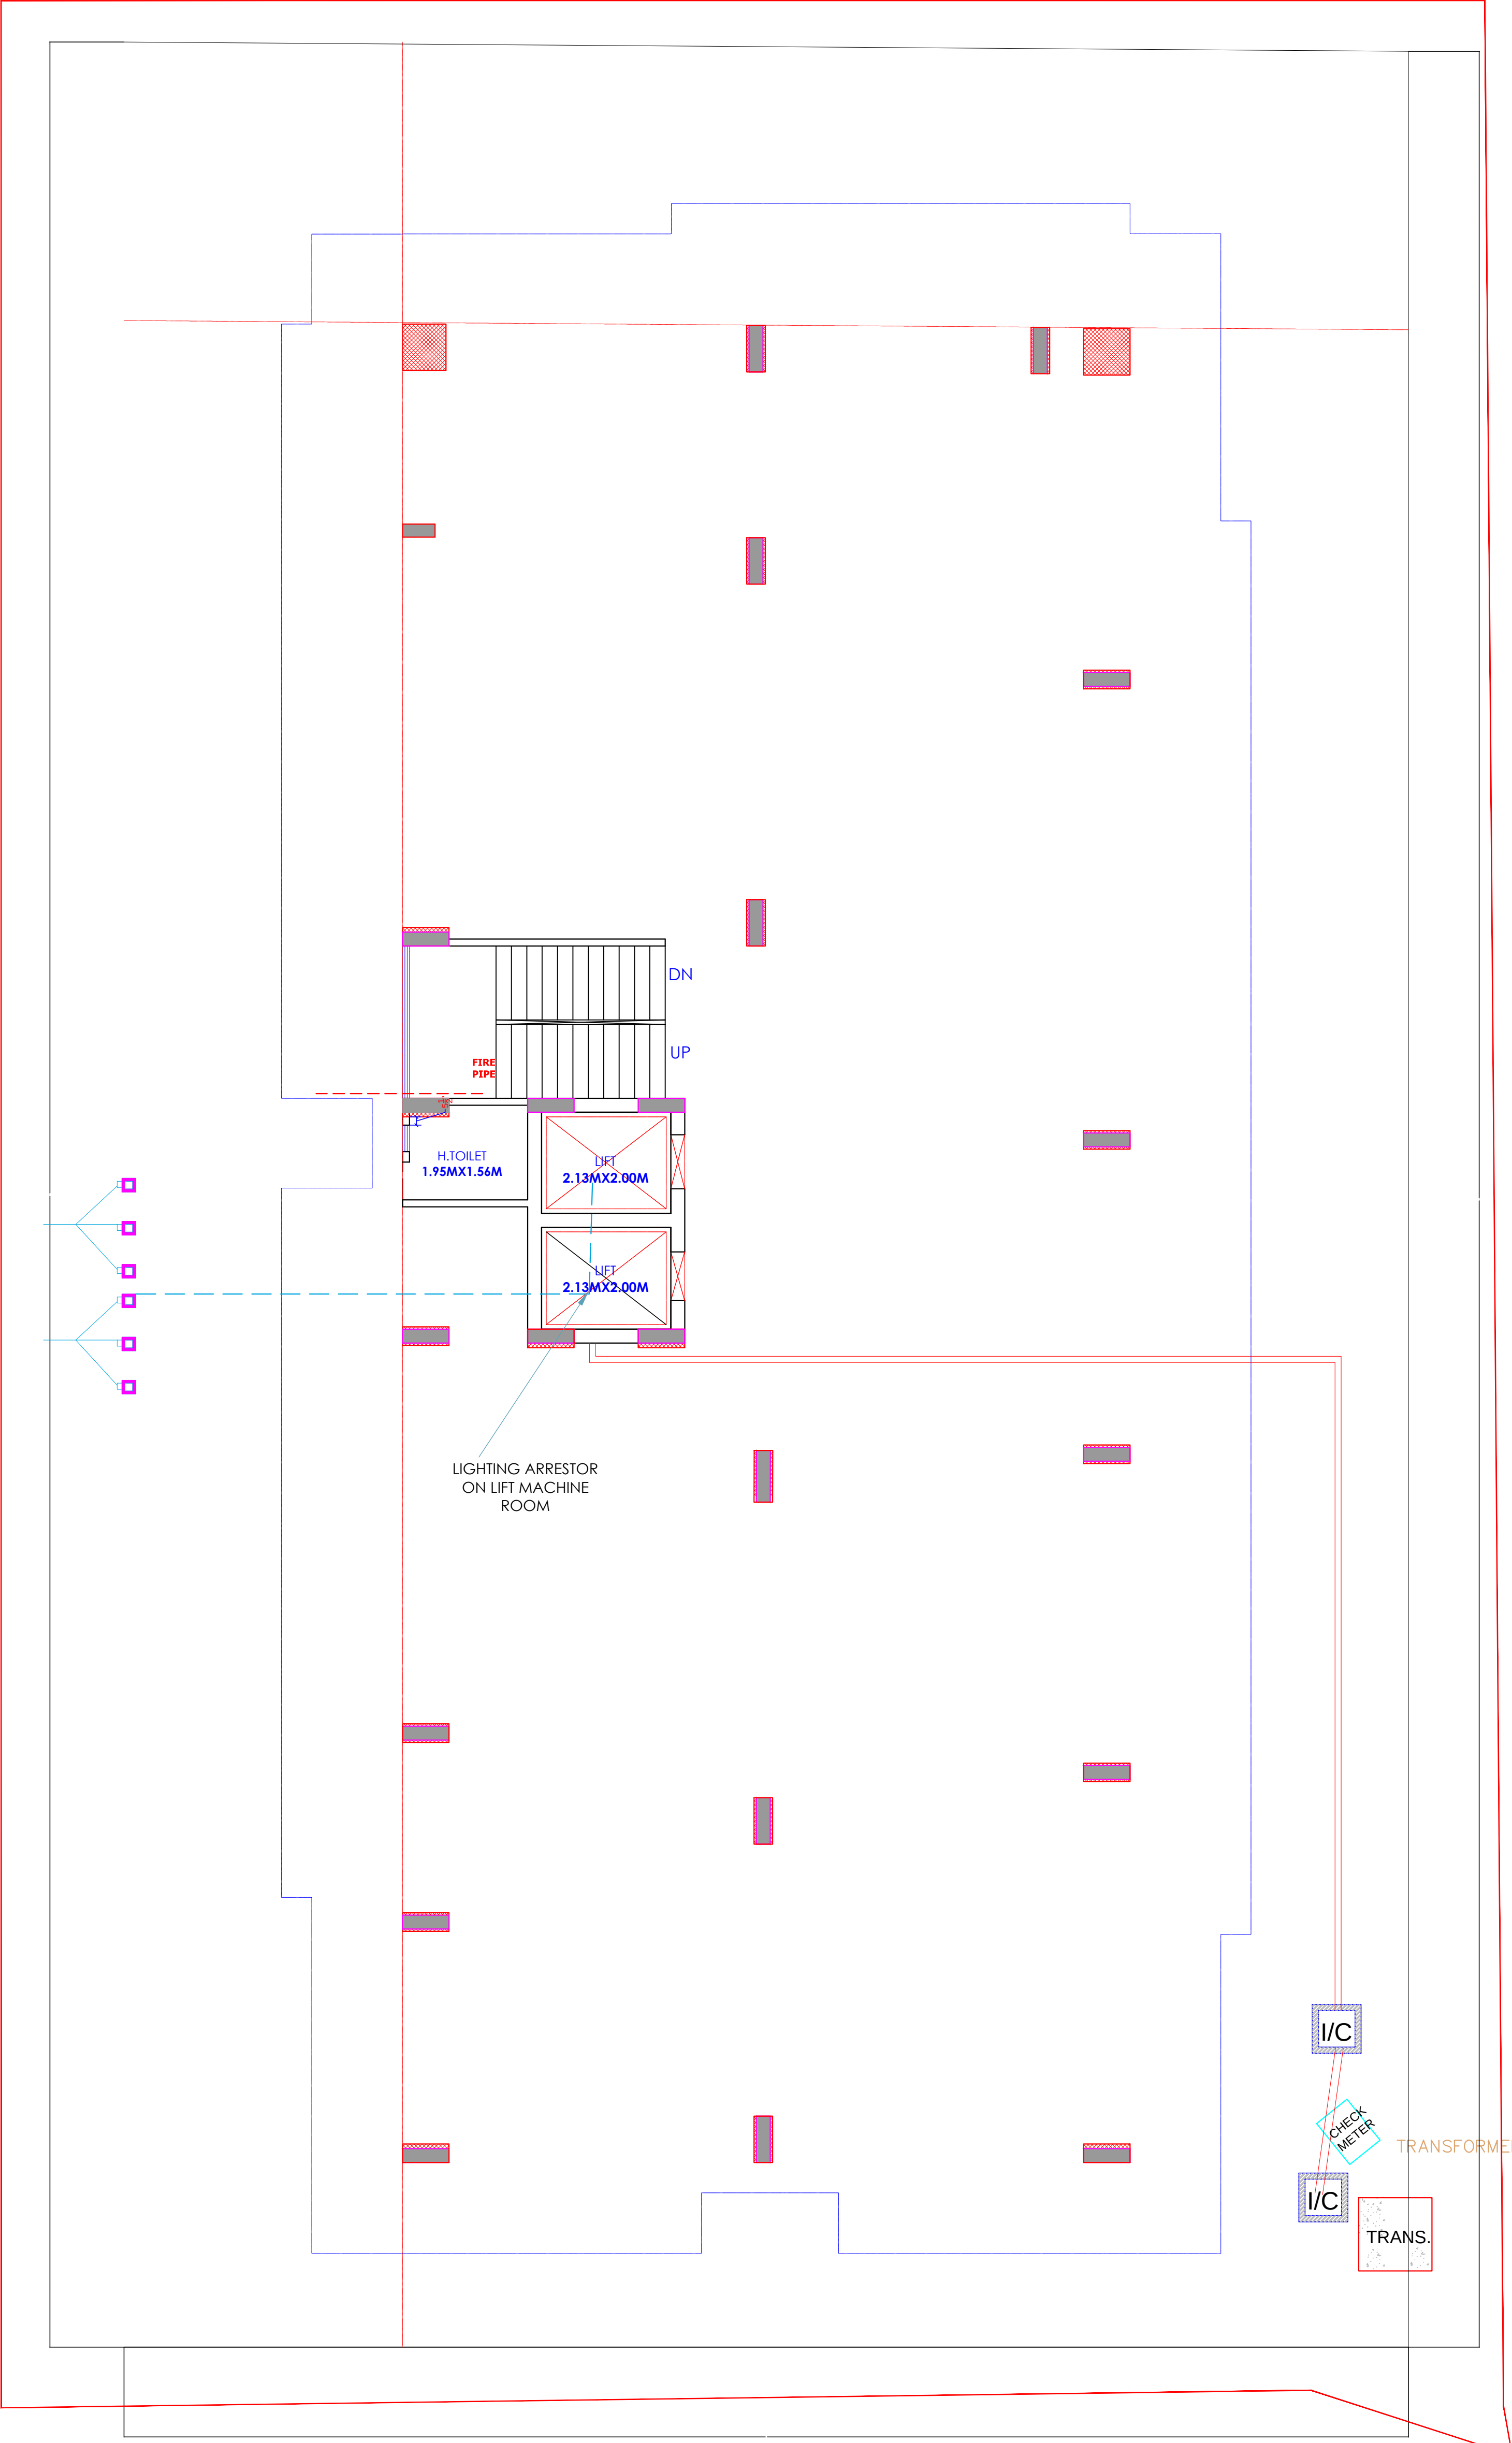

For Shree Salasar Developers
Proprietor

Krishna
KRISHNA KUMAR
B. Tech. (Mechanical)
M.E.P Consultant

LEGEND

SYMBOL	DESCRIPTION
[Symbol]	DISTRIBUTION BOX
[Symbol]	SWITCH BOARD (6A SOCKET & SWITCHES)
[Symbol]	16 A SOCKET WITH SWITCH
[Symbol]	6A POWER SOCKET WITH SWITCH
[Symbol]	CAMERA
[Symbol]	SPILT AC
[Symbol]	COMPUTER POINT
[Symbol]	TOILET MIRROR LIGHT 3x18w
[Symbol]	
[Symbol]	
[Symbol]	WALL BRACKET LED LIGHT
[Symbol]	1 x 14 W MIRROR LIGHT
[Symbol]	900 / 1200 MM SWEEP CEILING FAN
[Symbol]	1 x 72 W CHANDELIER LIGHT
[Symbol]	2 x 5 W CONCEALED FOOT LIGHT
[Symbol]	
[Symbol]	BSB
[Symbol]	BAC
[Symbol]	TVP
[Symbol]	6A 2 NOS. SOCKET -1 NOS. 16A SWITCH, TV COAXIAL SOCKET @HT 5'-6"
[Symbol]	16A S/S FOR GYSER & 6A S/S FOR RO @HT 5'-6"
[Symbol]	16A S/S FOR MICROWAVE & 6A S/S FOR MIXER @HT 5'-6"
[Symbol]	6A S/S FOR CHIMNEY@HT 5'-6"
[Symbol]	16A S/S FOR FRIEDGE@HT 5'-6"
[Symbol]	3 x 1.5 SQMM LIGHT CONTROL CU. WIRE
[Symbol]	3 x 1.5 SQMM 2 WAY LIGHT CONTROL WIRE
[Symbol]	3 x 2.5 SQMM CU. WIRE FOR AC IDU
[Symbol]	3 x 4.0 SQMM CU. WIRE FOR POWER CIRCUIT
[Symbol]	3 x 2.5 SQMM CU. WIRE FOR LIGHT CIRCUIT
[Symbol]	CAT-6 LAN WIRE RJ-45 JACK TO LAN SWITCH
[Symbol]	CAT-6 TELEPHONE WIRE RJ-11 JACK TO TTB
[Symbol]	RG-6 TV CABLE SETUP BOX TO TV SPLITTER
[Symbol]	CAT-6 CCTV CABLE CCTV CAMERA TO NVR


WARNING

1. This drawing is the sole copyright of Architects VISTAAR and should be used for the purpose expressly issued.

GENERAL NOTES

- 1. All dimensions are in feets and inches.
- 2. Do not scale this drawing follow written dimensions only.
- 3. This drawing should be read in conjunction with other architectural and structural drawings.
- 4. Any discrepancy in the drawing should be immediately brought to the notice of architect.

PROJECT TITLE			
PROJECT:- TOWN CREST -2 BUILDING AT PLOT-A-6,CHOPRA ENCLAVE(GANPATPURA), KIRTI NAGAR,JAIPUR			
DRAWING TITLE			
SERVICE(SLD/DISTRIBUTION DETAILS AFTER LT PANEL,EARTHING LAYOUT,EXTERNAL LIGHTING PLAN,LAYOUT,TV & TELEPHONE RISER DIAGRAM,LIGHTING ARRESTER LOCATION & PIT LOCATION,COORDINATION DRAWINGS,FIRE DETECTION & ALARM SYSTEM LAYOUT OF ALL FLOOR)			
ARCHITECTS :			
VISTAAR ARCHITECTS & PLANNERS Architects :: Interior Designers B-2/12, Chitrkoot scheme, main Gandhi Path,Opp mall of jaipur,Jaipur PH.- 0141-4116461,09001010366			
PATH :-	DATE	REV.	NORTH
DRN.	06-03-2025		
MANOJ KUMAWAT			
SCALE	JOB NO.		
N.T.S			

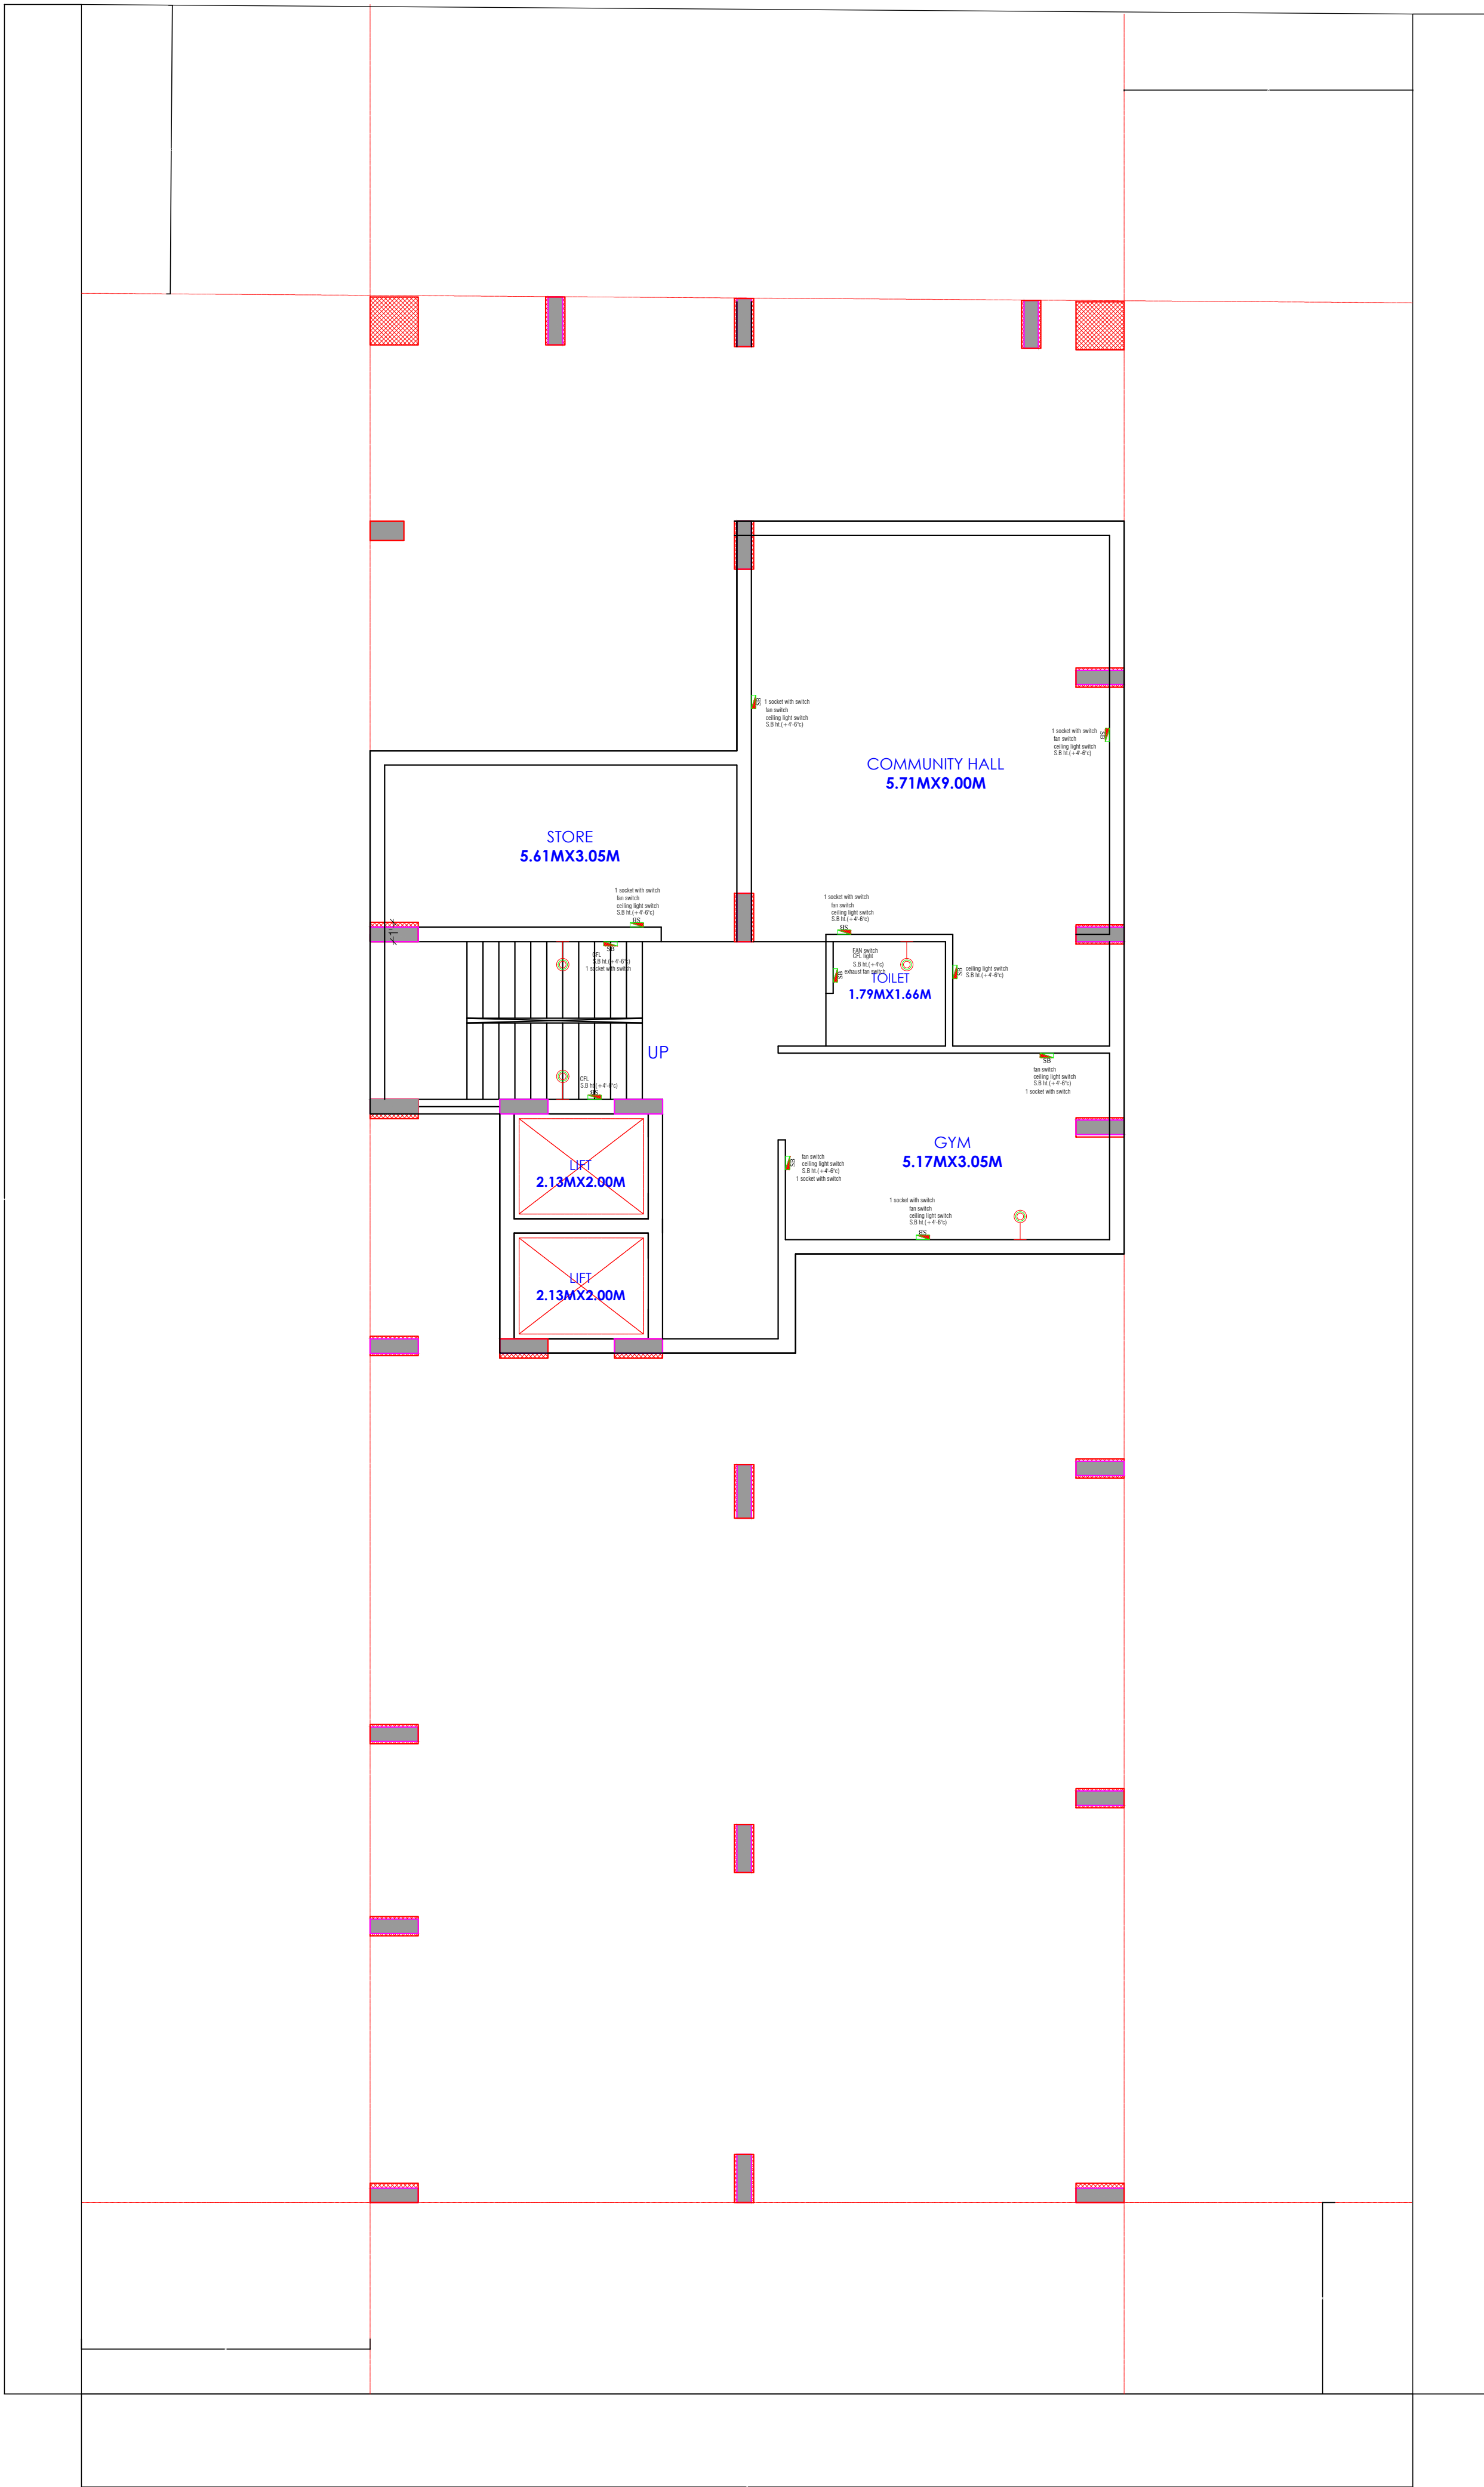

-----ROAD 30'-0" WIDE-----
H.T.LINE 132 KV(SAFETY CORRIDOR)

For Shree Salasar Developers
Proprietor


Krishna
KRISHNA KUMAR
B. Tech. (Mechanical)
M.E.P Consultant

- WARNING**
1. This drawing is the sole copyright of Architects **VISTAAR** and should be used for the purpose expressly issued.
- GENERAL NOTES**
1. All dimensions are in feet and inches.
2. Do not scale this drawing follow written dimensions only.
3. This drawing should be read in conjunction with other architectural and structural drawings.
4. Any discrepancy in the drawing should be immediately brought to the notice of architect.

PROJECT TITLE			
PROJECT:- TOWN CREST -2 BUILDING AT PLOT-A-6,CHOPRA ENCLAVE(GANPATPURA), KIRTI NAGAR,JAIPUR			
DRAWING TITLE			
BASEMENT FLOOR WALL ELECTRICAL PLAN			
ARCHITECTS :			
VISTAAR ARCHITECTS & PLANNERS Architects :: Interior Designers B-2/12, Chitrkoot scheme, main Gandhi Path,Opp mall of jaipur,Jaipur PH.- 0141-4116461,09001010366			
PATH :-			
DRN.	DATE	REV.	NORTH
MANDI KUMAWAT	06-03-2025		
SCALE	JOB NO.		
N.T.S			

For Shree Salasar Developers
Proprietor

Krishna
KRISHNA KUMAR
B. Tech. (Mechanical)
M.E.P Consultant

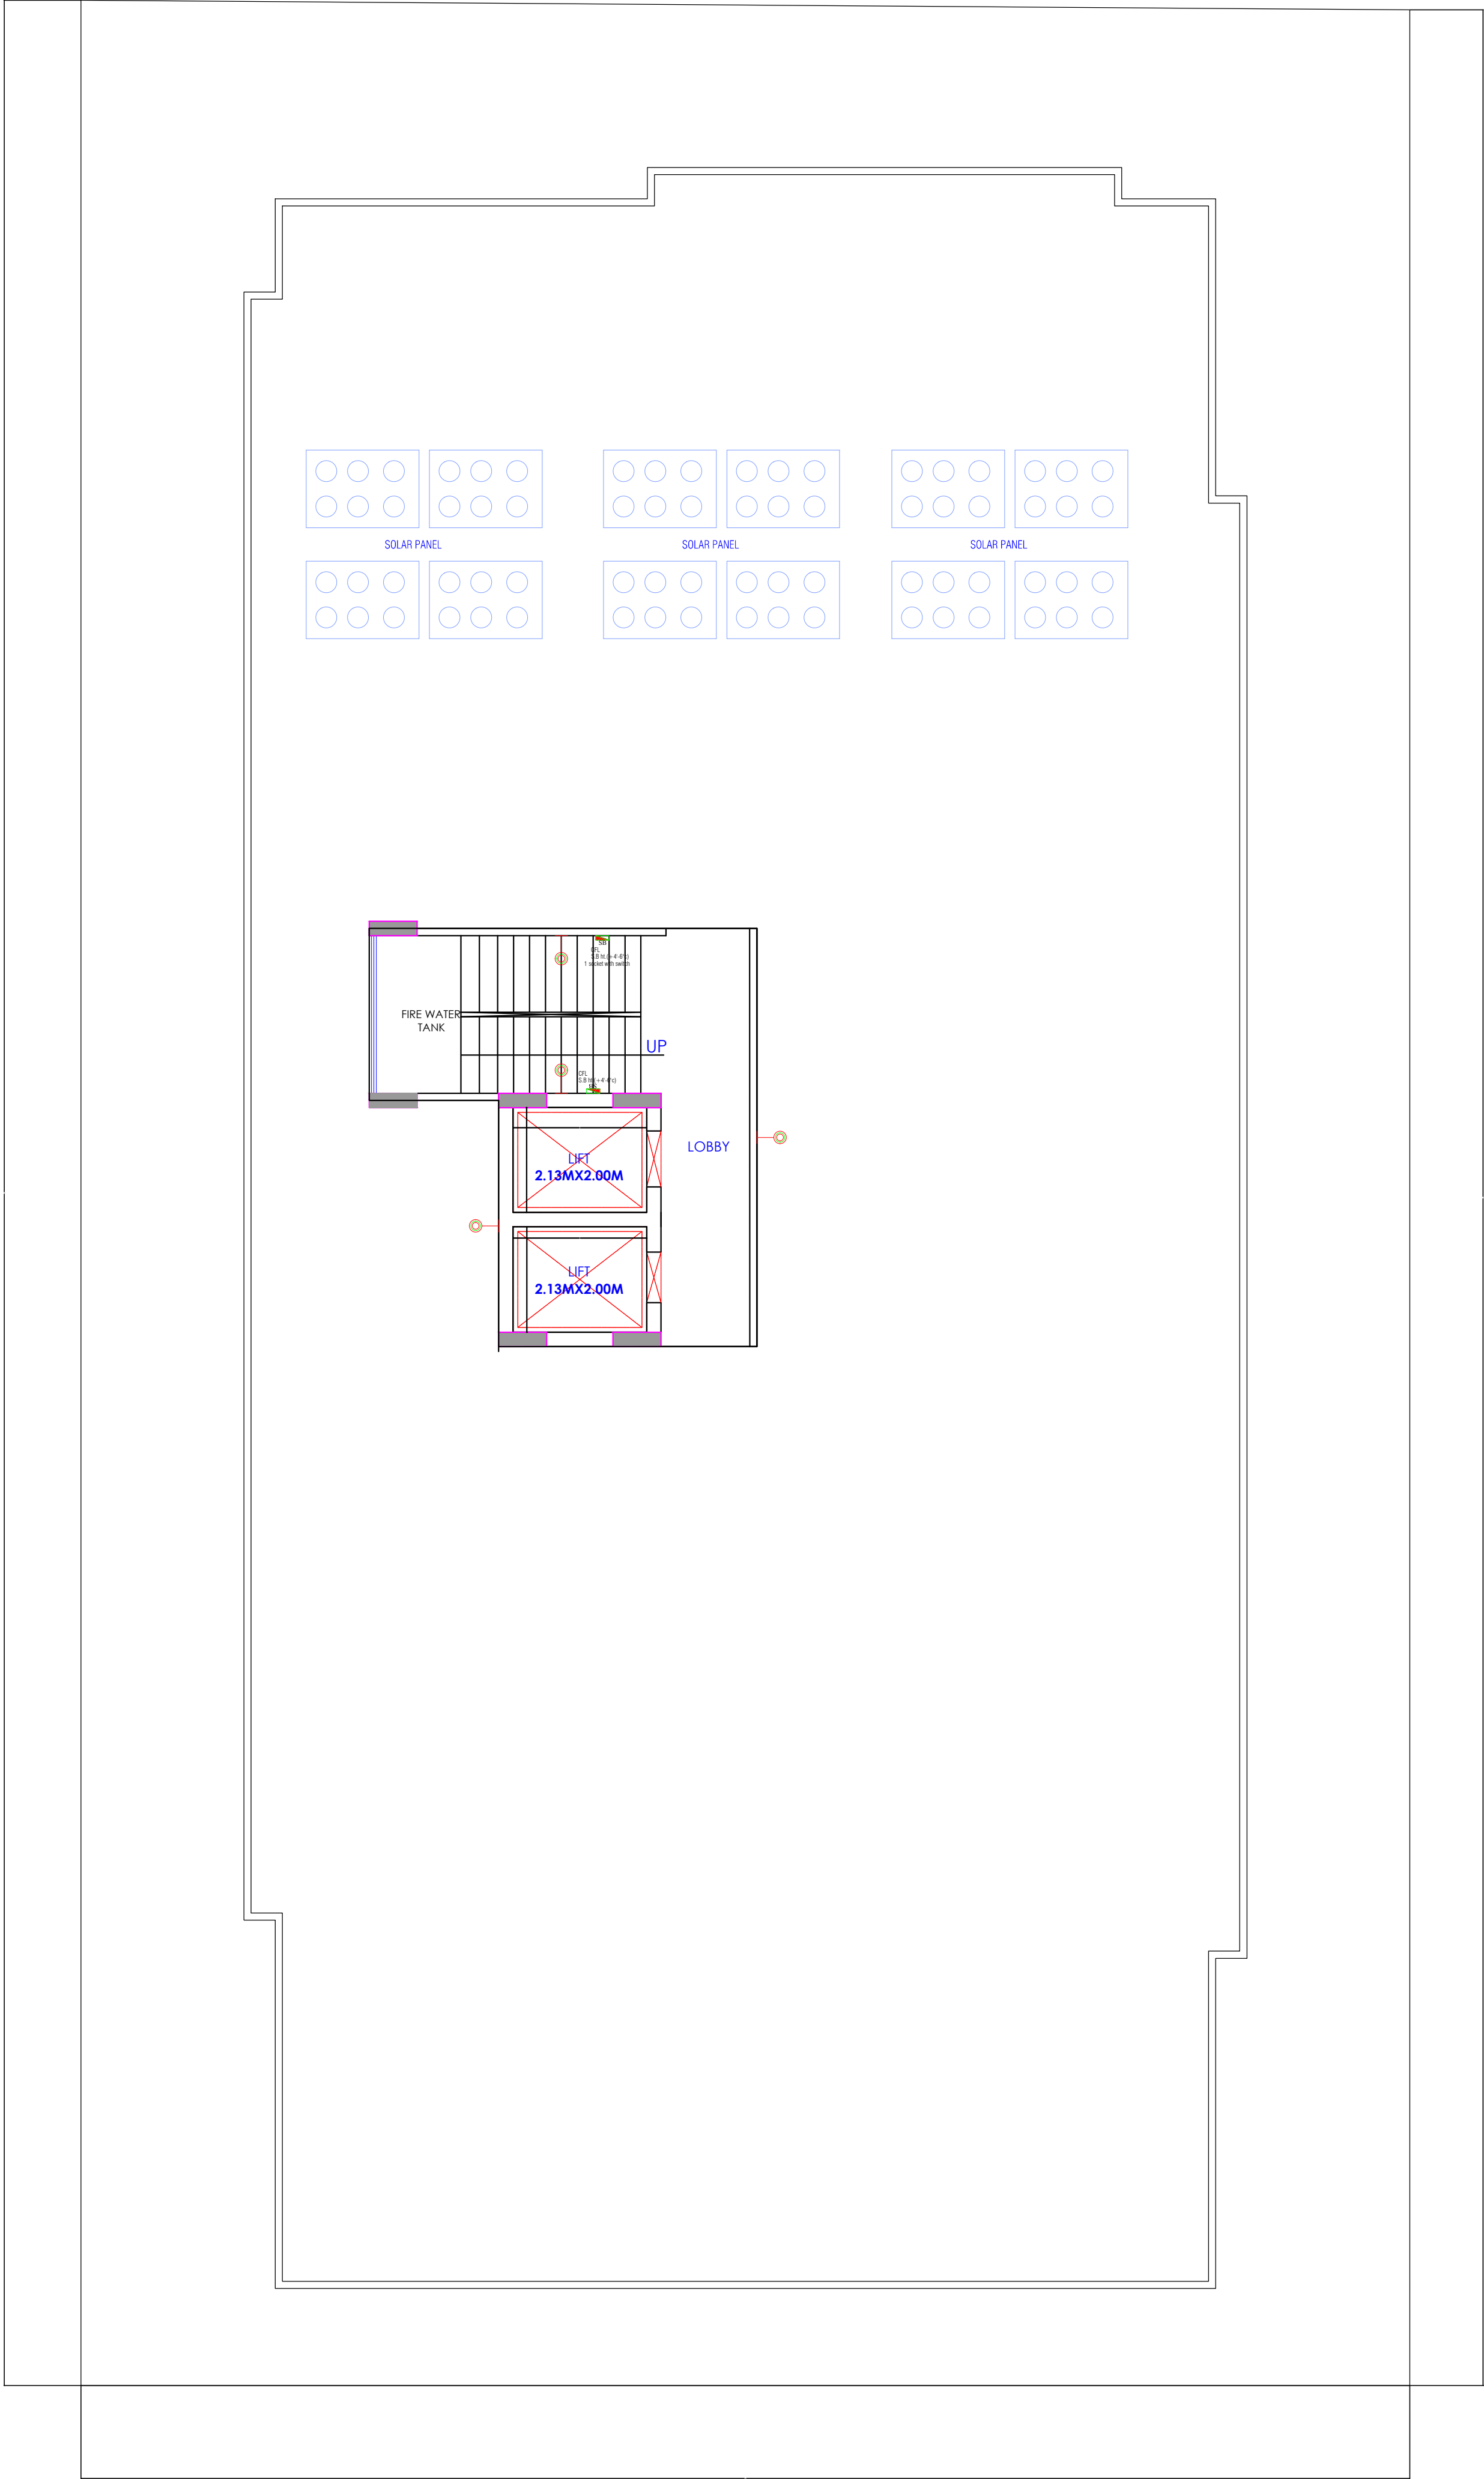

WARNING

1. This drawing is the sole copyright of Architects **VISTAAR** and should be used for the purpose expressly issued.

GENERAL NOTES

1. All dimensions are in feet and inches.
2. Do not scale this drawing follow written dimensions only.
3. This drawing should be read in conjunction with other architectural and structural drawings.
4. Any discrepancy in the drawing should be immediately brought to the notice of architect.

PROJECT TITLE

PROJECT:-
TOWN CREST -2
BUILDING AT PLOT-A-6,CHOPRA
ENCLAVE(GANPATPURA),
KIRTI NAGAR,JAIPUR

DRAWING TITLE


TERRACE FLOOR
WALL ELECTRICAL PLAN

ARCHITECTS :

VISTAAR ARCHITECTS & PLANNERS
Architects :: Interior Designers
B-2/12, Chitrkoot scheme,
main Gandhi Path,Opp mall of jaipur,Jaipur
PH.- 0141-4116461,09001010366

PATH:-

DRN.	DATE	REV.	NORTH
MANOJ KUMARWAT	06-03-2025		
SCALE	JOB NO.		
NTS			

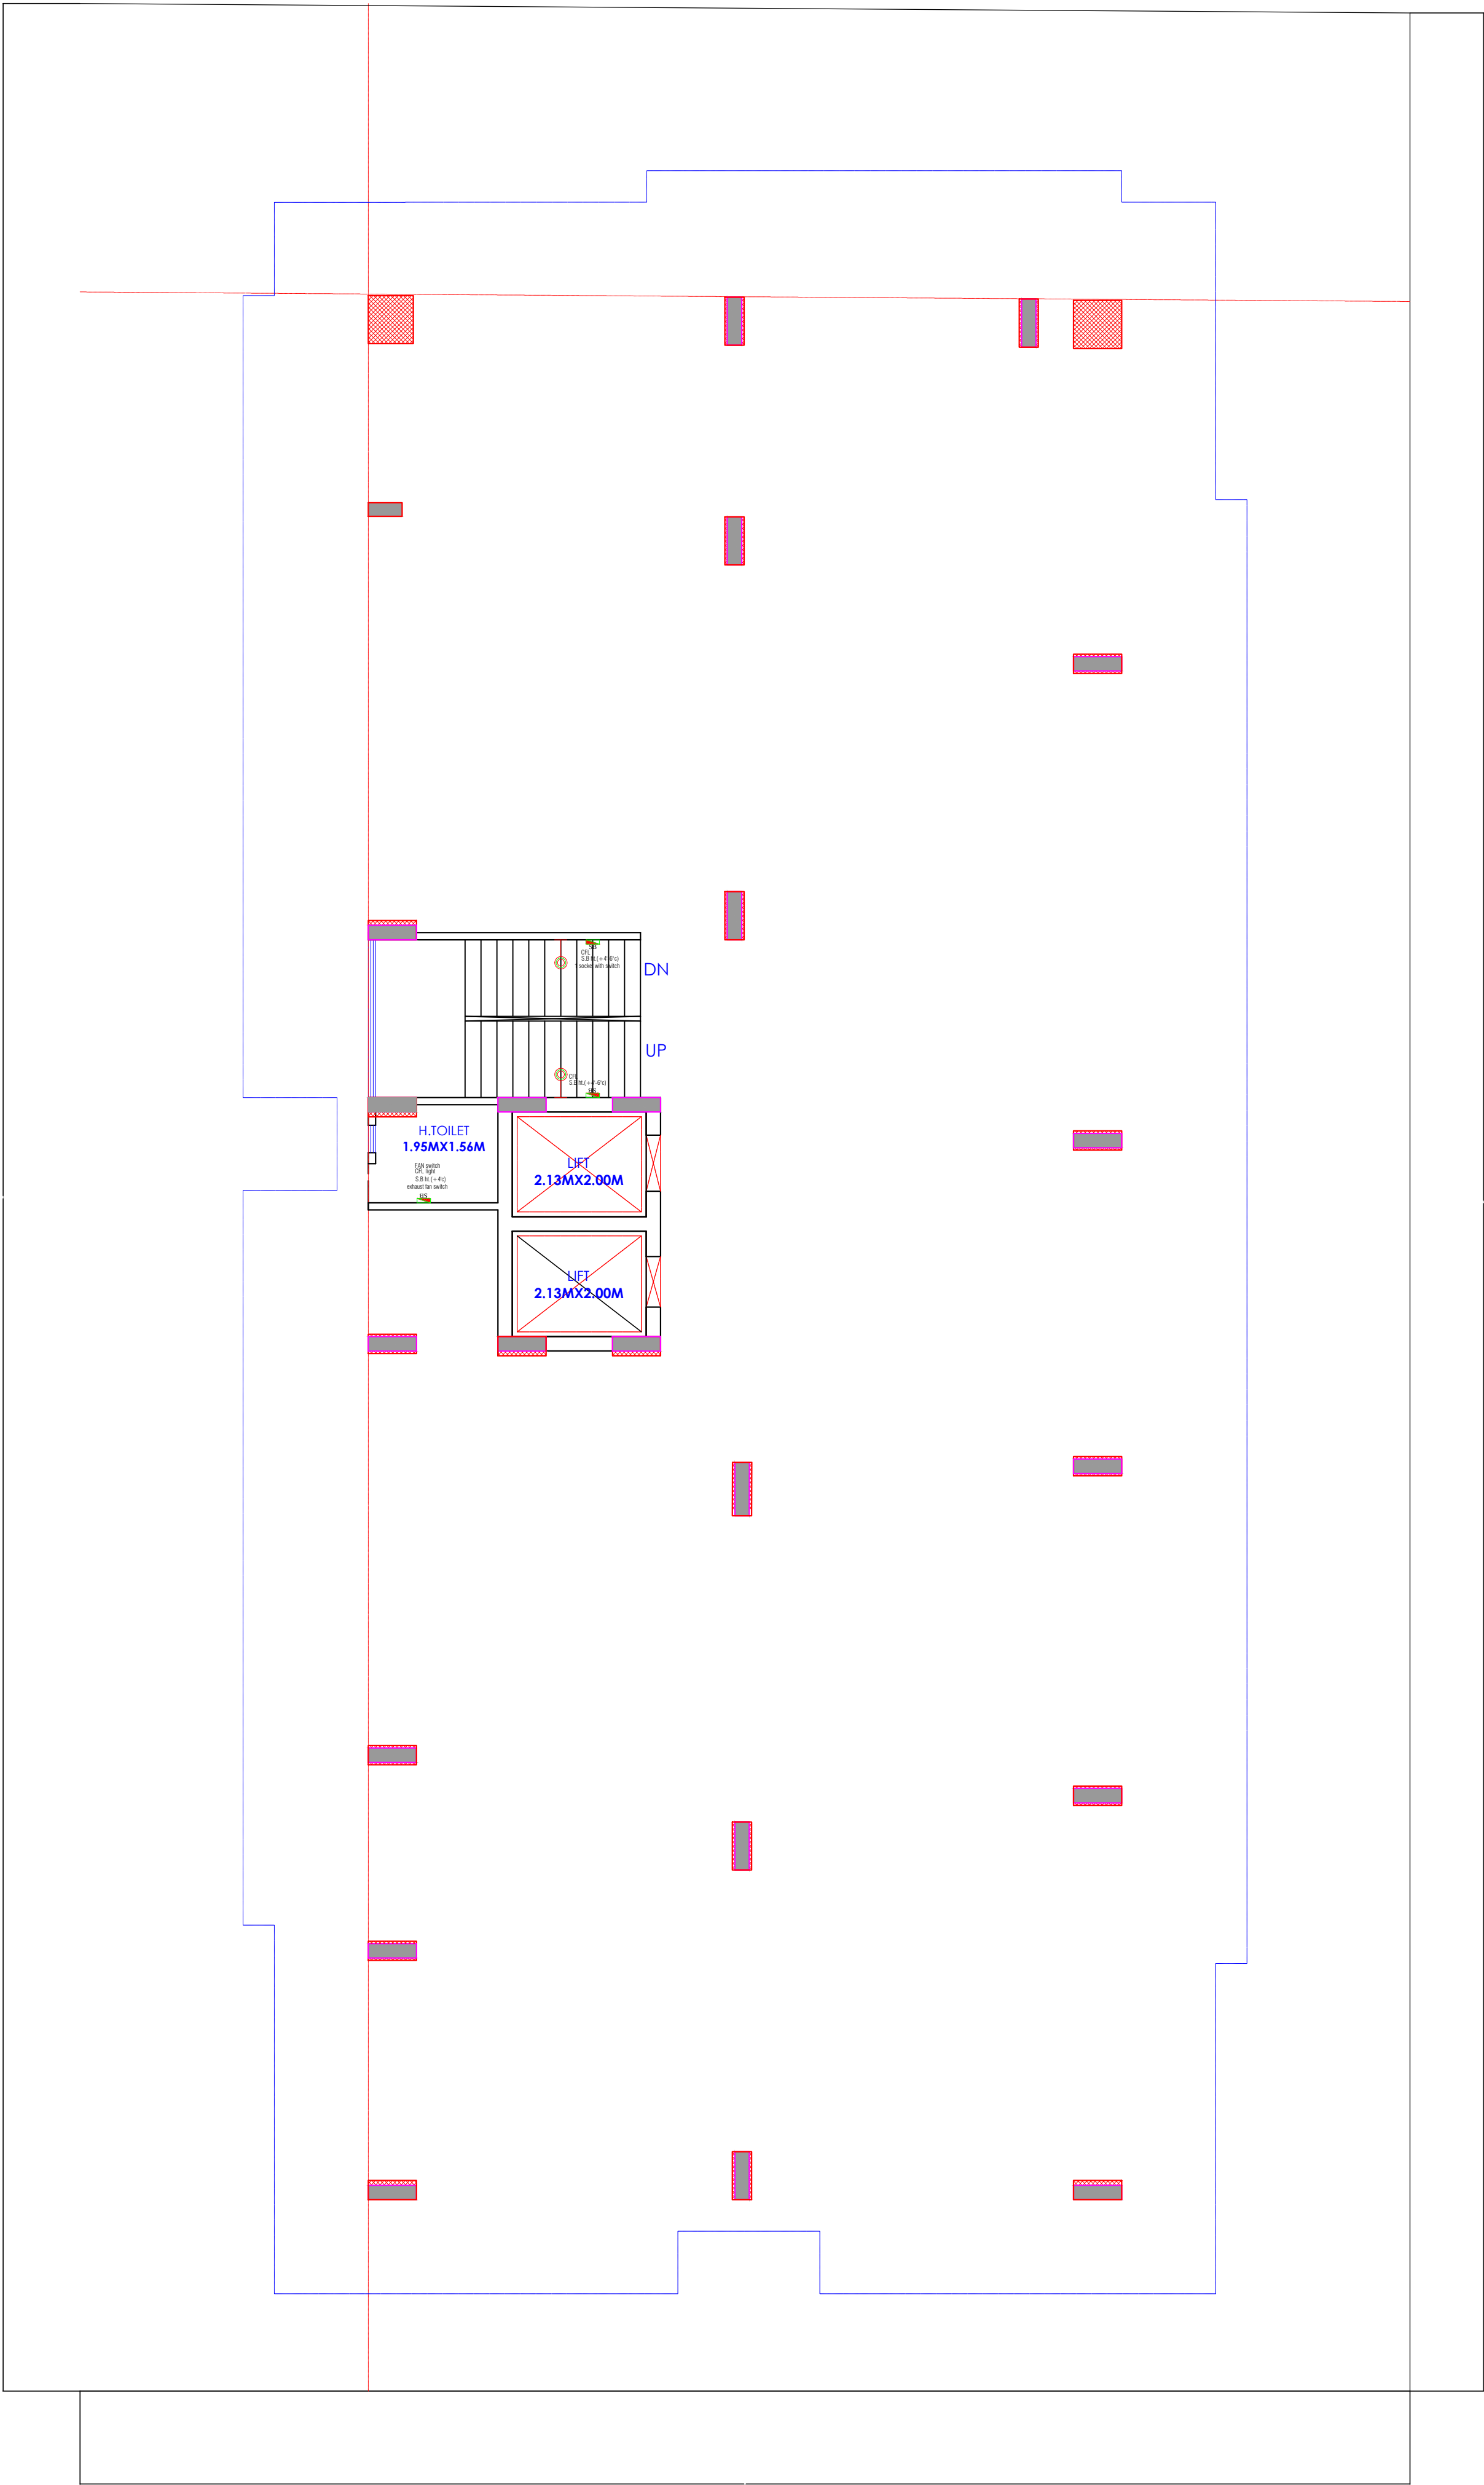

ROAD 30'-0" WIDE

H.T.LINE 132 KV (SAFETY CORRIDOR)

WARNING

1. This drawing is the sole copyright of Architects **VISTAAR** and should be used for the purpose expressly issued.

GENERAL NOTES

1. All dimensions are in feet and inches.
2. Do not scale this drawing follow written dimensions only.
3. This drawing should be read in conjunction with other architectural and structural drawings.
4. Any discrepancy in the drawing should be immediately brought to the notice of architect.

PROJECT TITLE

PROJECT:-
TOWN CREST -2
BUILDING AT PLOT-A-6, CHOPRA
ENCLAVE (GANPATPURA),
KIRTI NAGAR, JAIPUR

DRAWING TITLE

STILT FLOOR
WALL ELECTRICAL PLAN

ARCHITECTS :

VISTAAR ARCHITECTS & PLANNERS
Architects :: Interior Designers
B-2/12, Chitrakoot scheme,
main Gandhi Path, Opp mall of Jaipur, Jaipur
PH. - 0141-4116461, 09001010366

PATH :		DATE	REV.	NORTH
DRN.		06-03-2025		
SCALE	JOB NO.			
N.T.S				