


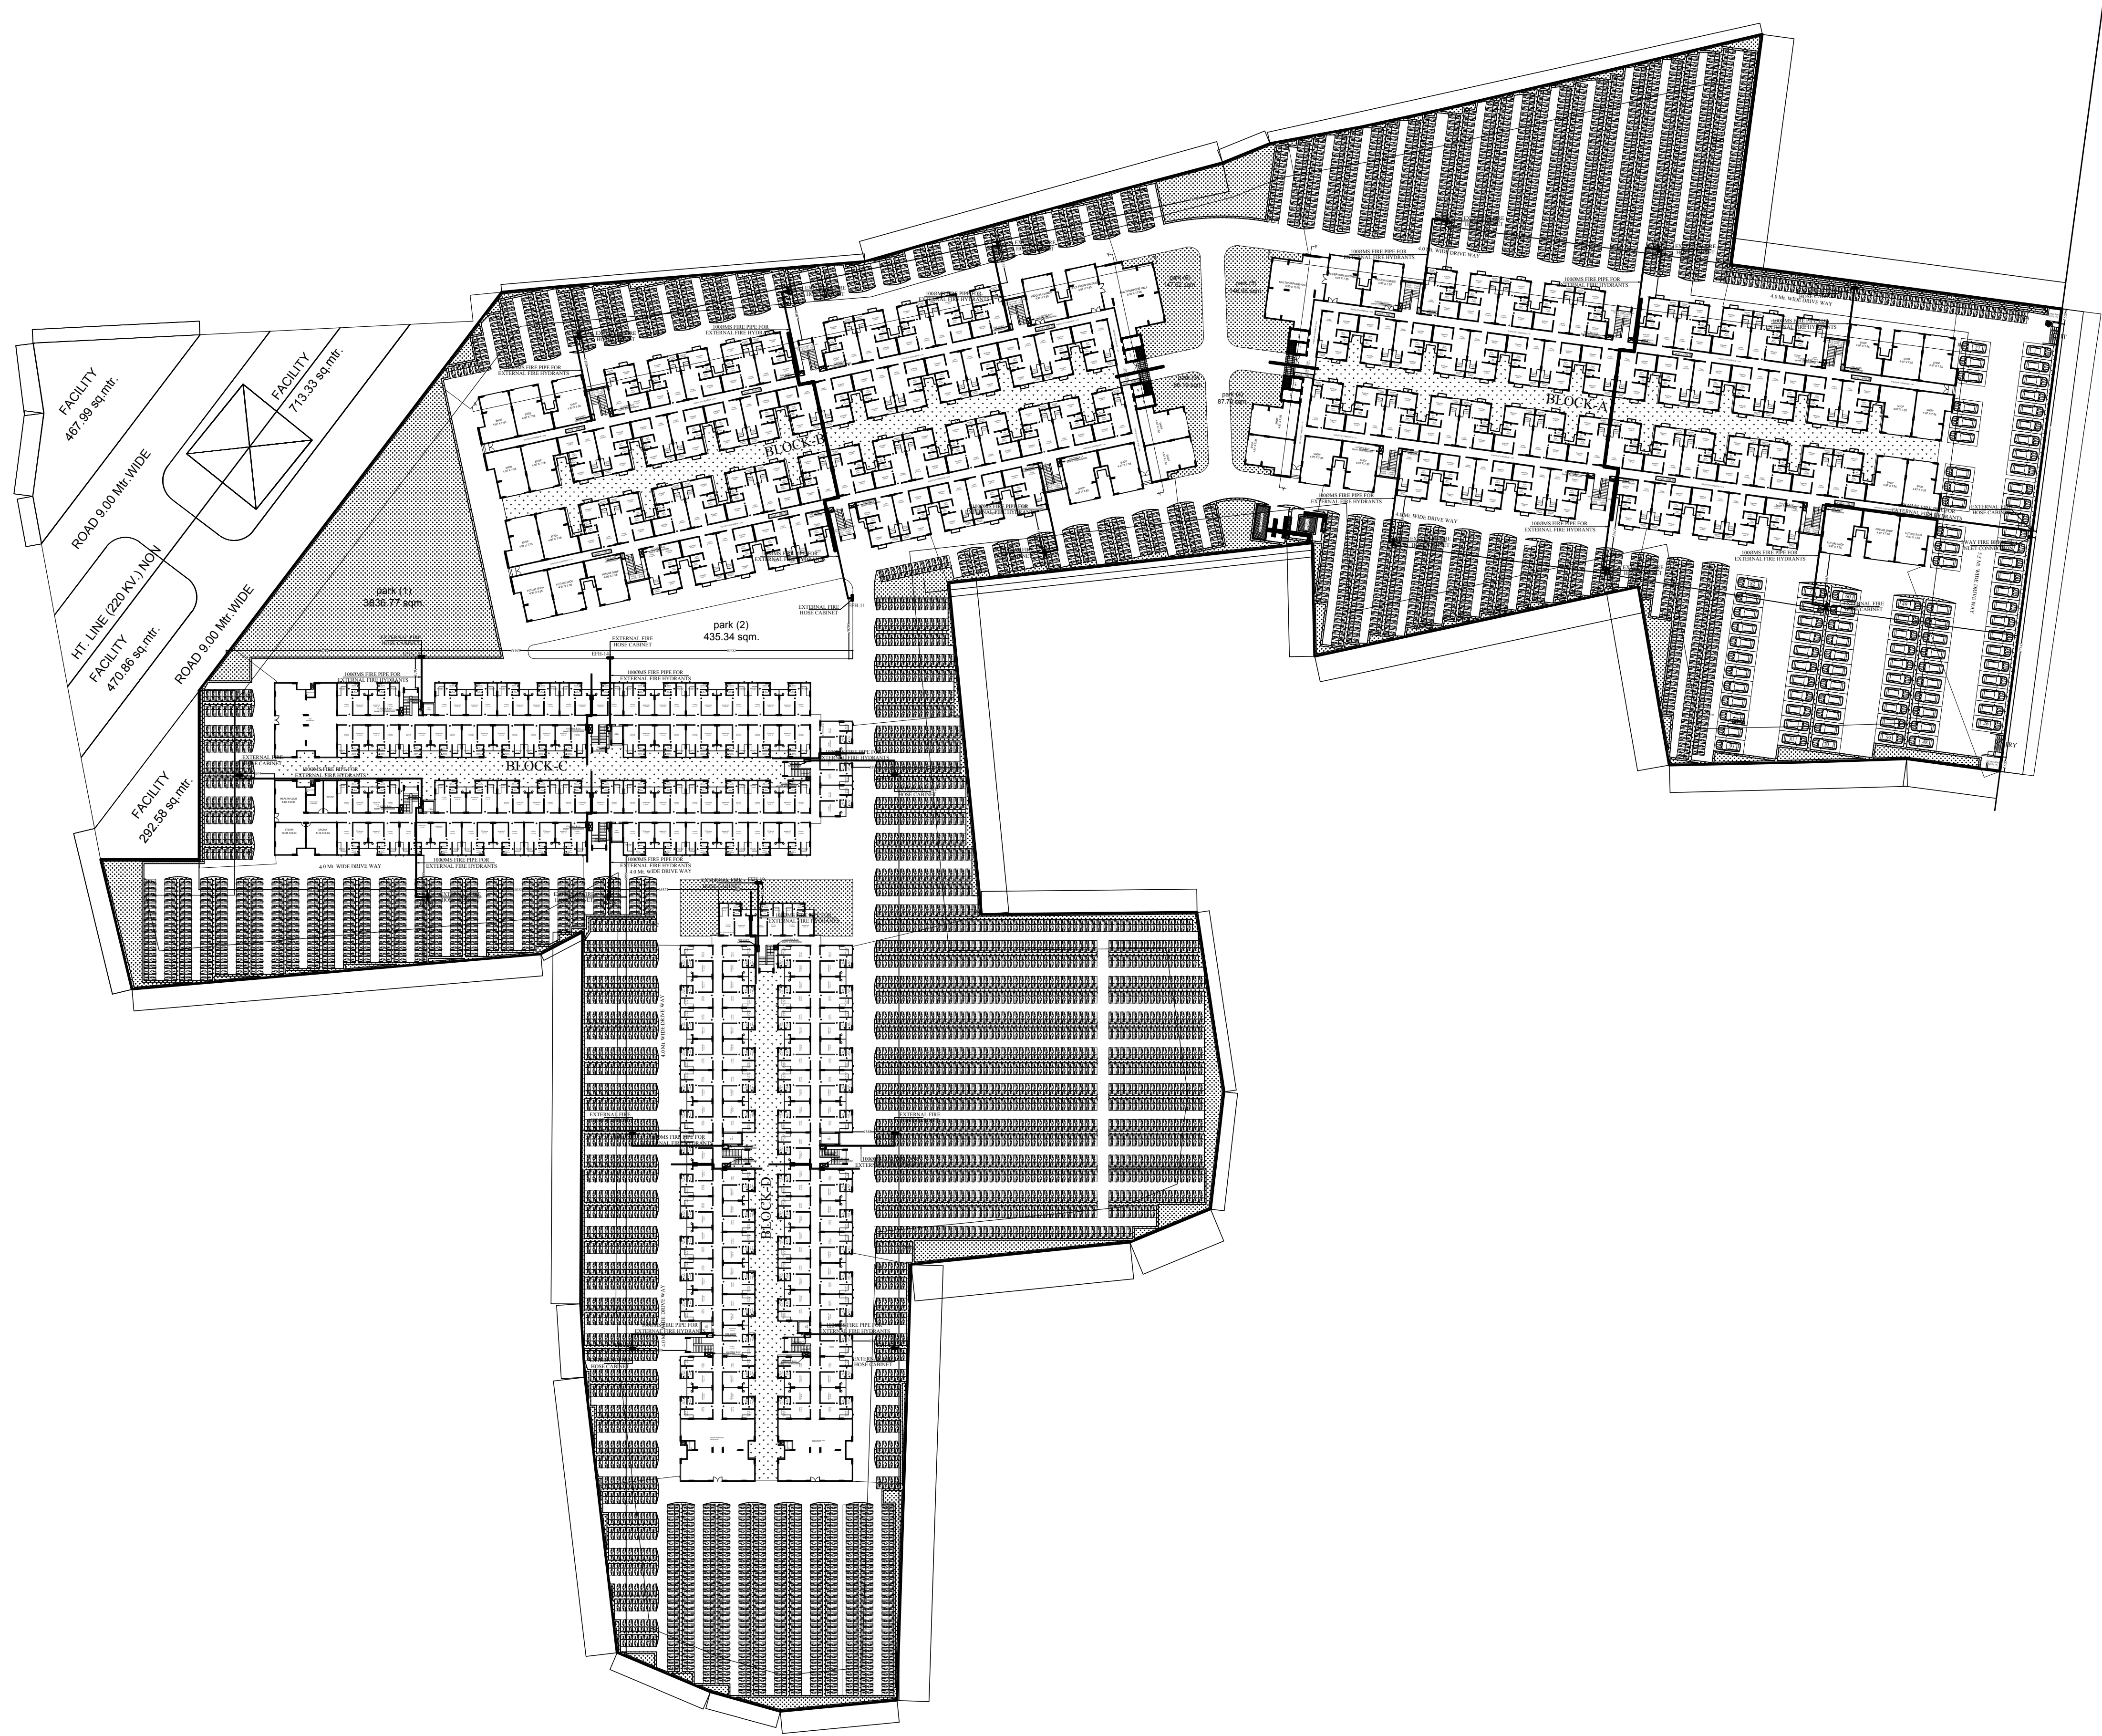


SECTOR ROAD 30.00 Mtr. WIDE

NAHAR 12.00 Mtr. WIDE

SECTOR ROAD 30.00 Mtr. WIDE

SITE PLAN

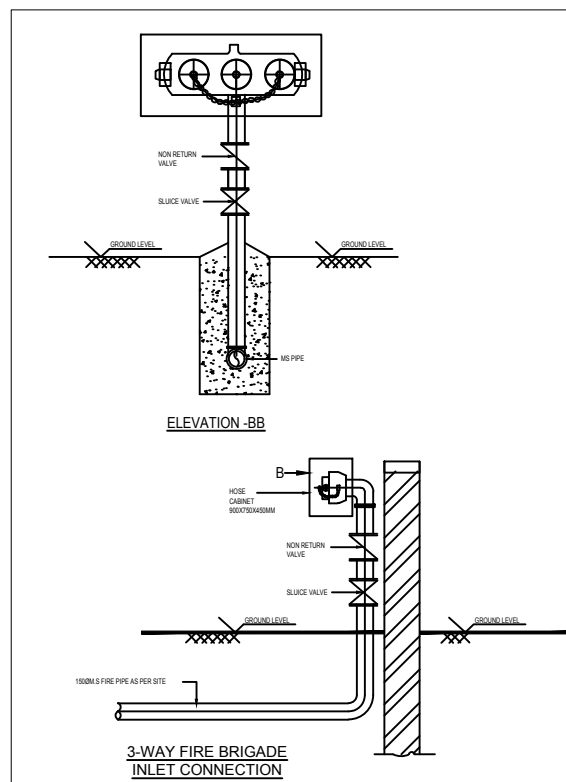

SYMBOL	QTY.	DESCRIPTION
		1000MS FIRE PIPE FOR EXTERNAL FIRE HYDRANTS
	22	FIRE HOSE CABINET
	23	EXTERNAL FIRE HOSE CABINET

PROJECT:-

VASUNDHARA
KUTUMB, BILWA

GENERAL NOTES:

1.0

All dimensions are in m unless noted otherwise

2.0

The dimensions are to be read and not scaled off the drawing.

3.0

Any discrepancy in the drawing shall be brought to the notice of the ARCHITECTS and shall not be changed or altered without the permission of the architect/engineer concerned.

4.0

This drawing is to be read in conjunction with other relevant drawings and specification given.

5.0

See enlarged floor plans and plan details for additional dimensions and partition types.

AREA ANALYSIS:

TOTAL PLOT AREA - 41508.73 SQ MT.
AREA UNDER SERVICE 9.0 MTR ROAD OF 220 KV HT LINE:- 2138.49 SQM.
AREA UNDER 30.0 MTR. WIDE ROAD - 475.0 SQM.
FACILITY AREA:- (713.33+467.99+470.86+292.58)=1944.76 SQM.
NET PLOT AREA:- 36948.48 SQM. (100 %)

KEY PLAN:

REVISION	DESCRIPTION	DATE

PURPOSE OF SENDING

☐

FOR REFERENCE

☒

FOR TENDER

☐

FOR APPROVAL

☐

FOR CONSTRUCTION

☐

FOR ESTIMATION

☐

AS BUILT

FOR TENDER

SERVICES CONSULTANT:
VIPUL CONSULTING,
F 9 / 440 , Keshav Marg, Chitrakut Scheme, Jaipur
PH: 91-0-83146-10438, 0141-2440946
Mail: vipul8599@yahoo.com
REV. NO. 00, Date:-11-07-2017

PROJECT:

PROPOSED HOUSING AT VILLAGE BILWA KALAN, TH. SANGANEER, JAIPUR KHASRANO. 78/2111, 79, 79/1, 80, 81, 82/2112, 83, 87, 164/2117, 169, 171, 172, 173, 174/1, 175/1, 176/1

DRAWING TITLE:

SITE EXTERNAL FIRE HYDRANT PLAN

DRAWING NO:

VAS-JAI/TD/AR-101

CLIENT:

MUKHYA MANTRI JAN AWAS YOJNA

DEVELOPER:

ABP AFFORDABLE HOUSING

PROJECT CODE

SCALE

1:300

DATE

11.07.2017

APPROVED BY

VIPUL AGARWAL

REVISION No.

NORTH:

N

CHECKED BY

SANJAY

DRAWN BY

VIJESH



ARCHITECT STAMP:

NOTE:-

This drawing is the sole property of ABP Affordable Housing. The drawing should not be reproduced, translated or transmitted in any form without prior permission from the proprietors.

ABP Affordable Housing

201-202, Geeta Enclave, Vinoba marg, C-Scheme, Jaipur

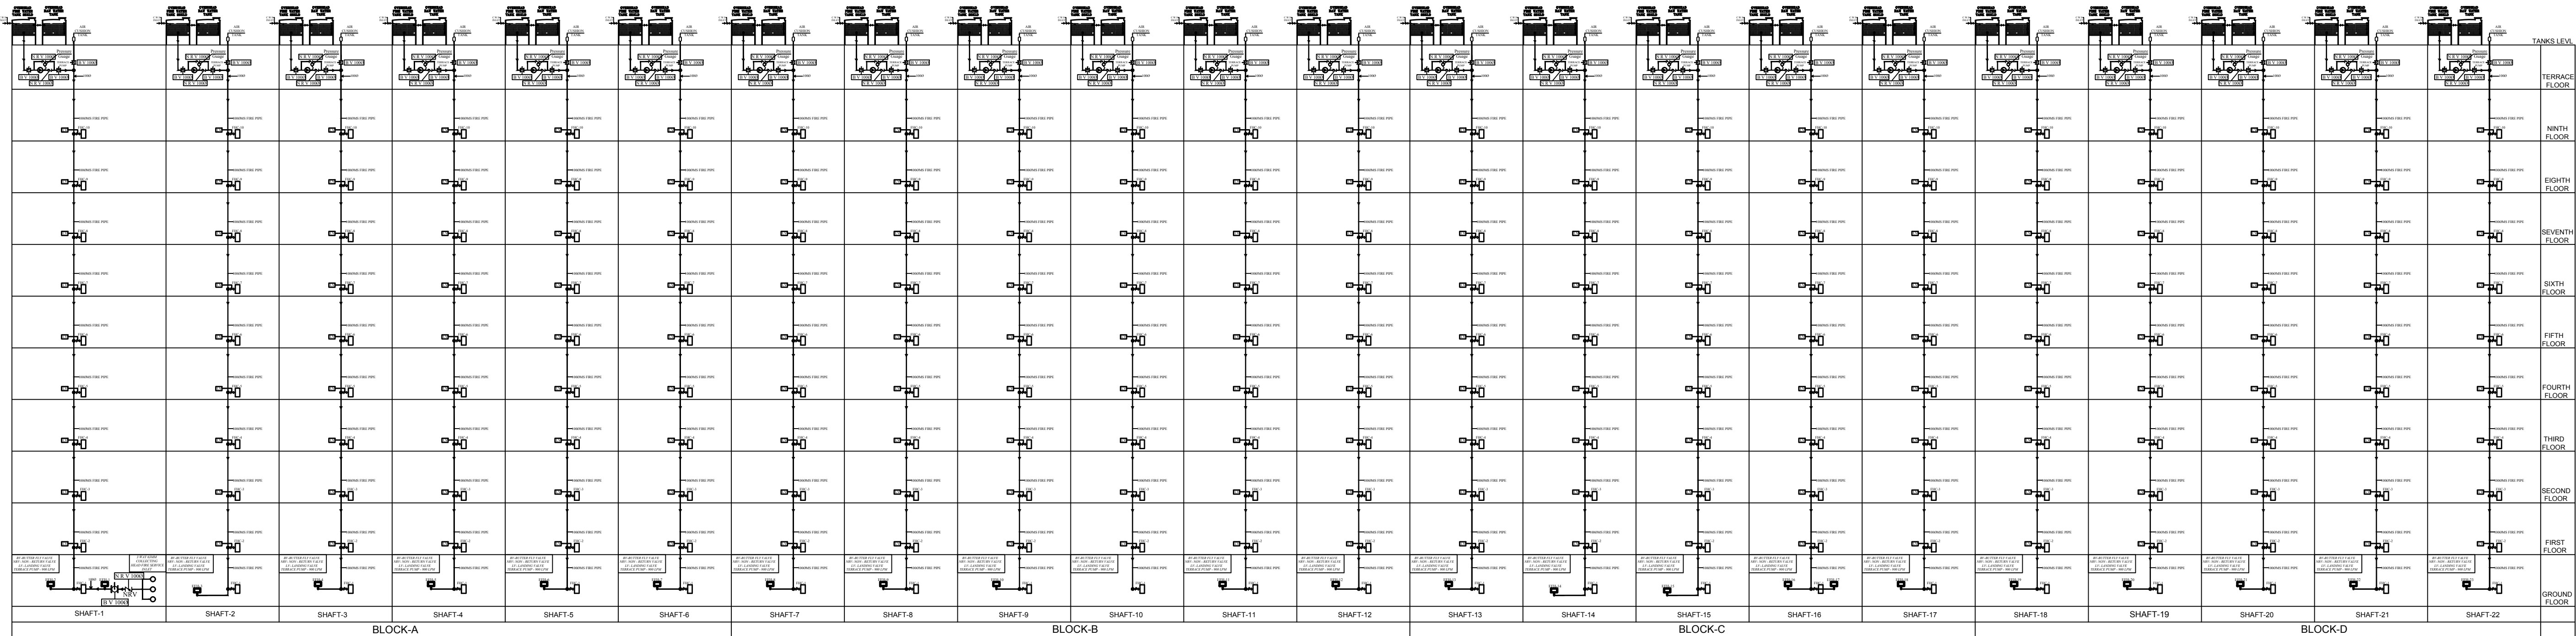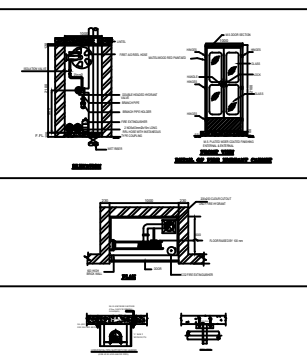

DRAWING			
S.No	Symbol	Description	Qty
1	[Symbol]	Water In Valve	67
2	[Symbol]	New Water Valve	45
3	[Symbol]	Landing Valve	229
4	[Symbol]	Pressure Gauge	21
5	[Symbol]	FIC	229
6	[Symbol]	Pressure Gauge	21

REVISIONS

No.	Description	Date
1	As per design	10/10/2023