


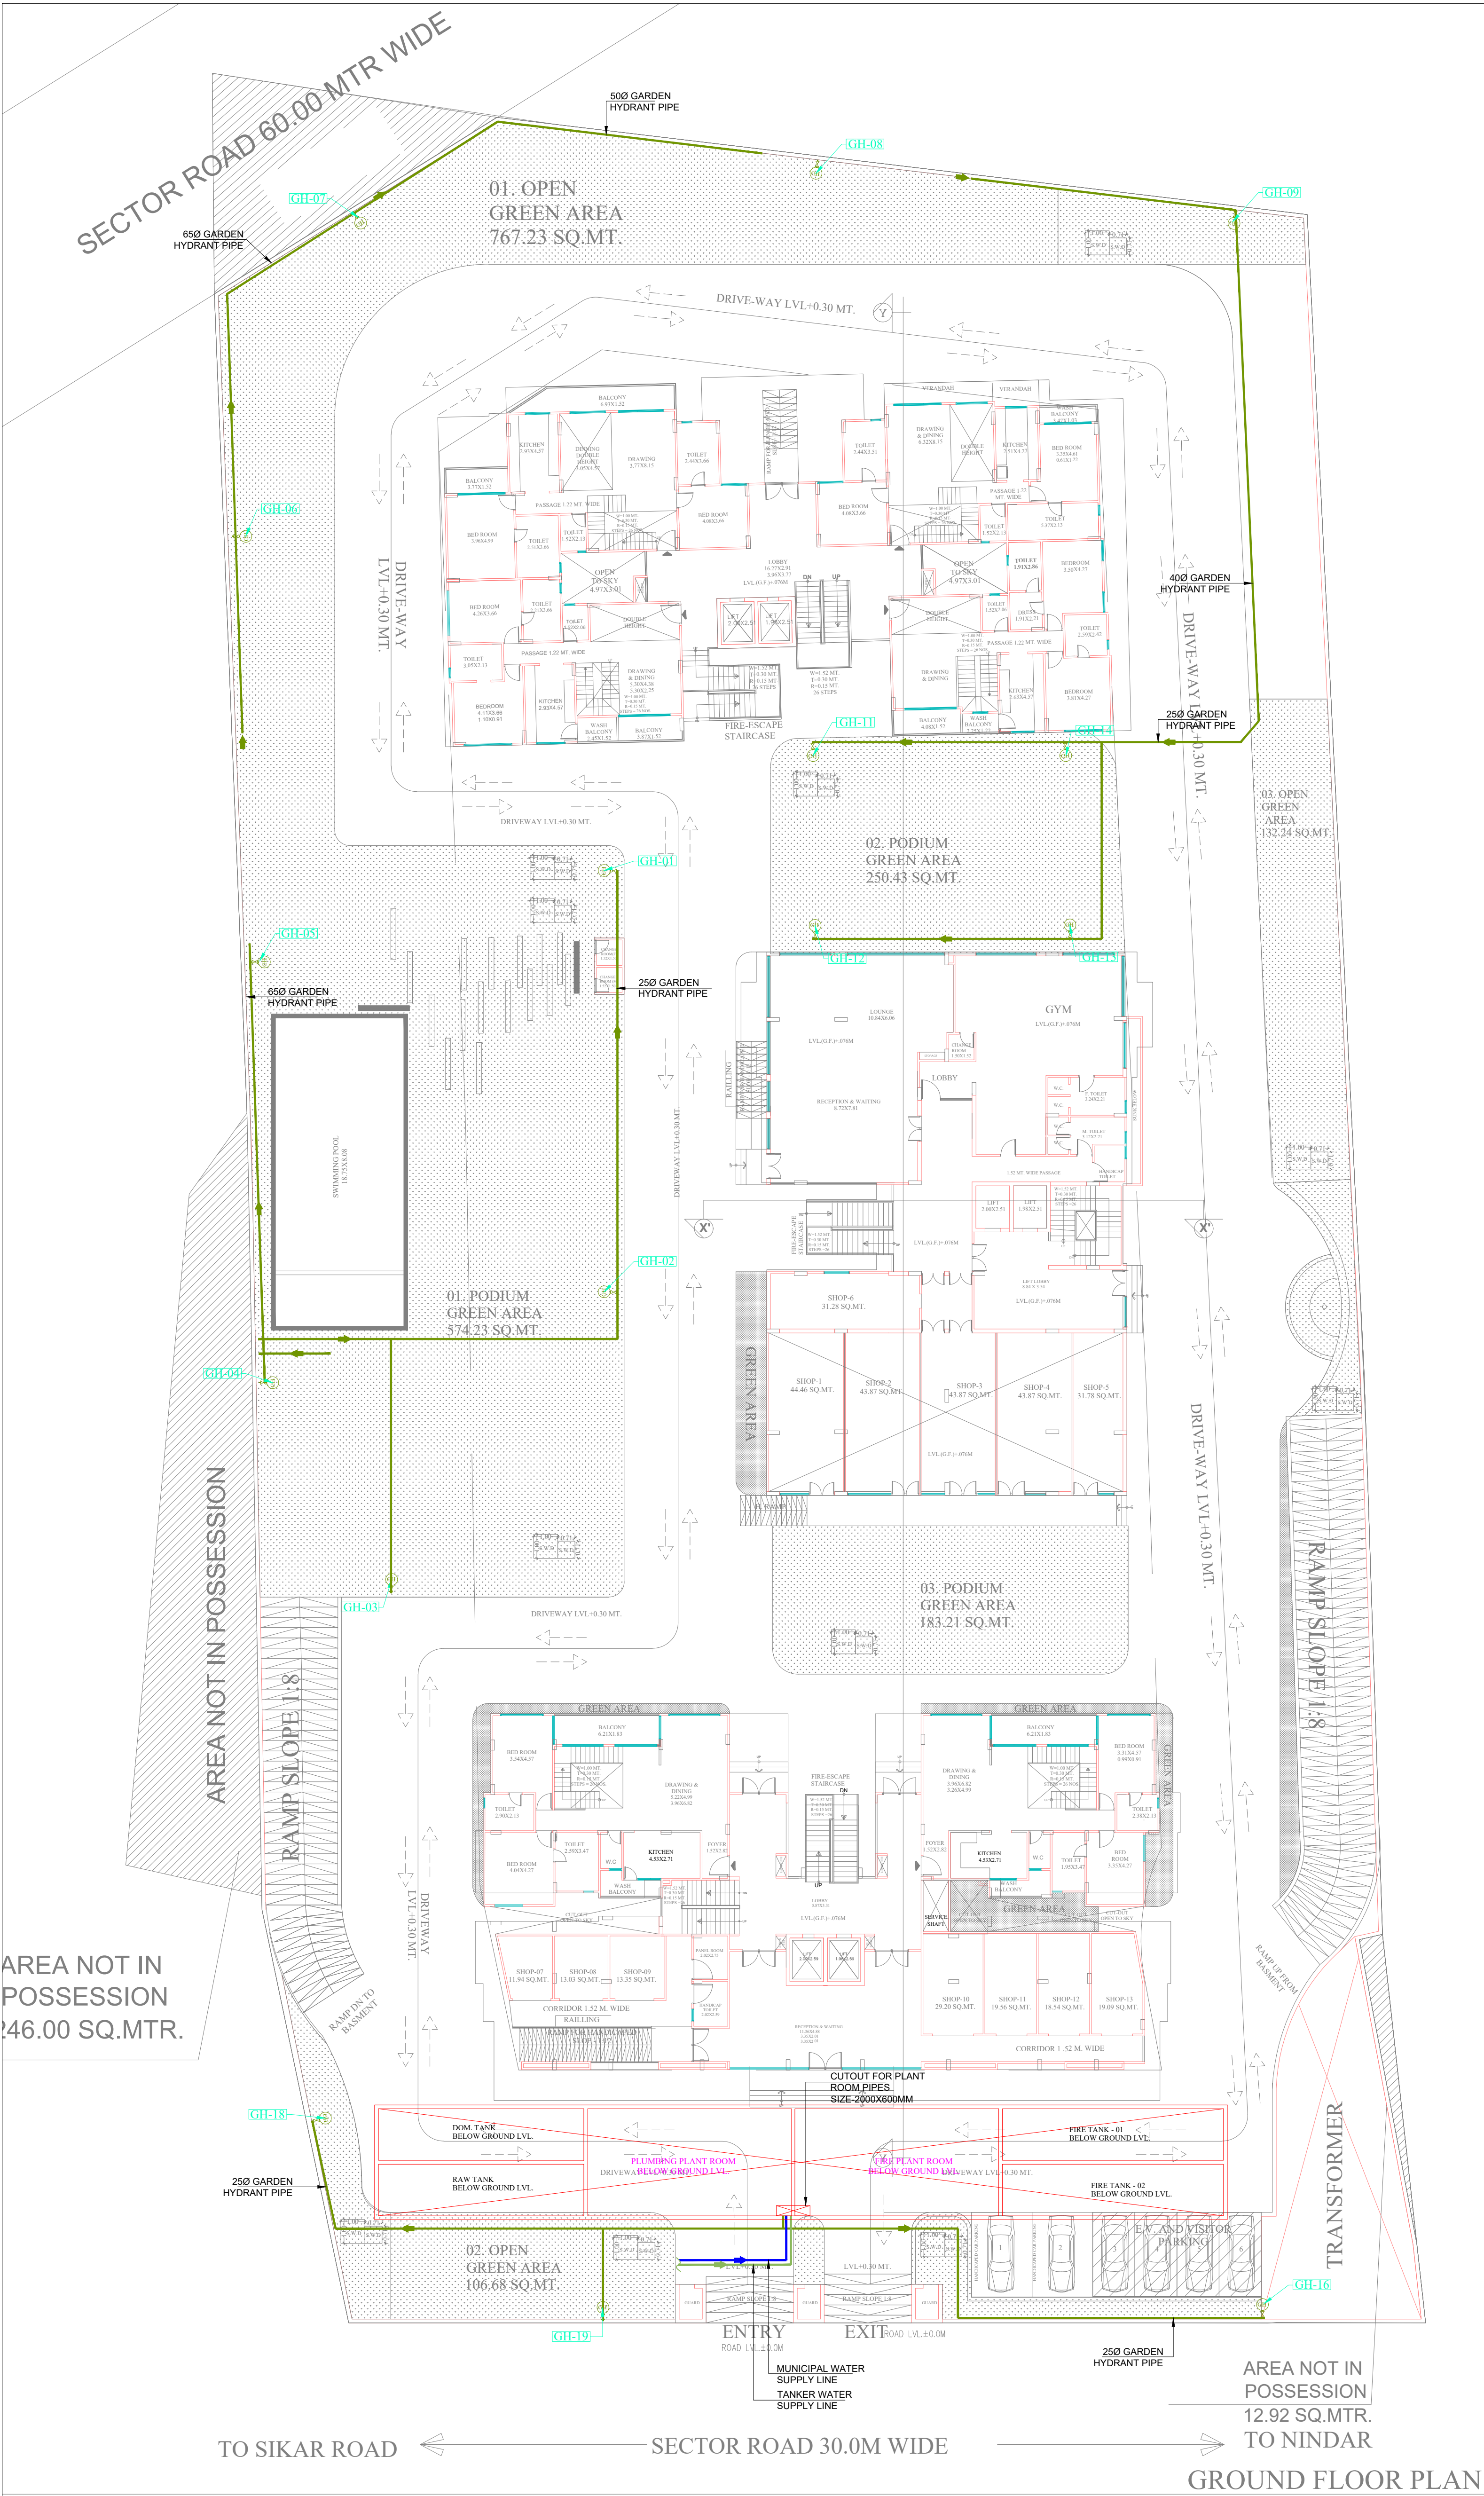

PLUMBING LEGEND:-		
MH	STORM WATER MANHOLE	
	STORM WATER MANHOLE	
	STORM LINE (RCC PIPE)	
	SEWER LINE	
	RAIN WATER HARVESTING PIT 3.0M DIA	
	DESILTING CHAMBER	
EFH	EXTERNAL FIRE HYDRANT	
FH	FIRE HYDRANT PIPE	
GHP	GARDEN HYDRANT PIPE	
GH	GARDEN HYDRANT	
MS	MUNICIPAL WATER SUPPLY LINE	
TW	TANKER WATER SUPPLY LINE	



MEP CONSULTANT
MJ Engineering Consultants Pvt. Ltd.
606, Madhuban Building,
55, Nehru Place, New Delhi -110019
Tel : 91-011-41051169 ;
E-mail : mjc@mjc.co.in ; mjecpl@gmail.com

SITE ADDRESS:-
PROPOSED GROUP HOUSING
AT KHASRA NO. 284/1, 287/1, 287
VILLAGE- MACHEDA, TEHSIL.AMER, JAIPUR

 
TITLE :-
GROUND FLOOR PLAN

\\IDEASNAS2\\mail\\Ideas Logo.jpg

124, HIMMAT NAGAR, TONK ROAD, JAIPUR
PHONE - 0141-2706227,2712377
email: ideasjaipur@gmail.com, web: www.ideasjaipur.com

SCALE -1:150

NORTH POINT



DRAWING TITLE
WATER SUPPLY LAYOUT
GROUND FLOOR PLAN

SCALE	1:200	STAGE	
DRAWN BY	JAGSEER	CHECKED BY	A.K
DATE	01.06.2026	APPROVED BY	A.K

DWG. NUMBER
25-683-PL-02




REVISION

WATER SUPPLY SCHEMATIC (DUAL PLUMBING SYSTEM)



SCHEMATIC DIAGRAM OF WATER SUPPLY

LEGEND : (Plumbing)		
S. No.	SYMBOL	DESCRIPTION
1.		DOMESTIC WATER SUPPLY PIPE
2.		FLUSHING WATER SUPPLY PIPE
3.		DOMESTIC WATER SUPPLY PIPE (TOP THREE FLOOR)
4.		BALL VALVE TYPE ISOLATING VALVE
5.		NON RETURN VALVE
6.		Y TYPE STRAINER
7.		PRV

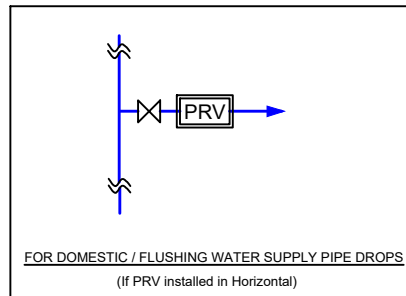

rev. no.	date	revision

Project
PROPOSED GROUP HOUSING
AT KHASRA NO. 284/1, 287/1,
287
VILLAGE - MACHEDA, TEHSIL, AMER
JAIPIUR

Title
PLUMBING EC SUBMISSION DRAWING

Subtitle
WATER SUPPLY SCHEMATIC (DUAL PLUMBING)

RERA SUBMISSION

Drawing Released for
☐ APPROVAL ☒ SUBMISSION
☐ ADVANCE COPY ☐ CONSTRUCTION

Org. no. 25-683-SLD Drawn by J.K

Scale NTS Designed by J.K

Date 18.06.2025 Checked by A.K

Architects

ideas
SHEKHAWAT & ASSOCIATES ARCHITECTS PVT. LTD.
254, Industrial Nagar, Tonk Road, Jaipur (Raj) India
Ph: +91 141-276227, 270237, 270580
Email: ideas@ideasapp.com | www.ideasapp.com

MEP CONSULTANTS :
M J ENGINEERING CONSULTANTS PVT. LTD.
606, Nidhuban Building,
55, Nehru Place, New Delhi - 110019
Ph: +91-11-41051169
Email: - mjecpl@gmail.com