
 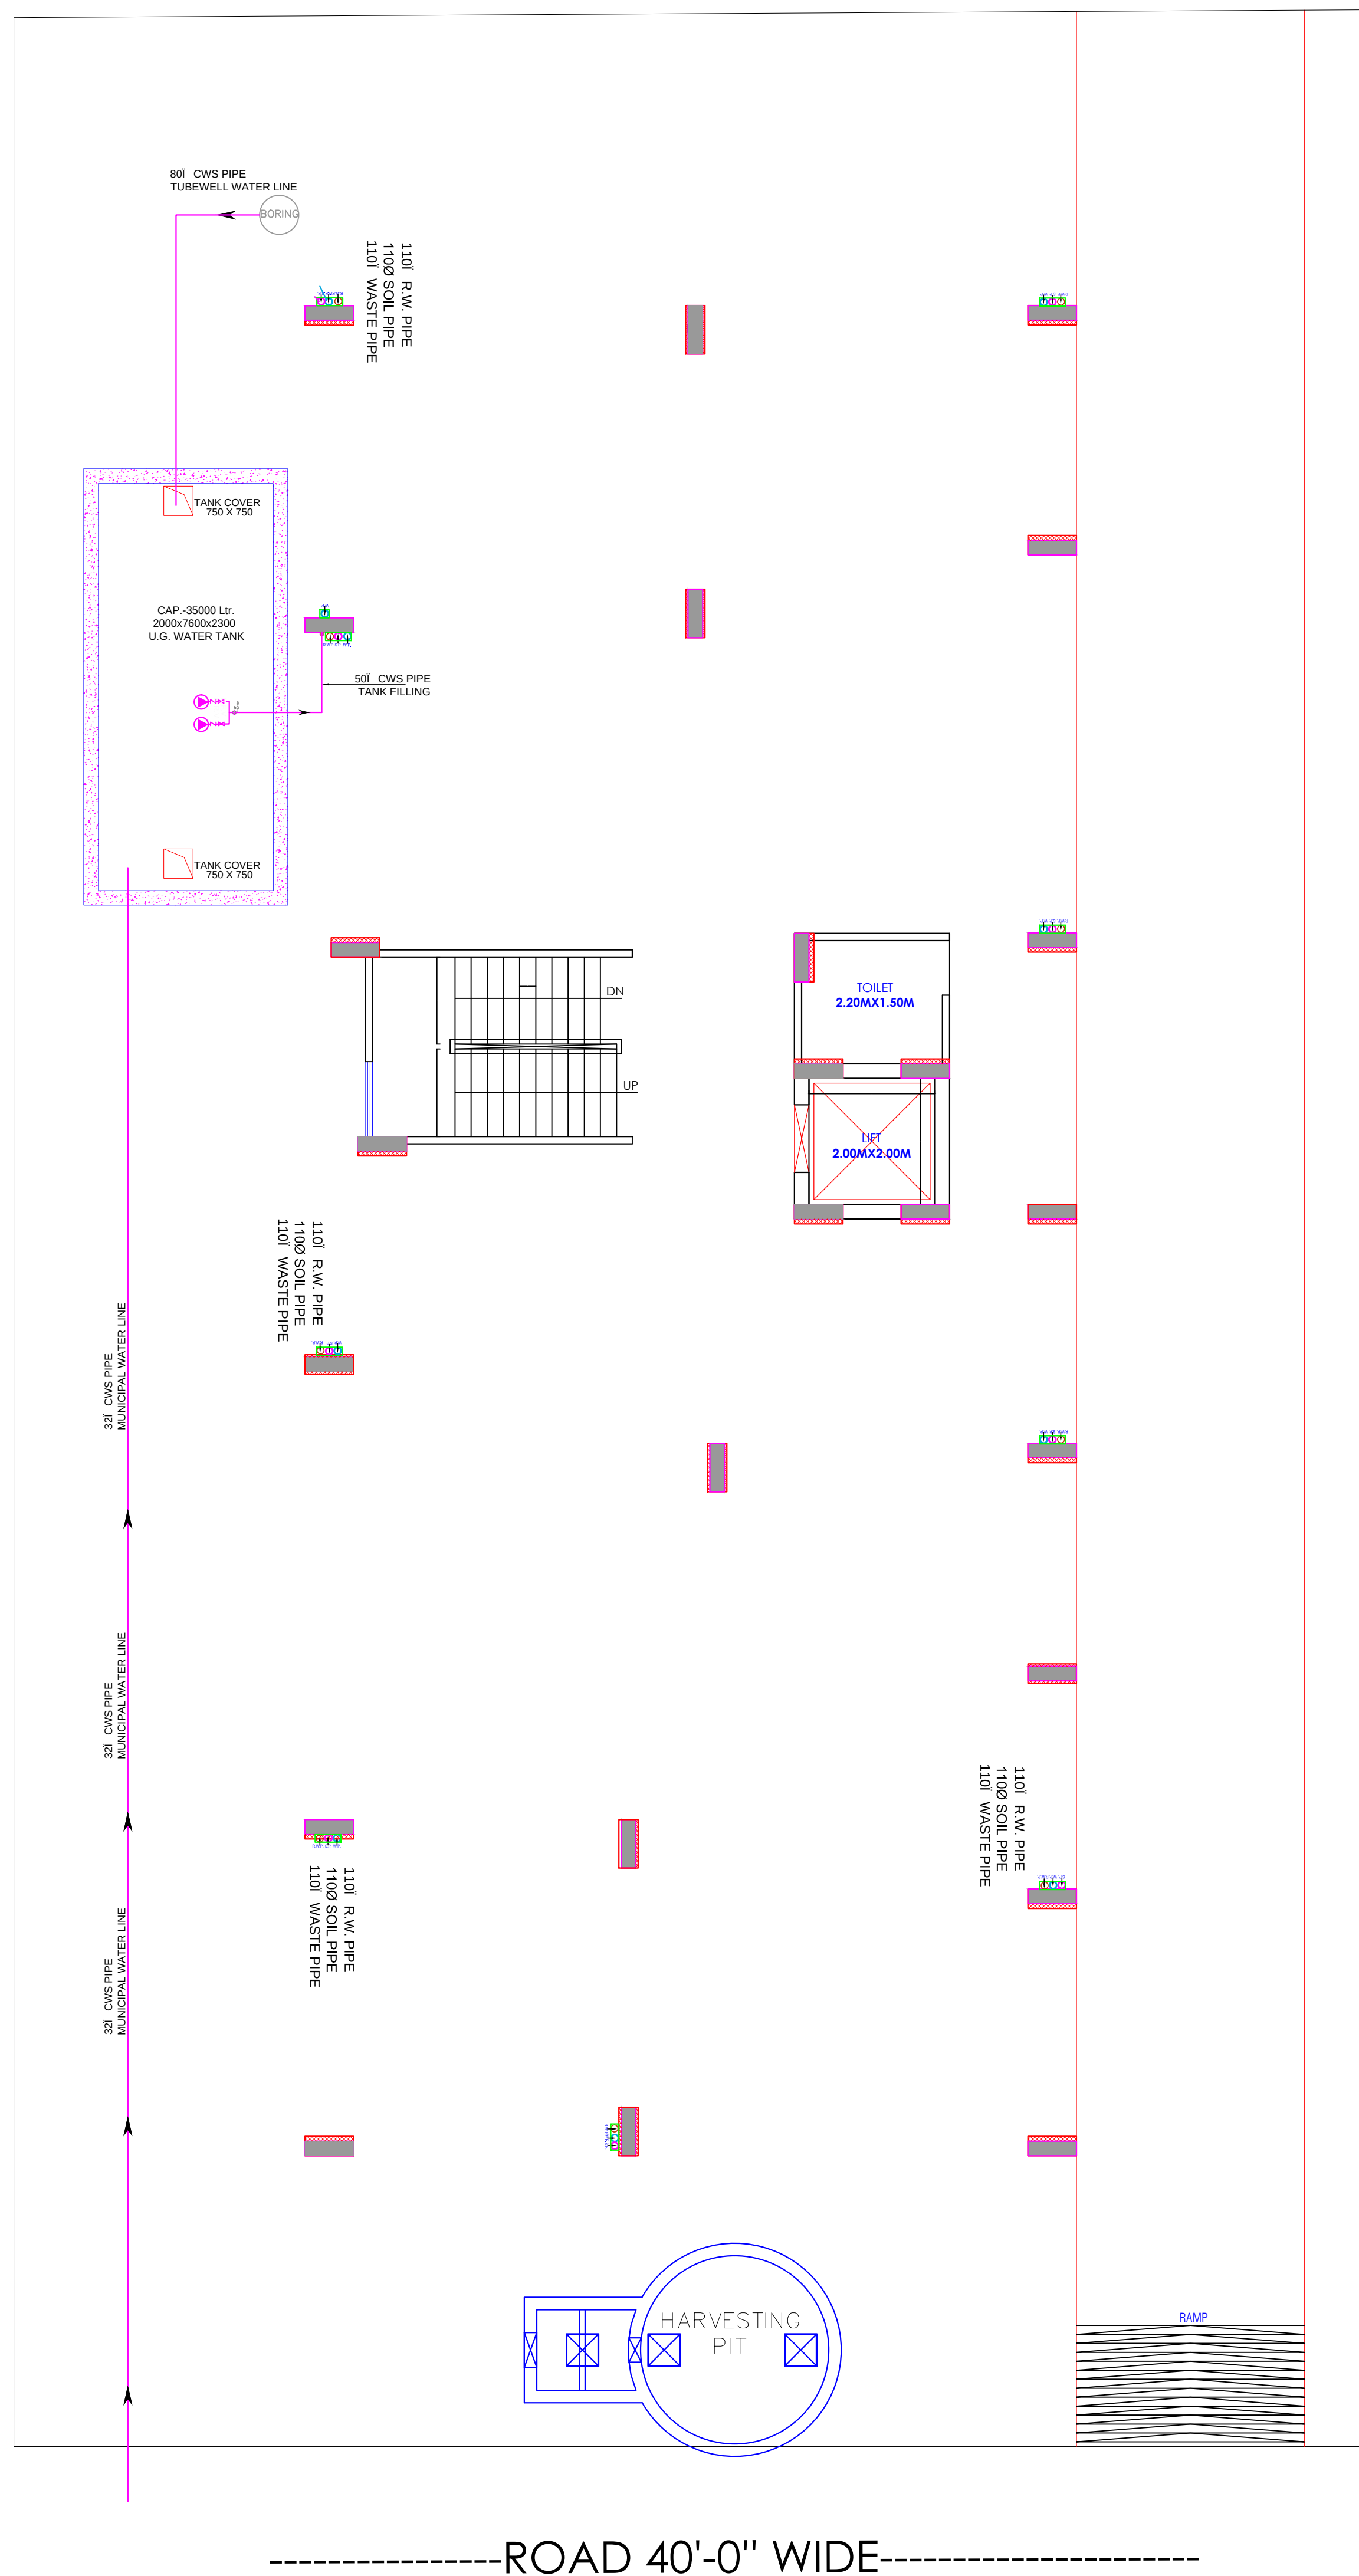




①	RAIN WATER PIPE		
②	WEST WATER PIPE		
③	SOILWATER PIPE		
④	 INSPECTION CHAMBER / GULLY TRAP		26" DEPTH
⑤	 MAN HOLE		26" DEPTH
⑥	 ELECTRICAL PIPELINE		

LEGENDS		
S.NO.	SYMBOL	DESCRIPTION
1.		SDR-11 Fresh Water Pipe
2.		SDR-11 Solar Water Pipe
3.		Waste Water Pipe (W.P.)
4.		Soil Pipe (S.P.)
5.		Rain Water Pipe (R.W.P.)
6.		Butter Fly Valve (B.F.V.)
7.		Geyser
8.		RO
9.		Single Lever Diverter
10.		Concealed Valve
11.		Angle Valve
12.		Nahani Trap
13.		P-Trap
14.		Tap
15.		Floor Drain (F.D.)
16.		Plain Tee (P-tee)
17.		Gully Trap (G.T.)
18.		

WARNING

1. This drawing is the sole copyright of Architects VISTAAR and should be used for the purpose expressly issued.

GENERAL NOTES

1. All dimensions are in feet and inches.
2. Do not scale this drawing follow written dimensions only.
3. This drawing should be read in conjunction with other architectural and structural drawings.
4. Any discrepancy in the drawing should be immediately brought to the notice of architect.

LUCKY HEIGHTS - 5
BUILDING AT PLOT-B-177,(N.P),B-177(M.P)&
B-177(S.P),ACHARYA VINOBA BHAVE NAGAR OF
JAWAHAR PURI BHAWAN GNSS,JAIPUR

DRAWING TITLE


STILT FLOOR PLAN
COMMON AREA WATER SUPPLY PLAN

ARCHITECTS :

VISTAAR ARCHITECTS & PLANNERS

Architects :: Interior Designers
B-2/12, Chitrkoot scheme,
main Gandhi Path, Opp mall of Jaipur, Jaipur-21
Email-Vistaararchitects.web@gmail.com
PH.- 0141-4116461, 09001010366

PATH :-			
DRN.	DATE	REV.	NORTH
MANOJ KUMAWAT	06-10-2024		
SCALE	JOB NO.		
N.T.S			

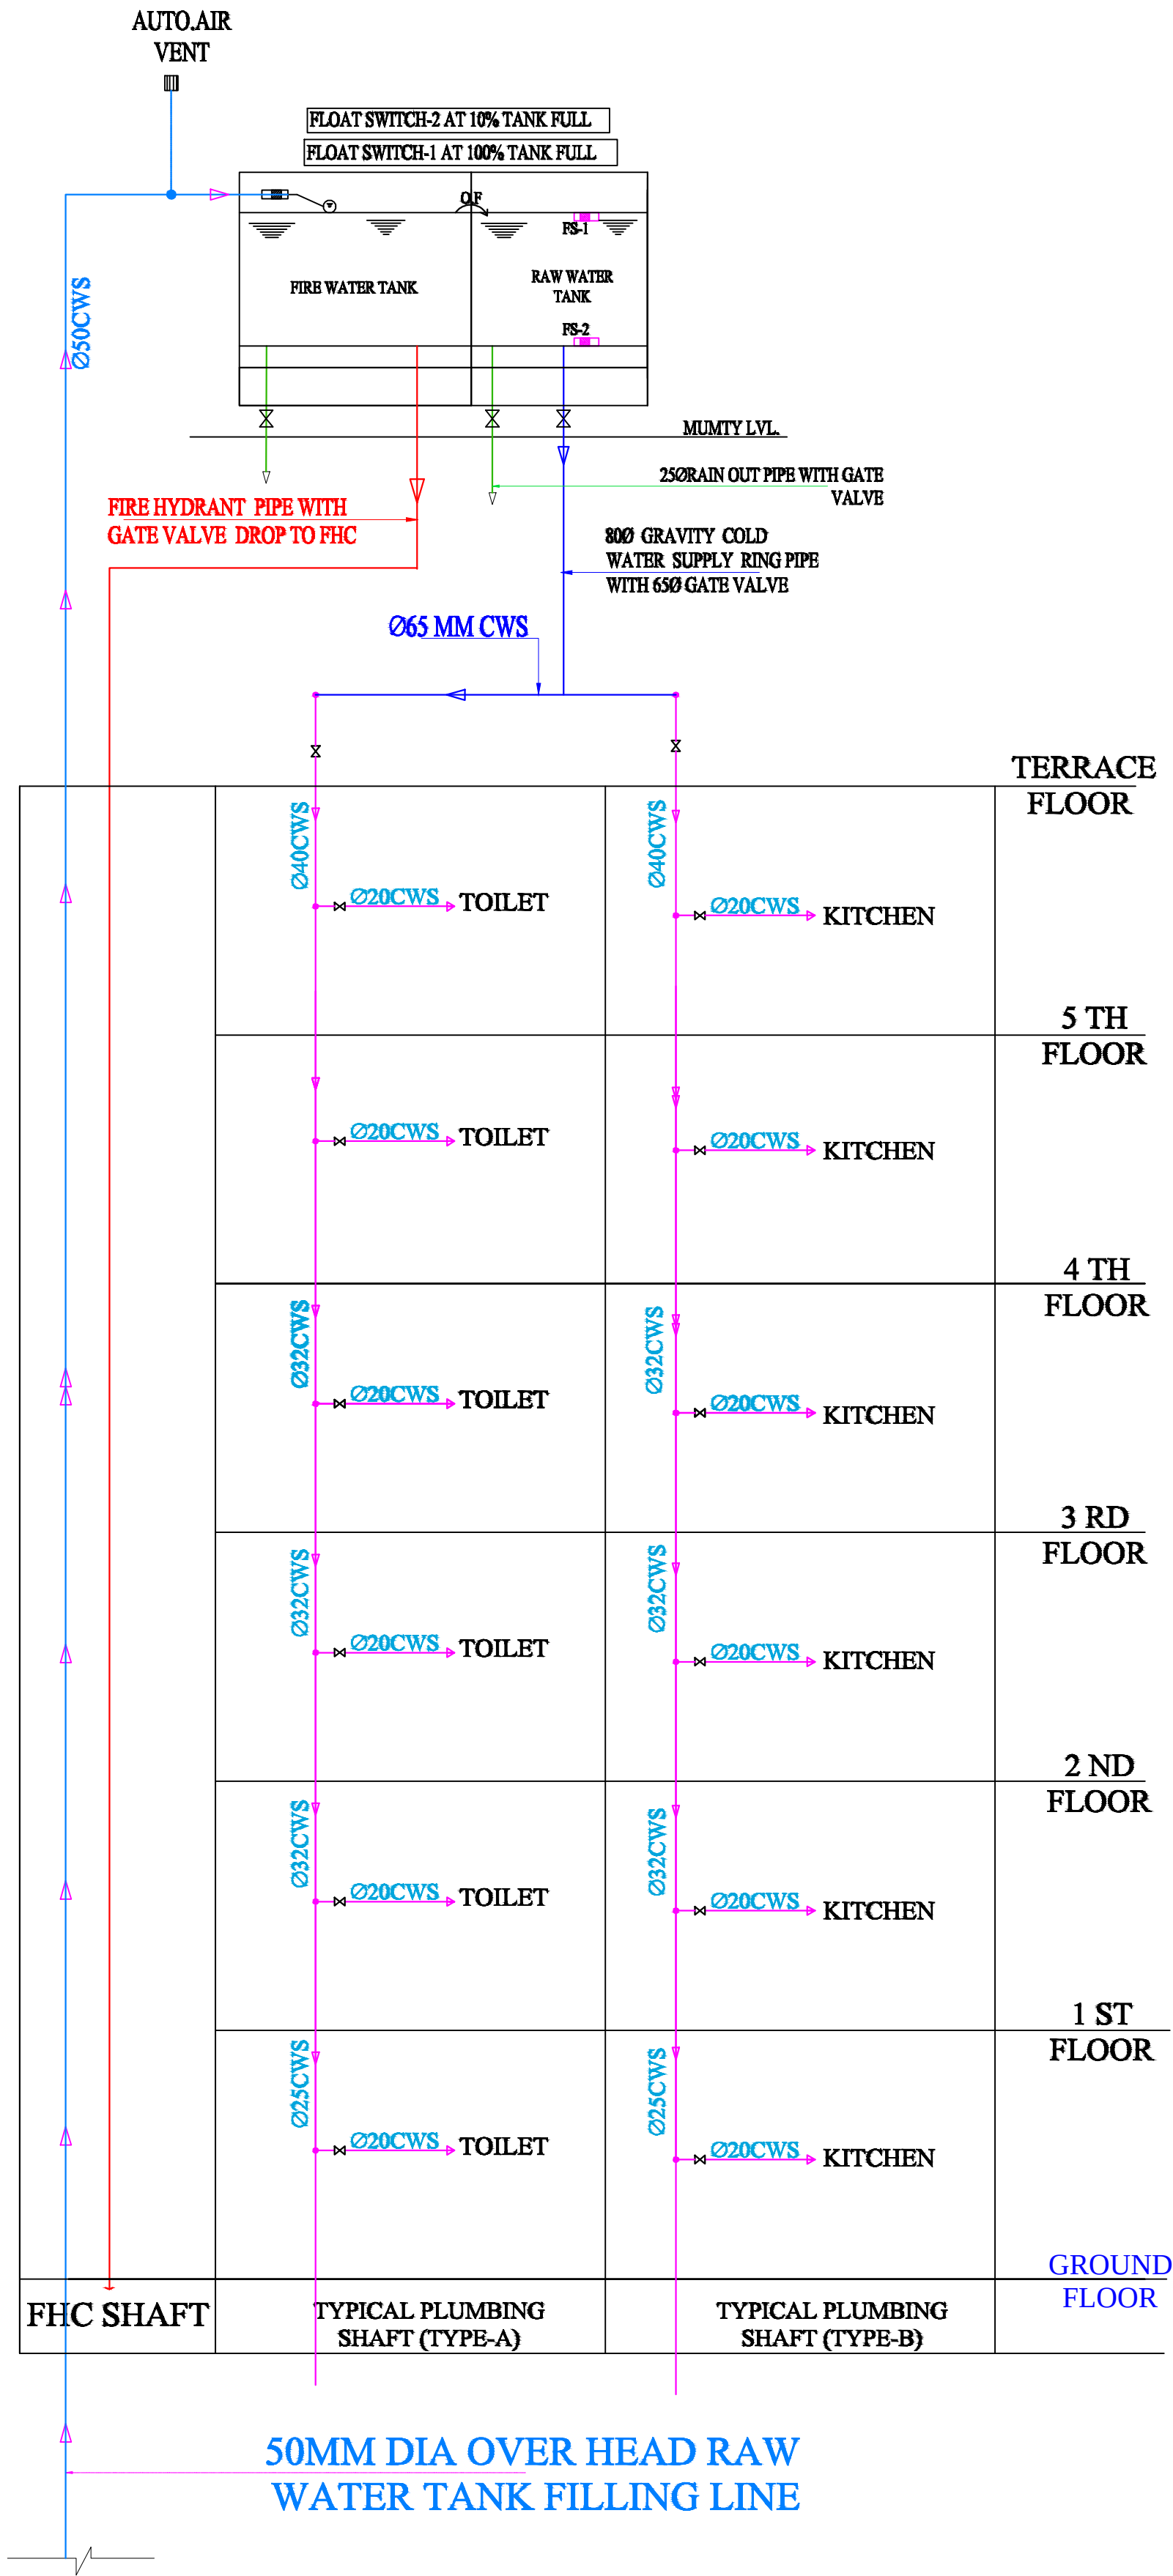

Krishna
KRISHNA KUMAR
B. Tech. (Mechanical)
M.E.P Consultant

For YASHASWI CONSTRUCTION
Proprietor

WARNING
1. This drawing is the sole copyright of Architects VISTAAR and should be used for the purpose expressly issued.

GENERAL NOTES
1. All dimensions are in feet and inches.
2. Do not scale this drawing follow written dimensions only.
3. This drawing should be read in conjunction with other architectural and structural drawings.
4. Any discrepancy in the drawing should be immediately brought to the notice of architect.

PROJECT TITLE
LUCKY HEIGHTS - 5
BUILDING AT PLOT-B-177, (N.P), B-177 (M.P) &
B-177 (S.P), ACHARYA VINOBA BHAVE
NAGAR OF JAWAHAR PURI
BHAWAN GNSS, JAIPUR

DRAWING TITLE
WATER SUPPLY DIAGRAM

ARCHITECTS :
VISTAAR ARCHITECTS &
PLANNERS
Architects :: Interior Designers
B-2/12, Chitrkoot scheme,
main Gandhi Path, Opp mall of jaipur, Jaipur
PH. - 0141-4116461, 09001010366

DATE	REV.	NORTH
03-12-2024		
SCALE	JOB NO.	
N.T.S		