


LEGEND:-	
	Ø6" SOIL WASTE PIPE
	Ø6" WASTE WATER PIPE
	Ø4" SOIL WASTE PIPE
	Ø4" WASTE WATER PIPE
	Ø4" RAIN WATER PIPE
	Ø3" VENT PIPE
	Ø6" SOIL WASTE WATER PIPE
	Ø6" WASTE WATER PIPE
	Ø6" RAIN WATER PIPE
	Ø4" SOIL WASTE WATER PIPE
	Ø4" WASTE WATER IPE
	Ø4" RAIN WATER PIPE
	Ø3" VENT PIPE
	CLEAN OUT POINT

Project Address:-

Situated at Khasra Numbers 785, 790, 791, Village Jaisinghpura Bas
Bhankrota, Tehsil Sanganer, Jaipur, 302026.

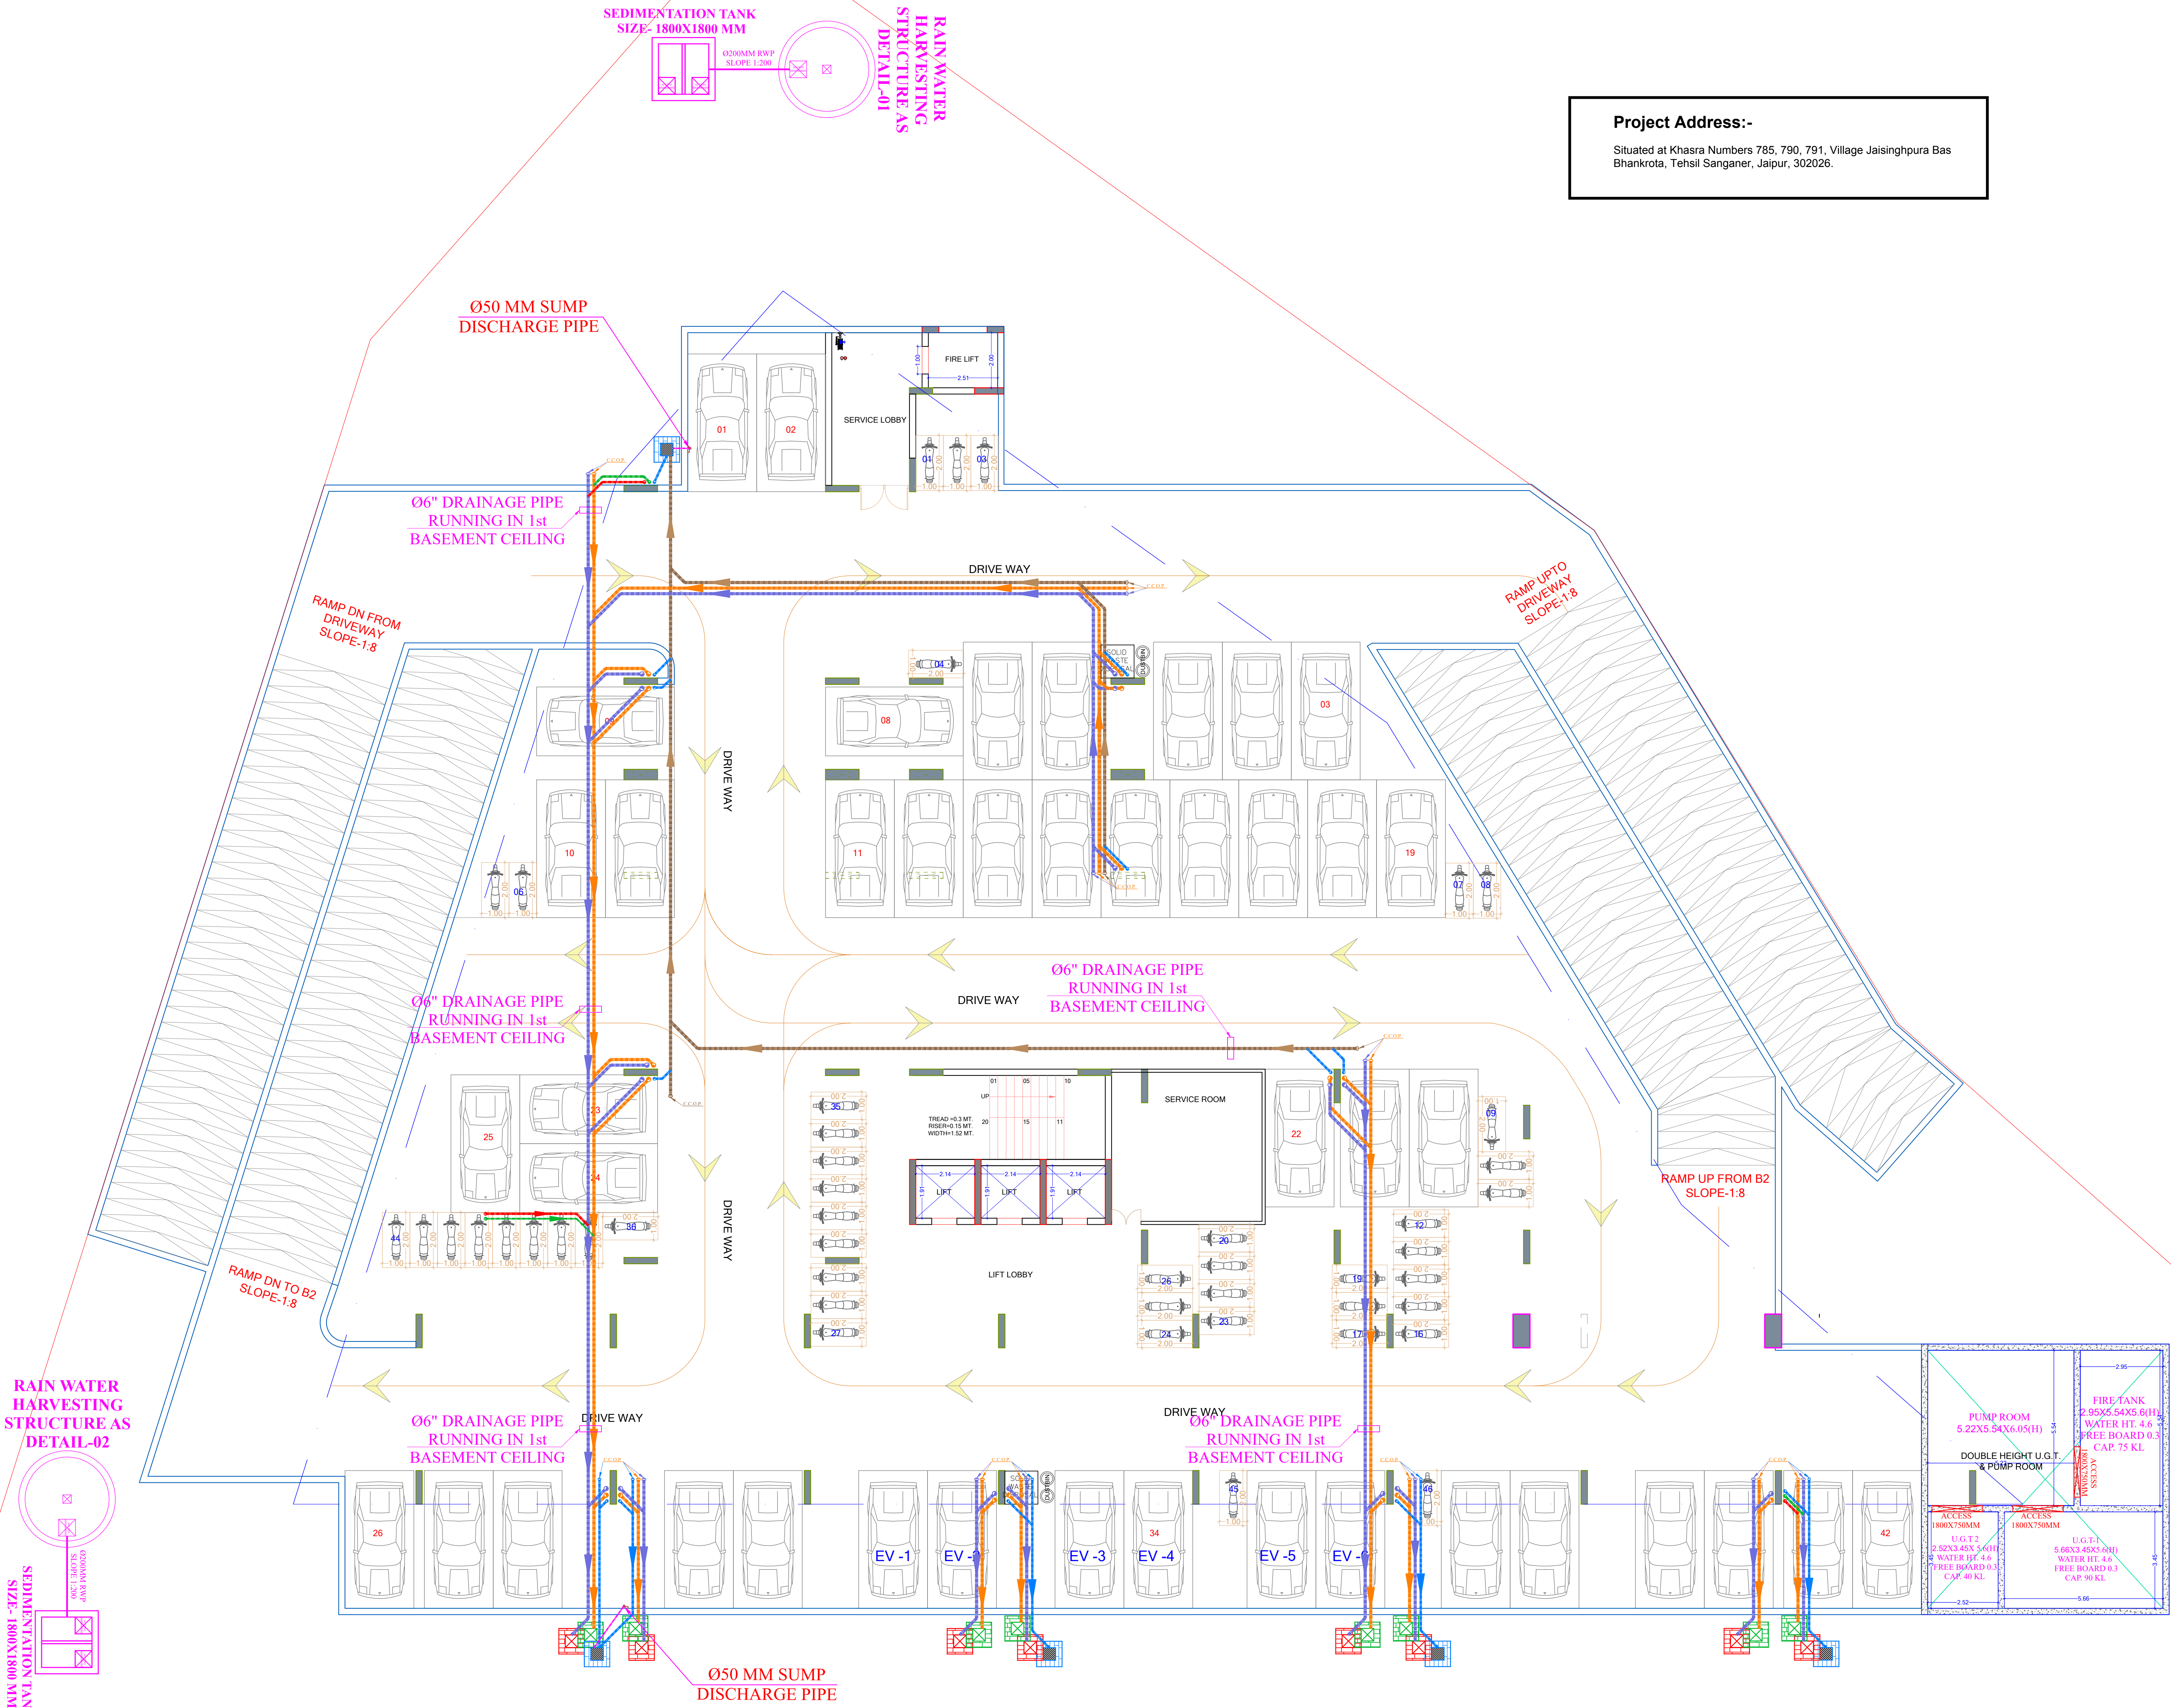

1st BASEMENT FLOOR PLAN

Bhupendra
BHANWAR LAL YADAV
MEP CONSULTANT
DIP. MECH. (RAC), B.TECH MECH.

REV. NO.	DESCRIPTION TO REVISION	REV. BY	DATE
R-00	DRAINAGE_PLAN	BABU_LAL	12.11.2025
-	-	-	-
-	-	-	-
ARCHITECT
Architect:
Tushar Sogani Designs Pvt. Ltd.
architects 'n' designers
Studio: 400, F-72, "Suryoday" Subhash Marg
Bagadiya Bhawan, C-Scheme, Jaipur-302001
Tel:-91-141-4004560, 4004537
email:studio@tsdplarch.com; website:www.tsdplarch.com

STRUCTURAL CONSULTANT

CLIENT

PROJECT NAME

Antilia Mansion


DWG TITLE


1ST BASEMENT_DRAINAGE_UGT
& PUMP ROOM, RAIN WATER
HARVESTING PLAN

DWG STATUS

FOR_RERA_SUBMISSION

MEP CONSULTANTS
**MEPEX**
ENRICH YOUR BUILDING ANATOMY
H.O.: S.R. SPORTS COMPLEX
HATOJ MOD, SIRSI ROAD,
JAIPUR, 302012.B.O.: 401 & 402,
RAGHU SAPPHIRE CENTER,
CIVIL LINES, JAIPUR, 302006.
Mo. No.-9571758110, 7568093164
Email: mepexconsultant@gmail.com
teammepex@gmail.com

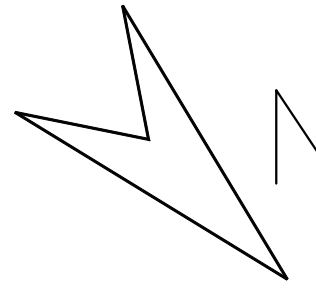DEALT BY:	CHECKED BY:	DIRECTION:
BABU LAL	AVINASH	
DRAWN NO.:	SCALE:	SHEET SIZE:
MPX/JAP/SHGR/1ST-BSF-DR/R-01	NTS	A1
		DATE:
		12.11.2025

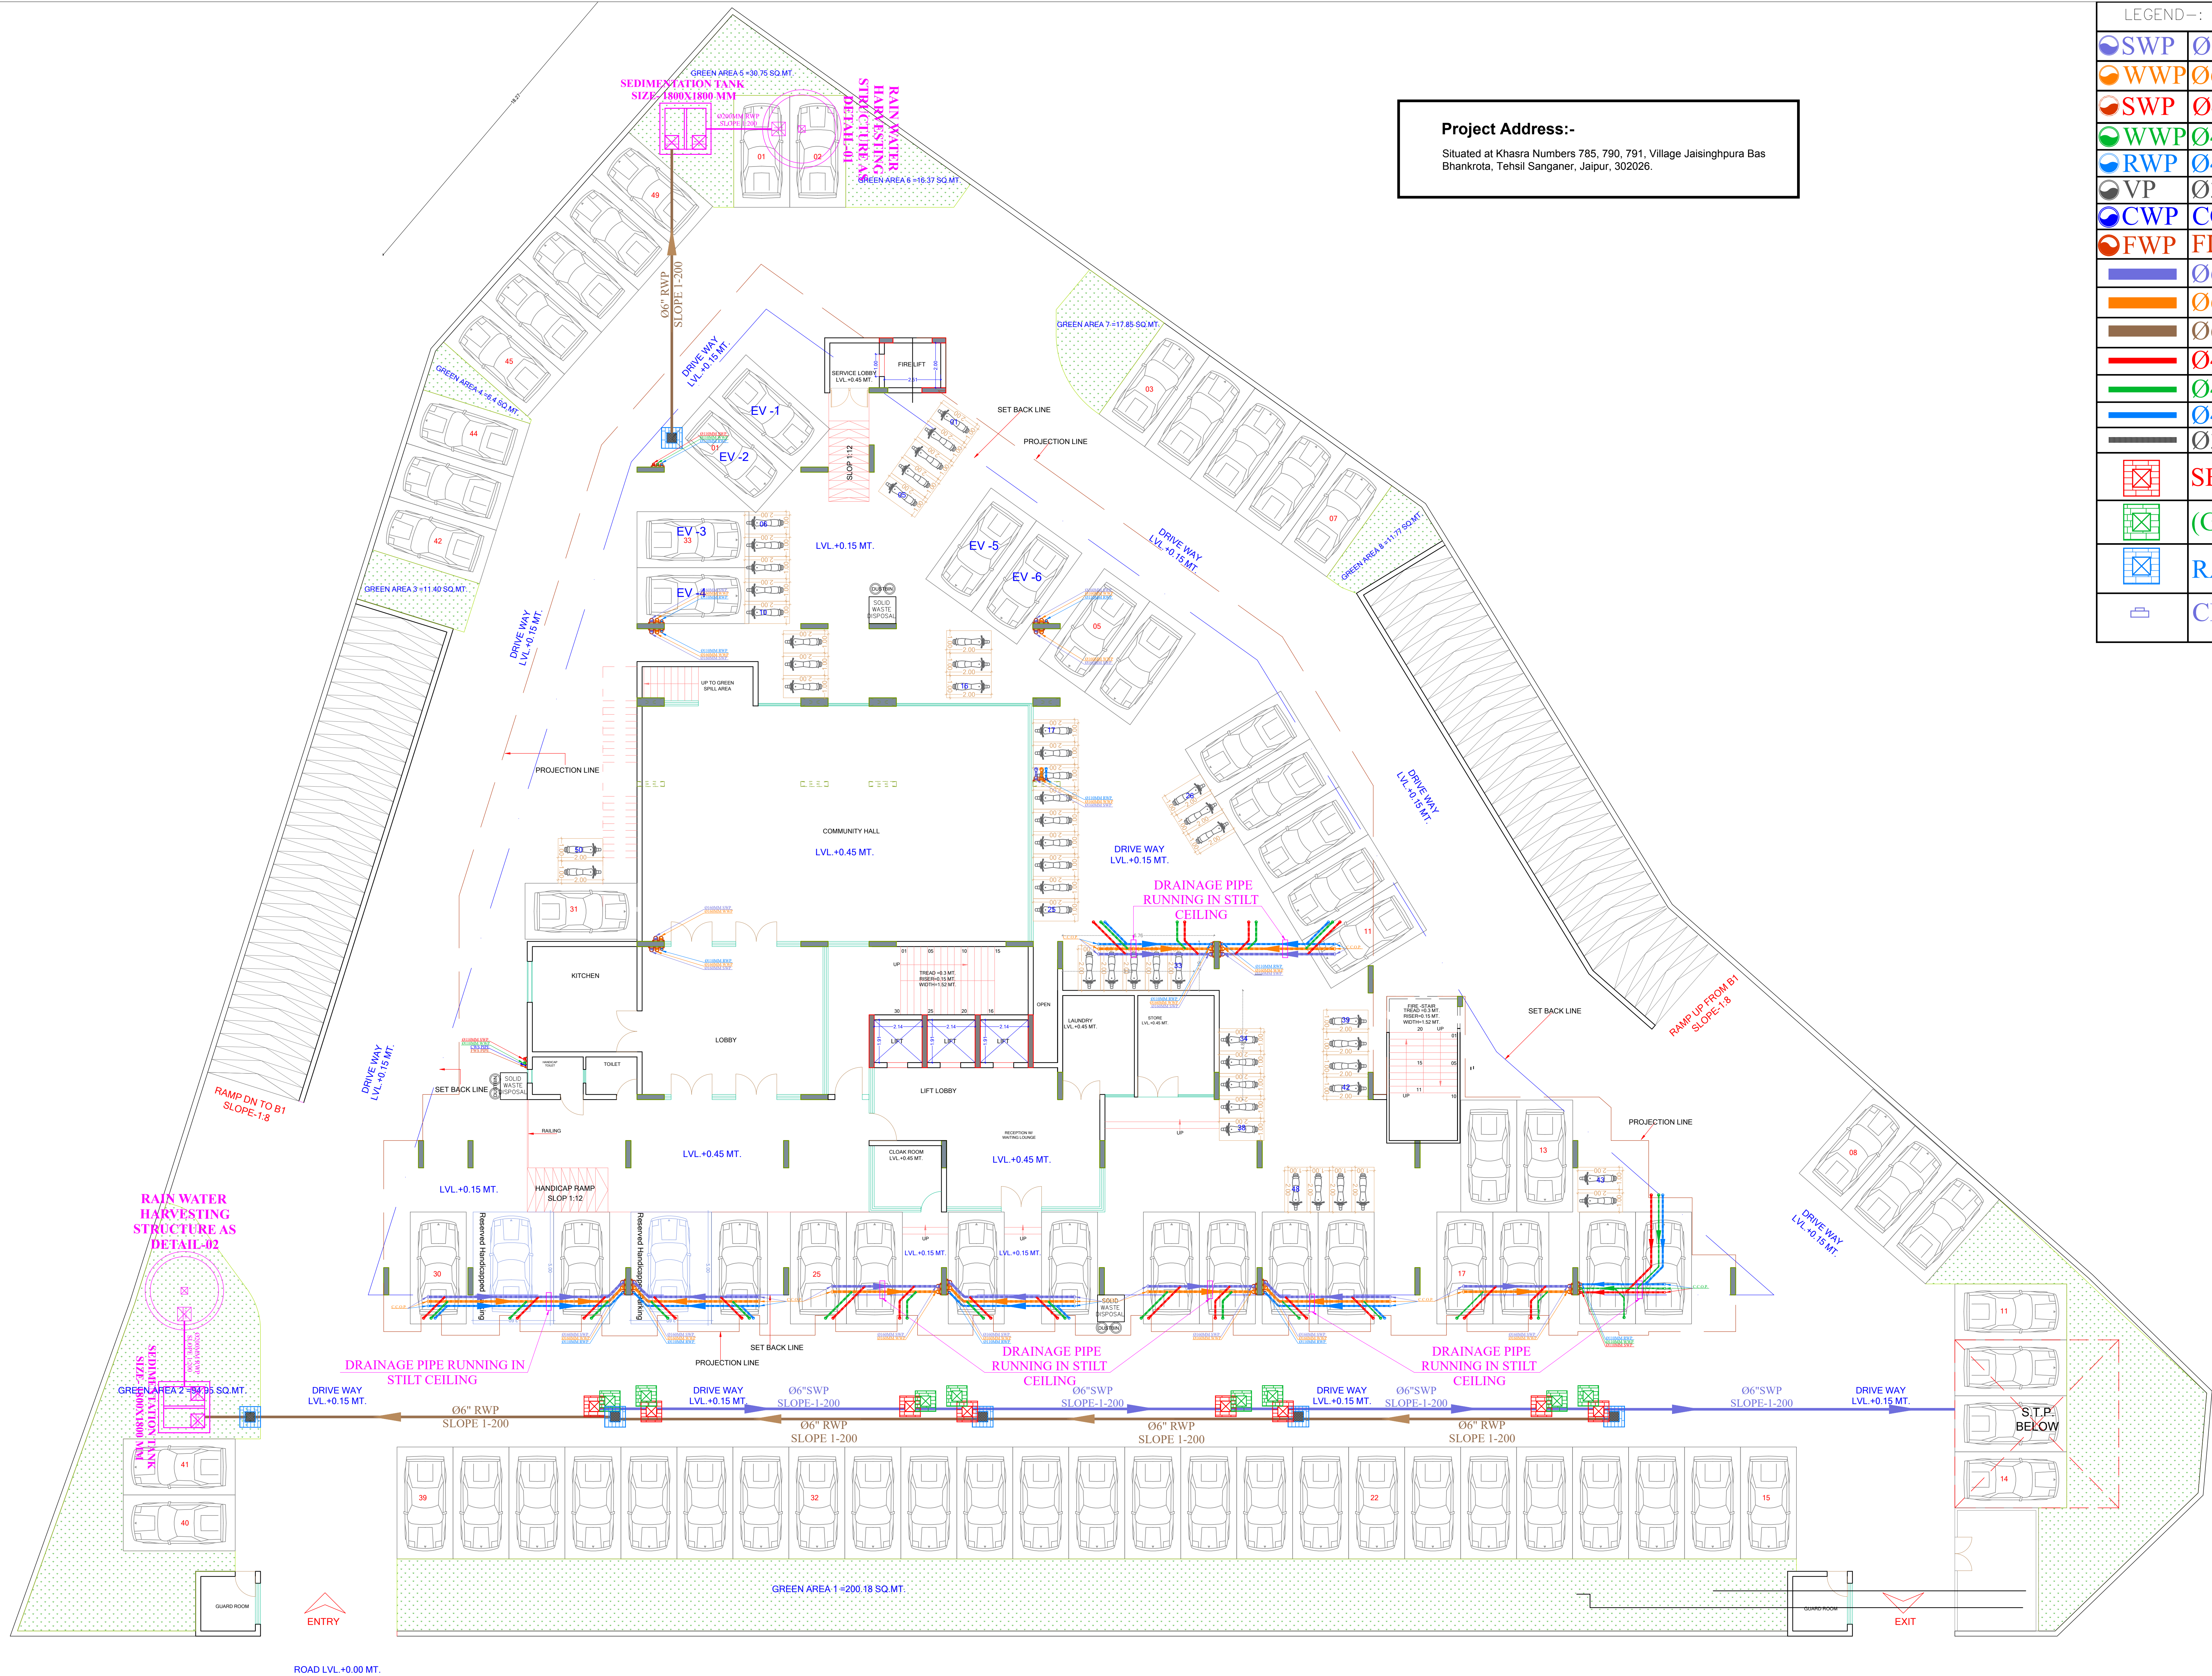

STILT FLOOR PLAN

REV. NO.	DESCRIPTION TO REVISION	REV. BY	DATE
R-00	DRAINAGE_PLAN	BABU_LAL	12.11.2025
-	-	-	-
-	-	-	-
Architect:
Tushar Sogani Designs Pvt. Ltd.
architects 'n' designers
Studio: 400, F-72, "Suryoday" Subhash Marg
Bagadiya Bhawan, C-Scheme, Jaipur-302001
Tel:+91-141-4004560, 4004537
email:studio@tsdplarch.com; website:www.tsdplarch.com

Structural Consultant

Client

Project Name

Antilia Mansion

DWG TITLE

STILT_FLOOR_DRAINAGE_UGT & PUMP ROOM, RAIN WATER HARVESTING LOCATION MARKING PLAN

DWG STATUS

FOR_RERA_SUBMISSION

MEP CONSULTANTS

MEPEX
ENRICH YOUR BUILDING ANATOMY

H.O.: S.R. SPORTS COMPLEX
HATOJ MOD, SIRSI ROAD,
JAIPUR, 302012.B.O.: 401 & 402,
RAGHU SAPPHIRE CENTER,
CIVIL LINES, JAIPUR, 302006.
Mo. No.-9571758110, 7568093164
Email: mepexconsultant@gmail.com
teammepex@gmail.com

DEALT BY:

BABU_LAL

CHECKED BY:

AVINASH

DRAWN NO.:

MPX/JAP/SHGR/ST-DR/PR/ RWH/R-00

SCALE:

NTS

SHEET SIZE:

A1

DATE:

12.11.2025

DIRECTION: