



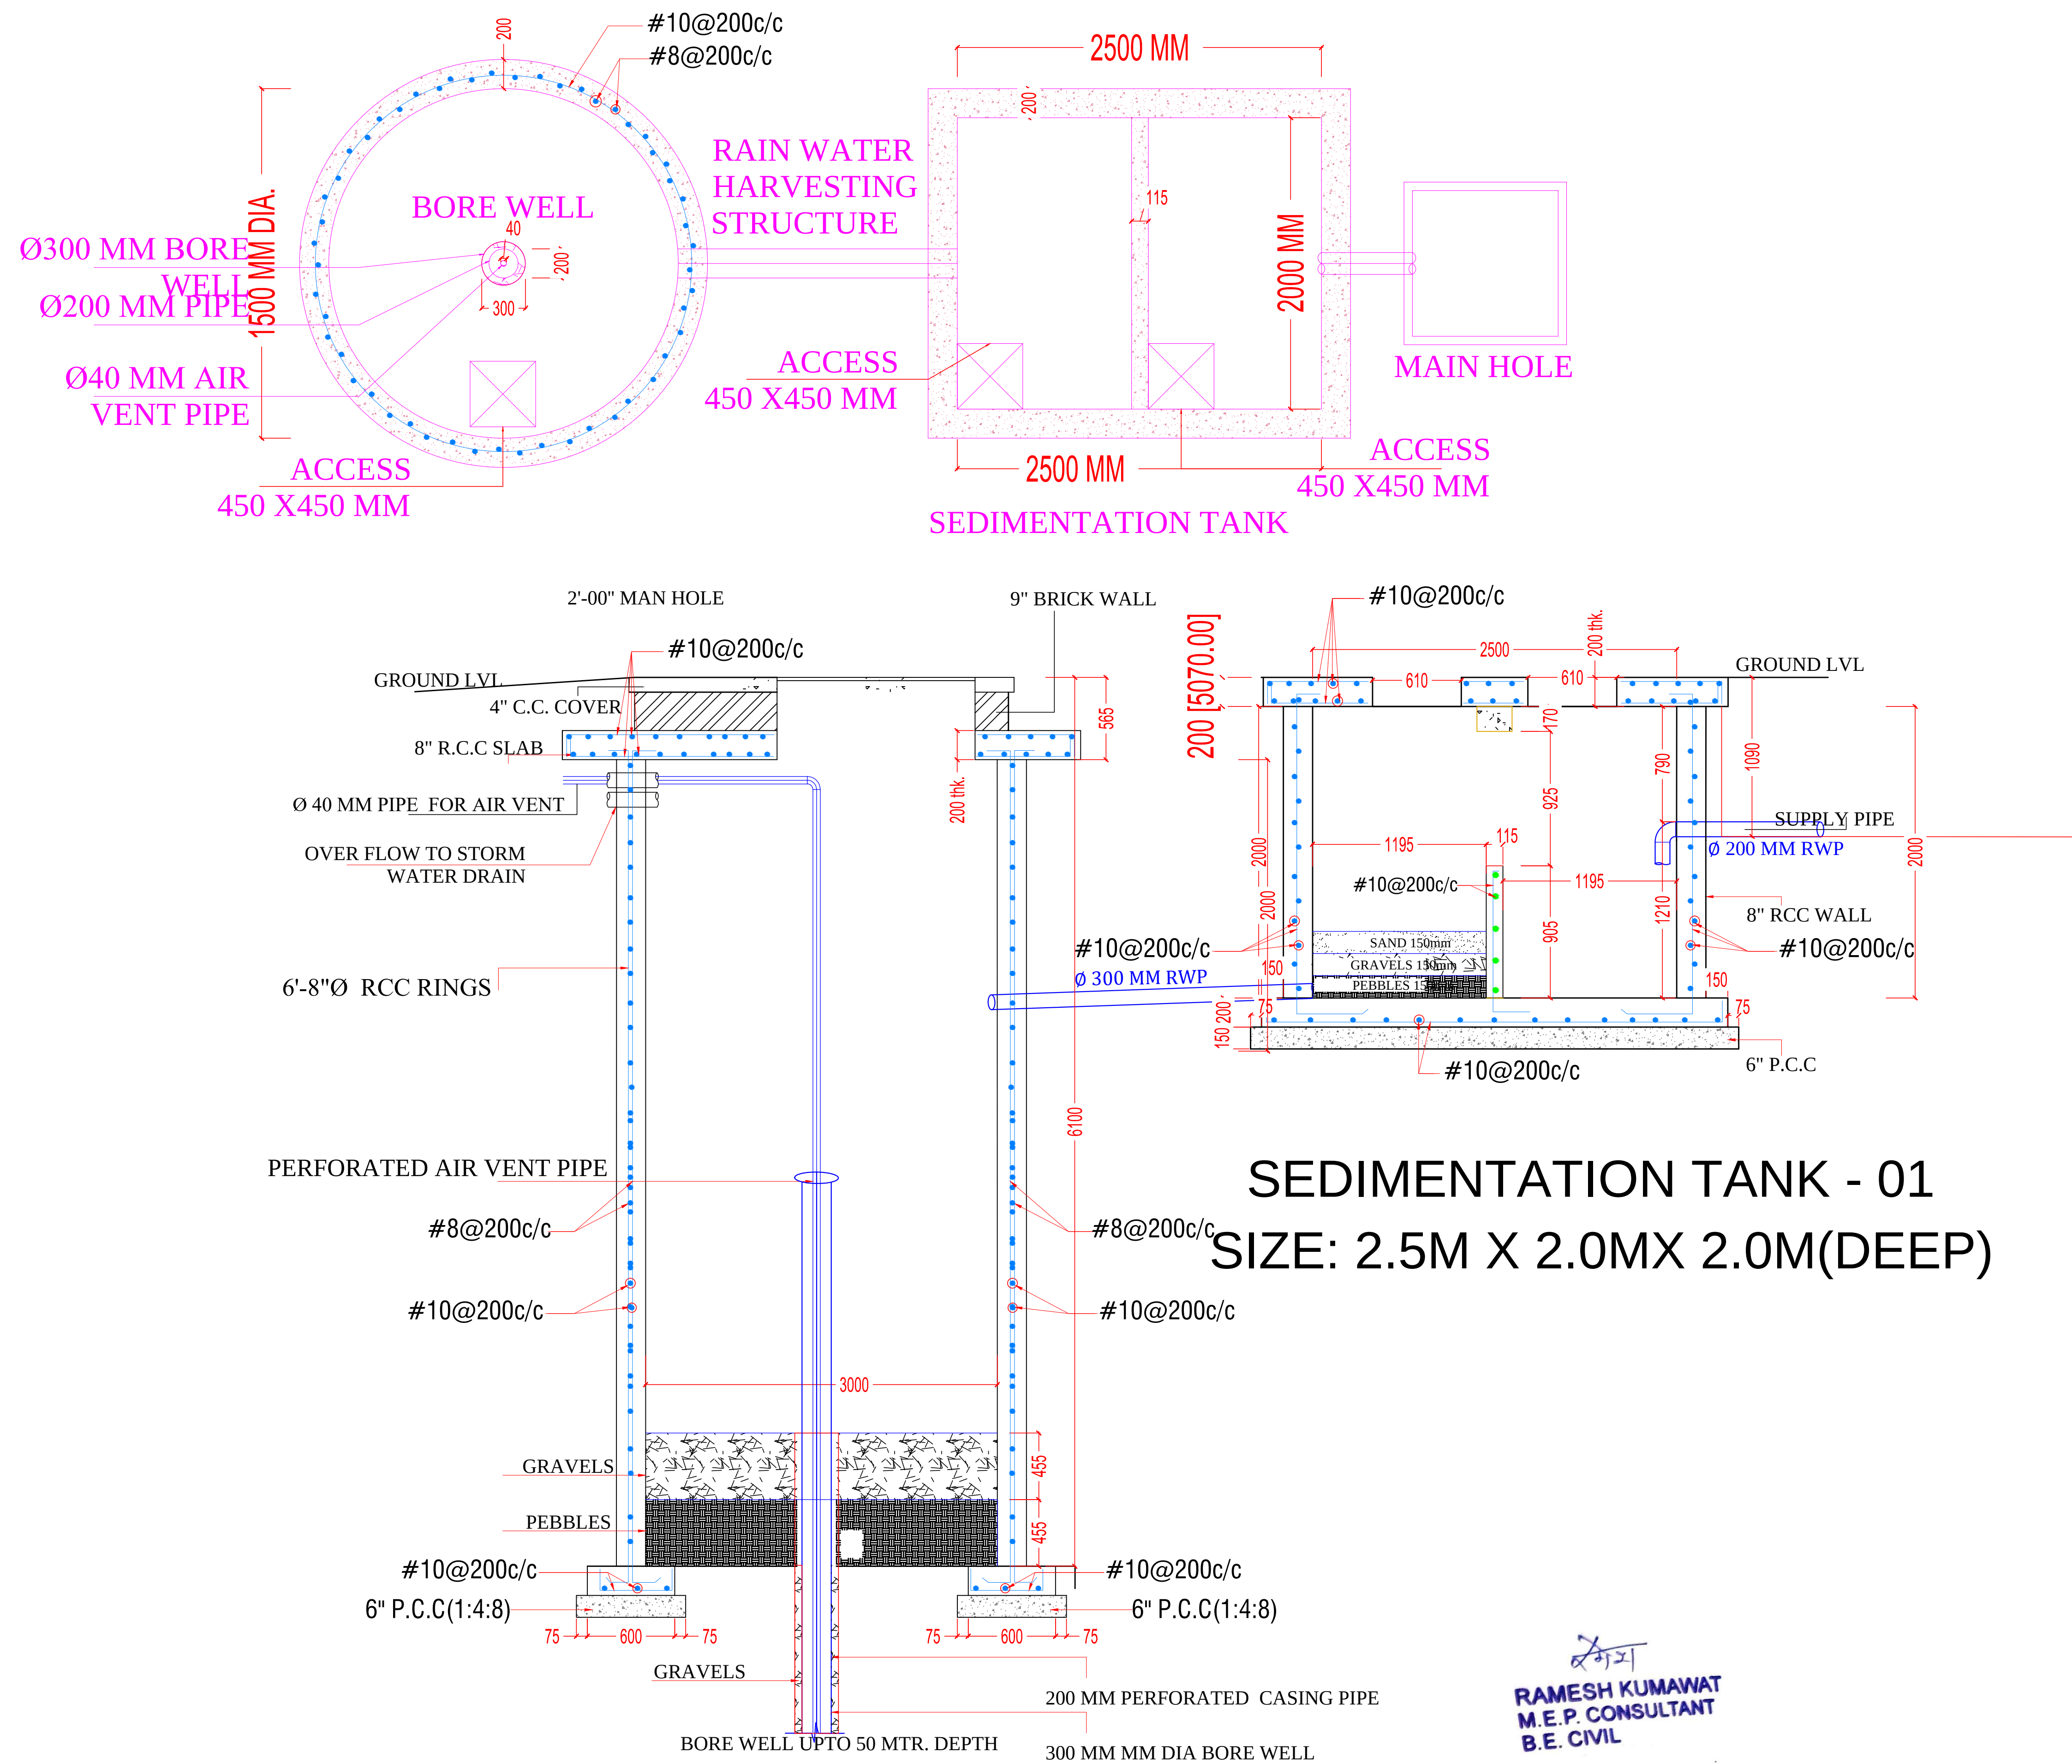

PROJECT TITLE :- PROPOSED BUILDING FOR FLATS, AT PLOT NO.- 1, 2, 3, 4 & 5, OF GOVIND BAGH PEARL SCHEME, VILLAGE - BEELWA KALA, TEH.- SANGANER , JAIPUR	DRAWING TITLE :- TYPICAL RAIN WATER HARVESTING	SPACE CONSULTANT PLOT-A-173, JAGDAMBA NAGAR, HEERAPURA POWER HOWER, JAIPUR (RAJ) 302024	DRN. BY		DATE
			APPD. BY		REVISION
			SCALE		

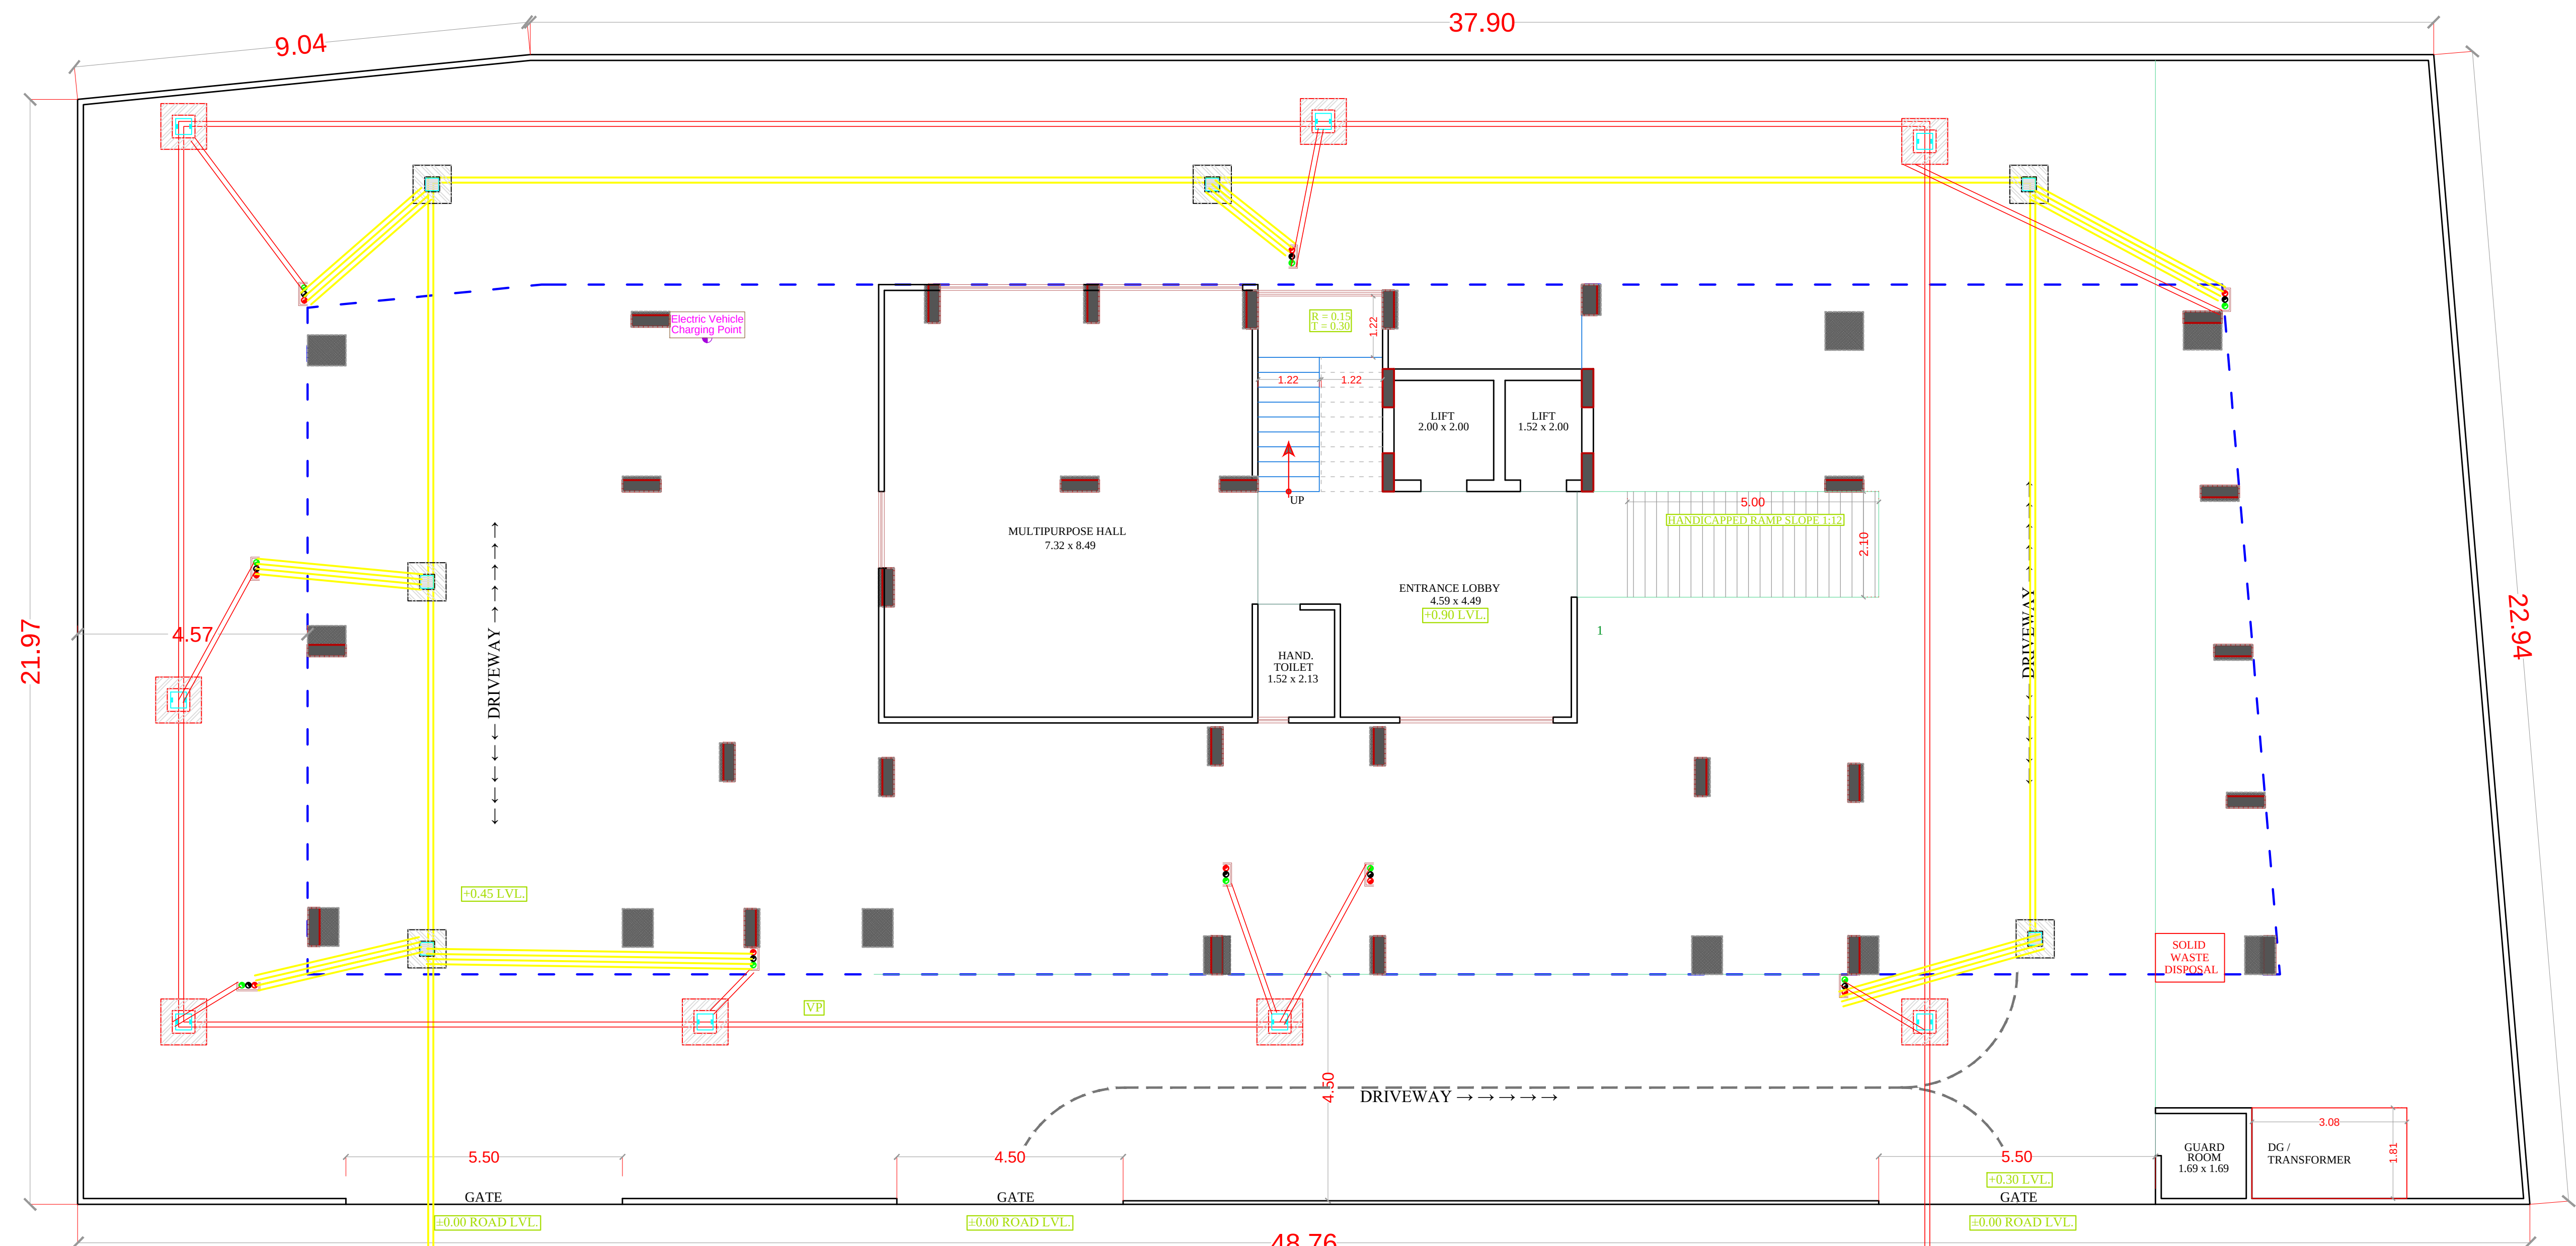

STILT FLOOR PLAN & PARKING LAYOUT

MAIN SEWER LINE

RAIN WATER LINE

SYMBOL	DESCRIPTION
	Ø 110 mm Soil Waste Water Pipe
	Ø 110 mm Waste Water Pipe
	Ø 110 mm Rain Water Pipe
	Ø 160 mm Rain Water Pipe Slope 1:200
	Ø 110 mm Rain Water Pipe Slope 1:200
	RC-12"X12" Depth According to Slope
	RC-18"X18" Depth According to Slope
	RC-24"X24" Depth According to Slope
	Flow Direction

RAMESH KUMAWAT
M.E.P. CONSULTANT
B.E. CIVIL

PROJECT TITLE :- PROPOSED BUILDING FOR FLATS, AT PLOT NO.- 1, 2, 3, 4 & 5, OF GOVIND BAGH PEARL SCHEME, VILLAGE - BEELWA KALA, TEH.- SANGANER , JAIPUR	DRAWING TITLE :- COMMON AREA RAIN WATER	SPACE CONSULTANT PLOT-A-173, JAGDAMBA NAGAR, HEERAPURA POWER HOWER, JAIPUR (RAJ) 302024	DRN. BY		DATE	NORTH
			APPD. BY		REVISION	
			SCALE	N.T.S		