
 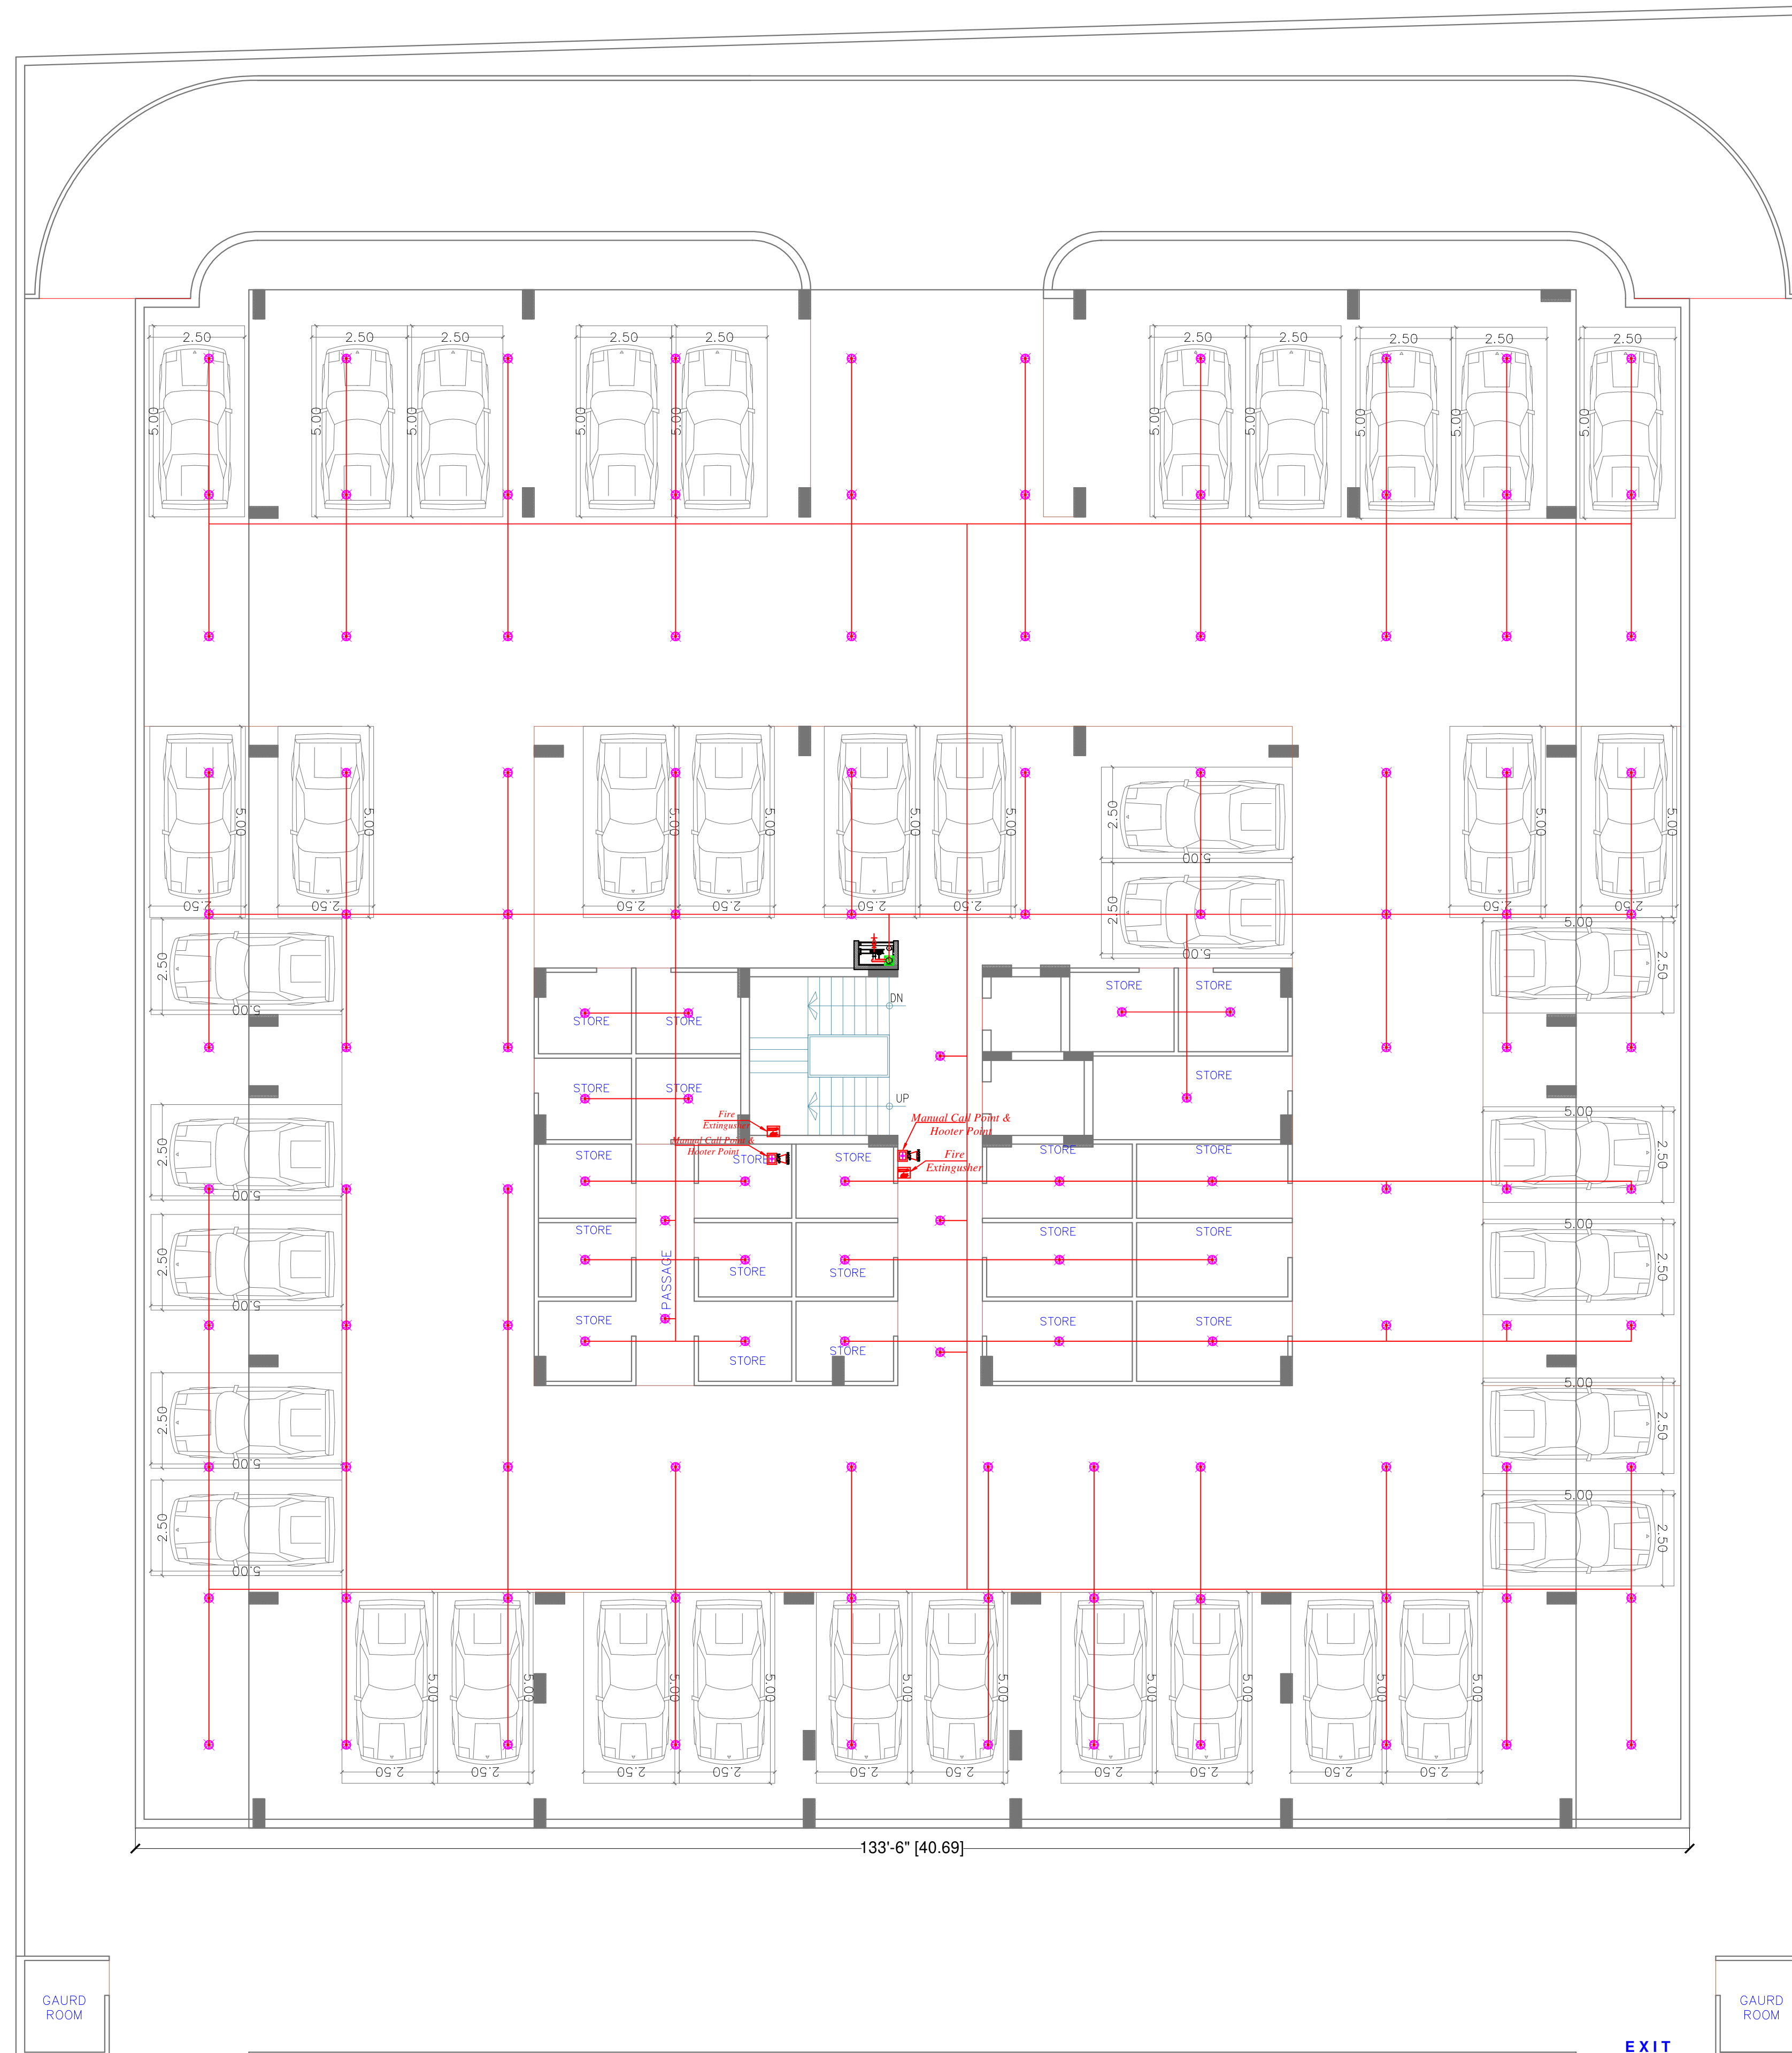




BASEMENT FLOOR

M/s RGB HEIGHTS

 PARTNER


VIPUL AGARWAL
 M.E.P. CONSULTANT
 B.E. ELECTRICAL

LEGENDS:

No.	Symbol	Description
01		FIRE EXTINGUISHER
01		MANUAL CALL POINT
01		HOOTER POINT

LEGENDS:

Mounting Ht.	Symbol	Description
CEILING		PENDANT SPRINKLER
CEILING		MS PIPE FOR SPRINKLER
		CONTROL VALVE


SERVICES CONSULTANT:
VIPUL CONSULTING,
 F 9 / 440 , Keshav Marg Chitrakut Scheme, Jaipur
 PH: 91-093146-10438, 0141-2440946 Mail: vipul8599@yahoo.com

DRN BY- SURENDER YADAV	CKD BY- SANJAY
APPD BY- VIPUL AGARWAL	REV.- 00
DATE- 13-06-2023	SCALE-

DRAWING:

BASEMENT FLOOR
 MANUAL CALL POINT, HOOTER
 POINT, FIRE HOSE CABINET
 MARKED & FIRE SPRINKLER PLAN



PROJECT:
 PROPOSED RESIDENTIAL
 BUILDING AT KHASRA NO. 300/2
 AT REVENUE VILLAGE -
 RAMSINGHPURA URF DHOLAI
 TEHSIL - SANGANER, DIST.
 JAIPUR RAJASTHAN

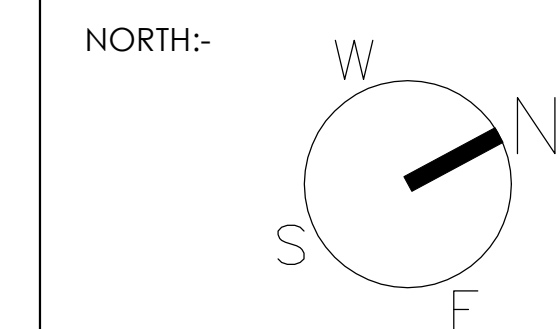

ARCHITECT:



B-6, Moti Marg, Bapu Nagar, Jaipur.
 Ph.: 9314510603
 E-Mail: spaceedgejpr@gmail.com

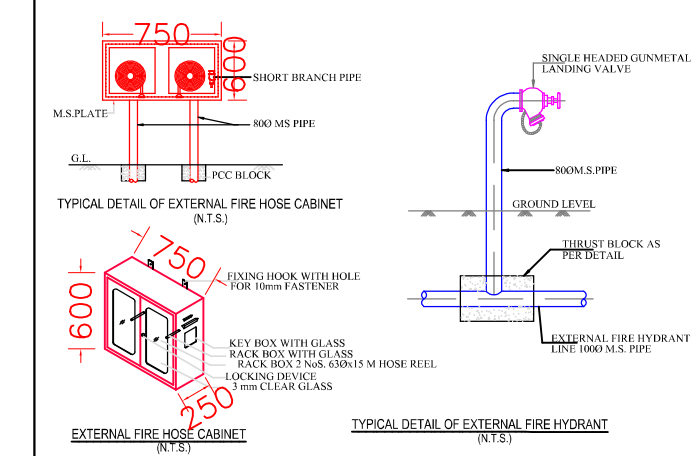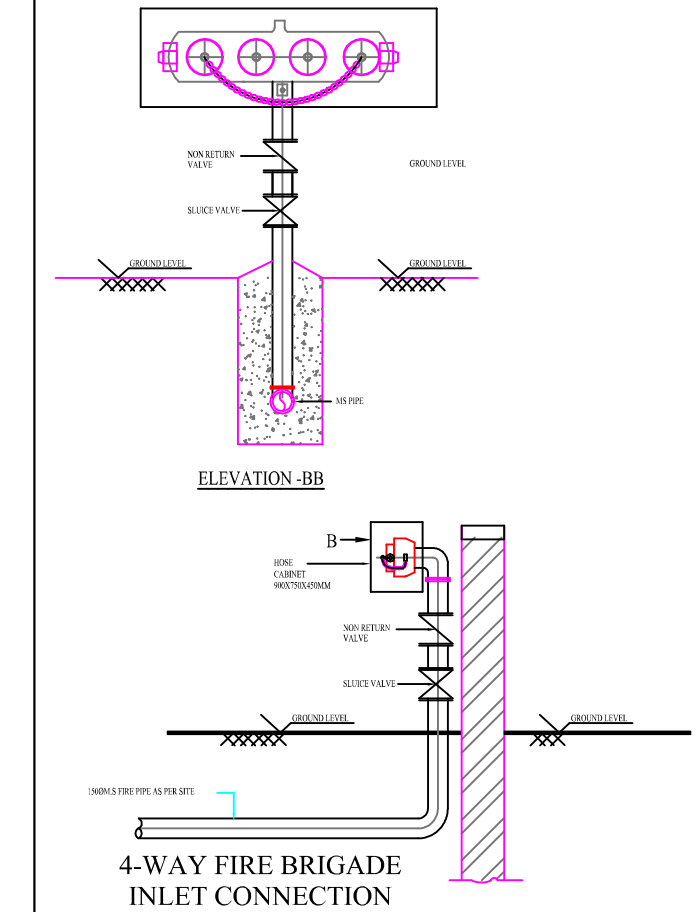


No.	Symbol	Description
01		<i>FIRE EXTINGUISHER</i>
01		<i>MANUAL CALL POINT</i>
01		<i>HOOTER POINT</i>

<p align="center">SERVICES CONSULTANT: VIPUL CONSULTING, F 9 / 440 , Keshav Marg Chitratuk Scheme Jaipur PH 91-0-93146-10438 ,0141-2440946 Mail:vipul8599@yahoo.com</p>	
D/N BY-	CKD BY-
SURENDER YADAV	SANJAY
APPD BY-	REV.-
VIPUL AGARWAL	00
DATE-	SCALE-
13-06-2023	
DRAWING:	

PROJECT:	<p>PROPOSED RESIDENTIAL BUILDING AT KHASRA NO. 300/2 AT REVENUE VILLAGE - RAMSINGHPURA URF DHOLAI TEHSIL - SANGANER, DIST. JAIPUR RAJASTHAN</p>
----------	---

 NORTH:-



 space
edge Architects


ARCHITECTS, INTERIOR DESIGNERS AND ENGINEERS

B-6, Moti Marg, Babu Nagar, Jaipur.
Ph.: 9314510603
E-Mail: spaceedgejpr@gmail.com

M/s RGB HEIGHTS
Dr. R. G. B.
 PARTNER



Vipul
VIPUL AGARWAL
M.E.P. CONSULTANT
B.E. ELECTRICAL

OVERHEAD
FIRE WATER TANK
25000LTR.

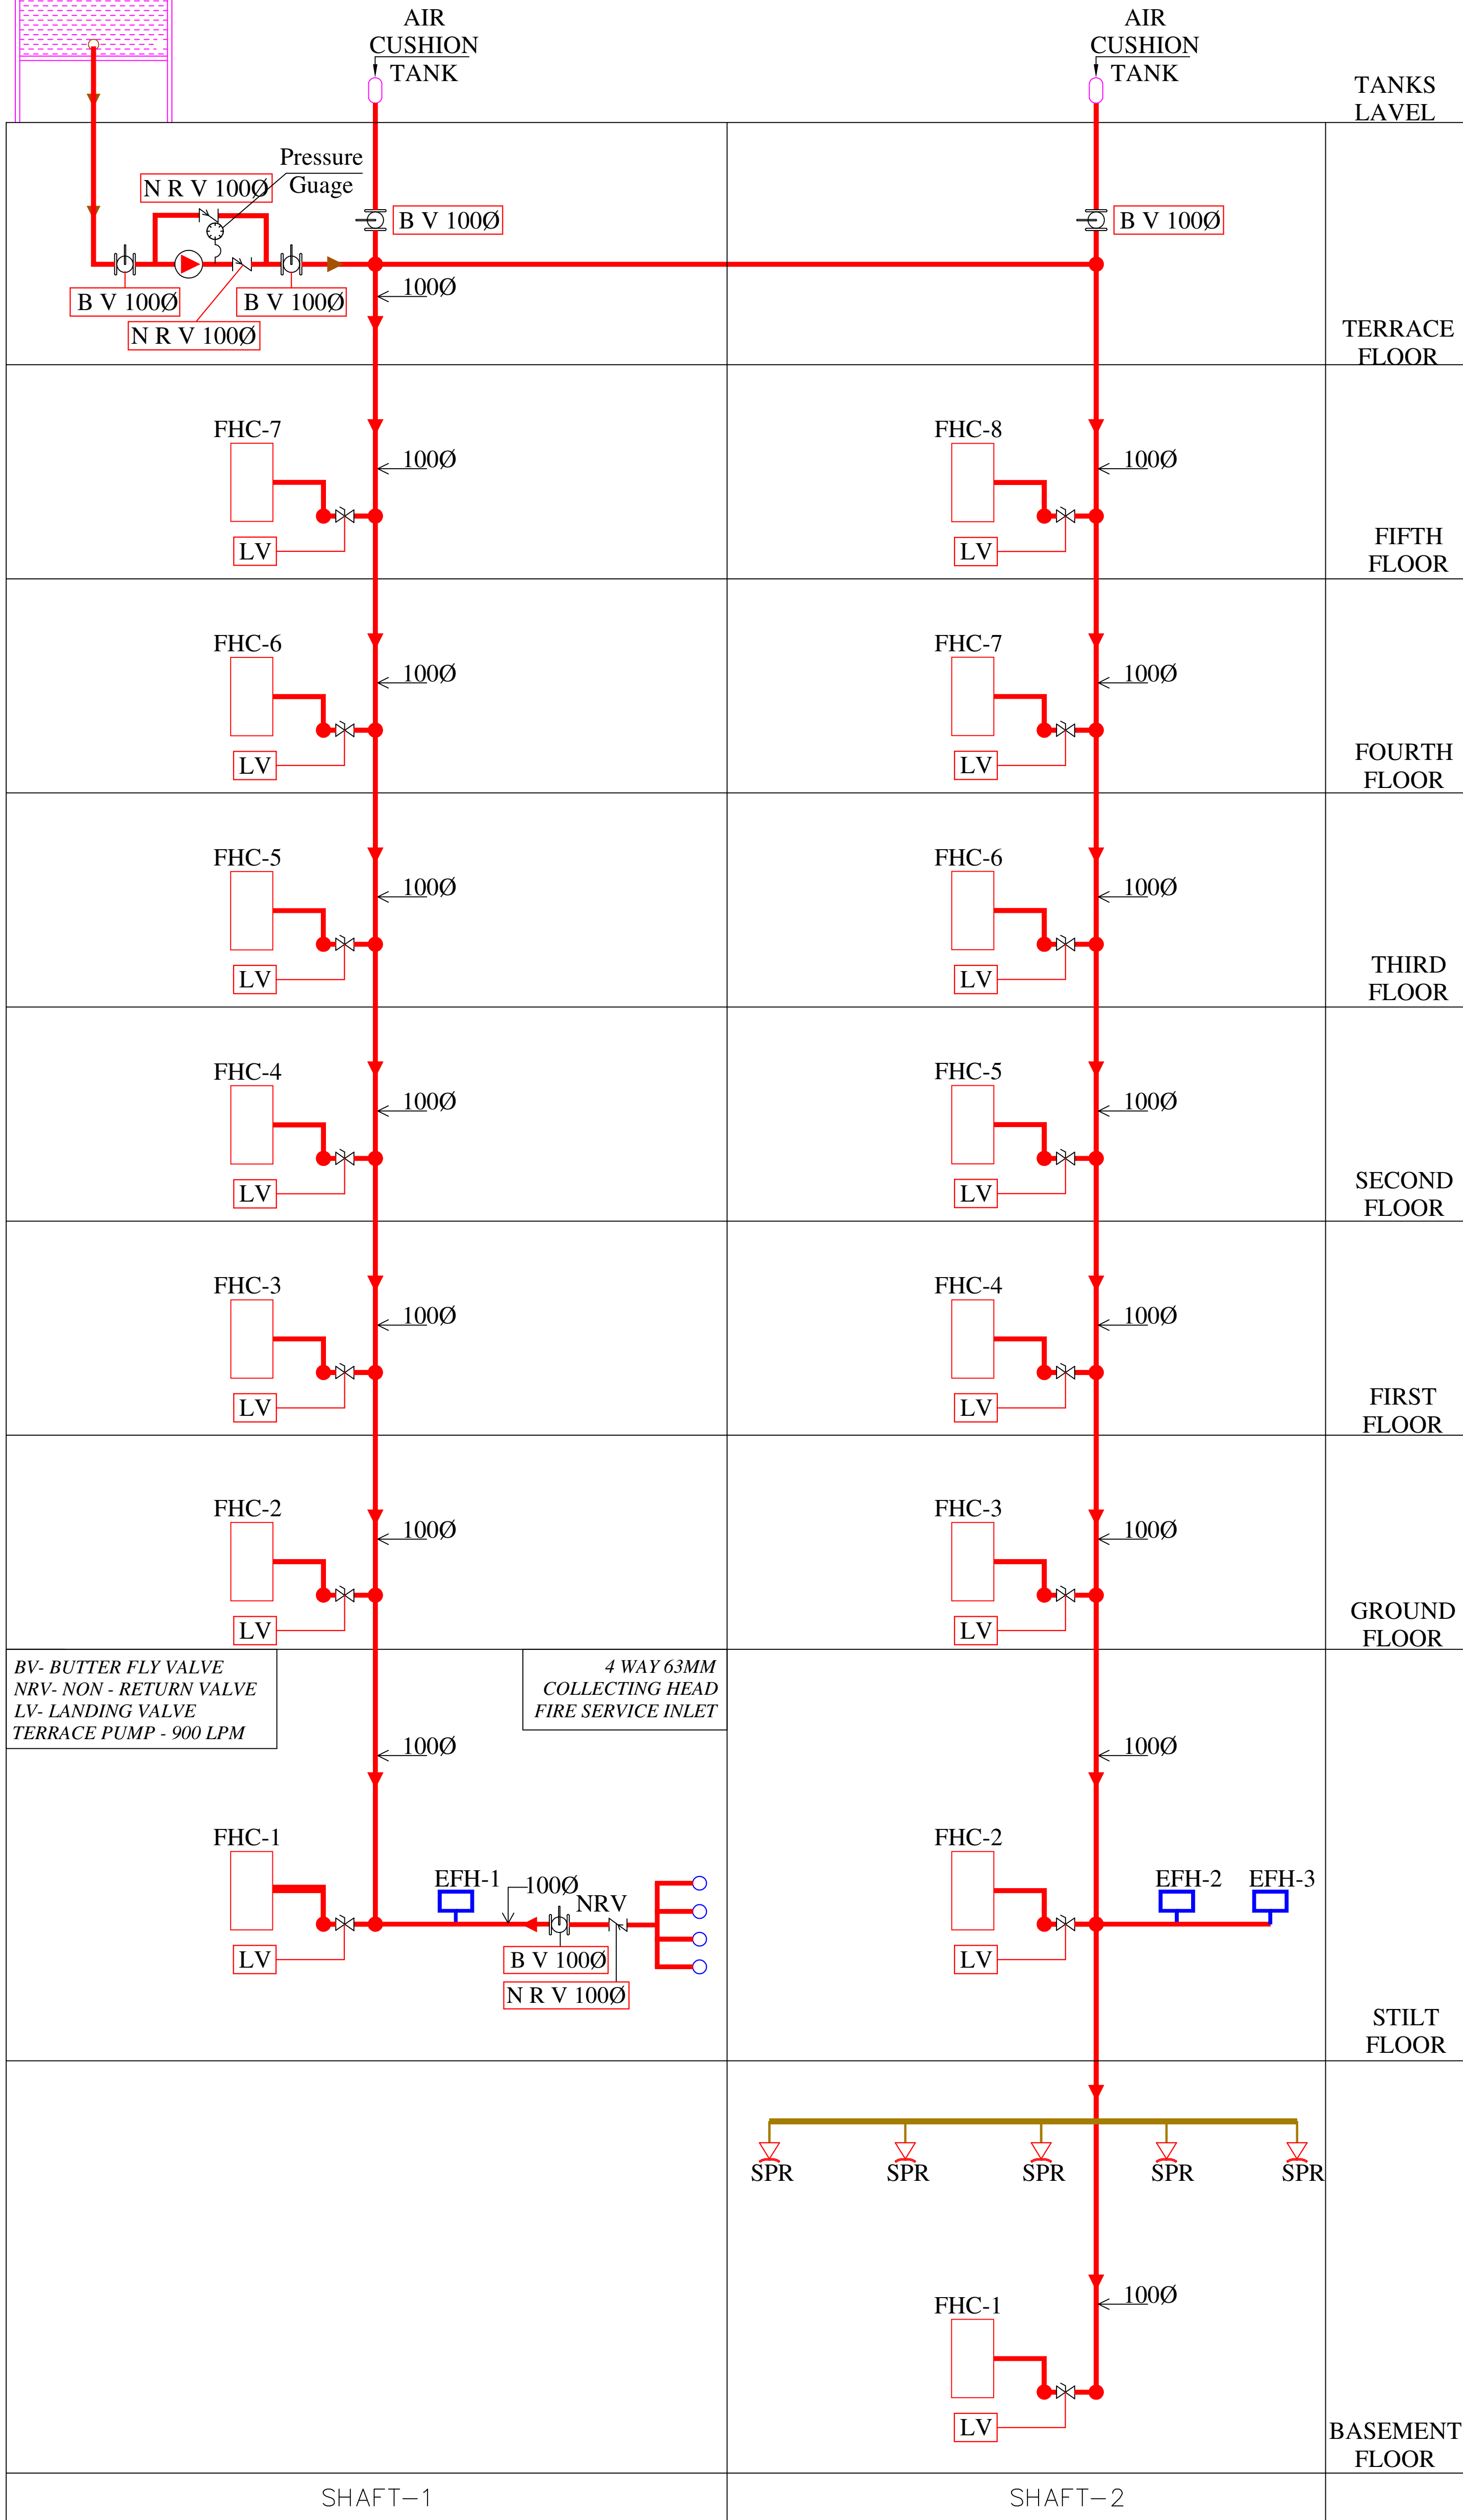

M/s RGB HEIGHTS
Partner

VIPUL
VIPUL AGARWAL
M.E.P. CONSULTANT
B.E. ELECTRICAL

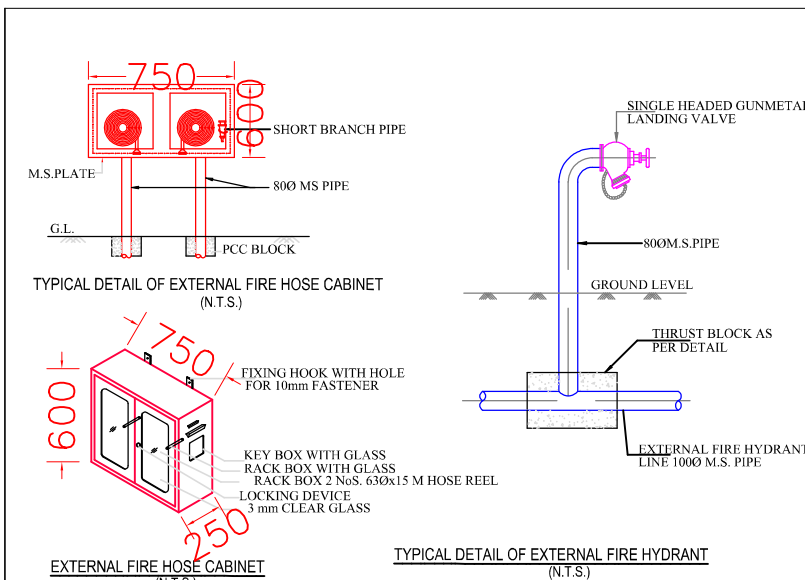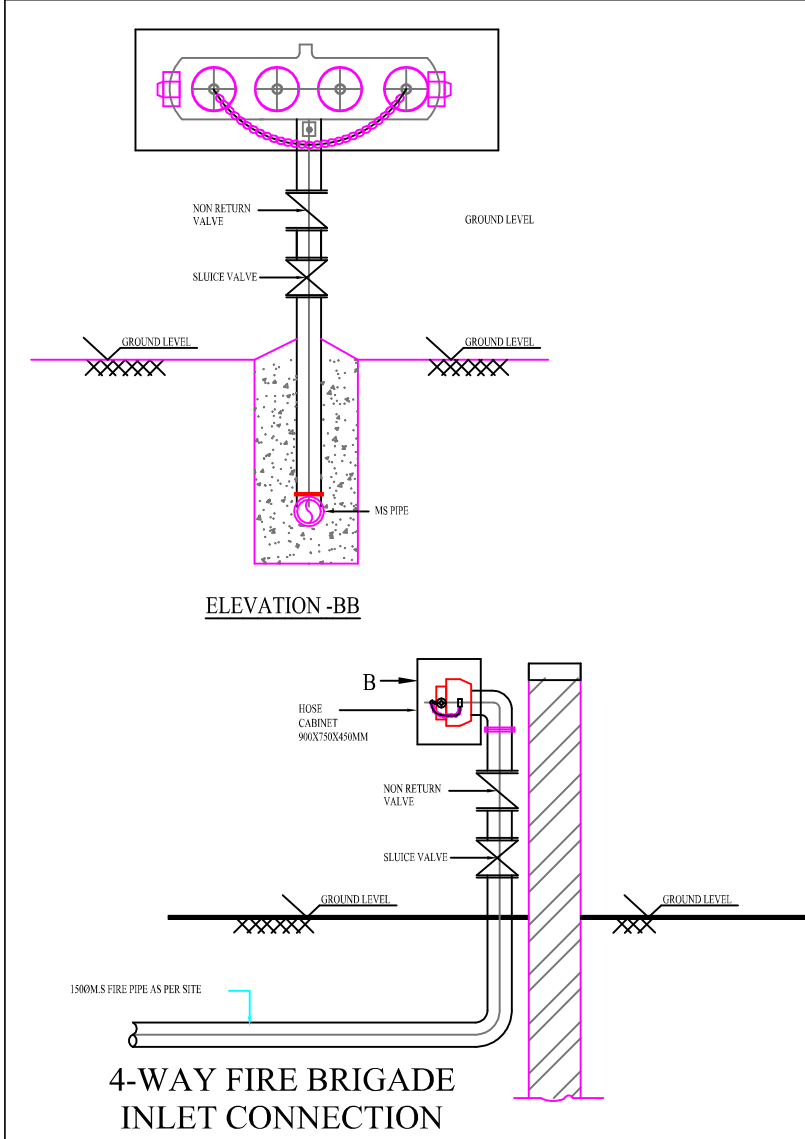

S.no.	Symbol	Description	Qty.	Size in mm
1.		Butter fly Valve	04	100Ø
2.		Non Return Valve	03	100Ø
3.		Landing Valve Single headed	15	63Ø
4.		Pressure Guage	01	
6.		External Fire Hose Cabinet	03	

SERVICES CONSULTANT:
VIPUL CONSULTING
F9/440,Keshav Marg Chitrakut Scheme,Jaipur
PH:91-0-93146-10438 ,0141-2440946 Mail:vipul8599@yahoo.com

PROJECT NAME:-

PROMOTER:-

PROJECT ADDRESS:-

PROPOSED RESIDENTIAL BUILDING AT
KHASRA NO. 300/2AT REVENUE VILLAGE -
RAMSINGHPURA URF DHOLAI,TEHSIL -
SANGANER, DIST. JAIPUR RAJASTHAN

PROJECT FOR REFERENCE:-

DRAWING:

FIRE SCHEMATIC LAYOUT

DRAWN. BY:-

CHKD. BY:-

SURENDER

SANJAY

APPD BY:-

DATE:-

REV.:-

VIPUL AGARWAL

13-06-2024

00