



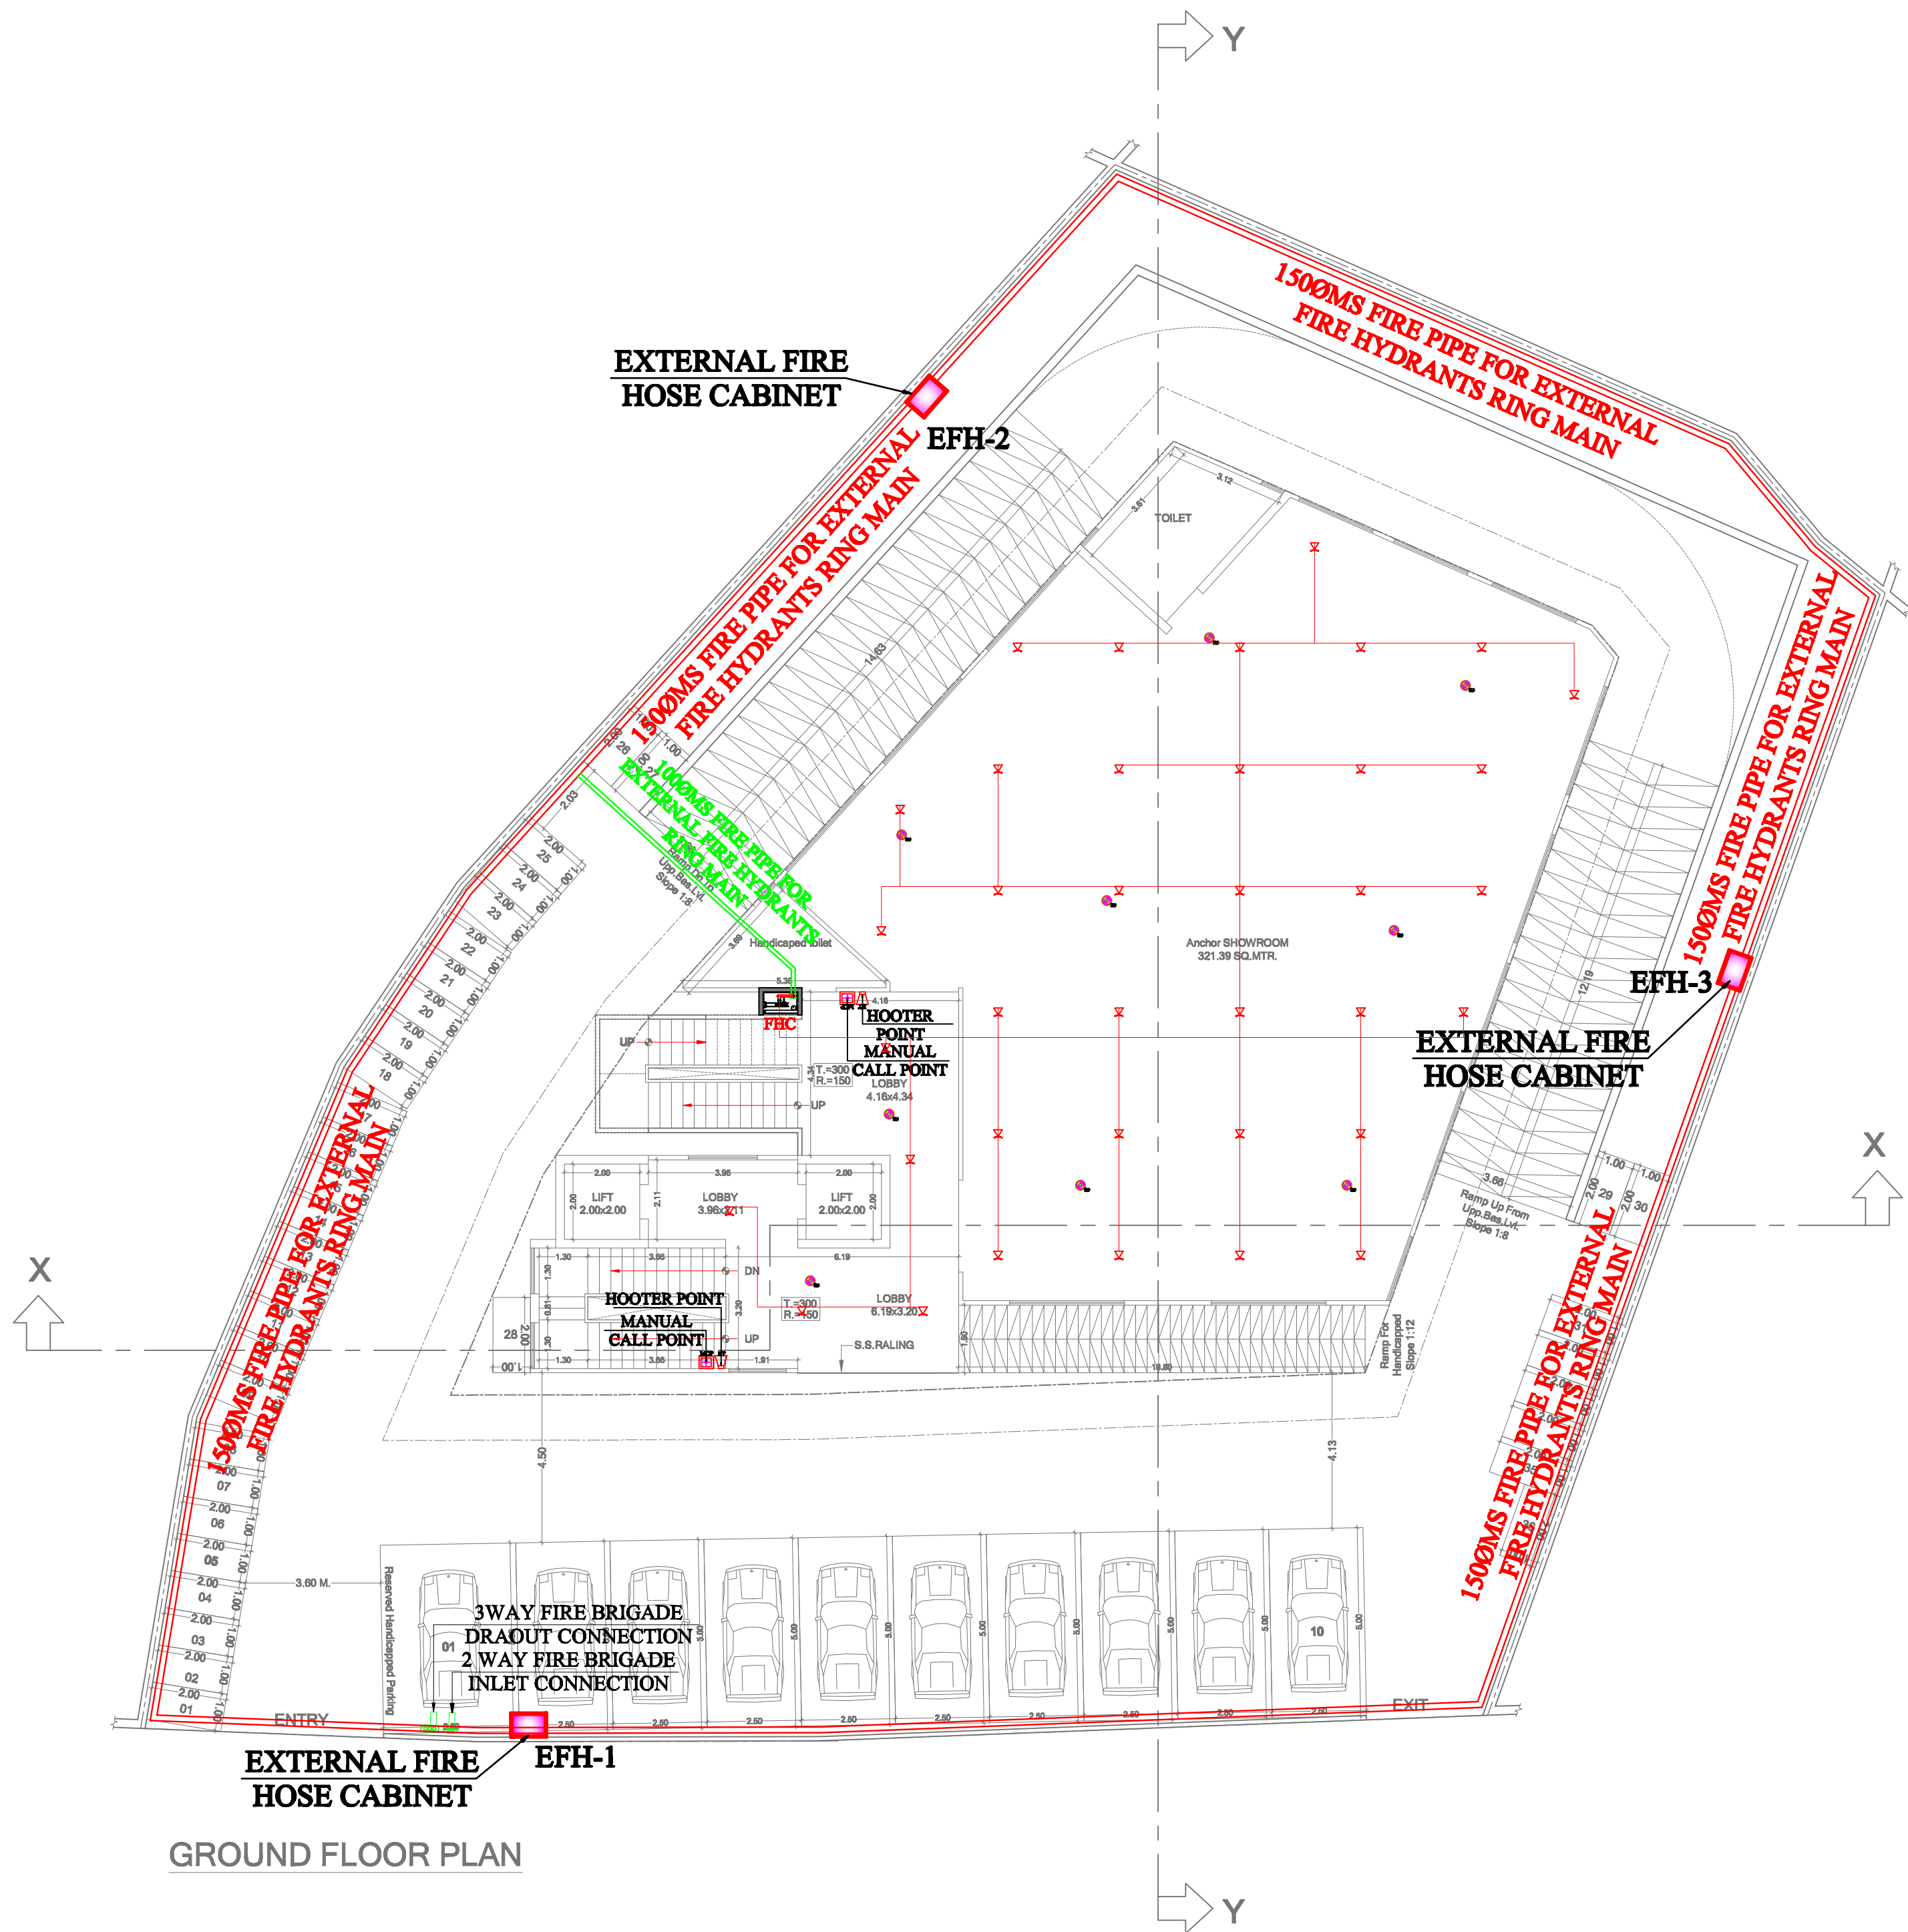

GROUND FLOOR PLAN

SHEET NO. - 03

TITLE:-
SUBMISSION DRAWING
GROUND FLOOR EXTERNAL FIRE
HYDRANT & SPRINKLER PLAN

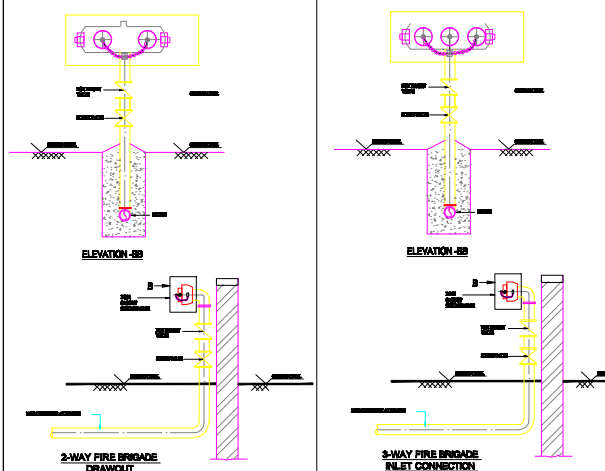

LEGENDS:

Mounting Height	No.	I D	Symbol	Description
CEILING			—	FIRE PIPE
CEILING	37		⋈	CEILING SPRINKLER
CEILING	09	SD	⊙	SMOKE DETECTOR
+42"	02	MCP	⊕	MANUAL CALL POINT
+90"	02	HT	⬮	HOOTER POINT
	01	FHC	⊞	FIRE HOSE CABINET

1500MS FIRE PIPE FOR EXTERNAL
FIRE HYDRANTS RING MAIN
1000MS FIRE PIPE FOR EXTERNAL
FIRE HYDRANTS RING MAIN

 
SERVICES CONSULTANT:
VIPUL CONSULTING,
F 9 / 440, Keshav Marg, Chitrakut
Scheme, Jaipur
PH:91-0-93146-10438, 0141-2440946
Mail: vipul8599@yahoo.com
REV. NO. 00 DATE: 17-05-2013

TITLE:-
SUBMISSION DRAWING
GROUND FLOOR EXTERNAL FIRE
HYDRANT & SPRINKLER PLAN

SCALE :- 1 = 100

DATE :- 08-06-2013

NORTH:-



PROJECT:-
PROPOSED COMMERCIAL BUILDING
AT KHASRA NO. -17,37&38,
SAHAKAR MARG, LAL KOTHI SCHEME,
VIL. - BHOJPURA, TEH. - JAIPUR.




ARCHITECTS:-
Tushar Sogani Designs Pvt. Ltd.
architects n designers
F-72, 105, "SURYODAY", '105', Subhash Marg,
Bagadiya Bhawan, C-Scheme, Jaipur.
TEL: +91-141-4004560, 4004537
email : tsdpljpr@rediffmail.com
website : www.tsdlarch.com

OWNER

ARCHITECTS

SHEET NO. - 05

**SUBMISSION DRAWING
SECTIONS & FIRE
SCHEMATIC LAYOUT**

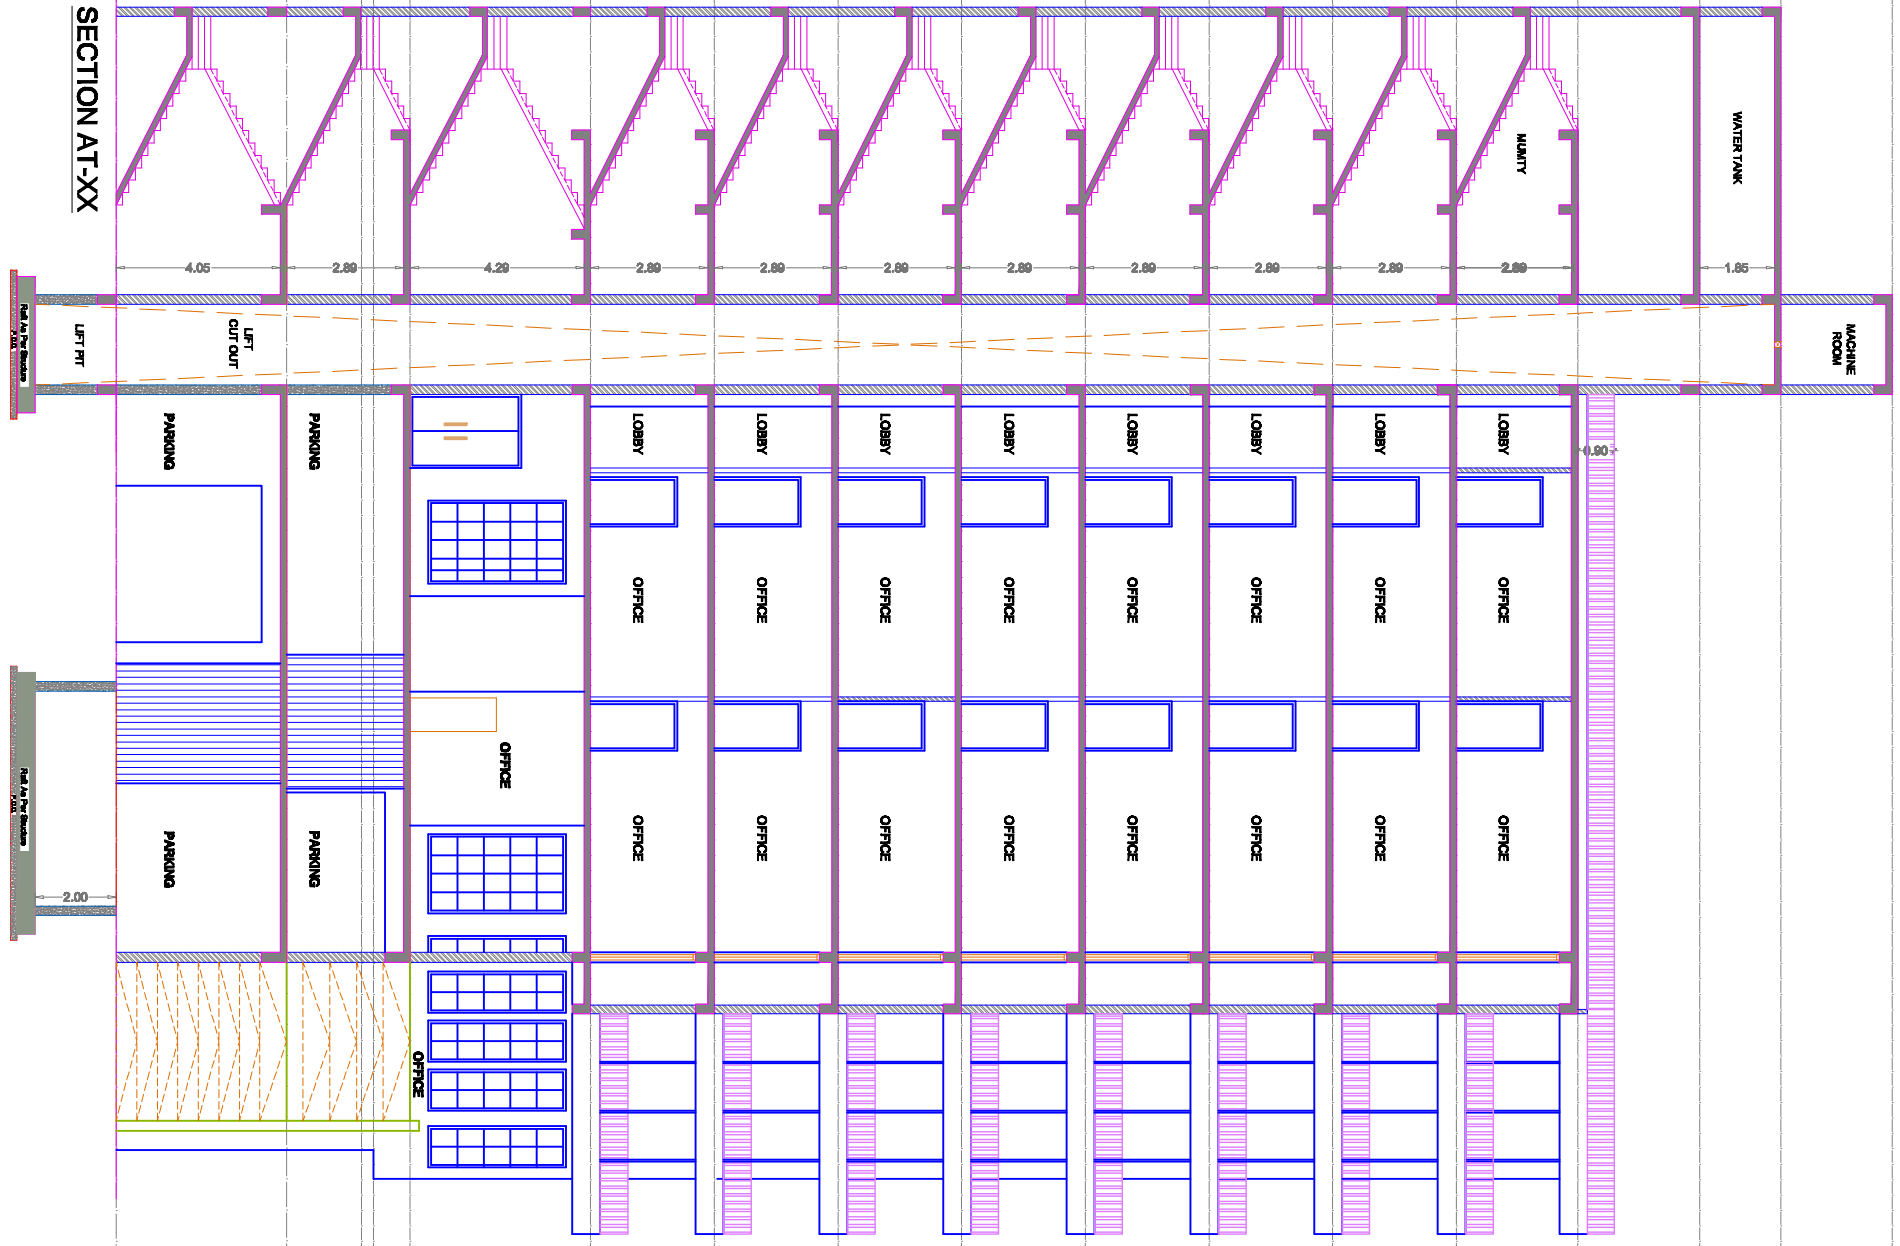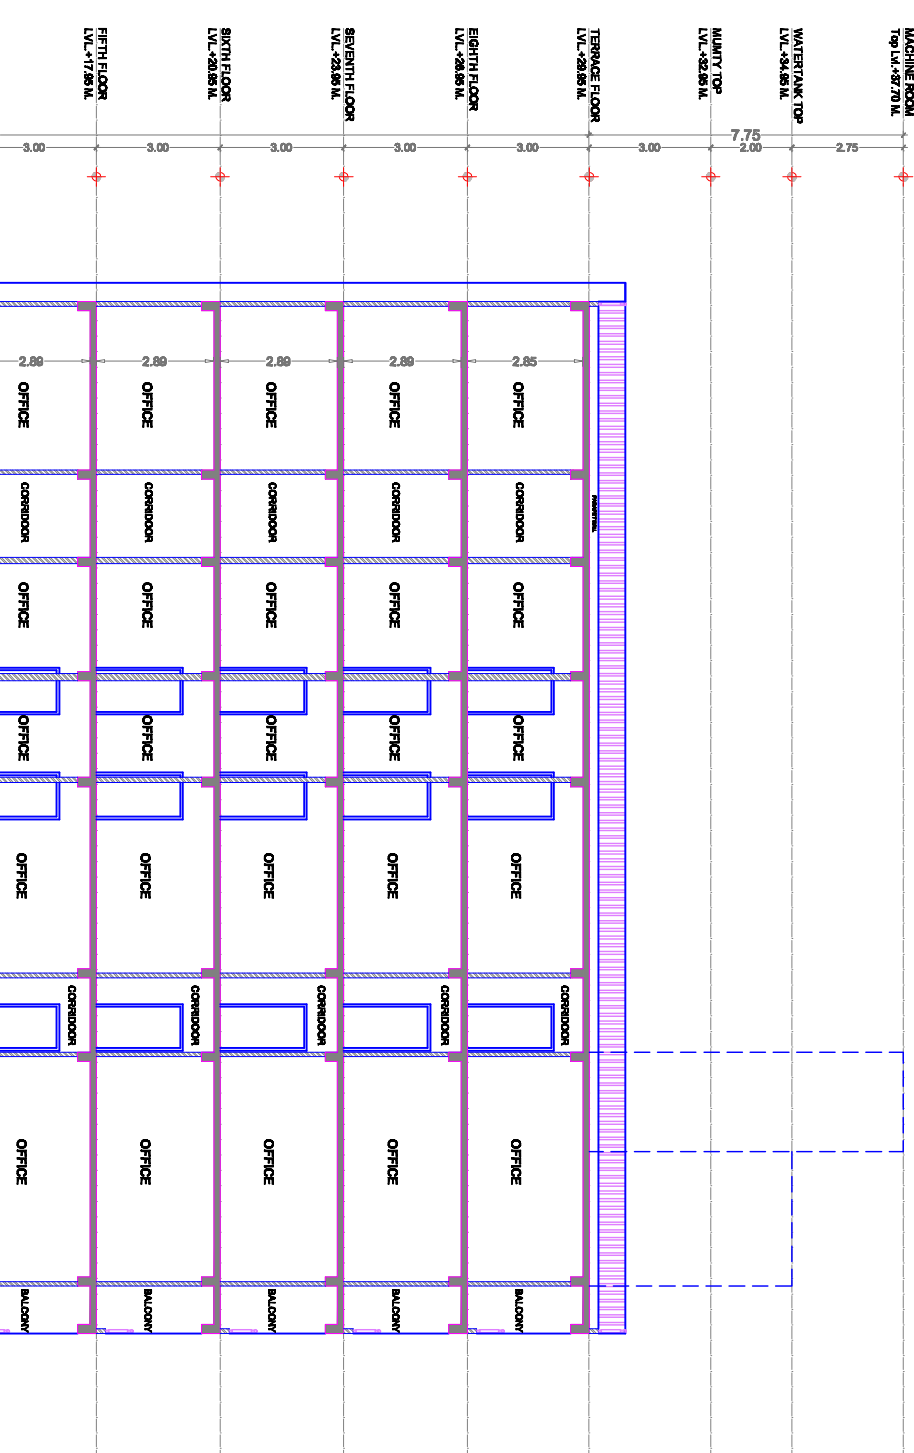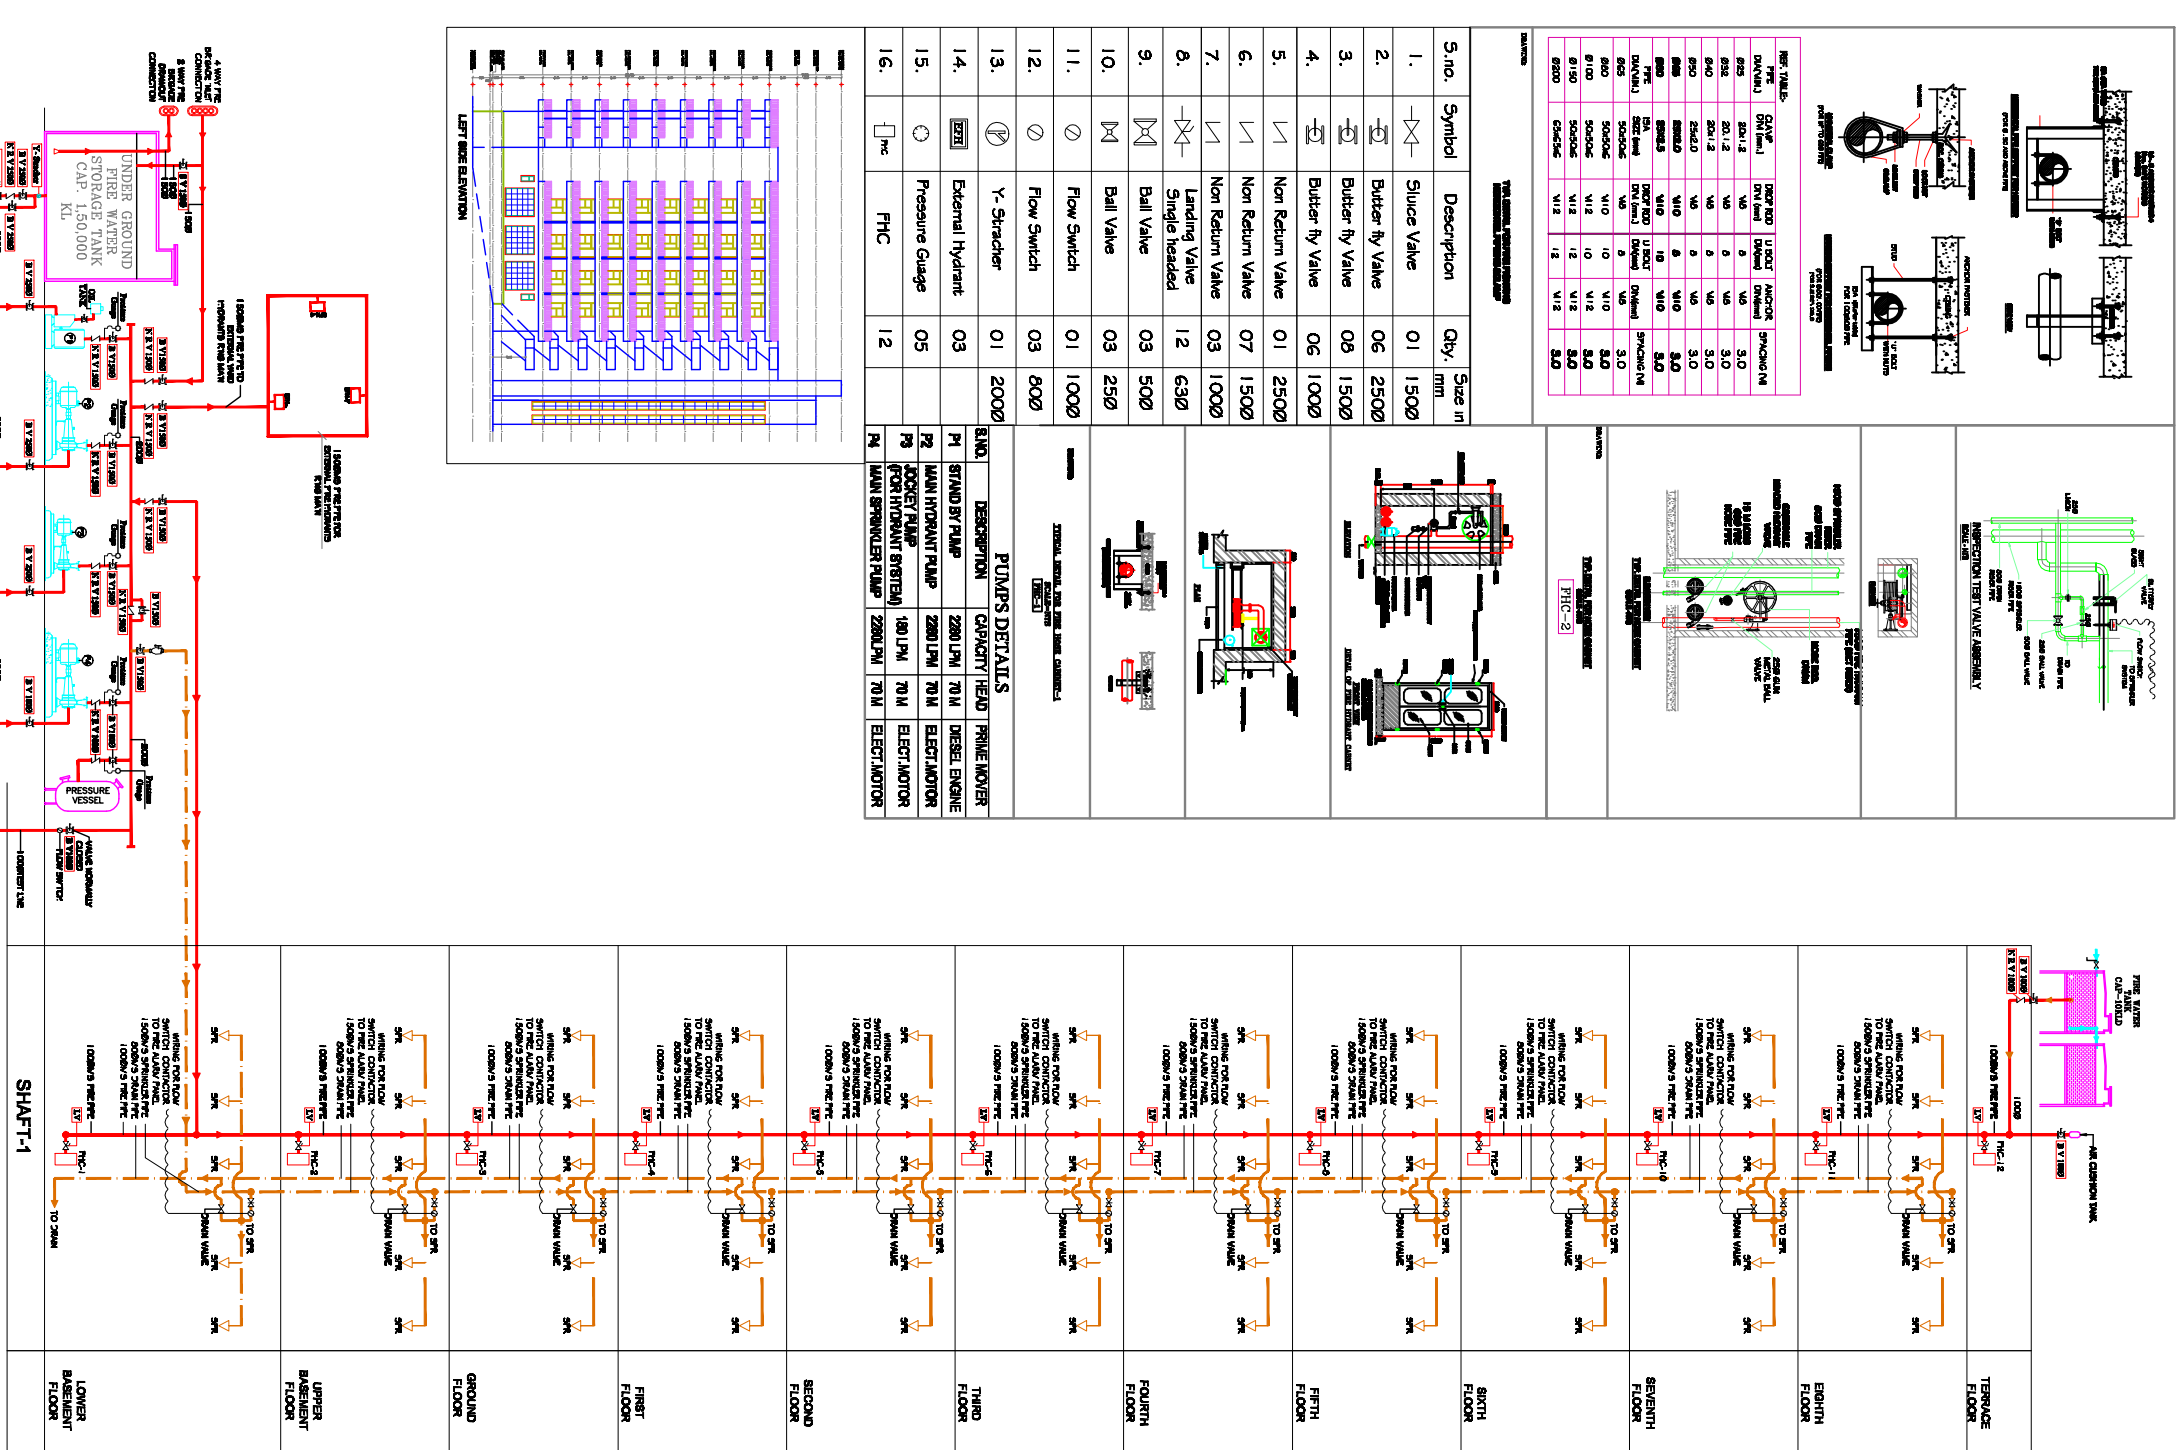

TITLE:-		SUBMISSION DRAWING	
SECTIONS & FIRE		SCHEMATIC LAYOUT	
SCALE :- 1 = 200	NORTH:-		
DATE :- 08-06-2013			
PROJECT:-			
PROPOSED COMMERCIAL BUILDING AT KHASRA NO. -17.37&38, SAHAKAR MARG,LAL KOTHI SCHEME, VILL.- BHOUPURA,TEH.-JAIPUR.			
ARCHITECTS:-			
Tushtar Sogani Designs Pvt. Ltd. architects n designers F-72, 105, "SURYODAYA", "105", Subhash Marg, Bagadiya Bhawan, C-Scheme,Jaipur. TEL:-+91-141-4004560,4004537 email :- tsdclpjr@rediffmail.com website :- www.tsdclpjr.com			

OWNER	ARCHITECTS
-------	------------