


ROAD 30'-0" WIDE

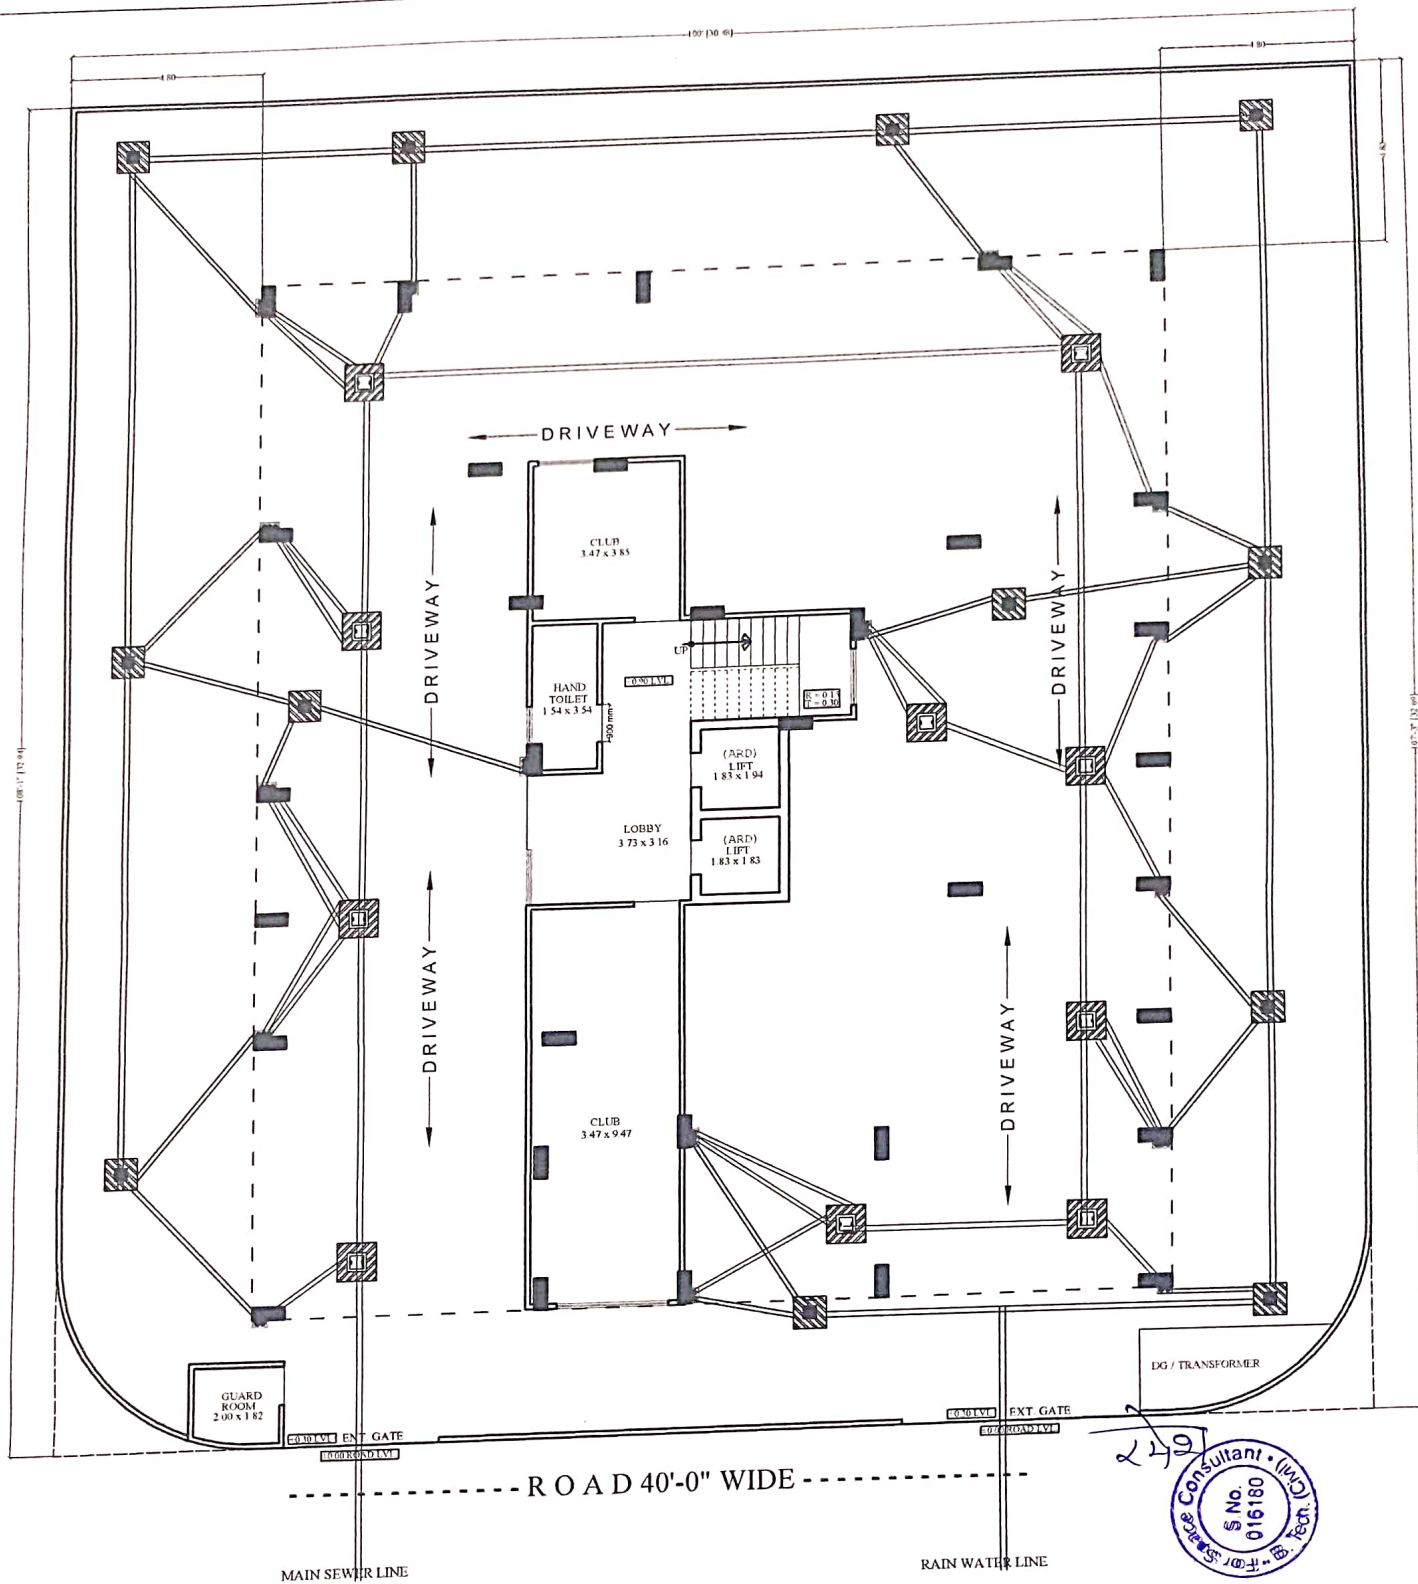

249




PROJECT TITLE :-
PROPOSED BUILDING AT PLOT
NO-A-211,A-212,A-213,A-214,A-215,
A-216,A-217,A-218,A-219 & A-
220,NARAYAN VATIKA, JAIPUR

DRAWING TITLE :-
STILT FLOOR
SANITARY PLAN

SPACE CONSULTANT
PLOT-A-173, JAGDAMBA NAGAR, HEERAPURA
POWER HOWER, JAIPUR (RAJ) 302024


DRN. BY		DATE
APPD. BY		REVISION
SCALE	N.T.S	

NORTH

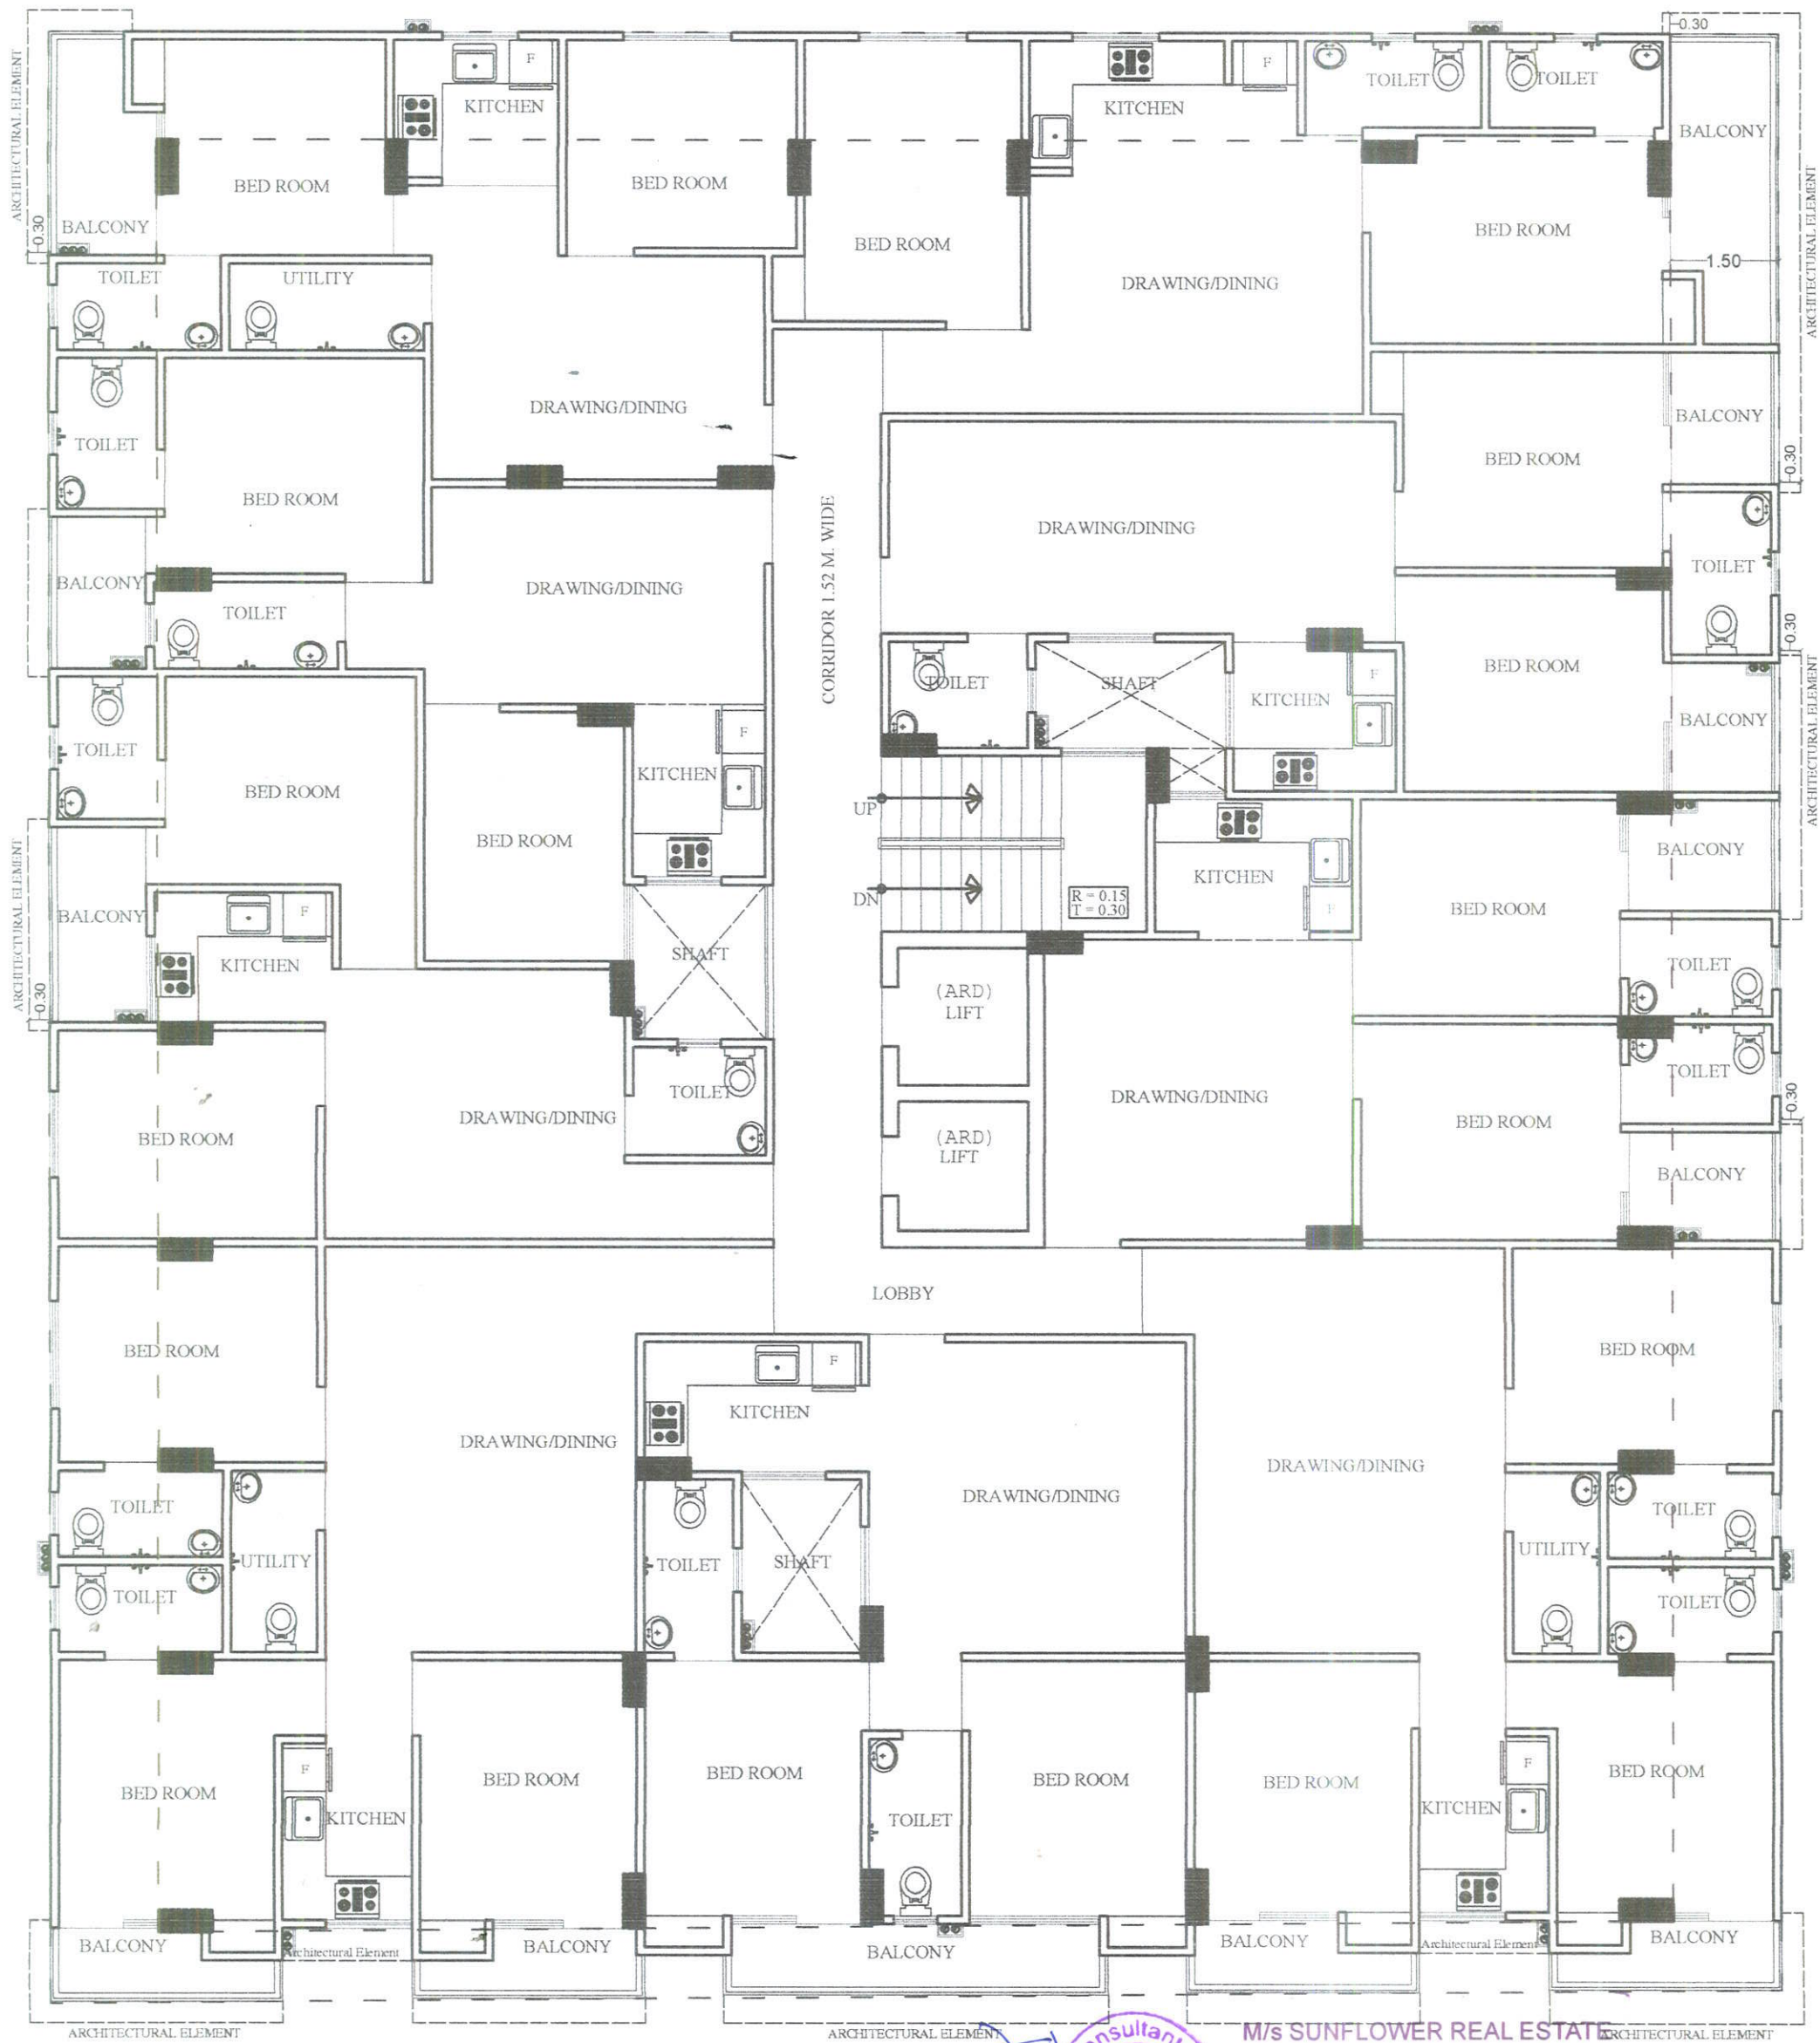

TYPICAL FLOOR SANITARY PLAN

<p>PROJECT TITLE :- PROPOSED BUILDING AT PLOT NO-A-211,A-212,A-213,A-214,A-215, A-216,A-217,A-218,A-219 & A- 220,NARAYAN VATIKA, JAIPUR</p>	<p>SPACE CONSULTANT PLOT-A-173, JAGDAMBA NAGAR, HEERAPURA POWER HOWER, JAIPUR (RAJ) 302024</p>	<p>DRN. BY APPD. BY SCALE N.T.S</p>	<p>M/S SUNFLOWER REAL ESTATE 24033 कुमार Partner NORTH DATE REVISION</p>
---	---	---	--

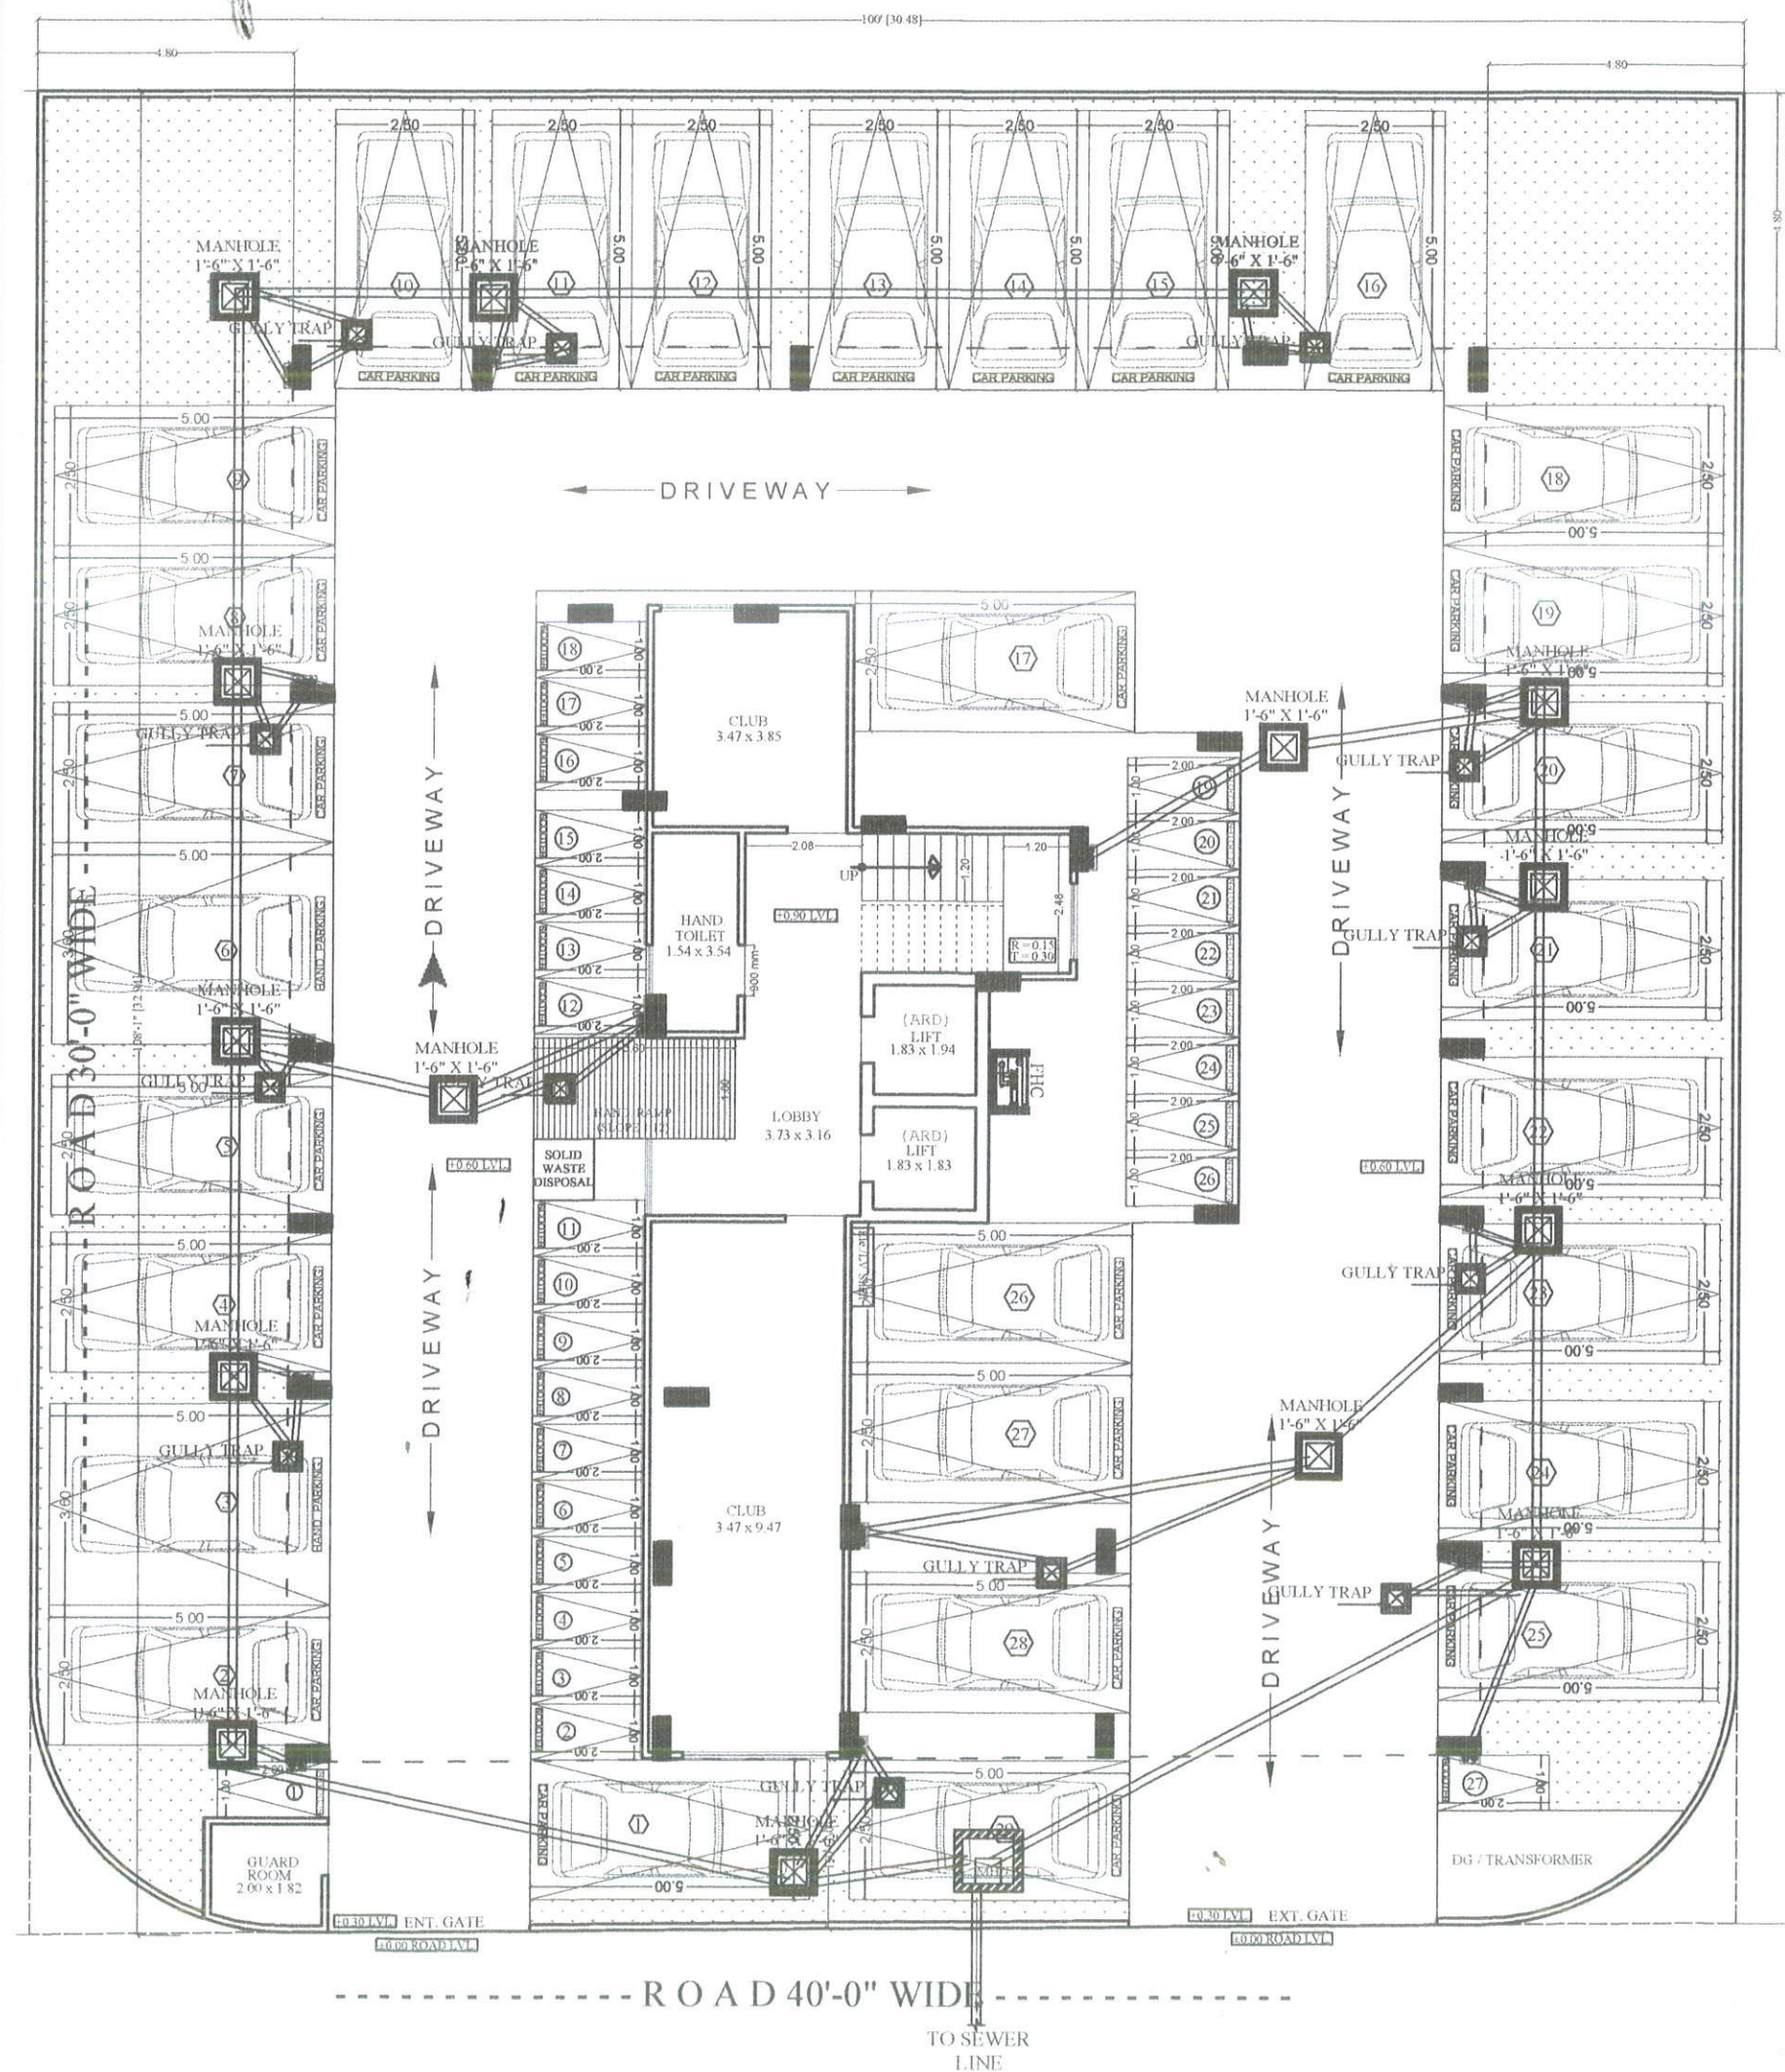

SYMBOL	DESCRIPTION
	110 mm Soil Waste Water Pipe
	110 mm Waste Water Pipe
	110 mm Rain Water Pipe
	160 mm Soil Waste Water Pipe Slope 1:150
	110 mm Soil Waste Water Pipe Slope 1:150
	110 mm Waste Water Pipe Slope 1:150
	75 mm Waste Water Pipe Slope 1:150
	50mm Waste Water Pipe Bottle Trap
	Floor Trap
	P-Trap Required
	Gully Trap - 12"X12" Depth According to Slope
	Main Hole - 18"X18" Depth According to Slope
	Main Hole - 24"X24" Depth According to Slope
	Main Hole - 36"X32" Depth According to Slope
	Flow Direction

SIGN:-

SEAL:

SPACE CONSULTANT
PLOT-A-173, JAGDAMBA NAGAR, HEERAPURA
POWER HOWER, JAIPUR (RAJ) 302024

ARCHITECT :-
FRANK SQUARE
ARCHITECTURE | PLANNER | DESIGNER
C-49 VIDYA APARTMENT PARAS MARG,
BAPU NAGAR JAIPUR, (RAJ.)
Email-afranksquare@gmail.com
Mobile-9461302542

PROJECT :-
PROPOSED BUILDING AT PLOT
NO-A-211,A-212,A-213,A-214,A-215,
A-216,A-217,A-218,A-219 & A-
220,NARAYAN VATIKA, JAIPUR

DRAWING:
**STILT FLOOR
EXTERNAL SEWERAGE
CHAMBER & PIPE ROUTE FOR
RERA SUBMISSION PLAN**

DATE
18-08-2023

SCALE:-
N.T.S.

M/s SUNFLOWER REAL ESTATE
अशोक कुमार
Partner