


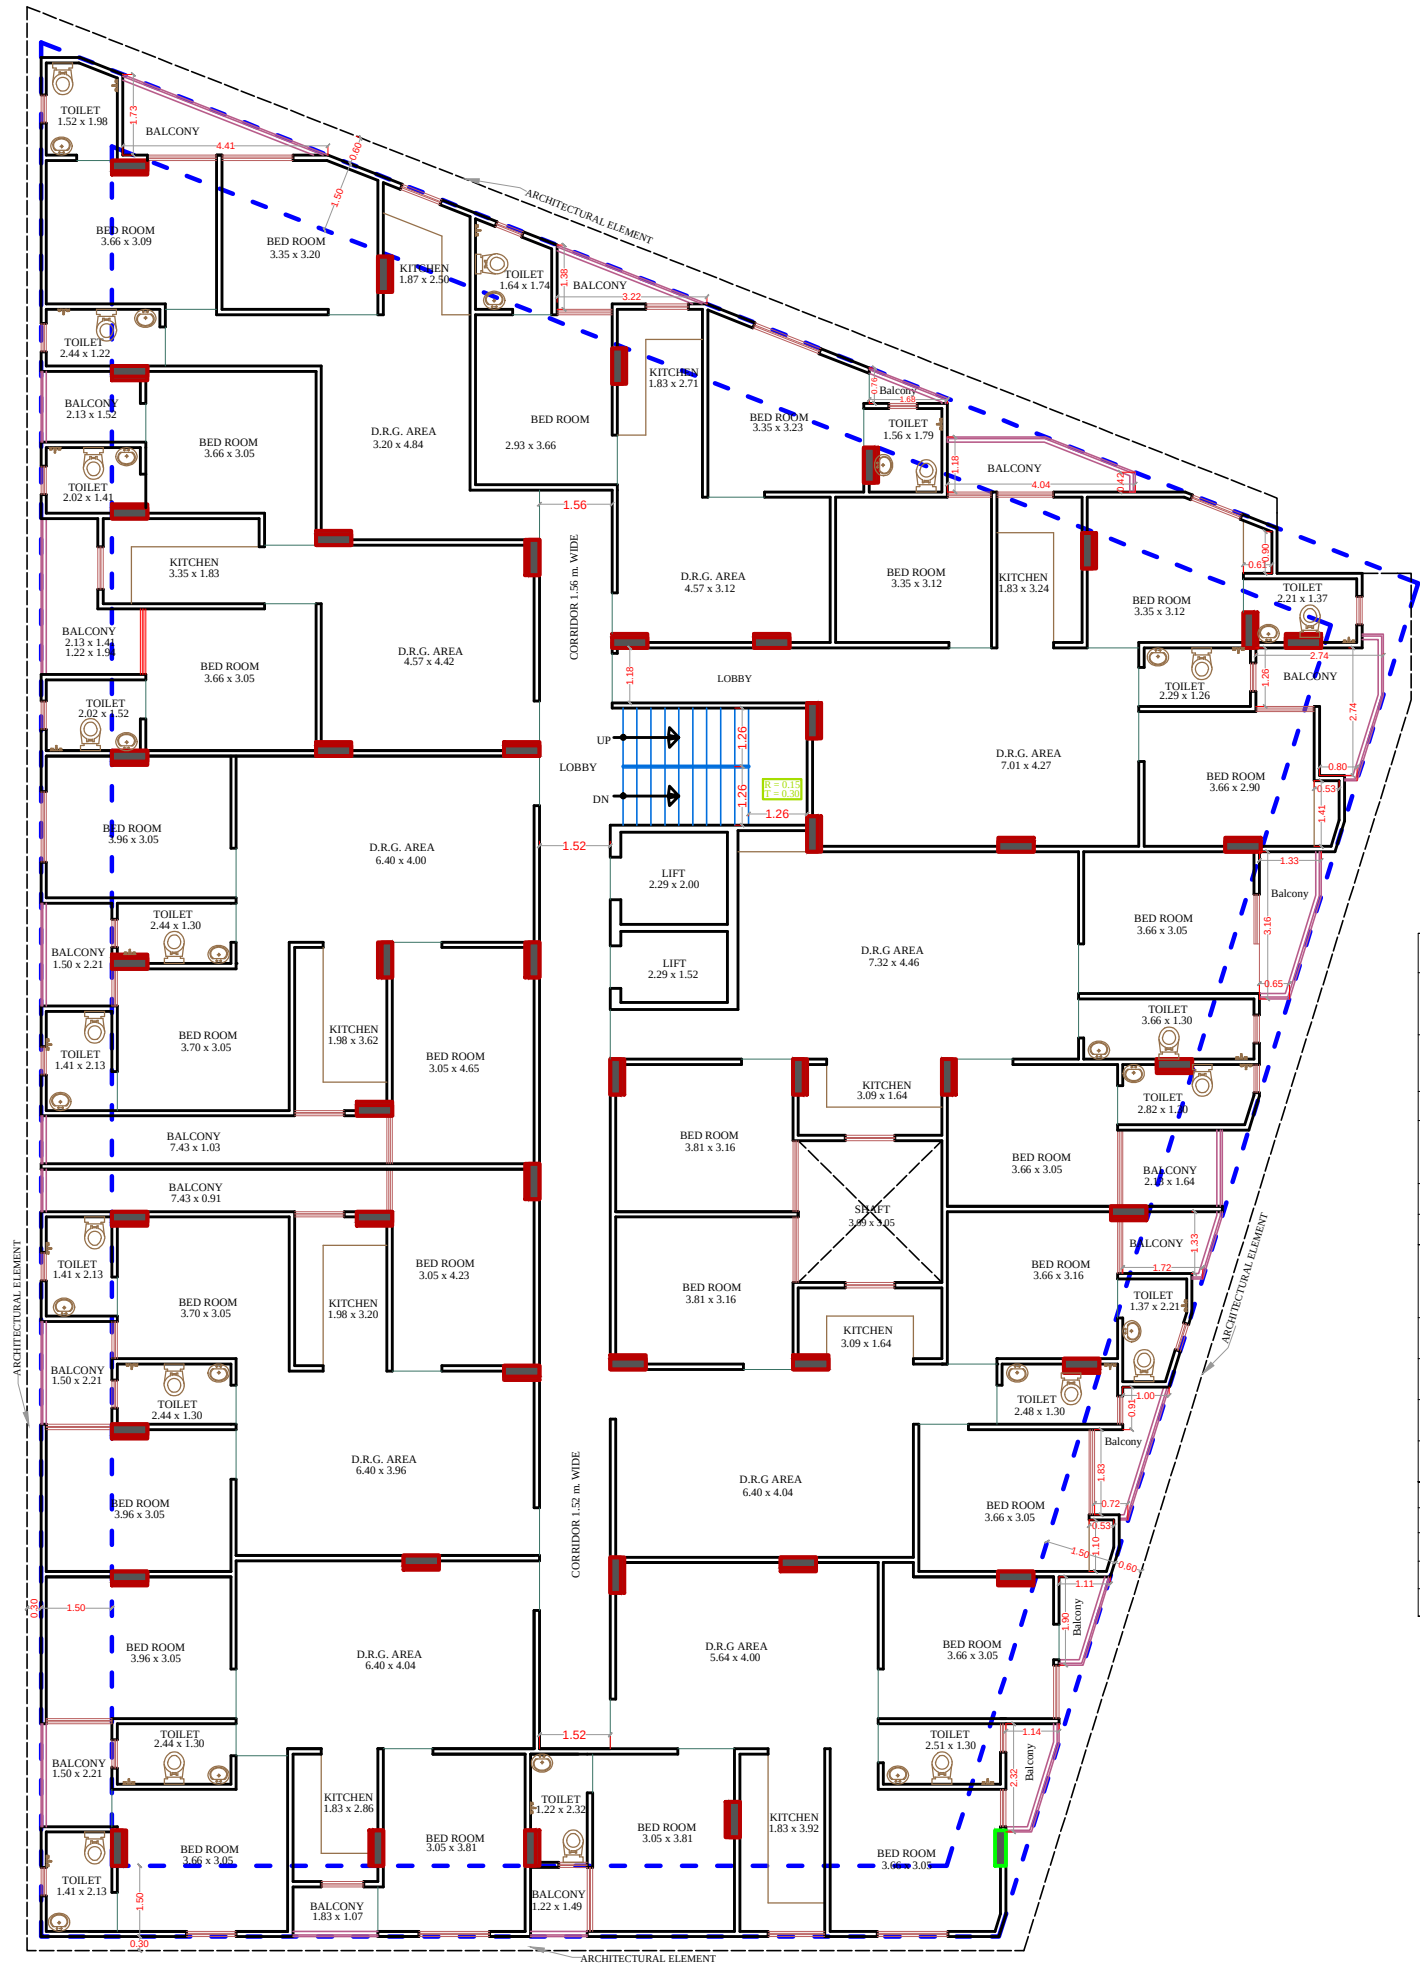

GROUND, 1st TO 5th FLOOR PLAN

All Heights For Finish Floor Lvl	SYMBOL	SYMBOL	DESCRIPTION
+1000MM			Ø 20MM CWS PIPE THRU WALL CHASE TO SINK
+1950MM			Ø 20MM HWS PIPE THRU WALL CHASE TO GEYSER
+1500MM			Ø 20MM CWS PIPE THRU WALL CHASE TO AQUAGUARD
+450MM			Ø 20MM CWS PIPE THRU WALL CHASE TO BASIN ANGLE VALVE
+800MM			Ø 20MM HWS PIPE THRU WALL CHASE TO BASIN ANGLE VALVE
+2100MM			Ø 20MM CWS PIPE THRU WALL CHASE TO CONCEALED STOP COCK
+300MM			Ø 20MM CWS PIPE THRU WALL CHASE TO FAUCET
+1800MM WALL MIXER DIVERTOR +2025MM OIL SHOWER			Ø 20MM HWS PIPE THRU WALL CHASE TO WALL MIXER / DIVERTOR
+600MM			Ø 20MM CWS PIPE THRU WALL CHASE TO TAP
+450MM			Ø 20MM CWS PIPE THRU WALL CHASE TO CISTERN ANGLE VALVE
+1200MM			Ø 20MM CWS PIPE THRU WALL CHASE TO URINAL ANGLE VALVE
+450MM			Ø 20MM CWS PIPE THRU WALL CHASE TO BASIN ANGLE VALVE
+1000MM	AS PER/ARCH.		SOAP DISH
+1500MM	AS PER/ARCH.		TOWEL RAIL
+450MM	AS PER/ARCH.		PAPER HOLDER
			COLD WATER SUPPLY LINE
			HOT WATER SUPPLY LINE

RAMESH KUMAWAT
M.E.P. CONSULTANT
B.E. CIVIL

PROJECT TITLE :- PROPOSED BUILDING AT PLOT. NO.-01, "KRISHNAM PEARL ESTATES", JAIPUR	DRAWING TITLE :- TYPICAL FLOOR PLUMBING	SERVICES CONSULTANT	DRN. BY		DATE	NORTH
			APPD. BY		REVISION	
			SCALE	N.T.S		

SYMBOL	DESCRIPTION
	110 mm Soil Waste Water Pipe
	110 mm Waste Water Pipe
	110 mm Rain Water Pipe
	160 mm Rain Water Pipe Slope 1:200
	110 mm Rain Water Pipe Slope 1:200
	RC-12"X12" Depth According to Slope
	RC-18"X18" Depth According to Slope
	RC-24"X24" Depth According to Slope
	Flow Direction

SEAL:-

RAMESH KUMAWAT
M.E.P. CONSULTANT
B.E. CIVIL

SPACE CONSULTANT
PLOT-A-173, JAGDAMBA NAGAR, HEERAPURA
POWER HOWER, JAIPUR (RAJ.) 302024


ARCHITECT :-

FRANK SQUARE
ARCHITECTURE | PLANNER | DESIGNER
C-49 VIDYA APARTMENT PARAS MARG,
BAPU NAGAR JAIPUR, (RAJ.)
Email-afranksquare@gmail.com
Mobile-9461302542

PROJECT :-
PROPOSED BUILDING AT PLOT.
NO.-01, "KRISHNAM PEARL
ESTATES", JAIPUR

DRAWING:
STILT FLOOR
EXTERNAL STORM DRAIN
AND RAIN WATER CHAMBER
PIPE ROUTE FOR
RERA SUBMISSION PLAN

DATE	
SCALE:-	N.T.S.

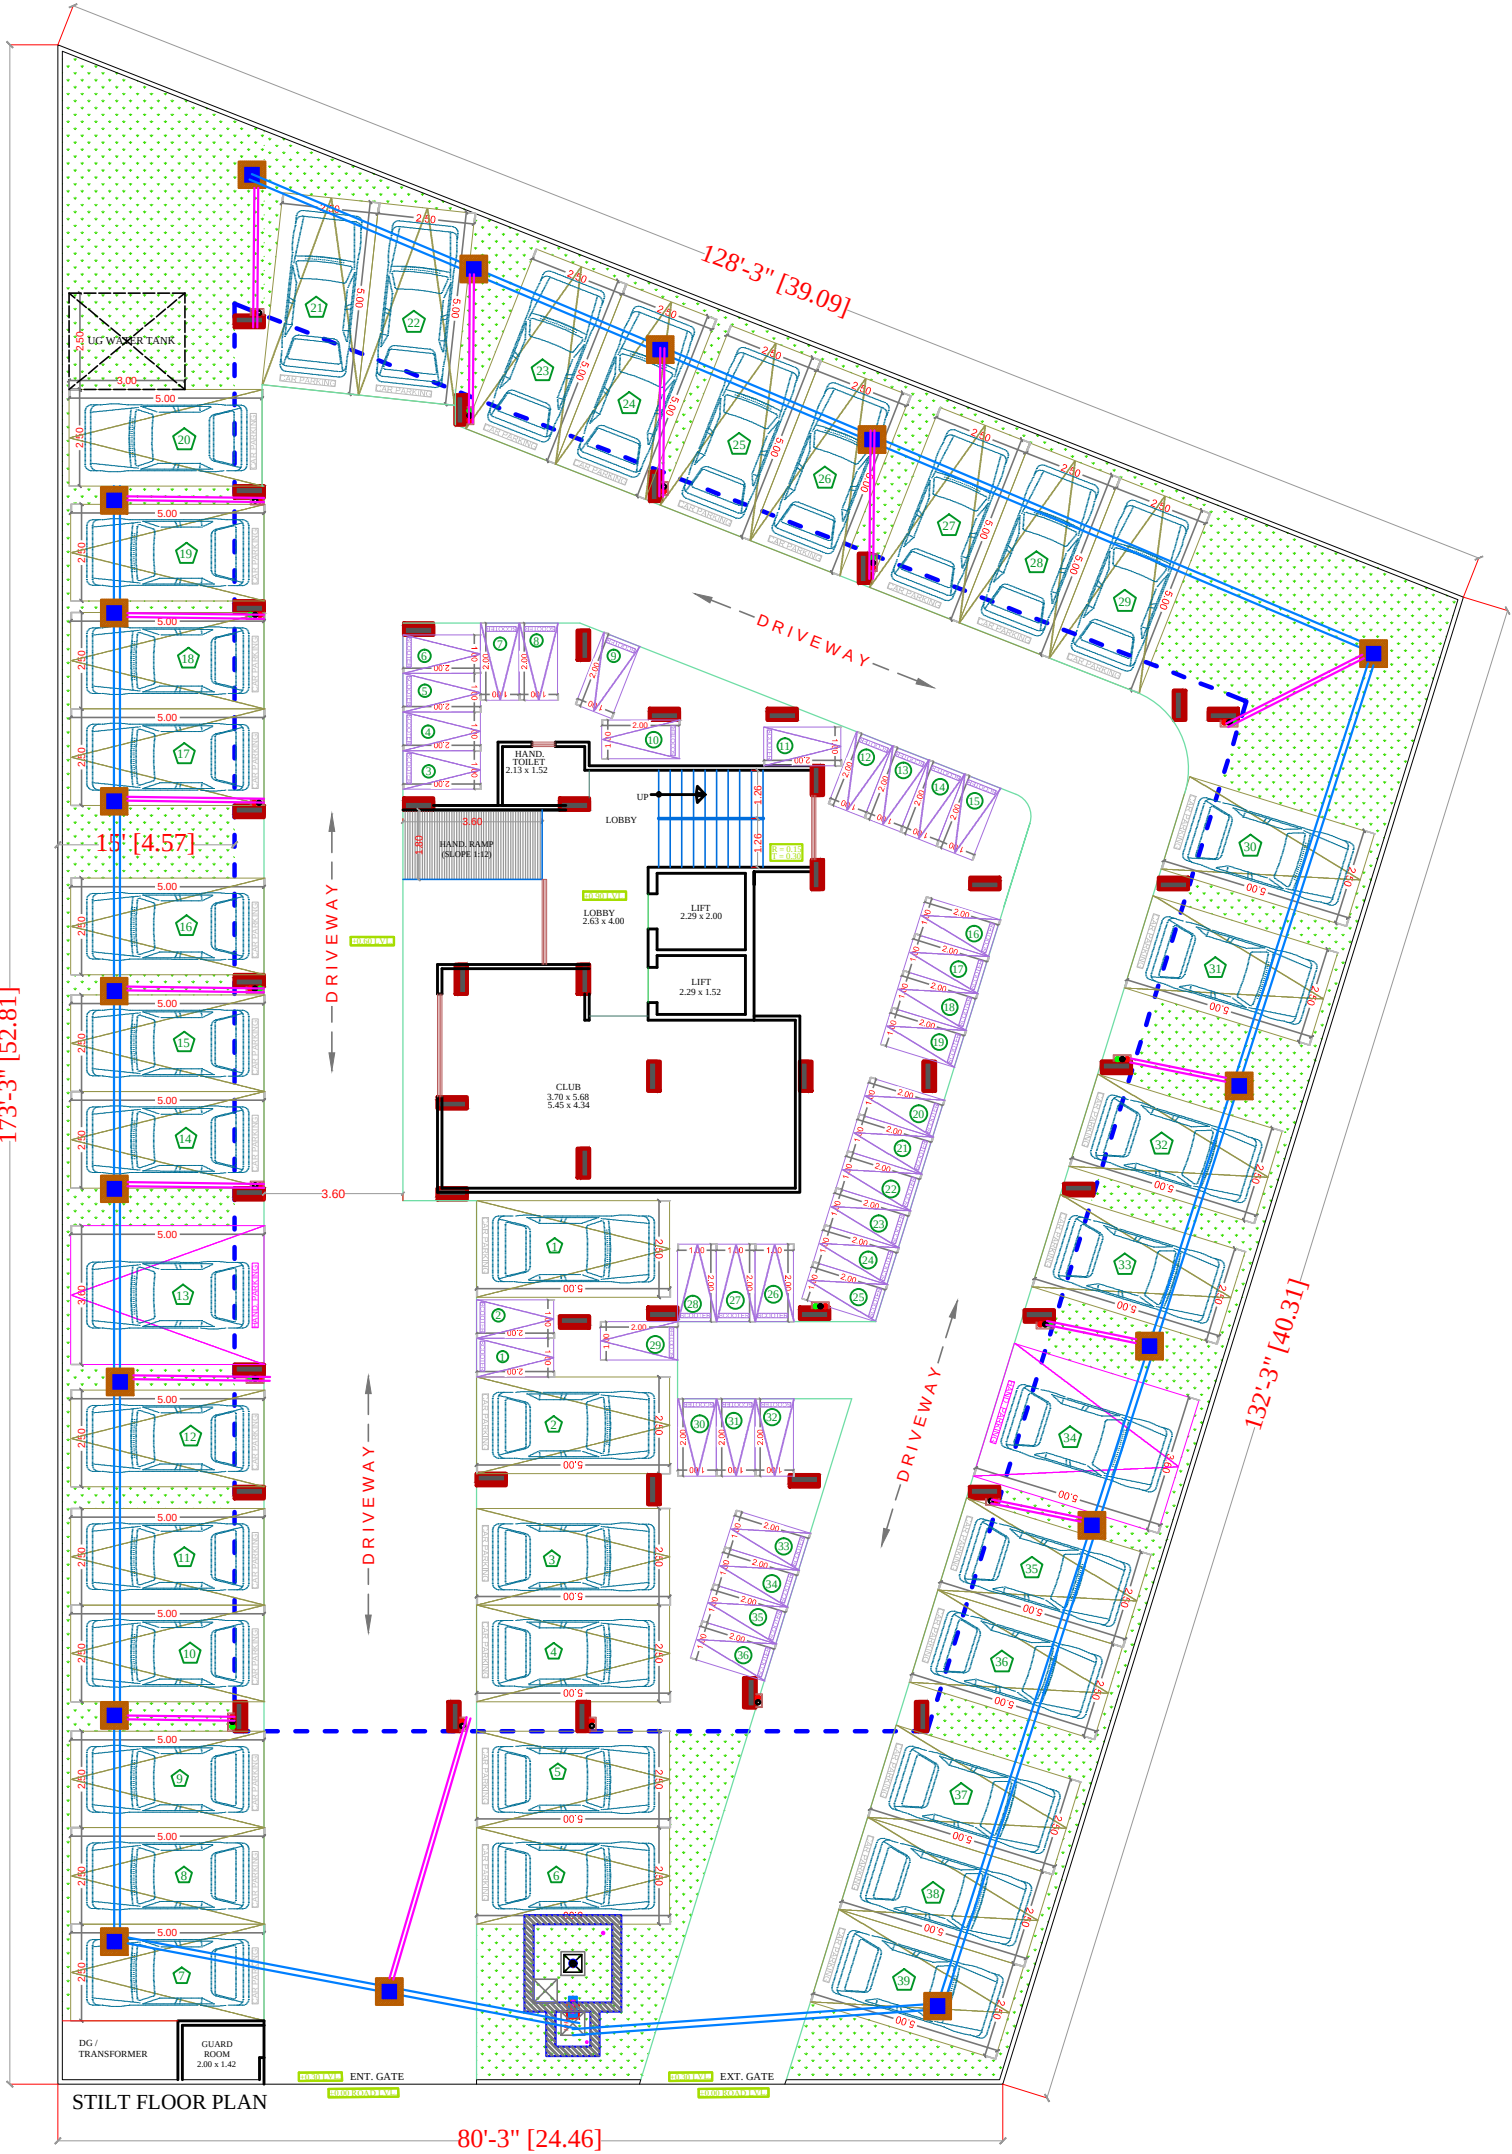

---- PROPOSED ROAD 60'-0" WIDE ----



SEAL:-


RAMESH KUMAWAT
M.E.P. CONSULTANT
B.E. CIVIL

ARCHITECT :-
 **FRANK SQUARE**
 ARCHITECTURE | PLANNER | DESIGNER
 C-49 VIDYA APARTMENT PARAS MARG,
 BAPU NAGAR JAIPUR, (RAJ.)
 Email-afranksquare@gmail.com
 Mobile-9461302542

DRAWING: STILT FLOOR
EXTERNAL SEWERAGE
CHAMBER & PIPE ROUTE FOR
RERA SUBMISSION PLAN

DATE	
SCALE:- N.T.S.	