

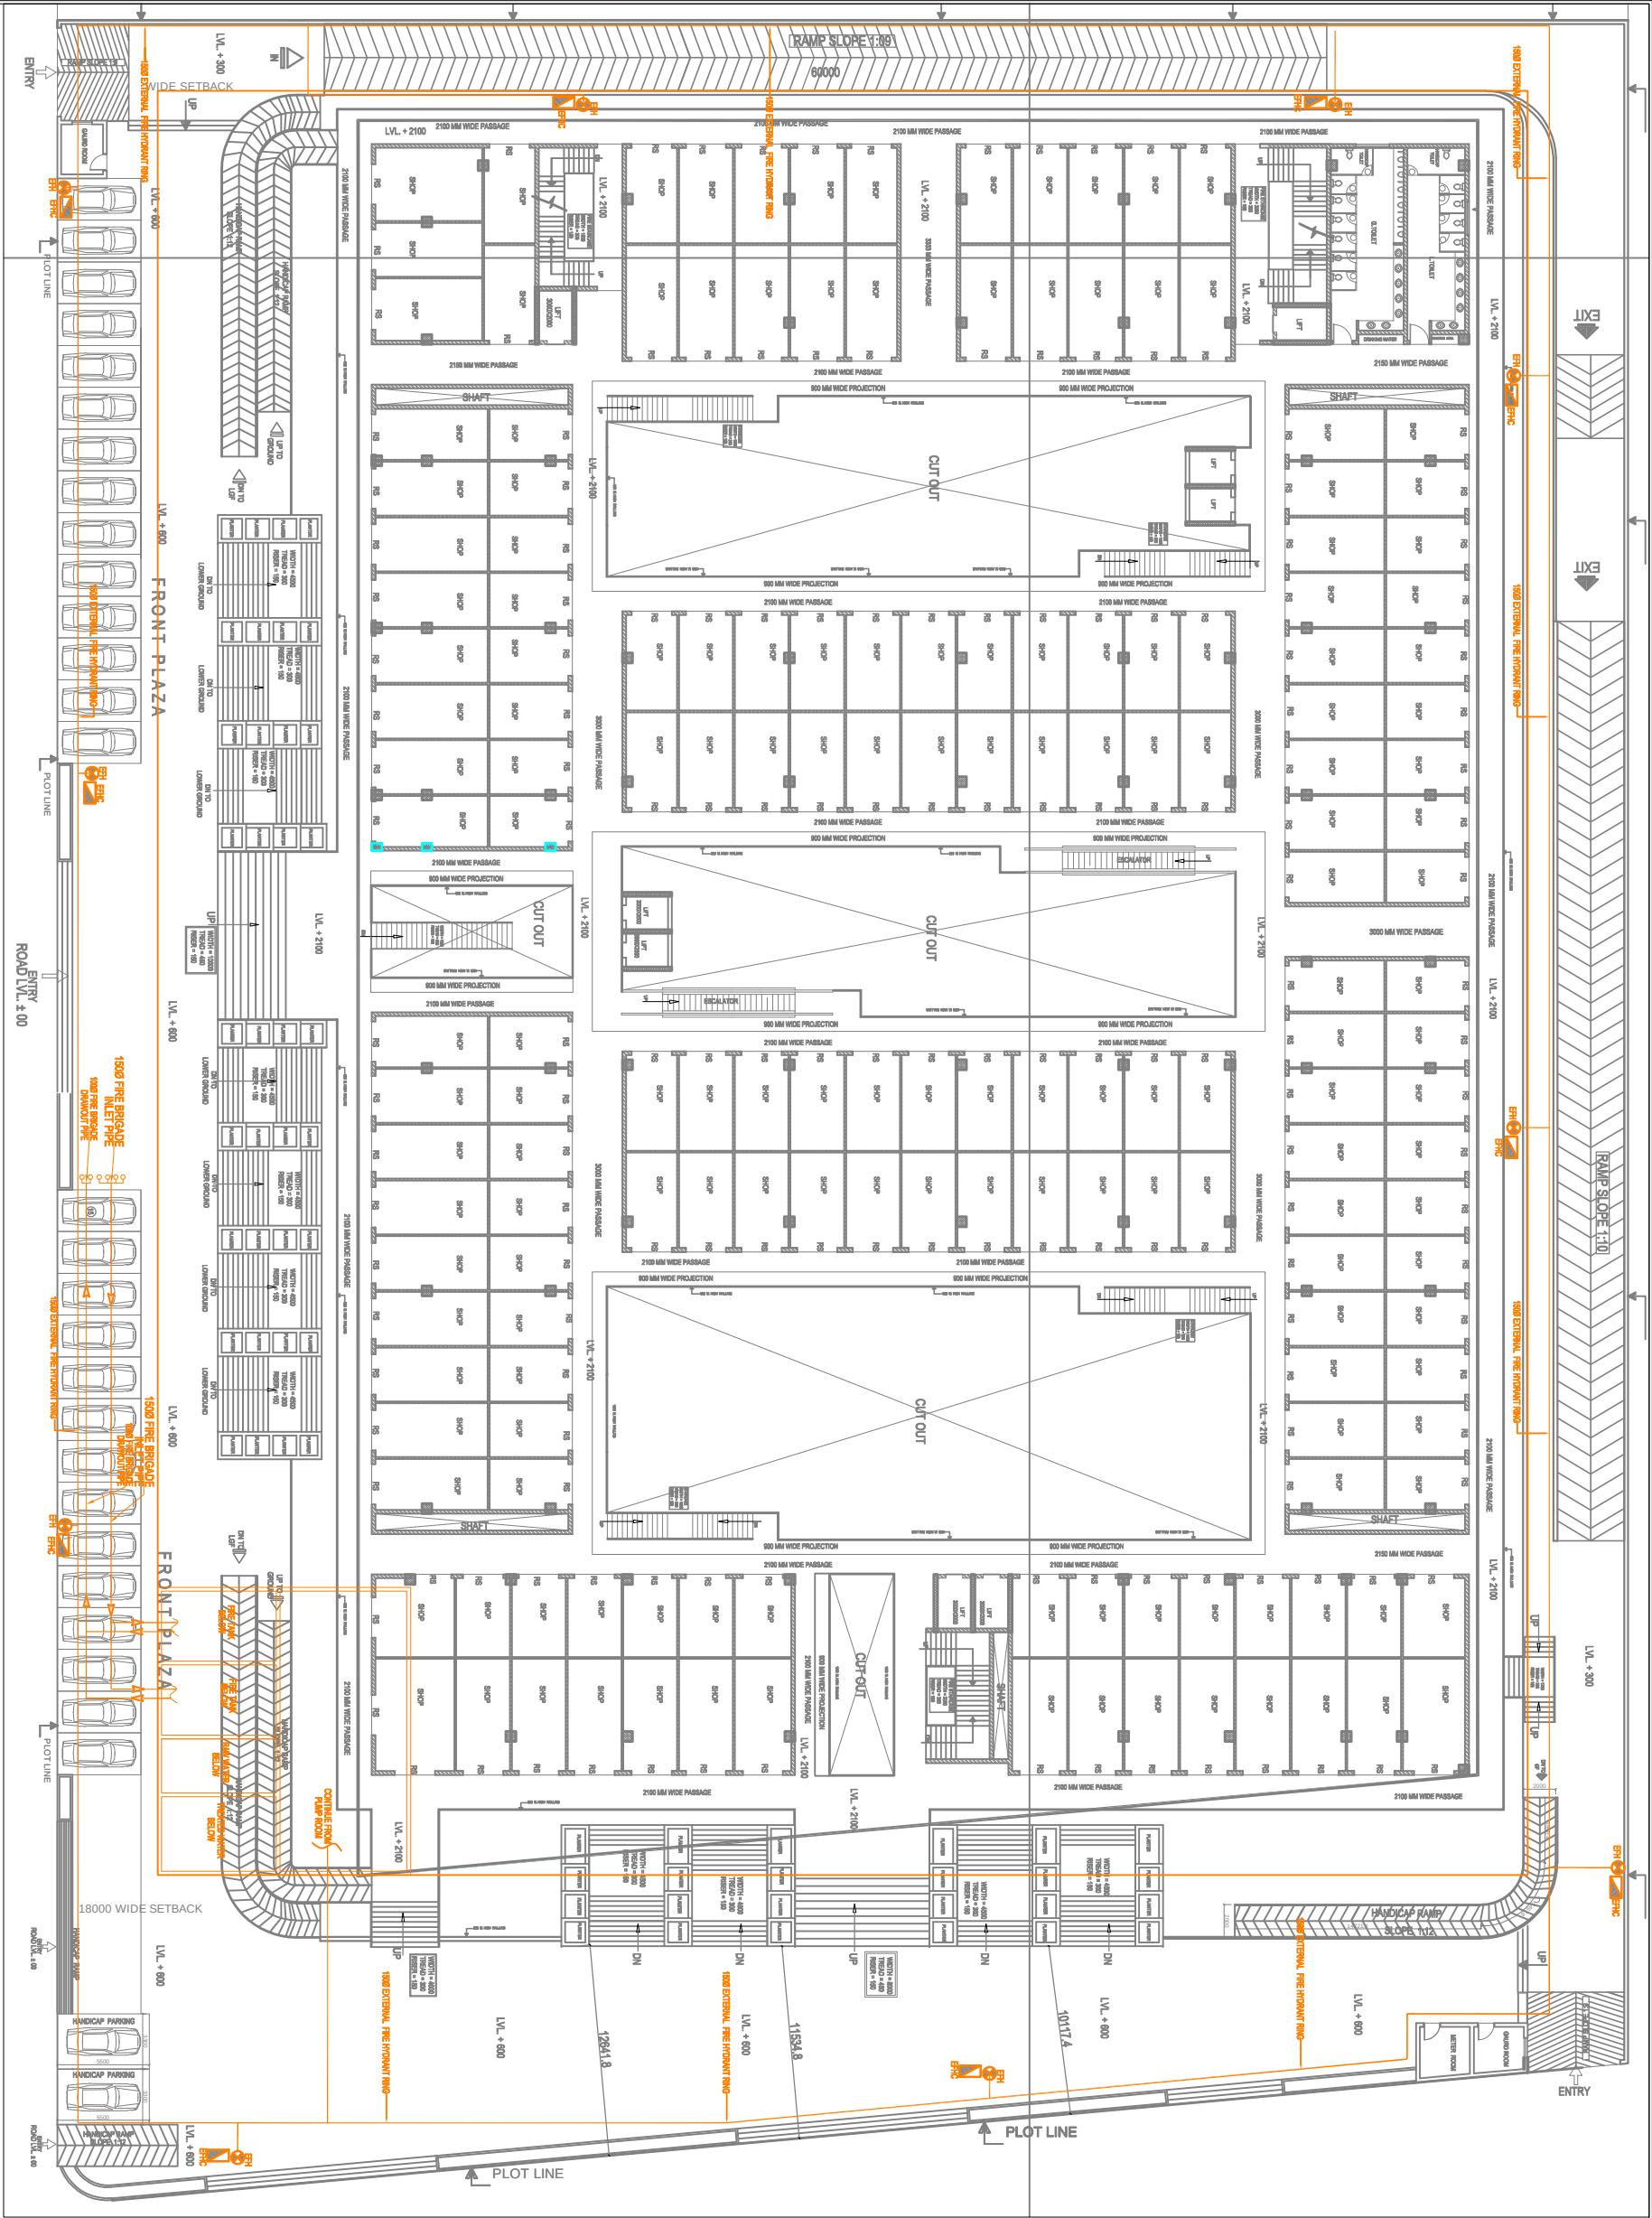
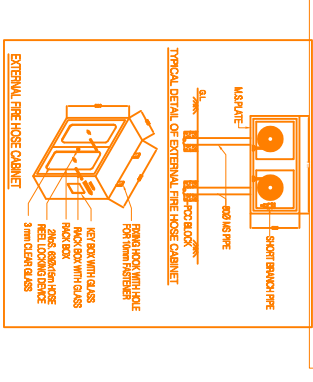
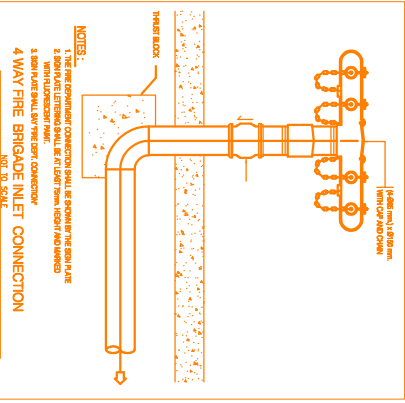


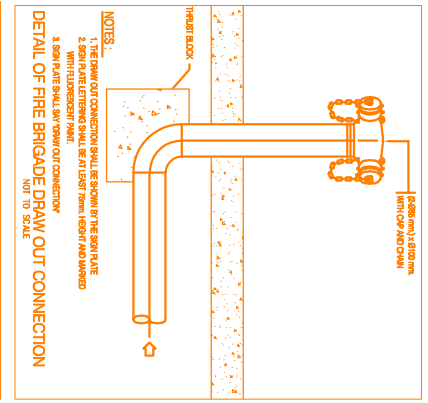

FIRE FIGHTING LEGEND:-	
	EXTERNAL FIRE HYDRANT
	EXTERNAL FIRE HYDRANT CABINET
	EXTERNAL FIRE HYDRANT PIPE
	4WAY FIRE BRIGADE INLET CONNECTION
	2WAY FIRE BRIGADE INLET CONNECTION
	FIRE HOSE CABINET

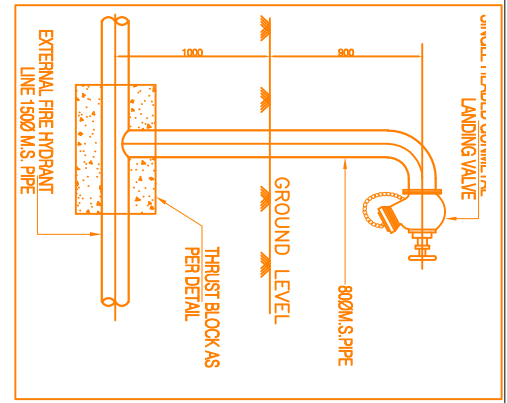

RERA SUBMISSION DRAWING

CLIENT M/S R-TECH CAPITAL
HIGHESTREY(JAIPUR) LTD.

ARCHITECT-
ARCHITECT SIGN.

MEP CONSULTANT:
Acrobat Engineers Pvt.Ltd.

DRAWING TITLE :
FIRE FIGHTING LAYOUT

DATE 11-07-2017

DRG. NO. AEA/JM/SP/FF-01

PROJECT PROPOSED SITE PLAN OF PLOT
NO. CP1-231 FOR MULTIPLEX
ALLIOTED TO M/S R-TECH CAPITAL
CAPITAL HIGHESTREY (JAIPUR) LTD.
AT INDUSTRIAL AREA APPAREL PARK JAIPUR.



Acrobat Engineers Pvt.Ltd.
H.No. 19 Block-18
Basement Level, Spring Field Colony
Faridabad (Haryana)
Tel. : 0129-4056009
customerservice@acrobateengineers.com

SITE PLAN
FIRE FIGHTING LAYOUT

DEALT AMIT MAURYA
CHECKED VIRENDRA

SCALE A1@ 1 : 200
REV. R0

