




LEGEND FOR FIRE FIGHTING	
	1500 M.S WETRISER FIRE PIPE
	1500 M.S SPRINKLER RISER PIPE
	800 M.S SPRINKLER DRAIN PIPE
	PENDENT TYPE SPRINKLER
	SIDE WALL TYPE SPRINKLER
	Hose Reel
	Manual call box
	CO2 fire extinguisher system
	EXTERNAL FIRE HYDRANT
	Hooter
	SPRINKLER HEADER PIPE
	SPRINKLER BRANCH PIPE

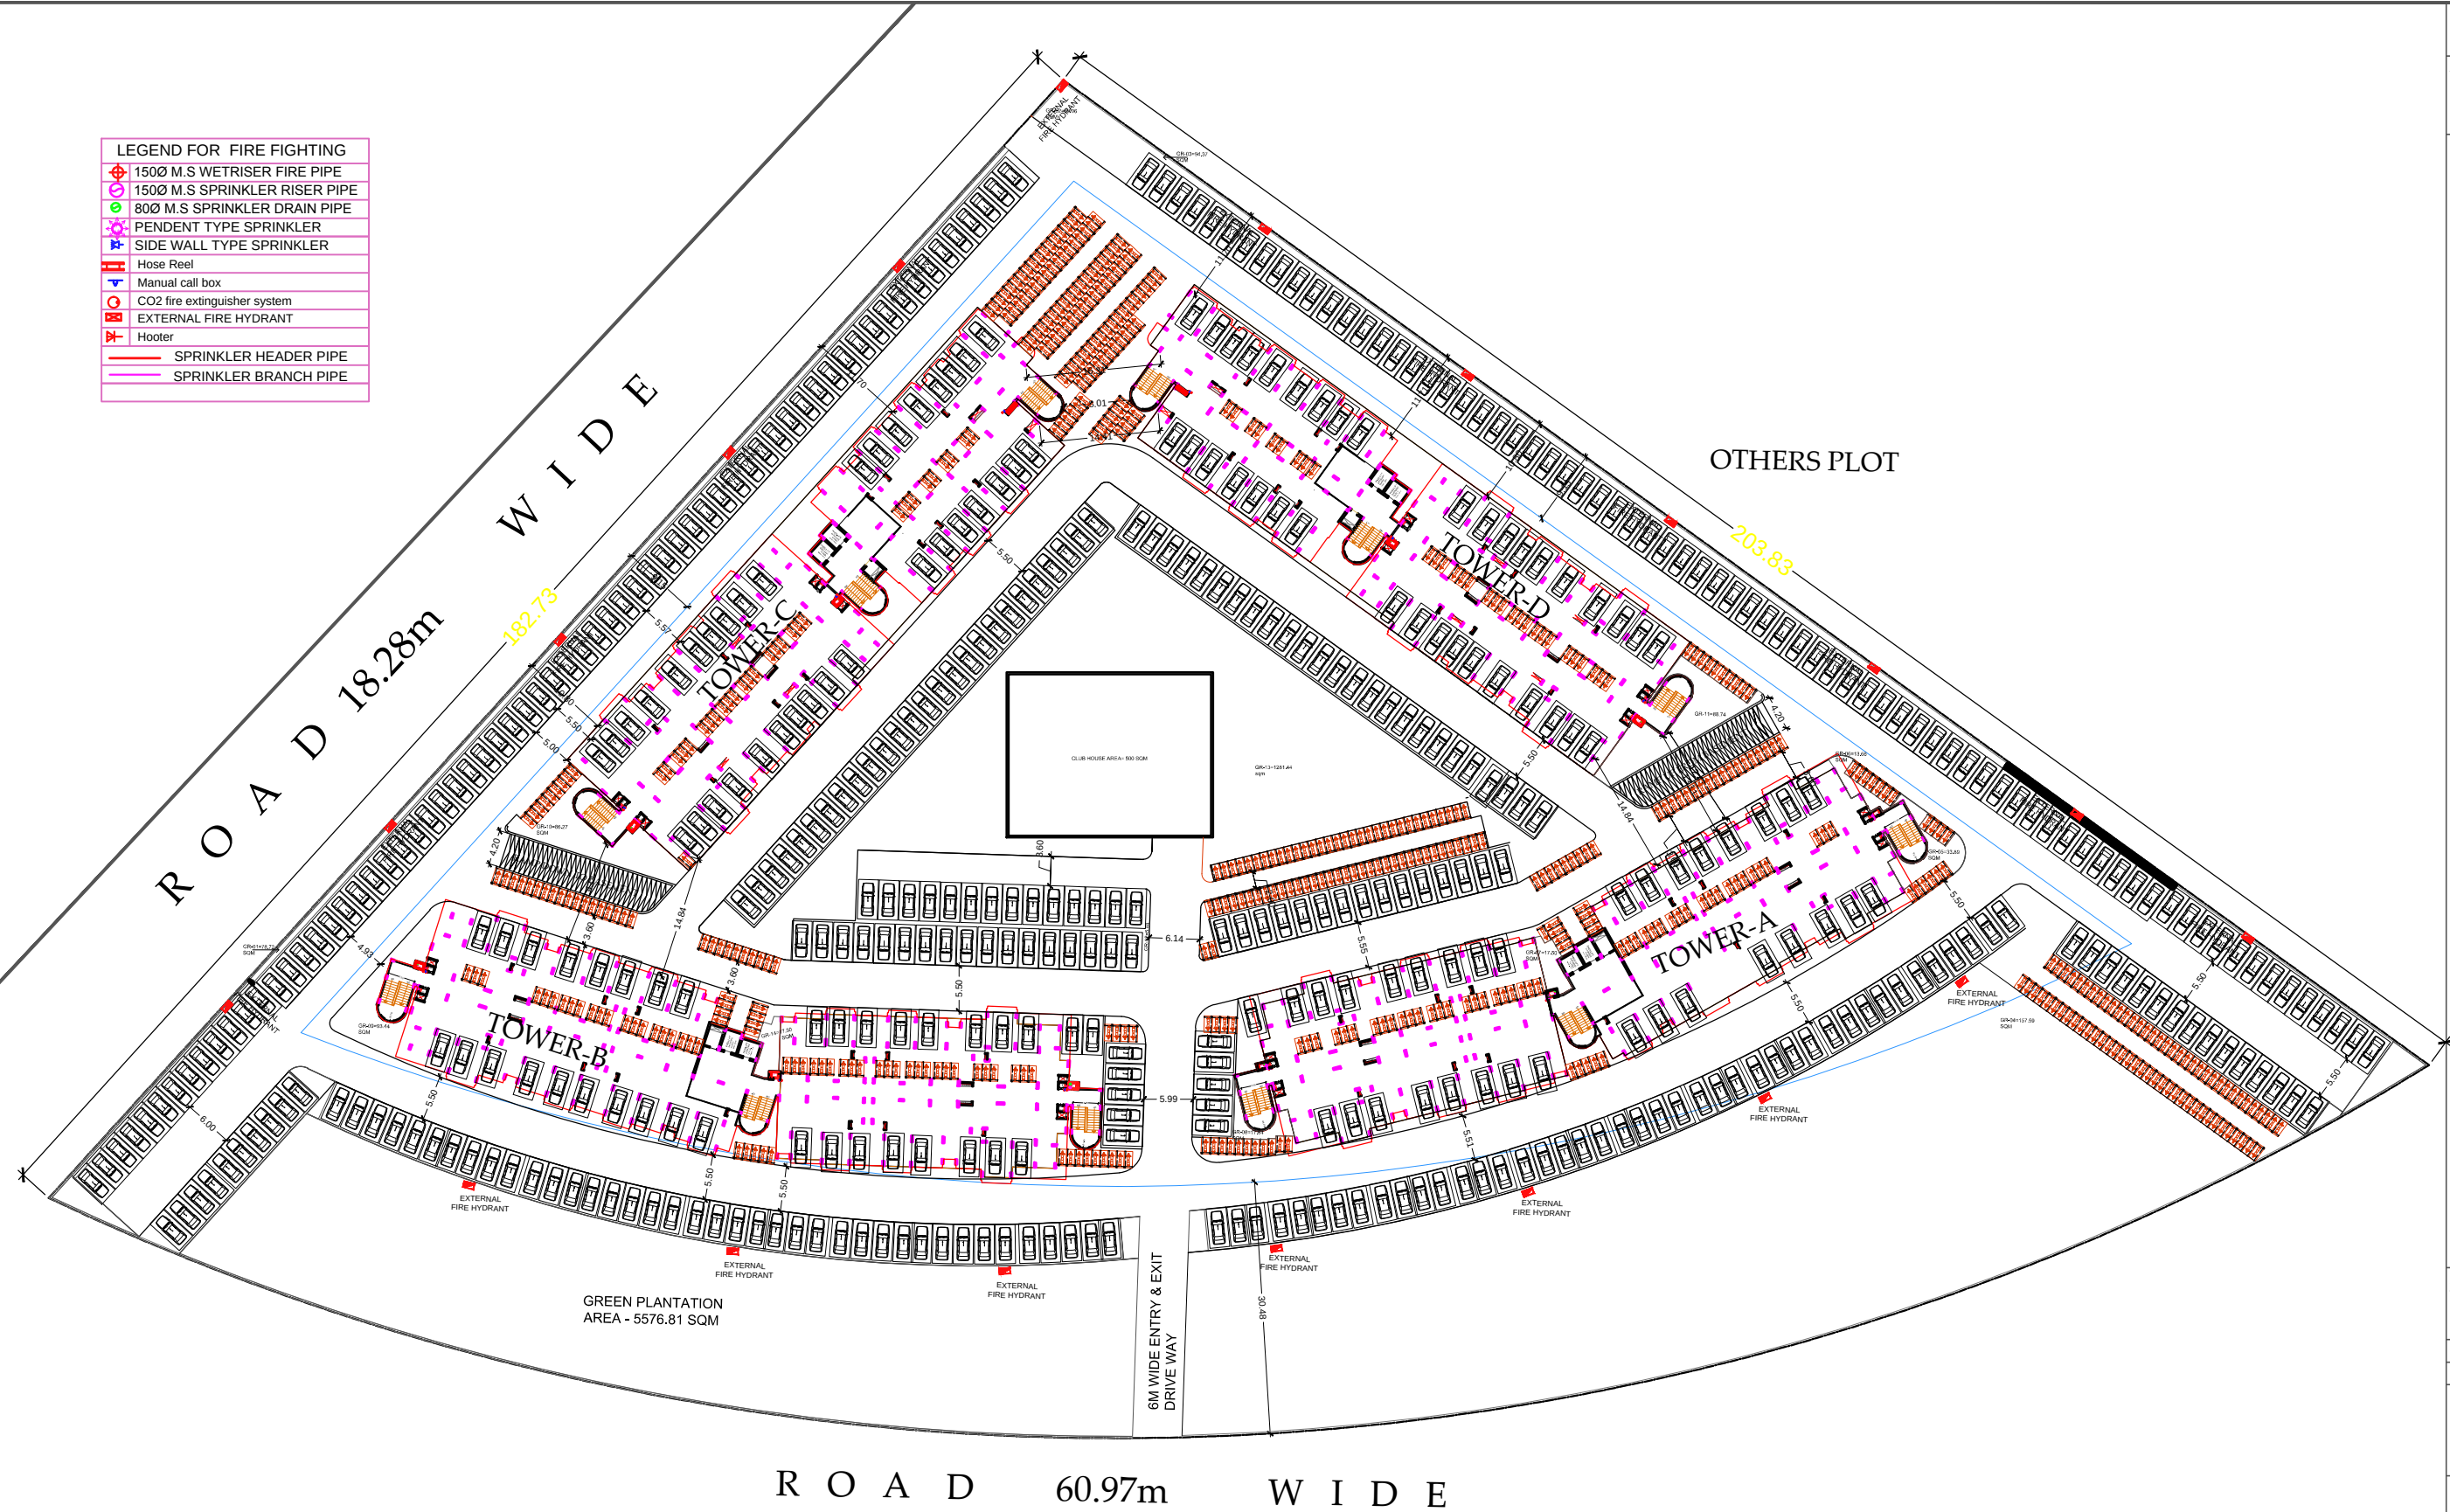

SHEET NO. - 2	
TITLE :- STILT FLOOR PLAN	
TITLE:- SUBMISSION DRAWINGS STILT FLOOR PLAN	
SCALE:- 1= 250	NORTH
DATE : 25/03/2014	
PROJECT:- PROPOSED GROUP HOUSING OF - L.J.K. RE- CONSTITUTE GROUP HOUSING KHASRA NO. 87/208/90-92-129 AT TONK ROAD , VILLAGE - HEMA KE NANGAL TEH- SANAGANER , JAIPUR	
ARCHITECTS:- MAITHEL & ASSOCIATES ARCHITECTS PVT. LTD. ARCHITECTS ENGINEERS INTERIOR DESIGNERS GREENWOODS, PLOT No. 1, LAL KOTHA SCHEME OPP. SANAGANER MARG, JAIPUR- 35 TEL. (0141) 2741664, 2743629 TELEFAX (0141) 2743619	
OWNER	ARCHITECTS

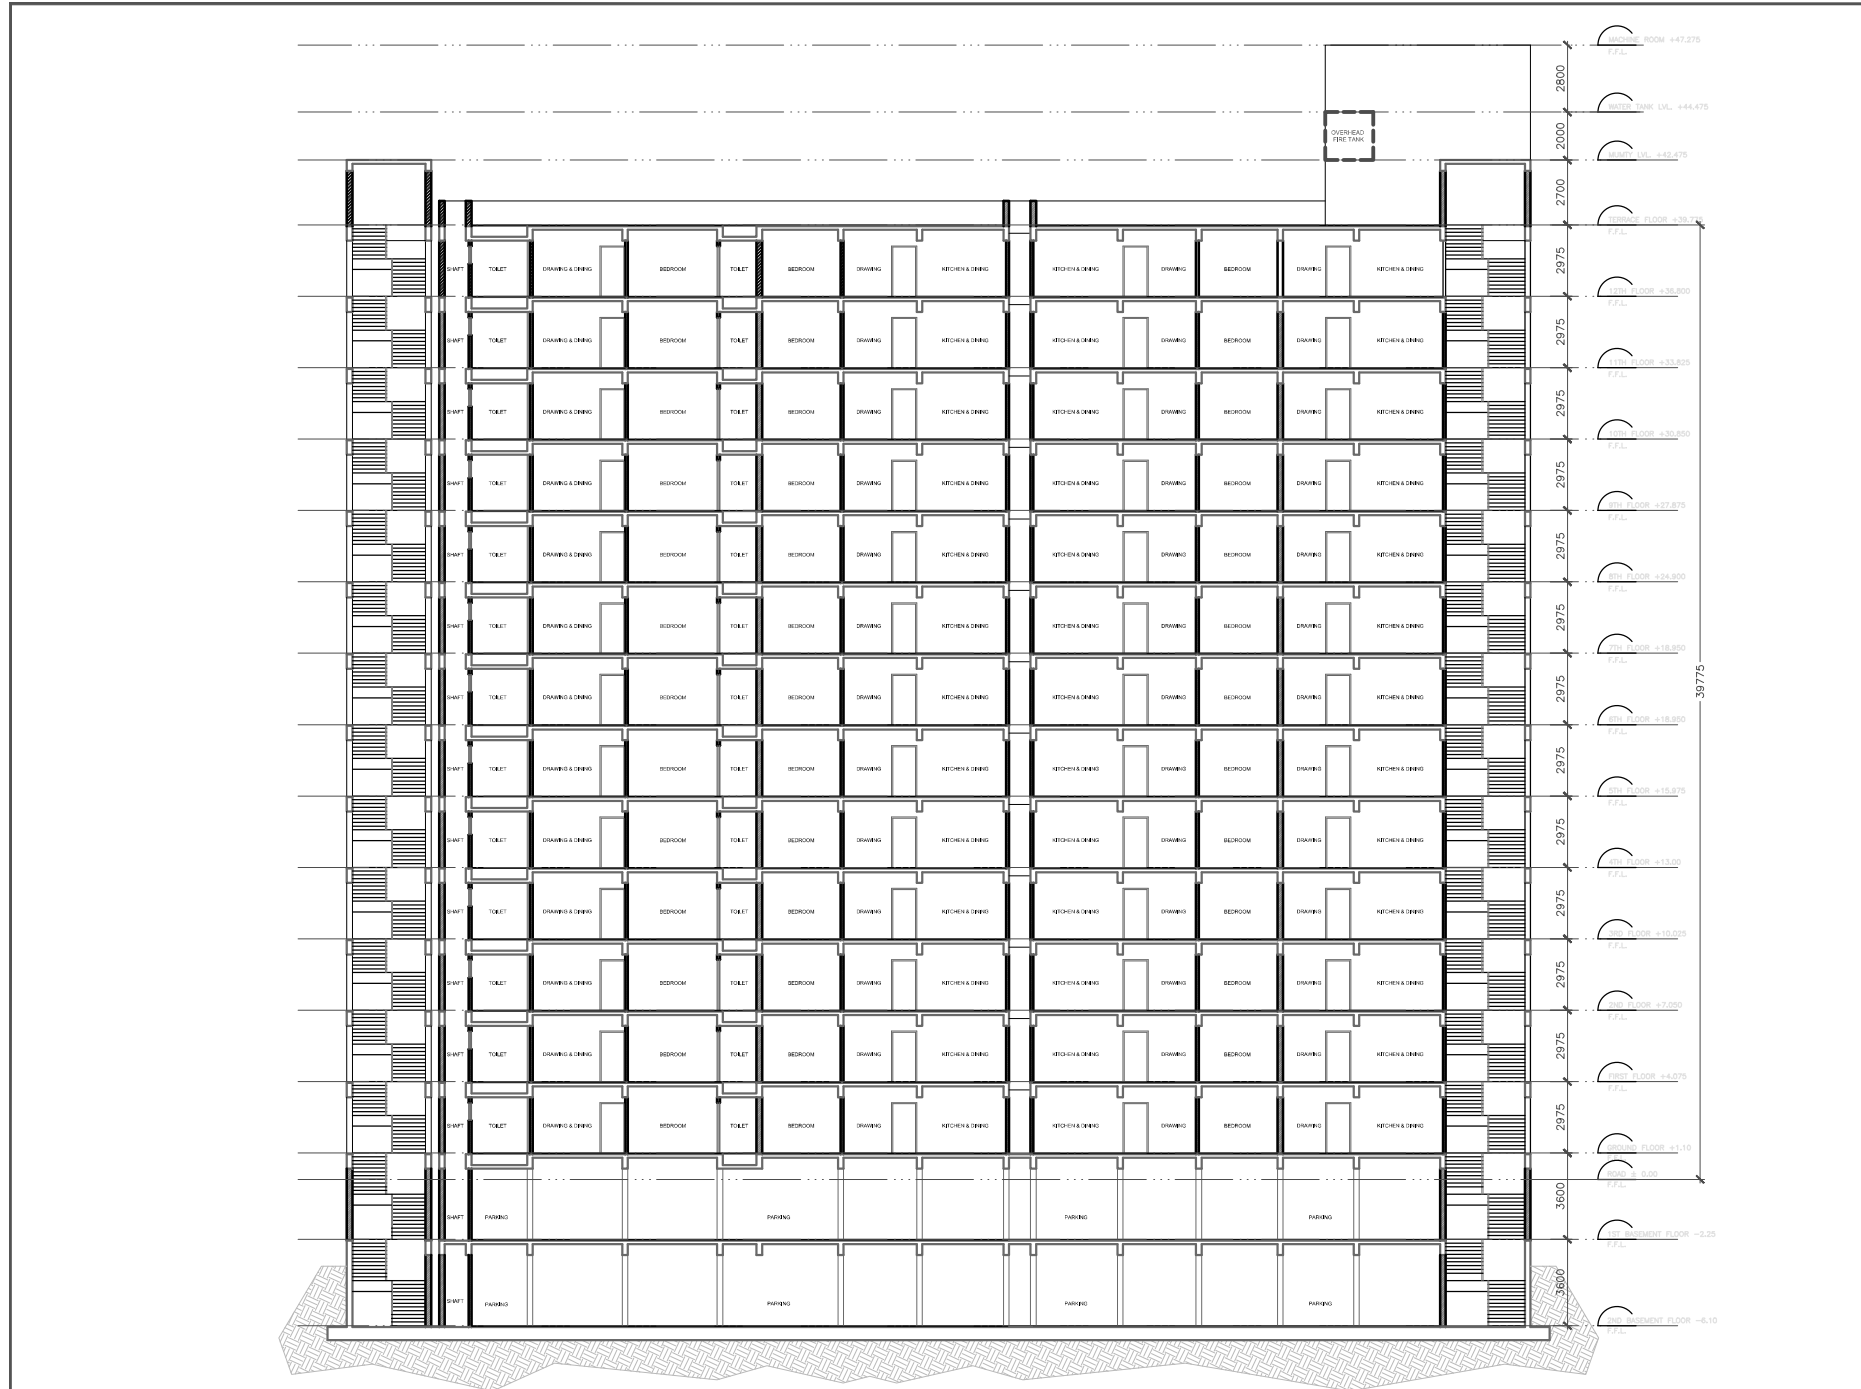

SECTION AT A-A

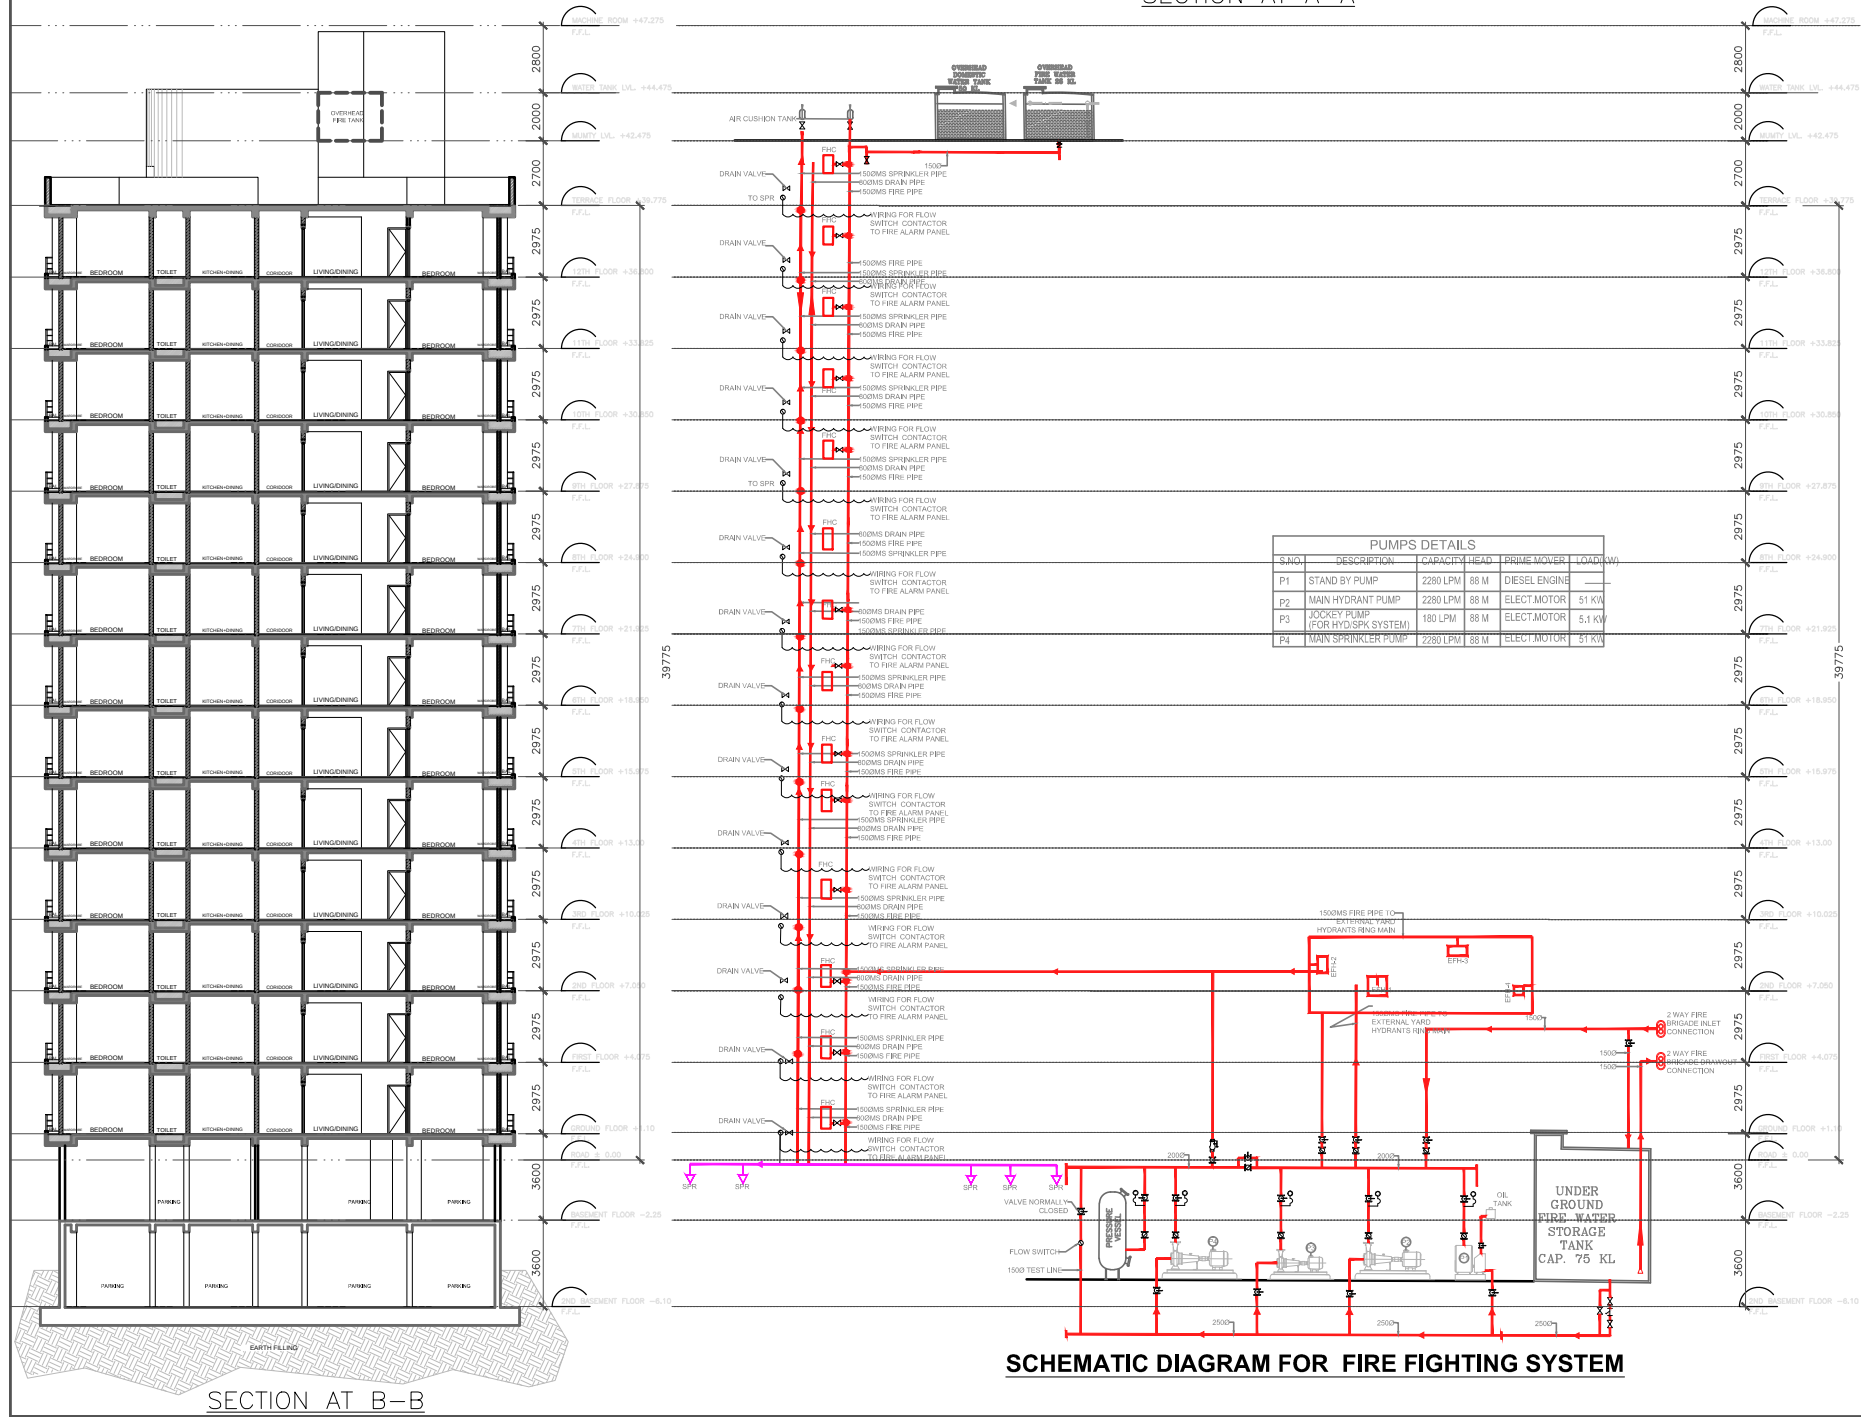

SCHEMATIC DIAGRAM FOR FIRE FIGHTING SYSTEM

SHEET NO. - 06

TITLE :-

SECTIONS
TOWER -B

TITLE :-

SUBMISSION DRAWINGS
SECTIONS
TOWER -B

SCALE:- 1= 100

DATE : 25/03/2014

PROJECT:-

ARCHITECTS:-

OWNER

ARCHITECTS

NORTH :
N

PROPOSED GROUP HOUSING
OF - I.J.K. RE-CONSTITUTE GROUP HOUSING
KHASRA NO. 87/298/90.92.129
AT TONK ROAD - VILLAGE - HEMA KE NANGAL
TEH- SANAGANER , JAIPUR

MAITHEL & ASSOCIATES ARCHITECTS PVT. LTD.
ARCHITECTS ENGINEERS INTERIOR DESIGNERS
GREENWOODS, PLOT NO. 11A/1, KOTH SCHEME
OFF SAHAKAR MARG, JAIPUR-15
TEL. (0141) 2741664, 2743619 TELEFAX (0141) 2743619