


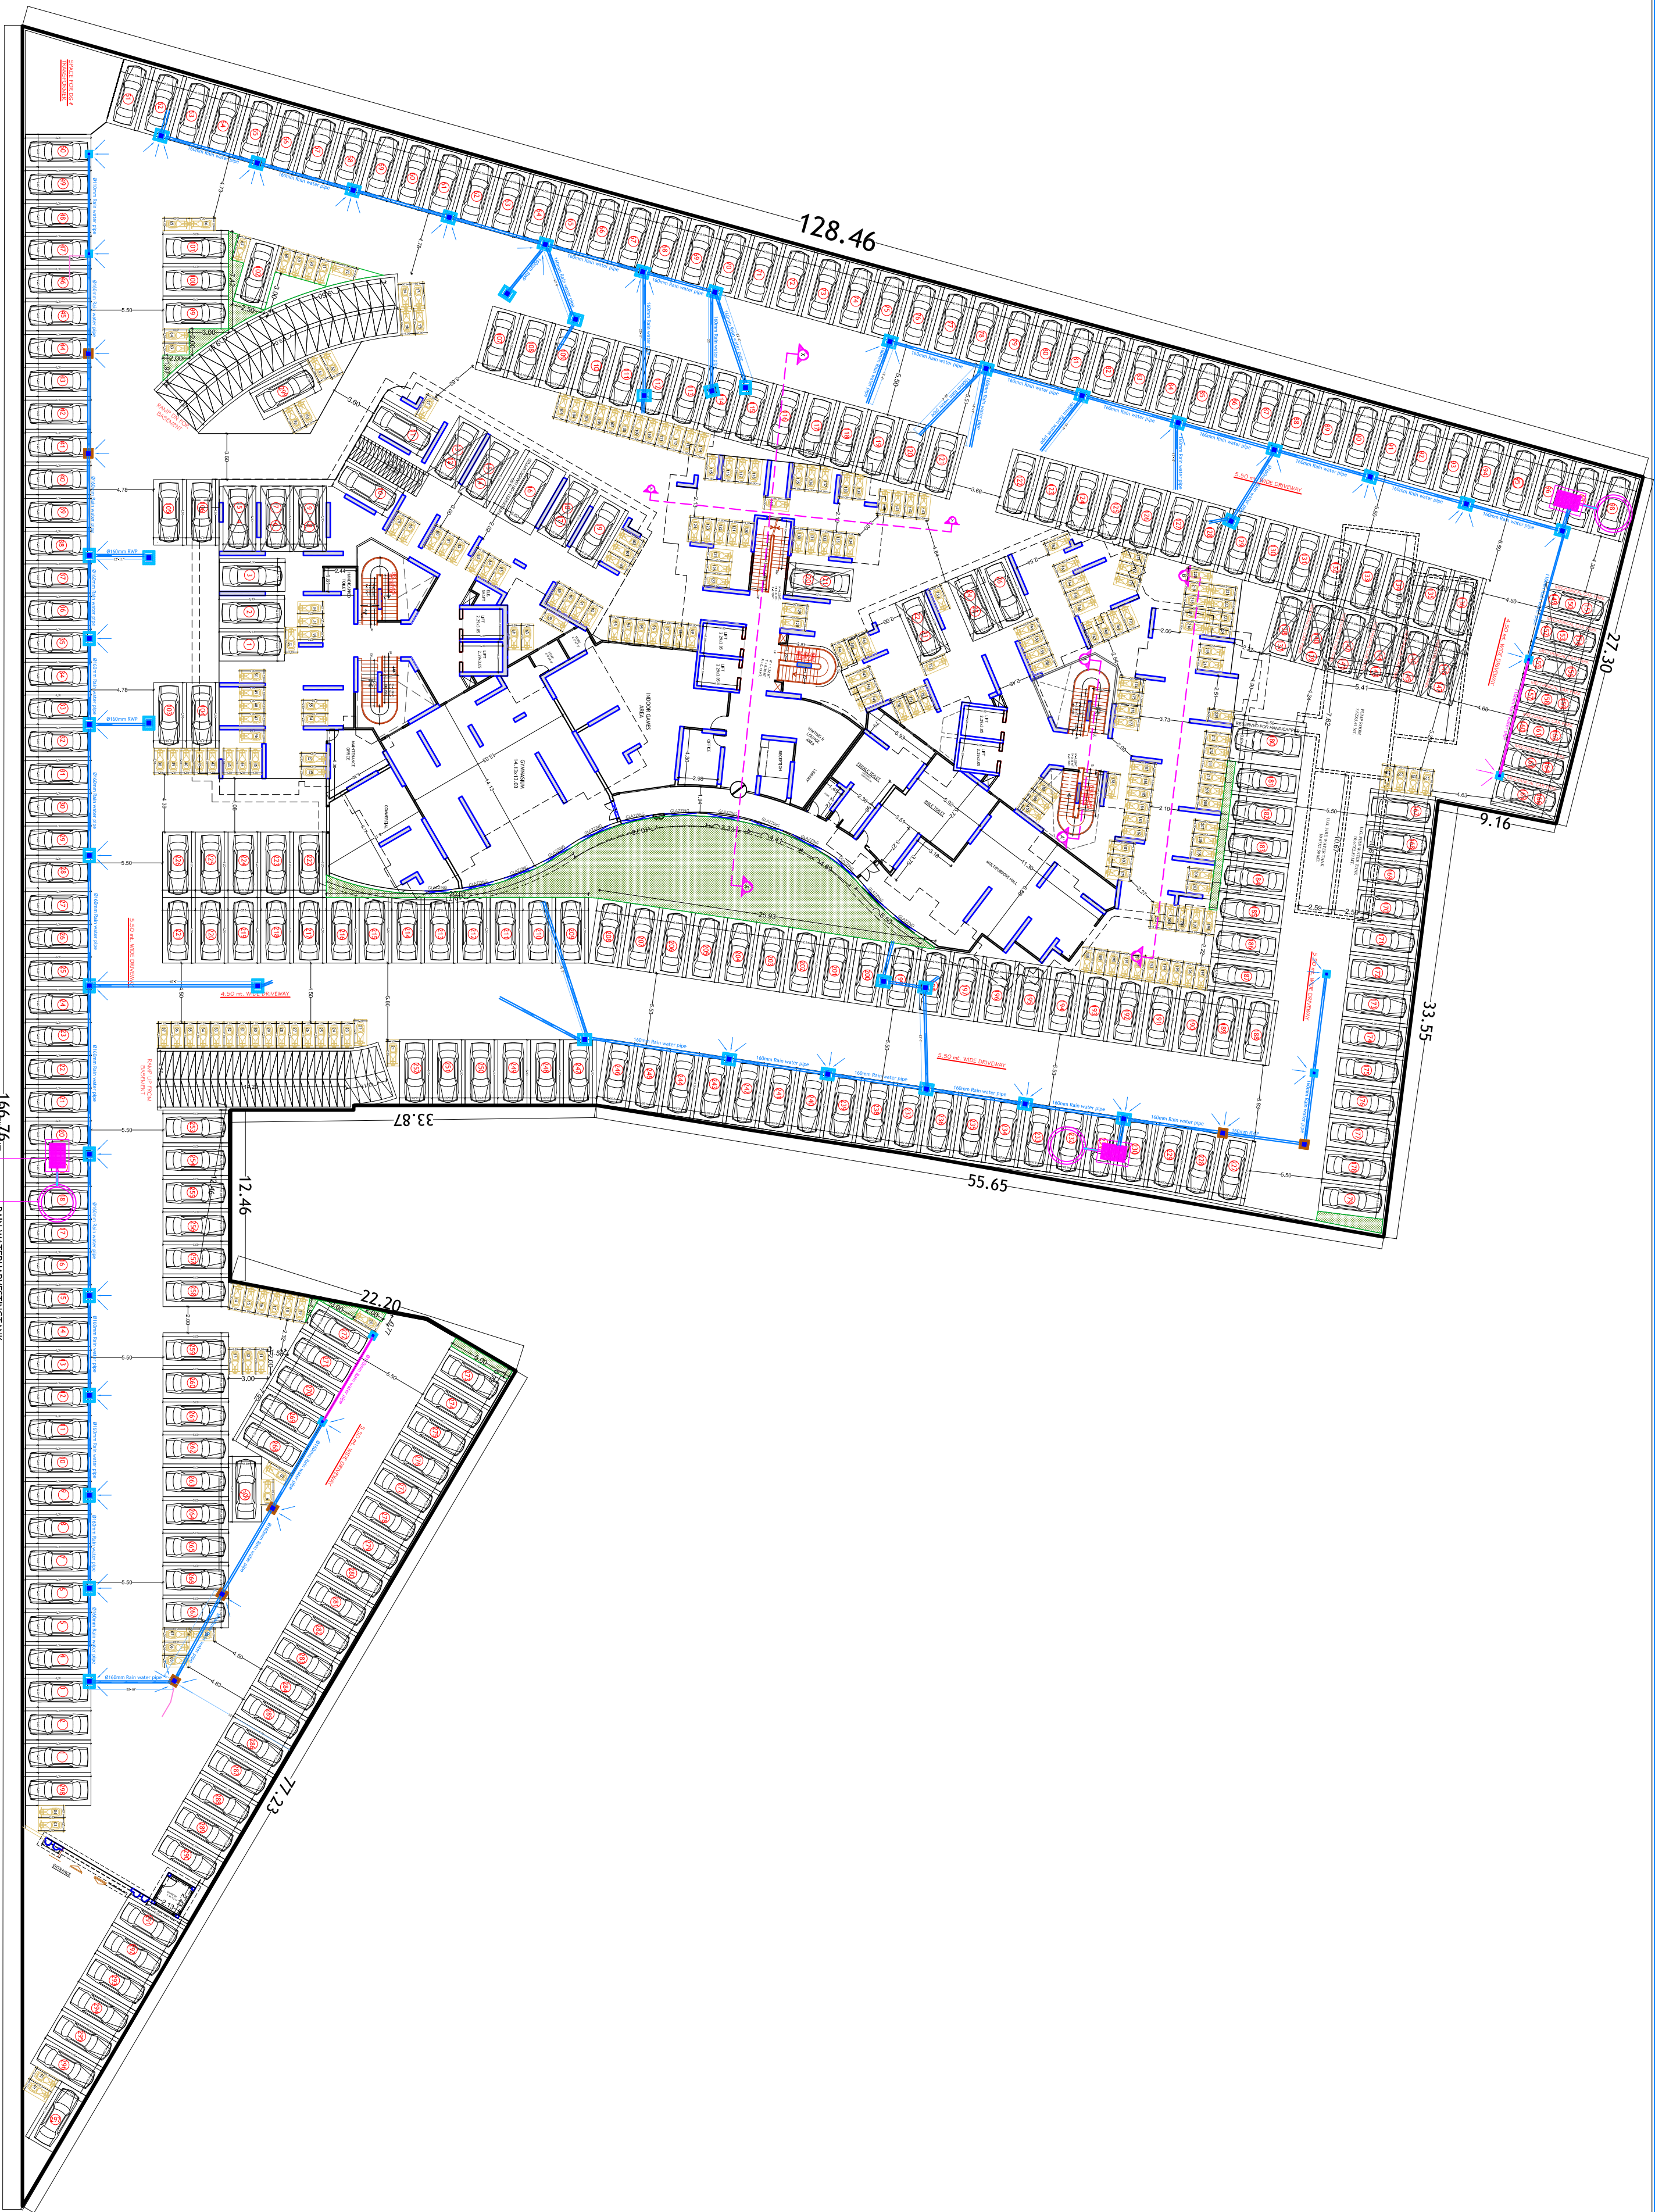

DRAWING TITLE
STORM WATER DRAINAGE PLAN

PROJECT TITLE:-
PROPOSED GROUP HOUSING IN KHASRA NO. 589/3,
594/1, 595 IN REVENUE VILLAGE - KESOPURA, TEHSIL
- SANGANER , AJMER ROAD , JAIPUR

PROJECT CONSULTANTS


ARCHITECTS & ENGINEERS
15A, HANUMANI MANDIR, TILAK NAGAR, JAIPUR
PHONE: 0141-2700227 / 2705580

SCALE 1:150

NORTH POINT 

OWNER

ARCHITECT

200'-0" WIDE ROAD

200'-0" WIDE ROAD

200'-0" WIDE ROAD

STILT FLOOR PLAN