


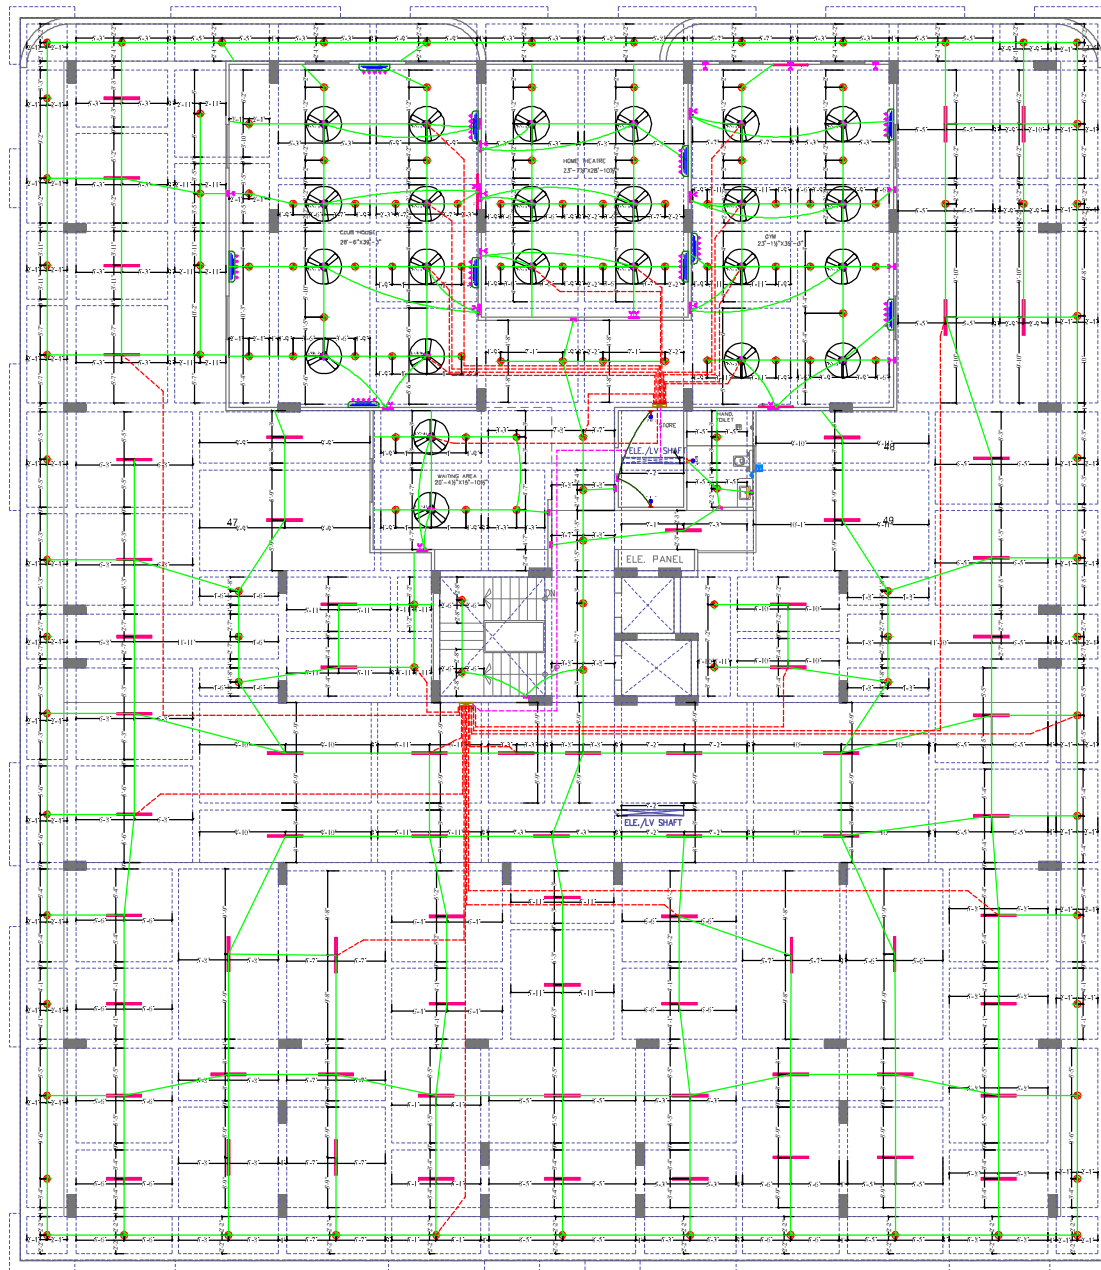

STILT FLOOR PLAN

PROJECT:-

PROPOSED RESIDENTIAL BUILDING AT KHASRA NO. 300/2
AT REVENUE VILLAGE - RAMSINGHPURA URF DHOLAI
TEHSIL - SANGANER, DIST. JAIPUR RAJASTHAN

SCALE:-

1:150

NORTH:-



ARCHITECT:-

space
edge Architects
B-6, GANESH KRIPA, MOTI MARG,
BAPU NAGAR JAIPUR - 302015,
TEL. 9314510603, 0141-4062903

Ms RGB HEIGHTS

Style
PARTNER

Vipul
VIPUL AGARWAL
M.E.P. CONSULTANT
B.E. ELECTRICAL

LEGENDS:

Mounting Height	No.	I D	Symbol	Description
IN RCC SLAB	CONDUIT			Rigid PVC 25mm dia. Conduit / 7/5 sqmm Wire For Light Points
IN FLOOR	CONDUIT			Rigid PVC 25mm dia. Conduit / 7/5 sqmm Wire For Light Points
IN RCC SLAB	CONDUIT			Rigid PVC 25mm dia. Conduit / 7/5 sqmm Wire For Light Circuits
IN FLOOR	CONDUIT			Rigid PVC 25mm dia. Conduit / 7/5 sqmm Wire For Light Circuits
IN RCC SLAB	CONDUIT			Rigid PVC 25mm dia. Conduit / 1.60 sqmm Wire For Power Circuits
IN FLOOR	CONDUIT			Rigid PVC 25mm dia. Conduit / 1.60 sqmm Wire For Power Circuits
IN RCC SLAB	CONDUIT			Submain Wire as Dfd From Main Panel on Ground Floor in 1 nos. 12mm dia Conduits
CEILING	24	PAN48"		CEILING PAN 48"
CEILING	133	DL		Led 6" Down Lighter 20W (Surface Mounted) Make:- Syska Led Cat.no:- SSK-15W GLD 6.5K/4K
CEILING	70	TLUC		LED CEILING TUBE LIGHT MAKE SYSKA LED CAT NO. SSK-15-20W
-50"	01	TLW		Led Wall Tube Light Make:- Syska Led Cat.no:- SSK-15-20W
-50"	01	BULB		Led Bulb 20W Make:- Syska Led Cat.no:- SSK-20W 5.7K/1K
-78"	01	ML		12x2 Led Mirror Light Make:- Syska Led Cat.no:- PPL-12x2
VENTILATOR HT.	01	CR		CEILING ROSE
VENTILATOR HT.	01	EXP		9" DIA FRESH AIR PAN
-50"	10	SAC		SPLIT AC INDOOR UNIT
-42"	19	SB		SWITCH BOARD
-18"	21	PP		M.A POWER POINT
-60"	02	MCB DU		MCB DISTRIBUTION BOARD

SERVICES CONSULTANT:

ASHI ASSOCIATES

F9/440, Keshav Marg Chitrakut Scheme, Jaipur
PH: 91-0-93146-10438, 0141-2440946 Mail: vipul8599@yahoo.com

DRAWN. BY:-

CHKD. BY:-

MAHENDRA

SANJAY

APPD. BY:-

VIPUL AGARWAL

DATE:-


REV.:-

25-07-2024

00

DRAWING TYPE :-

STILT FLOOR
ELECTRIC CONDUIT PLAN

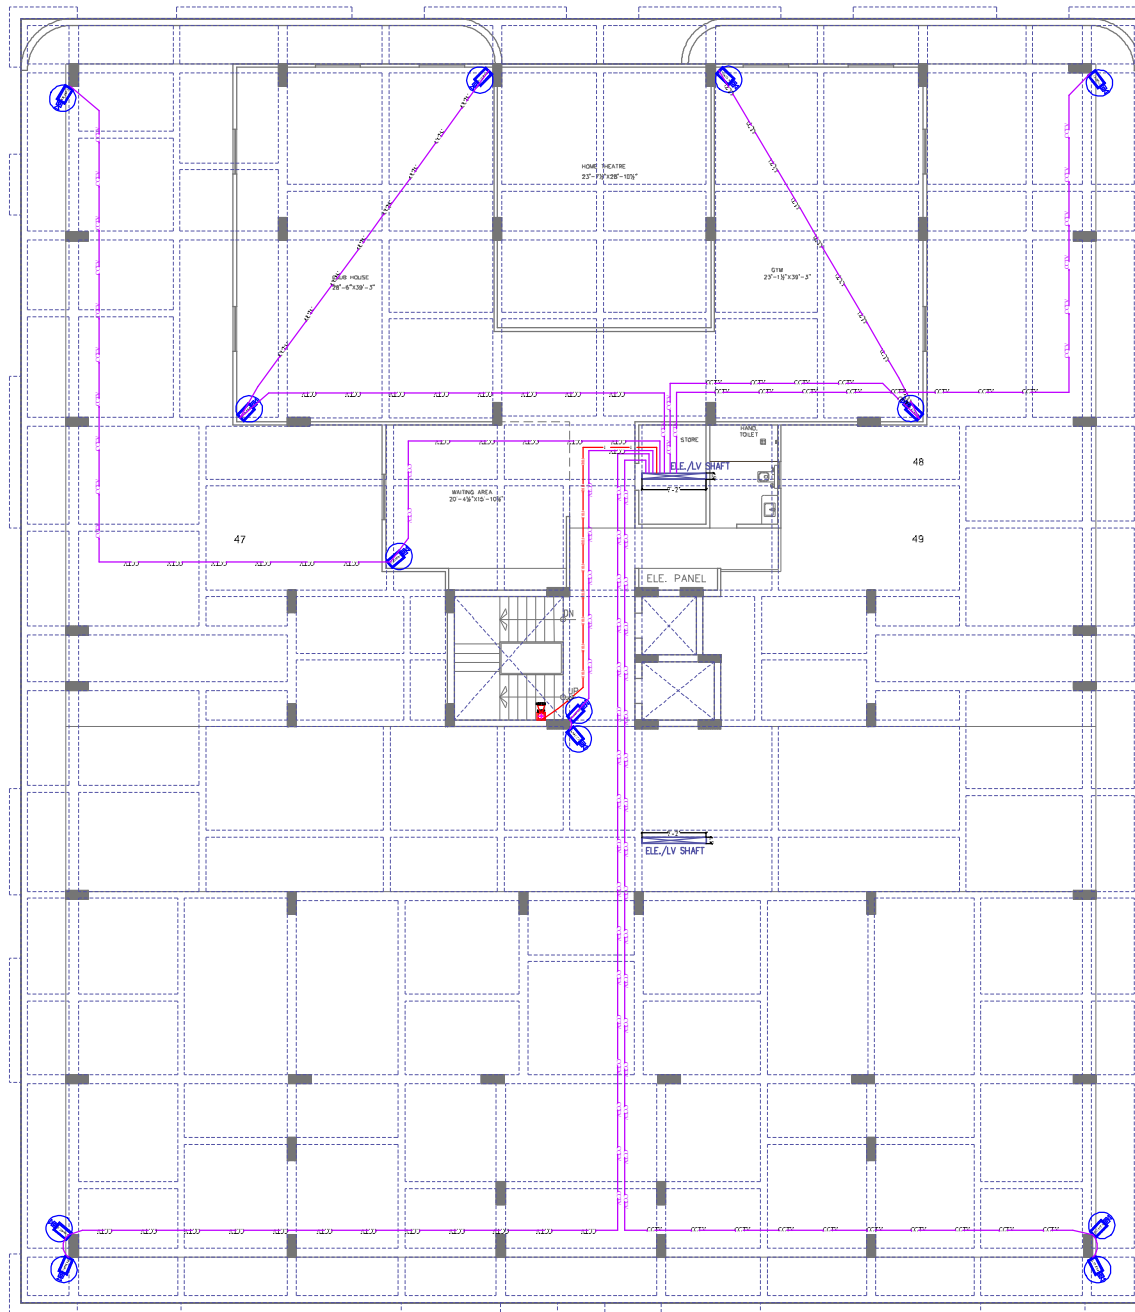

STILT FLOOR PLAN

PROJECT:-

PROPOSED RESIDENTIAL BUILDING AT KHASRA NO. 300/2
AT REVENUE VILLAGE - RAMSINGHPURA URF DHOLAI
TEHSIL - SANGANER, DIST. JAIPUR RAJASTHAN

SCALE:-

1:150

NORTH:-



ARCHITECT:-



B-6, GANESH KRIPA, MOTI MARG,
BAPU NAGAR JAIPUR - 302015.
TEL. 9314510603, 0141-4062903

M/s RGB HEIGHTS
Style
PARTNER

Vipul
VIPUL AGARWAL
M.E.P. CONSULTANT
B.E. ELECTRICAL

LEGENDS:

Mouting Height	No.	I D	Symbol	Description
IN RCC SLAB		CONDUIT		Rigid PVC Conduit 25mm/3/4" Coaxial Wire/Cat-6 Cable for Video Door Phone & Security Camera-(C.C.T.V.)
IN RCC SLAB		CONDUIT		Rigid PVC 25mm dia. Conduit / 2X1.5 sq. mm Copper Wire For Fire Alarm
+45"	01	MCP		MANUAL CALL POINT
+90"	01	I/O		HOOVER POINT
+90"	13	CCTV		WALL MOUNTED CCTV CAMERA

SERVICES CONSULTANT:
ASHI ASSOCIATES

F9/440,Keshav Marg Chitrakut Scheme,Jaipur
PH:91-0-93146-10438,0141-2440946 Mail:vipul8599@yahoo.com

DRAWN. BY:-

CHKD. BY:-

MAHENDRA

SANJAY

APPD. BY:-

VIPUL AGARWAL

DATE:-


REV.:-

25-07-2024

00

DRAWING TYPE :-

STILT FLOOR
LV CONDUIT PLAN

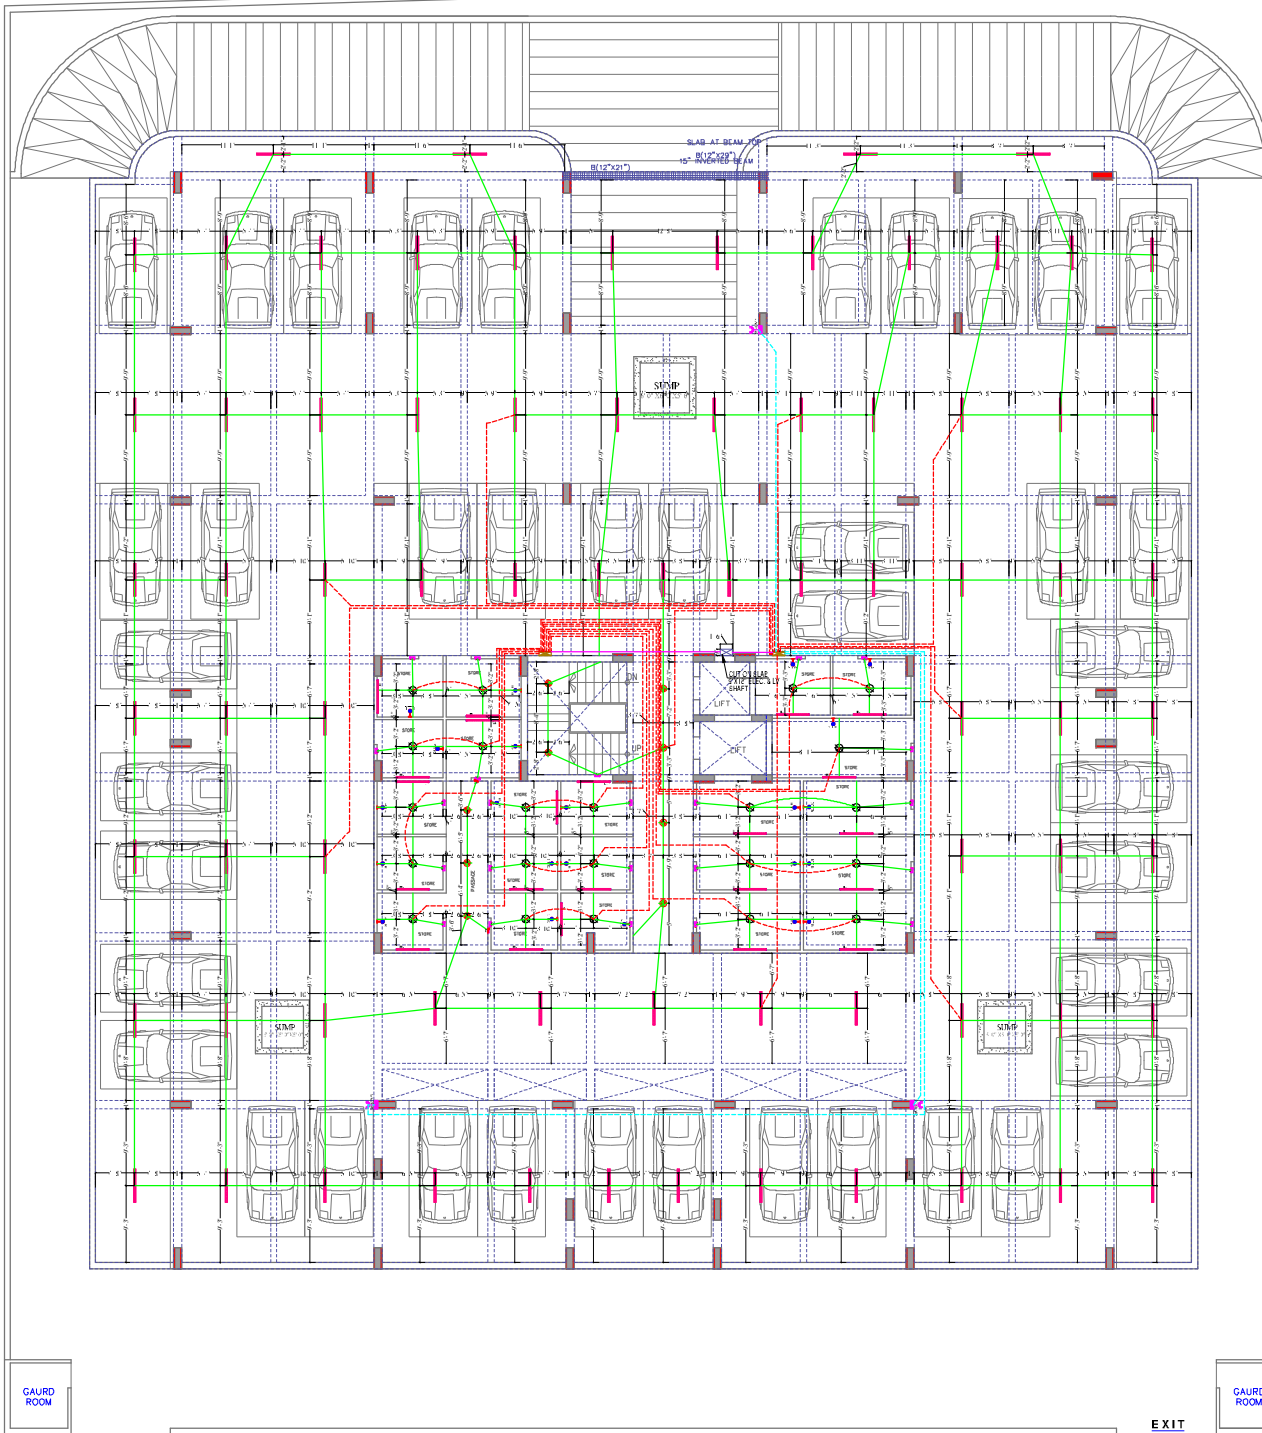

M/S RGB HEIGHTS
PARTNER

VIPUL AGARWAL
M.E.P. CONSULTANT
B.E. ELECTRICAL

LEGENDS:

Meaning	No.	ID	Symbol	Description
IN RCC SLAB		CONDUIT		Rigid PVC 25mm dia. Conduit 1/2.5 sqmm Wire For Light Points
IN RCC SLAB		CONDUIT		Rigid PVC 25mm dia. Conduit 2.5 sqmm Wire For Light Points
IN RCC SLAB		CONDUIT		Rigid PVC 25mm dia. Conduit 4.00 sqmm Wire For Power Cables
IN RCC SLAB		CONDUIT		Salvini Wire in DD From Main Panel on Ground Floor in Line 25mm dia. Conduit
CEILING	22	FB		FAN BOX
100"	22	BULB		Led Bulb 30W Make: Syska Led Cat no: SSC 30W S 7K/SK
CEILING	76	TL		LED CEILING TUBE LIGHT MAKE: SYSKA LED CAT NO.: SSC TS 30W
190"	22	TLW		LED WALL TUBE LIGHT MAKE: SYSKA LED CAT NO.: SSC TS 30W Led P. Down Lighter 30W (Surface Mounted)
CEILING	09	DL		Led P. Down Lighter 30W (Surface Mounted) Make: Syska Led Cat no.: STL 15W GLD 8.5K/4K
142"	25	SB		SWITCH BOARD
118"	03	IP SUMP		16A POWER POINT FOR SUMP
160"	02	MCB DB		MCB DISTRIBUTION BOARD

SERVICES CONSULTANT:
ASHI ASSOCIATES
P-9/440, Keshav Marg Chitrakut Scheme, Jaipur
PH: 91-0-93-146-10438, 0141-2449946, Mail: vipul8599@yahoo.com

DRAWN. BY:-
KEDAR

CHKD. BY:-
SANJAY

APPD. BY:-
VIPUL AGARWAL

DATE:-
06-07-2024

REV:-
00

DRAWING TYPE :-
BASEMENT FLOOR ROOF
ELECTRIC CONDUIT PLAN

PROJECT:
PROPOSED RESIDENTIAL BUILDING AT
KHASRA NO. 300/2
AT REVENUE VILLAGE - RAMSINGHPURA
URF DHOLAI
TEHSIL - SANGANER, DIST. JAIPUR
RAJASTHAN

ARCHITECT:

space edge Architects
ARCHITECTS, INTERIOR DESIGNERS AND ENGINEERS

B-6, Moti Marg, Bapu Nagar, Jaipur.
Ph.: 9314510603
E-Mail: spaceedgejpr@gmail.com

WORKING DRAWING

SH. NO.
01


DATE : 06-06-2024

SCALE: NTS

NOTE



THIS DRAWING IS THE SOLE PROPERTY
OF SPACE EDGE ARCHITECTS AND IS
NOT TO BE COPIED, USED OR
REPRODUCED FOR ANY PURPOSE OTHER
THAN FOR WHICH IT HAS BEEN LOANED.

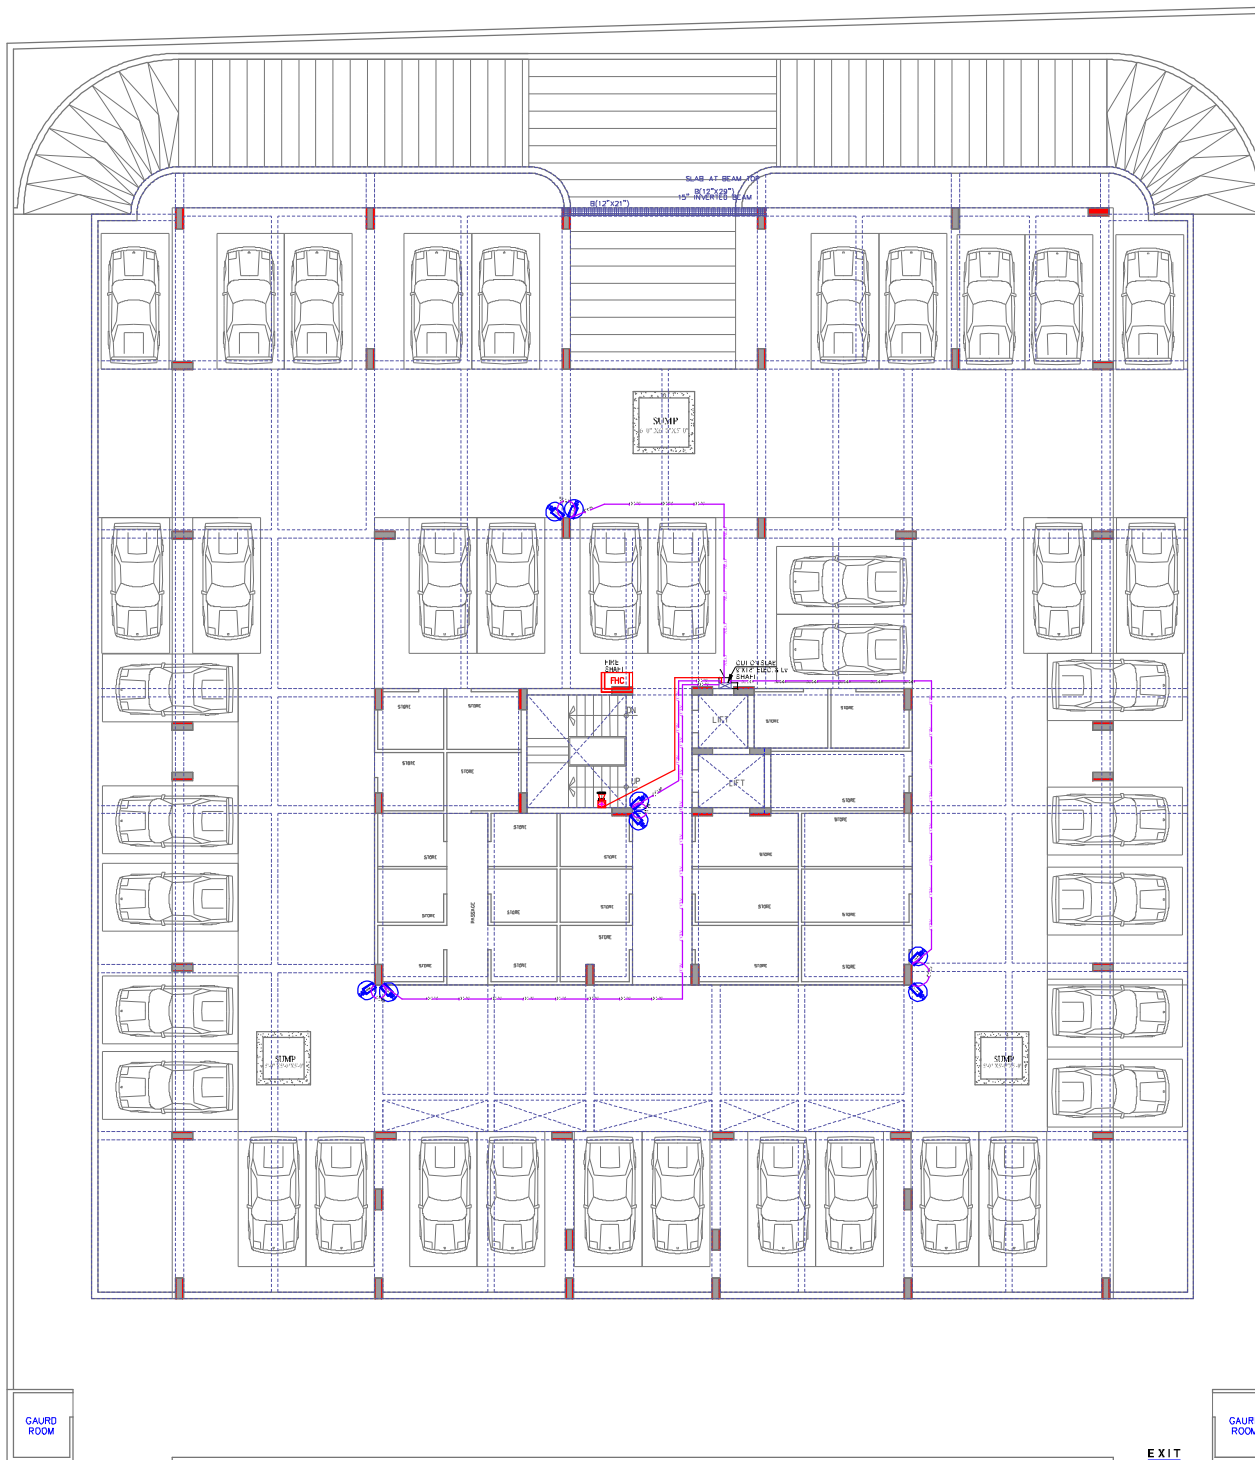

M/s RGB HEIGHTS
Dr. R. K. PARTNER

Vipul
VIPUL AGARWAL
 M.E.P. CONSULTANT
 B.E. ELECTRICAL

LEGENDS:

Quantity	No.	ID	Symbol	Description
IN ROOF SLAB	CONDUIT	10	10	Rigid PVC Conduit (25mm) - 10'0" x 10'0" x 10'0"
IN ROOF SLAB	CONDUIT	10	10	Rigid PVC Conduit (25mm) - 10'0" x 10'0" x 10'0"
14"	01	MCP	+	MANUAL CALL POINT
10"	01	WTP	W	WATER POINT
10"	01	CCTV	C	WALL MOUNTED CCTV CAMERA

SERVICES CONSULTANT:
ASHI ASSOCIATES
 F-9/440, Keshav Marg Chitrakut Scheme Jaipur
 PH: 91-0-93146-10438 / 0141-2440946 Mail: vipul8599@yahoo.com

DRAWN BY:-

CHKD. BY:-

KEDAR

SANJAY

APPD. BY:-

VIPUL AGARWAL

DATE:-

REV.:-

06-07-2024

00

DRAWING TYPE :-

BASEMENT FLOOR ROOF
 LV CONDUIT PLAN

PROJECT:

PROPOSED RESIDENTIAL BUILDING AT
 KHASRA NO. 300/2
 AT REVENUE VILLAGE - RAMSINGHPURA
 URF DHOLAI
 TEHSIL - SANGANER, DIST. JAIPUR
 RAJASTHAN

ARCHITECT:

space edge Architects
 ARCHITECTS, INTERIOR DESIGNERS AND ENGINEERS

B-6, Moti Marg, Bapu Nagar, Jaipur.
 Ph: 9314510603
 E-Mail: spaceedgepr@gmail.com

WORKING DRAWING

SH. NO. 01
 DATE : 06-06-2024
 SCALE: NTS



NOTE

THIS DRAWING IS THE SOLE PROPERTY
 OF SPACE EDGE ARCHITECTS AND IS
 NOT TO BE COPIED, USED OR
 REPRODUCED FOR ANY PURPOSE OTHER
 THAN FOR WHICH IT HAS BEEN LOANED.