


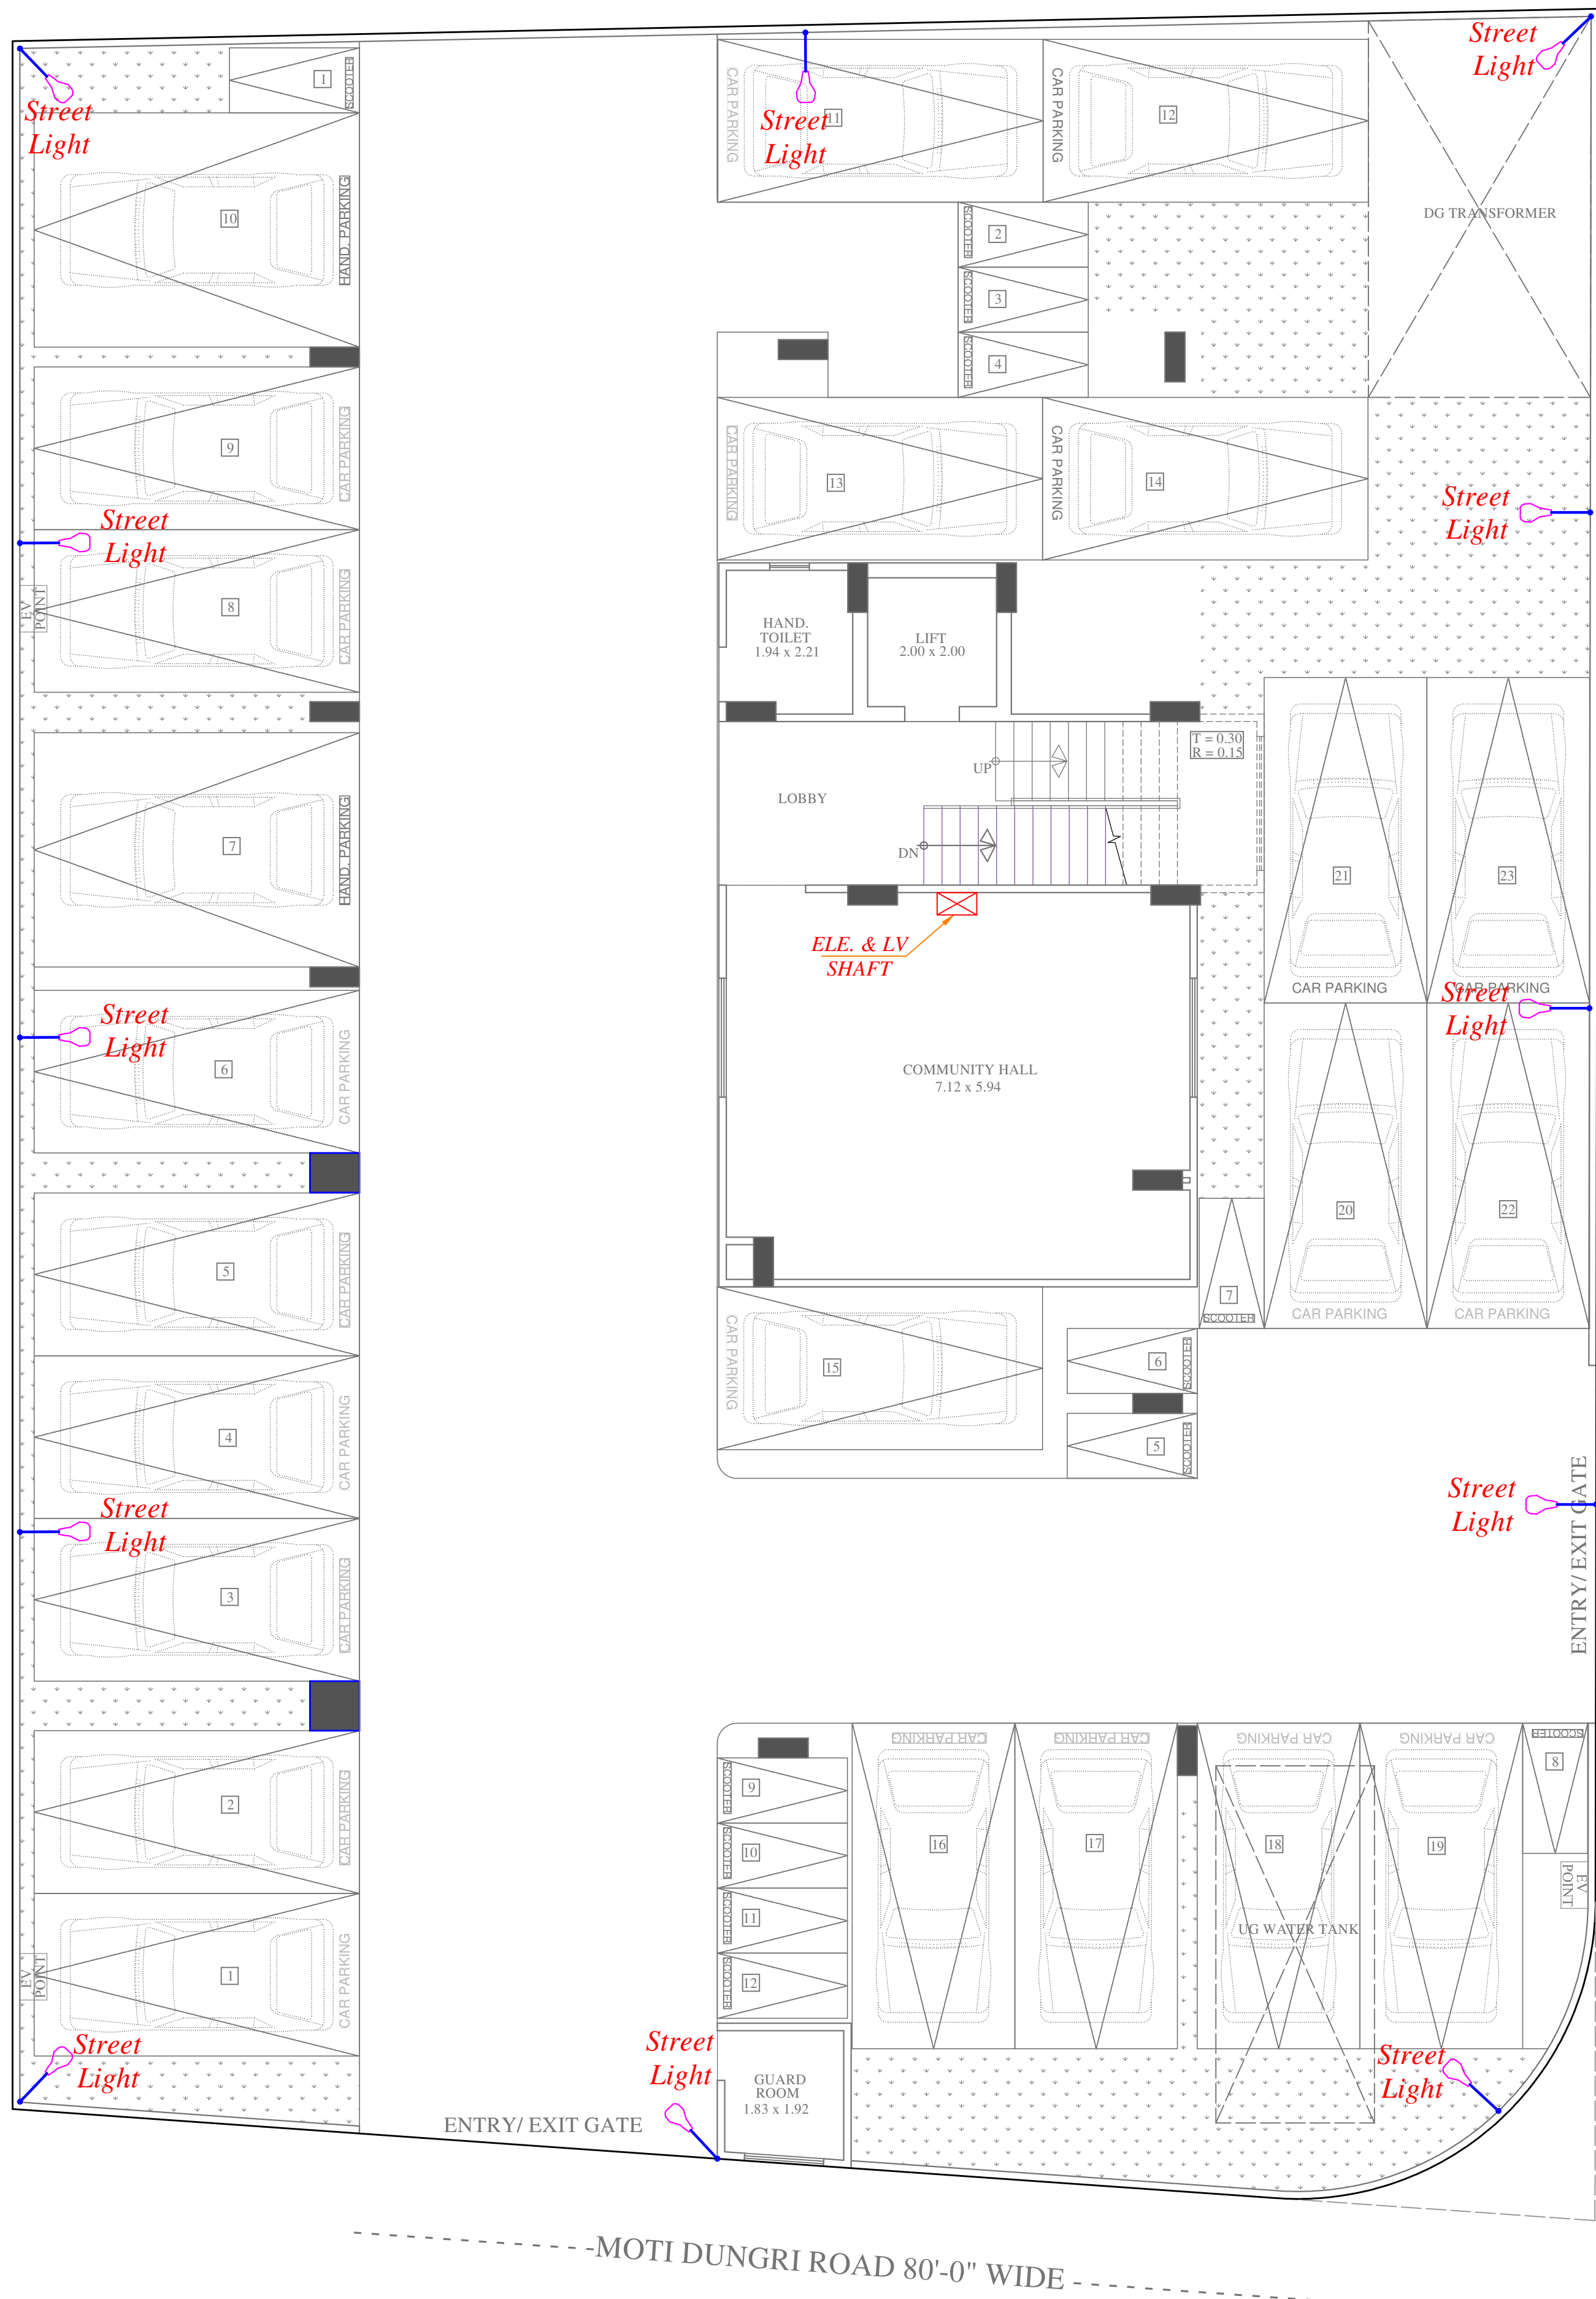

Vipul
VIPUL AGARWAL
M.E.P. CONSULTANT
B.E. ELECTRICAL

LEGENDS:

Qty.	ID	Symbol	Description
12	PL		STREET LIGHT

SERVICES CONSULTANT:
ASHI ASSOCIATES,
F 9 / 440 , Keshav Marg Chitrakut Scheme,Jaipur
PH:91-0-93146-10438 ,0141-2440946 Mail:vipul8599@yahoo.com

DRN BY- SURENDER YADAV	CKD BY- SANJAY
APPD BY- VIPUL AGARWAL	REV.- 00
DATE- 21-06-2023	SCALE-




PROJECT NAME:-
VIRASAT TRILOK
PROMOTER:-
SRS BUILDERS

PROJECT ADDRESS:-
PROPOSED RESIDENTIAL BUILDING AT
PLOT NO. 10, UNIYARA GARDEN, JAIPUR
(RAJASTHAN)

DRAWING:
STILT FLOOR
EXTERNAL STREET LIGHT
FOR RERA SUBMISSION PLAN

ARCHITECT :-
 SPACE GRID
C-49,vidya Apartment,paras Marg,
Bapu Nagar,near Janta Store
Circle, Jaipur-302015
Ph-09314918766,0141-4005506(o)
Email:-info.spacegrid@gmail.com



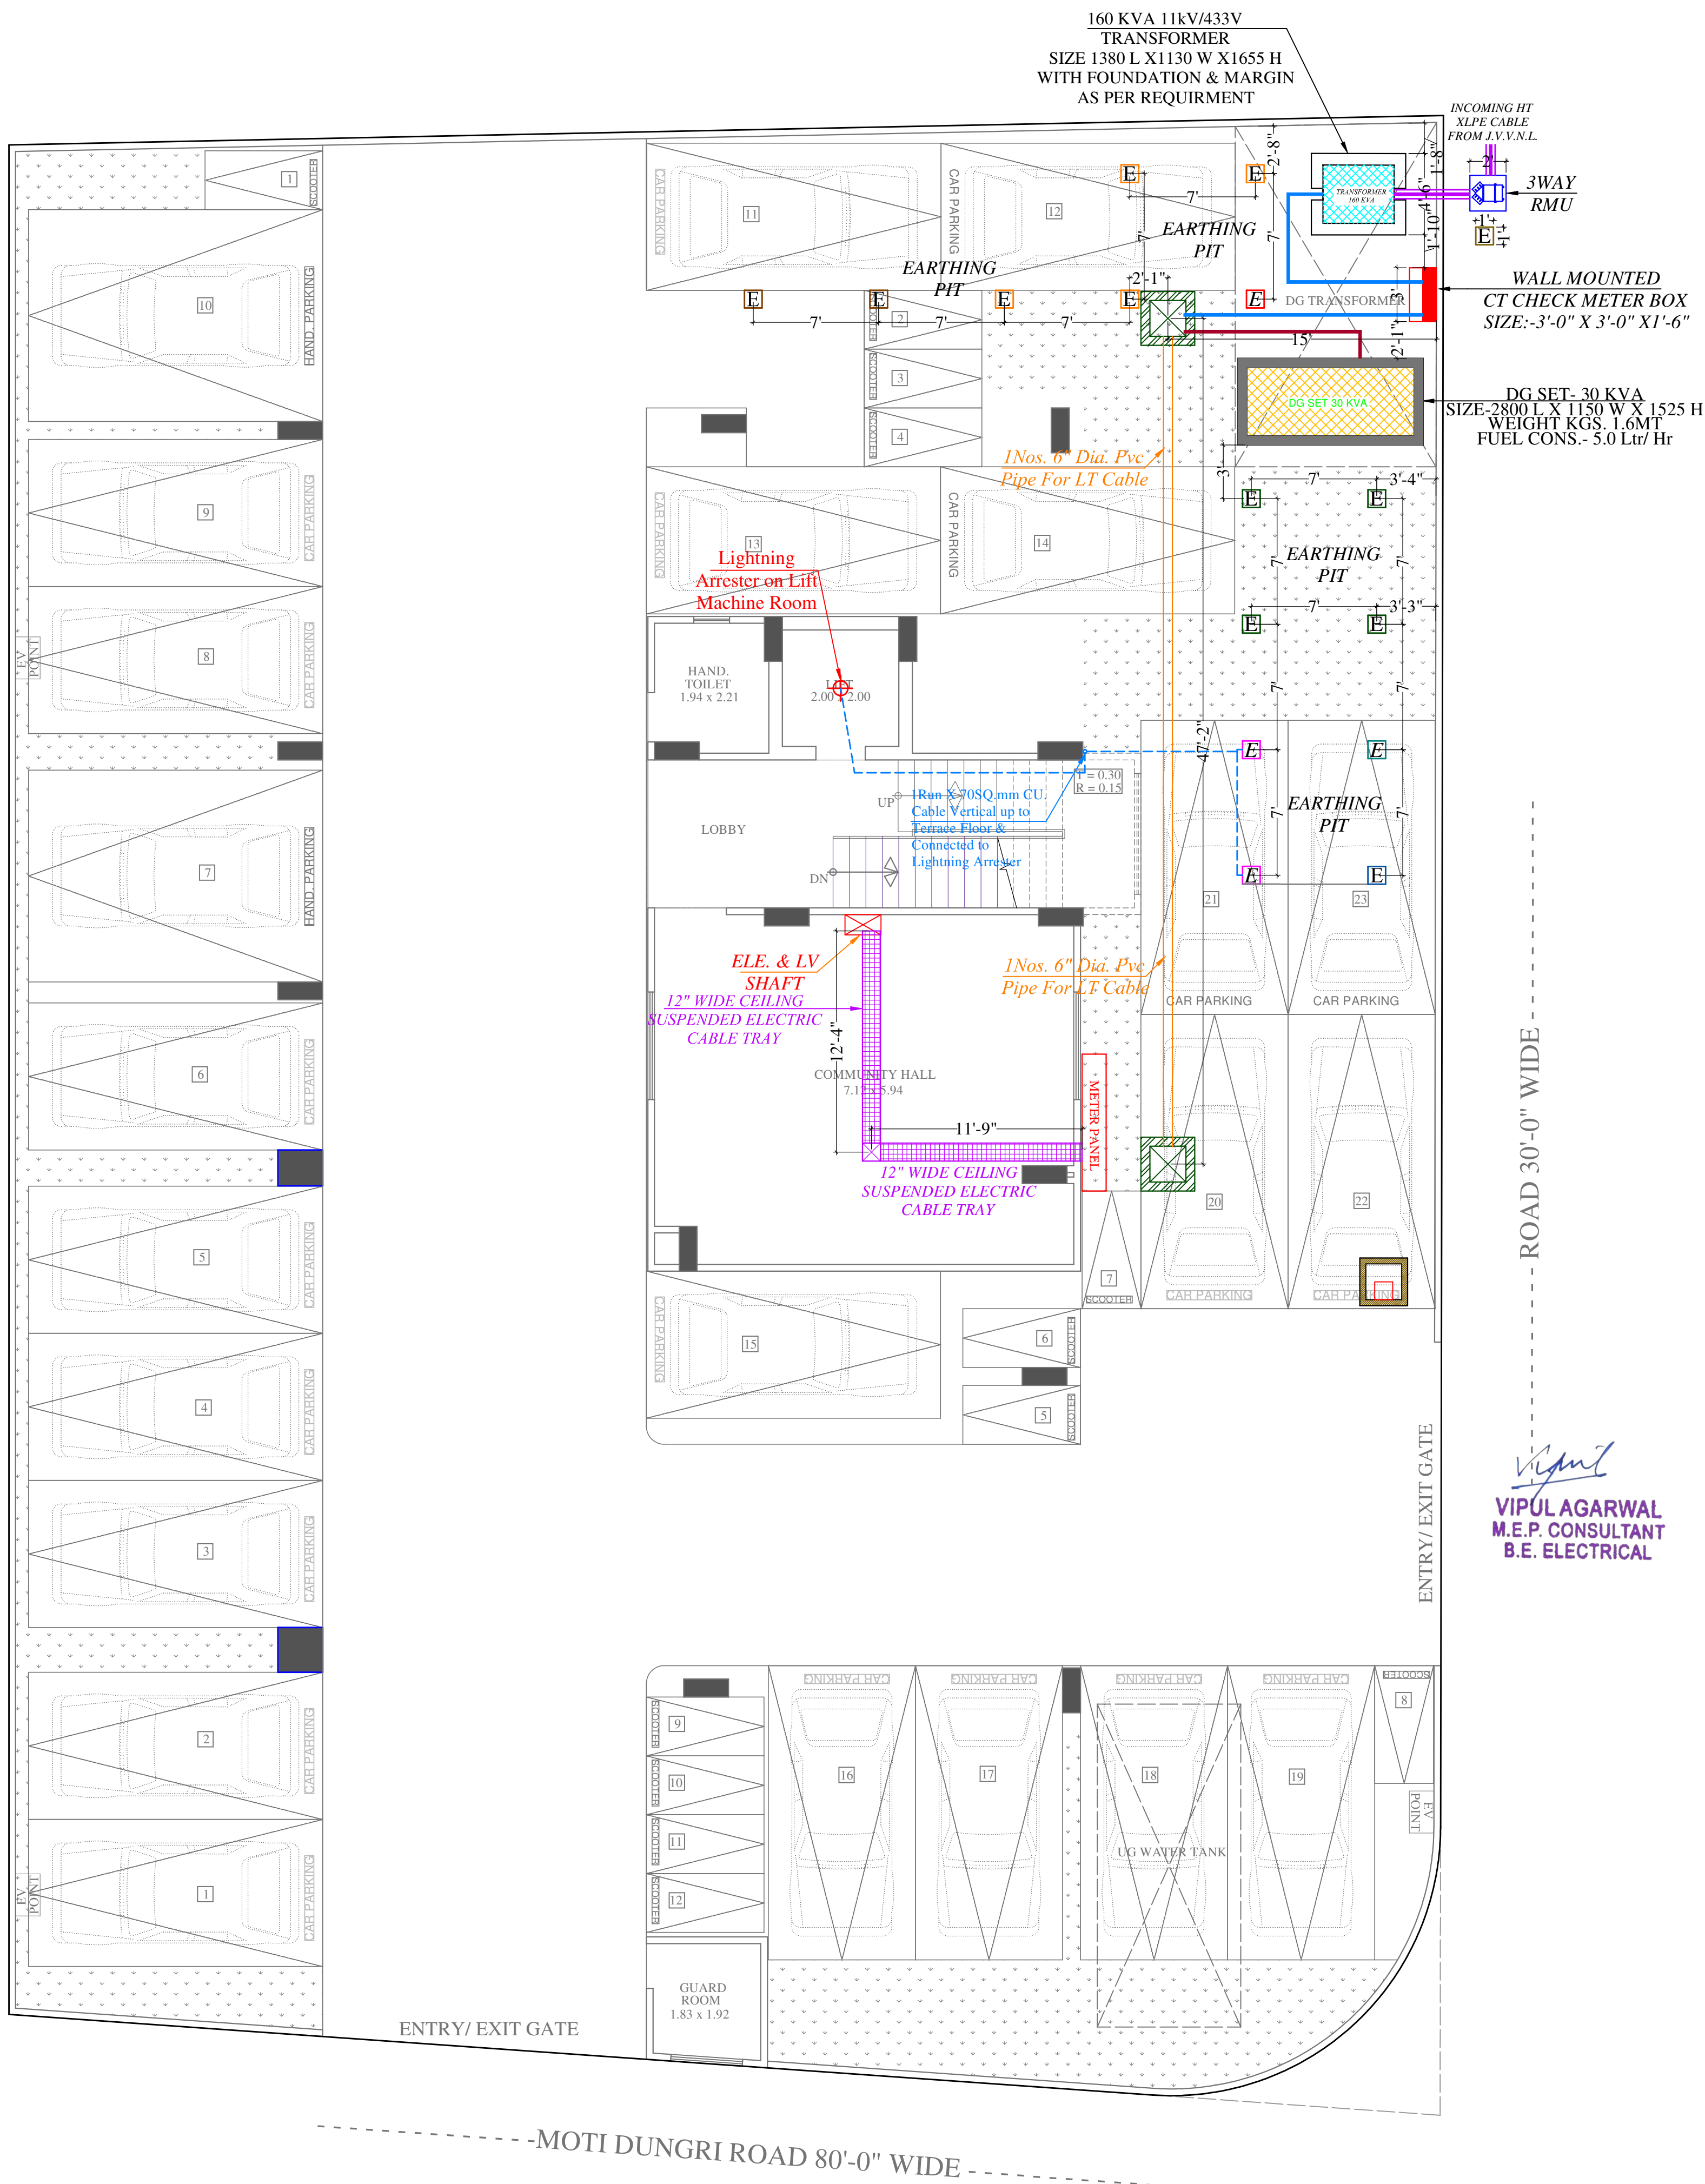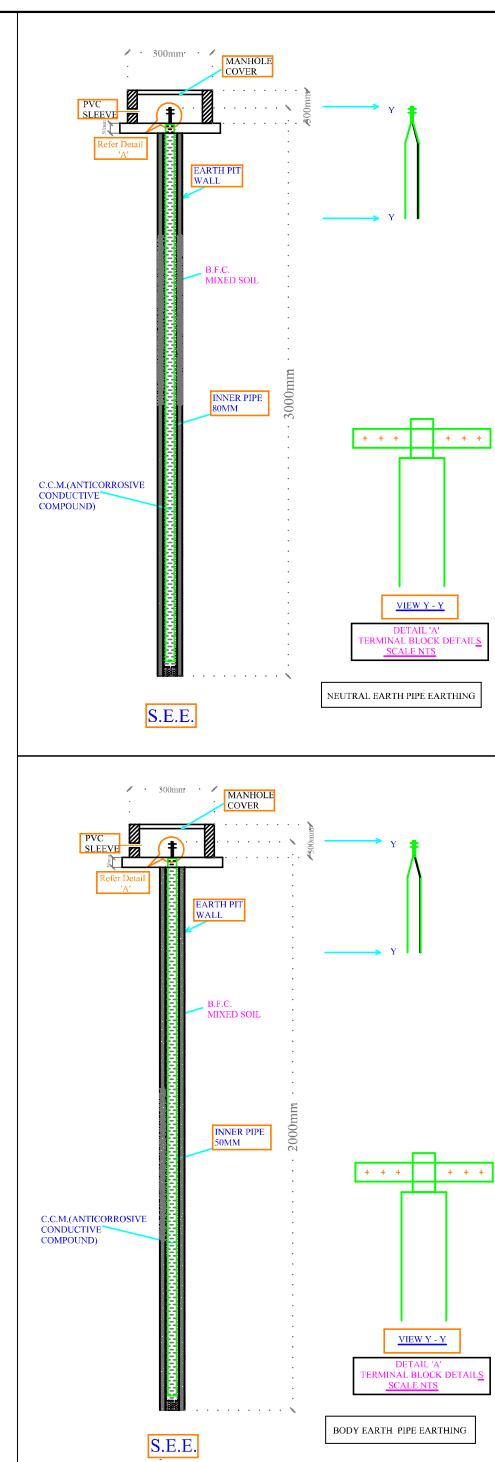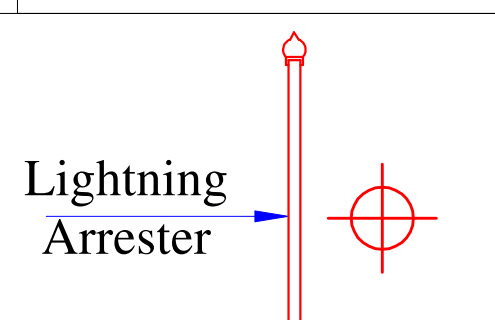

Lightning Arrester

Model: Stormaster – ESE - 30
(Level 2/Medium Protection)
(Protection radius - 25M,
Mast Height -2 Mtr)

EARTHING DETAILS		
01	50MM PIPE(2METER)	3 WAY RMU BODY EARTH
01	50MM PIPE(2METER)	CT CHECK METER BOX EARTH
02	50MM PIPE(2METER)	TRANSFORMER BODY EARTH
02	80MM PIPE(3METER)	TRANSFORMER NEUTRAL EARTH
02	50MM PIPE(2METER)	DG SET BODY EARTH
02	80MM PIPE(3METER)	DG SET NEUTRAL EARTH
02	50MM PIPE(2METER)	LIGHTNING ARRESTER-BODY-EARTH
01	50MM PIPE(2METER)	ELECTRIC PANEL BODY EARTH
01	50MM PIPE(2METER)	TELEPHONE EXCH. BODY EARTH
02	50MM PIPE(2METER)	LIFT PANEL BODY EARTH

NOTES:
1. ALL NEUTRAL EARTHS TO BE CONNECTED 50 X 3 GI EARTH STRIP FROM EARTH PIT TO EQUIPMENT.
2. ALL BODY EARTHS TO BE CONNECTED 25 X 3 GI EARTH STRIP FROM EARTH PIT TO EQUIPMENT.

SERVICES CONSULTANT:
ASHI ASSOCIATES,
F 9 / 440 , Keshav Marg Chitrakut Scheme,Jaipur
PH:91-0-93146-10438 ,0141-2440946 Mail:vipul8599@yahoo.com

DRN BY- SURENDER YADAV CKD BY- SANJAY
APPD BY- VIPUL AGARWAL REV.- 00
DATE- 21-06-2023 SCALE-


PROJECT NAME:- VIRASAT TRILOK


PROMOTER:- SRS BUILDERS

PROJECT ADDRESS:-
PROPOSED RESIDENTIAL BUILDING AT
PLOT NO. 10, UNIYARA GARDEN, JAIPUR
(RAJASTHAN)

DRAWING:
ELECTRIC SUB-STATION,
CABLE ROUTE & LIGHTNING ARRESTER
PLAN FOR RERA SUBMISSION

ARCHITECT :-
SPACE GRID
C-49,vidya Apartment,paras Marg,
Bapu Nagar,near Janta Store
Circle, Jaipur-302015
Ph-09314918766,0141-4005506(o)
Email:-info.spacegrid@gmail.com

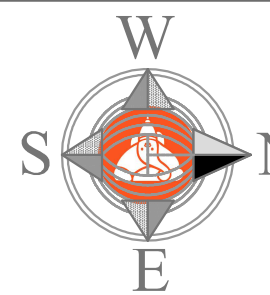

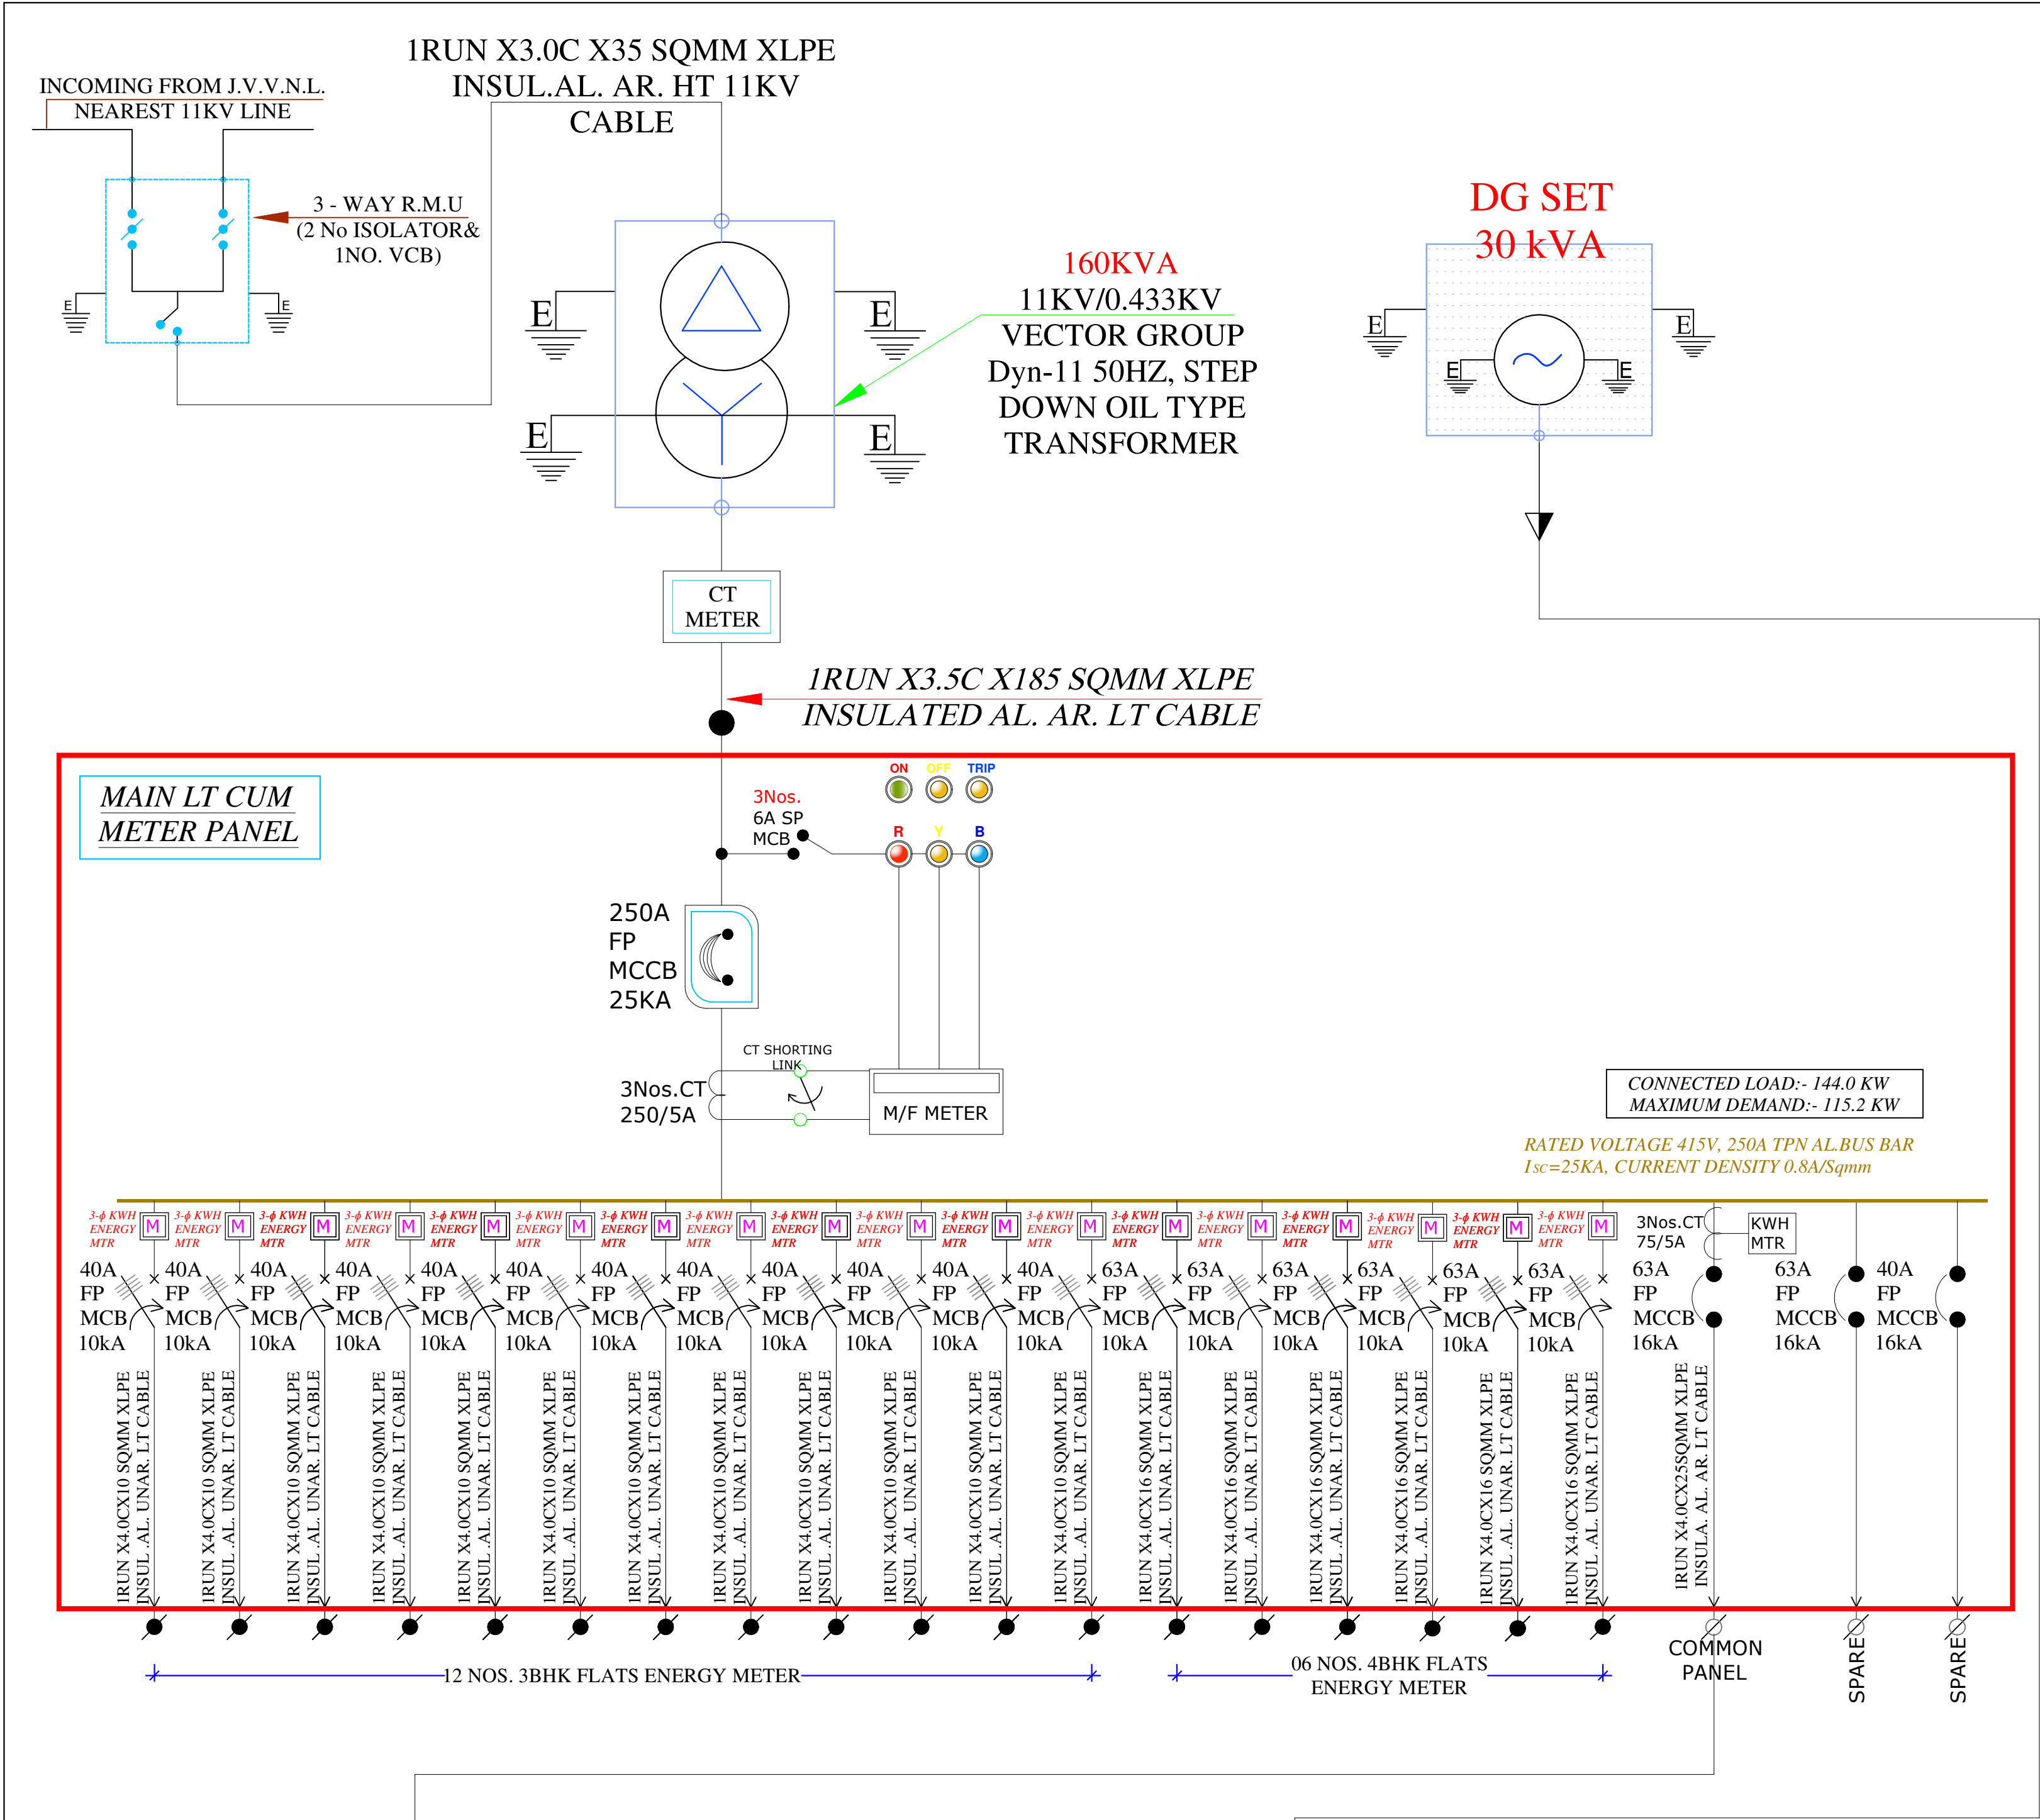

MEP CONSULTANT:
ASHI ASSOCIATES
F 9-440, KESHAV MARG,
CHITRAKUT SCHEME, JAIPUR
PH:93146-10438,2440946
E MAIL:vipul8599@yahoo.com

PROJECT ADD:-
"VIRASAT"
RESI. APARTMENT AT PL NO. 10,
UNIYARA GARDEN, JAIPUR

PROJECT NAME:-
VIRASAT TRILOK

PROMOTER:-
SRS BUILDERS

TITLE:-
ALL DISTRIBUTION PANEL

DRAWING:-
SINGLE LINE DIAGRAM


DATE:- 20-06-2024 **REV:-** 00

DRAWN BY:-
SURENDER YADAV

CHECKED BY:-
VIPUL AGARWAL

NOTE:-
THIS SLD HAS BEEN PREPARED AS PER CONCEPT STAGE DATA AVAILABLE WITH US. KINDLY CONTACT US FOR FINAL SLD & DETAILS BEFORE PLACING ORDER FOR FABRICATION.WE SHALL NOT BE RESPONSIBLE , IF THE PANELS ARE UNDER UTILISED OR OVER LOADED AT ANY STAGE.

VIPUL AGARWAL
M.E.P. CONSULTANT
B.E. ELECTRICAL

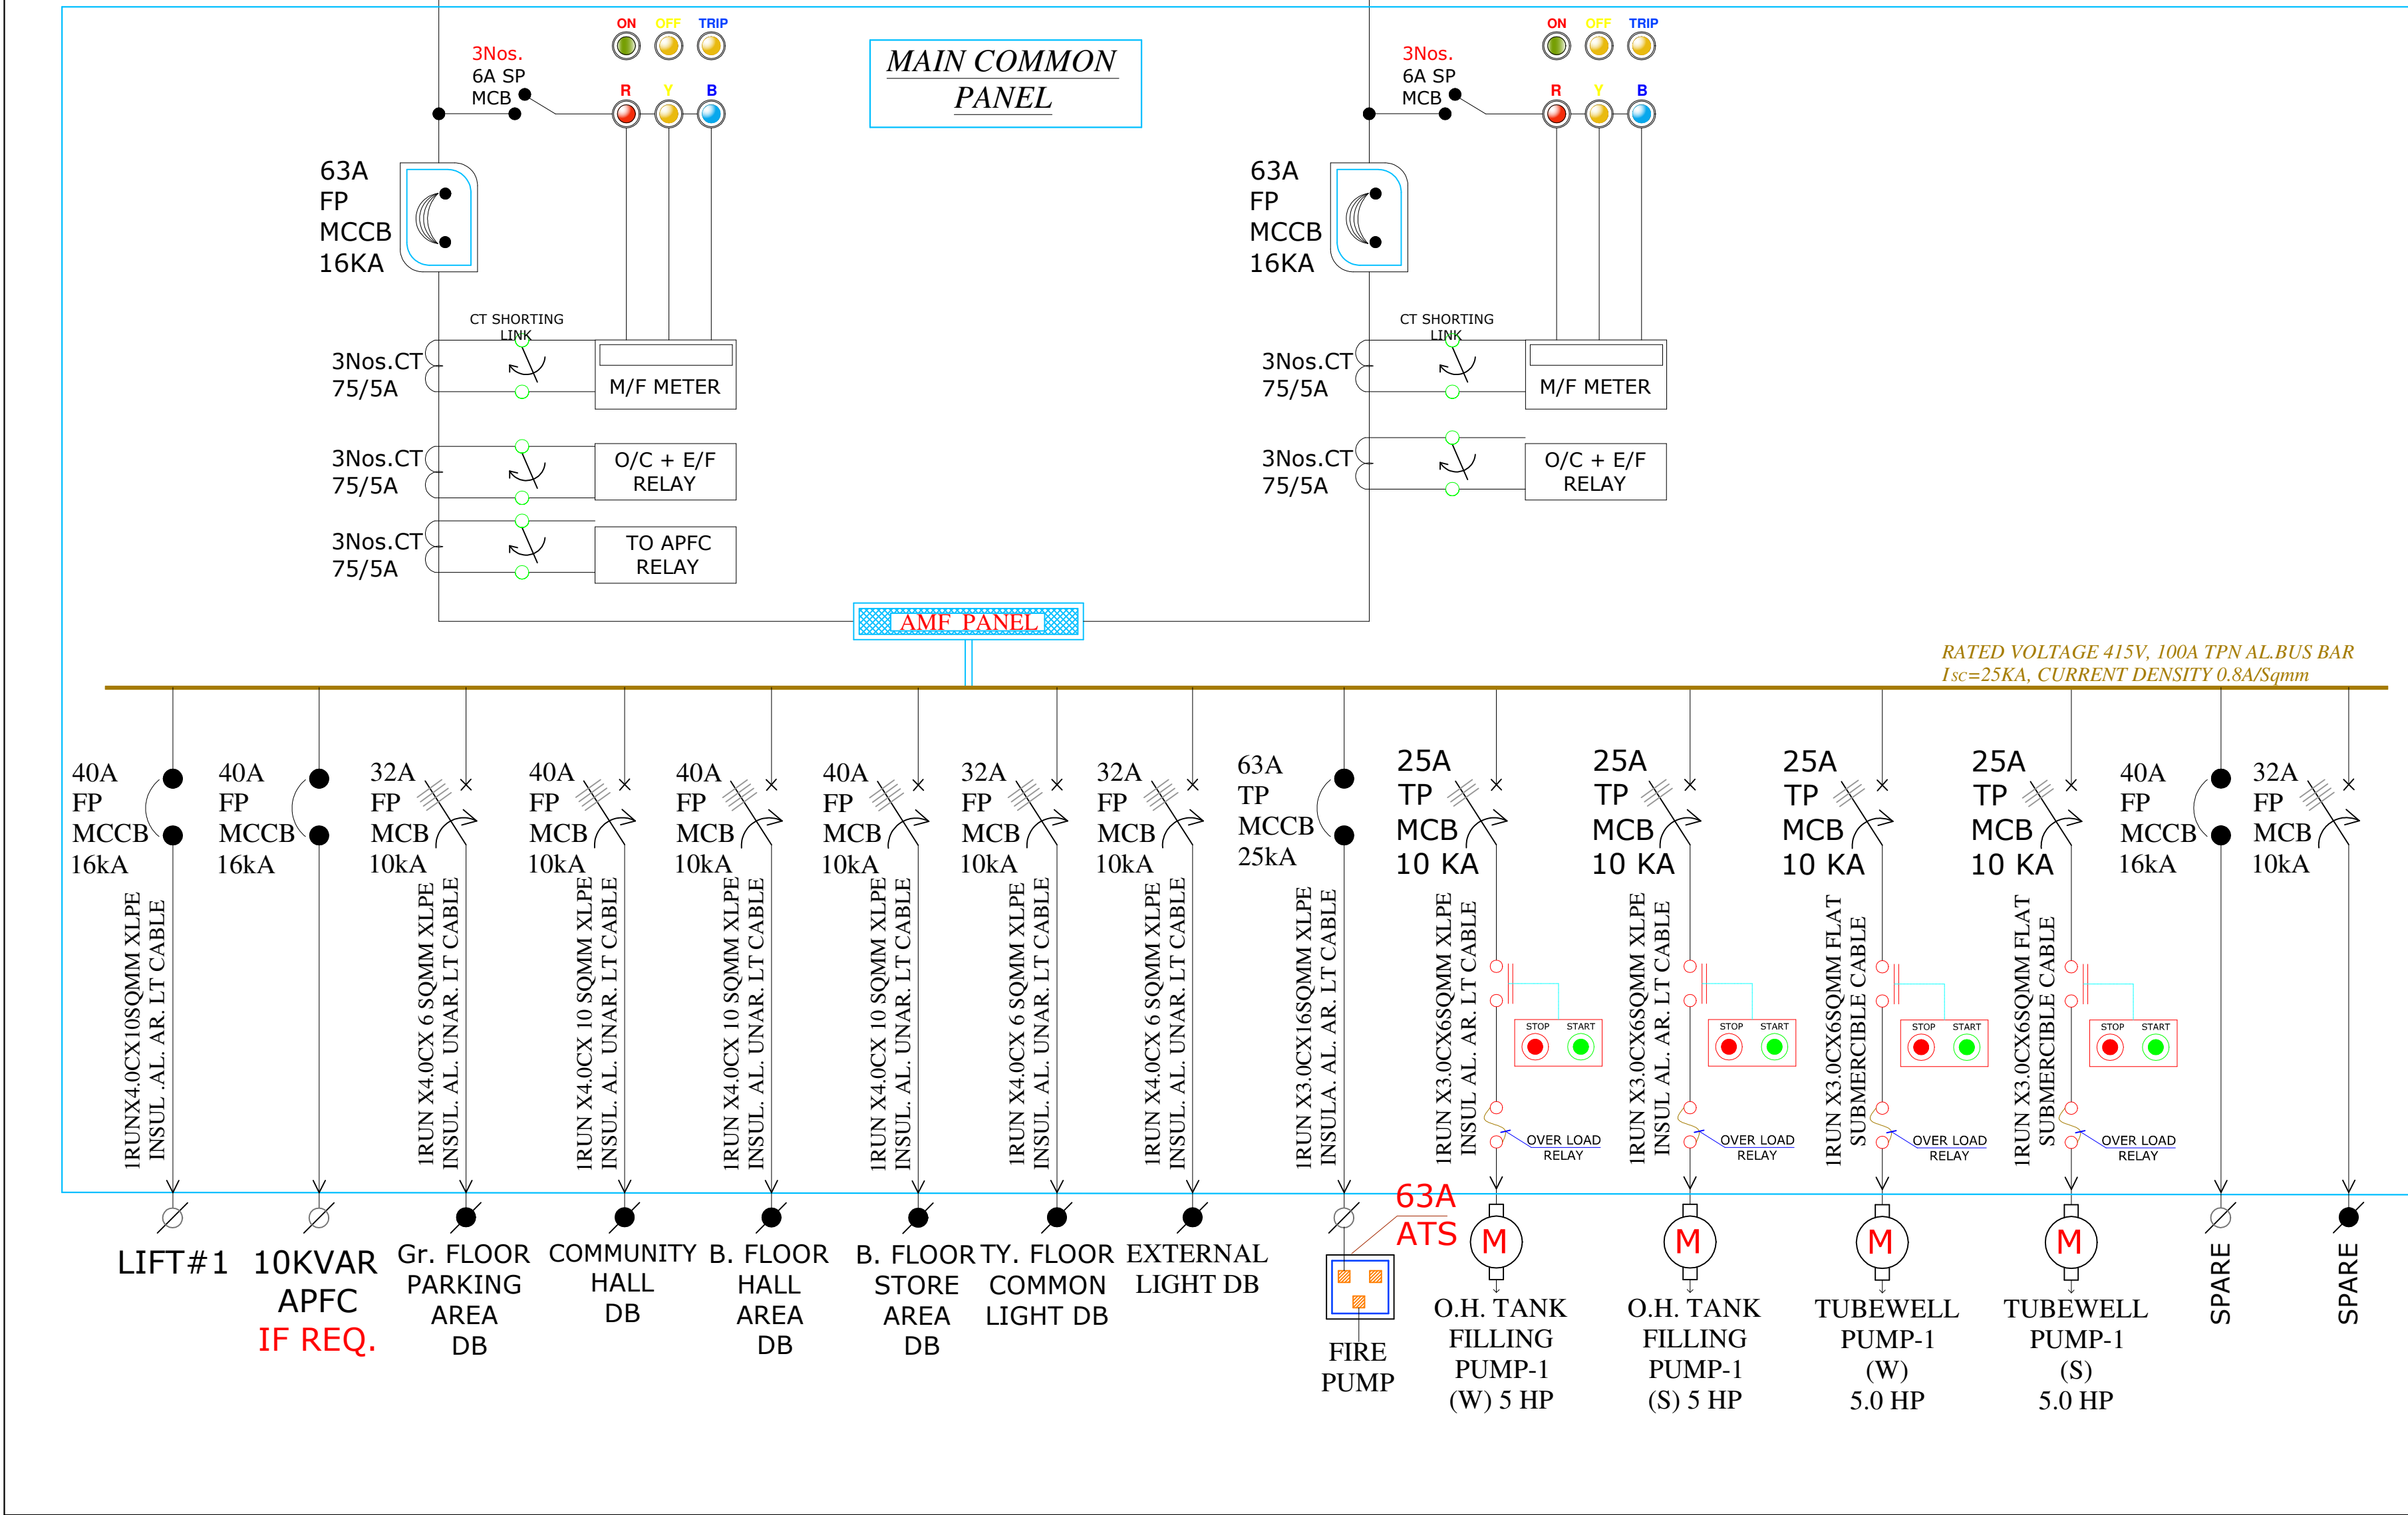

Vipul
VIPUL AGARWAL
M.E.P. CONSULTANT
B.E. ELECTRICAL

LEGENDS:

Mounting Height	No.	ID	Symbol	Description
CEILING	04	FAN48"		CEILING FAN 48"
CEILING	32	DL		Led 6" Down Lighter 20W (Surface Mounted) Make:- Syska Led Cat no:- SDL-15W GLD 6.5K/4K
CEILING	12	TL		LED CEILING TUBE LIGHT MAKE:- SYSKA LED CAT NO:- SSK-T5-20W
+90°	04	TL/W		Led Wall Tube Light Make:- Syska Led Cat no:- SSK-T5-20W
+90°	01	BULB		Led Bulb 20W Make:- Syska Led Cat no:- SSK-20W 5.7K/3K
VENTILATOR HT.	01	CR		CEILING ROSE
VENTILATOR HT.	01	EXF		9" DIA FRESH AIR FAN
+90°	02	SAC		SPLIT AC INDOOR UNIT
+42°	05	SB		SWITCH BOARD
+18°	04	PP		16 A POWER POINT
+60°	01	MCB DB		MCB DISTRIBUTION BOARD

SERVICES CONSULTANT:
ASHI ASSOCIATES
F 9 / 440 , Keshav Marg Chitrakut Scheme,Jaipur
PH:91-0-93146-10438 ,0141-2440946 Mail:vipul8599@yahoo.com

PROJECT NAME:-

VIRASAT TRILOK

PROMOTER:-

SRS BUILDERS


PROJECT ADD:-

PROPOSED RESIDENTIAL
BUILDING AT PLOT NO. 10,
UNIYARA GARDEN, JAIPUR

DRAWING TITLE:-

STILT FLOOR
ELECTRIC POINT MARKING PLAN

DATE:- 20-06-2024	DRG. NO. EC-01
REV.:- 00	
DRN:- MAHENDRA	
CKD.:- SANJAY	
APPD.:- VIPUL AGARWAL	
ARCHITECT :-	

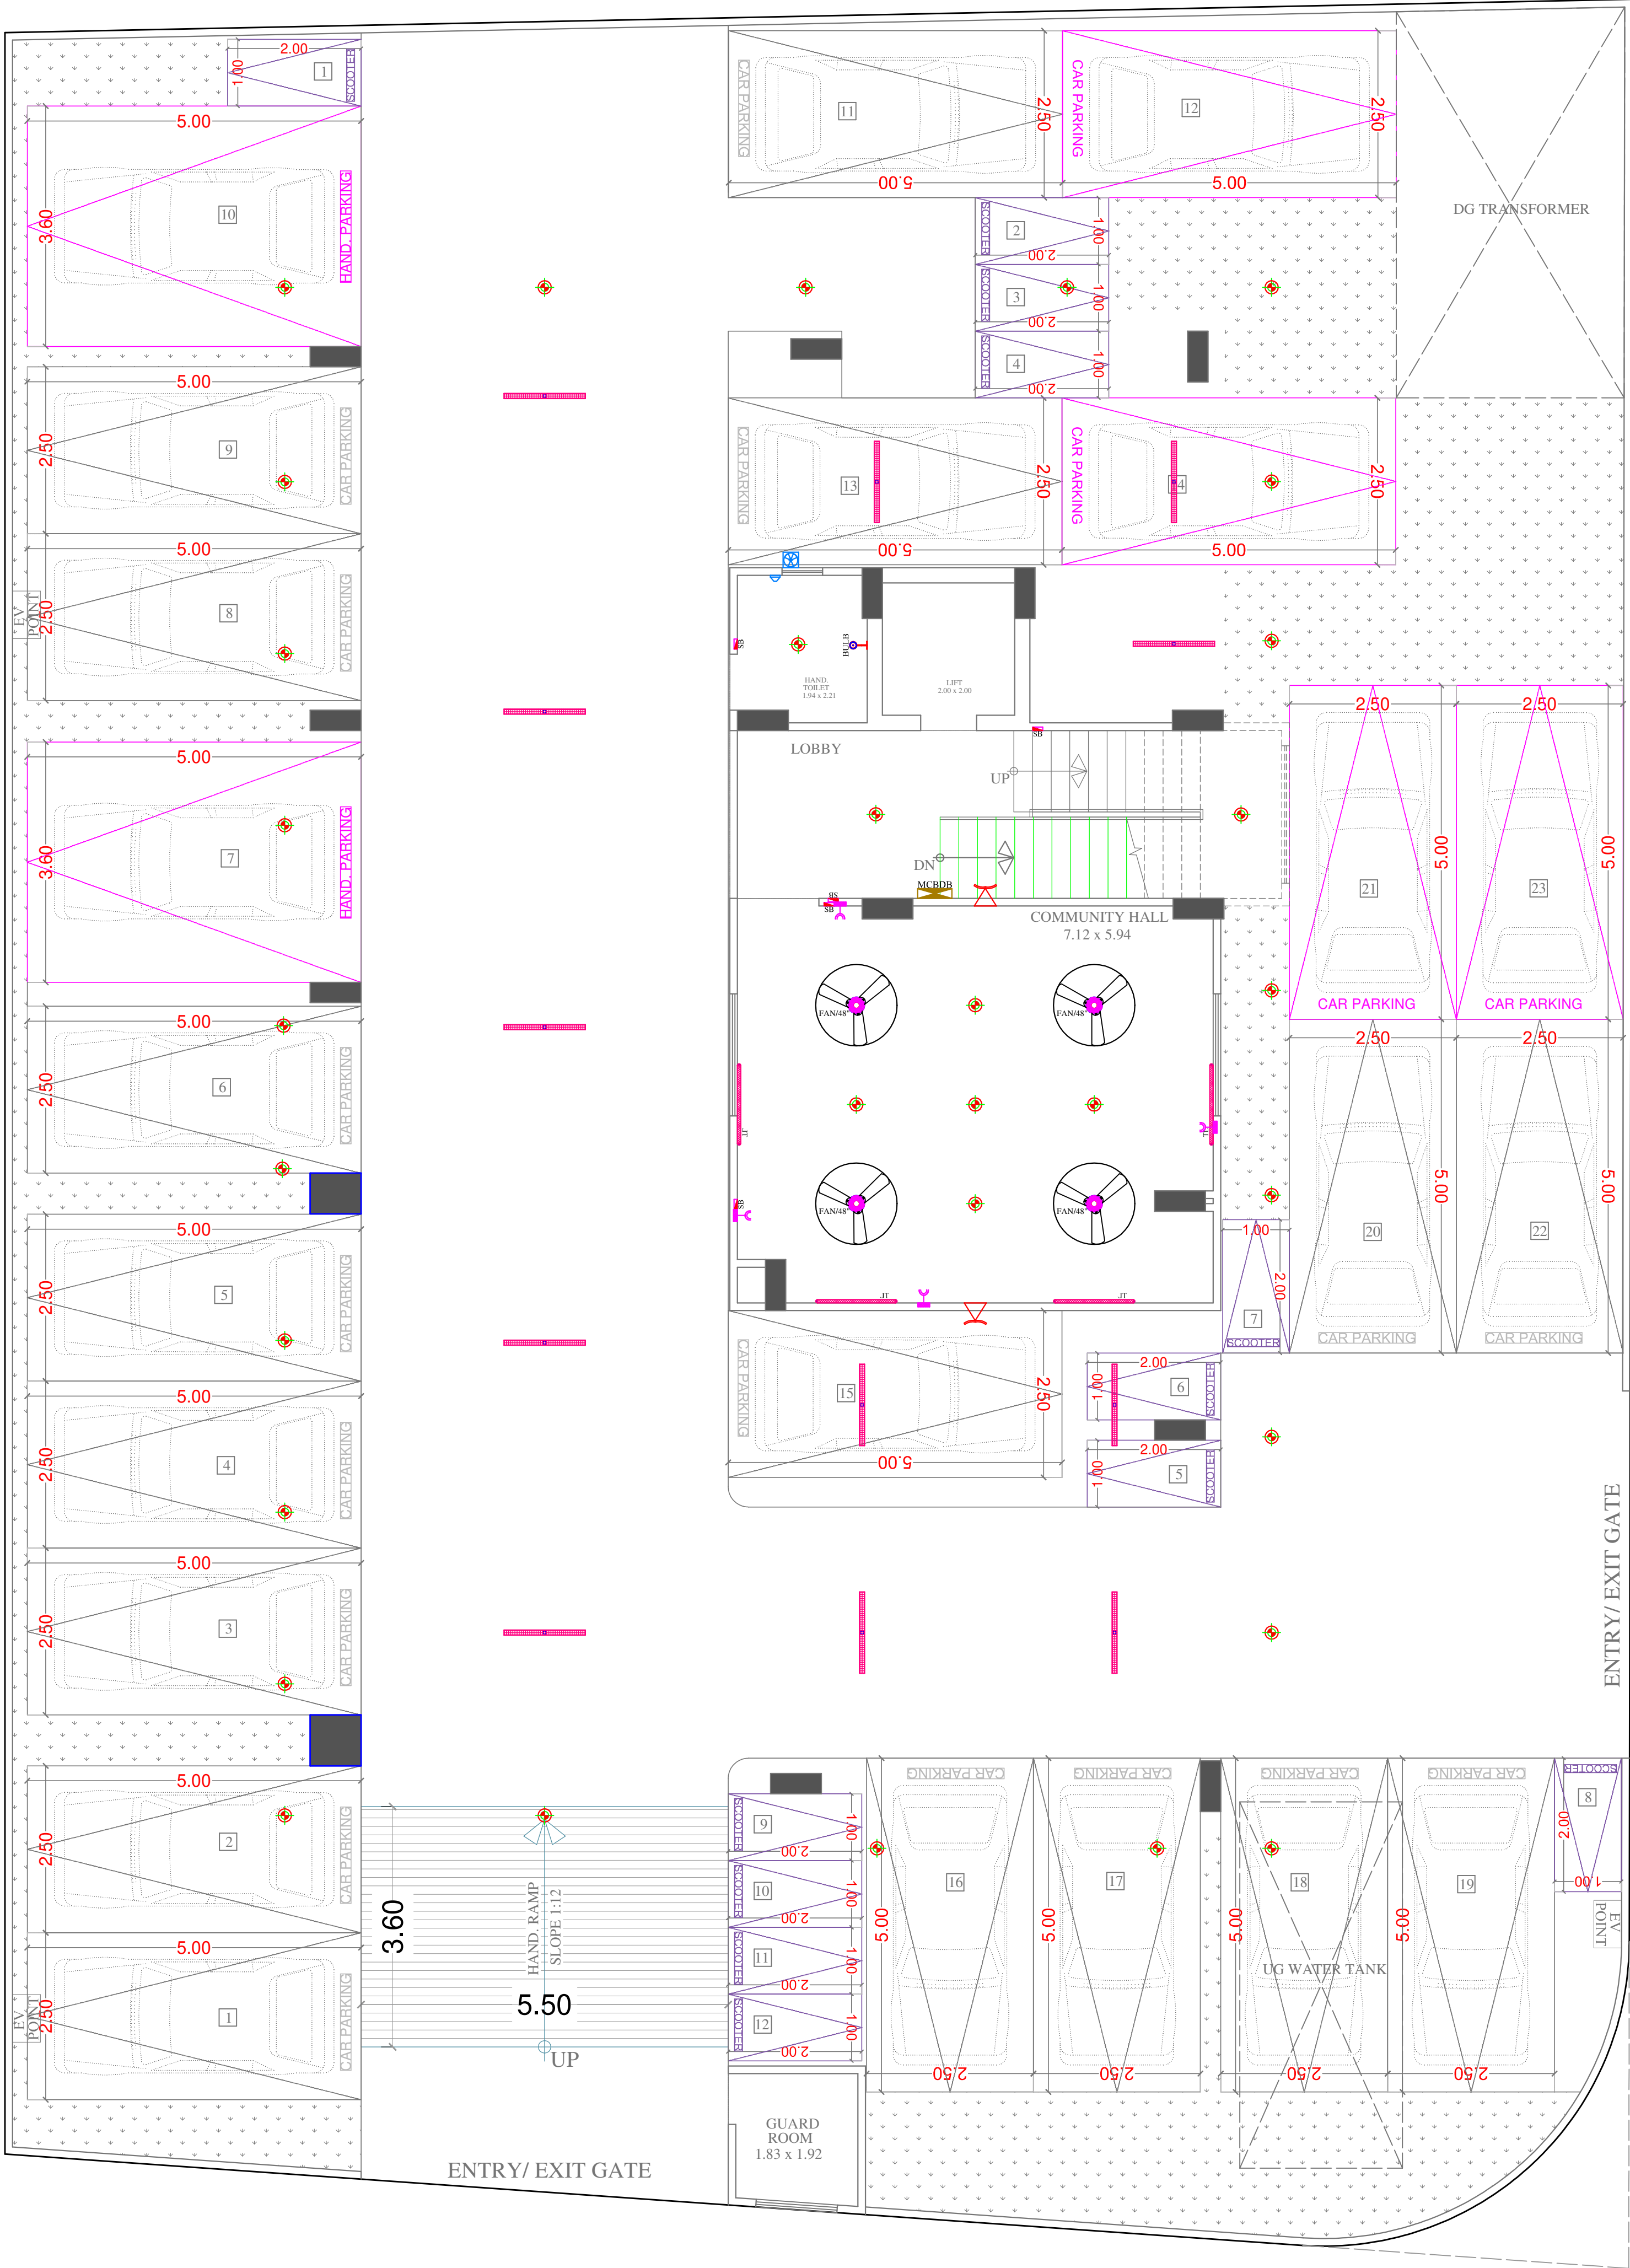

STILT PLAN