
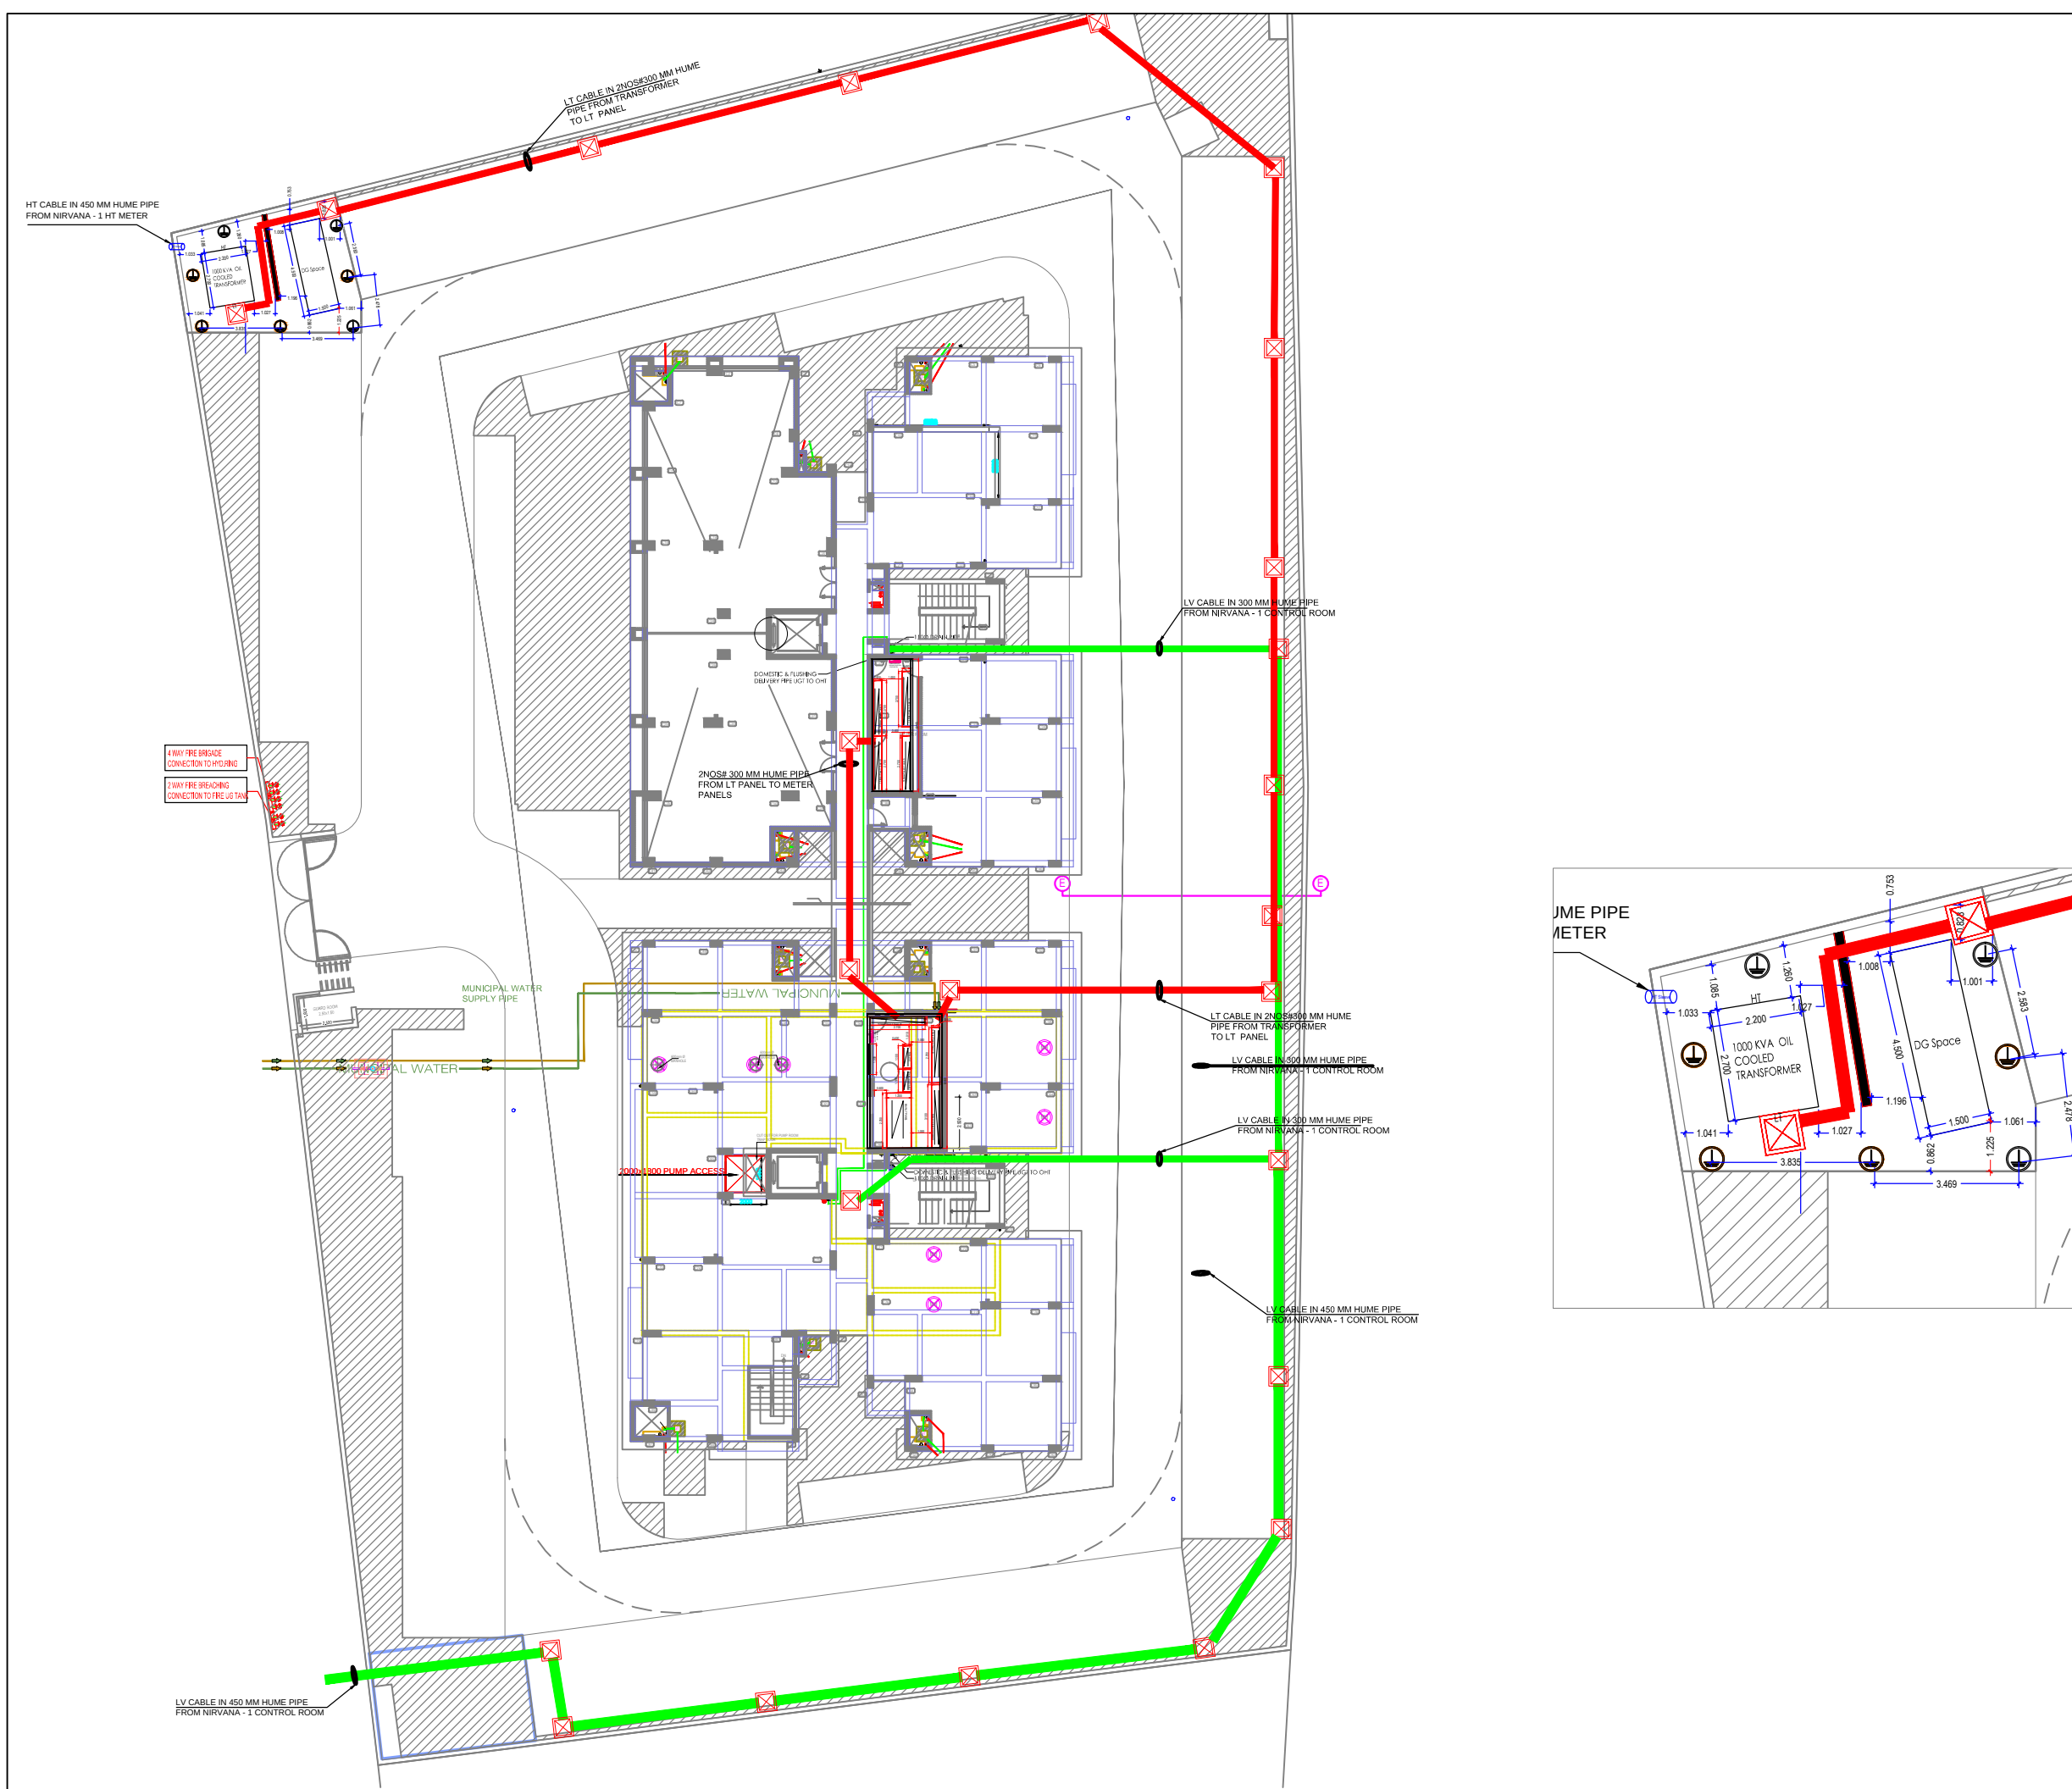


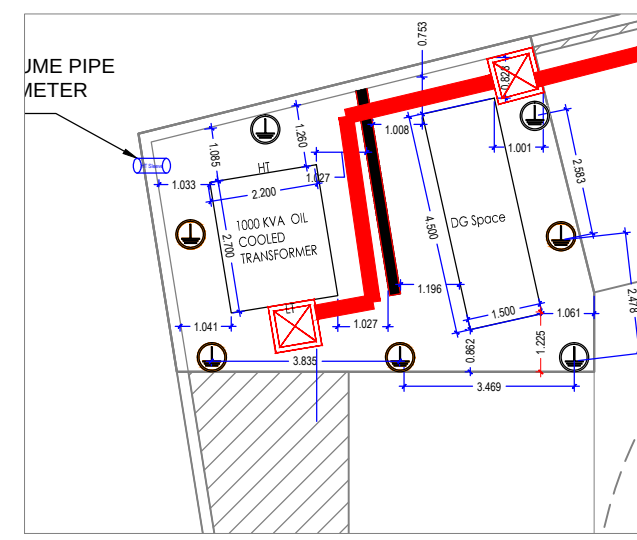

KEY PLAN:

SCALE : NTS

NOTES:

1. ALL DIMENSIONS GIVEN ON THIS DRAWING ARE IN MILLIMETERS. DO NOT SCALE THE DRAWINGS, ANY DISCREPANCIES FOUND SHOULD BE REPORTED TO THE RESPONSIBLE ARCHITECT OR ENGINEER IMMEDIATELY.
2. IT IS THE RESPONSIBILITY OF THE CONTRACTOR TO ASCERTAIN AND CONFIRM THAT ALL DIMENSIONS SHOWN IN THESE DRAWINGS SHALL COMPLY WITH THE SITE DIMENSIONS AND LEVELS PRIOR TO PREPARING DRAWINGS AND EXECUTING THE WORKS.

DRAWING REFERENCE:

ARCHITECTURAL DRAWING,
i) 20151007_drawing docket REV-RO (DT:26.10.15)
A101-109_All floor plans20151007
STRUCTURAL DRAWING,
ii) 0000000, REV-RO (DT:00.00.00)

REV.	DATE	DESCRIPTION	DRN	CHKD.

CLIENT:

MAHIMA GROUP

PROJECT:

NIRVANA PLOT-2

PMC:

ARCHITECT:

m | a | architects

MEP SERVICES CONSULTANT:

EMC

ELECTRO-MECH CONSULTANTS
106/107 Floor, 26th March Avenue, Suite 408 2nd, 3rd Floor, 408 409 410, Indira Nagar, Delhi
Tel : +91-822 8810 3097/2630 /9671
Email : emc.mumbai@gmail.com / emc@emcmumbai.co.uk

TITLE:

Substation Layout

NORTH

ORG. NO.

EMC-530-CO-01

JOB NO.

530

REVISION

A1

DRAWN	DATE	SCALE	CHKD.	APP.
PRADIP	29.11.2014	1:150	KARTIK	RUPESH G.