


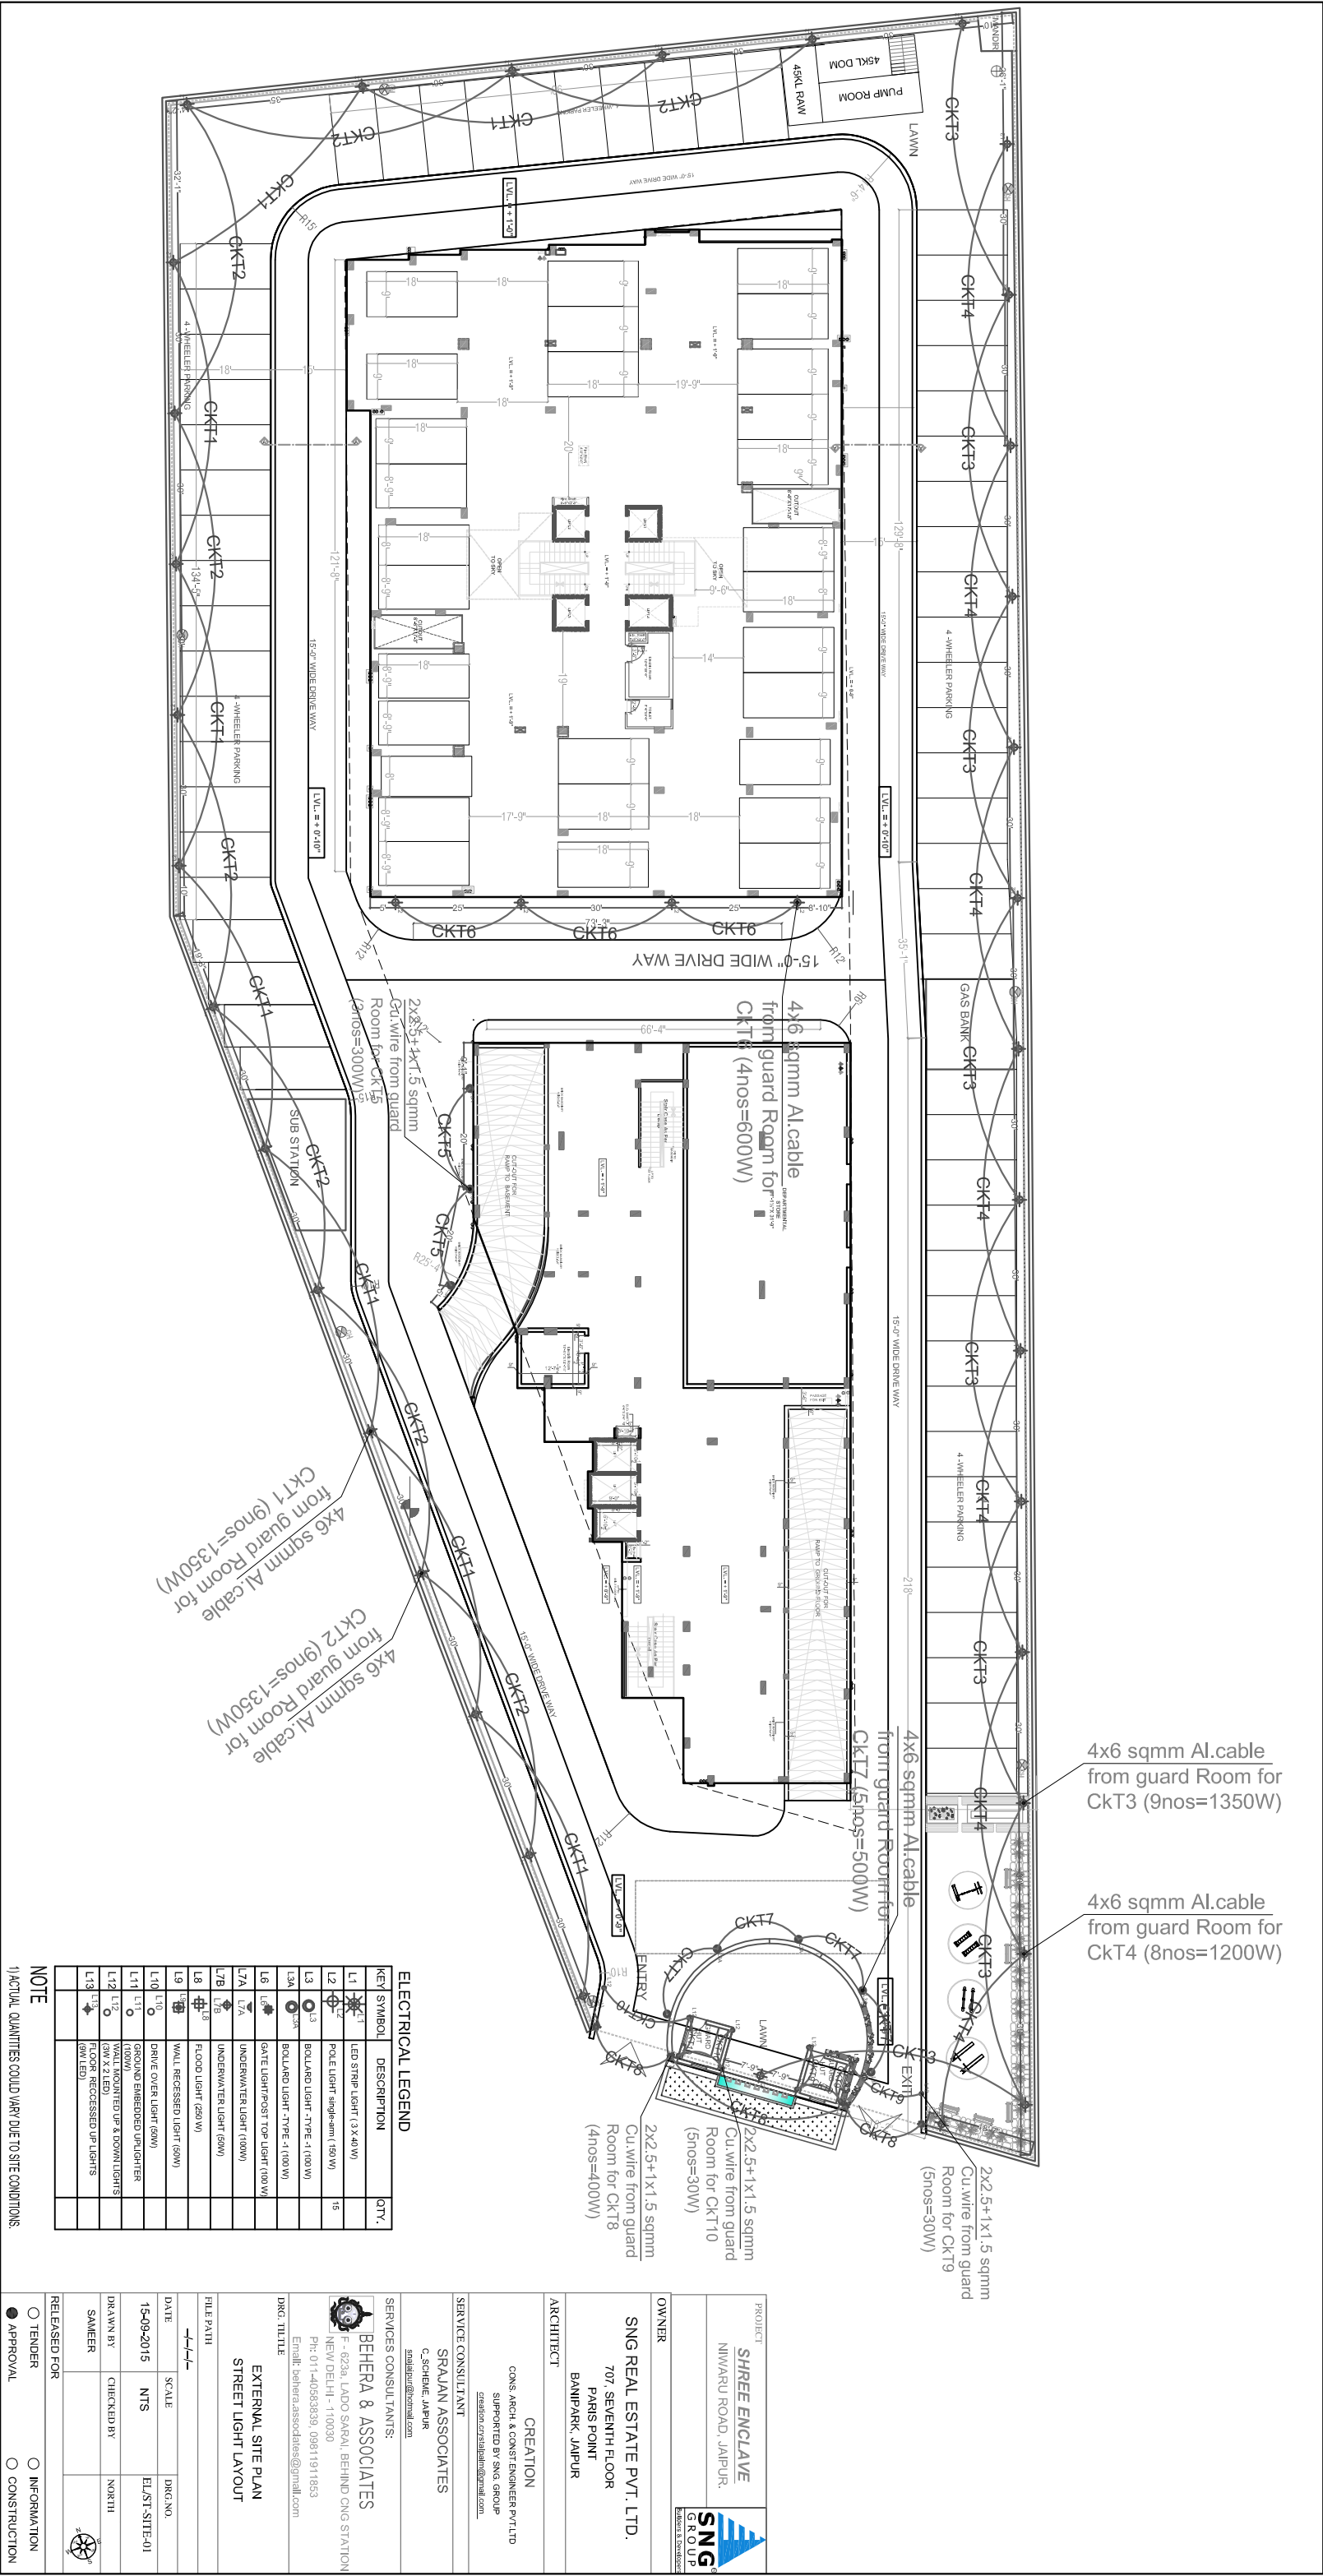

ELECTRICAL LEGEND		
KEY SYMBOL	DESCRIPTION	QTY.
L1	LED STRIP LIGHT (2X40W)	15
L2	POLE LIGHT single-arm (150W)	
L3	BOLLARD LIGHT -TYPE 1 (100W)	
L3A	BOLLARD LIGHT -TYPE 1 (100W)	
L6	GATE LIGHT/POST TOP LIGHT (100W)	
L7A	UNDERWATER LIGHT (100W)	
L7B	UNDERWATER LIGHT (50W)	
L8	FLOOD LIGHT (60W)	
L9	WALL RECESSED LIGHT (50W)	
L10	DRIVE OVER LIGHT (50W)	
L11	GROUND EMBEDDED UNLIGHTER (100W)	
L12	DOWNLIGHTS (2W X 2 LED)	
L13	FLOOR RECESSED UP LIGHTS (2W LED)	

NOTE
1) ACTUAL QUANTITIES COULD VARY DUE TO SITE CONDITIONS.

PROJECT SHREE ENCLAVE NIMWARU ROAD, JAIPUR.		
OWNER SNG REAL ESTATE PVT. LTD. 707, SEVENTH FLOOR PARIS POINT BANIPARK, JAIPUR		
ARCHITECT CREATION CONS. ARCH & CONST. ENGINEER PVT. LTD SUPPORTED BY SNG GROUP creation.creation@gmail.com		
SERVICE CONSULTANT SRAJAN ASSOCIATES C. SCHEDE, JAIPUR srajan@sraindian.com		
SERVICES CONSULTANTS:  BEHERA & ASSOCIATES F - 623a, LAOO SARAI, BEHIND CNG STATION NEW DELHI - 110030 Ph: 011-40563839, 09811911853 Email: behera.associates@gmail.com		
DRG. TITLE EXTERNAL SITE PLAN STREET LIGHT LAYOUT		
FILE PATH 		
DATE 15-09-2015	SCALE NTS	DRG. NO. EL/ST-SITE-01
DRAWN BY SAMEER	CHECKED BY NORTH	
RELEASED FOR ☐ TENDER ☒ APPROVAL		☐ INFORMATION ☐ CONSTRUCTION

SCHEDULE OF PIPES

PIPE NO.	DESCRIPTION
1	110 OD uPVC SOIL
2	110 OD uPVC WASTE
3	DOMESTIC WATER SUPPLY D/N TAKE PIPE *
4	FLUSHING WATER SUPPLY D/N TAKE PIPE *
5	90 OD uPVC RAIN WATER PIPE FOR BALCONY
6	110 OD uPVC RAIN WATER PIPE FOR TERRACE
7	HOT WATER SUPPLY D/N TAKE PIPE ONLY FOR KITCHEN * (SOLAR)
8	DOMESTIC WATER SUPPLY RISER PIPE *
9	FLUSHING WATER SUPPLY RISER PIPE *
BOB	BOTTOM OF BEAM
BOP	BOTTOM OF PIPE

DRG. TITLE

BASEMENT CEILING PLAN

PLUMBING LAYOUT

FILE PATH

---/---/---

DATE	SCALE	DRG.NO.
11-06-2013	FIT TO SCALE	PL-BA-B-01

DRAWN BY	CHECKED BY	NORTH
M.SINGH	SOMNATH	

RELEASED FOR

☐ TENDER

☐ INFORMATION

☐ APPROVAL

☒ CONSTRUCTION

OWNER

SNG REAL ESTATE PVT. LTD.
707, SEVENTH FLOOR
PARIS POINT
BANIPARK, JAIPUR

ARCHITECT

CREATION
CONS. ARCH. & CONST. ENGINEER PVT. LTD.
SUPPORTED BY SNG GROUP
sngarch@svsengineer@gmail.com


SERVICE CONSULTANT

SRAJAN ASSOCIATES
C. SICHME, JAIPUR
srajanpur@gmail.com

PLUMBING CONSULTANTS:


 **BEHERA & ASSOCIATES**
F - 623a, LADO SARAI, BEHIND CNG STATION
NEW DELHI - 110030
Ph: 011-40583839, 09811911853

Email: behera.associates@gmail.com

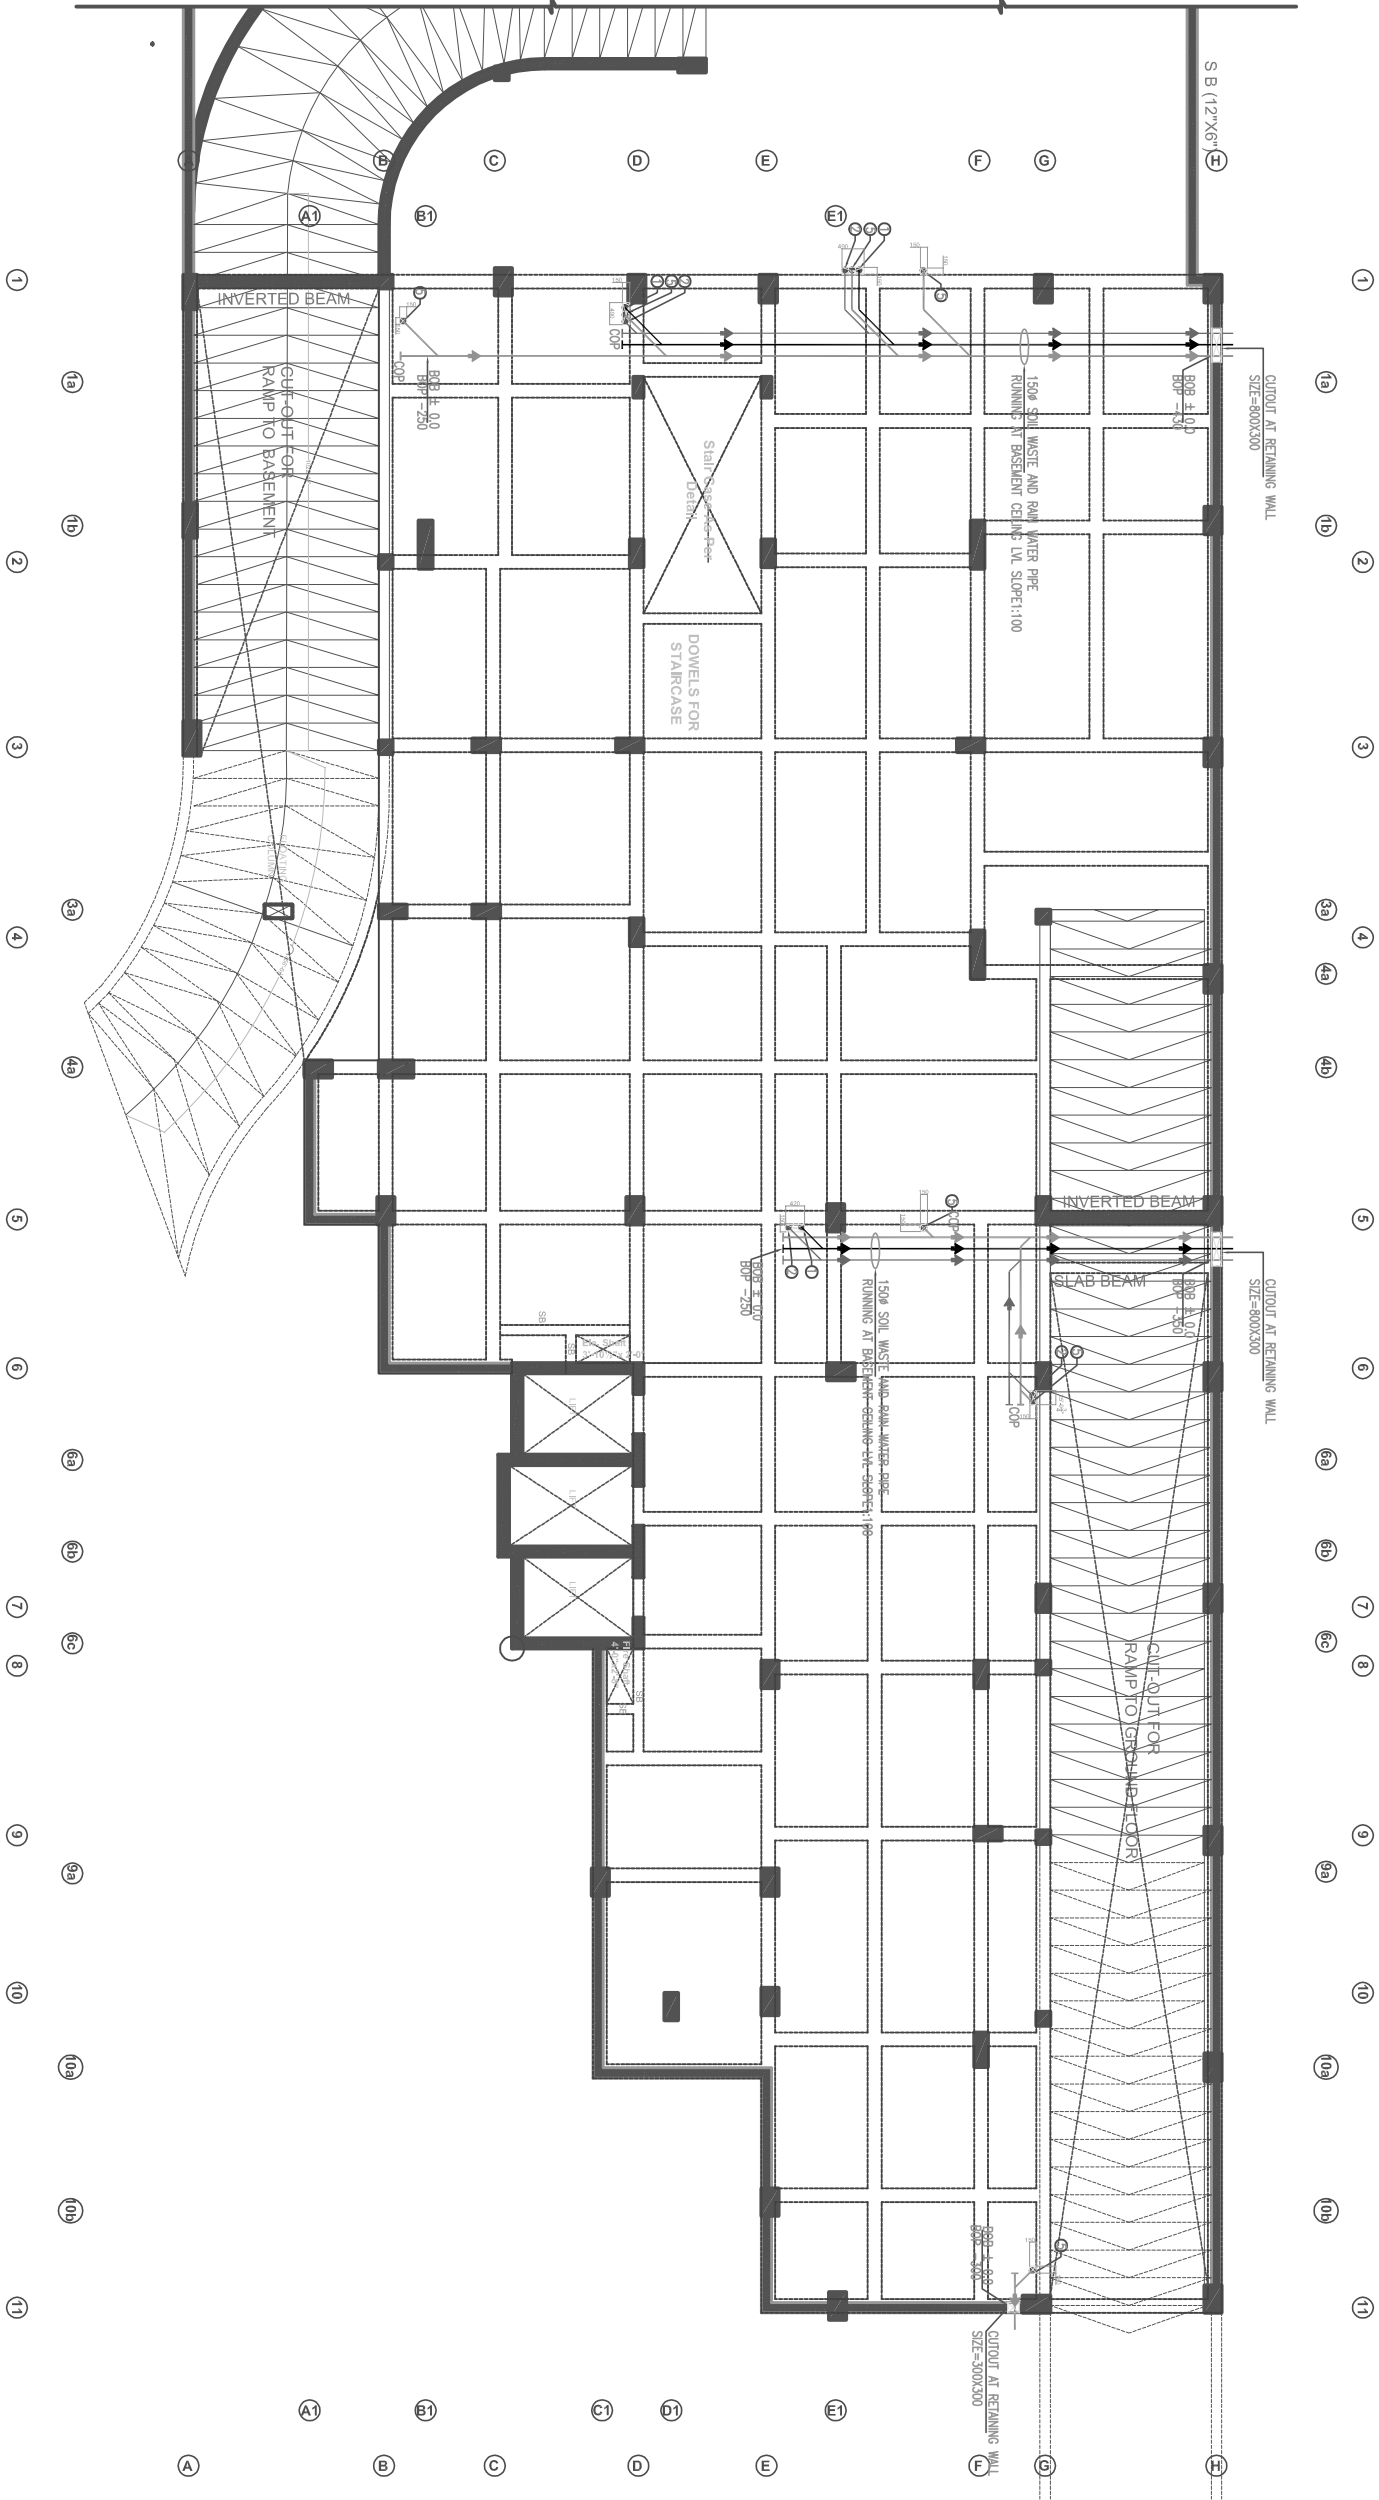

BASEMENT ROOF SHUTTERING PLAN

ALL BEAM SIZE 12"X18"

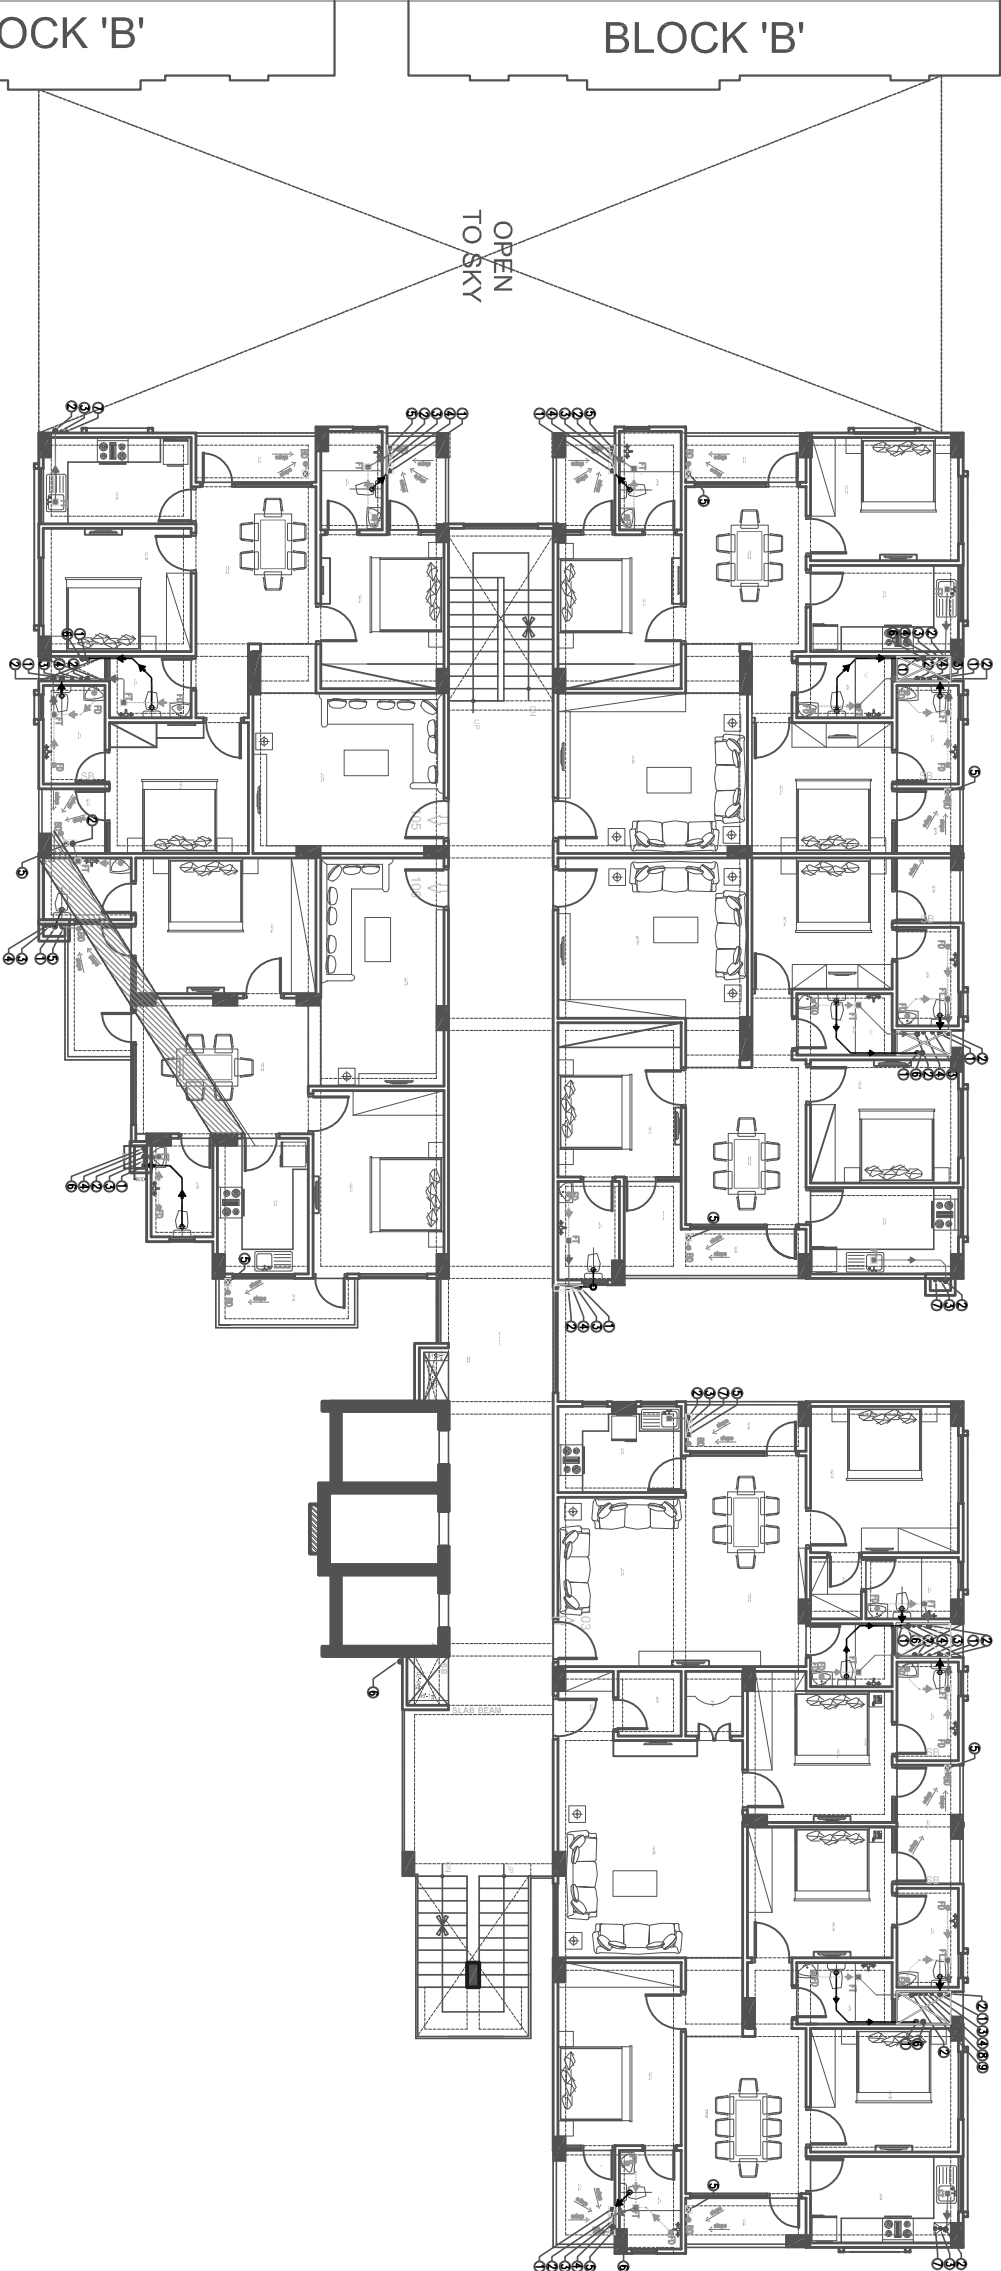

PROJECT

SHREE ENCLAVE
NIWARU ROAD, JAIPUR



SNG
GROUP
SHREE & LAMBERS

PLUMBING NOTES:-

1. FLOOR DRAIN (FD) TO FLOOR TRAP (FT) 63 OD uPVC WASTE PIPE.
2. FLOOR TRAP (FT) TO VERTICAL PIPE 110 OD uPVC
3. 110 OD uPVC PIPE USED FOR SOL. & WASTE.
4. 110 OD uPVC PIPE USED FOR TERRACE RAIN WATER
5. 90 OD uPVC PIPE USED FOR BALCONY.

SCHEDULE OF PIPES

PIPE NO.	DESCRIPTION
①	110 OD uPVC SOIL
②	110 OD uPVC WASTE
③	DOMESTIC WATER SUPPLY D/N TAKE PIPE *
④	FLUSHING WATER SUPPLY D/N TAKE PIPE *
⑤	90 OD uPVC RAIN WATER PIPE FOR BALCONY
⑥	110 OD uPVC RAIN WATER PIPE FOR TERRACE
⑦	HOT WATER SUPPLY D/N TAKE PIPE ONLY FOR KITCHEN * (SOLAR)
⑧	DOMESTIC WATER SUPPLY RISER PIPE *
⑨	FLUSHING WATER SUPPLY RISER PIPE *

DRG. TITLE
FIRST FLOOR PLAN
PLUMBING LAYOUT

FILE PATH

DATE	SCALE	DRG.NO.
24-06-2013	N.T.S.	PLS/CR/1384
DRAWN BY	CHECKED BY	NORTH
M.SINGH	SOMNATH	

RELEASED FOR

- ☐ TENDER
- ☐ INFORMATION
- ☐ APPROVAL
- ☒ CONSTRUCTION

OWNER

SNG REAL ESTATE PVT. LTD.
707, SEVENTH FLOOR
PARIS POINT
BANIPARK, JAIPUR

ARCHITECT



CREATION
CONS. ARCH. & CONST. ENGINEER PVT. LTD.
SUPPORTED BY SNG GROUP
SNGRO.COM/MAIL@SNGRO.COM.

SERVICE CONSULTANT

SRAJAN ASSOCIATES
C, SCHEME, JAIPUR
SRAJAN@GMAIL.COM

PLUMBING CONSULTANTS:

 **BEHERA & ASSOCIATES**
F - 623a, LADO SARAI, BEHIND CNG STATION
NEW DELHI - 110030
Ph: 011-40583839, 098711911853
Email: behera.associates@gmail.com

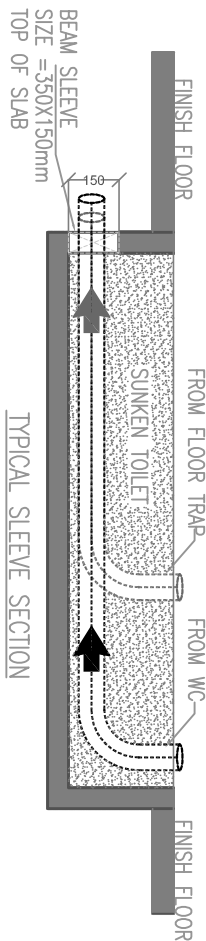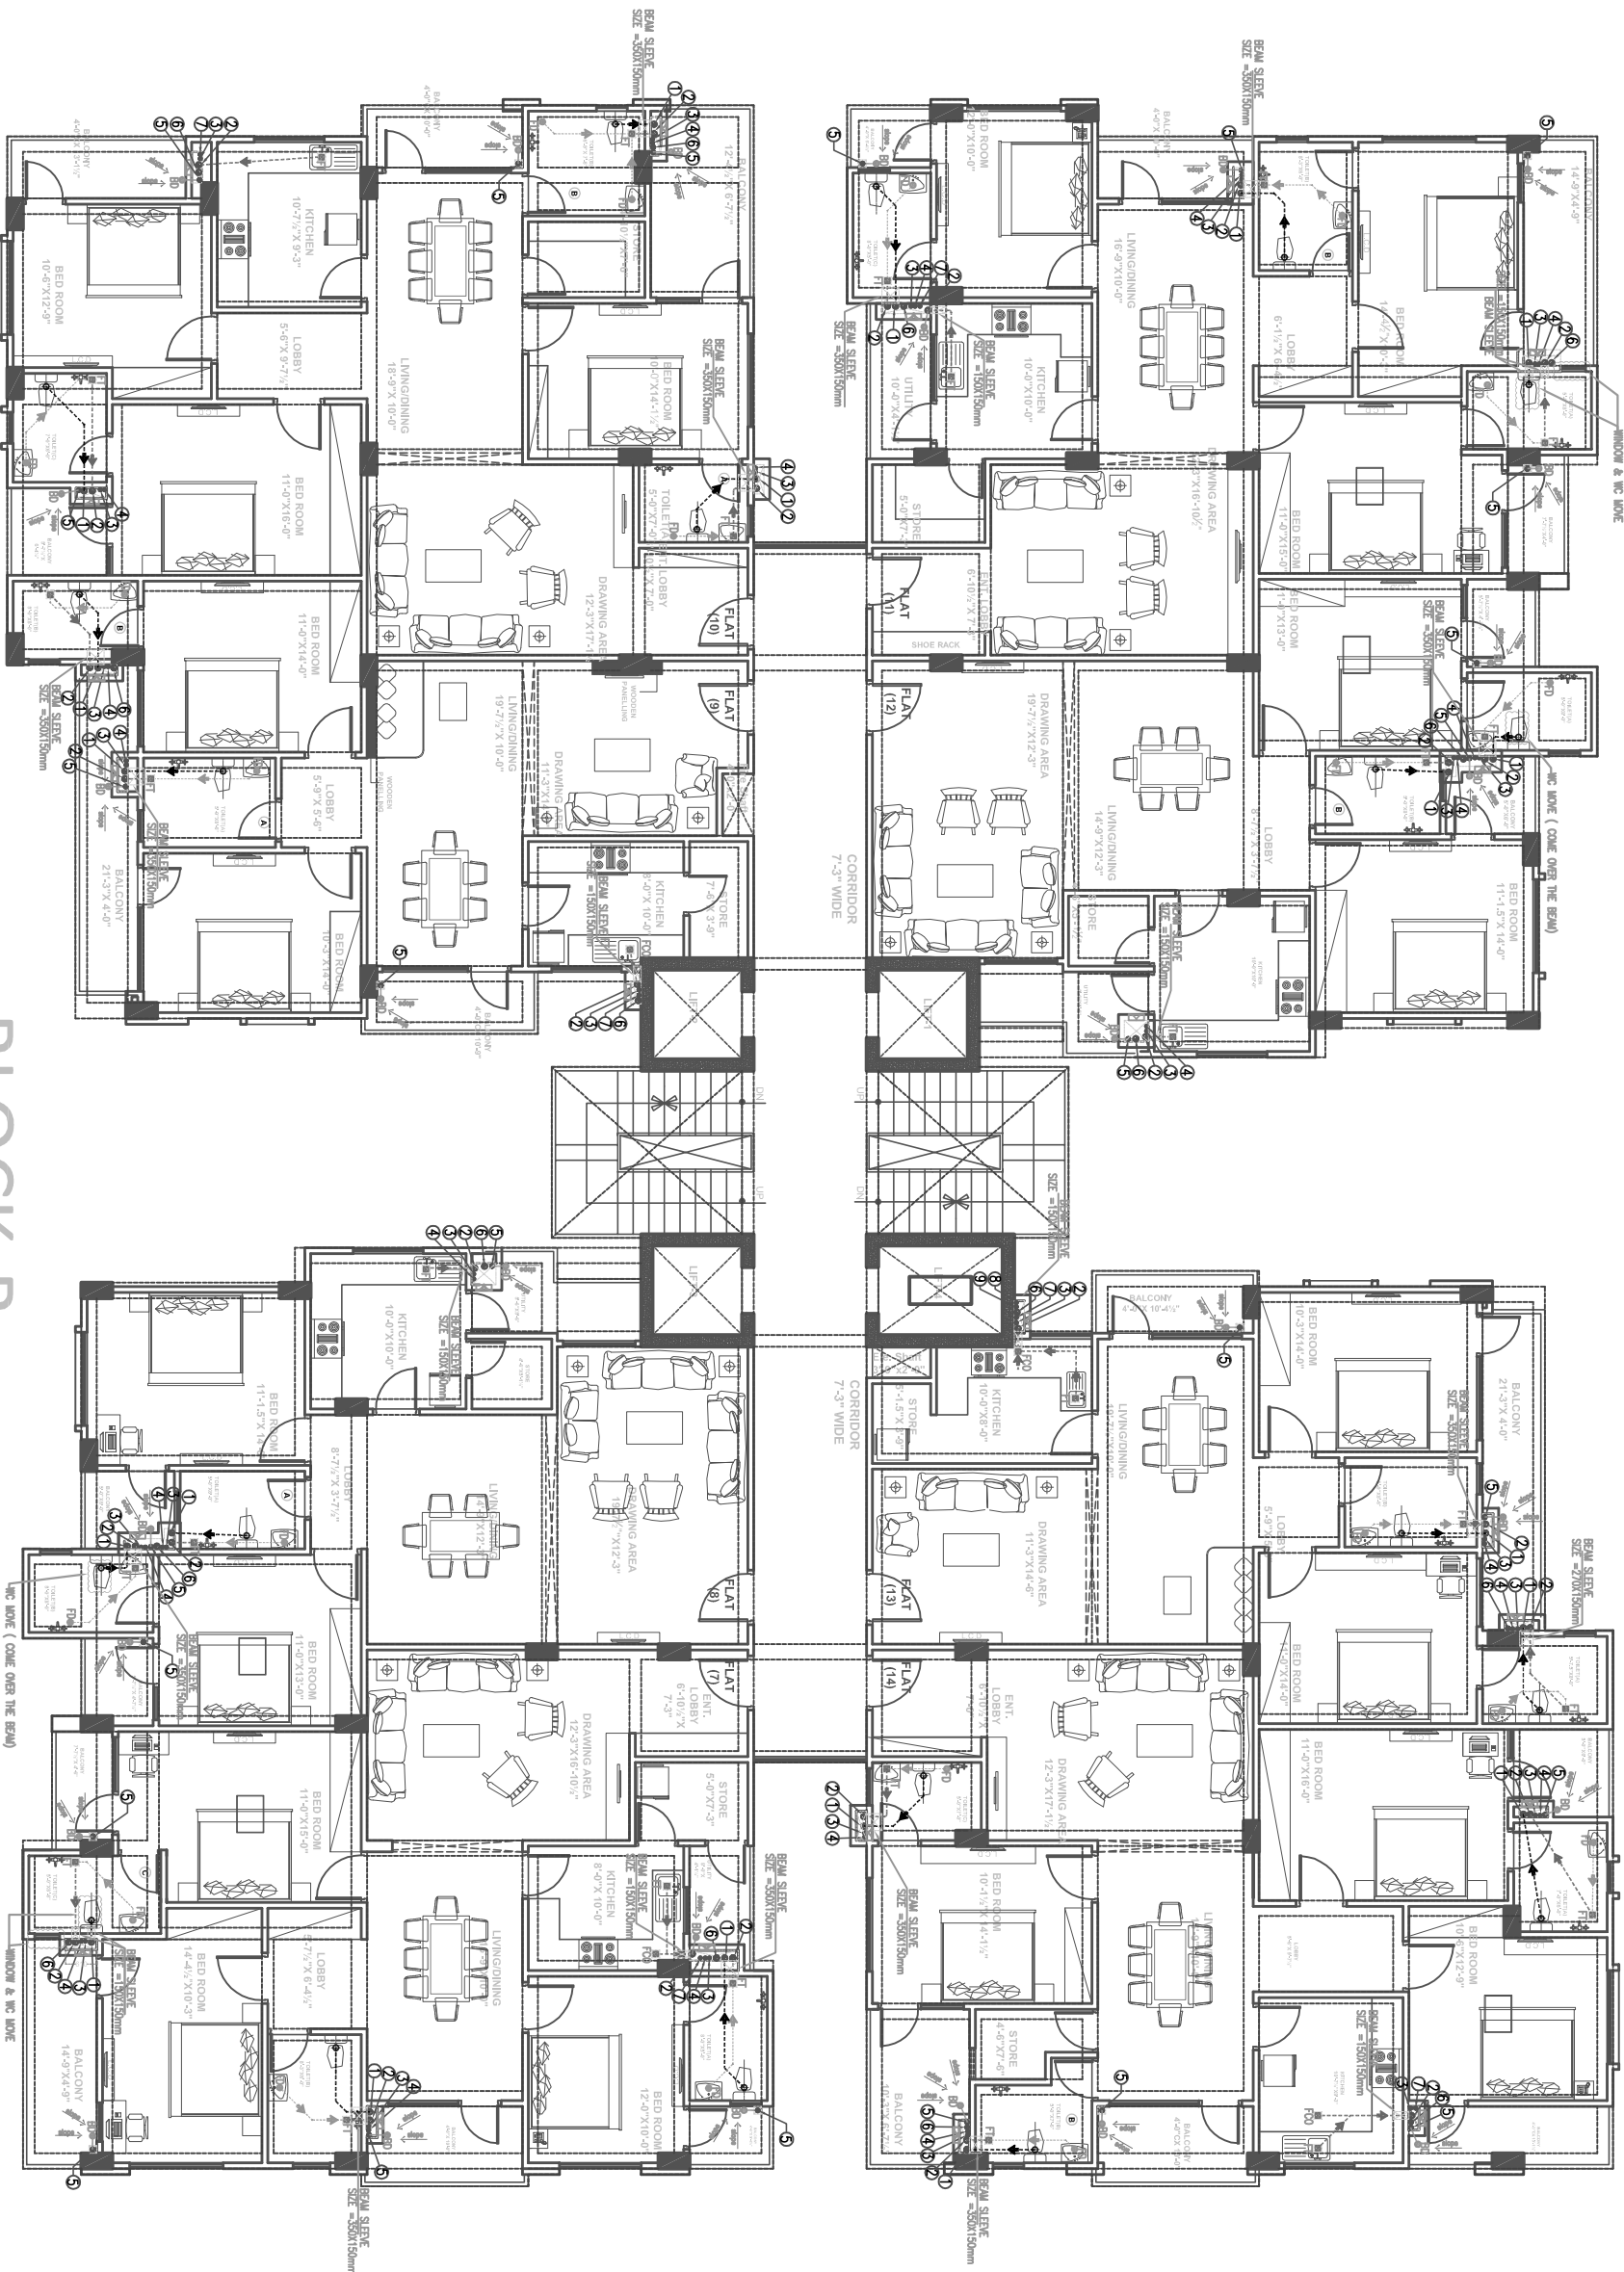

PROJECT

SHREE ENCLAVE
NIWARU ROAD, JAIPUR.



SNG
GROUP
Builder & Developer

PLUMBING NOTES:-

- FLOOR DRAIN (FD) TO FLOOR TRAP (FT) 63 OD uPVC WASTE PIPE.
- FLOOR TRAP (FT) TO VERTICAL PIPE 110 OD uPVC
- 110 OD uPVC PIPE USED FOR SOIL & WASTE.
- 110 OD uPVC PIPE USED FOR TERRACE RAIN WATER
- 90 OD uPVC PIPE USED FOR BALCONY.

SCHEDULE OF PIPES

PIPE NO.	DESCRIPTION
①	110 OD uPVC SOIL
②	110 OD uPVC WASTE
③	DOMESTIC WATER SUPPLY D/N TAKE PIPE *
④	FLUSHING WATER SUPPLY D/N TAKE PIPE *
⑤	90 OD uPVC RAIN WATER PIPE FOR BALCONY
⑥	110 OD uPVC RAIN WATER PIPE FOR TERRACE
⑦	HOT WATER SUPPLY D/N TAKE PIPE ONLY FOR KITCHAN * (SOLAR)
⑧	DOMESTIC WATER SUPPLY RISER PIPE *
⑨	FLUSHING WATER SUPPLY RISER PIPE *

DRG. TITLE
TYPICAL FLOOR PLAN
1st TO 10th FLOOR
PLUMBING LAYOUT

FILE PATH

--/-/-/--

DATE	SCALE	DRG.NO.
30-09-13	N.T.S.	PL/S-A/CR/13/88
DRAWN BY	CHECKED BY	NORTH
M.SINGH	SOMNATH	

- RELEASED FOR
- ☐ TENDER
- ☐ INFORMATION
- ☐ APPROVAL
- ☒ CONSTRUCTION

OWNER

PARTH INFRATECH PVT.Ltd.
707, SEVENTH FLOOR
PARB HOUT
BANI PARK, JAIPUR

ARCHITECT


CREATION
CONS. ARCH. & CONST ENGINEER PVT.LTD
SUPPORTED BY SNG GROUP
creation.creation@gmail.com

SERVICE CONSULTANT

SRAJAN ASSOCIATES
C. SICHEM, JAIPUR
srajan@bnpmail.com


PLUMBING CONSULTANTS:

**BEHERA & ASSOCIATES**
F - 623a, LADO SARAI, BEHIND CNG STATION
NEW DELHI - 110030
Ph: 011-40583839, 09811911853
Email: behera.associates@gmail.com

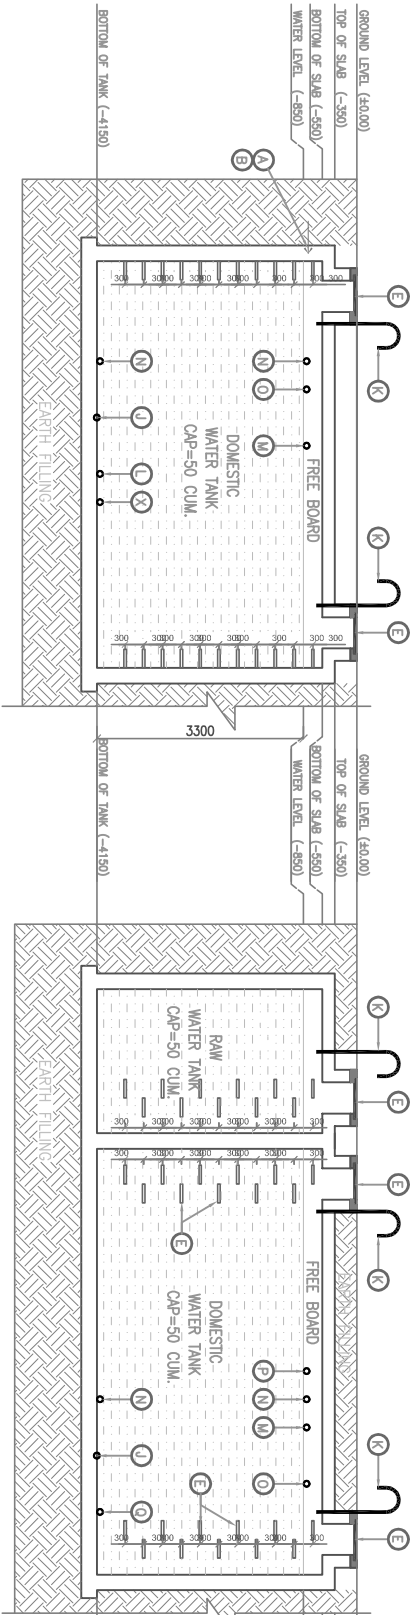

UNDER ROUND WATER TANK SECTION = (Z-Z)



UNDER ROUND WATER TANK SECTION = (Y-Y)

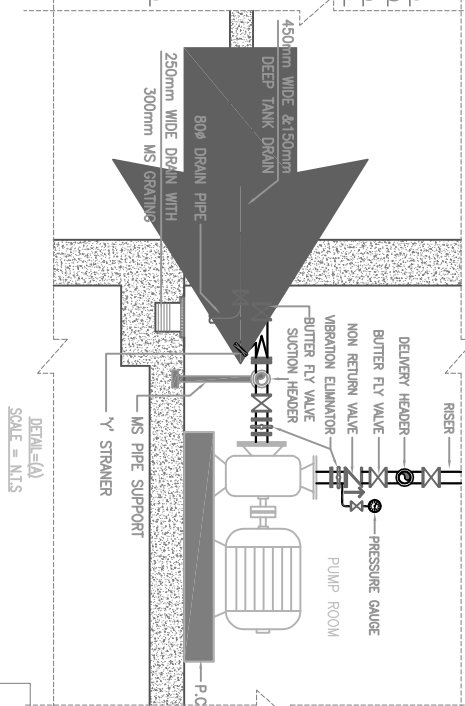




DETAIL-A
SCALE = N.T.S

WATER SUPPLY PUMPS:-	
P1	RAW WATER TRANSFER PUMP. 2 NOS. (1 WORKING + 1 STAND BY)
P2	DOMESTIC WATER TRANSFER PUMP 2 NOS. (1 WORKING + 1 STAND BY)
P3	GARDEN HYDRANT PUMPS PUMP 2 NOS. (1 WORKING + 1 STAND BY)
CH	CHLORINATOR.
M	BUTTER FLY VALVE
N	NON RETURN VALVE (NRV)

LEGENDS:-				
SYMBOL	DESCRIPTION	DN OF PIPE	PIPE LOCATION	BOTTOM OF SLAB
A	INLET CONNECTION FROM CITY WATER.	800	UPPER LEVEL.	-800
B	INLET CONNECTION FROM TUBE WELL.	1000	UPPER LEVEL.	-800
C	PIPE BRIDGE MINIMUM CONNECTION.	---	---	---
D	MANHOLE COVER.	5000	TOP OF SLAB	---
E	FOOT REST.	Ø 300mm/C	---	---
F	TANK TO OVER FLOW.	---	---	---
G	DRAIN PIPE.	800	LOWER LEVEL.	-4300
H	VENT PIPE.	1000	TOP OF SLAB	---
I	SECTION PIPE FOR RAW WATER PUMPS.	1000	LOWER LEVEL.	-4150
J	OVER FLOW PIPE.	500	UPPER LEVEL.	-800
K	LEVEL INDICATOR.	250	UPPER & LOWER	-800/-4150
L	LEVEL CONTROLLER.	250	UPPER LEVEL.	-800
M	DOMESTIC WATER INLET CONNECTION.	1000	UPPER LEVEL.	-800
N	SECTION PIPE FOR DOMESTIC WATER PUMPS.	1000	LOWER LEVEL.	-4150
O	SECTION PIPE FOR GARDEN HYDRANT PUMPS.	1000	LOWER LEVEL.	-4150

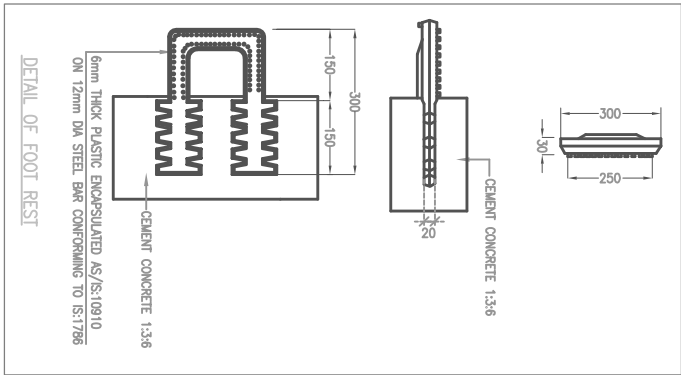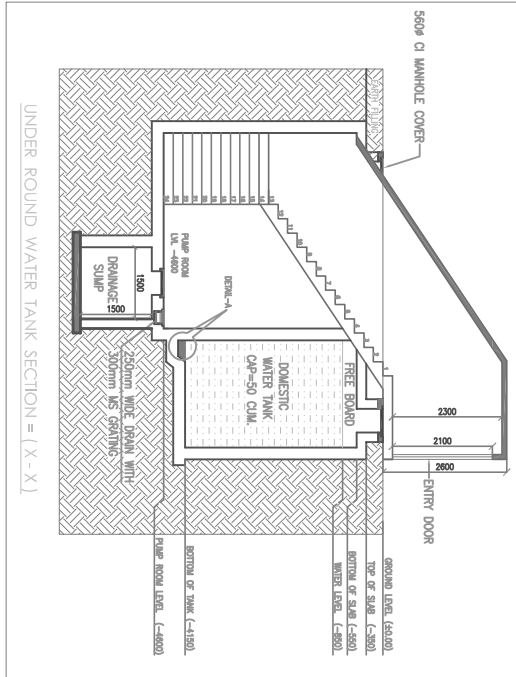

SUMP WITH 2 NOS. SUBMERSIBLE PUMP (1 WORKING+1 STAND BY)
SIZE-(1.5mx1.5mx1.8m)

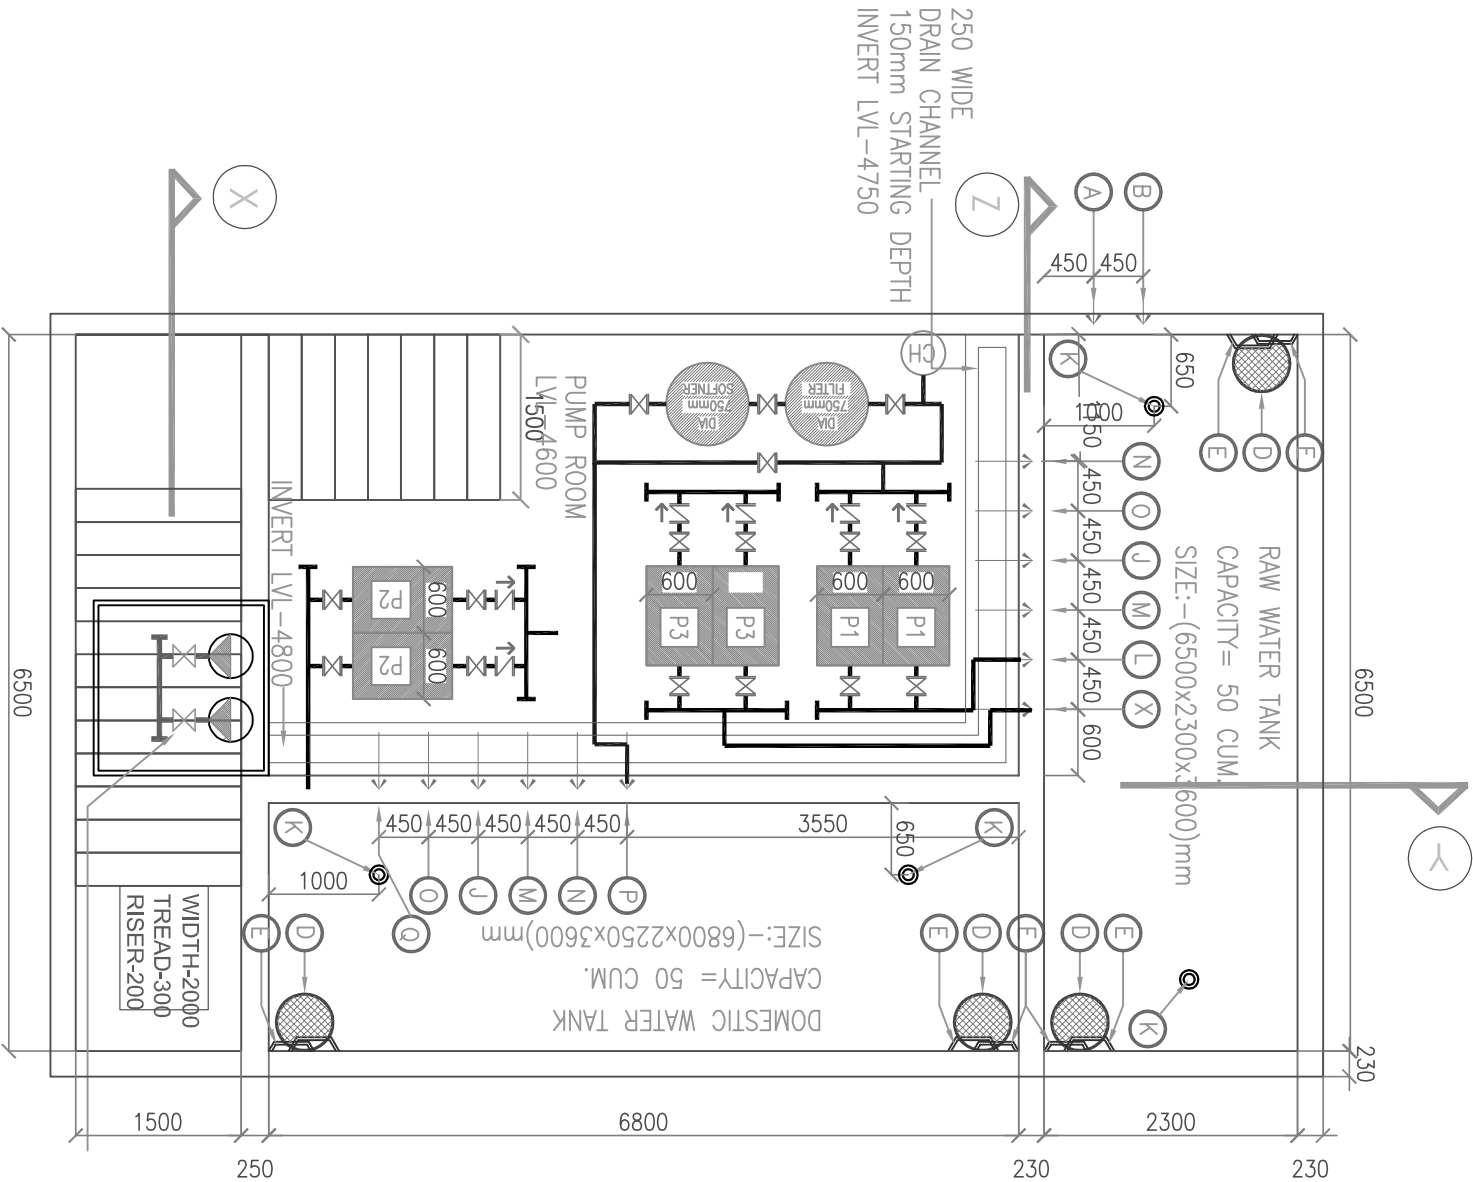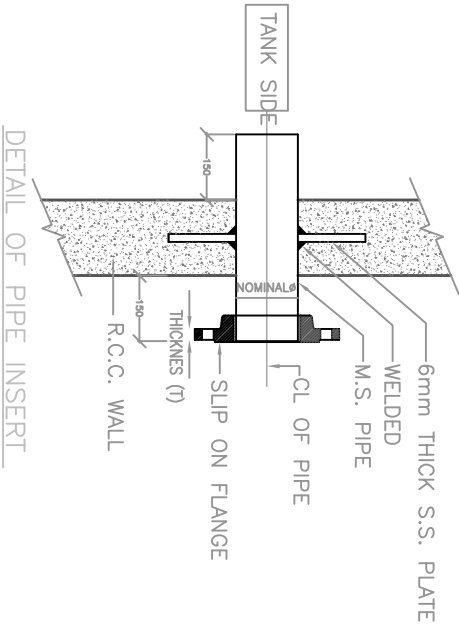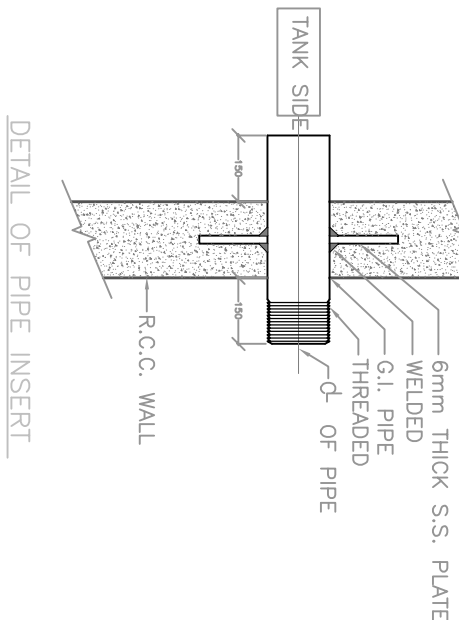

OWNER
SNG REAL ESTATE PVT. LTD.
707, SEVENTH FLOOR
PARIS POINT
BANIPARK, JAIPUR

ARCHITECT
CREATION
CONS. ARCH. & CONST. ENGINEER PVT. LTD
SUPPORTED BY SNG GROUP
creation.aryshahpalm@gmail.com

PRIME CONSULTANT
SRAJAN ASSOCIATES
C.SCHEME, JAIPUR
srajanbpu@hotmail.com

ASSOCIATES PLUMBING CONSULTANTS:
BEHERA & ASSOCIATES
F - 623a, LADO SARAI, BEHIND CNG STATION
NEW DELHI - 110030
Ph: 011-40583839, 09811911853
Email: behera.associates@gmail.com

DRG. TITLE
UNDER GROUND WATER TANK
DETAIL LAYOUT

FILE PATH
--/--/--

DATE
12-01-2015
SCALE
NTS

DRAWN BY
M.SINGH
CHECKED BY
SOMNATH

RELEASED FOR
TENDER
INFORMATION
CONSTRUCTION