


RAIN WATER LINE

MAIN SEWER LINE

EXT ROAD 60'-0" WIDE

70' [21.34]

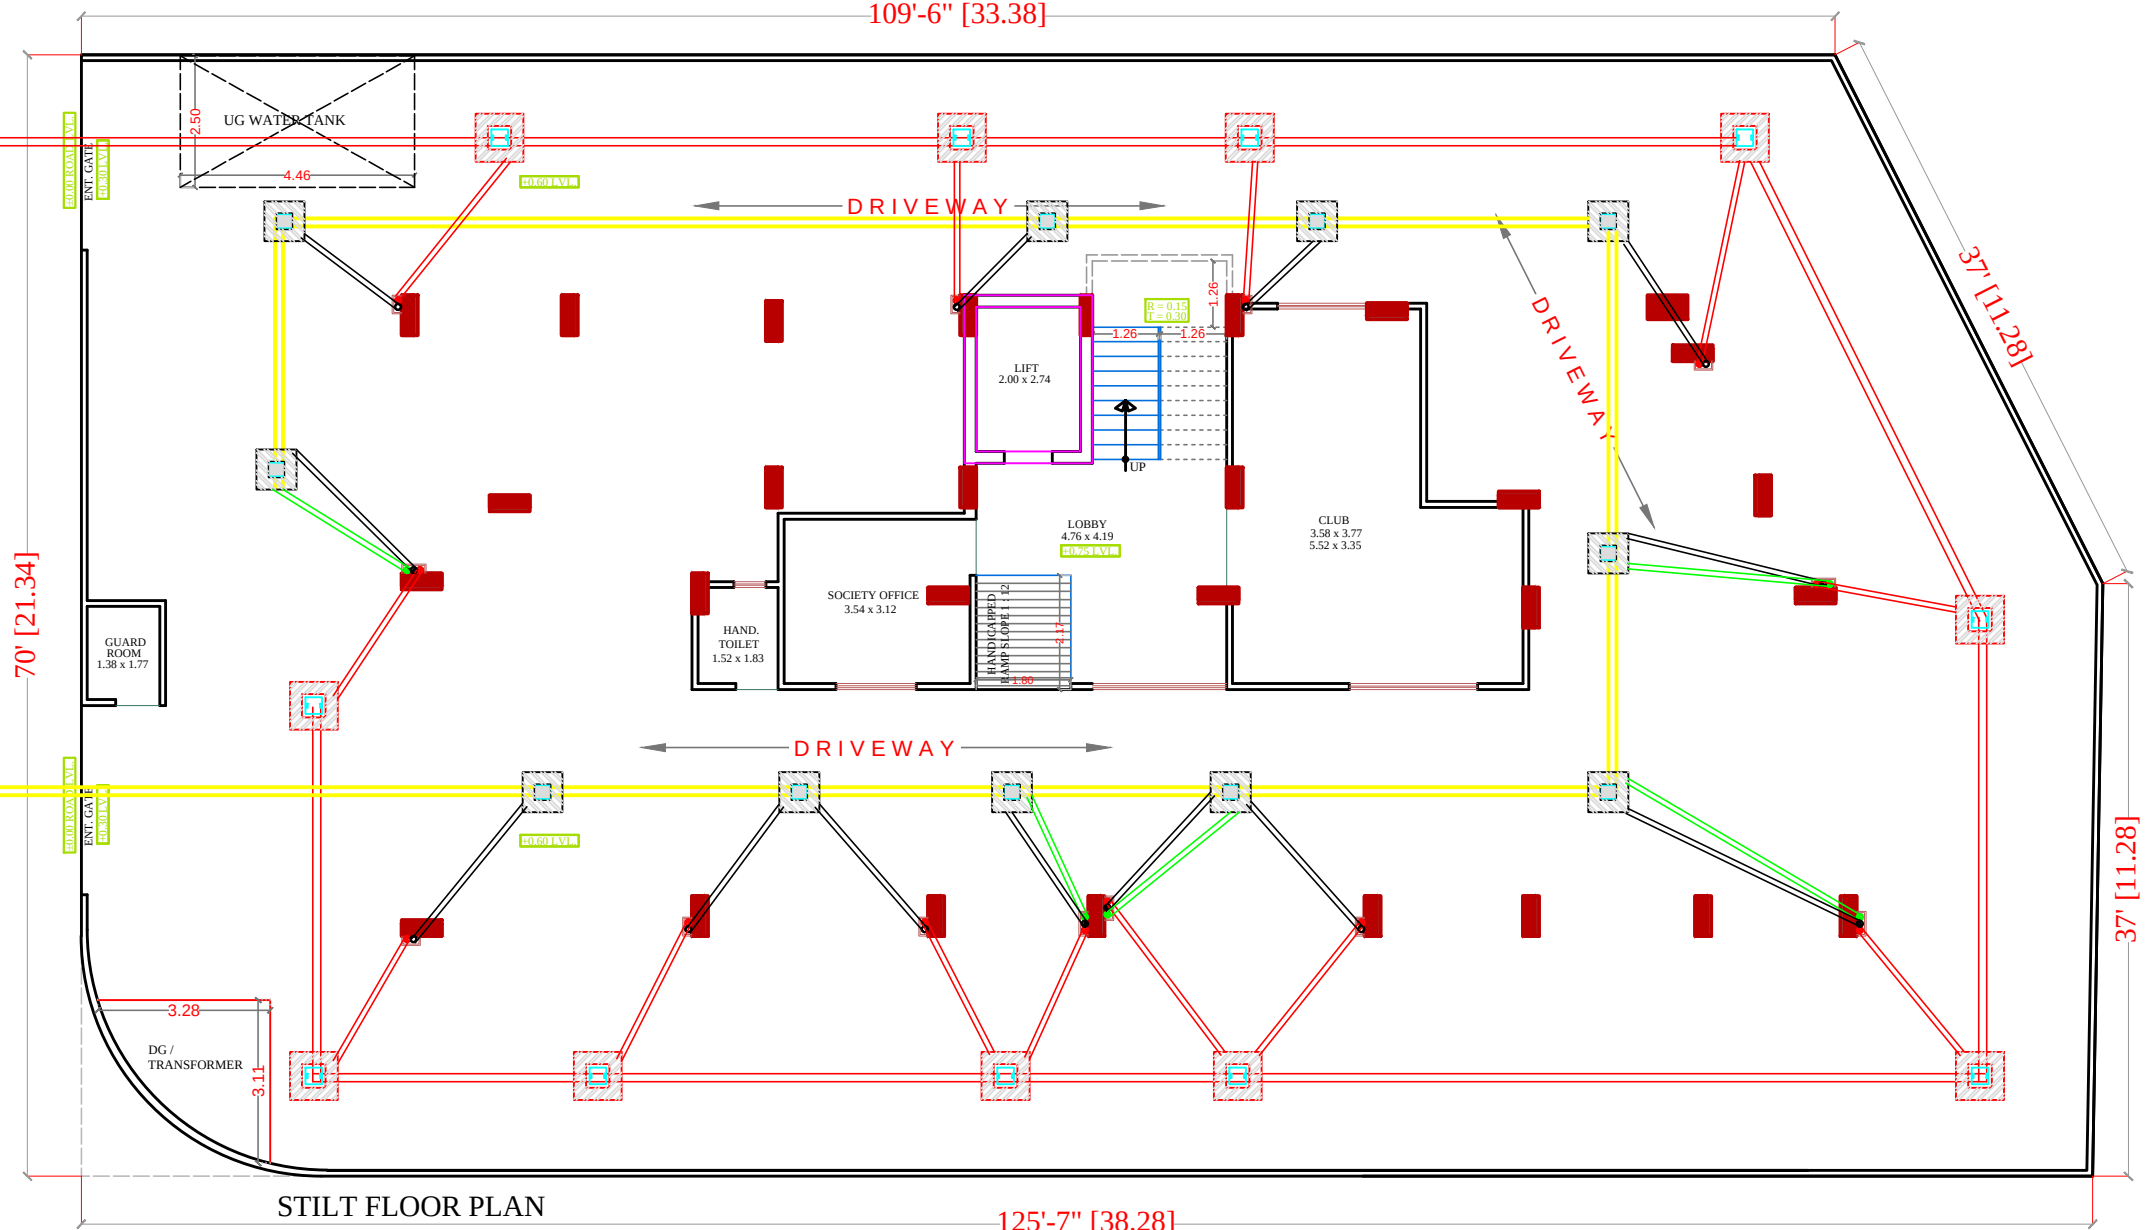

STILT FLOOR PLAN

125'-7" [38.28]

ROAD 40'-0" WIDE

37' [11.28]

37' [11.28]

RAMESH KUMAWAT
M.E.P. CONSULTANT
B.E. CIVIL

SYMBOL	DESCRIPTION
	Ø 110 mm Soil Waste Water Pipe
	Ø 110 mm Waste Water Pipe
	Ø 110 mm Rain Water Pipe
	Ø 160 mm Rain Water Pipe Slope 1:200
	Ø 110 mm Rain Water Pipe Slope 1:200
	RC-12"X12" Depth According to Slope
	RC-18"X18" Depth According to Slope
	RC-24"X24" Depth According to Slope
	Flow Direction

PROJECT TITLE :-

PROPOSED BUILDING AT PLOT NO- A-231,
A-232 & A-233, SHREE RAM NIKUNG-A,
VILLAGE:- RAMPURA URF
KANWERPURA TEH.-SANGANER, JAIPUR

DRAWING TITLE :-

STILT FLOOR
COMMON AREA RAIN
WATER SUPPLY

SPACE CONSULTANT

PLOT-A-173, JAGDAMBA NAGAR, HEERAPURA
POWER HOWER, JAIPUR (RAJ) 302024

DRN. BY

APPD. BY

SCALE

N.T.S

DATE

REVISION

NORTH

