

MUMTY LEVEL

TERRACE FLOOR PLAN

10th FLOOR PLAN

9th FLOOR PLAN

8th FLOOR PLAN

7th FLOOR PLAN

6th FLOOR PLAN

5th FLOOR PLAN

4th FLOOR PLAN

3rd FLOOR PLAN

2nd FLOOR PLAN

1st FLOOR PLAN

MEZZANINE FLOOR PLAN

STILT FLOOR PLAN

UPPER BASEMENT FLOOR PLAN


LOWER BASEMENT FLOOR PLAN

FIRE FIGHTING PUMP DETAILS:-


S.NO.	DESCRIPTION	PUMP & EQUIPMENT IDENTIFICATION NO.	CAPACITY OF PUMP	HEAD OF PUMP	QTY.
01.	DIESEL DRIVEN FIRE PUMP	F-1	2280	90M HEAD	1NO.
02.	ELECTRICAL DRIVEN MAIN HYDRANT PUMP	F-2	2280	90M HEAD	1NO.
03.	ELECTRICAL JOCKEY PUMP	F-3	180	90M HEAD	1NO.
04.	PRESSURE VEESEL	PV			

LEGEND:-


	BUTTERFLY VALVE		STRAINER
	PENDENT TYPE SPRINKLER		AUXILIARY DRAIN VALVE
	FIRST AID FIRE HOSE REEL 36.5 LENGHT x 20 MM Ø		SIGHT GLASS
	1 NOS. SINGLE OUTLET LANDING VALVE		AIR RELEASE VALVE
	INSTALATION CONTROL VALVE		NON RETURN VALVE
	PRESSURE GAUGE		VIBRATION ISOLATORS
			PRESSURE GAUGE
			FLOW INDICATION SWITCH

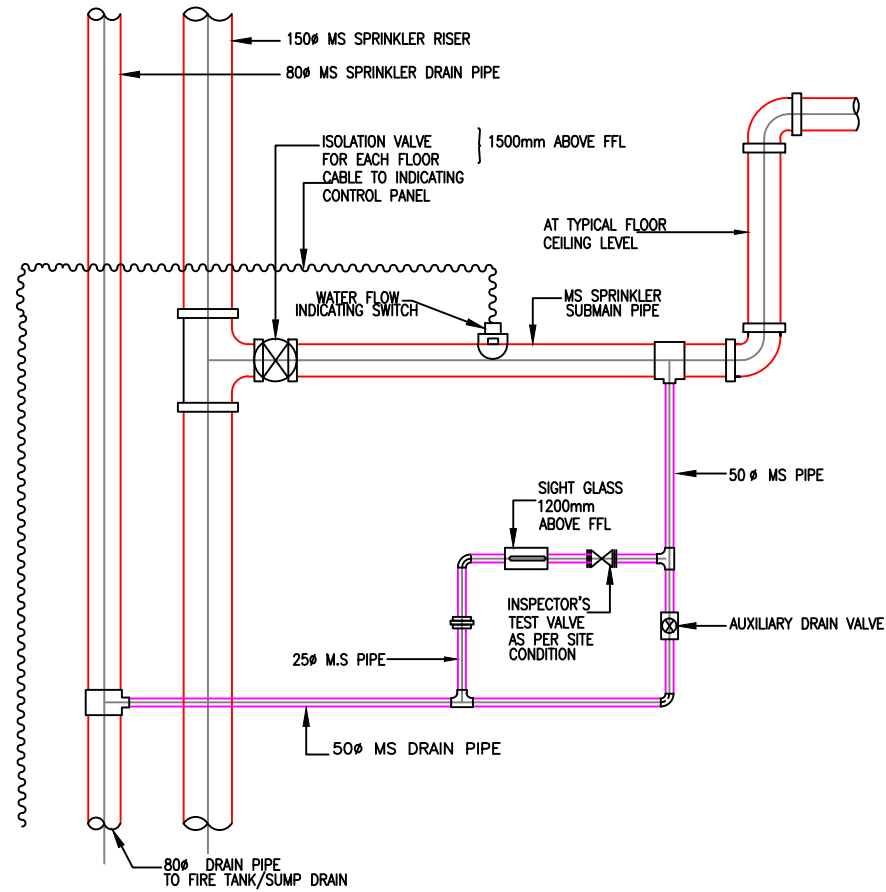

INSPECTION, TESTING & DRAIN ASSEMBLY DETAIL

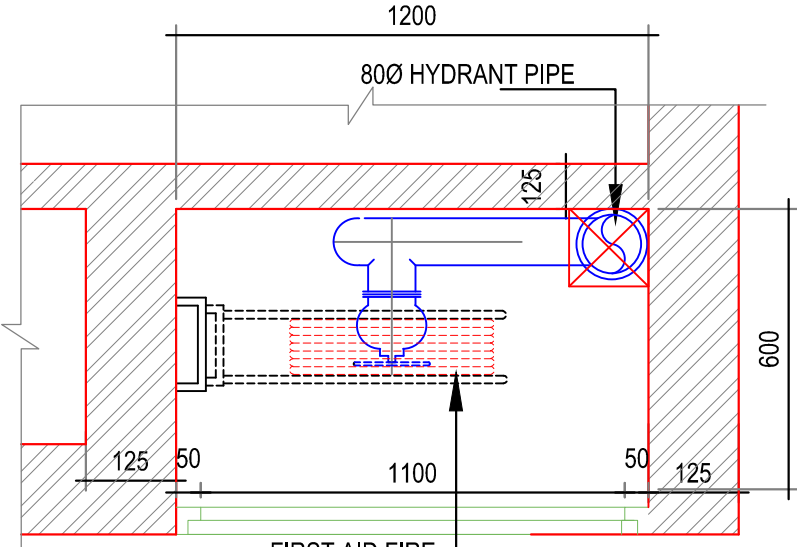

[PLAN]

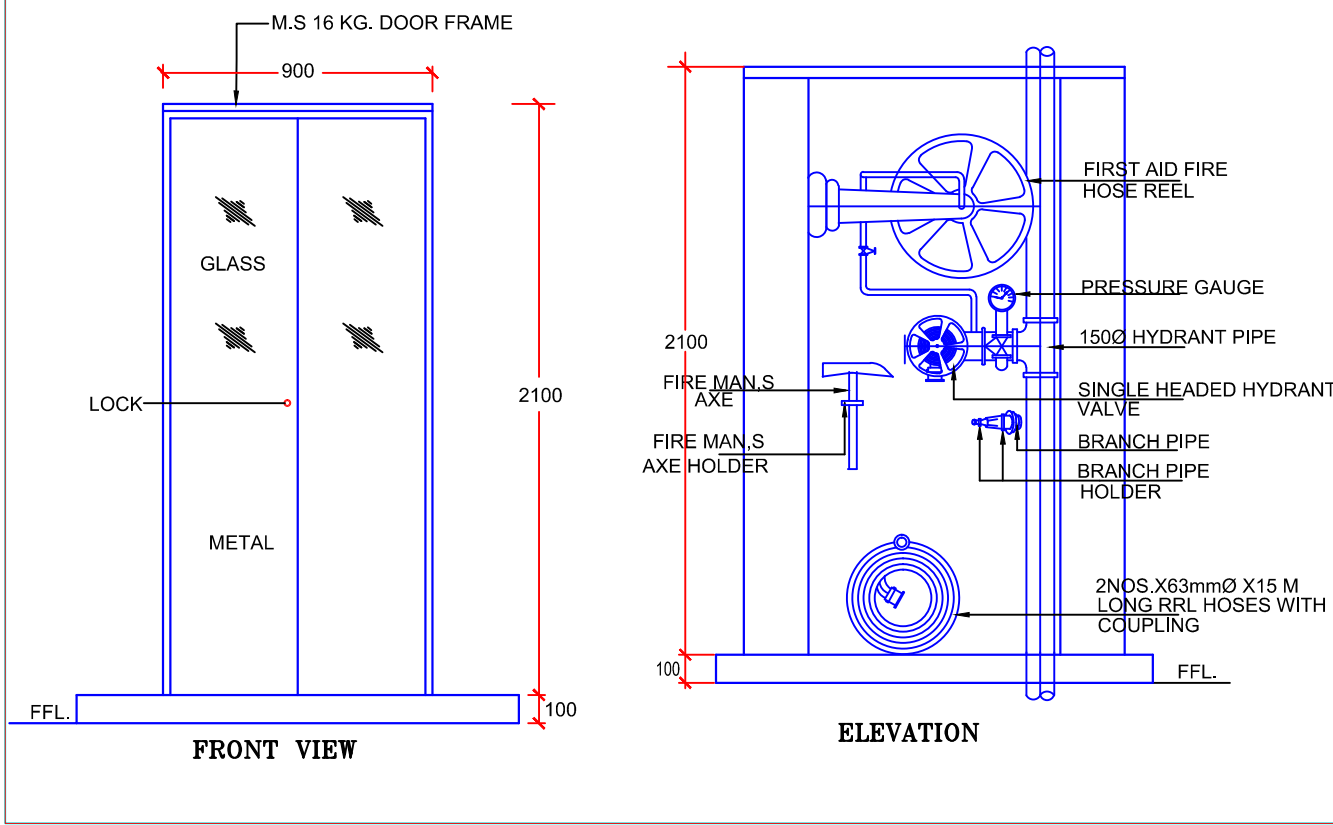

FOR APPROVAL

PROJECT

BANI PARK


ARCHITECTS:

Malhotra & Associates

Architects - Engineers - Interiors Designers

1Ind floor,
C-86B, Nand Kishor Pareek Marg
J.L.N. Marg, Bapu Nagar, Jaipur
Ph: 0141-2700661, 2706431
email:ashokar_malhotra@yahoo.com

PLUMBING & FIRE FIGHTING CONSULTANTS

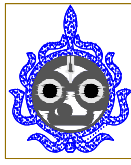

BEHERA & ASSOCIATES
F-623a, LADO SARAI BEHIND CNG FILLING STATION
NEW DELHI - 110030
PH:- 011-40583898
MOB:- 9811911853
EMAIL:-behera.associates@gmail.com

DRAWING TITLE :

FIRE FIGHTING LAYOUT
SCHEMATIC DIAGRAM

SCALE : 1:100 @ A1

DRAWN BY : DEEPAK

DATE : 19-05-17

CHECKED BY: B.SINGH

PROJECT NO :

APPROVED BY : S.BEHERA

DRAWING NO :

PL / BA /109

REVISION

0

DIRECTION

NORTH