


FOR RERA

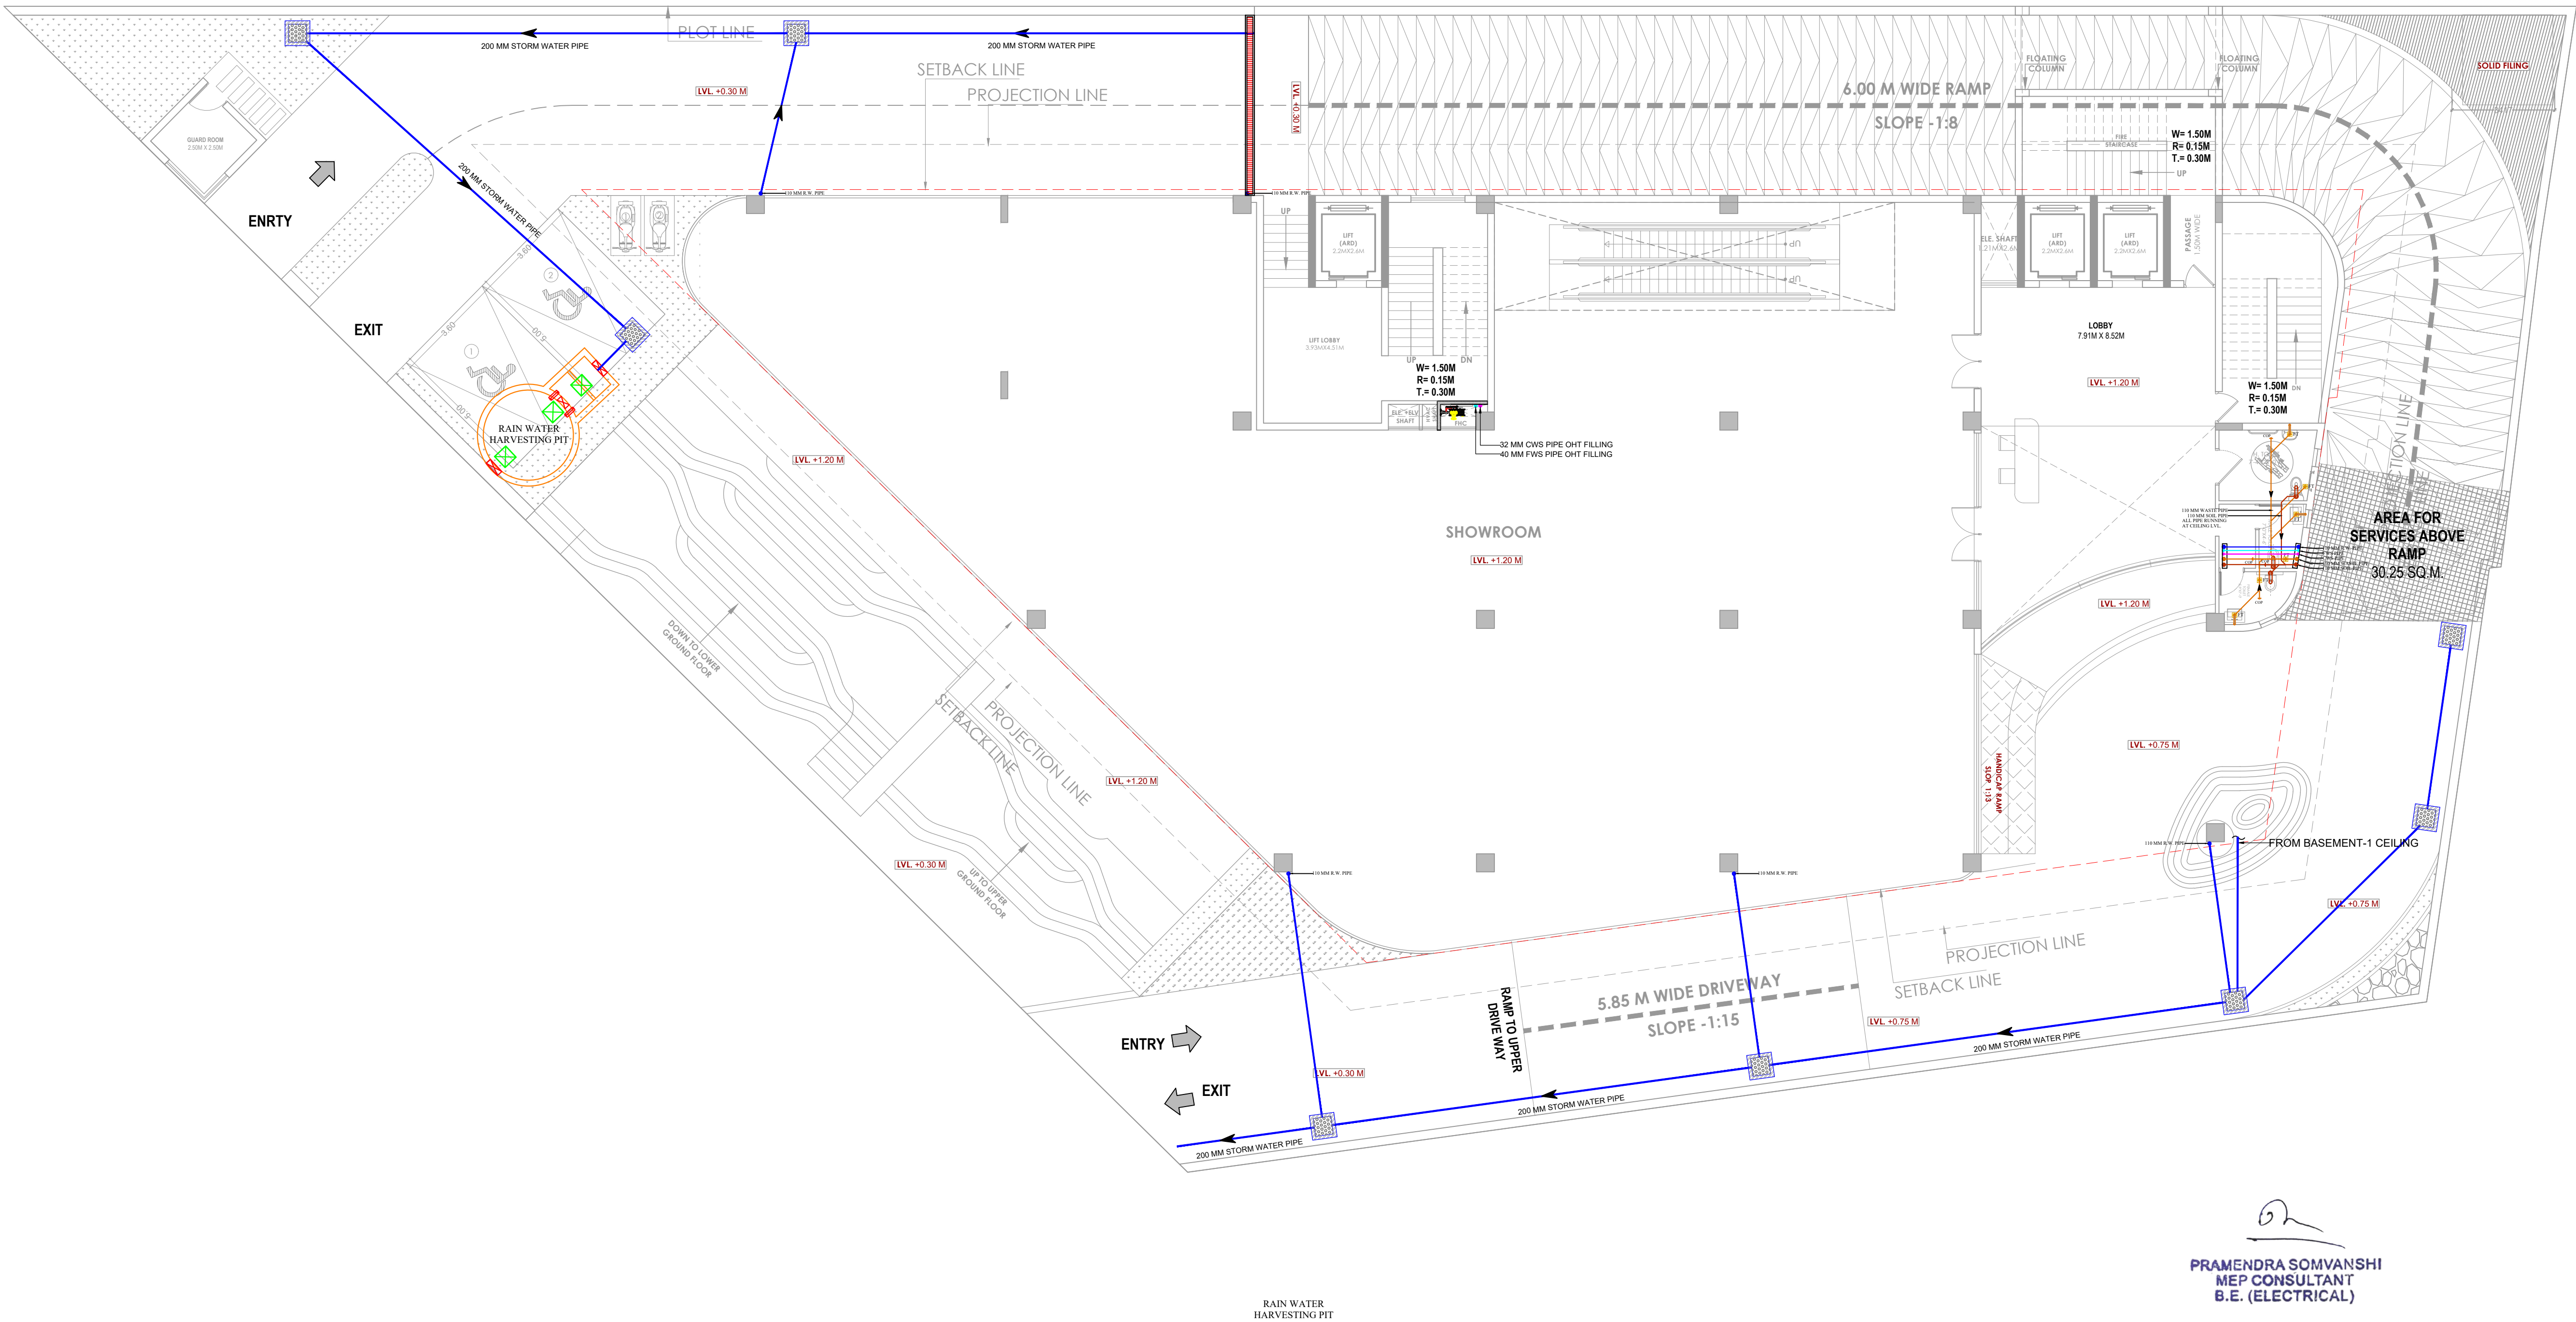

GROUND FLOOR DRAINAGE LAYOUT

LEGEND:-

SOIL PIPE (UPVC-6kg B-Type)		
WASTE PIPE (UPVC-6kg B-Type)		
RAIN PIPE (UPVC-6kg B-Type)		
COLD WATER SUPPLY (CWS) (CPVC -SDR-11)		
FLUSHING WATER SUPPLY (FWS) (CPVC -SDR-11)		
EXTERNAL RAIN WATER PIPE (UPVC-6kg B-Type)		
SEWER LINE- EXTERNAL (DWC-SN-8)		
SEWERAGE MANHOLE 600 X 600 MM		
STORM WATER MANHOLE		
KHURRA		
GULLY TRAP		
110 MM (P-TRAP) FLOOR TRAP (FT)		
BALL VALVE		
NRV		

FOR RERA			
MEPCO ENGINEERS			
207, Vishveshvaraiya Nagar Ext., Gopal Pura Bye Pass, Jaipur-302018 MAIL:- info@mepcoengineers.com Mob. No. +91-8426901595			
DRAWN BY :-	CHECKED BY :-	REVISION :-	DATE :-
RAMESH	PRAMENDRA	R-0	04-08-2025
DRAWING TITLE			
GROUND FLOOR DRAINAGE LAYOUT			
PROJECT TITLE:-			
PROPOSED COMMERCIAL BUILDING AT PLOT NO. 2, 3 & 4, SCHEME NO.1, PRITHVIRAJ NAGAR, AT REVENUE VILLAGE:-MANGYAWAS, TEH. SANGANER, DIST. JAIPUR, RAJASTHAN.			

STUDIO SAARTH
ARCHITECTURE / URBAN DESIGNER

A:C -424 KING'S ROAD .NIRMAN NAGAR
JAIPUR - 302019 , RAJASTHAN

SCALE 1:100	NORTH POINT
DATE :- 19.05.2025	

AR. PUNEET DUA CA/2005/35530	
ARCHITECT	