

PLUMBING LEGEND:-

	2500 S.W PIPE
	1500 S.W PIPE
	SEWER WATER MANHOLE
	SEWER WATER MANHOLE
	2500 S.W PIPE FOR SEWER LINE SLOPE 1:200
	2000 S.W PIPE FOR SEWER LINE SLOPE 1:150

PLUMBING NOTE FOR SEWER WATER :-

DIA OF M.H	DEPTH OF MH
910mm Dia	900 TO 1650
1220mm Dia	1650 TO 2300
1520mm Dia	2300 & ABOVE
PLUMBING NOTE FOR SEWER WATER :-	
MANHOLE SIZE (MM)	DEPTH OF MH (MM)
MH - 900 X 900 mm	750 TO 1000 mm
MH - 1200 X 900 mm	1000 mm & ABOVE




C.L	GROUND LEVEL
I.L	INVERT LEVEL
C.L	CONNECTION LEVEL

PRODUCED BY AN AUTODESK EDUCATIONAL PRODUCT



NOTES:
1. DIMENSIONS SHALL BE GIVEN IN METERS UNLESS OTHERWISE SPECIFIED.
2. ALL DIMENSIONS ARE IN MILLIMETERS UNLESS OTHERWISE SPECIFIED.
3. THE DRAWING SHALL BE USED IN CONJUNCTION WITH OTHER RELEVANT DRAWINGS.
4. ANY DISCREPANCY IN DIMENSIONS SHALL BE REPORTED TO THE ARCHITECT IMMEDIATELY.
5. ALL THE LEVELS ARE SHOWN IN METERS.

DATE	REV. NO.	DESCRIPTION
REVISIONS		
PREP BY	DRAWN BY	APPROVED BY
InGenious Studio Pvt. Ltd.		
155-155, FIRST FLOOR, SPACE+TECH PARK, SONNA ROAD, GURGAON		
Tel./Email : +91-124-4263861, info@ingeniousstudio.in		
CLIENT	GRASS FIELD FIRE CAPITAL DEVELOPERS PVT. LTD.	
PROJECT TITLE	INDIOTY (A MASTERPLANNED WORLD)	
DRAWING TITLE	PLUMBING DRAWING SEWERAGE LAYOUT	
SCALE	AS SHOWN	DATE
PROJECT NO.	PL - SITE - BA-302	DATE
DATE	DATE	DATE

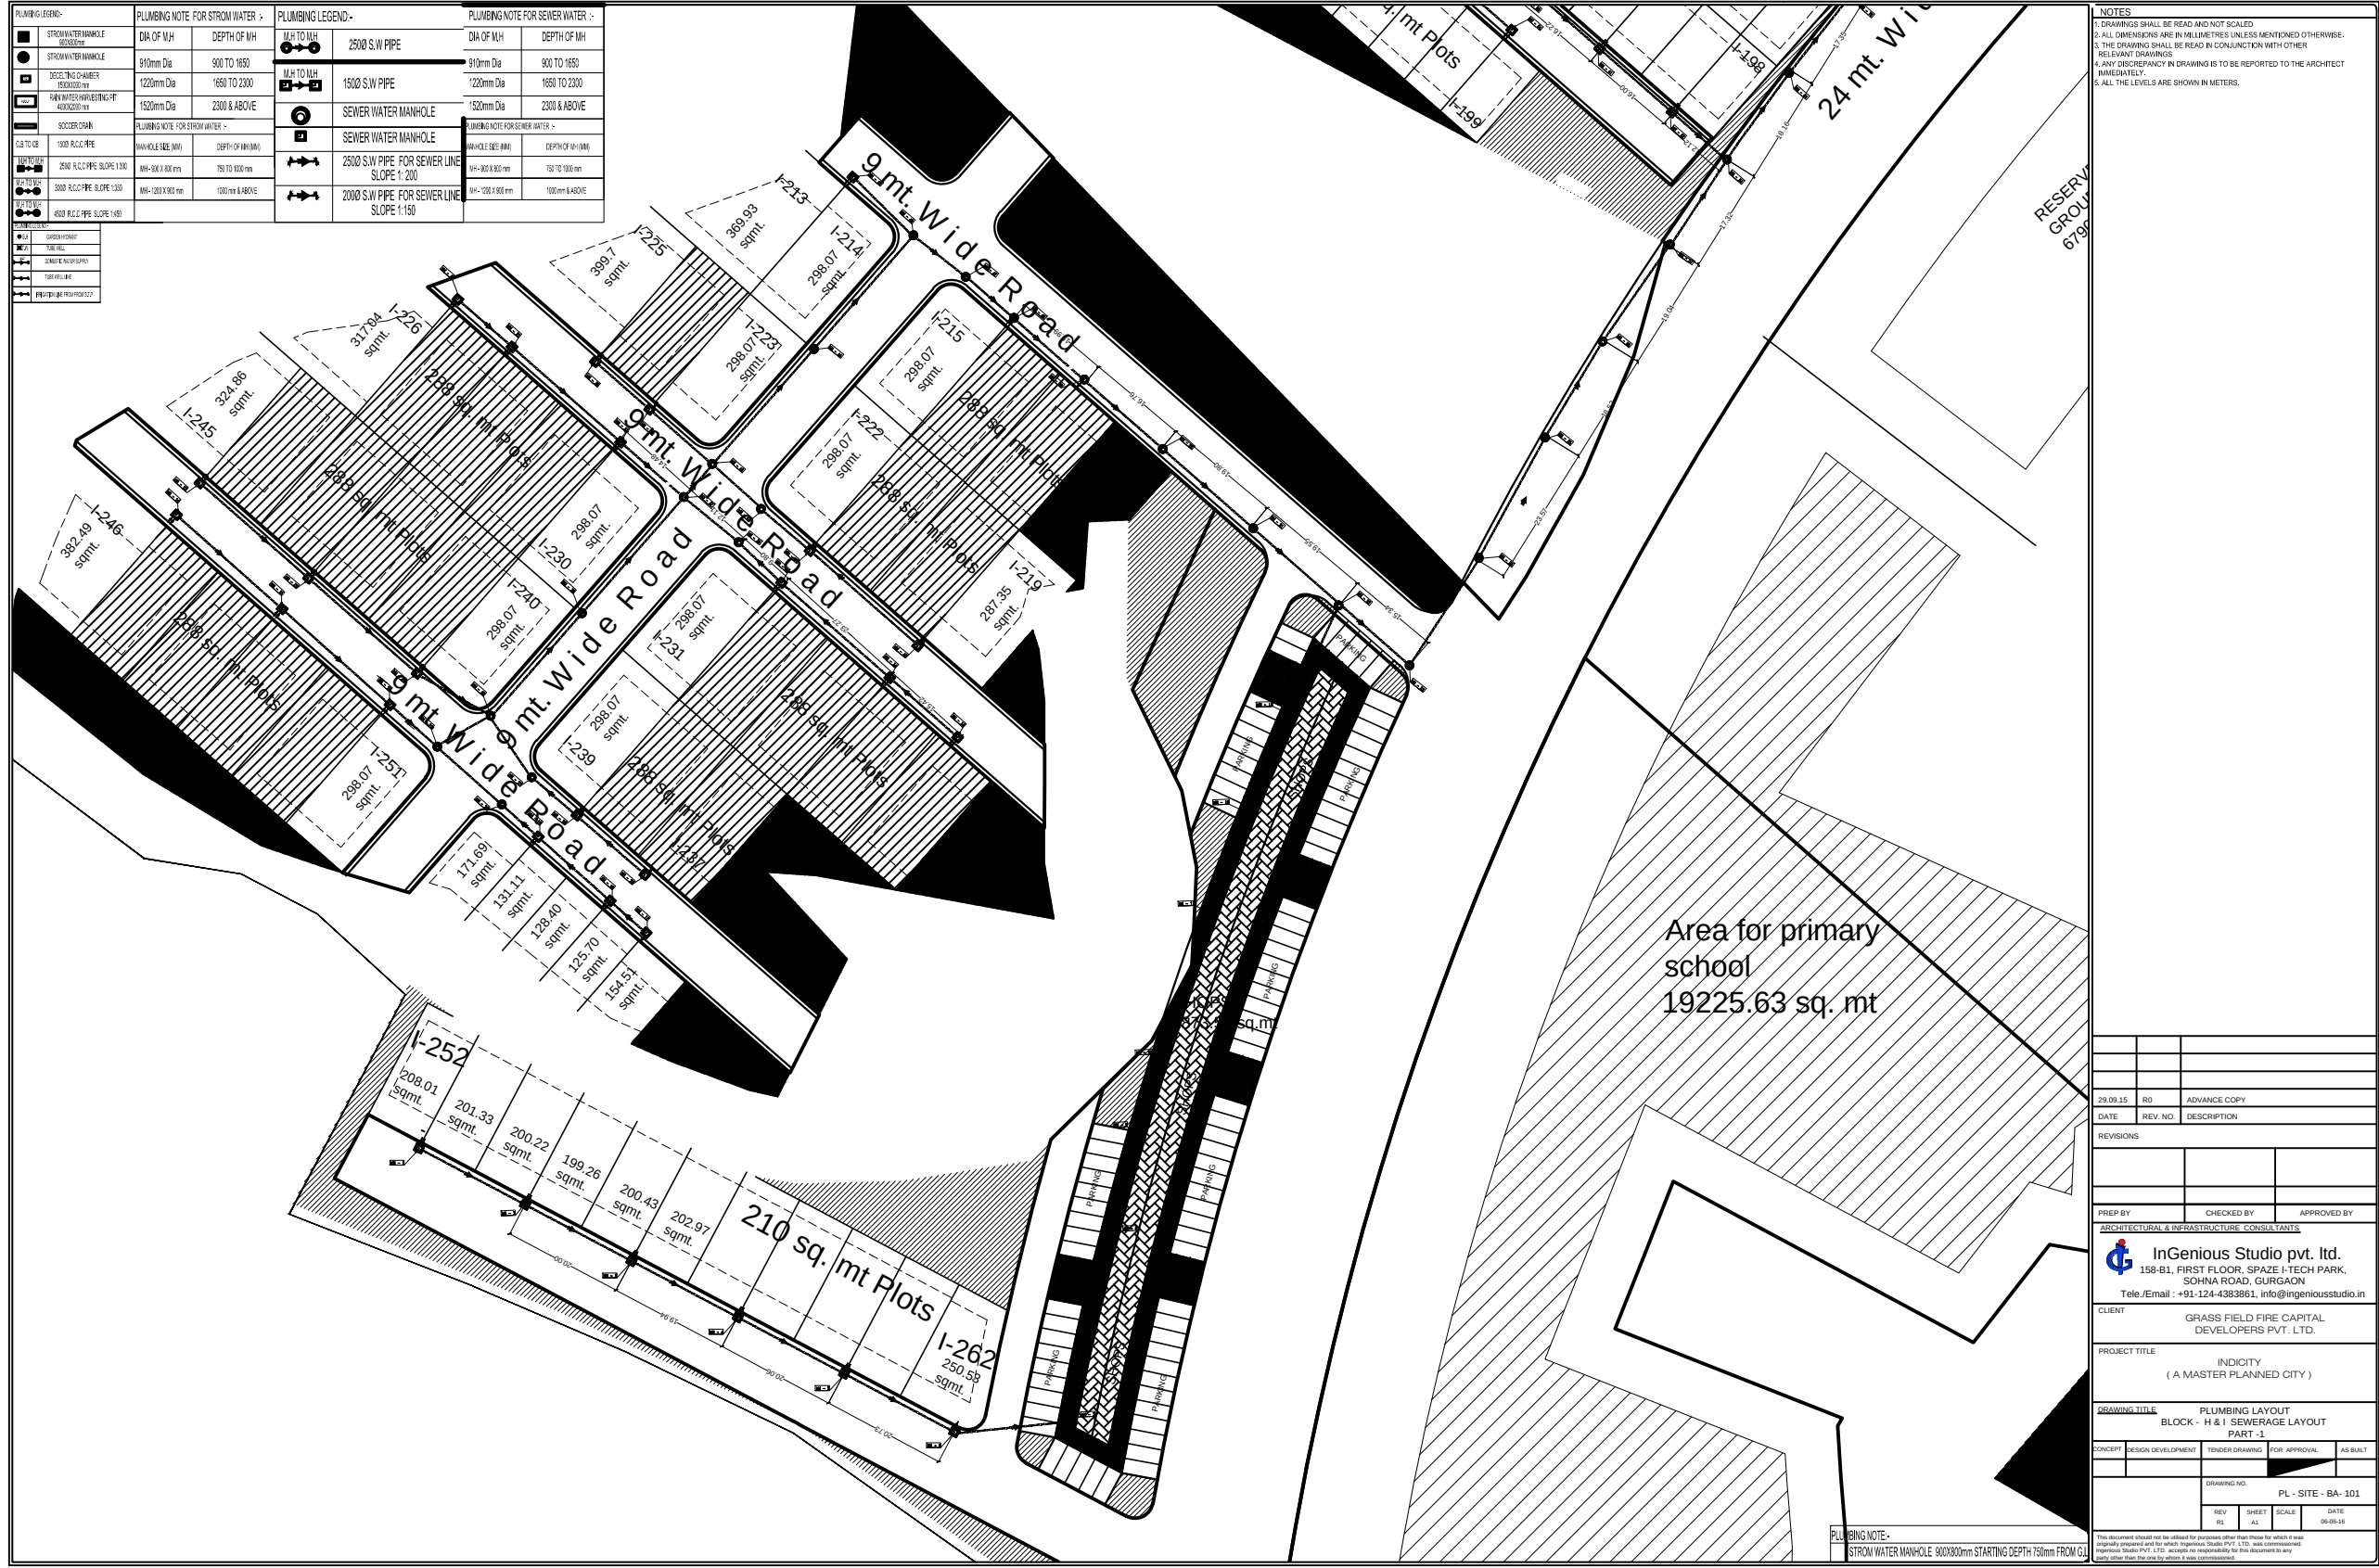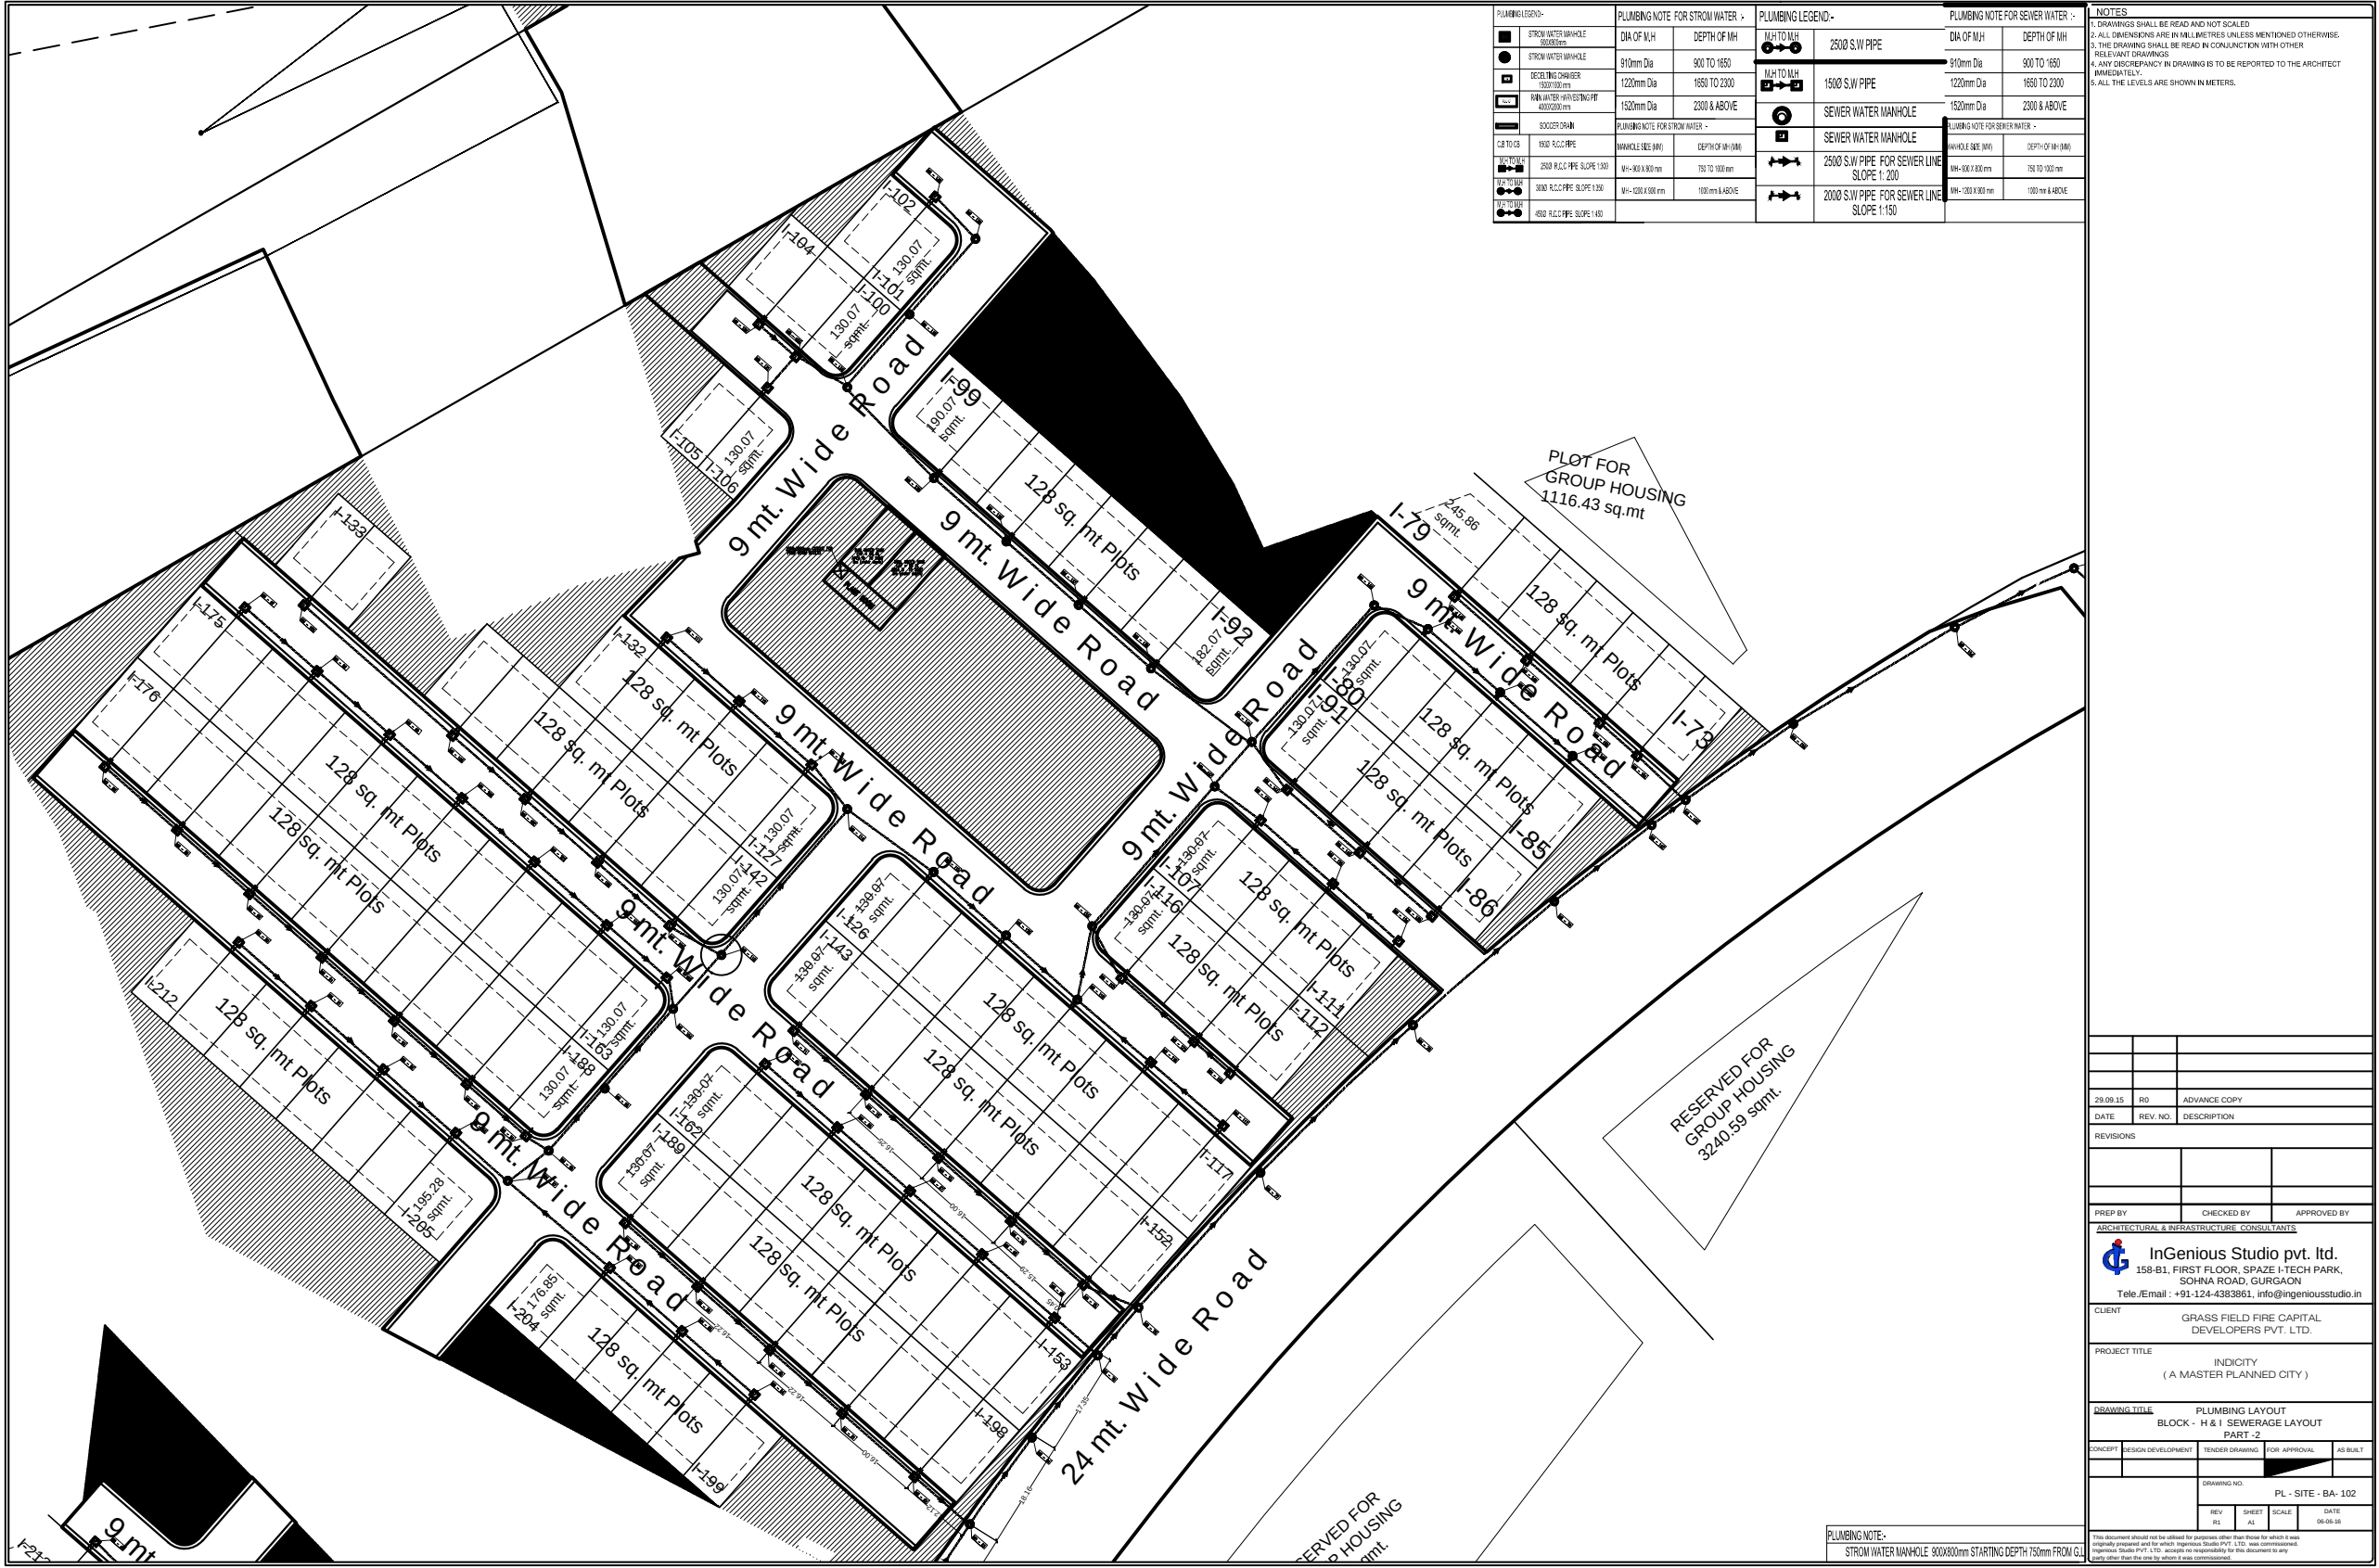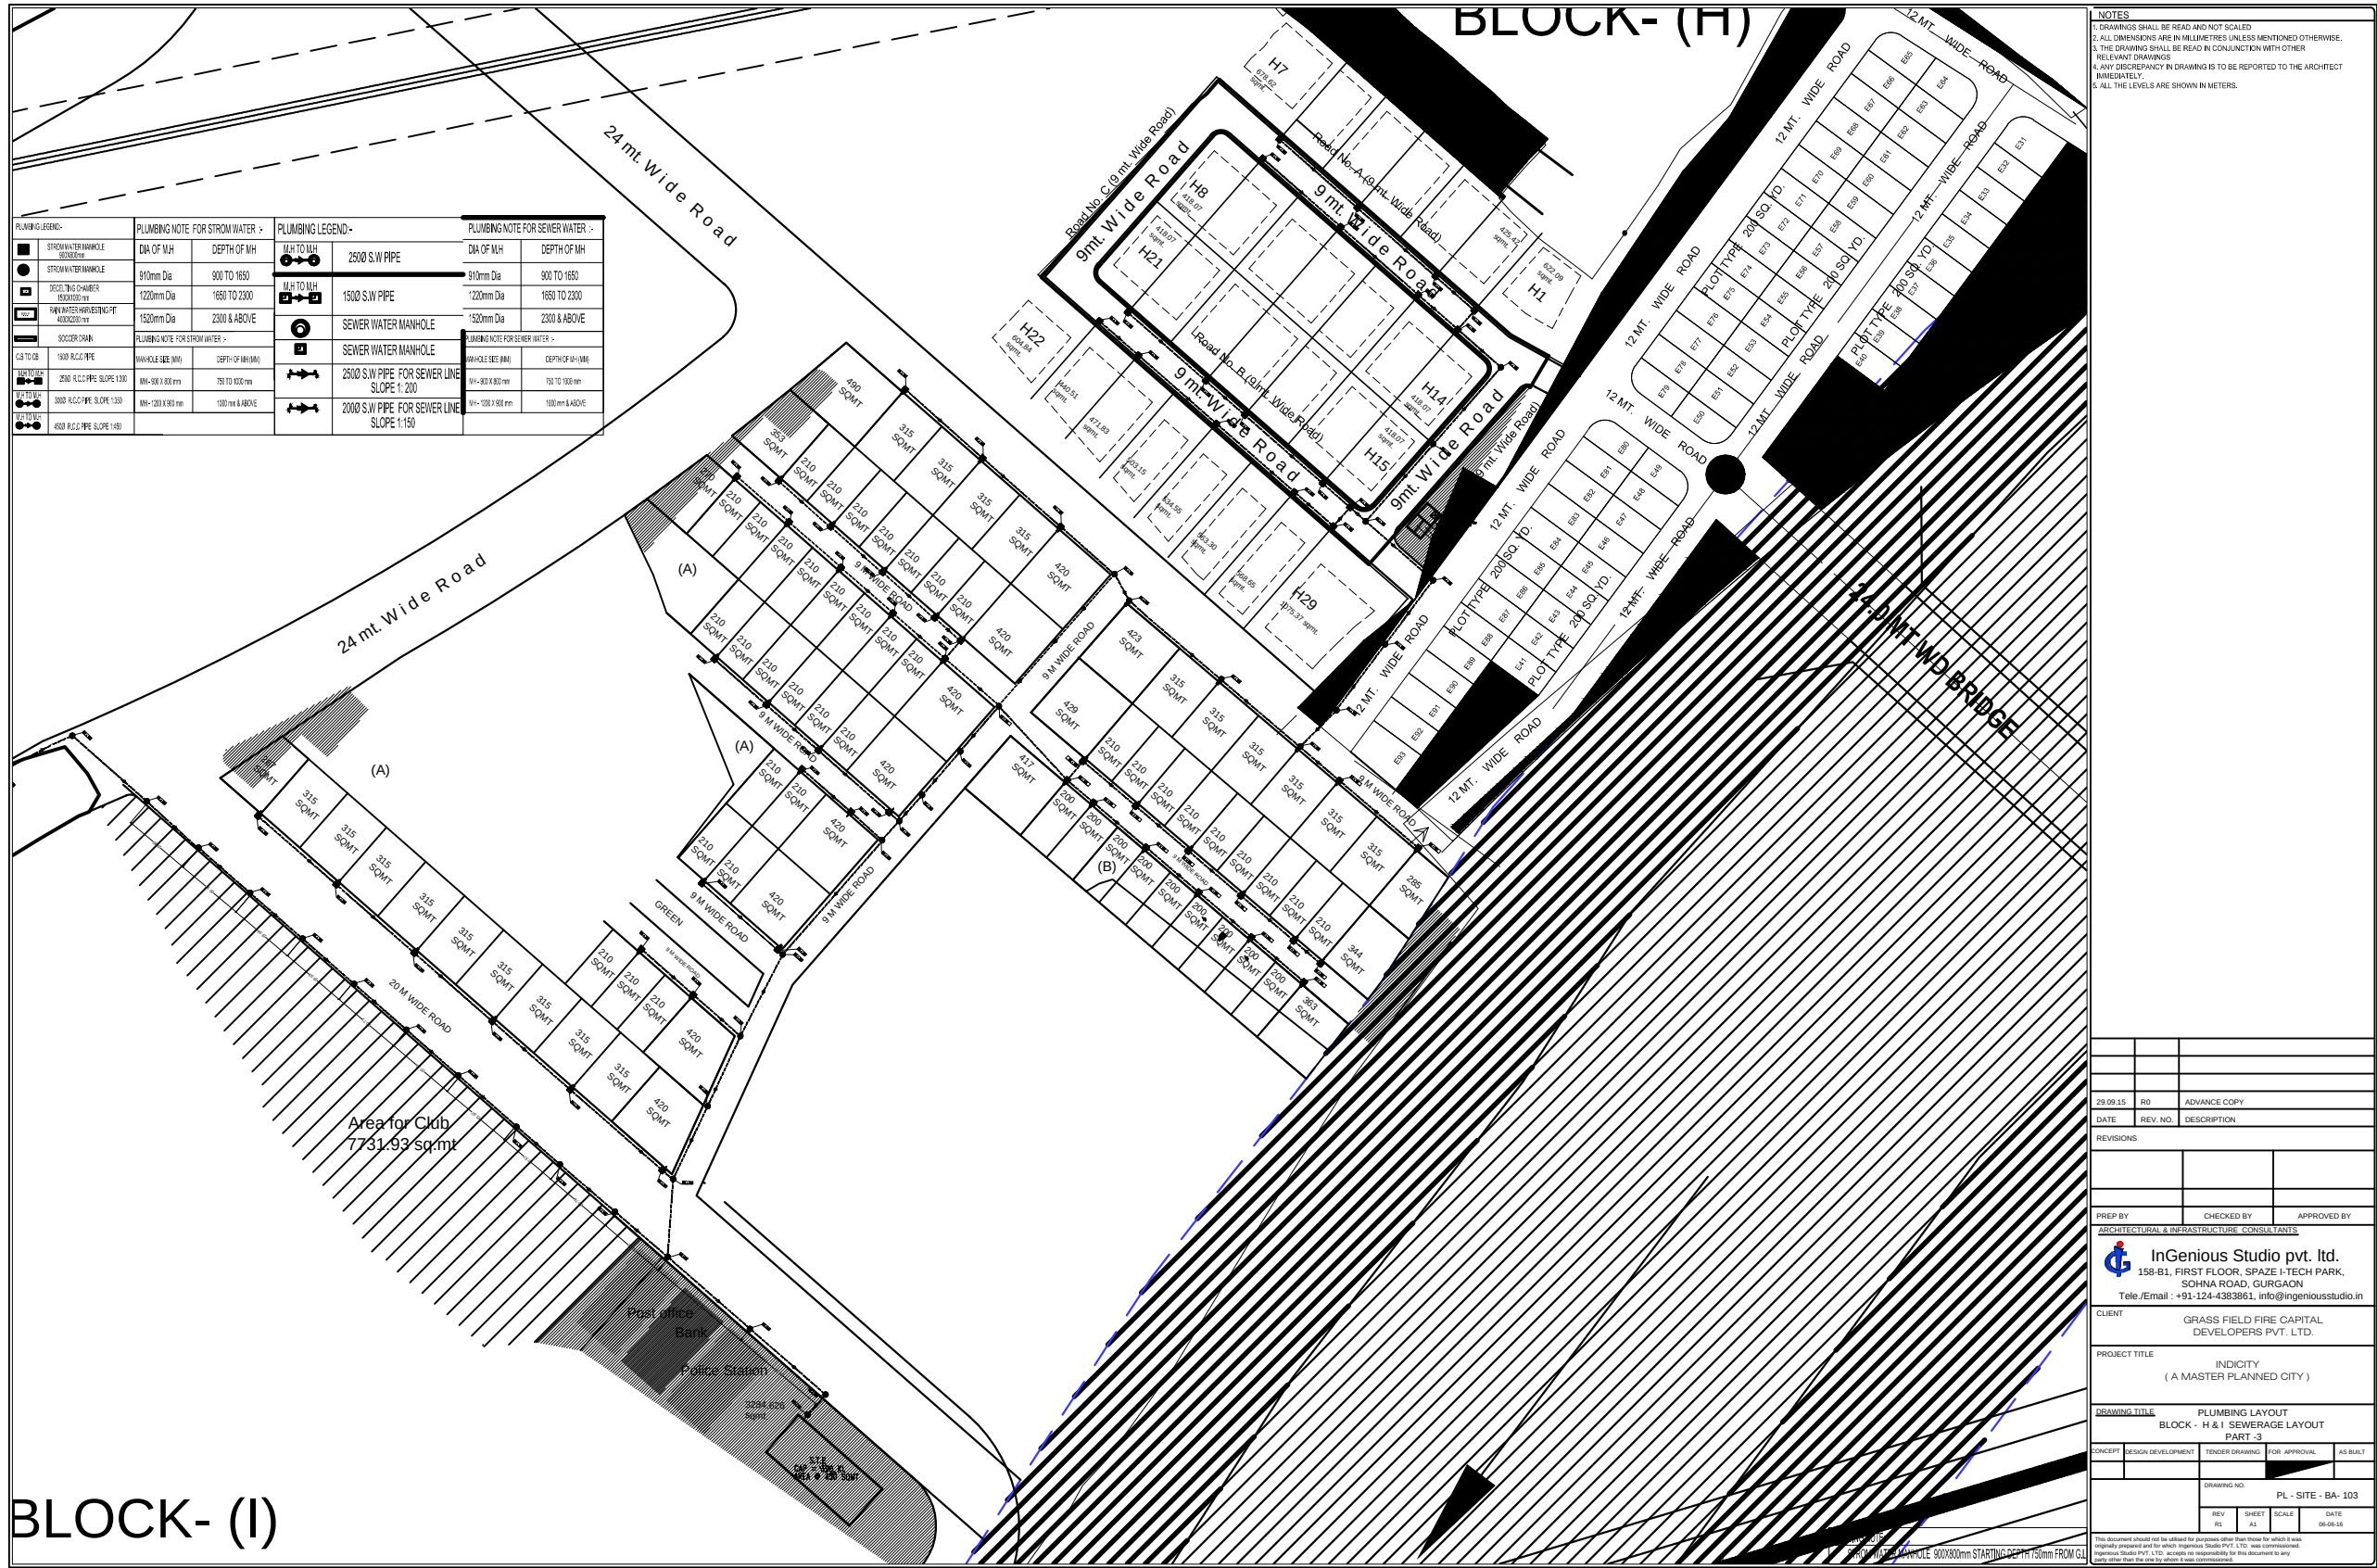

BLOCK- (I)




ION LINE


Proposed Road 48m wide

I-BLOCK ELECTRICAL CONDUIT LAYOUT

BLOCK- (I)

BLOCK- (K)

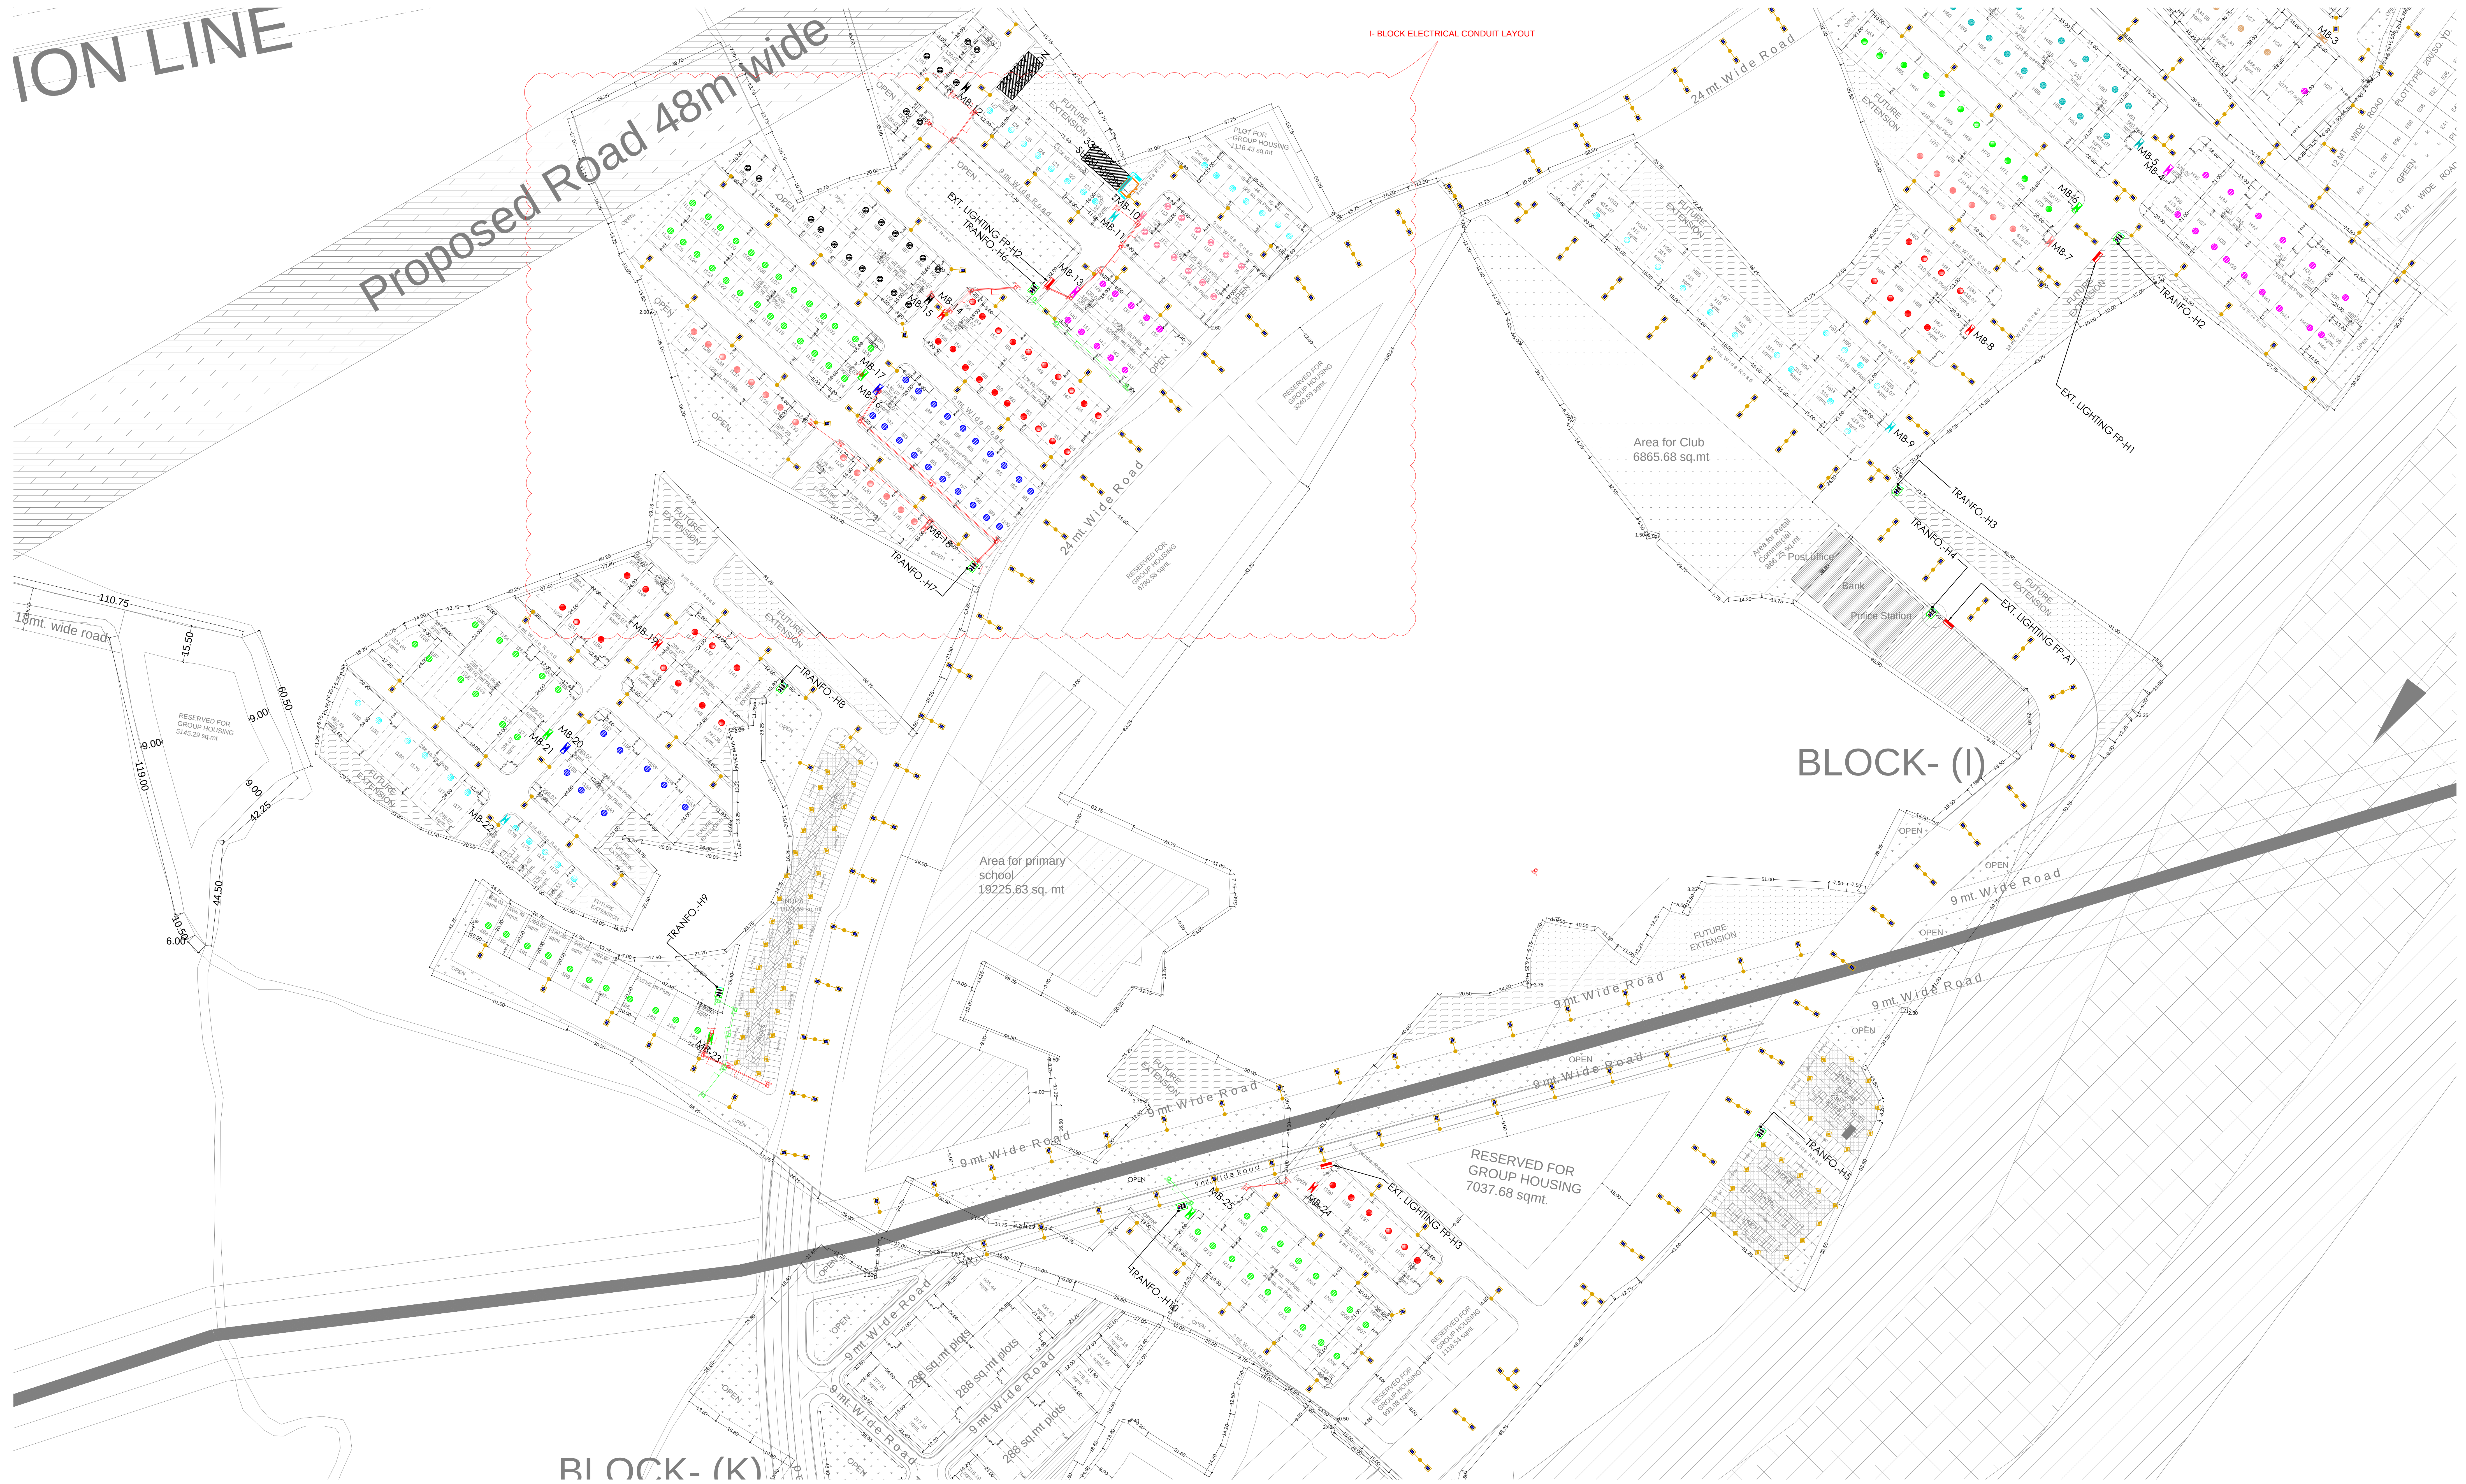

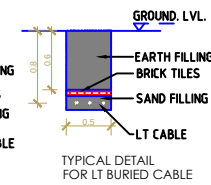

NOTE:-1. ALL MENTIONED PIPE SIZE IS INTERNAL PIPE DIAMETER.
2. ALL HT PIPE SHALL BE RCC TYPE.
3. ALL MV PIPE SHALL BE HDPE TYPE.

[illegible]