


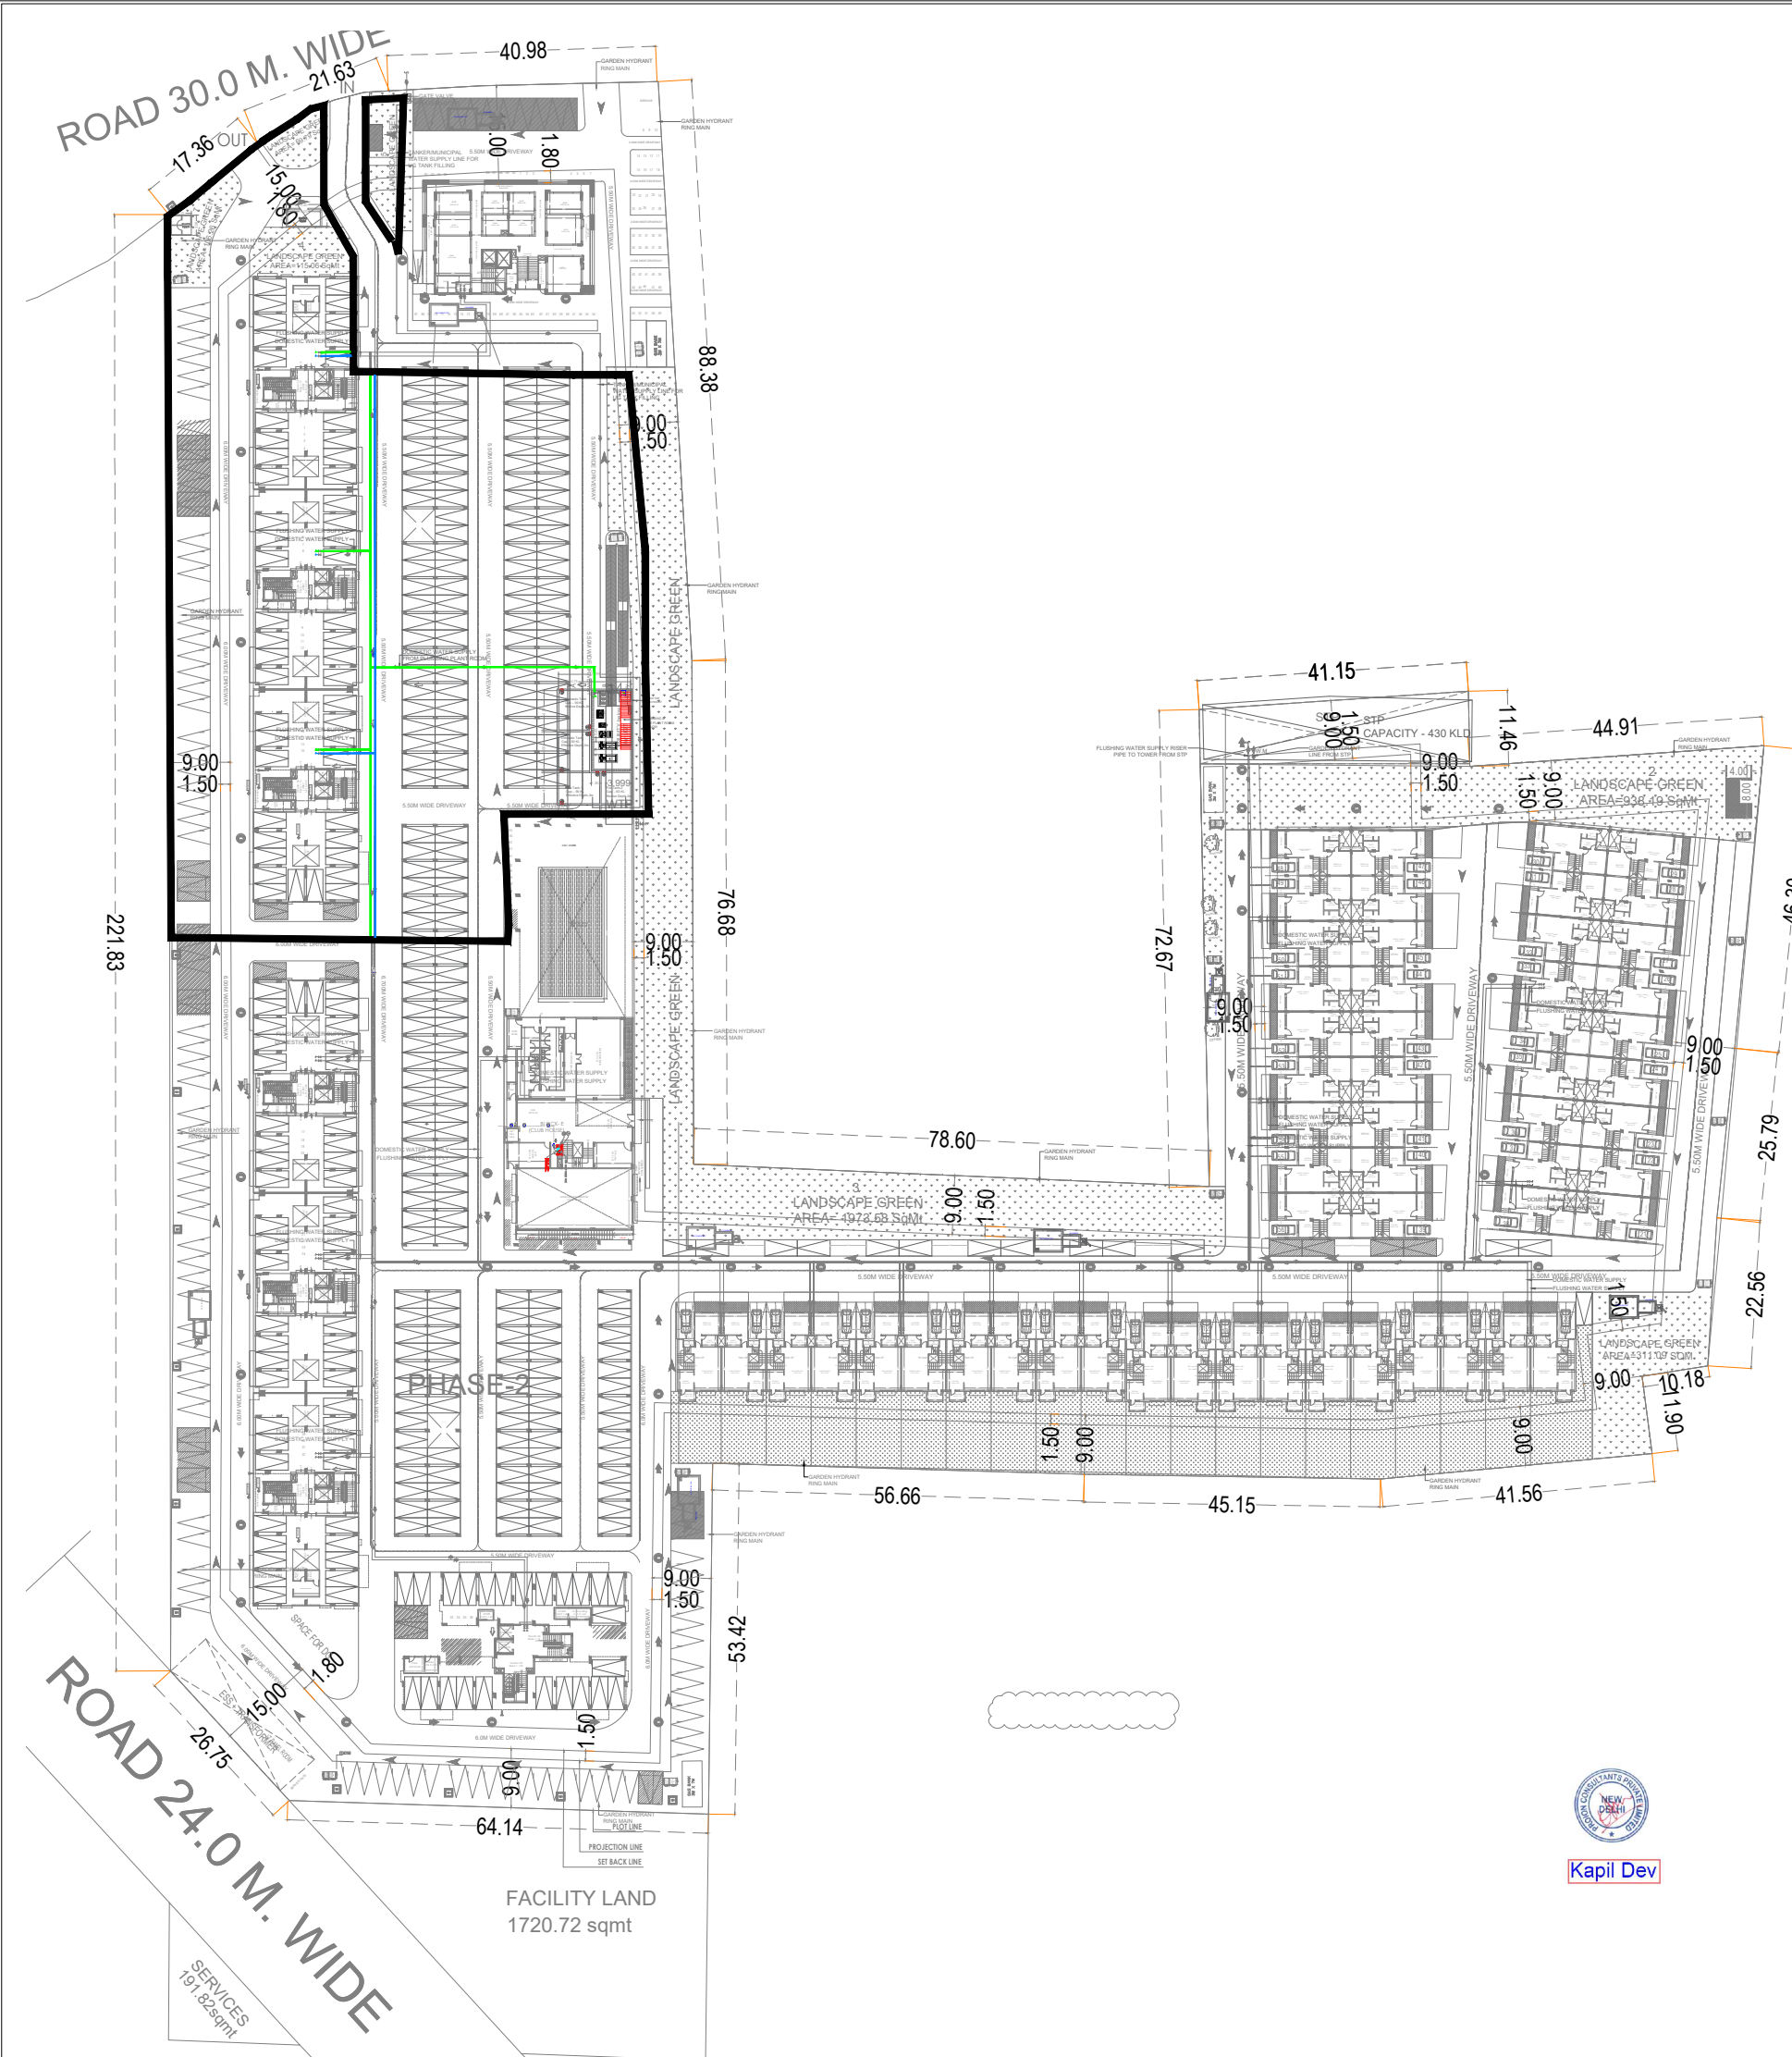

S.N.	PLUMBING LEGENDS:-	
01	DOMESTIC WATER SUPPLY LINE	
02	FLUSHING WATER SUPPLY LINE	
03	VALVE	
S.N.	PLUMBING LEGENDS:-	
01	EXTERNAL FIRE LINE	
02	GARDEN HYDRANT	GH

PROJECT TITLE :-	
ASHIANA NITARA, AT JAIPUR	
CLIENT :-	
ASHIANA HOUSING, JAIPUR	
ARCHITECTS	
Ricky Mathur & Associates architects interior designers planners 33, Dhuleshwar Garden, Jaipur. (RAJ.) India. 302 001 Tel: 91-141-234 2688, 4004700 Fax: 91-141-400 8700 e-mail: ricky@rickymathur.com	
DRAWING TITLE :-	
SITE PLAN DUAL PLUMBING LAYOUT	
SCALE 1 : 400	DATE OCTOBER 2024
DEALT BY	STATUS SUBMISSION
ARCHITECTS SIGN.	
CLIENTS SIGN.	
SHEET NO. - 02	NORTH -

