
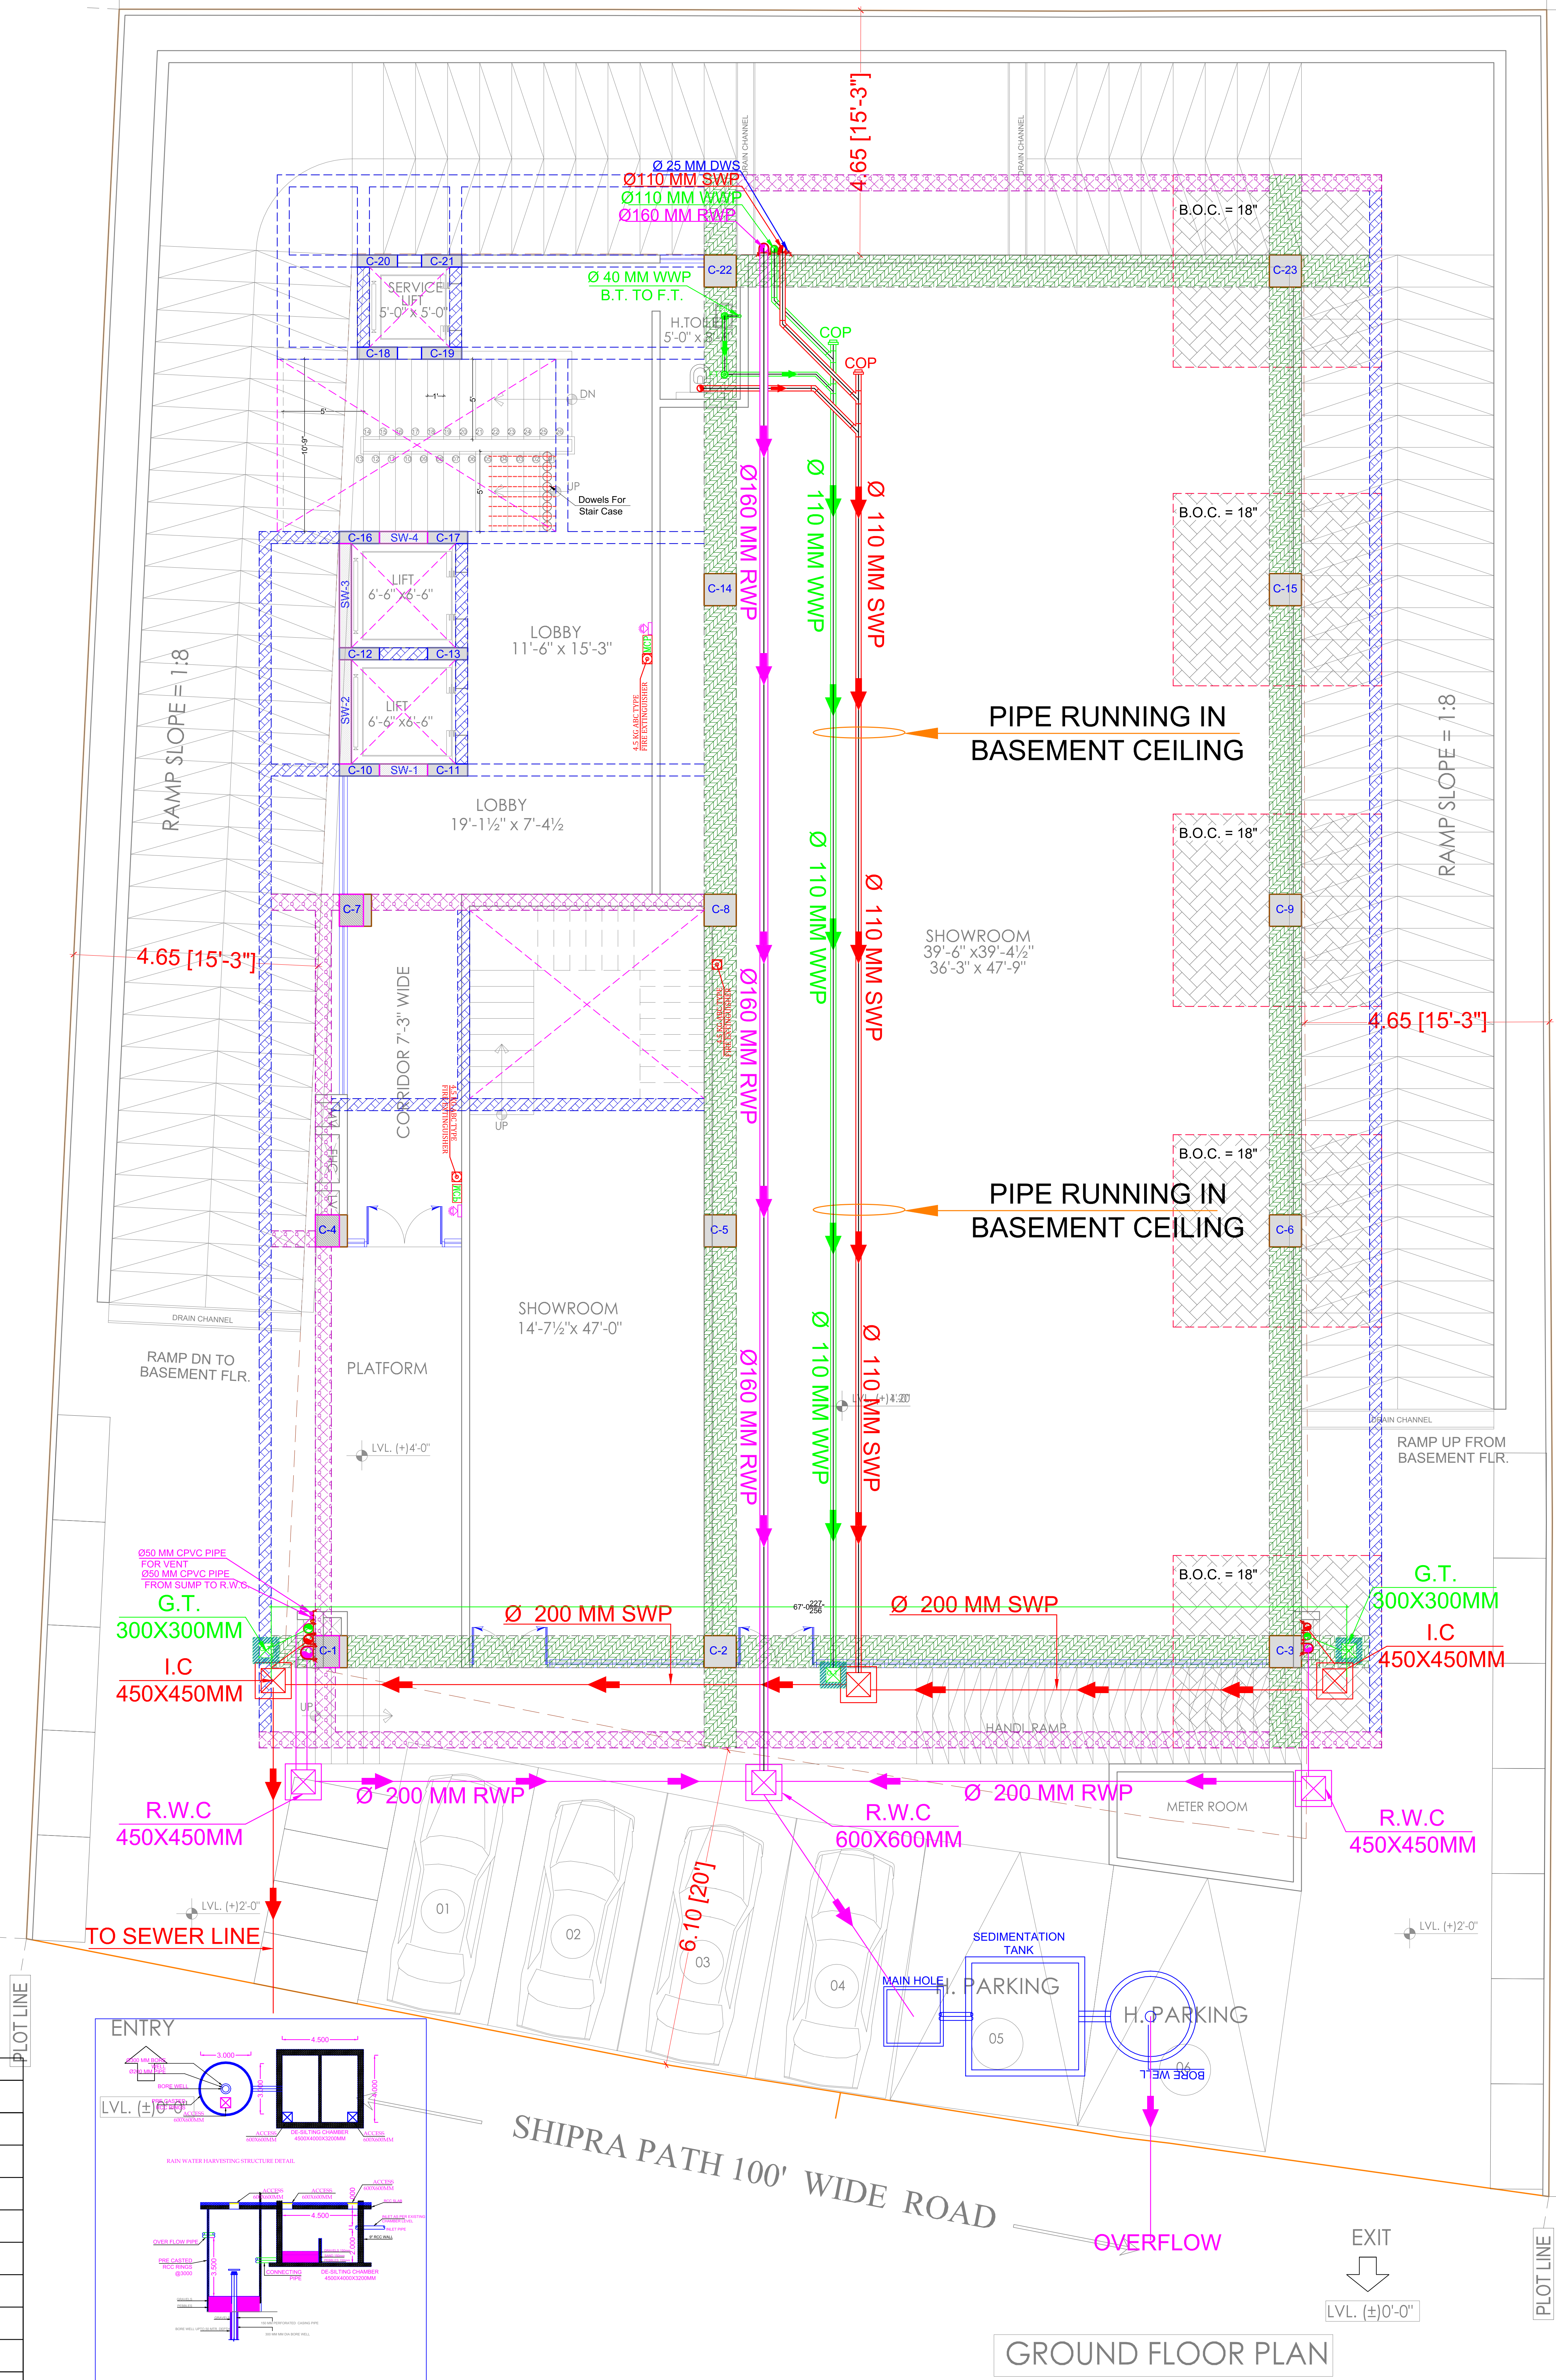


PLOT LINE

PLOT LINE

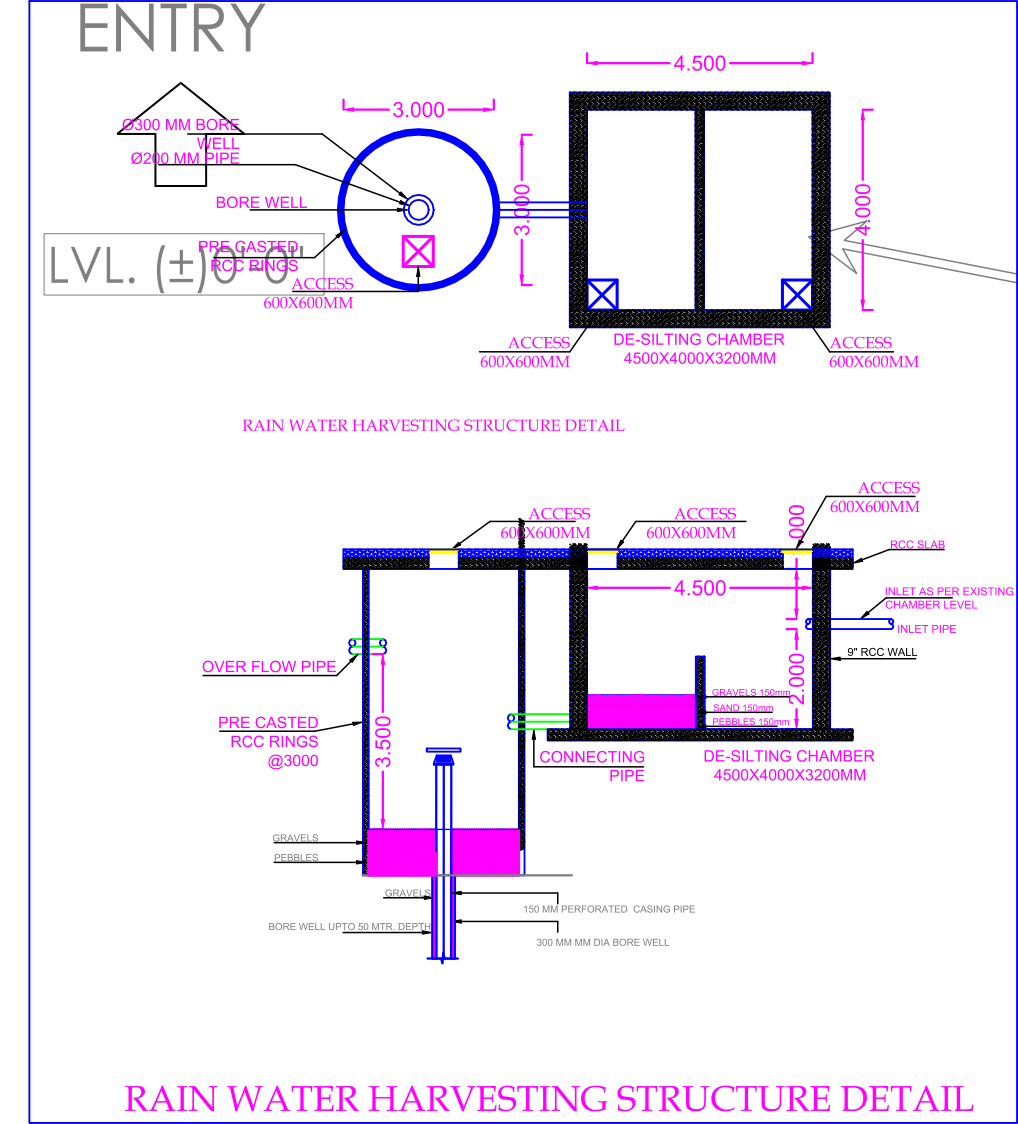

LEGEND	
SR.NO	DESCRIPTION
WWP	WASTE WATER PIPE
SWP	SOIL WATER PIPE
RWP	RAIN WATER PIPE
G.T.	GULLY TRAP
I.C.	INSPECTION CHAMBER
R.W.C.	RAIN WATER CHAMBER
F.T.	FLOOR TRAP
B.T.	BOTTLE TRAP
DWS	DOMESTIC WATER SUPPLY PIPE

GENERAL NOTES :
1. ALL THE DIMENSIONS ON THE DRAWING ARE IN WRITTEN.
2. ONLY WRITTEN DIMENSIONS ARE TO BE FOLLOWED, DRAWING SHOULD NOT BE SCALED IN ANY CIRCUMSTANCES.
3. ALL MEASUREMENTS MUST BE CHECKED AND VERIFIED BY THE CONTRACTORS PRIOR TO EXECUTION OF WORK AT THE SITE.
4. THIS DRAWING IS TO BE READ IN CONJUNCTION WITH ALL RELEVANT STRUCTURAL, ARCHITECTURAL & FACILITY PLANNING DRAWINGS.
5. ANY DISCREPANCIES MUST BE BROUGHT TO THE NOTICE OF THE ENGINEER IMMEDIATELY & PRIOR TO EXECUTION AT SITE.
6. CO-ORDINATION WITH SERVICES SUCH AS HVAC, PLUMBING & ELECTRICAL, ETC. IS THE RESPONSIBILITY OF THE CONTRACTORS.
7. FOR DETAILS, REFER RELEVANT LARGE SCALE DETAIL DRGS. AS INDICATED.

DEVELOPER :
Adapt Buildtech LLP
Add.-Plot No. C-33, 2nd Floor
Vidhan Sabha Road Lal Kothi
Jaipur - 302015
PROJECT ADDRESS:-
78/13-B (7-R1 Part, Shipra Path,
Mansarovar, Jaipur, 302020

DRAWING TITLE:-
GROUND FLOOR DRAINAGE LAYOUT
PROJECT NAME :-
ADAPT ONE

CONSULTANT
AMP INFRA SERVICES
VILLA NO 16. SHUBHASIS GEETA
JAISINGHPURA, BHANKROTA &
CHIMANPURA, JAIPUR 302026
EMAIL ID- ampinfrajpr@gmail.com
CONTACT NO. :- 9462866389

ARCHITECT
ANOOP GUPTA & ASSOCIATES
ARCHITECTS & INTERIOR CONSULTANTS
91, VISHNU GARDEN COLONY,
NEAR AIRPORT CIRCLE,
TONK ROAD, JAIPUR - 302029
TEL : 0141-2552948
DRAWING NO.:-

SUBMITTED FOR :-
PRELIMINARY ☐ APPROVAL ☐
PROPOSAL ☐ GFC ☒
DATE :- 31-07-2025
DRAWN :- MO.AJARUDIN
APPROVED :- NARESH
NORTH :-
SCALE :- N.T.S

Dr. Raw Kant Pareek
M. Tech (Civil)
Ph.d (Environment)