



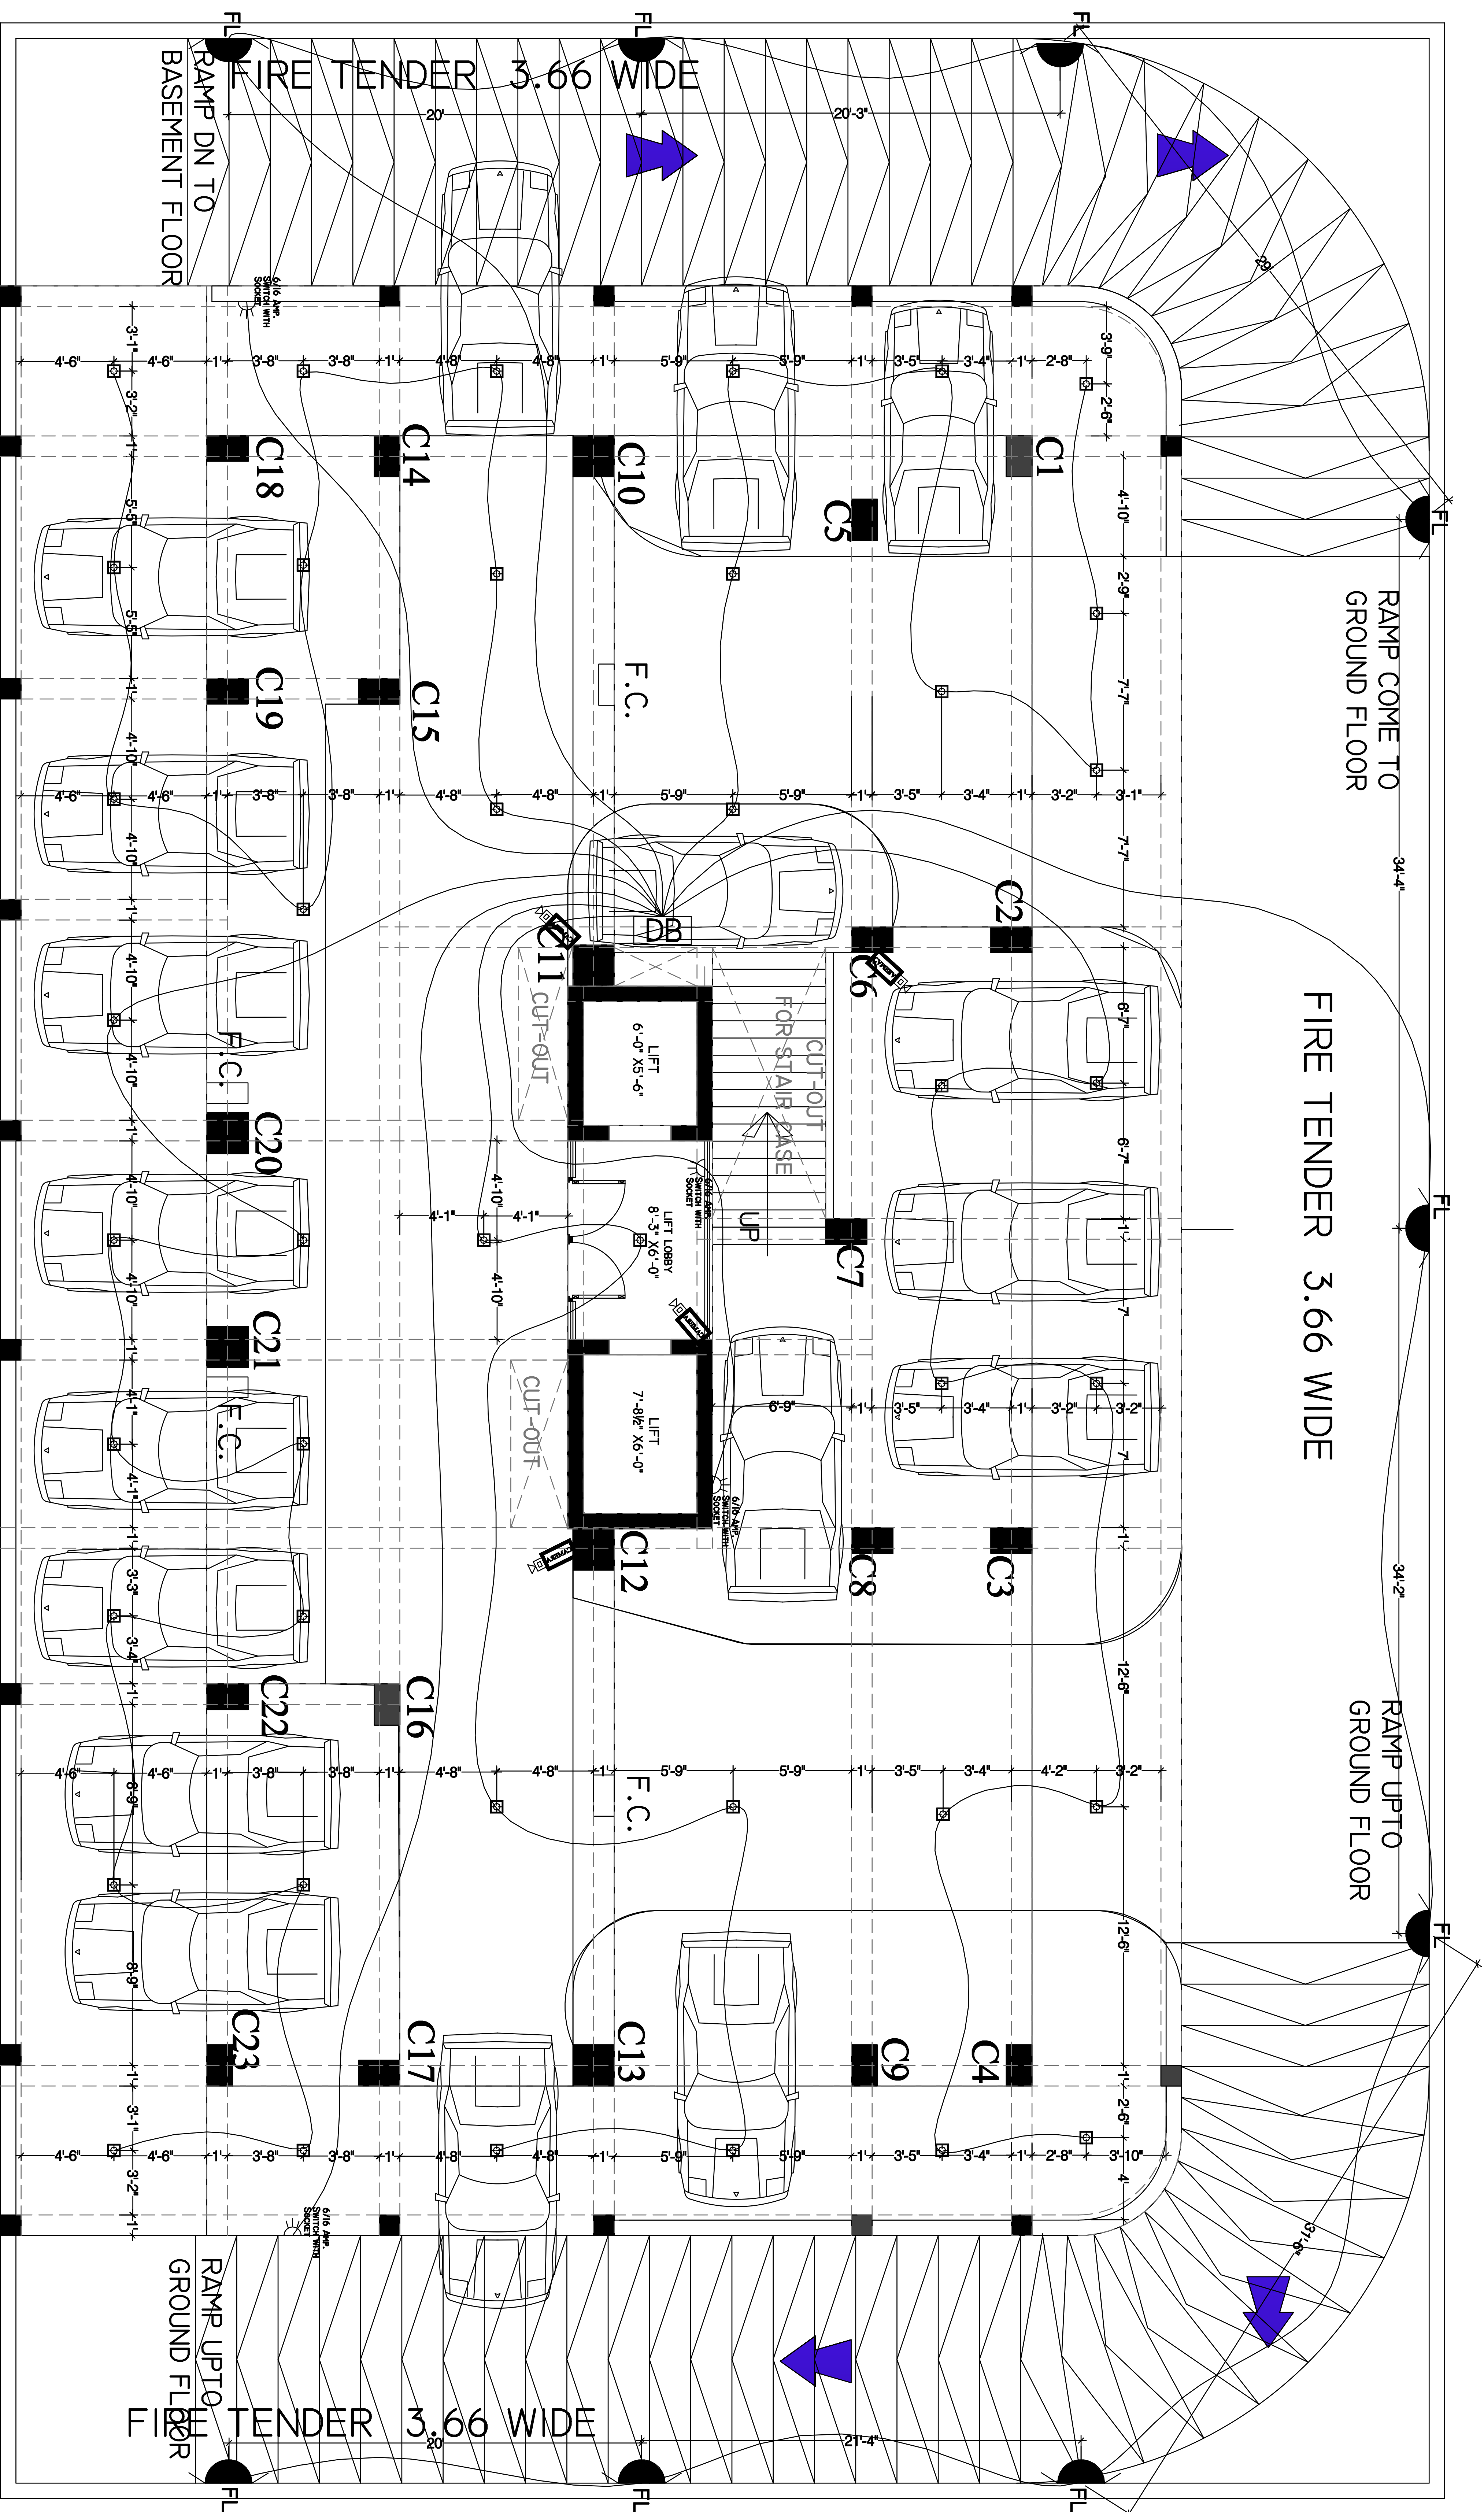

BASEMENT FLOOR PLAN

DRAWING TITLE :- BASEMENT FLOOR ELECTRICAL LAYOUT


OWNER		DATE :	
RAJUKH DEVELOPERS PVT.LTD.		28-06-2016	
PROPOSED RESIDENTIAL APARTMENT		SCALE :	
NIPMAN NAGAR -AB, JAIPUR		DRAWING NO. :	
NAME OF DRAWING:		DRAWN BY:	
FIRST FLOOR ELECTRICAL PLAN		CHECKED BY: NIKESH MAMORIA	
NOTES: THIS DRAWING IS THE PROPERTY OF K.S. CREATION IT SHALL NOT BE COPIED OR USED WITHOUT THEIR WRITTEN PERMISSION NOT MADE KNOWN TO A THIRD PARTY. THE INFORMATION IS ISSUED ON THE UNDERSTANDING THAT NO PART THEREOF SHALL BE DUPLICATED FOR THE PURPOSE. -		APPROVED BY:	

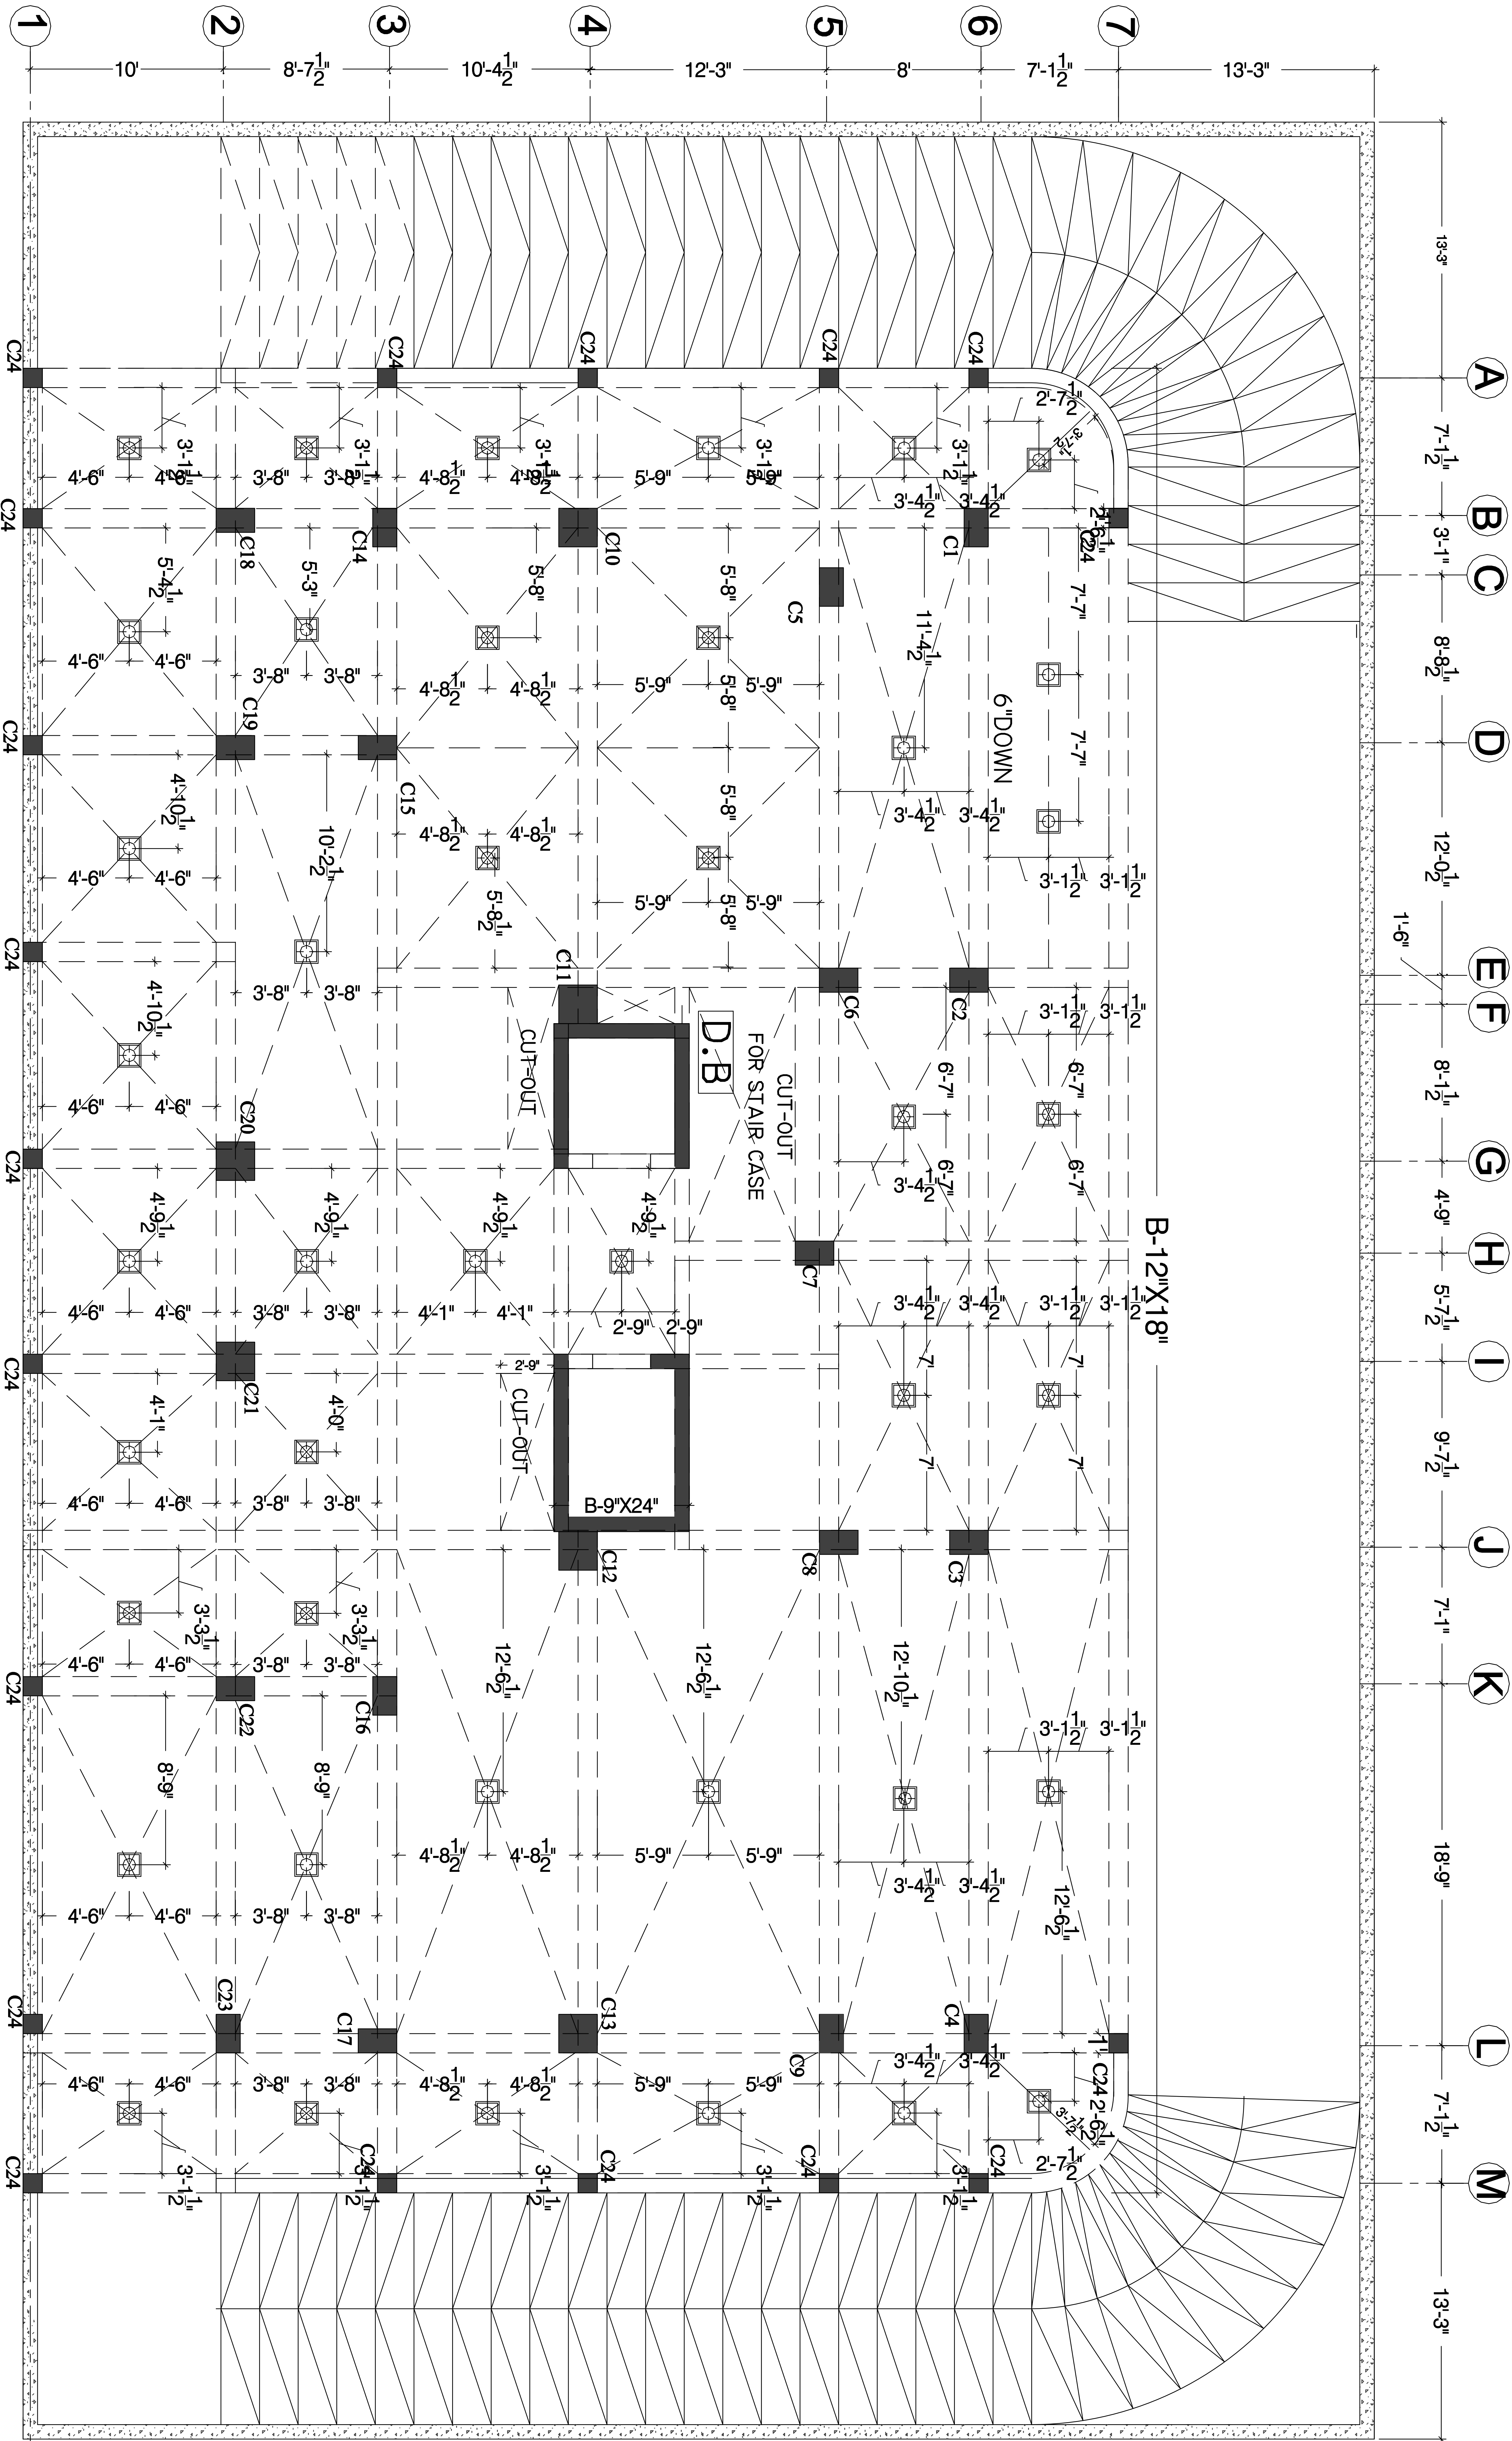

BASEMENT FLOOR ELECTRICAL PLAN


OWNER		NAME	
RAJ SUKH DEVELOPERS PVT.LTD.		PROPOSED RESIDENTIAL APARTMENT	
		NIRMAL NAGAR -AB, JAIPUR	
		DATE : 13-05-2016	
		SCALE :	
		DRAWING NO. : (AR/01)	
		DRAWN BY :	
		CHECKED BY : NIKESH MAMORIA	
		APPROVED BY :	

NOTES:
THIS DRAWING IS THE PROPERTY OF R.S. CREATION
IT SHALL NOT BE COPIED OR USED WITHOUT THEIR
WRITTEN PERMISSION NOT MADE KNOWN TO A THIRD PARTY
THE INFORMATION IS BASED ON THE UNDERSIGNED DRAWING THAN NO
OTHER THAN THE EXPRESSED PURPOSE .

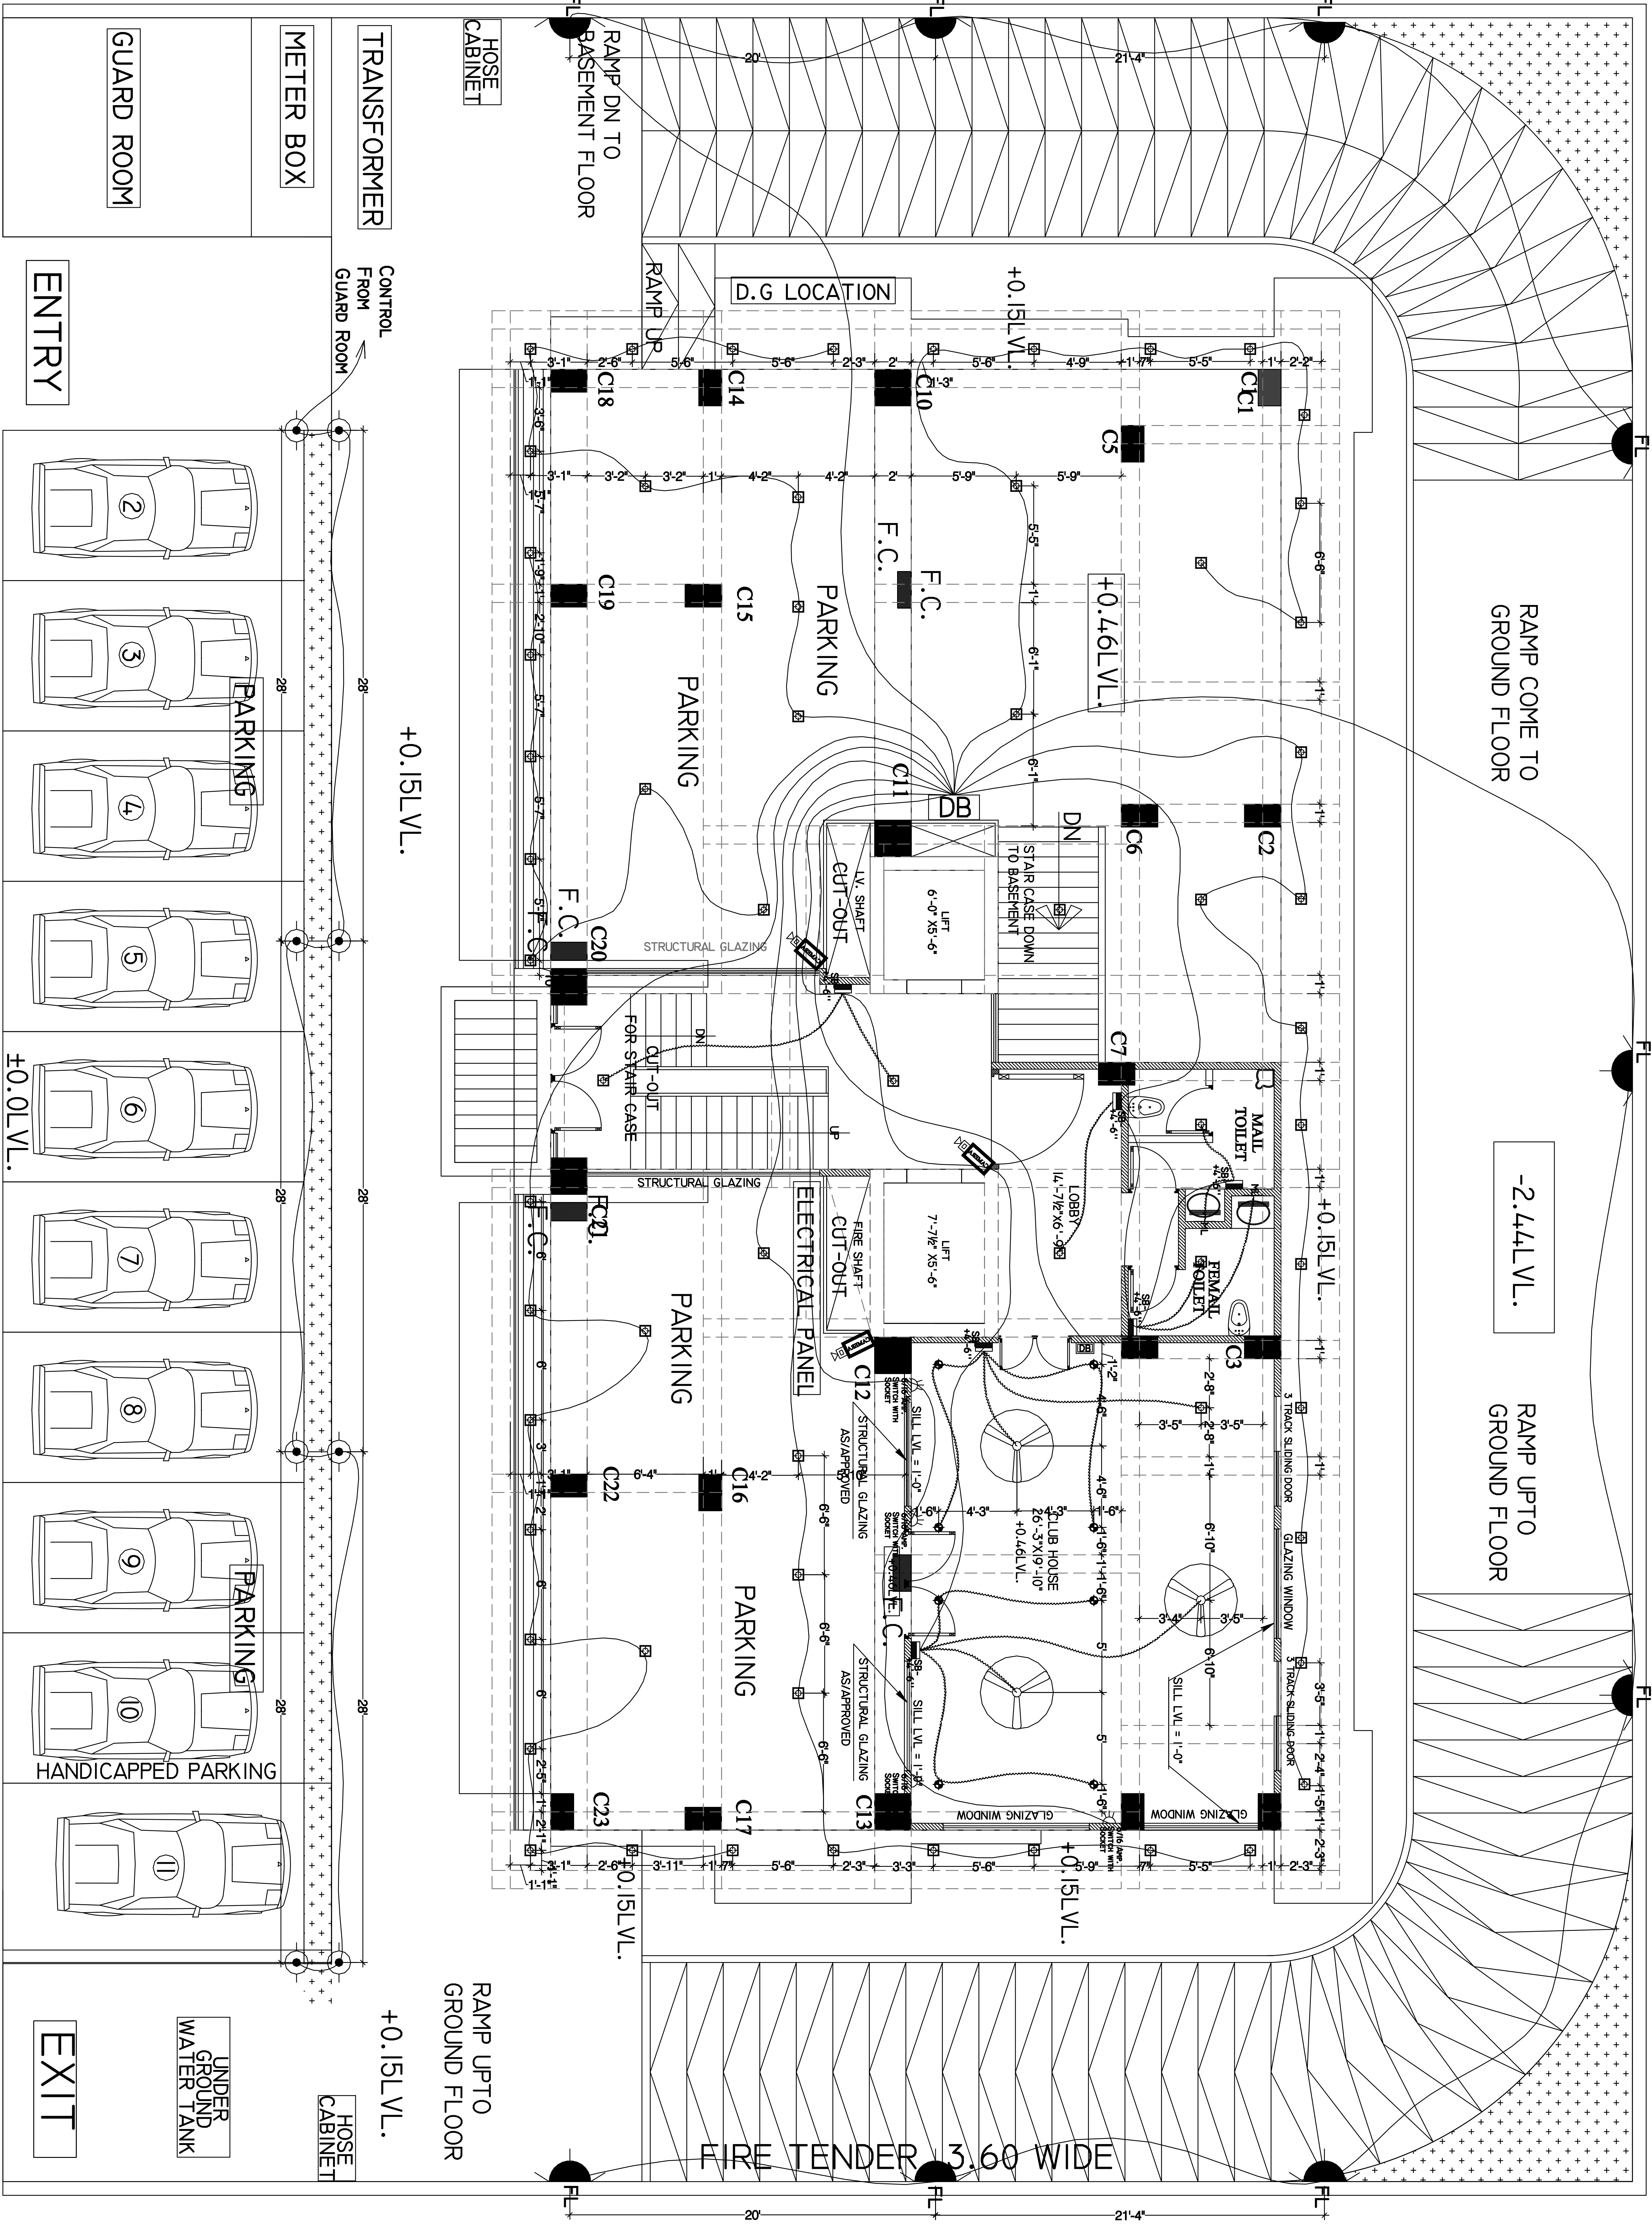

STILT FLOOR ELECTRICAL PLAN

OWNER		RAJ SUKH DEVELOPERS PVT. LTD.	
PROPOSED RESIDENTIAL APARTMENT		NIRMAL NAGAR -AB, JAIPUR	
NAME OF DRAWING:		STILT FLOOR ELECTRICAL PLAN	
NOTES: THIS DRAWING IS THE PROPERTY OF K.S. CREATION IT SHALL NOT BE COPIED OR USED WITHOUT THEIR WRITTEN PERMISSION NOR MADE KNOWN TO A THIRD PARTY. THE INFORMATION IS ISSUED ON THE UNDERSTANDING THAT NO PART THEREOF SHALL BE DUPLICATED FOR THE PURPOSE. - OTHER THAN THE EXPRESSED PURPOSE.			
DATE :		28-06-2016	
SCALE :		DRAWING NO. : (AR/01)	
DRAWN BY:		CHECKED BY: NIKESH MAMORIA	
APPROVED BY:			

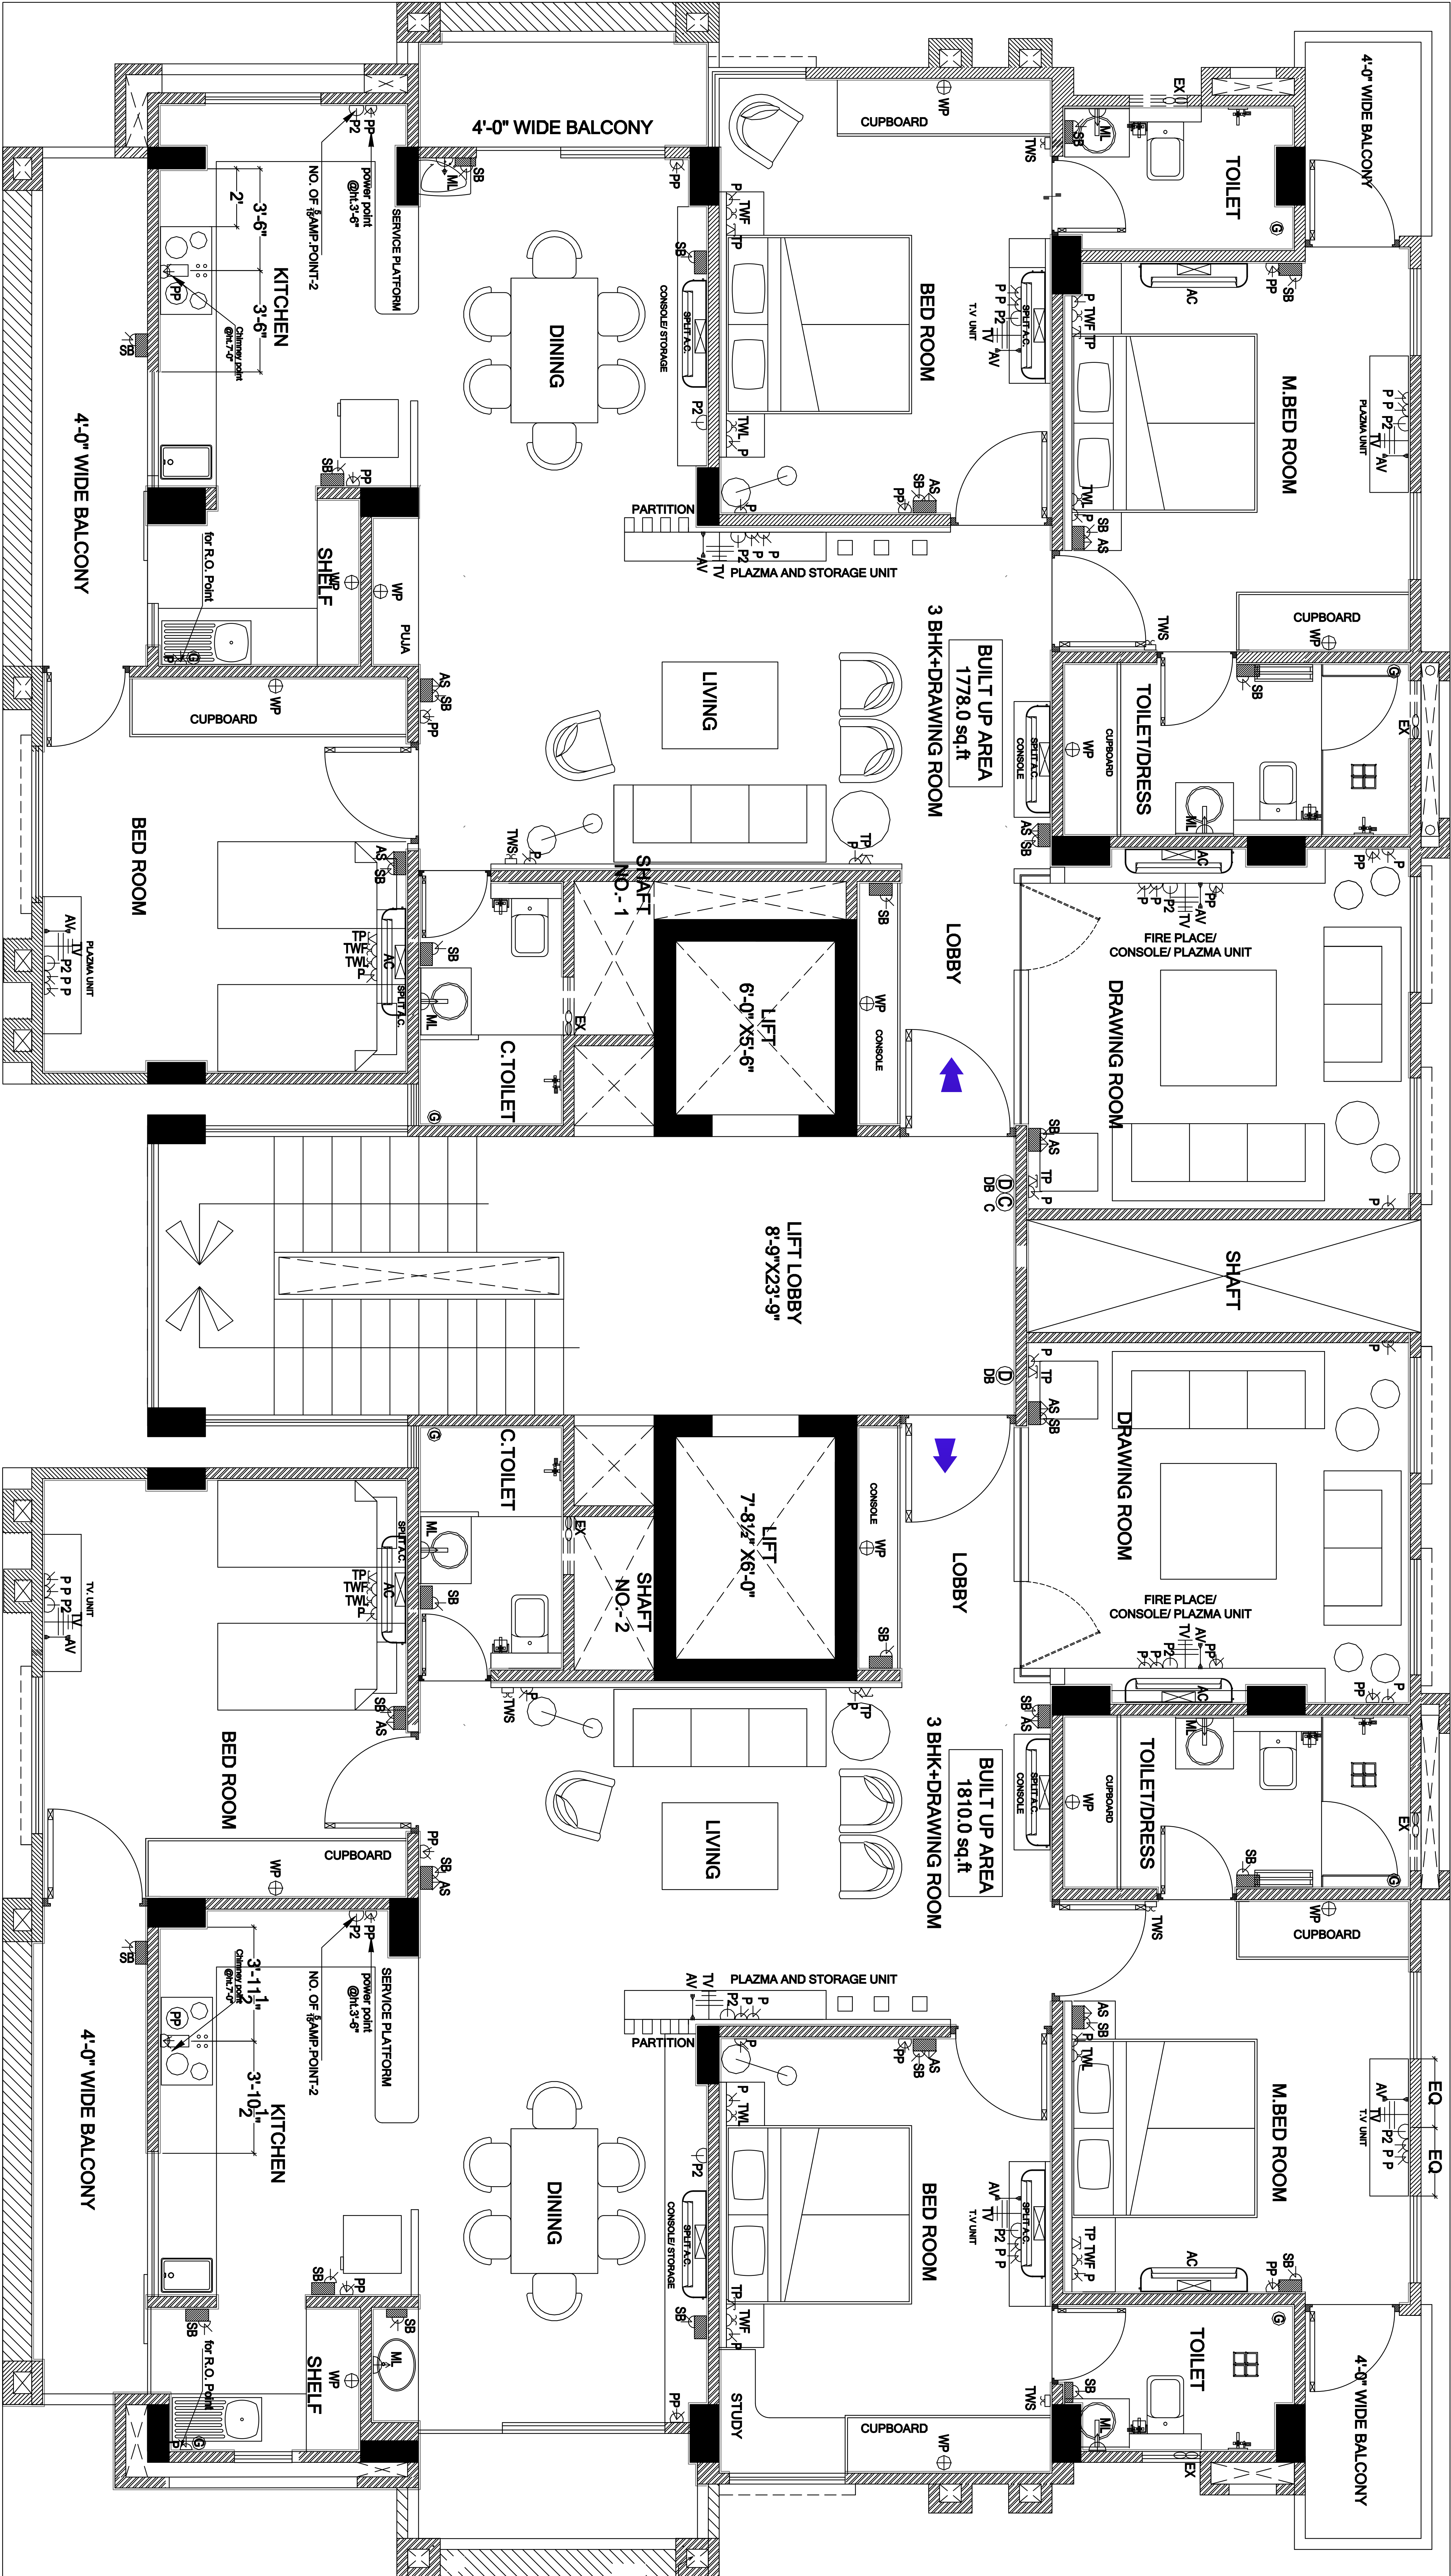

TYPICAL FLOOR ELECTRICAL DRAWING

ELECTRICAL LEGEND			
S.NO. TYPE	NAME	SYMBOL	TOP HEIGHT
1	EX	EXHAUST POINT	—
2	RJ	RJ 45 NETWORKING	2-0"
3	PP	POWER POINT 25 AMP.	1-0"
4	P	POINT 5/10 AMP.	2-0"
5	P1	POINT 5/10AMP.	3-0"
6	TV	TELEVISION	2-0"
7	TWL	TWO WAY LIGHT	2-0"
8	TWF	TWO WAY FAN	2-0"
9	AV	AUDIO VIDEO WIRE	2-0x3-6"
10	G	GYSER POINT	7-6"

ELECTRICAL LEGEND			
S.NO. TYPE	NAME	SYMBOL	TOP HEIGHT
11	TP	TELEPHONE	2-0"
12	TWS	TWO WAY SWITCH	4-0"
13	SB	SWITCH BRD. AND 5AMP.	4-0"
14	WP	WALL POINT	7-0"
15	P2	POINT 5/10 AMP.	3-6"
16	AC	INDOOR AC UNIT POINT	8-6"
17	ML	MIRROR LIGHT	4-0"
18	DB	DOOR BELL	4-0"
19	C	CAMERA POINT	CEILING LVL.
20	AS	A.C. SWITCH ON/OFF	ON SWITCH BRD.

OWNER		NAME		DATE :- 30-01-2016	
RAJSUKH DEVELOPERS PVT.LTD.		PROPOSED RESIDENTIAL APARTMENT		SCALE :	
		NIRMAN NAGAR -AB, JAIPUR		DRAWING NO. :	
		TYPICAL FLOOR WALL ELECTRICAL LAYOUT		DRAWN BY:	
				(AB/01)	
		NOTES THIS DRAWING IS THE PROPERTY OF R.S. CREATION IT SHALL NOT BE COPIED OR USED WITHOUT THEIR WRITTEN PERMISSION NOR MADE KNOWN TO A THIRD PARTY. PART THEREOF SHALL BE OBLIGATED FOR THE PURPOSE :-		CHECKED BY: A.YASHWANT SHARMA	
				APPROVED BY:	

