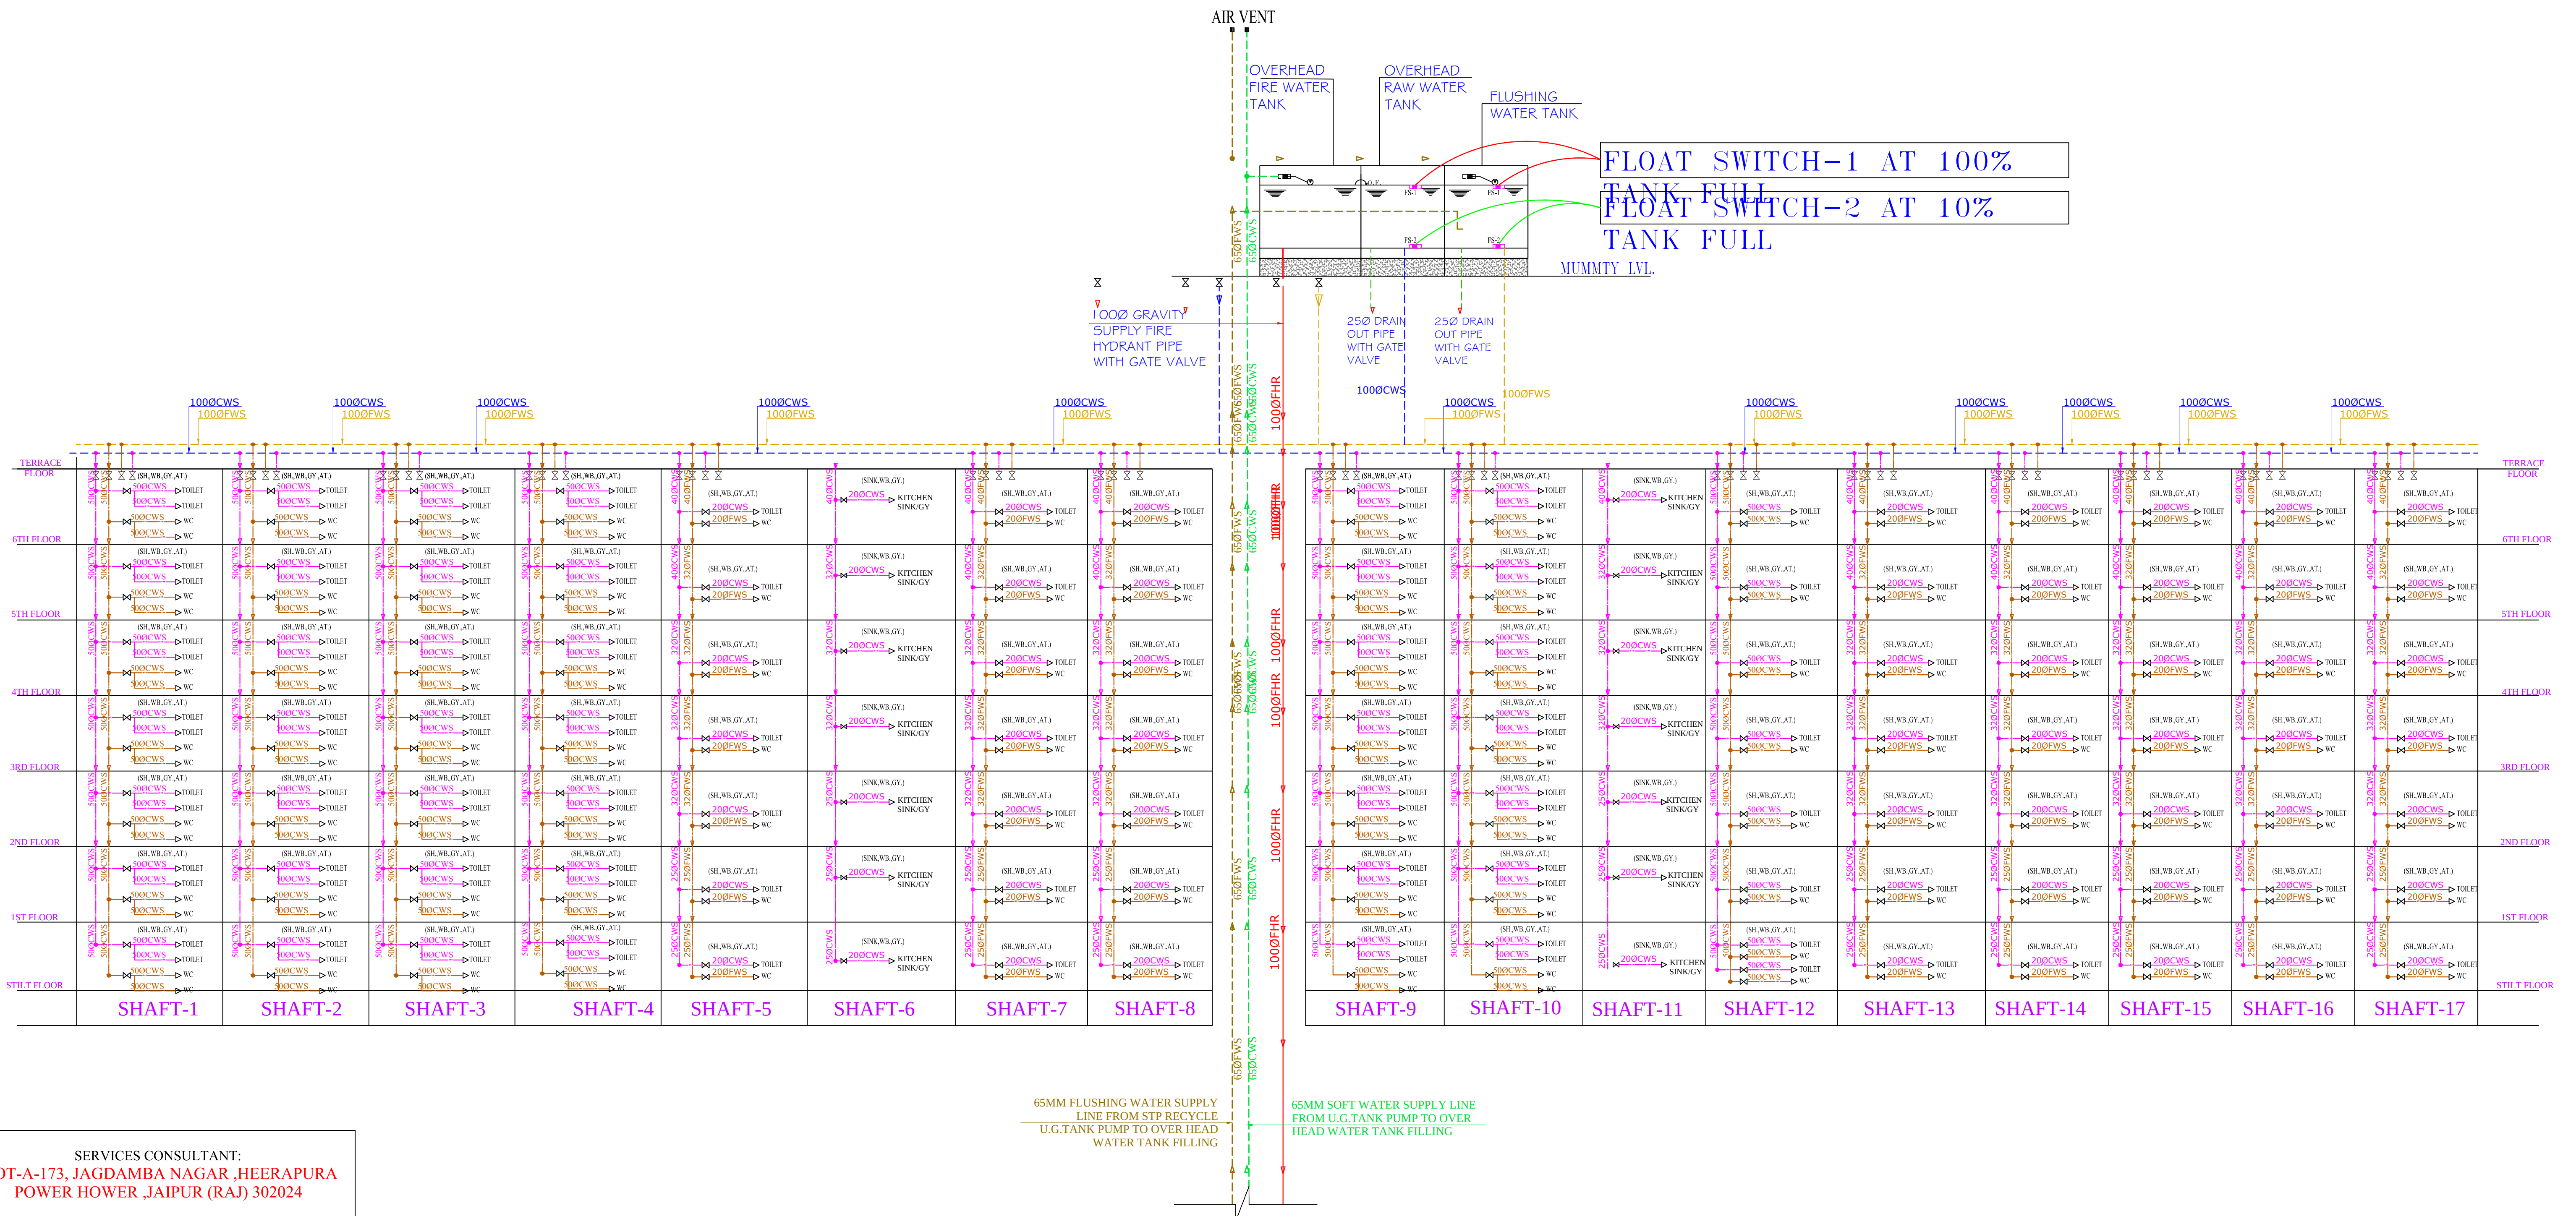


WATER SUPPLY SCHEMATIC DIAGRAM



SERVICES CONSULTANT:
PLOT-A-173, JAGDAMBA NAGAR ,HEERAPURA
POWER HOWER ,JAIPUR (RAJ) 302024

ARCHITECTS:-

 **FRANK SQUARE**

ARCHITECTURE | PLANNER | DESIGNER
C-49 VIDYA APARTMENT PARAS MARG,
BAPU NAGAR JAIPUR, (RAJ.)
Email-afranksquare@gmail.com
Mobile-9461302542

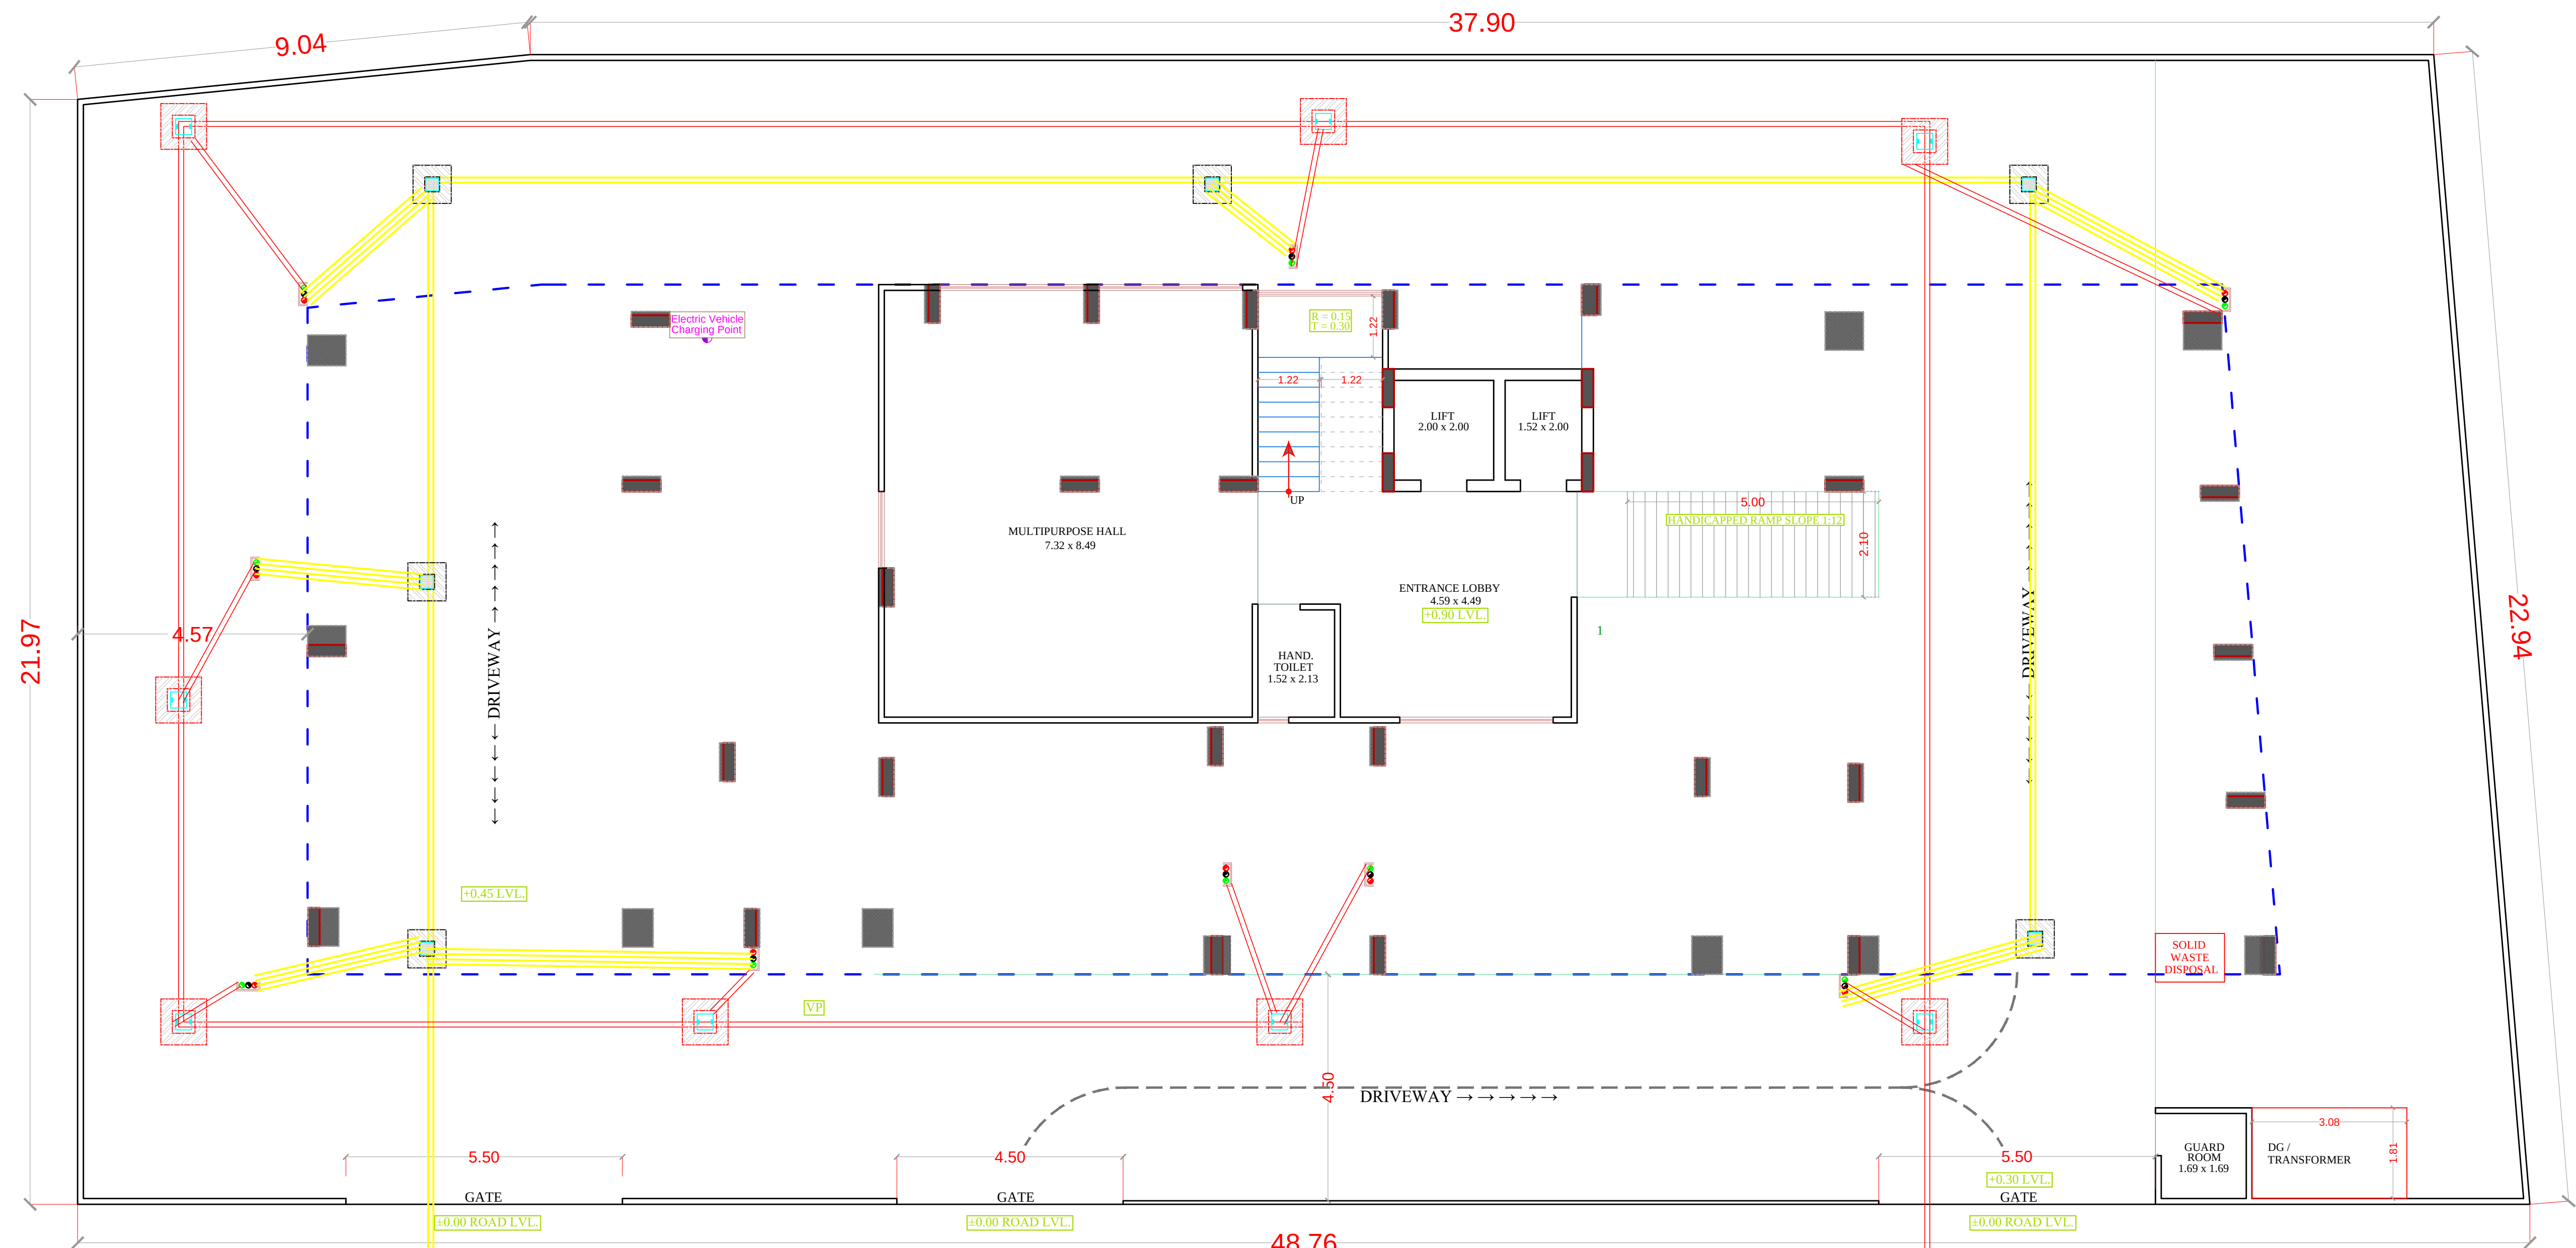

RAMESH KUMAWAT
M.E.P. CONSULTANT
B.E. CIVIL

Project: PROPOSED BUILDING FOR
FLATS, AT PLOT NO.- 1, 2, 3, 4 &
5, OF GOVIND BAGH PEARL
SCHEME, VILLAGE - BEELWA
KALA, TEH.- SANGANER ,

Drawing: JAIPUR

WATER SUPPLY SCHEMATIC
DIAGRAM

DRN BY :	CHCKD BY :
APPRVD BY :	DATE.:-



STILT FLOOR PLAN & PARKING LAYOUT

MAIN SEWER LINE

RAIN WATER LINE

RAMESH KUMAWAT
M.E.P. CONSULTANT
B.E. CIVIL

SYMBOL	DESCRIPTION
	Ø 110 mm Soil Waste Water Pipe
	Ø 110 mm Waste Water Pipe
	Ø 110 mm Rain Water Pipe
	Ø 160 mm Rain Water Pipe Slope 1:200
	Ø 110 mm Rain Water Pipe Slope 1:200
	RC-12"X12" Depth According to Slope
	RC-18"X18" Depth According to Slope
	RC-24"X24" Depth According to Slope
	Flow Direction

PROJECT TITLE :- PROPOSED BUILDING FOR FLATS, AT PLOT NO.- 1, 2, 3, 4 & 5, OF GOVIND BAGH PEARL SCHEME, VILLAGE - BEELWA KALA, TEH.- SANGANER , JAIPUR	DRAWING TITLE :- STILT FLOOR COMMON AREA WATER SUPPLY	SPACE CONSULTANT PLOT-A-173, JAGDAMBA NAGAR, HEERAPURA POWER HOWER, JAIPUR (RAJ) 302024	DRN. BY			NORTH
				DATE		
			APPD. BY		REVISION	
		SCALE	N.T.S			