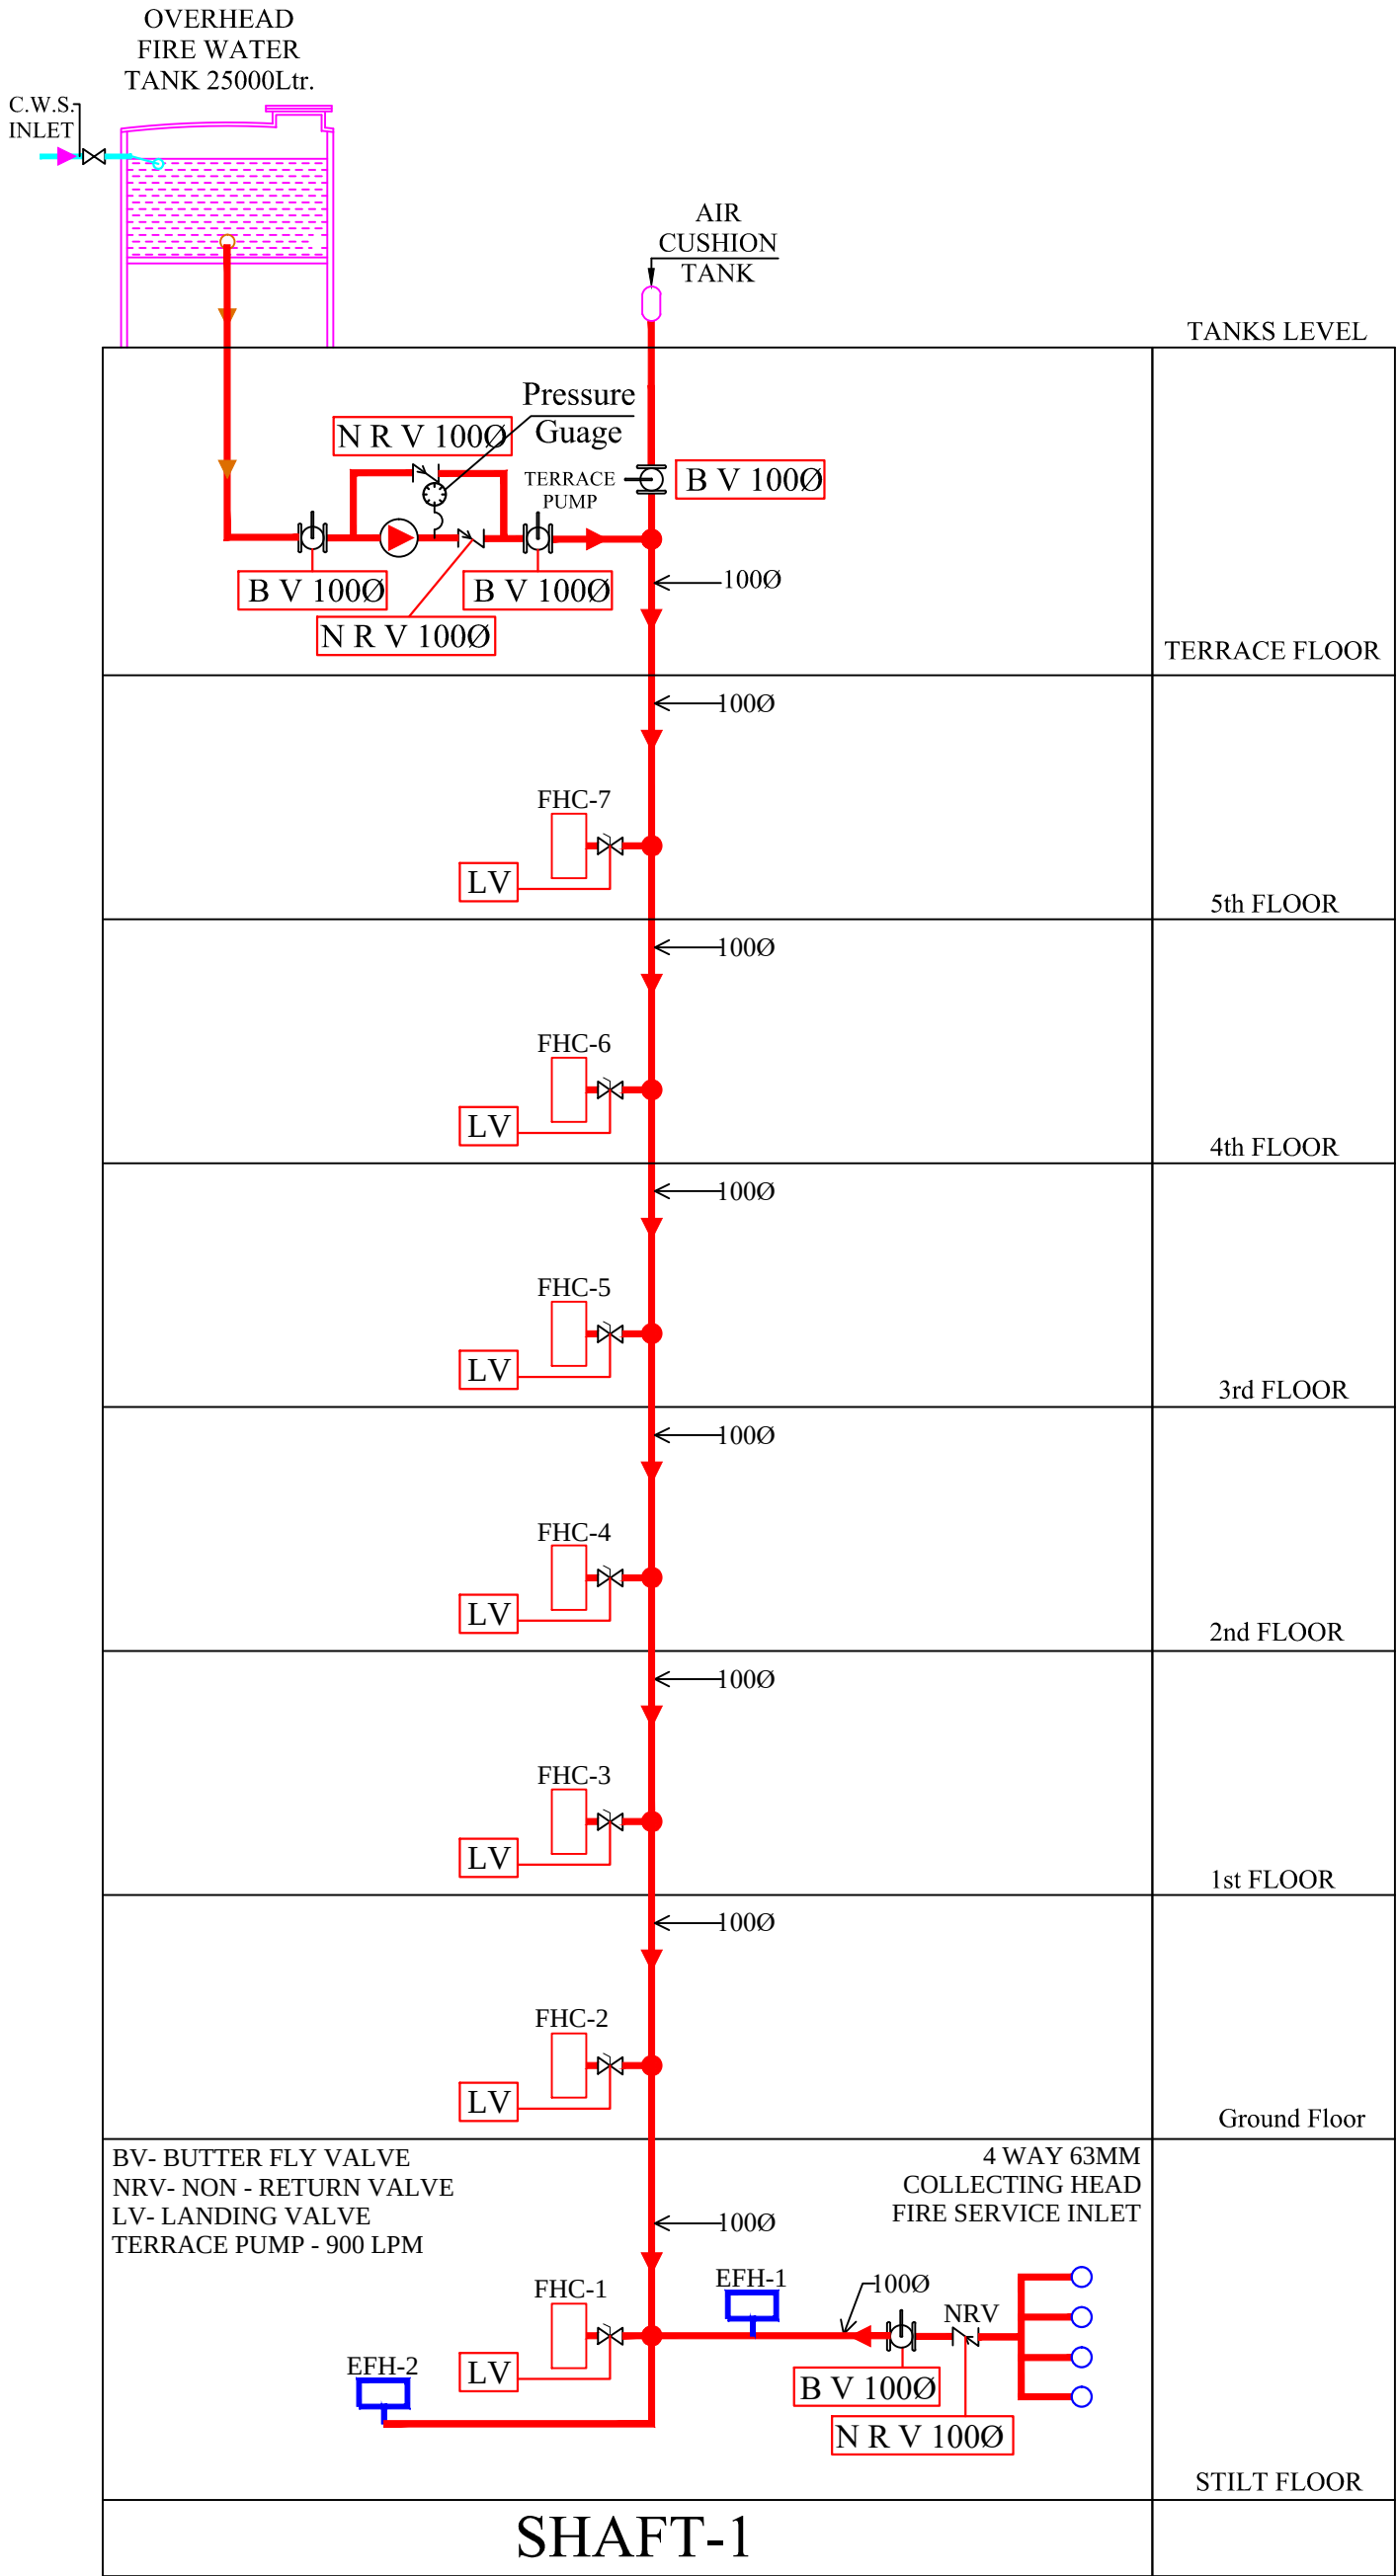
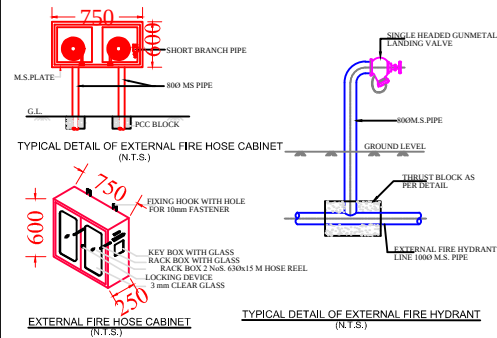
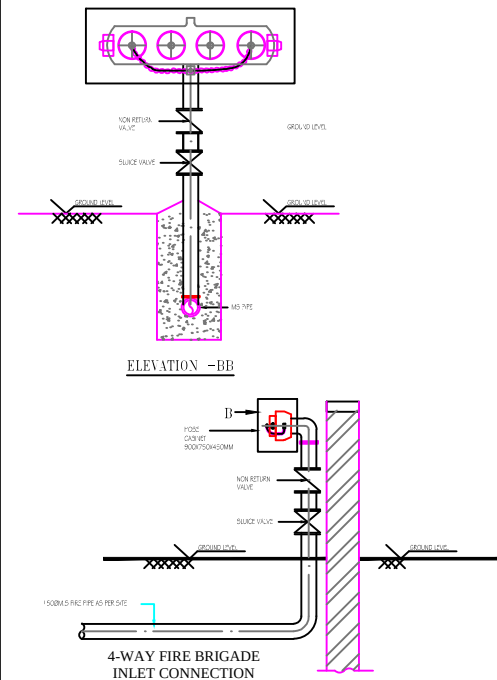


DRAWING: TYPICAL DETAIL FOR FIRE HOSE CABINET-1

SCALE: 1:10

FIG-3

S.no.	Symbol	Description	Qty.	Size in mm
1.		Butter fly Valve	04	100Ø
2.		Non Return Valve	03	100Ø
3.		Landing Valve Single headed	09	63Ø
4.		Pressure Gauge	01	
5.		FHC	07	
6.		External Fire Hose Cabinet	02	

SIGN:- SEAL:-

RAMESH KUMAR
M.E.P. CONSULTANT
B.E. CIVIL

SPACE CONSULTANT


PLOT-A-173, JAGDAMBA NAGAR, HEERAPURA
POWER HOWER, JAIPUR (RAJ) 302024

PROJECT :-

PROPOSED BUILDING AT PLOT NO- A-231,
A-232 & A-233, SHREE RAM NIKUNG-A,
VILLAGE:- RAMPURA URF
KANWERPURA TEH.-SANGANER, JAIPUR

DRAWING:-

FIRE SCHEMATIC LAYOUT

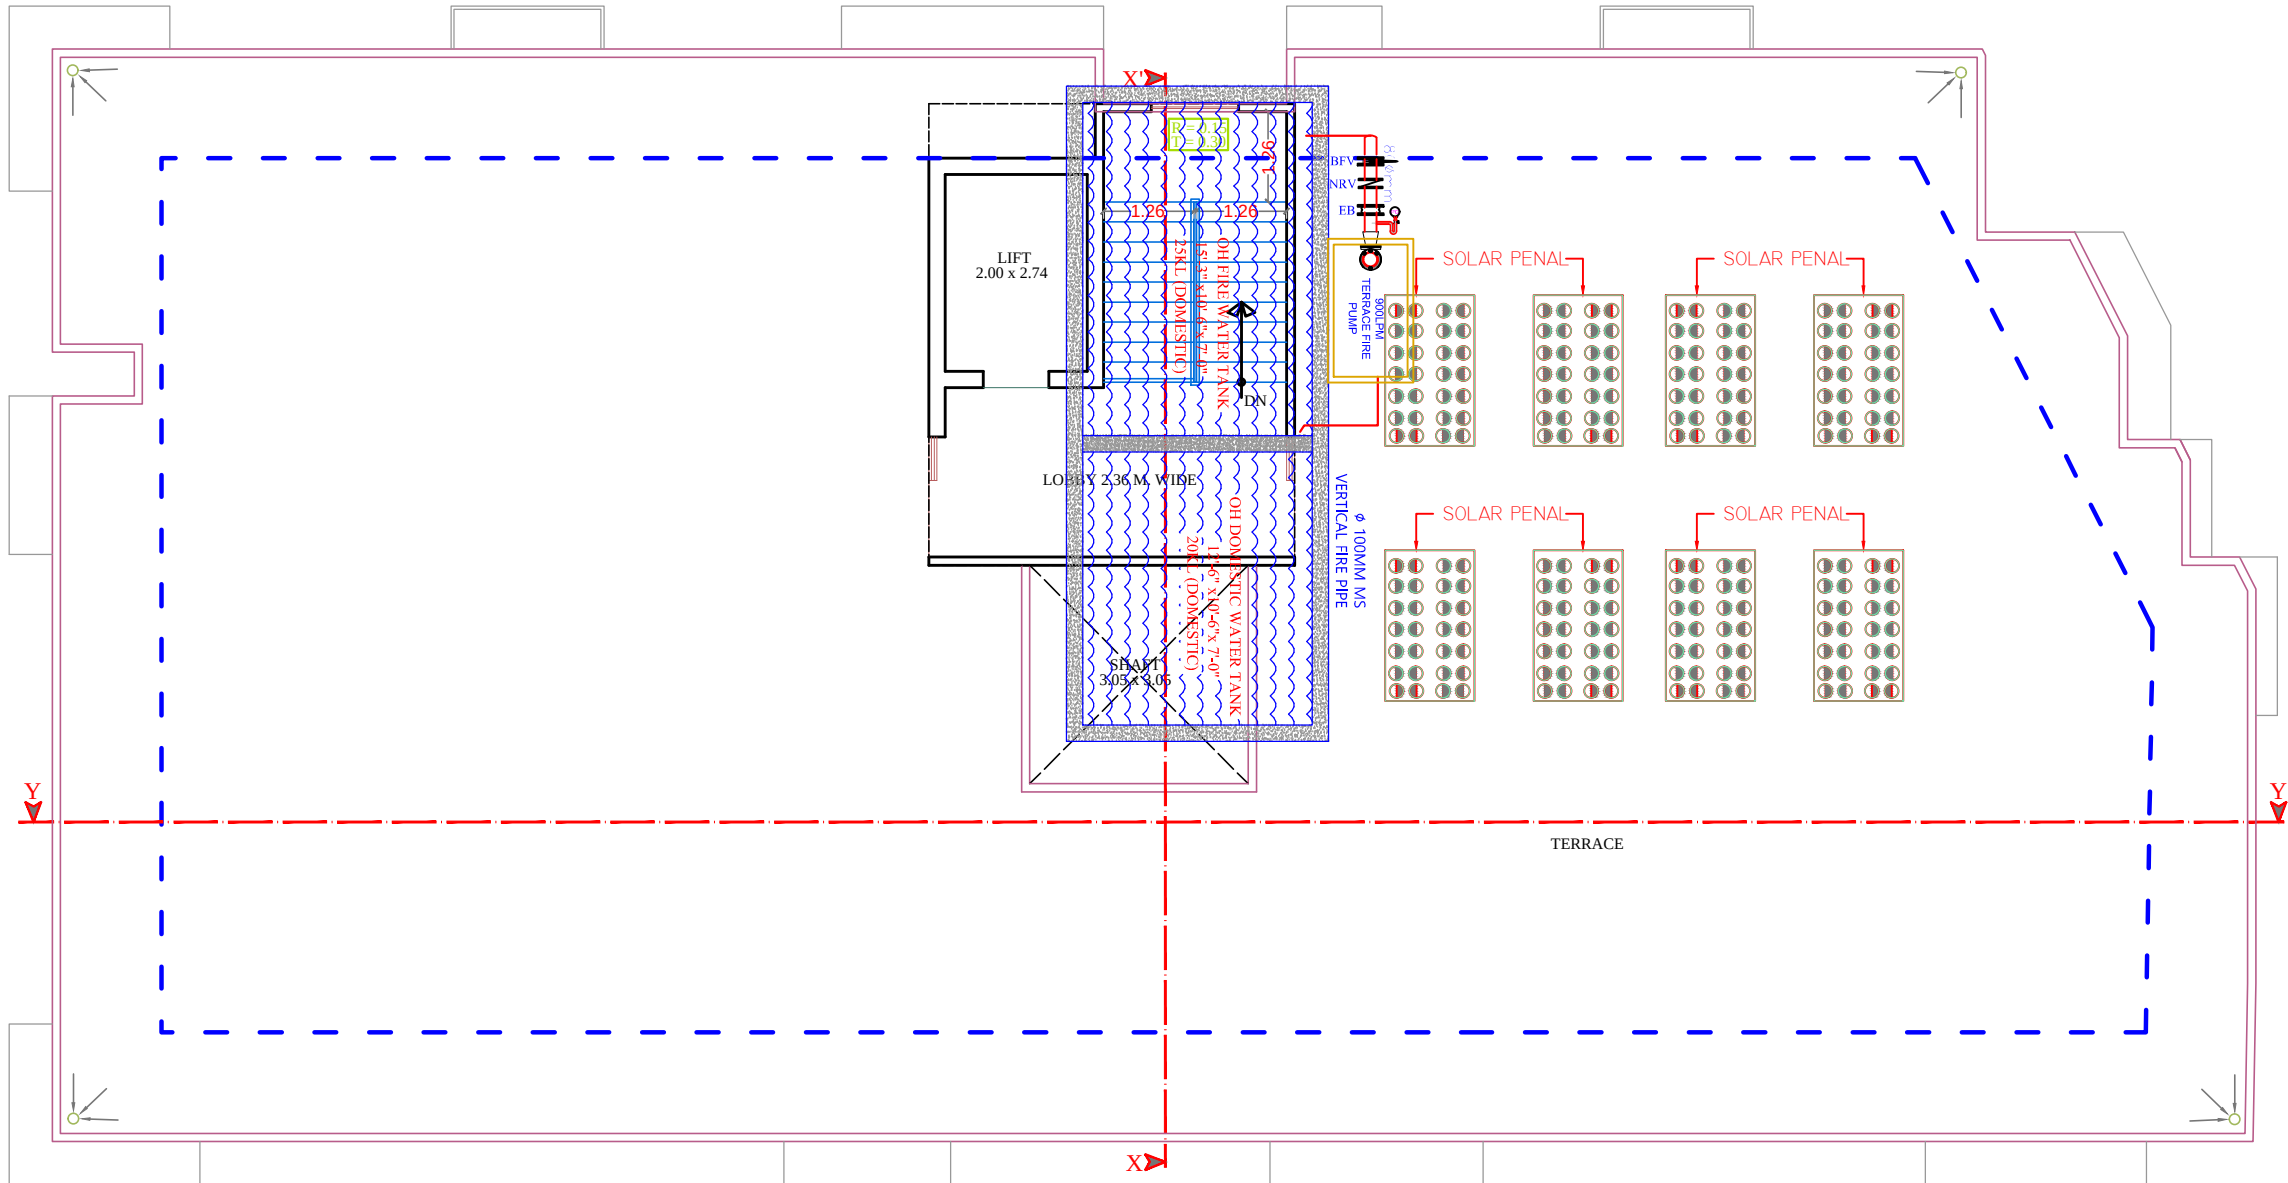

TERRACE FLOOR PLAN

RAMESH KUMAWAT
M.E.P. CONSULTANT
B.E. CIVIL

LEGENDS:			
SR NO.	Symbol	Description	Qty.
1.		HYDRANT	00
2.		HOSE REEL	00
3.		HOSE BOX	01
4.		FOUR WAY	00
5.		FIRE PUMP	01
6.		WATER TANK	01

PROJECT TITLE :-
PROPOSED BUILDING AT PLOT NO- A-231,
A-232 & A-233, SHREE RAM NIKUNG-A,
VILLAGE:- RAMPURA URF
KANWERPURA TEH.-SANGANER, JAIPUR

DRAWING TITLE :-
TARRACE FLOOR
FIRE FIGHTING

SPACE CONSULTANT

PLOT-A-173, JAGDAMBA NAGAR, HEERAPURA
POWER HOWER, JAIPUR (RAJ) 302024

DRN. BY


APPD. BY

SCALE

DATE

REVISION

NORTH

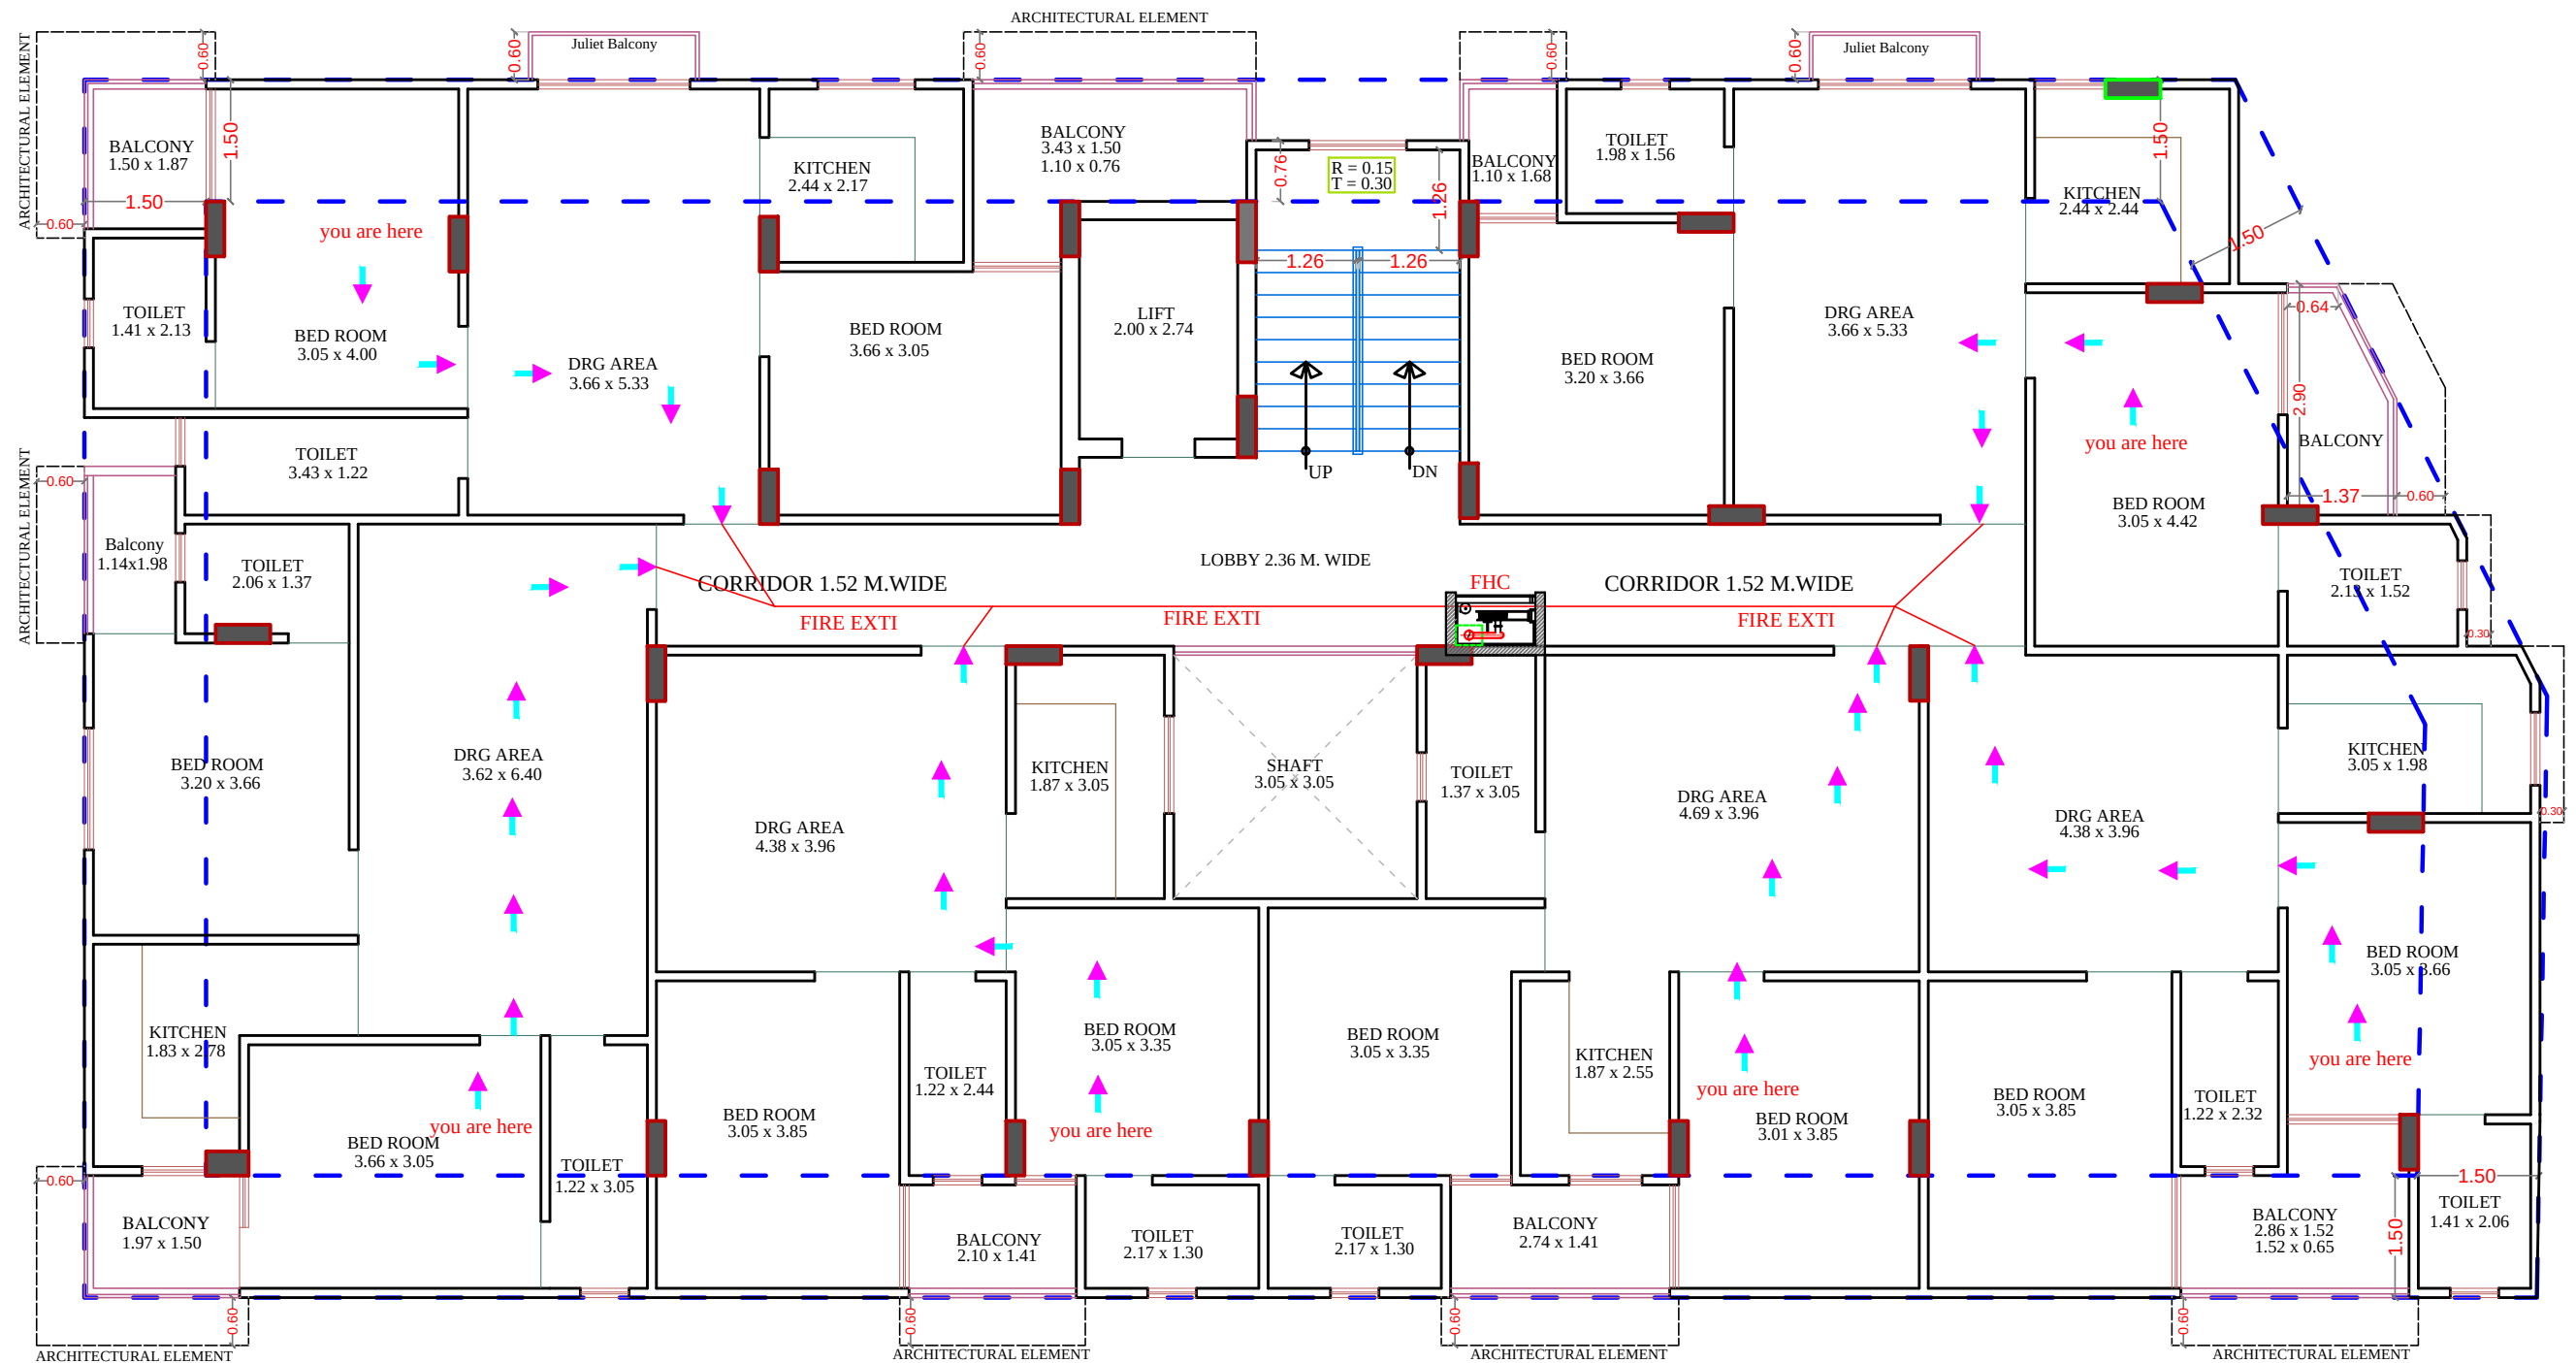

GROUND, 1st TO 5th FLOOR PLAN

Ramesh Kumawat
RAMESH KUMAWAT
M.E.P. CONSULTANT
B.E. CIVIL

PROJECT TITLE :-
PROPOSED BUILDING AT PLOT NO- A-231,
A-232 & A-233, SHREE RAM NIKUNG-A,
VILLAGE:- RAMPURA URF
KANWERPURA TEH.-SANGANER, JAIPUR

TYPICAL FLOOR FIRE FIGHTING LAYOUT

SPACE CONSULTANT
 PLOT-A-173, JAGDAMBA NAGAR, HEERAPURA
 POWER HOWER, JAIPUR (RAJ) 302024

DRN. BY

APPD. BY

NTS
SCALE

DATE

REVISION