


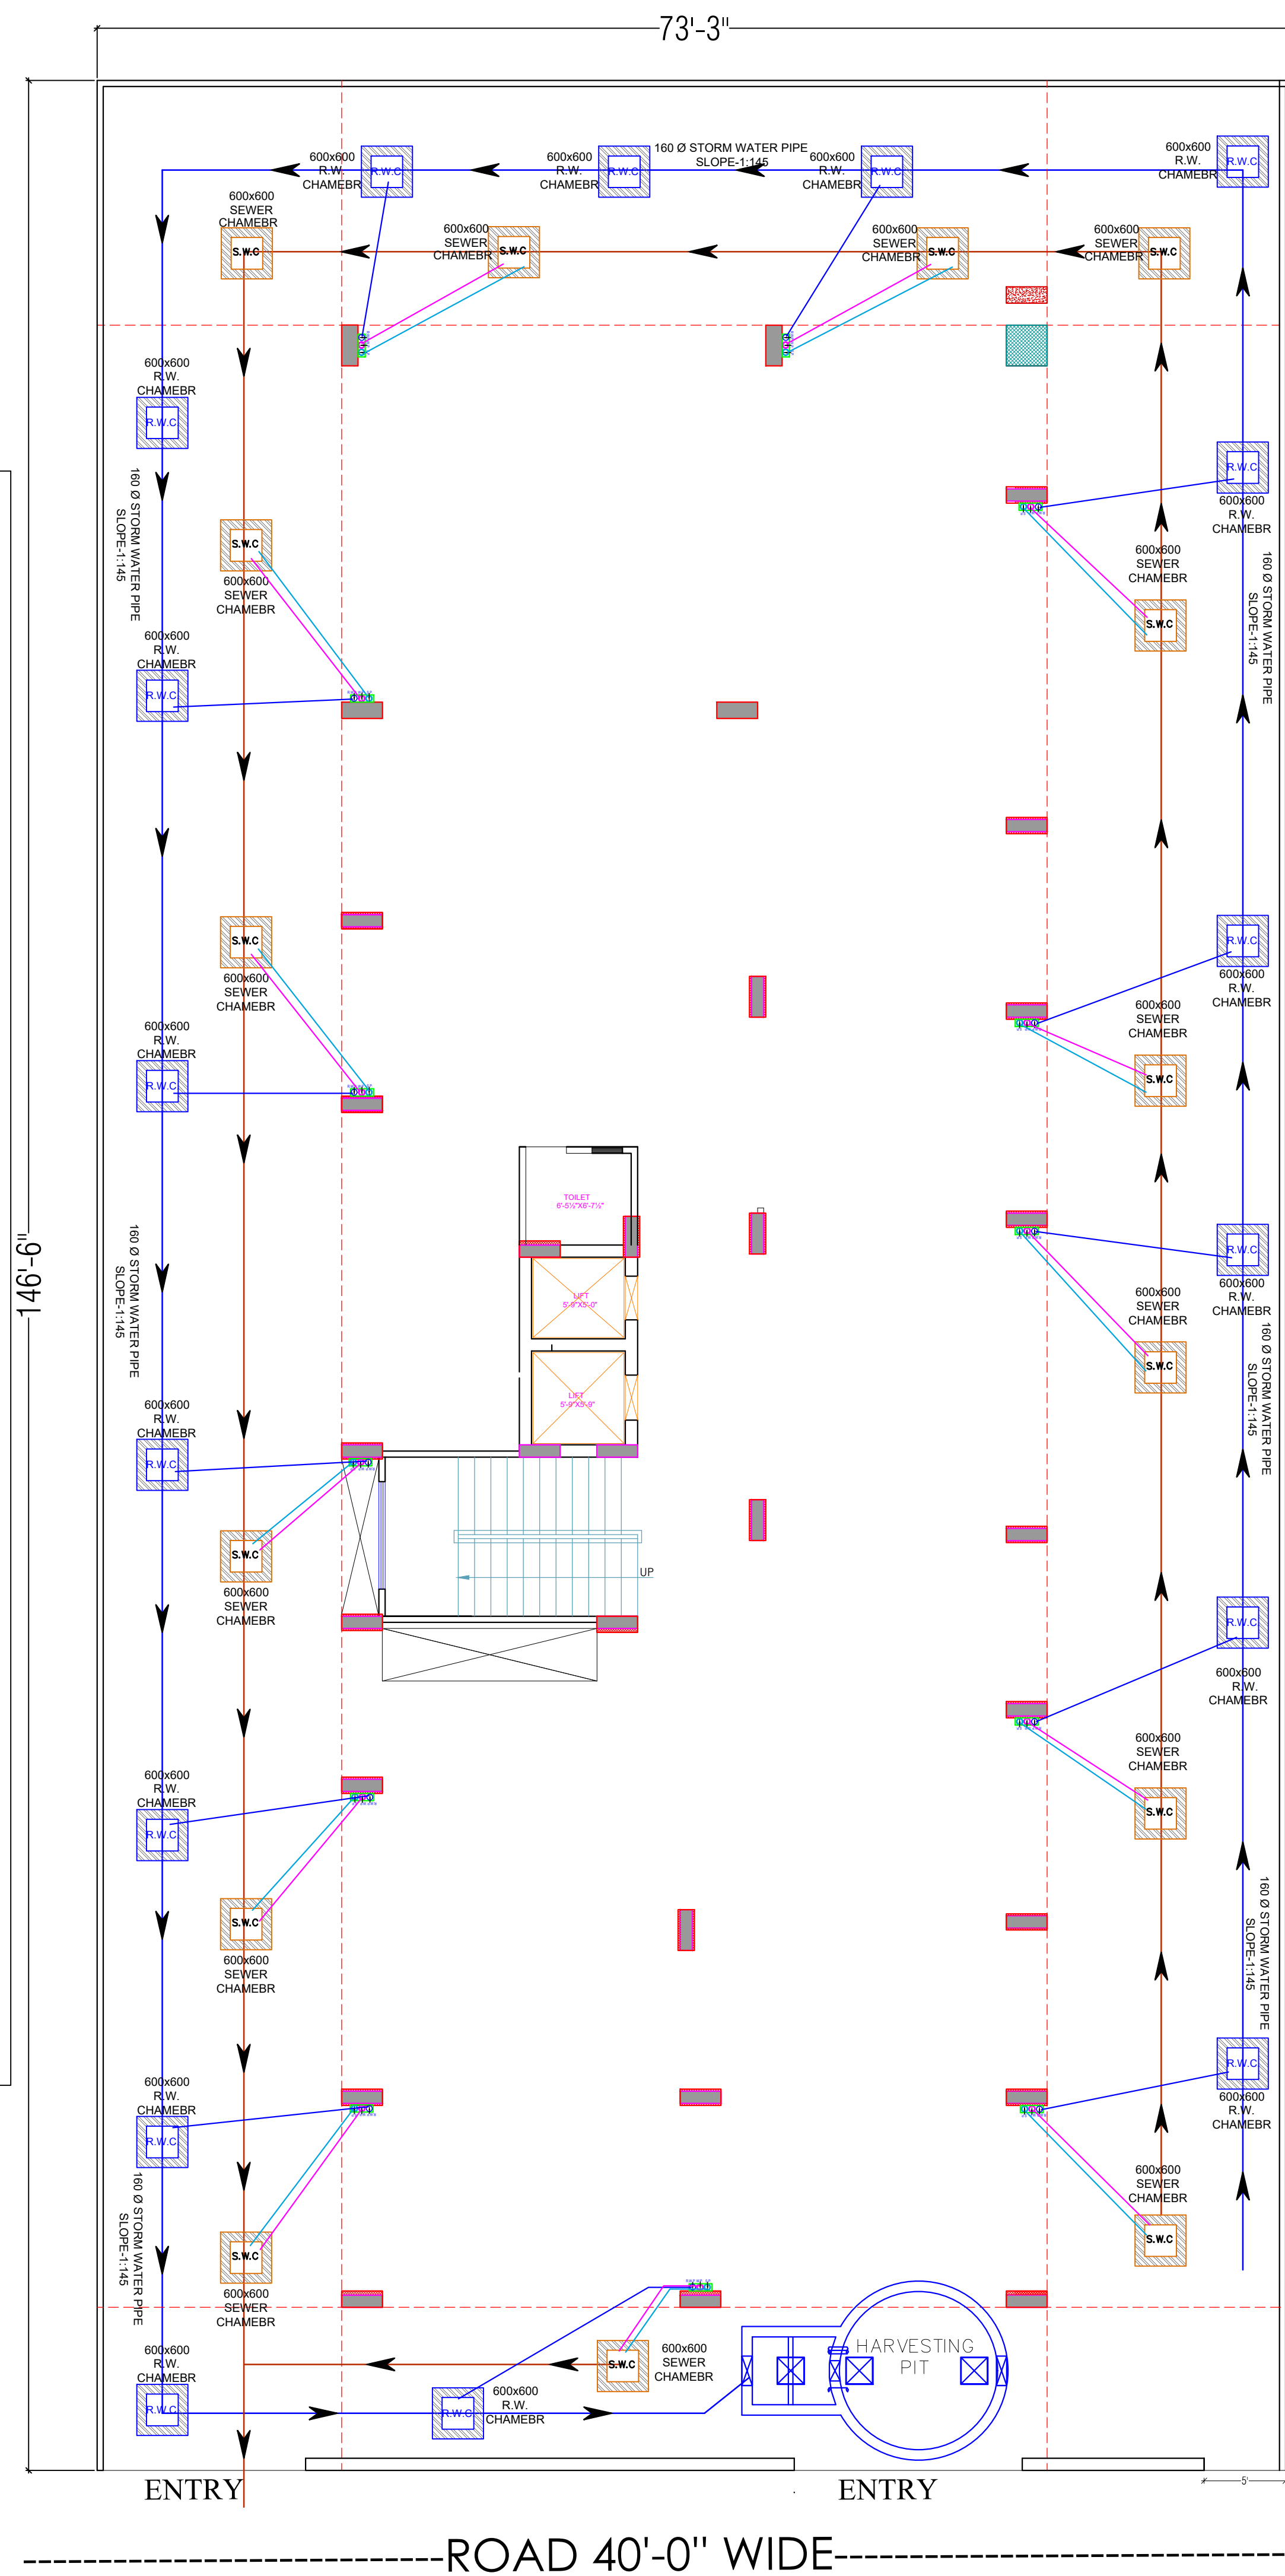

Sachin
SACHIN KUMAR
B. TECH. (CIVIL)

WARNING

1. This drawing is the sole copyright of Architects VISTAAR and should be used for the purpose expressly issued.

GENERAL NOTES

1. All dimensions are in feet and inches.
2. Do not scale this drawing follow written dimensions only.
3. This drawing should be read in conjunction with other architectural and structural drawings.
4. Any discrepancy in the drawing should be immediately brought to the notice of architect.

PROJECT TITLE

THE PARK VISTA
PROPOSED RESIDENTIAL
BUILDING AT KHASRA NO.-399/2 AT
REVENUR-VILL.-MOHANPURA,
TEH.-SANGANER,JAIPUR


DRAWING TITLE

3. SANITATION (STORM WATER DRAINAGE, SEWERAGE, STP, SOLID WASTE DISPOSAL) AND RAIN WATER HARVESTING PLAN

ARCHITECTS :

VISTAAR ARCHITECTS & PLANNERS
Architects :: Interior Designers
B-2/12, Chitarkoot scheme,
main Gandhi Path, Opp mall of jaipur, Jaipur
PH.- 0141-4116461, 09001010366

PATH :-			
DRN.	DATE	REV.	NORTH
MANOJ KUMAWAT	12-08-2026		
SCALE	JOB NO.		
N.T.S			

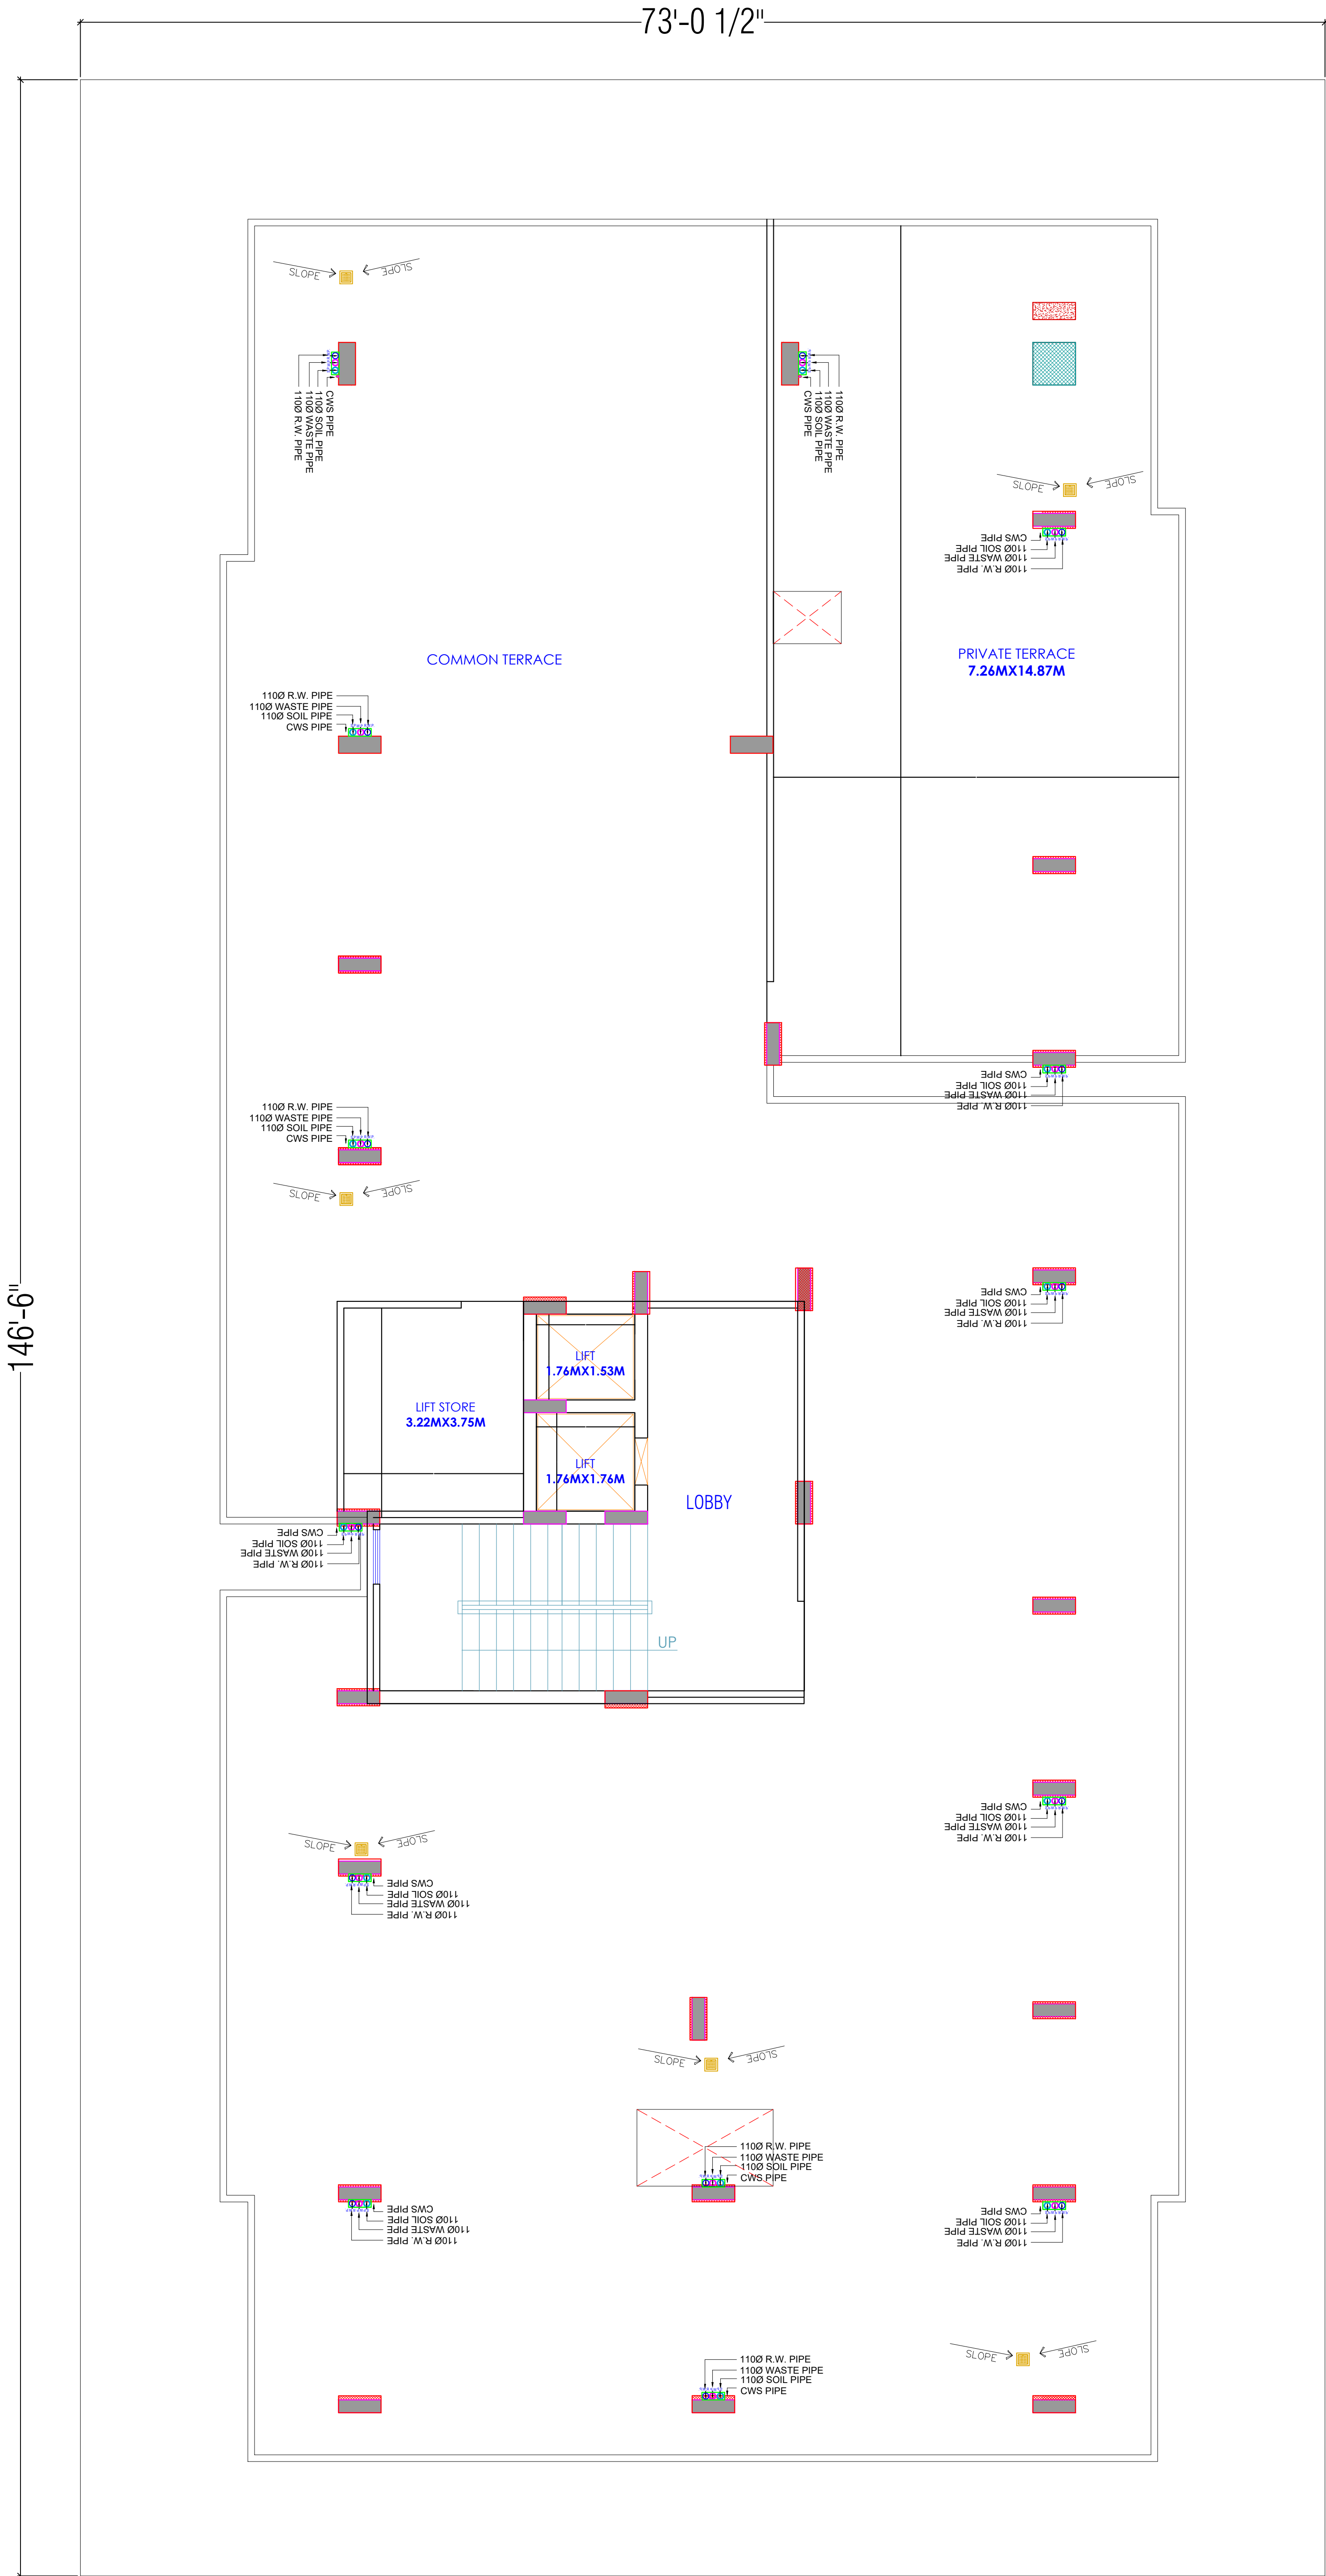

LEGENDS		
S.NO.	SYMBOL	DESCRIPTION
1.		SDR-11 Fresh Water Pipe
2.		SDR-11 Solar Water Pipe
3.		Waste Water Pipe (W.P.)
4.		Soil Pipe (S.P.)
5.		Rain Water Pipe (R.W.P.)
6.		Butter Fly Valve(B.F.V.)
7.		Geyser
8.		RO
9.		Single Lever Diverter
10.		Concealed Valve
11.		Angle Valve
12.		Nahani Trap
13.		P-Trap
14.		Tap
15.		Floor Drain (F.D.)
16.		Plain Tee (P-tee)
17.		Gully Trap (G.T.)
18.		

FOR SHREE SALASAR DEVELOPERS
Sachin
PROPRIETOR

Sachin
SACHIN KUMAR
B. TECH. (CIVIL)

WARNING

1. This drawing is the sole copyright of Architects **VISTAAR** and should be used for the purpose expressly issued.

GENERAL NOTES

1. All dimensions are in feet and inches.
2. Do not scale this drawing follow written dimensions only.
3. This drawing should be read in conjunction with other architectural and structural drawings.
4. Any discrepancy in the drawing should be immediately brought to the notice of architect.

PROJECT TITLE

THE PARK VISTA
PROPOSED RESIDENTIAL
BUILDING AT KHASRA NO.-399/2 AT
REVENUR-VILL.-MOHANPURA,
TEH.-SANGANER,JAIPUR

DRAWING TITLE

**TERRACE FLOOR
DRAINAGE LAYOUT**

ARCHITECTS :

VISTAAR ARCHITECTS & PLANNERS
Architects :: Interior Designers
B-2/12, Chitrkoot scheme,
main Gandhi Path,Opp mall of jaipur,Jaipur
PH.- 0141-4116461,09001010366

PATH --			
DRN.	DATE	REV.	NORTH
MANGJ KUMAWAT	12-08-2026		
SCALE	JOB NO.		
N.T.S			