

PROJECT NAME :  
  
SHRI VINAYAK HOME - IV

DEVELOPER NAME:  
  
N.S. RESIDENCY  
Proprietorship\_NATHU RAM

ARCHITECTS :  
  
4 INSIDE  
ARCHITECTURE N INTERIORS  
Plot no. 72, S.P. Marg, C- Scheme  
jaipur, rajasthan, India  
cont: +91 9950595991, 91 9982812777  
e.mail: jeets.arch@gmail.com

STRUCTURAL CONSULTANTS:

SERVICES CONSULTANTS:  
  
Er. SANJEEV SHARMA  
B.E (Electrical)

| LEGEND:- |                               |           |
|----------|-------------------------------|-----------|
| ①        | SOIL PIPE                     |           |
| ②        | WASTE PIPE                    |           |
| ③        | VENT PIPE                     |           |
| ④        | COLD WATER SUPPLY (CWS)       |           |
| ⑤        | HOT WATER SUPPLY (HWS)        |           |
|          | RAIN WATER PIPE               |           |
| SW       | SEWER LINE- EXTERNAL          |           |
| RW       | STORM WATER DRAINAGE PIPE     |           |
|          | SEWERAGE MANHOLE              | M.H.      |
|          | STORM WATER MANHOLE           | M.H.      |
| GT       | GULLY TRAP                    |           |
| BV       | BALL VALVE                    |           |
| FT       | FLOOR TRAP                    |           |
| FD       | FLOOR FLOOR DRAIN             |           |
|          | RAIN WATER COLLECTION CHAMBER | 450X450MM |
|          | KHURRA                        |           |

- GENERAL NOTES:
- All dimension on this drawing are in MKS System Only written dimensions are to be followed. drawing should not be scaled.
  - All measurements must be checked and verified by the contractors prior to execution of work at the site.
  - This drawing is to be read in conjunction with all relevant structural, services & facility planning drawings.
  - Architectural drawings are to be followed for the location of all structural members & masonry walls, for sizes & reinforcement details of structural members, relevant structural drawings are to be referred.
  - Any discrepancies between architectural, structural & services drawings must be brought to the notice of the architects immediately & prior to execution at site. Co-ordination with services such as hvac, plumbing & electrical, etc. is the responsibility of the contractors.
  - All masonry walls should be aligned with the columns as indicated on the plan, irrespective of the position as calculated with the dimensioning.
  - For details, refer relevant large scale detail drgs. as indicated.

PROJECT:  
  
PROPOSED RESIDENTIAL BUILDING ON P. NO.- 34-A & 34 PRITHVIRAJ NAGAR, (BALRAMPURA URF KHEJARO KA BAS) , JAIPUR

NAME OF DRAWING:  
  
STILT FLOOR  
WATER SUPPLY

DRAWN BY:  
Banwari Lal

APPROVED BY:  
JITENDRA SHARMA

DRAWING  
WORKING DRAWING

NORTH:

PROJECT NO.:  
DATE:  
12-02-2024

SCALE:  
NTS


REV NO.:  
R-0

DRAWING NO.:  
PROJECT CATEGORY BLOCK FLOOR TYPE NUMBER

A-02

For N S RESIDENCY  
Nathu Ram  
Proprietor

80'-0" WIDE ROAD  
STILT FLOOR WATER SUPPLY

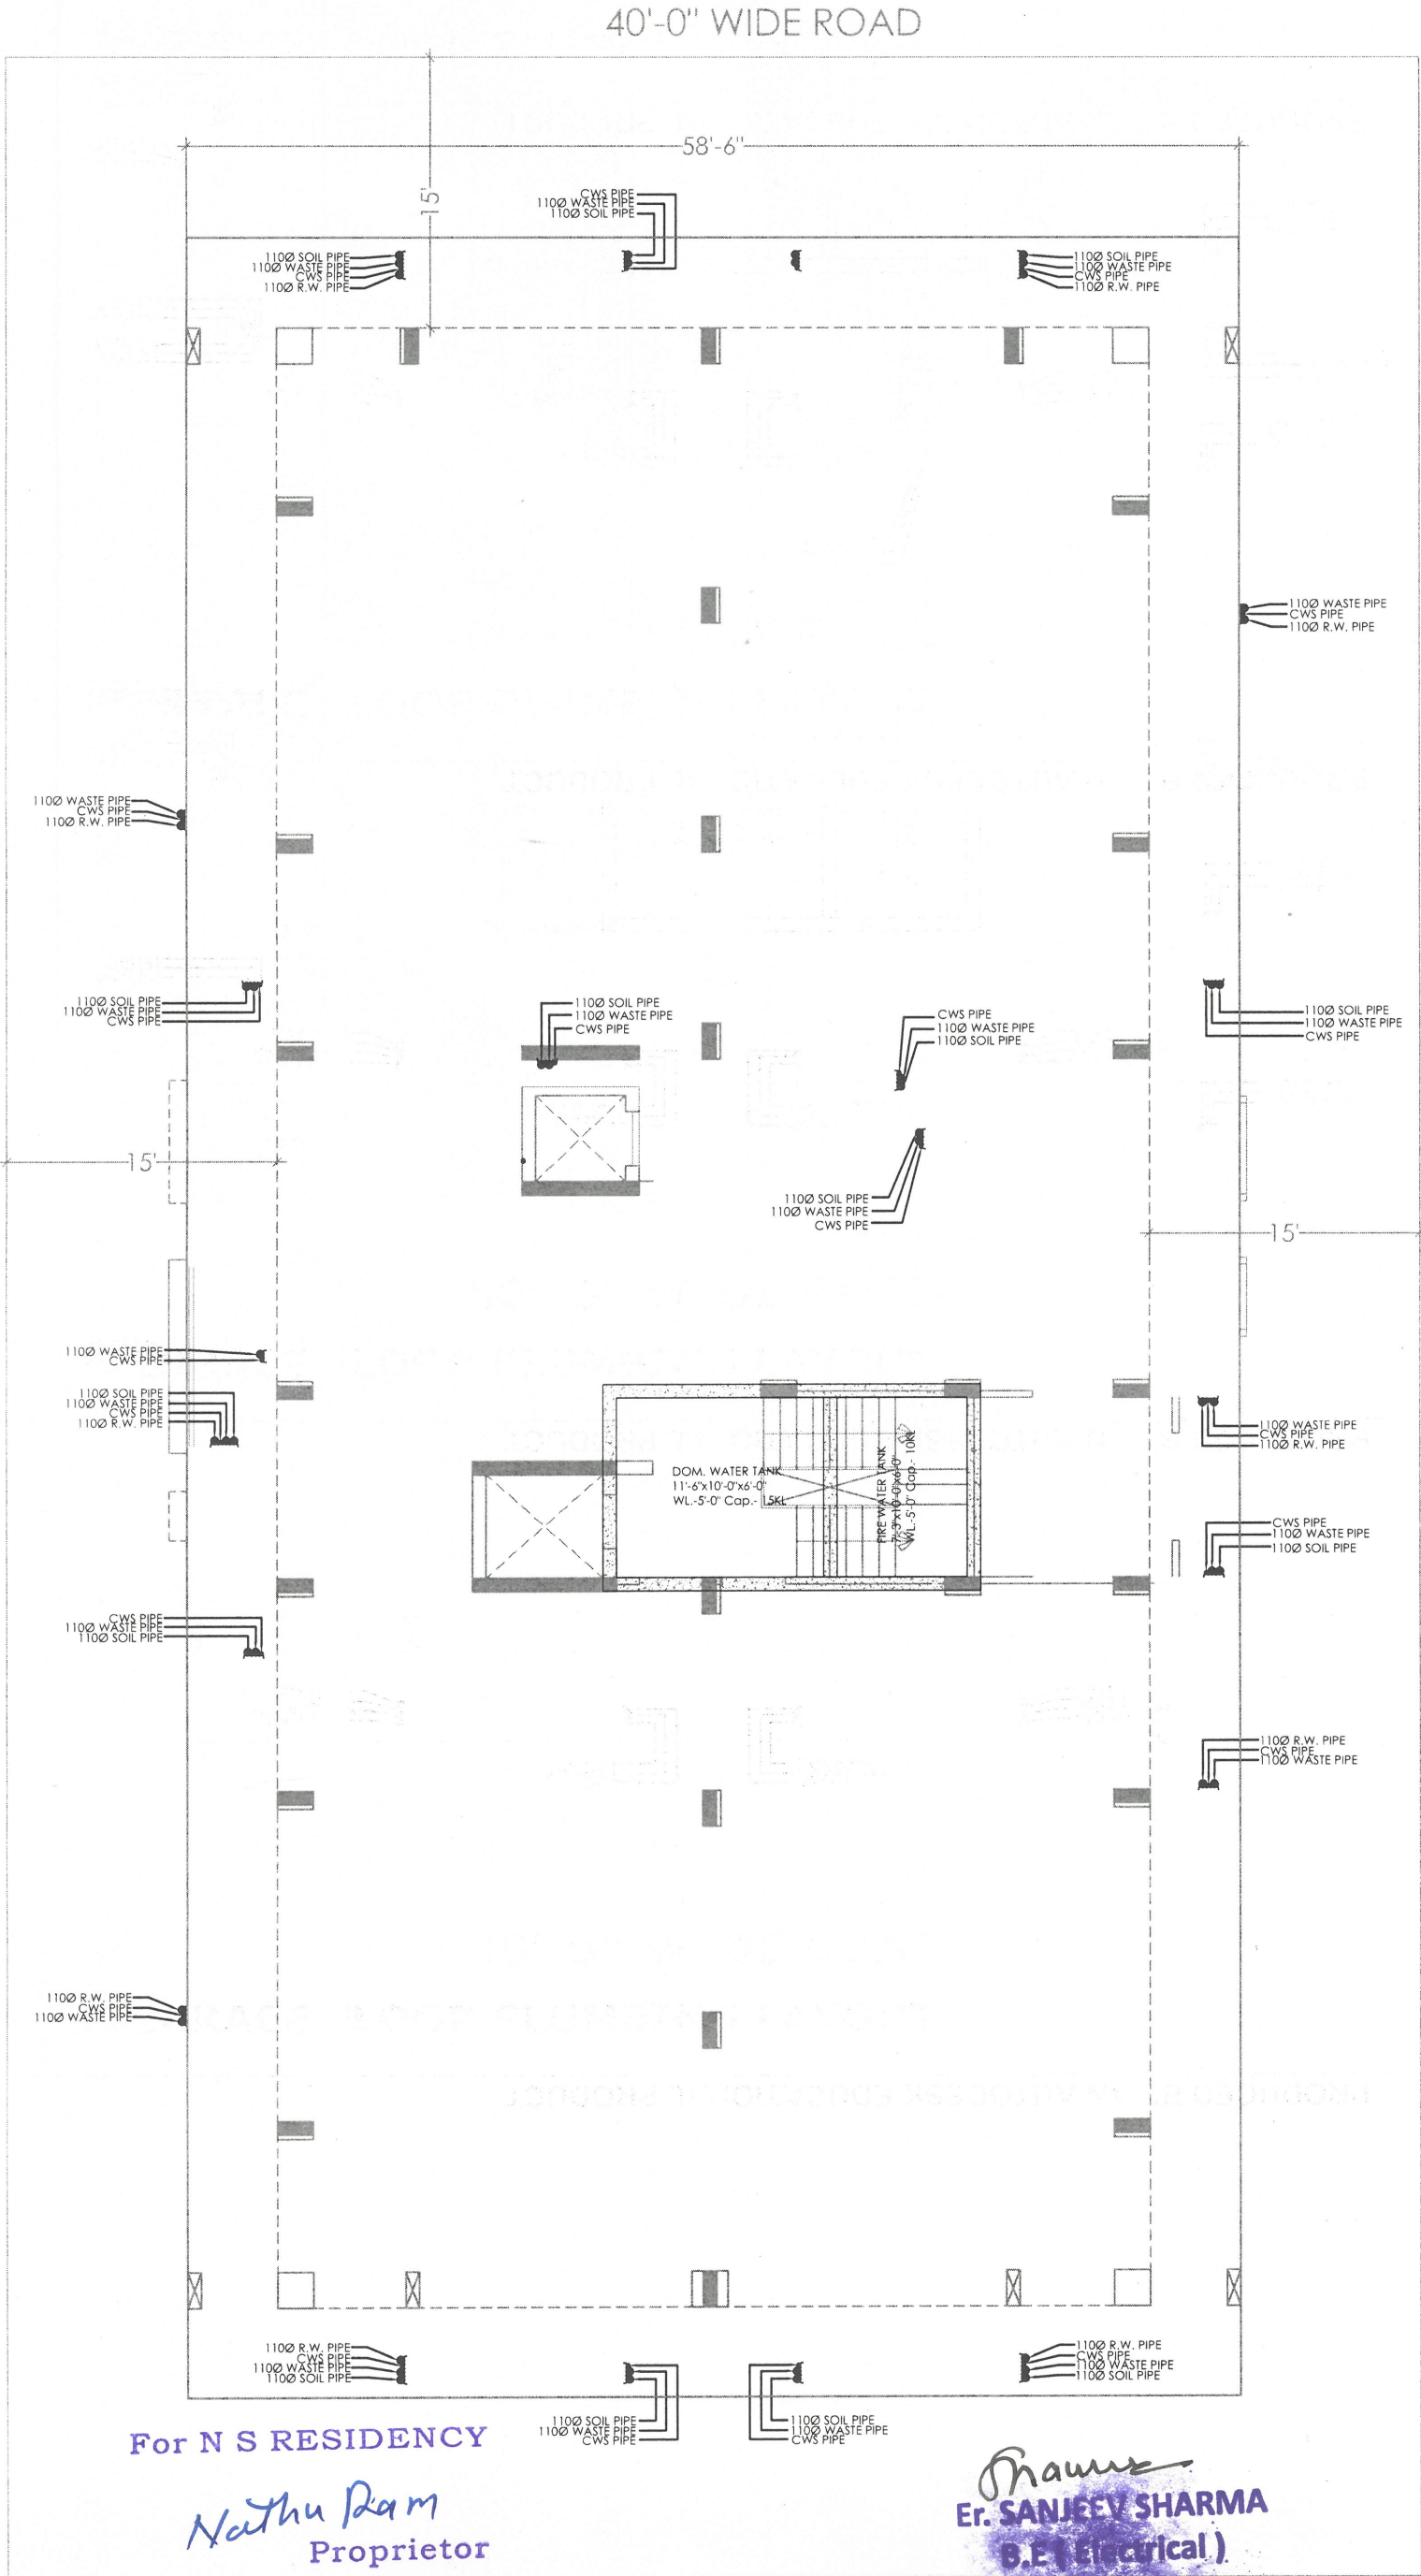

PROJECT NAME :

SHRI VINAYAK HOME - IV

DEVELOPER :

N.S. RESIDENCY  
Proprietorship\_NATHU RAM

ARCHITECTS :

INSIDE  
ARCHITECTURE N INTERIORS  
Plot no. 72, S.P. Marg, C- Scheme  
jaipur, rajasthan, India  
cont: +91 9950595991, 91 9982812777  
e.mail: jeets.arch@gmail.com

STRUCTURAL CONSULTANTS:

MEP CONSULTANT : --  
SHRI SHYAM CONSULTANT  
PLUMBING ! FIRE ! ELECTRICAL ! STP !WTP  
JAIPUR-302006  
PH.NO. +91 9785427711

DEALT BY RAMESH REVISION 00 DATE: 15.10.2023

| LEGEND:- |                                         |      |
|----------|-----------------------------------------|------|
| ①        | SOIL PIPE                               |      |
| ②        | WASTE PIPE                              |      |
| ③        | VENT PIPE                               |      |
| ④        | COLD WATER SUPPLY (CWS)                 |      |
| ⑤        | HOT WATER SUPPLY (HWS)                  |      |
|          | RAIN WATER PIPE                         |      |
| SW       | SEWER LINE- EXTERNAL                    |      |
| RW       | STORM WATER DRAINAGE PIPE               |      |
|          | SEWERAGE MANHOLE                        | M.H. |
|          | STORM WATER MANHOLE                     | M.H. |
| GT       | GULLY TRAP                              |      |
| BV       | BALL VALVE                              |      |
| FT       | FLOOR TRAP                              |      |
| FD       | FLOOR FLOOR DRAIN                       |      |
|          | RAIN WATER COLLECTION CHAMBER 450X450MM |      |
|          | KHURRA                                  |      |

| S.No           | DATE                                                                                                                                                                                                            | REVISION DESCRIPTION |
|----------------|-----------------------------------------------------------------------------------------------------------------------------------------------------------------------------------------------------------------|----------------------|
| GENERAL NOTES: |                                                                                                                                                                                                                 |                      |
| 1.             | All dimension on this drawing are in MKS System. Only written dimensions are to be followed. drawing should not be scaled.                                                                                      |                      |
| 2.             | All measurements must be checked and verified by the contractors prior to execution of work at the site.                                                                                                        |                      |
| 3.             | This drawing is to be read in conjunction with all relevant structural, services & facility planning drawings.                                                                                                  |                      |
| 4.             | Architectural drawings are to be followed for the location of all structural members & masonry walls. for sizes & reinforcement details of structural members, relevant structural drawings are to be referred. |                      |
| 5.             | Any discrepancies between architectural, structural and services drawings must be brought to the notice of the architects immediately & prior to execution at site.                                             |                      |
| 6.             | Co-ordinate with services such as hvac, plumbing & electrical, etc. is the responsibility of the contractors.                                                                                                   |                      |
| 7.             | All masonry walls should be aligned with the columns as indicated on the plan, irrespective of the position as calculated with the dimensioning.                                                                |                      |
| 8.             | For details, refer relevant large scale detail dgs. as indicated.                                                                                                                                               |                      |

PROJECT:  
PROPOSED RESIDENTIAL BUILDING ON  
P. NO.- 34-A & 34 PRITHVIRAJ NAGAR,  
(BALRAMPURA URF KHEJARO KA BAS)  
, JAIPUR

NAME OF DRAWING:  
**TERRACE FLOOR  
WATER SUPPLY**

DRAWN BY: Banwari lal APPROVED BY: JITENDRA SHARMA

DRAWING: WORKING DRAWING NORTH:

PROJECT NO. : DATE: 12-02-2024

SCALE: NTS REV NO. : R-0

DRAWING NO. :

A-02