



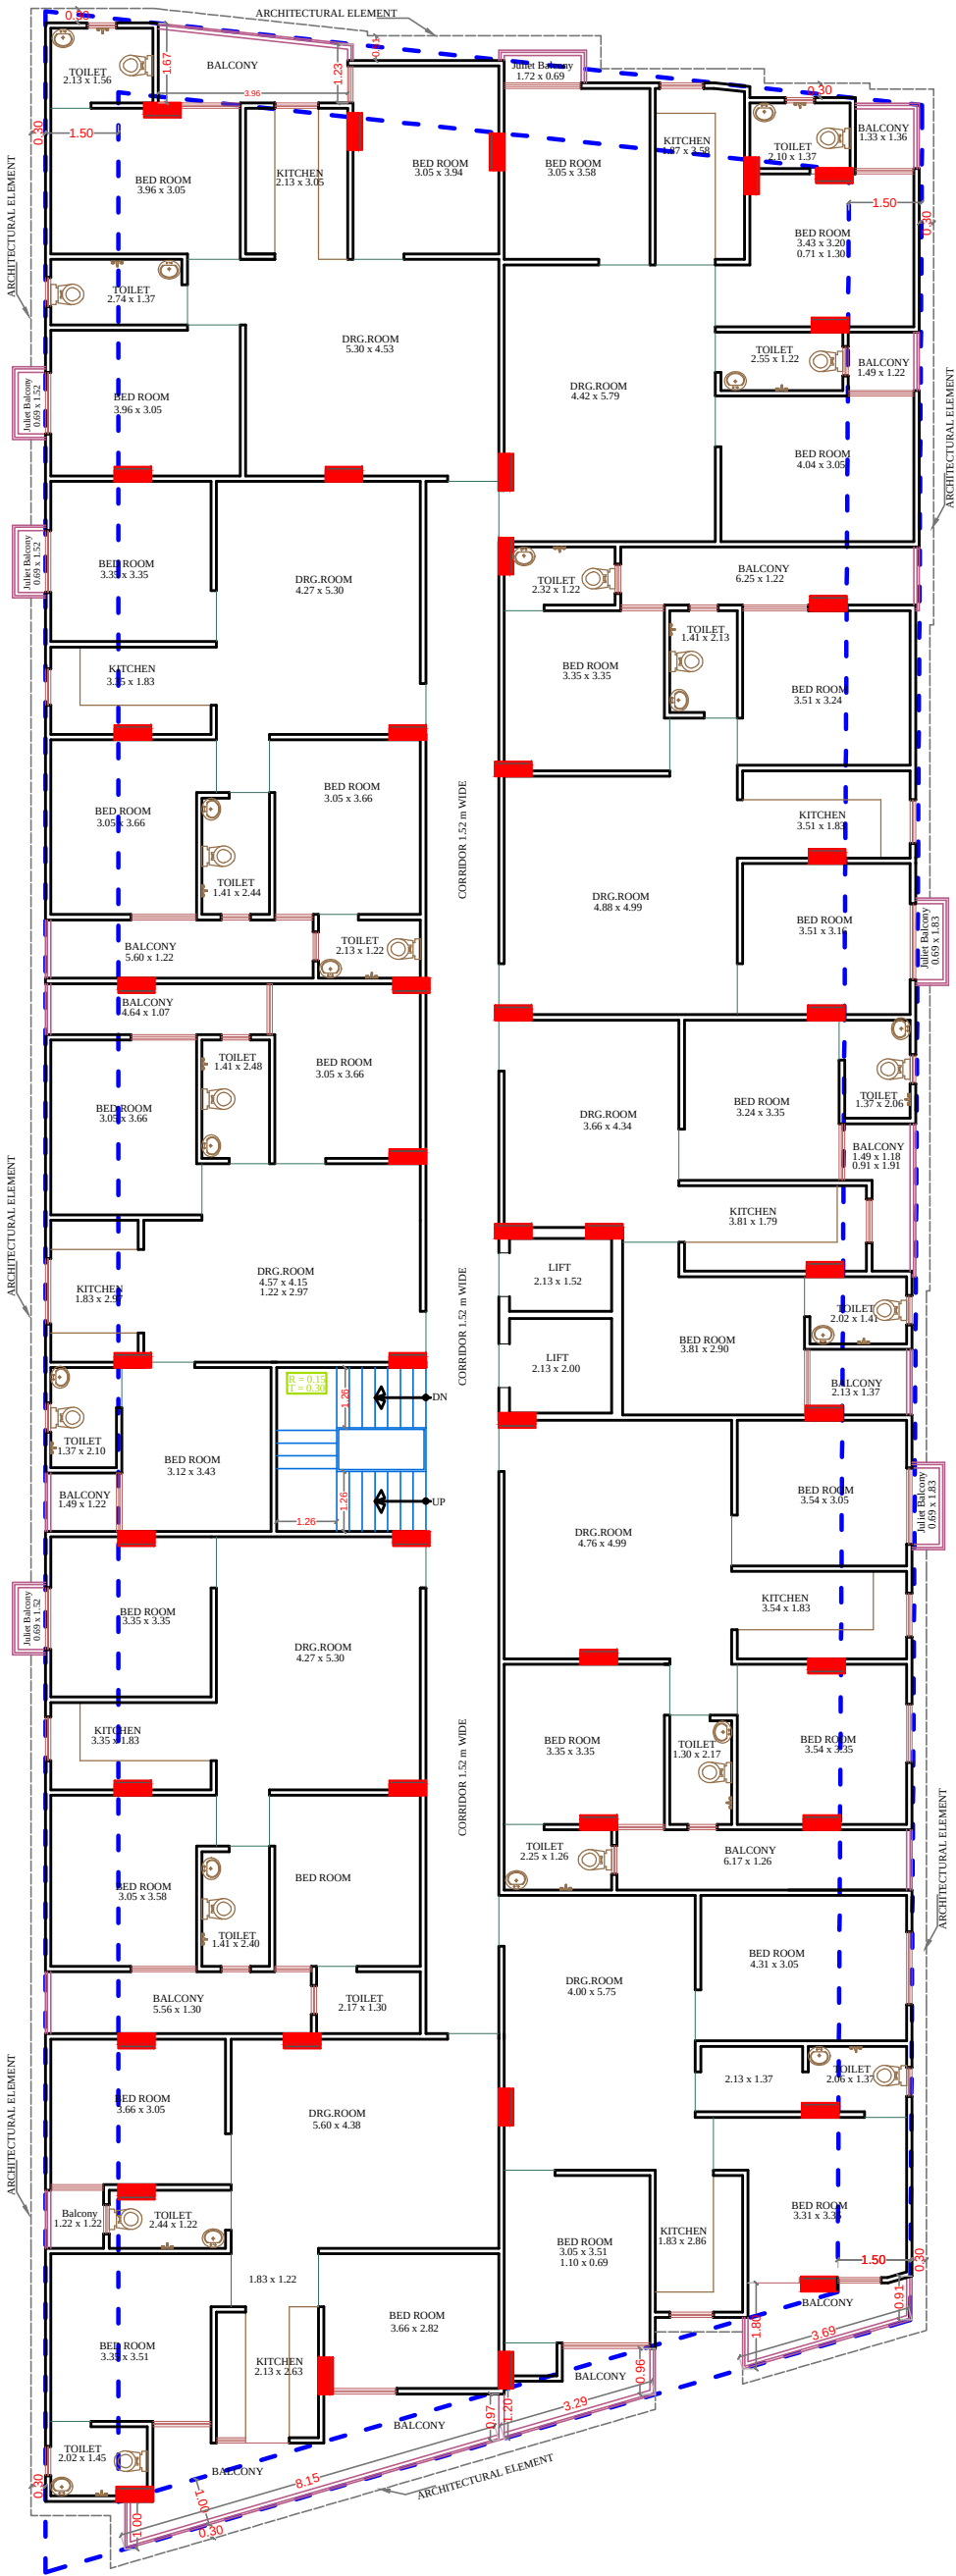

All Heights For Finish Floor Lvl	SYMBOL	SYMBOL	DESCRIPTION
-1000MM			Ø 20MM CWS PIPE THRU WALL CHASE TO SINK
			Ø 20MM HWS PIPE THRU WALL CHASE TO SINK
+1950MM			Ø 20MM CWS PIPE THRU WALL CHASE TO GEYSER
+1500MM			Ø 20MM CWS PIPE THRU WALL CHASE TO AQUAGUARD
+450MM			Ø 20MM CWS PIPE THRU WALL CHASE TO BASIN ANGLE VALVE
+800MM			Ø 20MM HWS PIPE THRU WALL CHASE TO BASIN ANGLE VALVE
+2100MM			Ø 20MM CWS PIPE THRU WALL CHASE TO CONCEALED STOP COCK
+300MM			Ø 20MM CWS PIPE THRU WALL CHASE TO FAUCET
+1000MM WALL MIXER DIVERTOR			Ø 20MM CWS PIPE THRU WALL CHASE TO WALL MIXER / DIVERTOR
+800MM GUSHOWER			Ø 20MM HWS PIPE THRU WALL CHASE TO WALL MIXER / DIVERTOR
+600MM			Ø 20MM CWS PIPE THRU WALL CHASE TO TAP
+450MM			Ø 20MM CWS PIPE THRU WALL CHASE TO CISTERN ANGLE VALVE
+1200MM			Ø 20MM CWS PIPE THRU WALL CHASE TO URINAL ANGLE VALVE
+450MM			Ø 20MM CWS PIPE THRU WALL CHASE TO BASIN ANGLE VALVE
+1000MM	AS PER/ARCH.		SOAP DISH
+1500MM	AS PER/ARCH.		TOWEL RAIL
+450MM	AS PER/ARCH.		PAPER HOLDER
			COLD WATER SUPPLY LINE
			HOT WATER SUPPLY LINE

RAMESH KUMAWAT
M.E.P. CONSULTANT
B.E. CIVIL

PROJECT TITLE :- PROPOSED BUILDING AT KHASARA NO-3401/2403 (OLD) 3405/3401 (NEW) IN VILLAGE-SIROLI, SANGANER,JAIPUR	DRAWING TITLE :- TYPICAL FLOOR PLUMBING	SPACE CONSULTANT PLOT-A-173, JAGDAMBA NAGAR, HEERAPURA POWER HOWER, JAIPUR (RAJ) 302024	DRN. BY		DATE	NORTH
			APPD. BY		REVISION	
			SCALE	N.T.S		

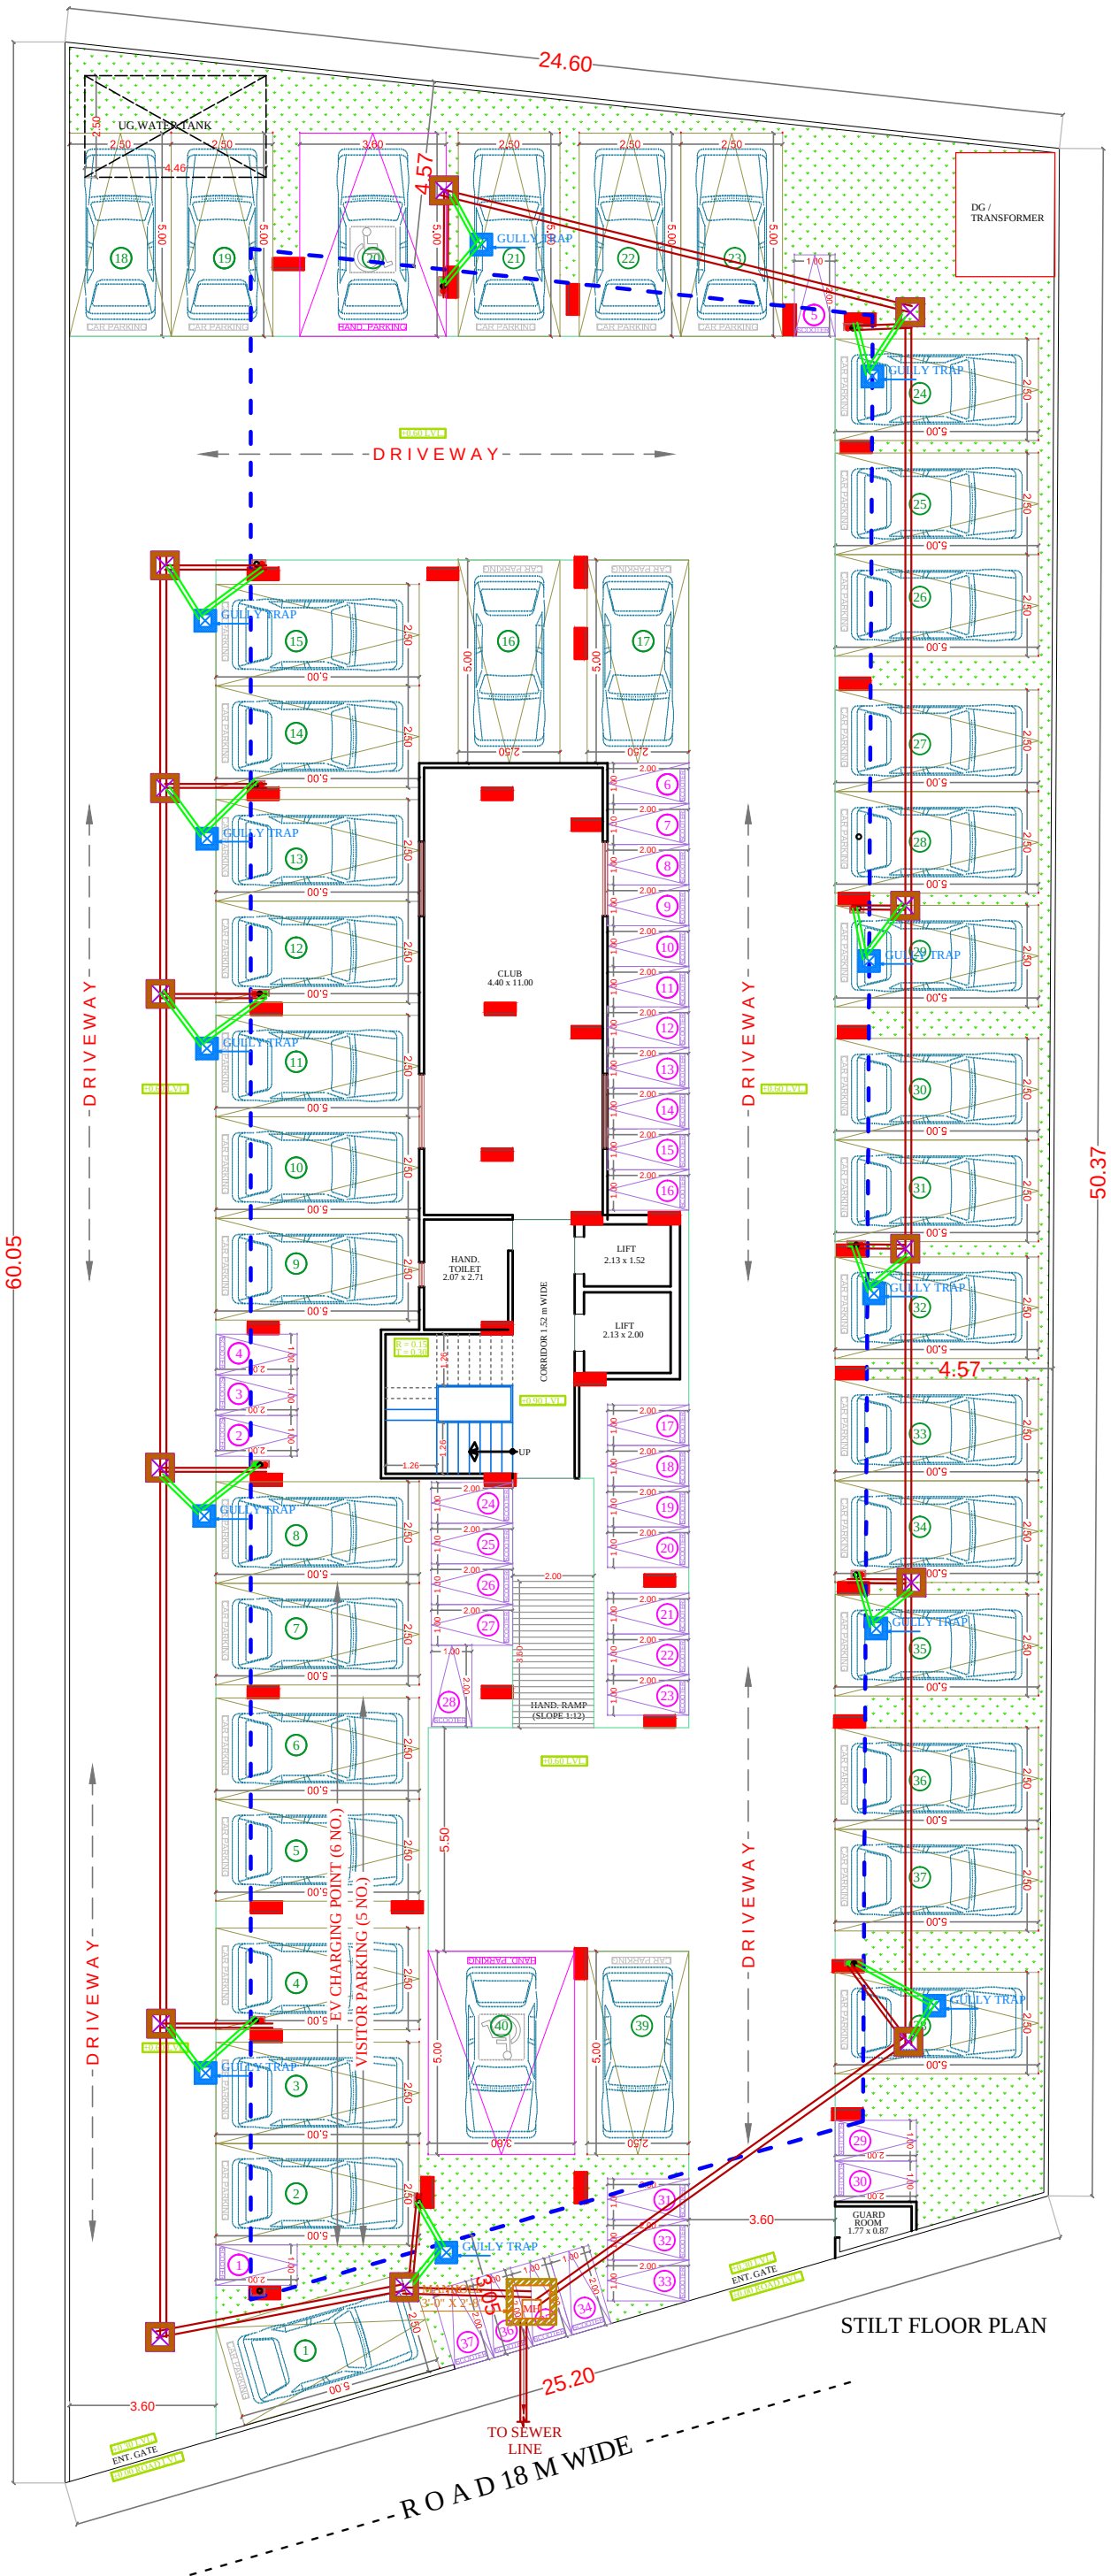

SYMBOL	DESCRIPTION
	110 mm Soil Waste Water Pipe
	110 mm Waste Water Pipe
	110 mm Rain Water Pipe
	110 mm Soil Waste Water Pipe Slope 1:150
	110 mm Waste Water Pipe Slope 1:150
	75 mm Waste Water Pipe Slope 1:150
	50mm Waste Water Pipe Bottle Trap
	Floor Trap
	P-Trap Required
	Gully Trap-12"x12" Depth According to Slope
	Main Hole-18"x18" Depth According to Slope
	Main Hole-24"x24" Depth According to Slope
	Main Hole-36"x32" Depth According to Slope
	Flow Direction

RAMESH KUMAWAT
M.E.P. CONSULTANT
B.E. CIVIL

SIGN:-


SPACE CONSULTANT
PLOT-A-173, JAGDAMBA NAGAR, HEERAPURA
POWER HOWER, JAIPUR (RAJ.) 302024

ARCHITECT :-
 FRANK SQUARE
ARCHITECTURE | PLANNER | DESIGNER
C-49 VIDYA APARTMENT PARAS MARG,
BAPU NAGAR JAIPUR, (RAJ.)
Email-afranksquare@gmail.com
Mobile-9461302542

PROJECT :-
PROPOSED BUILDING AT
KHASARA NO-3401/2403 (OLD)
3405/3401 (NEW) IN
VILLAGE-SIROLI,
SANGANER,JAIPUR

DRAWING:
STILT FLOOR
EXTERNAL SEWERAGE
CHAMBER & PIPE ROUTE FOR
RERA SUBMISSION PLAN

DATE
SCALE:-
N.T.S.

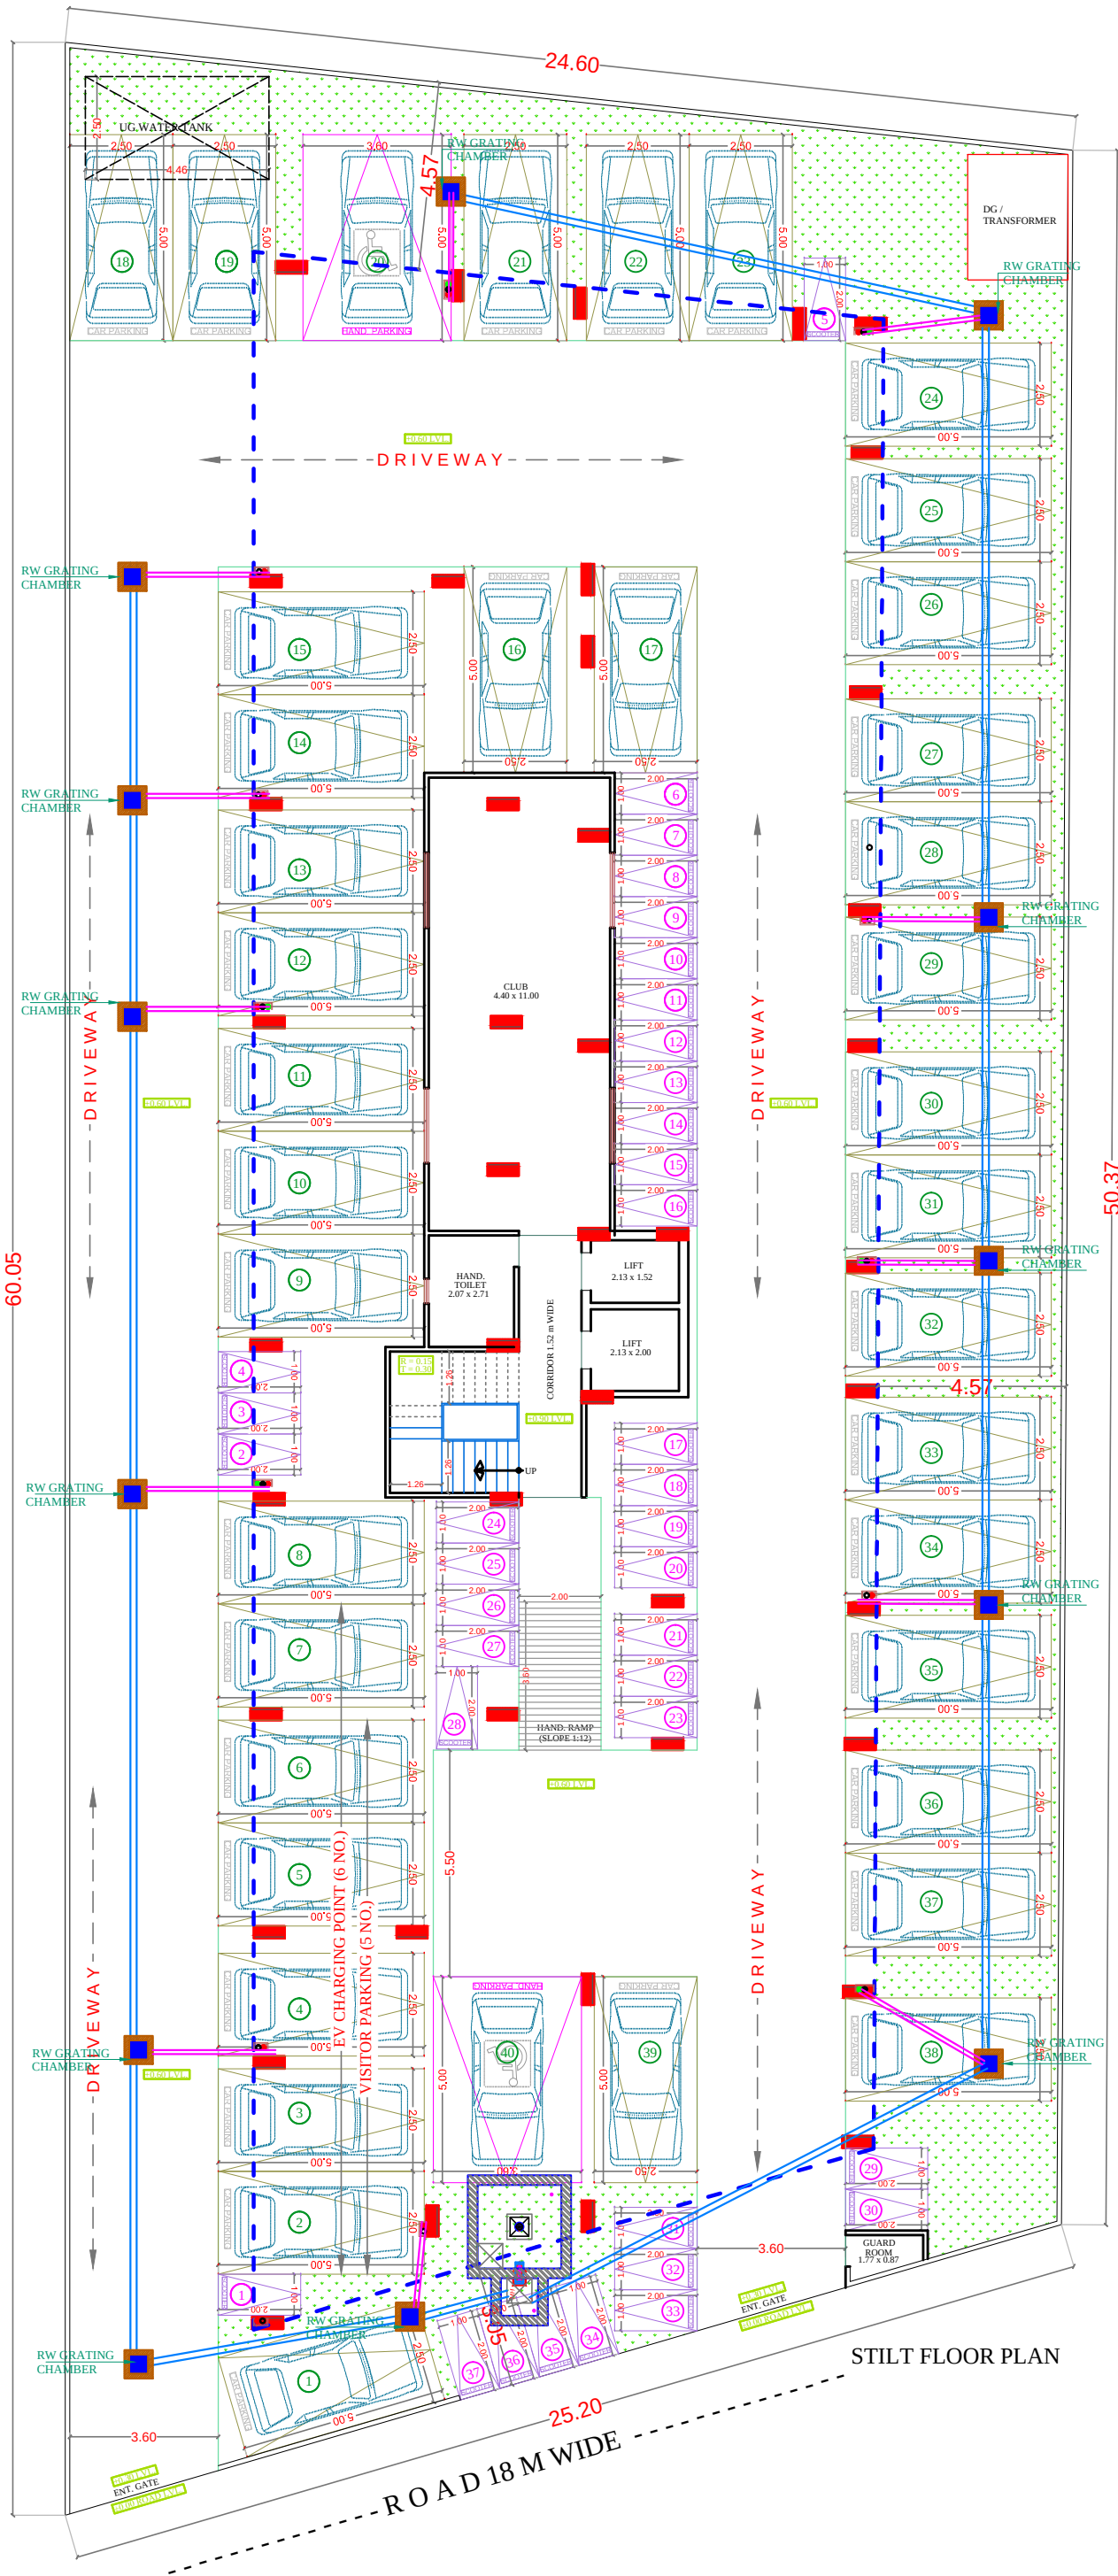

STILT FLOOR PLAN

SYMBOL	DESCRIPTION
	Ø 110 mm Soil Waste Water Pipe
	Ø 110 mm Waste Water Pipe
	Ø 110 mm Rain Water Pipe
	Ø 160 mm Rain Water Pipe Slope 1:200
	Ø 110 mm Rain Water Pipe Slope 1:200
	RC-1.2'X1.2' Depth According to Slope
	RC-1.8'X1.8' Depth According to Slope
	RC-2.4'X2.4' Depth According to Slope
	Flow Direction

RAMESH KUMAWAT
M.E.P. CONSULTANT
B.E. CIVIL

SPACE CONSULTANT
PLOT-A-173, JAGDAMBA NAGAR, HEERAPURA
POWER HOWER, JAIPUR (RAJ) 302024

ARCHITECT :-

FRANK SQUARE
ARCHITECTURE | PLANNER | DESIGNER
C-49 VIDYA APARTMENT PARAS MARG,
BAPU NAGAR JAIPUR, (RAJ.)
Email-afranksquare@gmail.com
Mobile-9461302542

PROJECT :-
PROPOSED BUILDING AT
KHASARA NO-3401/2403 (OLD)
3405/3401 (NEW) IN
VILLAGE-SIROLI,
SANGANER,JAIPUR

DRAWING:
STILT FLOOR
EXTERNAL STORM DRAIN
AND RAIN WATER CHAMBER
PIPE ROUTE FOR
RERA SUBMISSION PLAN

DATE	
SCALE:-	N.T.S.