

PROJECT NAME :

ASTHA EMPIRE -II

DEVELOPER
NAME :

ASTHA DREAM HOMES

ARCHITECTS :

4 INSIDE

ARCHITECTURE N INTERIORS

Plot no. 72, S.P. Marg, C-Scheme

jaipur, rajasthan, India

cont: +91 9950595991, 91

9982812777

e.mail: 4insideofficial@gmail.com

MEP CONSULTANT :-

SHRI SHYAM CONSULTANT

PLUMBING | FIRE | ELECTRICAL | STP | WTP

JAIPUR-302006

PH.NO. +91 9785427711

DEALT BY

RAMESH

REVISION

00

DATE:

05.02.2024

LEGEND:-

①	SOIL PIPE	
②	WASTE PIPE	
③	VENT PIPE	
④	COLD WATER SUPPLY (CWS)	
⑤	HOT WATER SUPPLY (HWS)	
	RAIN WATER PIPE	
SW	SEWER LINE- EXTERNAL	
RW	STORM WATER DRAINAGE PIPE	
	SEWERAGE MANHOLE	M.H.
	STORM WATER MANHOLE	M.H.
GT	GULLY TRAP	
BV	BALL VALVE	
FT	FLOOR TRAP	
FD	FLOOR FLOOR DRAIN	
	RAIN WATER COLLECTION CHAMBER	
	450X450MM	
	KHURRA	

PROJECT:

PROPOSED RESIDENTIAL FLATS ON
PLOT NO.-R-9/11,R-9/12,R-9/13
SCHEME CHORDIA CITY
(INDRAPRASTH COLONY)
AJMER ROAD ,JAIPUR

NAME OF DRAWING:

Stilt Floor Water Supply, Rain Water
Harvesting, Sanitation

DRAWING

WORKING DRAWING

NORTH:

N

PROJECT NO. :

DATE :

19, Jan. - 2024

SCALE :

NTS


REV NO. :

R-0

DRAWING NO. :

PROJECT	CATEGORY	BLOCK	FLOOR	TYPE	NUMBER

A-01

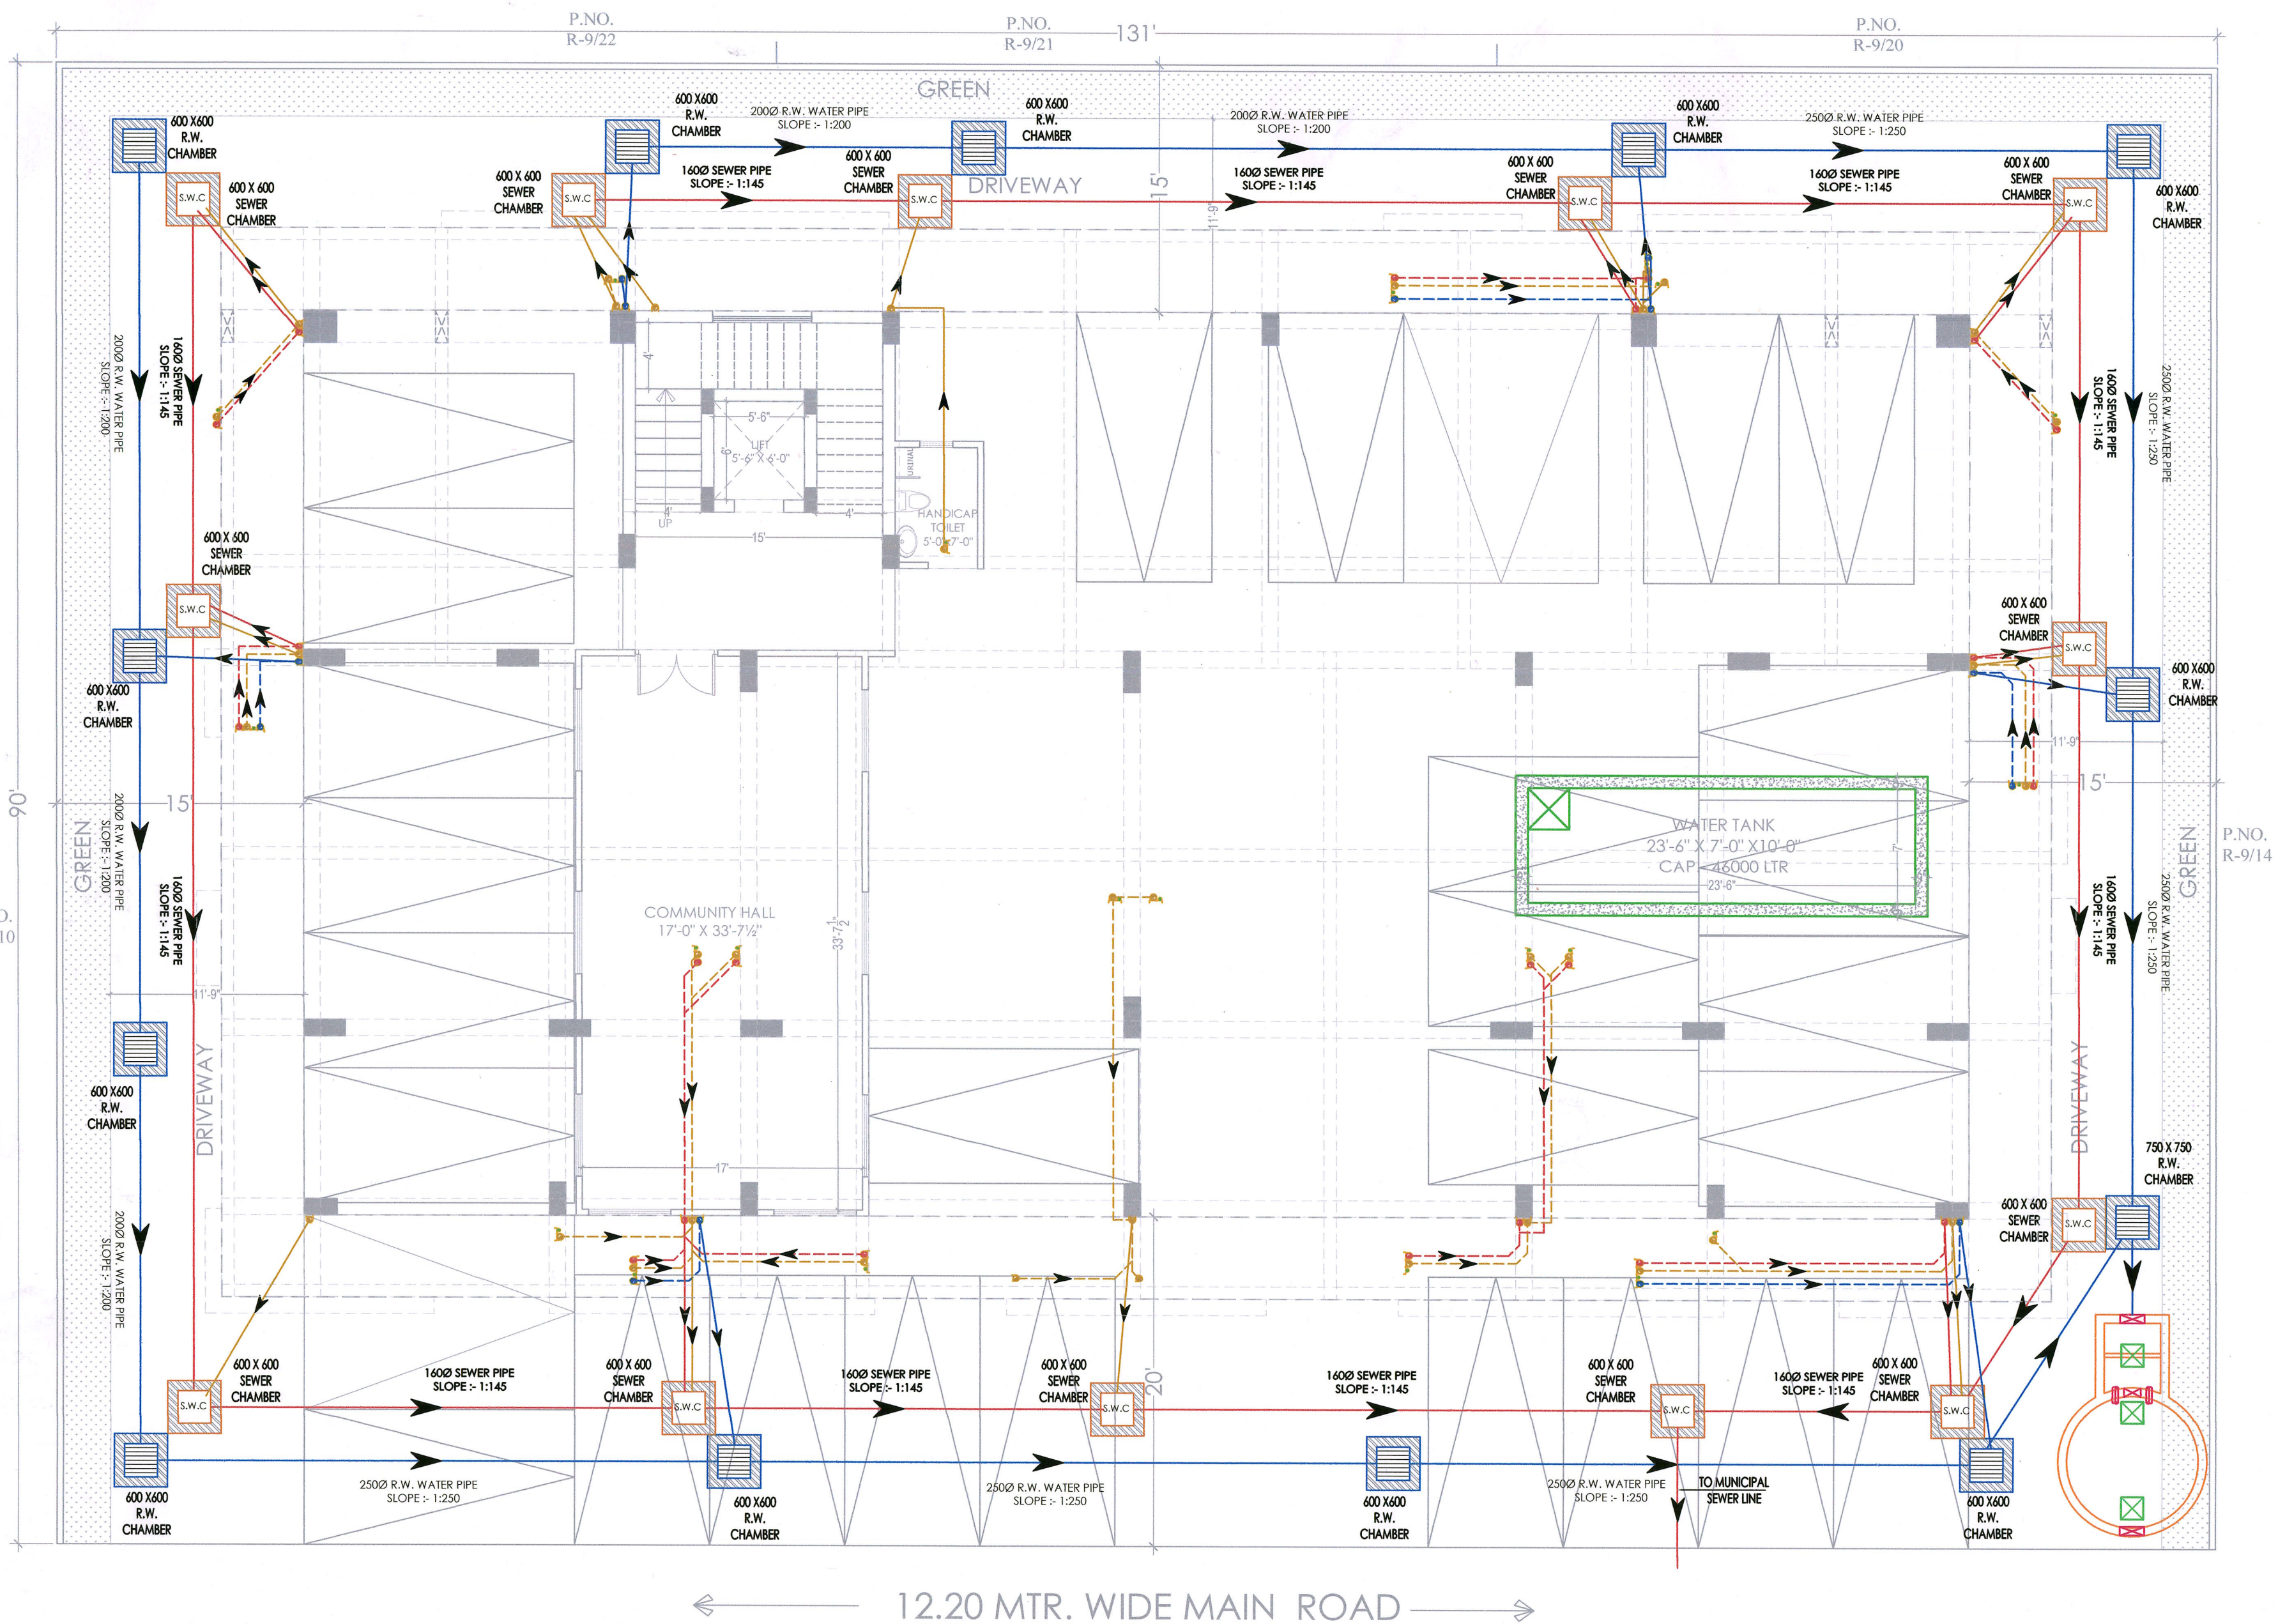

STILT FLOOR PLUMBING LAYOUT

For ASTHA DREAM HOMES
Partner

Draw
Er. SANJEEV SHARMA
B.E. (Electrical)

PROJECT NAME :

ASTHA EMPIRE -II

DEVELOPER
NAME :

ASTHA DREAM HOMES

ARCHITECTS :

4 INSIDE

ARCHITECTURE N INTERIORS

Plot no. 72, S.P. Marg, C-Scheme

jaipur, rajasthan, India

cont: +91 9950595991, 91

9982812777

e.mail: 4insideofficial@gmail.com

MEP CONSULTANT :-

SHRI SHYAM CONSULTANT

PLUMBING | FIRE | ELECTRICAL | STP | WTP

JAIPUR-302006

PH.NO. +91 9785427711

DEALT BY

RAMESH

REVISION

00

DATE:

05.02.2024

LEGEND:-

①	SOIL PIPE	
②	WASTE PIPE	
③	VENT PIPE	
④	COLD WATER SUPPLY (CWS)	
⑤	HOT WATER SUPPLY (HWS)	
	RAIN WATER PIPE	
SW	SEWER LINE- EXTERNAL	
RW	STORM WATER DRAINAGE PIPE	
	SEWERAGE MANHOLE	M.H.
	STORM WATER MANHOLE	M.H.
GT	GULLY TRAP	
BV	BALL VALVE	
FT	FLOOR TRAP	
FD	FLOOR FLOOR DRAIN	
	RAIN WATER COLLECTION CHAMBER 450X450MM	
	KHURRA	

PROJECT:

PROPOSED RESIDENTIAL FLATS ON
PLOT NO.-R-9/11,R-9/12,R-9/13
SCHEME_CHORDIA CITY
(INDRAPRASHTH COLONY)
AJMER ROAD ,JAIPUR

 
NAME OF DRAWING:

Typical Floor Plan G+5 Water Supply,
Rain Water Harvesting, Sanitation

DRAWING

WORKING DRAWING

NORTH:



PROJECT NO.:

DATE:

19, Jan. - 2024

SCALE:

NTS

REV NO.:

R-0

DRAWING NO.:

PROJECT CATEGORY BLOCK FLOOR TYPE NUMBER

A-01



12.20 MTR. WIDE MAIN ROAD

For ASTHA DREAM HOMES

Partner

ER. SANJEEV SHARMA
B.E. (Electrical)

TYPICAL FLOOR PLAN G+5 PLUMBING LAYOUT