



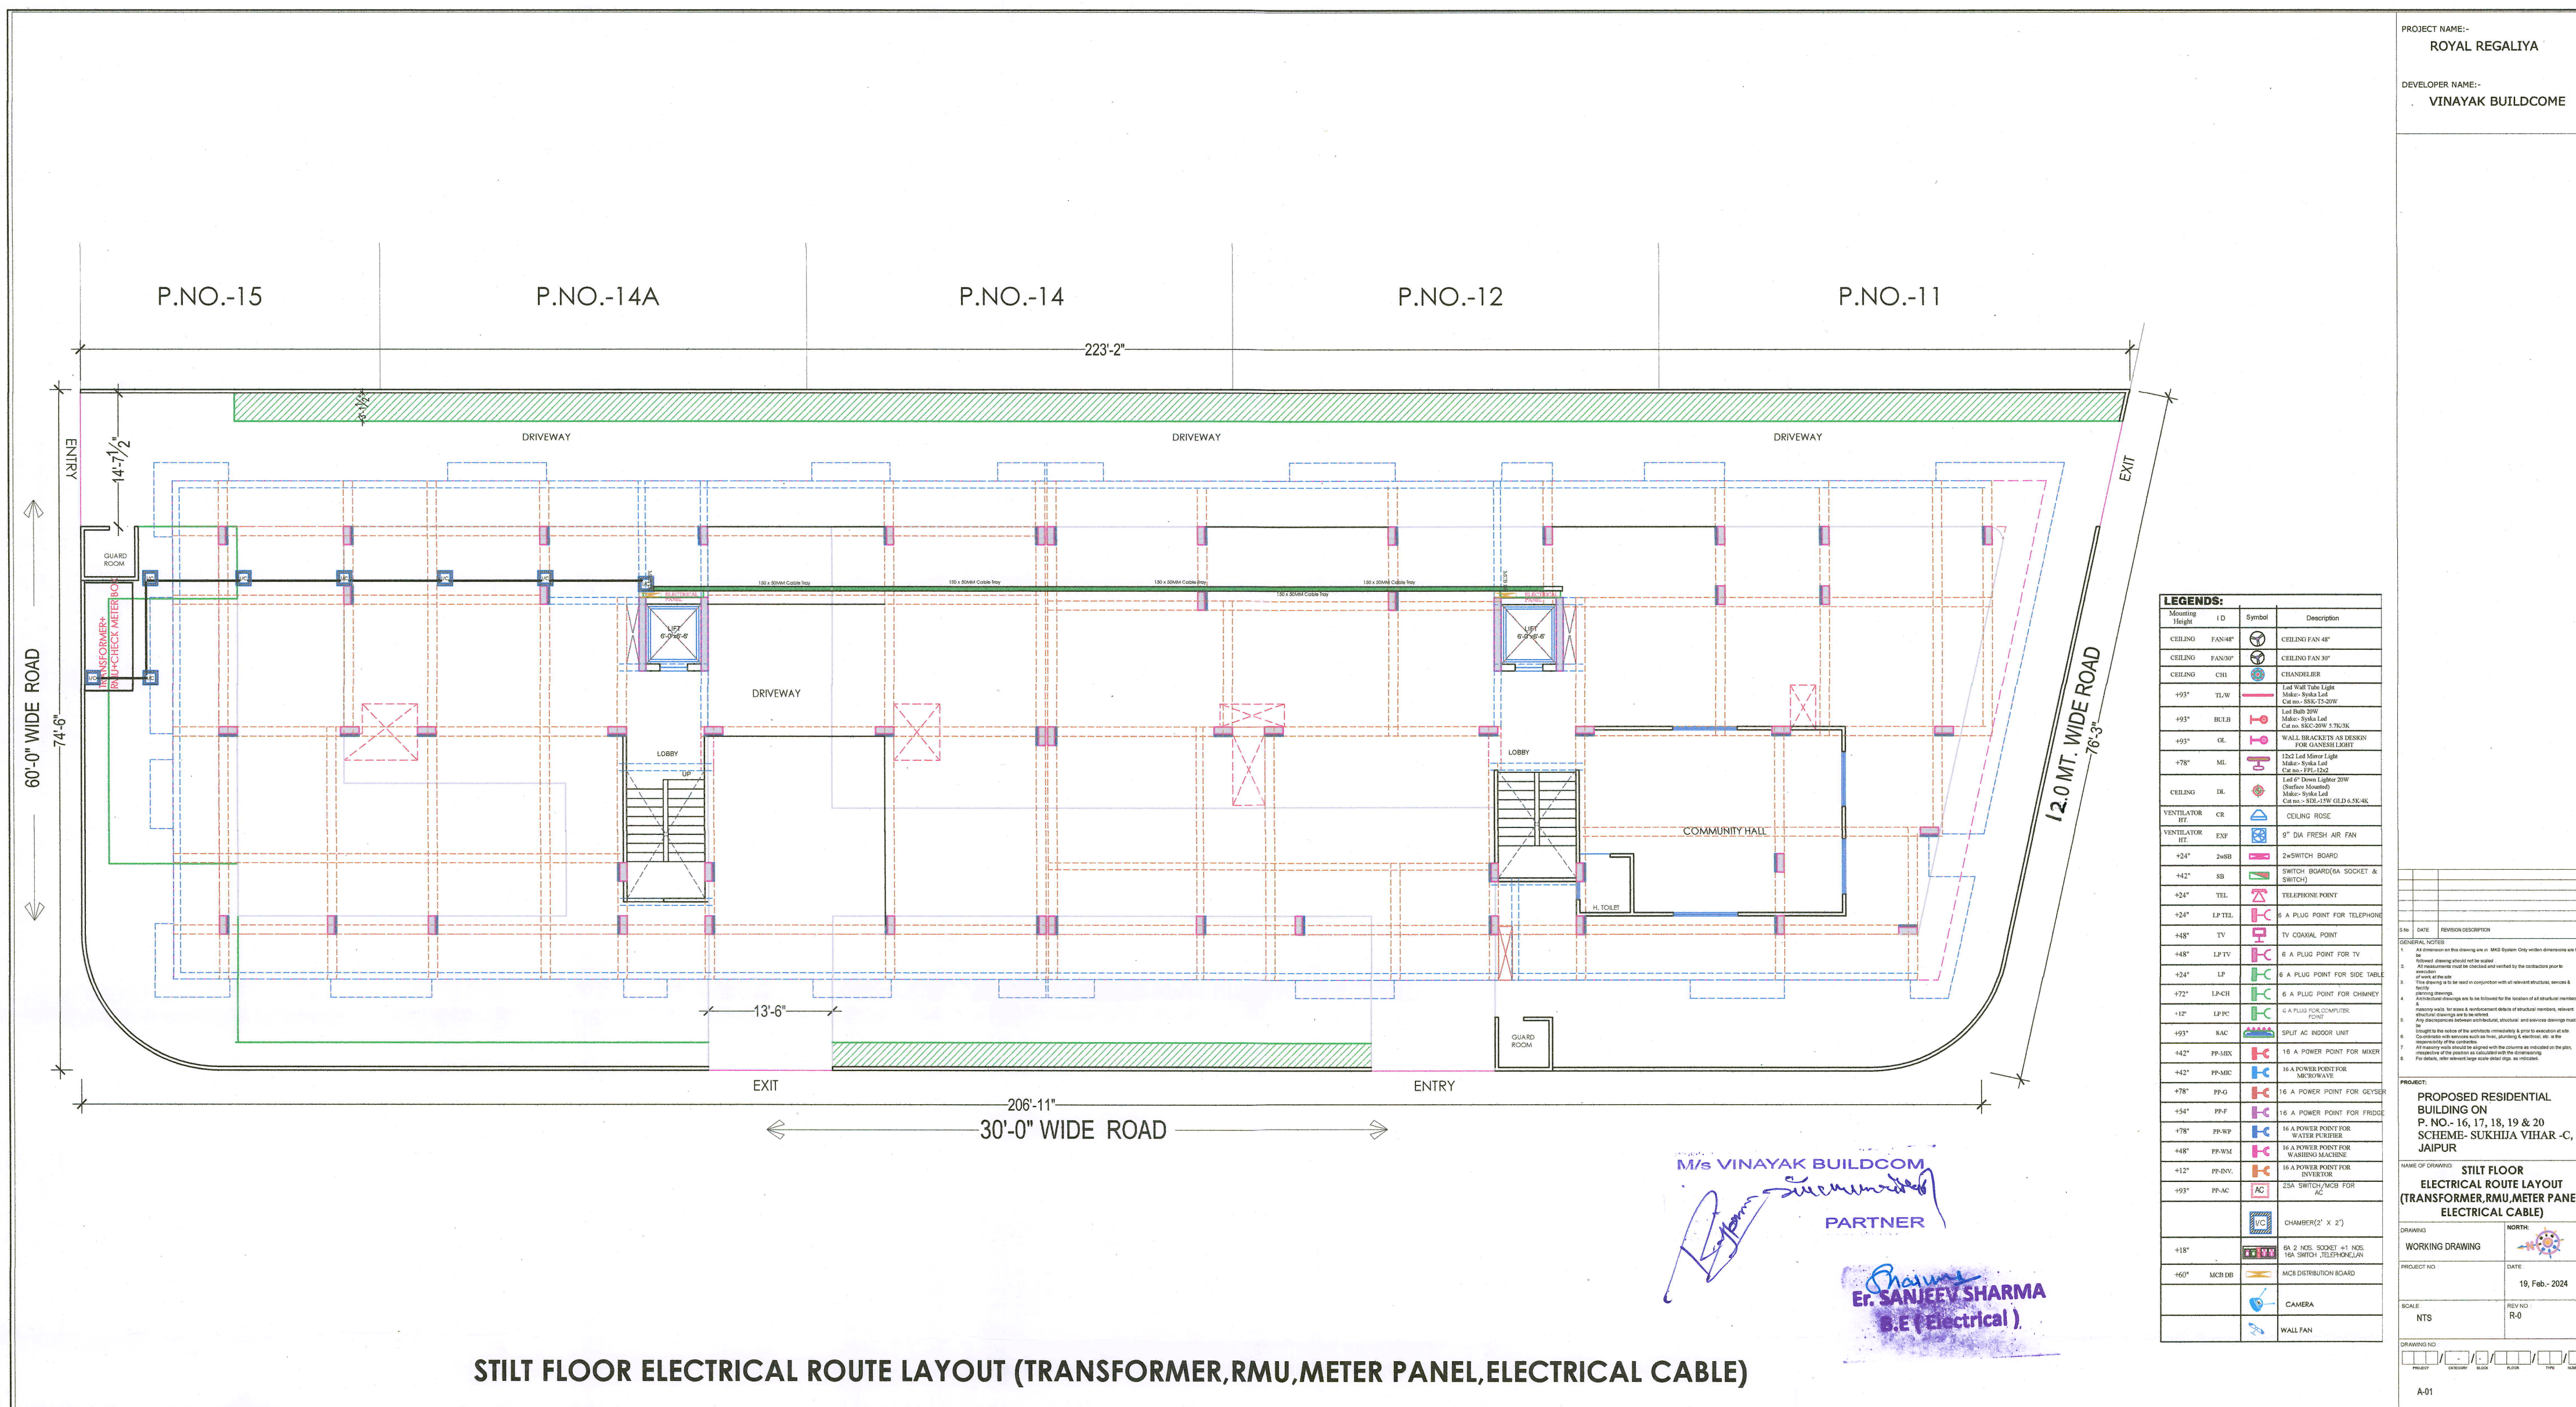

PROJECT NAME:-
ROYAL REGALIYA
DEVELOPER NAME:-
VINAYAK BUILDCOME

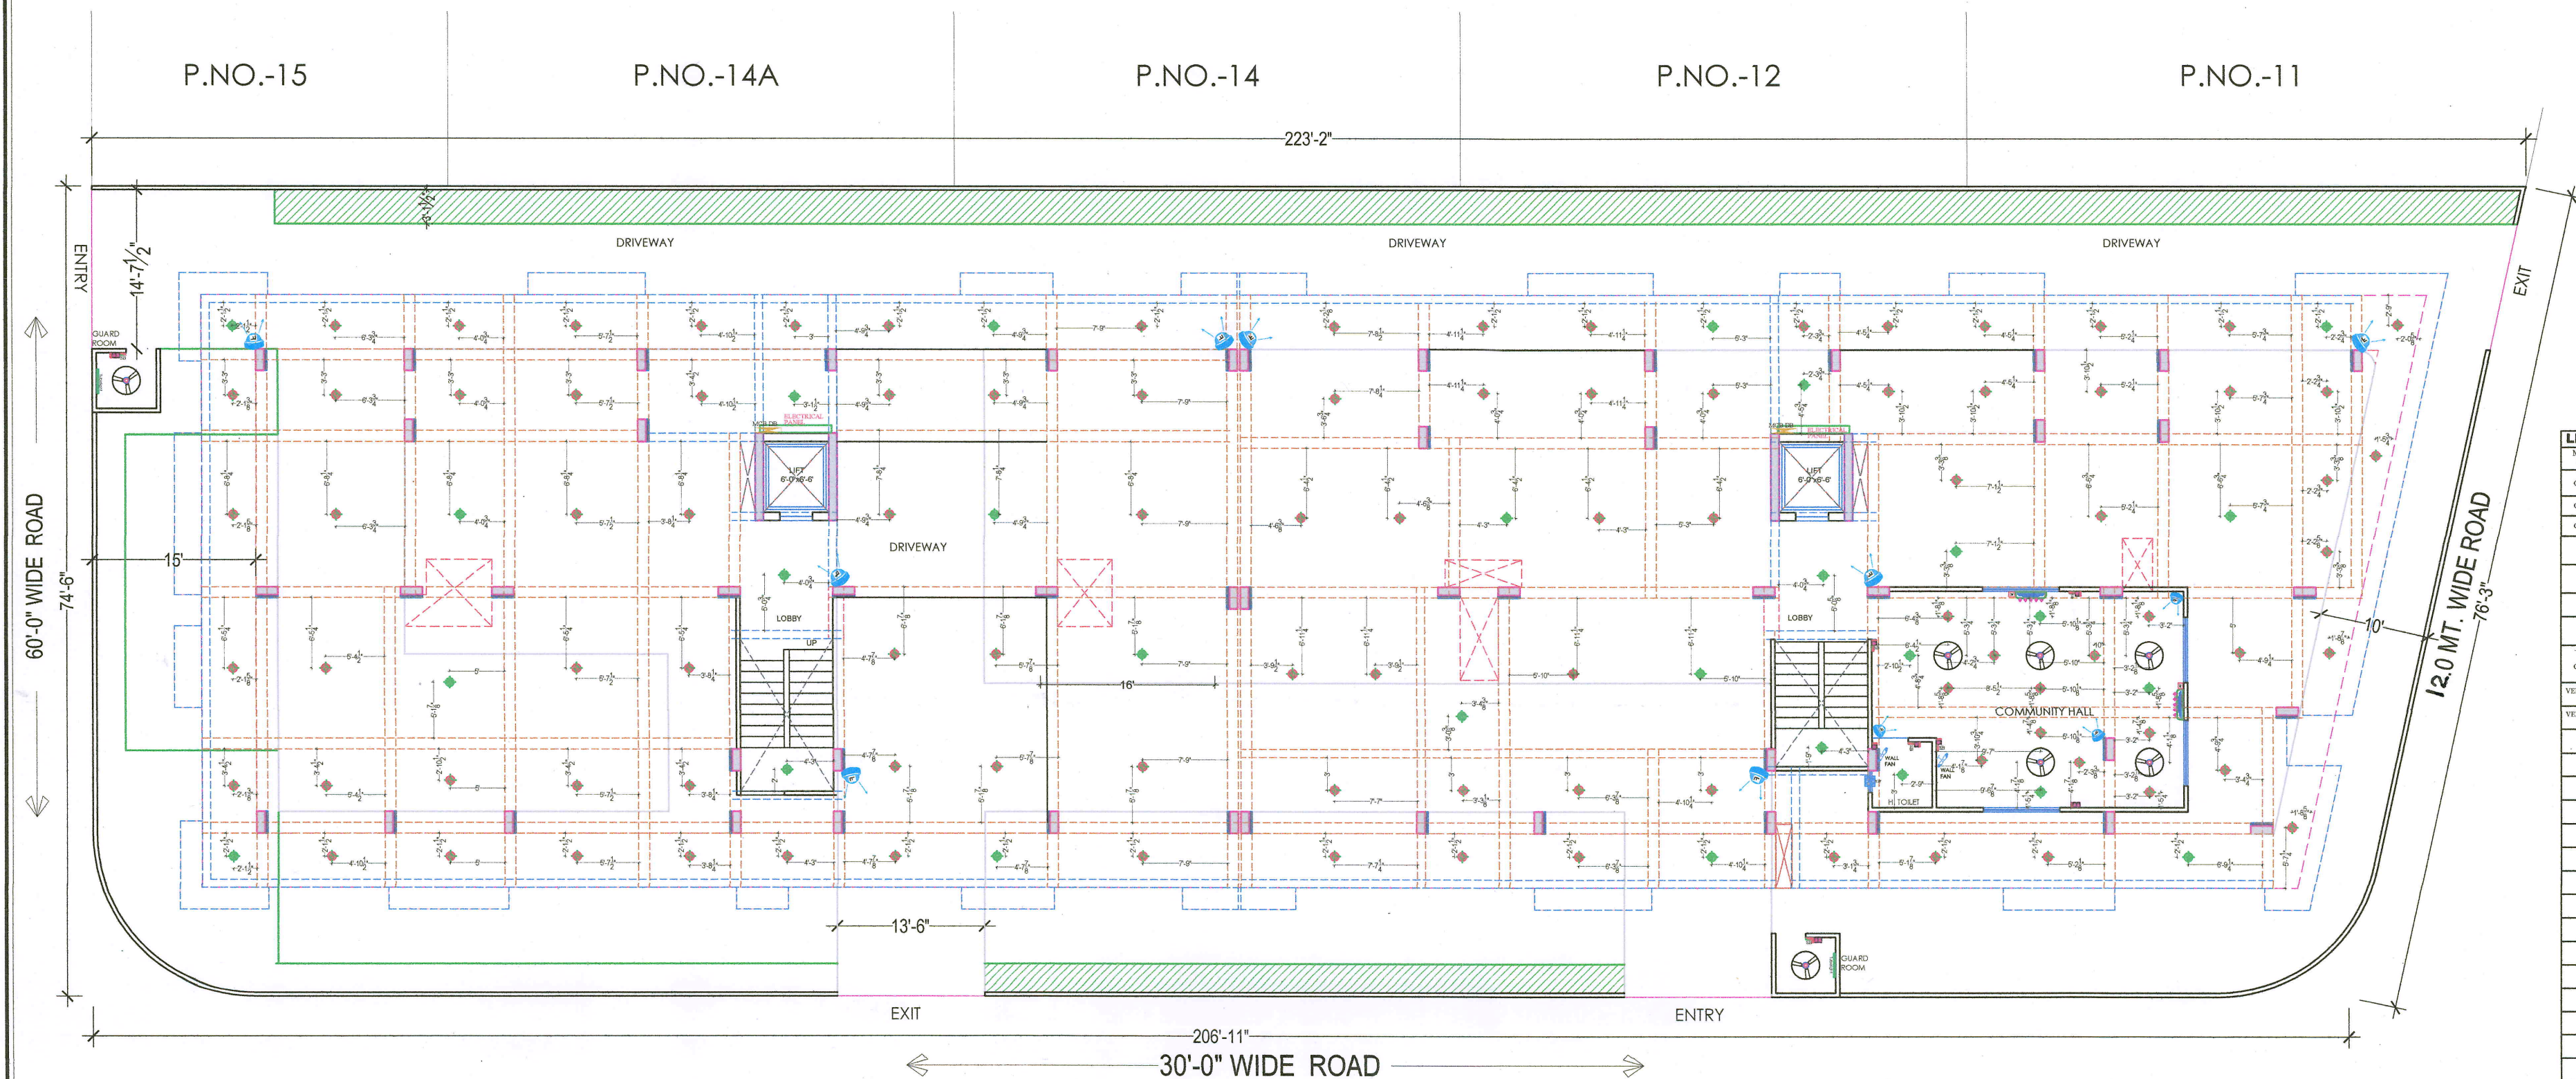

LEGENDS:			
Mounting Height	ID	Symbol	Description
CEILING FAN 48"			CEILING FAN 48"
CEILING FAN 36"			CEILING FAN 36"
CEILING CH			CHANDIELIER
+93" TL/W			LED Wall Tube Light Make:- Syntex Ltd Cat no:- SSC-TS-20W
+93" BULB			LED Bulb 20W Make:- Syntex Ltd Cat no:- SSC-20W 5.75/3K
+93" GL			WALL BRACKETS AS DESIGN FOR CANSSEL LIGHT
+78" ML			12x2 LED Mirror Light Make:- Syntex Ltd Cat no:- TFS-12x2
CEILING DL			LED 6" Down Light 20W (Surface Mounted) Make:- Syntex Ltd Cat no:- SSC-15W GLD 6.5K/4K
VENTILATOR BL			CEILING ROSE
VENTILATOR HT			9" DIA FRESH AIR FAN
+24" 2wSB			2w SWITCH BOARD
+42" SB			SWITCH BOARD (A SOCKET & SWITCH)
+24" TBL			TELEPHONE POINT
+24" LP-TBL			A PLUG POINT FOR TELEPHONE
+48" TV			TV CONSOLE POINT
+48" LP-TV			A PLUG POINT FOR TV
+24" LP			A PLUG POINT FOR SIDE TABLE
+72" LP-CH			A PLUG POINT FOR CHIMNEY
+12" LP-PC			A PLUG POINT FOR COMPUTER
+93" SAC			SPLIT AC INDOOR UNIT
+42" PP-MIX			A POWER POINT FOR MIXER
+42" PP-MDC			A POWER POINT FOR MICROWAVE
+78" PP-G			A POWER POINT FOR GEYSER
+54" PP-F			A POWER POINT FOR FRIDGE
+78" PP-WP			A POWER POINT FOR WATER PURIFIER
+48" PP-WM			A POWER POINT FOR WASHING MACHINE
+12" PP-INV			A POWER POINT FOR INVERTER
+93" PP-AC			25A SWITCH/MCB FOR AC
			CHAMBER (2' X 2')
+18"			6x2 NOS. SOCKET 41 NOS. (A SWITCH, TELEPHONE, ETC.)
+60"			MCB DISTRIBUTION BOARD
			CAMERA
			WALL FAN

GENERAL NOTES:
1. All dimensions and elevations are in SI units unless otherwise specified.
2. All work shall be done in accordance with the latest Indian Standards.
3. This drawing is to be used in conjunction with all relevant structural, services & other drawings.
4. Architectural changes are to be followed for the location of all structural members.
5. All electrical work shall be done in accordance with the latest Indian Standards.
6. All electrical work shall be done in accordance with the latest Indian Standards.
7. All electrical work shall be done in accordance with the latest Indian Standards.
8. All electrical work shall be done in accordance with the latest Indian Standards.

PROPOSED RESIDENTIAL
BUILDING ON
P. NO.- 16, 17, 18, 19 & 20
SCHEME- SUKHIA VIHAR -C,
JAIPUR

NAME OF DRAWING:
STILT FLOOR
CEILING ELECTRICAL LAYOUT,
ELECTRICAL POINT DRAWING,
CAMERA POINT DRAWING

DATE: 19, Feb - 2024
SCALE: NTS
REV NO: R-0

PROJECT NO:
DRAWING NO:
A-01

STILT FLOOR CEILING ELECTRICAL LAYOUT, ELECTRICAL POINT DRAWING, CAMERA POINT DRAWING

M/s VINAYAK BUILDCOM
PARTNER
Er. SANJEEV SHARMA
B.E (Electrical)