
 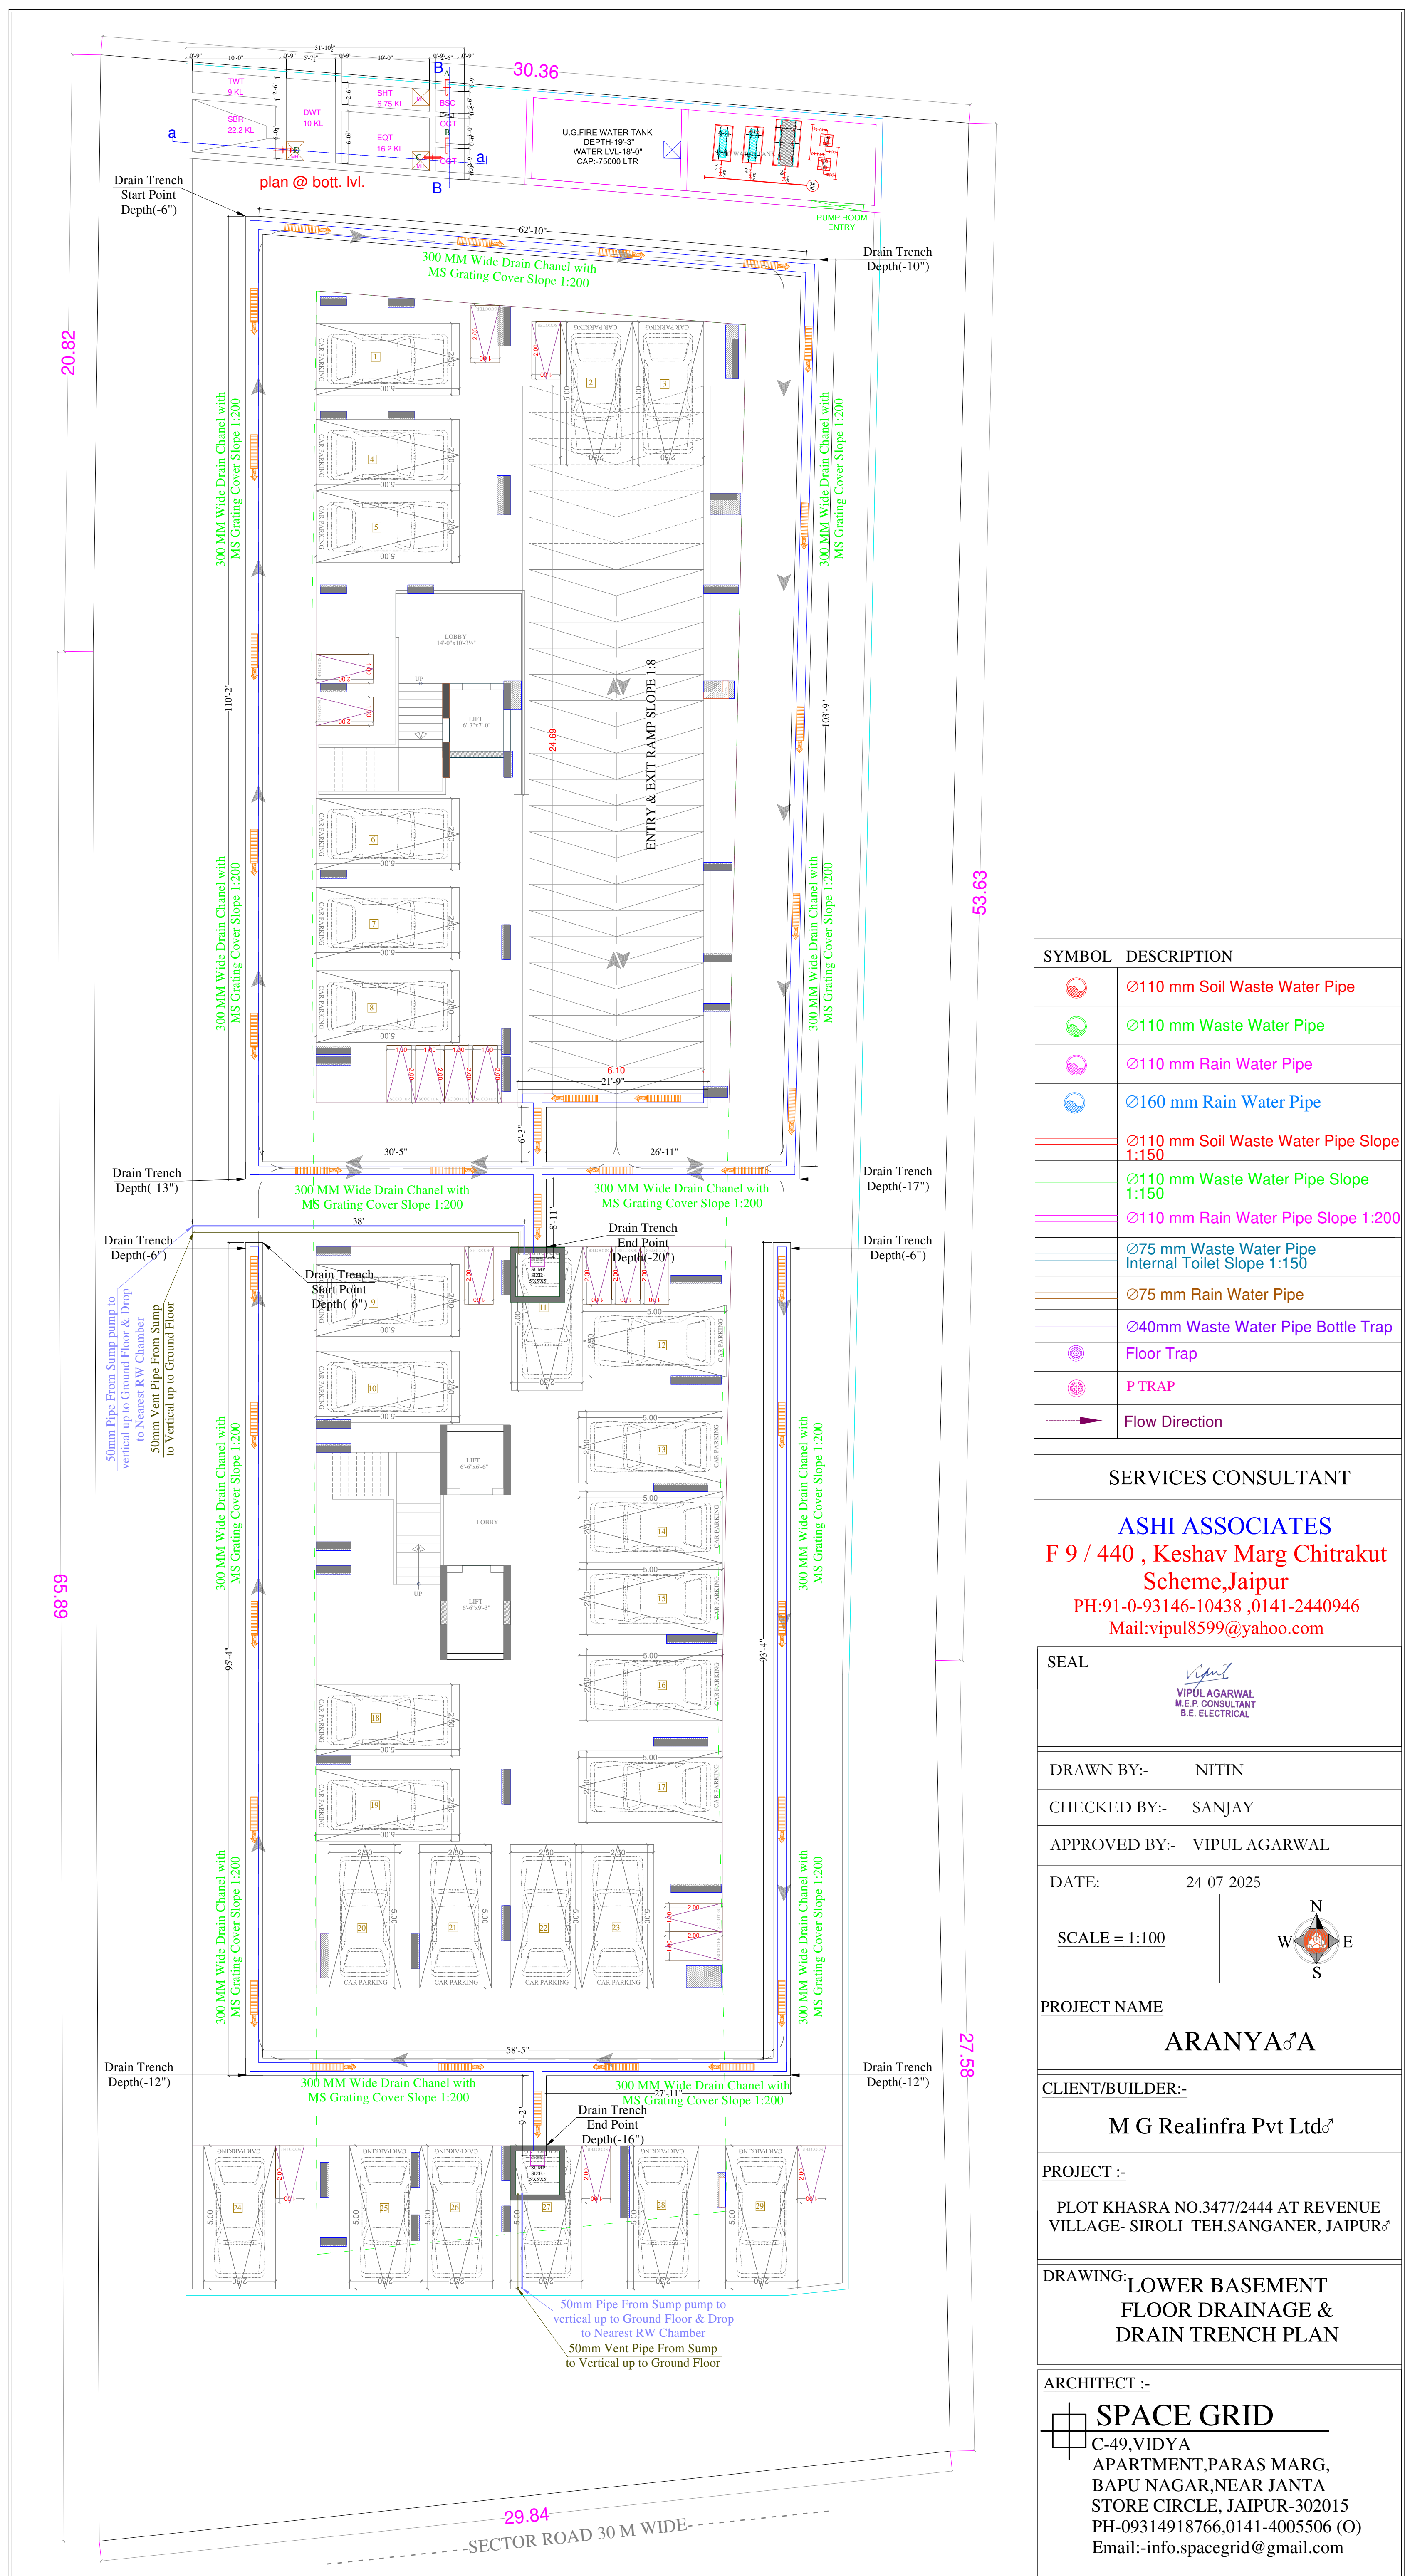
 




SYMBOL	DESCRIPTION
	Ø110 mm Soil Waste Water Pipe
	Ø110 mm Waste Water Pipe
	Ø110 mm Rain Water Pipe
	Ø160 mm Rain Water Pipe
	Ø110 mm Soil Waste Water Pipe Slope 1:150
	Ø110 mm Waste Water Pipe Slope 1:150
	Ø110 mm Rain Water Pipe Slope 1:200
	Ø75 mm Waste Water Pipe Internal Toilet Slope 1:150
	Ø75 mm Rain Water Pipe
	Ø40mm Waste Water Pipe Bottle Trap
	Floor Trap
	P TRAP
	Flow Direction

SERVICES CONSULTANT

ASHI ASSOCIATES
F 9 / 440 , Keshav Marg Chitrakut
Scheme,Jaipur
PH:91-0-93146-10438 ,0141-2440946
Mail:vipul8599@yahoo.com

SEAL

Vipul
VIPUL AGARWAL
M.E.P. CONSULTANT
B.E. ELECTRICAL

DRAWN BY:- NITIN

CHECKED BY:- SANJAY

APPROVED BY:- VIPUL AGARWAL

DATE:- 24-07-2025

SCALE = 1:100



PROJECT NAME

ARANYA♂A

CLIENT/BUILDER:-

M G Realinfra Pvt Ltd♂

PROJECT :-

PLOT KHASRA NO.3477/2444 AT REVENUE
VILLAGE- SIROLI TEH.SANGANER, JAIPUR


DRAWING: LOWER BASEMENT
FLOOR DRAINAGE &
DRAIN TRENCH PLAN

ARCHITECT :-



SPACE GRID

C-49,VIDYA
 APARTMENT,PARAS MARG,
 BAPU NAGAR,NEAR JANTA
 STORE CIRCLE, JAIPUR-302015
 PH-09314918766,0141-4005506 (O)
 Email:-info.spacegrid@gmail.com

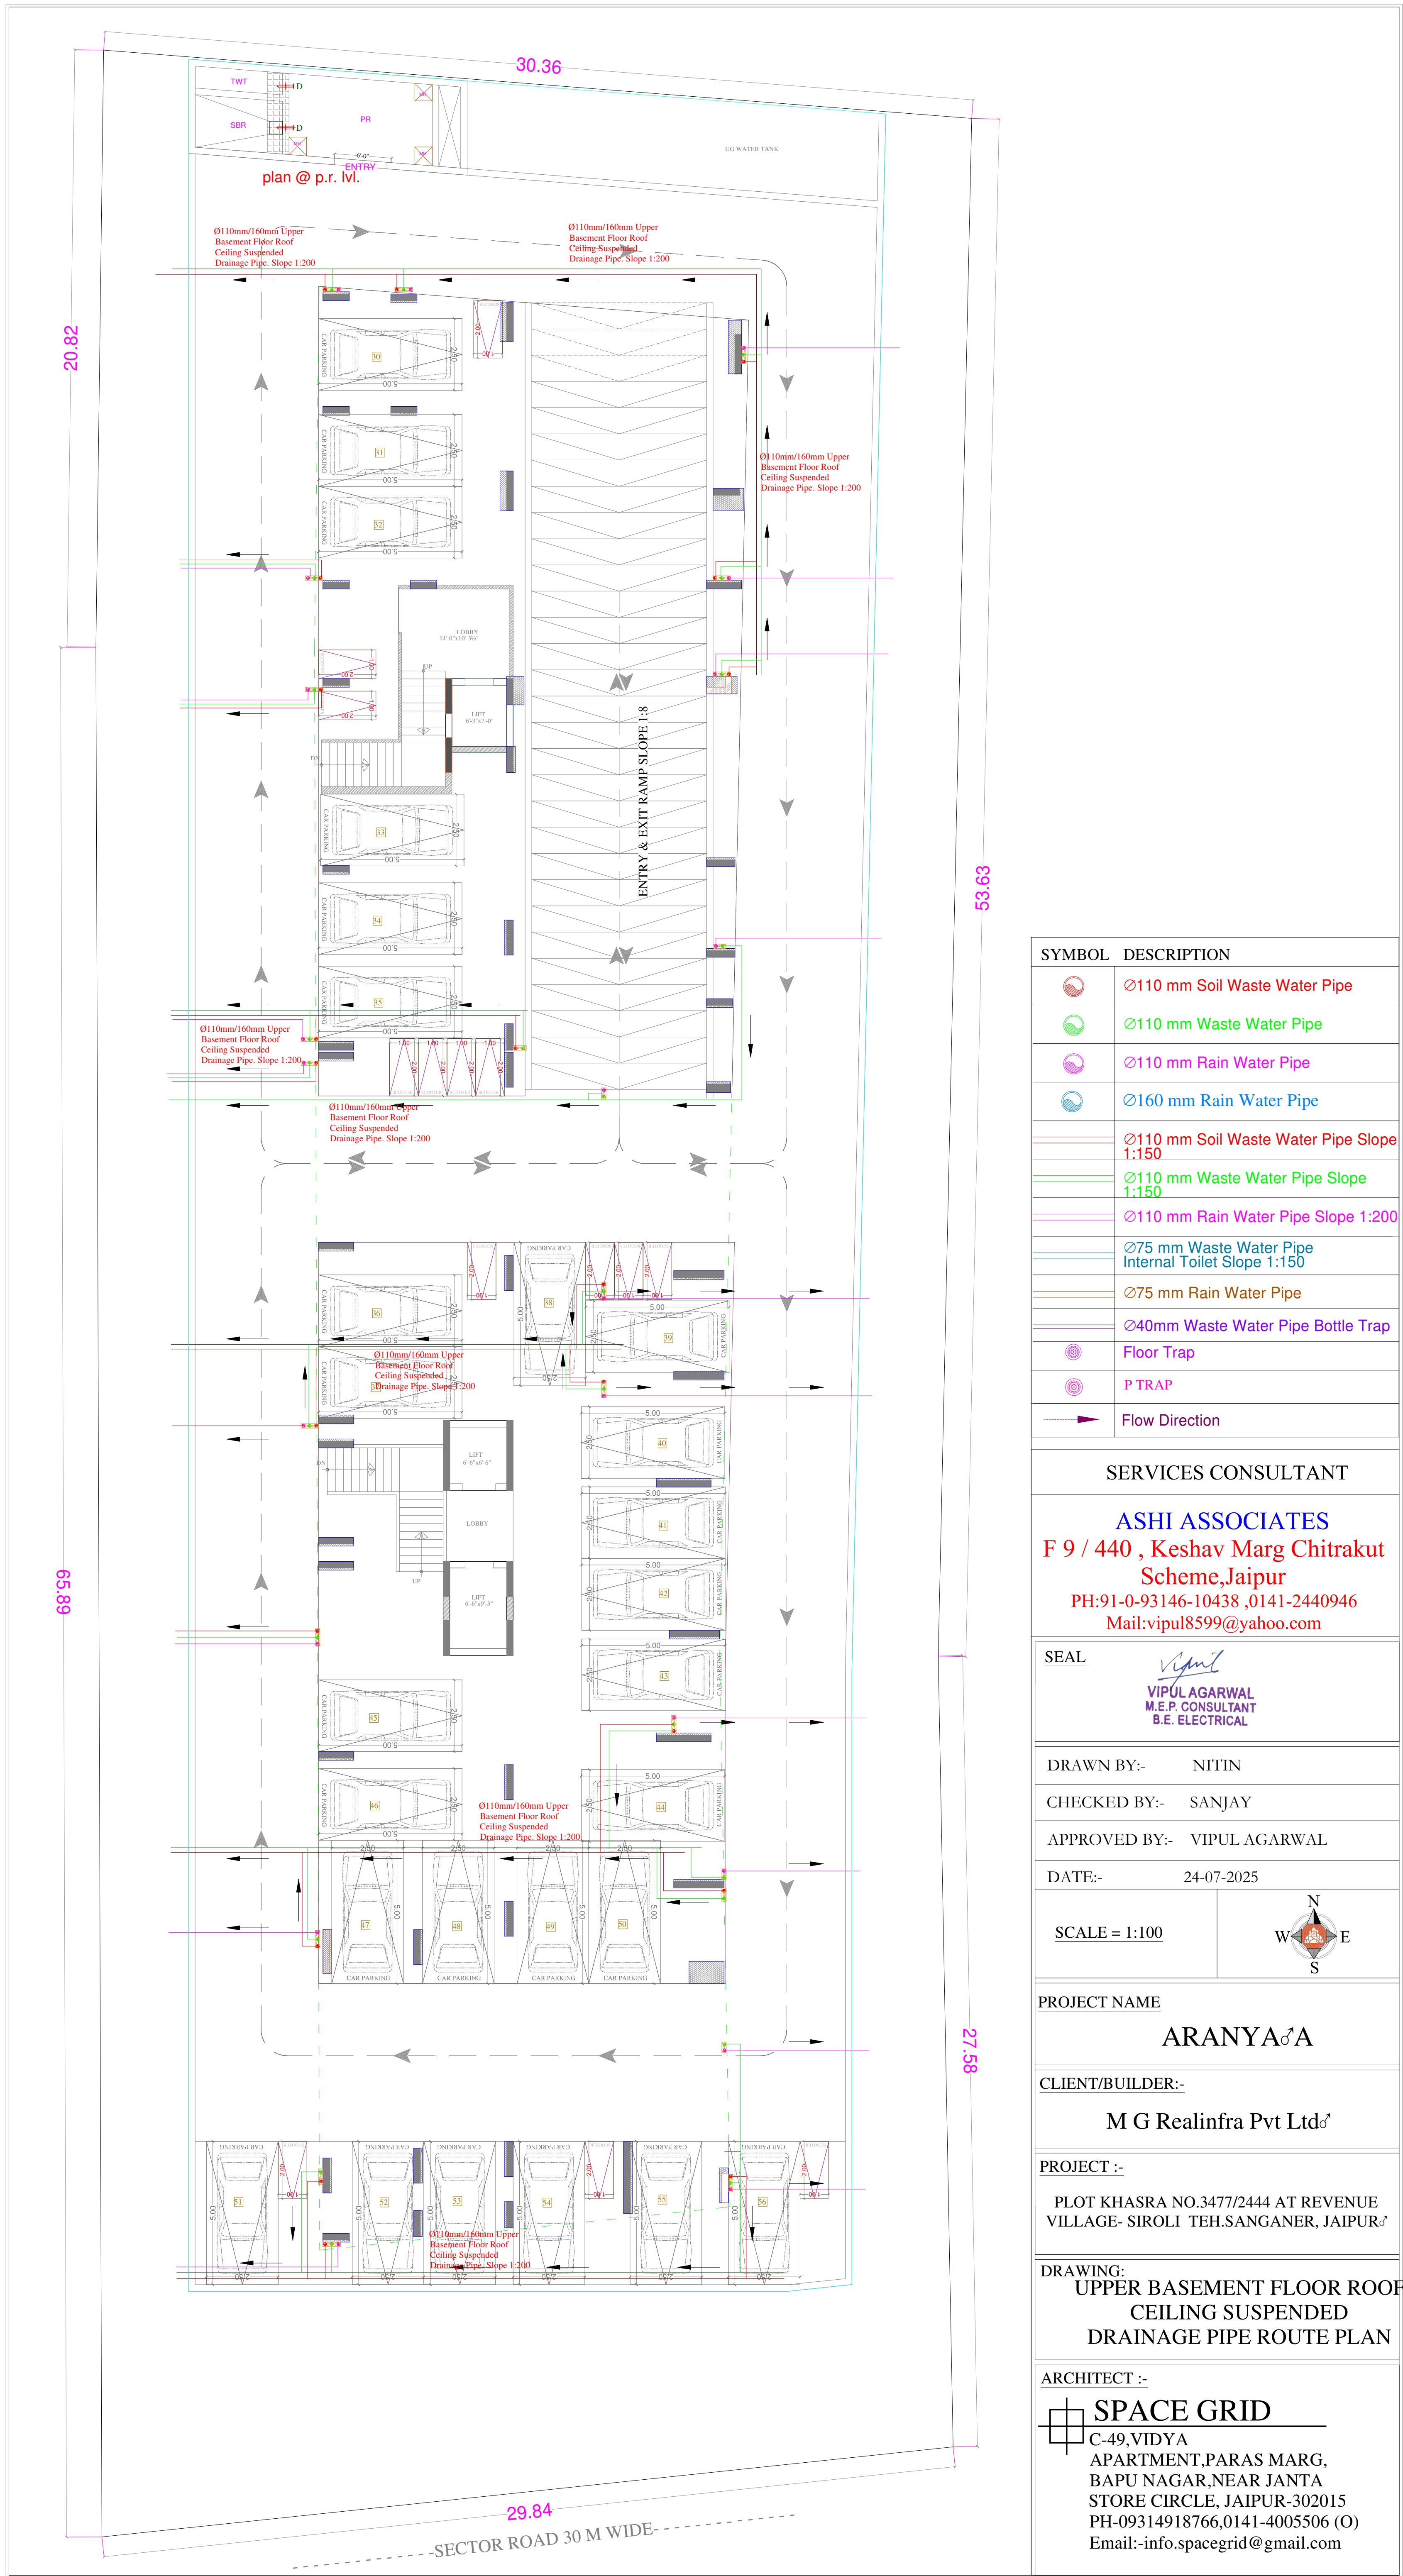

SYMBOL	DESCRIPTION
	Ø110 mm Soil Waste Water Pipe
	Ø110 mm Waste Water Pipe
	Ø110 mm Rain Water Pipe
	Ø160 mm Rain Water Pipe
	Ø110 mm Soil Waste Water Pipe Slope 1:150
	Ø110 mm Waste Water Pipe Slope 1:150
	Ø110 mm Rain Water Pipe Slope 1:200
	Ø75 mm Waste Water Pipe Internal Toilet Slope 1:150
	Ø75 mm Rain Water Pipe
	Ø40mm Waste Water Pipe Bottle Trap
	Floor Trap
	P TRAP
	Flow Direction

SERVICES CONSULTANT

ASHI ASSOCIATES
F 9 / 440 , Keshav Marg Chitrakut Scheme,Jaipur
PH:91-0-93146-10438 ,0141-2440946
Mail:vipul8599@yahoo.com

SEAL

VIPUL AGARWAL
M.E.P. CONSULTANT
B.E. ELECTRICAL

DRAWN BY:- NITIN

CHECKED BY:- SANJAY

APPROVED BY:- VIPUL AGARWAL

DATE:- 24-07-2025

SCALE = 1:100

PROJECT NAME

ARANYA A

CLIENT/BUILDER:-

M G Realinfra Pvt Ltd

PROJECT :-

PLOT KHASRA NO.3477/2444 AT REVENUE VILLAGE- SIROLI TEH.SANGANER, JAIPUR

DRAWING:

UPPER BASEMENT FLOOR ROOF
CEILING SUSPENDED
DRAINAGE PIPE ROUTE PLAN


ARCHITECT :-

SPACE GRID
C-49,VIDYA
APARTMENT,PARAS MARG,
BAPU NAGAR,NEAR JANTA
STORE CIRCLE, JAIPUR-302015
PH-09314918766,0141-4005506 (O)
Email:-info.spacegrid@gmail.com



SYMBOL	DESCRIPTION
	Ø110 mm Soil Waste Water Pipe
	Ø110 mm Waste Water Pipe
	Ø110 mm Rain Water Pipe
	Ø160 mm Rain Water Pipe
	Ø110 mm Soil Waste Water Pipe Slope 1:150
	Ø110 mm Waste Water Pipe Slope 1:150
	Ø110 mm Rain Water Pipe Slope 1:200
	Ø75 mm Waste Water Pipe Internal Toilet Slope 1:150
	Ø75 mm Rain Water Pipe
	Ø40mm Waste Water Pipe Bottle Trap
	Floor Trap
	P TRAP
	Flow Direction

SERVICES CONSULTANT	
ASHI ASSOCIATES F 9 / 440 , Keshav Marg Chitrakut Scheme,Jaipur PH:91-0-93146-10438 ,0141-2440946 Mail:vipul8599@yahoo.com	
SEAL	
VIPUL AGARWAL M.E.P. CONSULTANT B.E. ELECTRICAL	
DRAWN BY:-	NITIN
CHECKED BY:-	SANJAY
APPROVED BY:-	VIPUL AGARWAL
DATE:-	24-07-2025
SCALE = 1:100	
PROJECT NAME	
ARANYA A	
CLIENT/BUILDER:-	
M G Realinfra Pvt Ltd	
PROJECT :-	
PLOT KHASRA NO.3477/2444 AT REVENUE VILLAGE- SIROLI TEH.SANGANER, JAIPUR	
DRAWING:	
STILT FLOOR ROOF DRAINAGE WITH DROPAGE & PIPE ROUTE PLAN	
ARCHITECT :-	
SPACE GRID	
C-49,VIDYA APARTMENT,PARAS MARG, BAPU NAGAR,NEAR JANTA STORE CIRCLE, JAIPUR-302015 PH-09314918766,0141-4005506 (O) Email:-info.spacegrid@gmail.com	

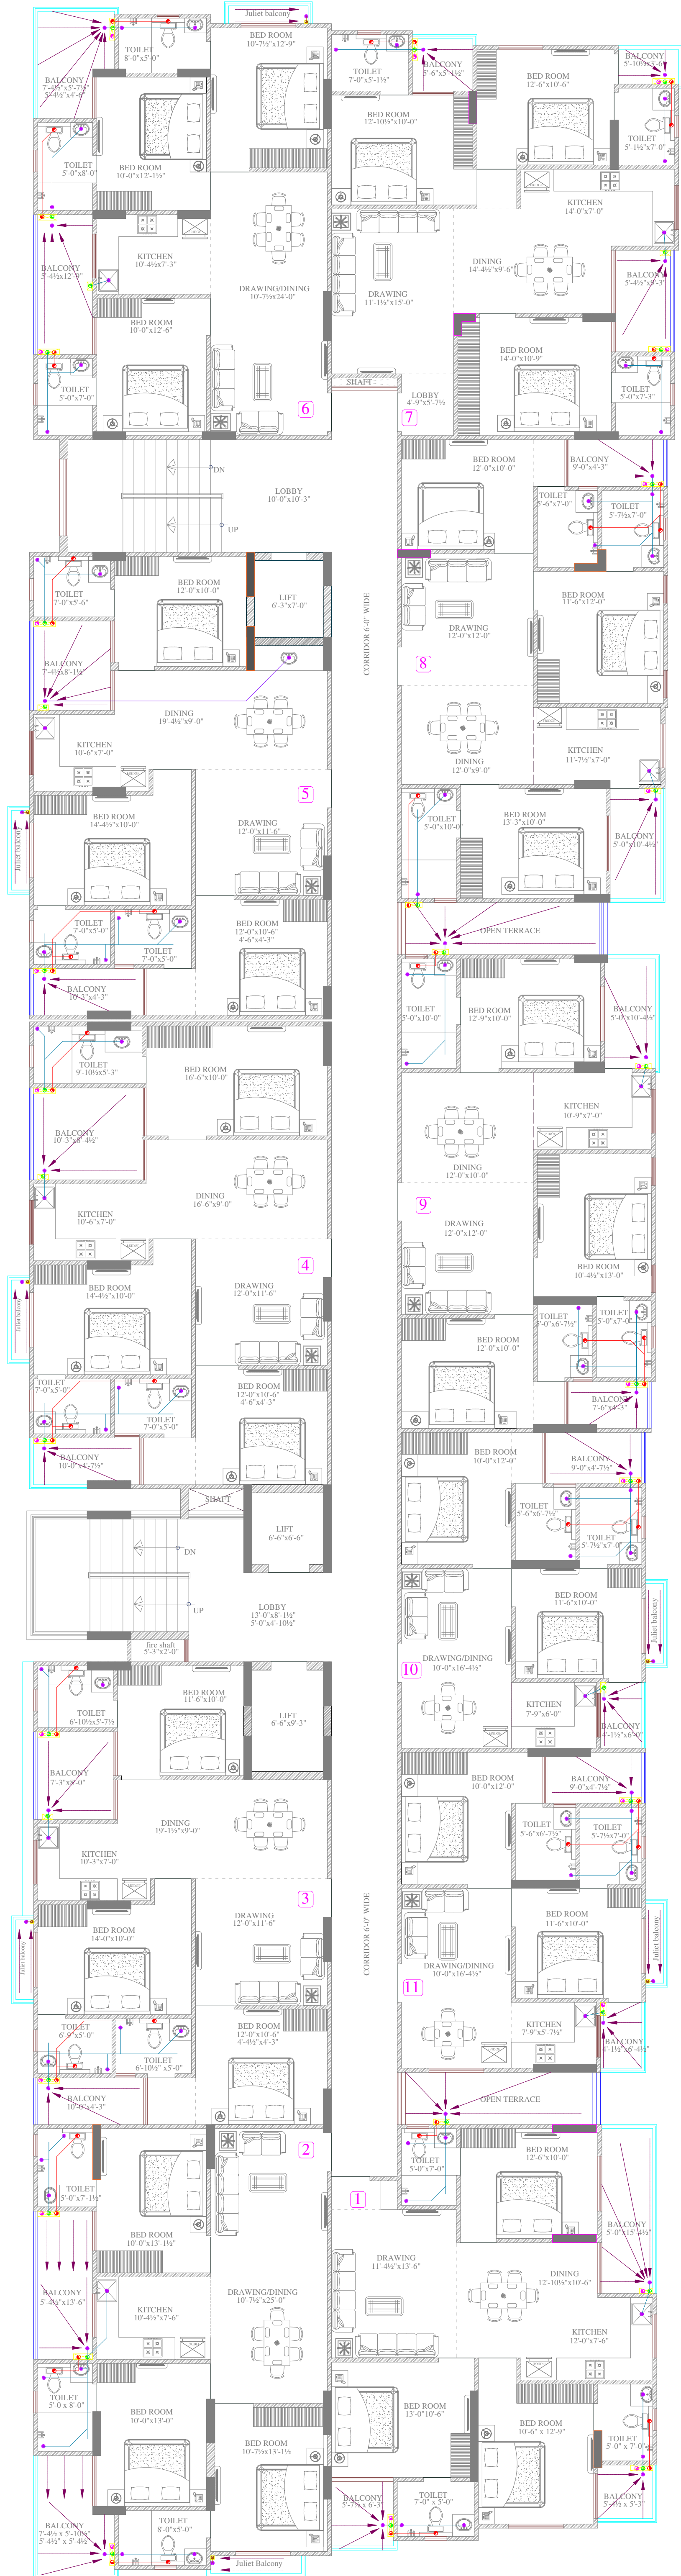

SYMBOL	DESCRIPTION
	Ø110 mm Soil Waste Water Pipe
	Ø110 mm Waste Water Pipe
	Ø110 mm Rain Water Pipe
	Ø160 mm Rain Water Pipe
	Ø110 mm Soil Waste Water Pipe Slope 1:150
	Ø110 mm Waste Water Pipe Slope 1:150
	Ø110 mm Rain Water Pipe Slope 1:200
	Ø75 mm Waste Water Pipe Internal Toilet Slope 1:150
	Ø75 mm Rain Water Pipe
	Ø40mm Waste Water Pipe Bottle Trap
	Floor Trap
	P TRAP
	Flow Direction

SERVICES CONSULTANT

ASHI ASSOCIATES
F 9 / 440 , Keshav Marg Chitrakut
Scheme,Jaipur
PH:91-0-93146-10438 ,0141-2440946
Mail:vipul8599@yahoo.com

SEAL

VIPUL AGARWAL
M.E.P. CONSULTANT
B.E. ELECTRICAL

DRAWN BY:- NITIN

CHECKED BY:- SANJAY

APPROVED BY:- VIPUL AGARWAL

DATE:- 24-07-2025

SCALE = 1:100

PROJECT NAME

ARANYA♂A

CLIENT/BUILDER:-

M G Realinfra Pvt Ltd♂

PROJECT :-


PLOT KHASRA NO.3477/2444 AT REVENUE
VILLAGE- SIROLI TEH.SANGANER, JAIPUR♂

DRAWING:

FIRST FLOOR
DRAINAGE PLAN


ARCHITECT :-

SPACE GRID
C-49,VIDYA
APARTMENT,PARAS MARG,
BAPU NAGAR,NEAR JANTA
STORE CIRCLE, JAIPUR-302015
PH-09314918766,0141-4005506 (O)
Email:-info.spacegrid@gmail.com

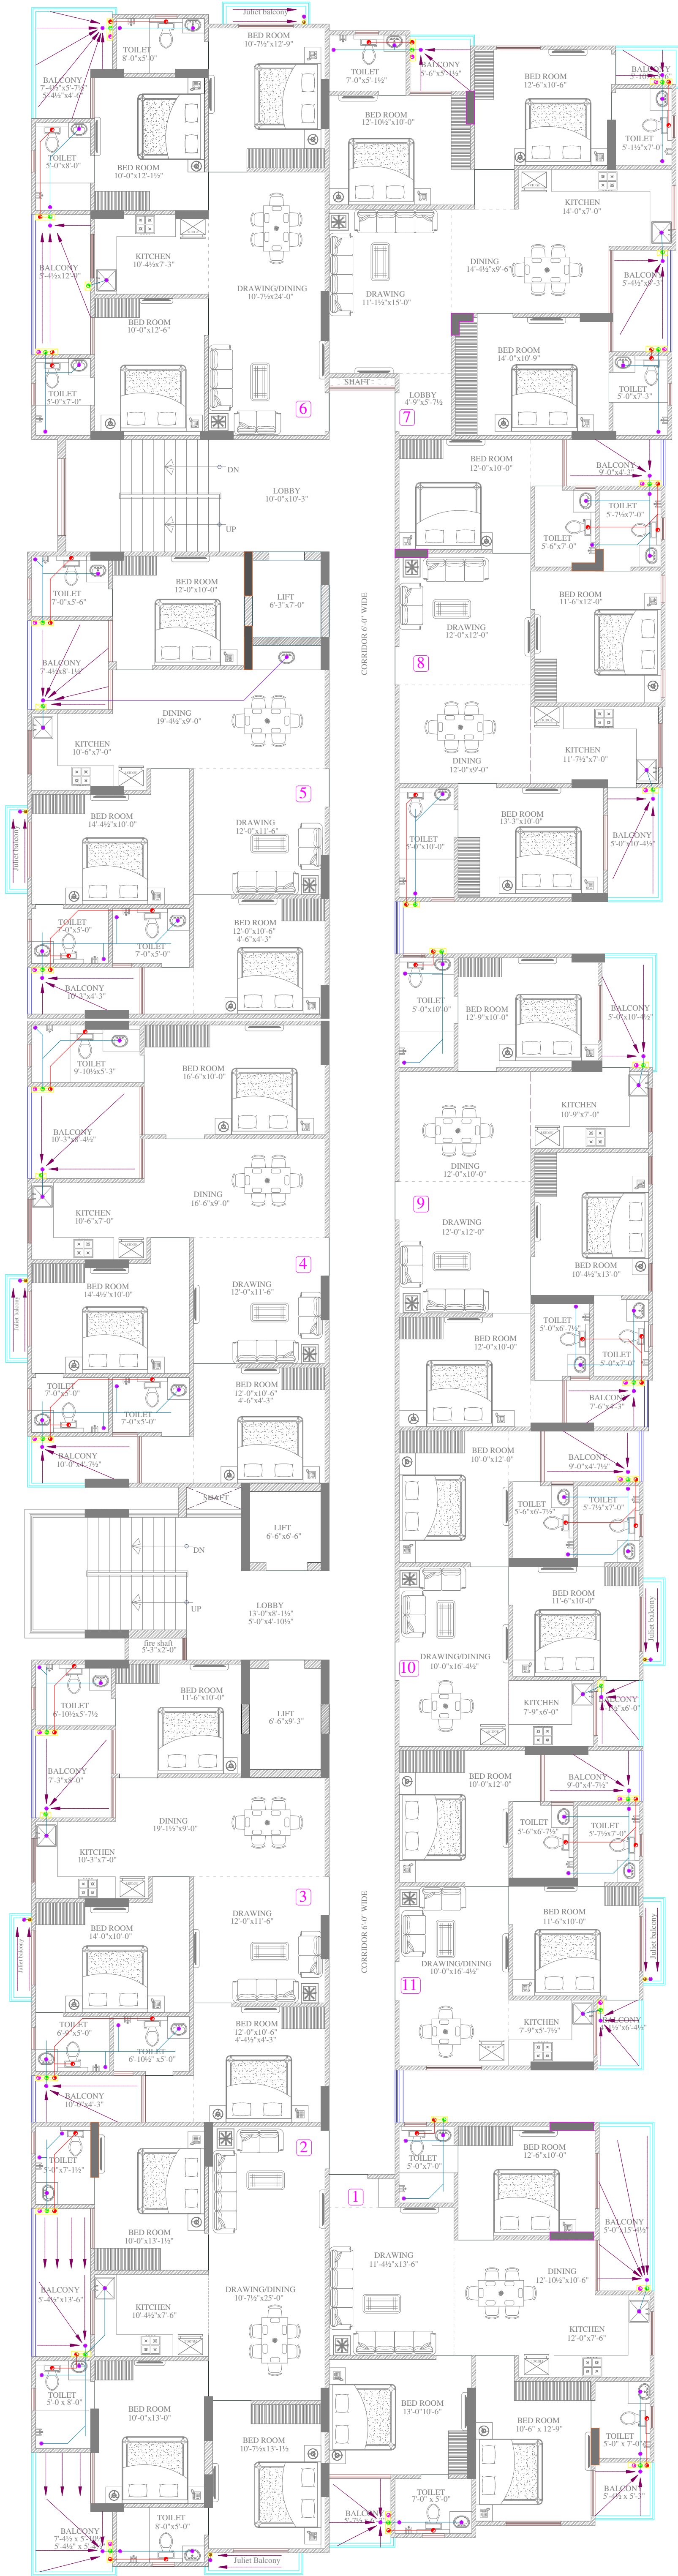

SYMBOL	DESCRIPTION
	Ø110 mm Soil Waste Water Pipe
	Ø110 mm Waste Water Pipe
	Ø110 mm Rain Water Pipe
	Ø160 mm Rain Water Pipe
	Ø110 mm Soil Waste Water Pipe Slope 1:150
	Ø110 mm Waste Water Pipe Slope 1:150
	Ø110 mm Rain Water Pipe Slope 1:200
	Ø75 mm Waste Water Pipe Internal Toilet Slope 1:150
	Ø75 mm Rain Water Pipe
	Ø40mm Waste Water Pipe Bottle Trap
	Floor Trap
	P TRAP
	Flow Direction

SERVICES CONSULTANT	
ASHI ASSOCIATES F 9 / 440 , Keshav Marg Chitrakut Scheme,Jaipur PH:91-0-93146-10438 ,0141-2440946 Mail:vipul8599@yahoo.com	
SEAL	
DRAWN BY:- NITIN	
CHECKED BY:- SANJAY	
APPROVED BY:- VIPUL AGARWAL	
DATE:- 24-07-2025	
SCALE = 1:100	
PROJECT NAME	
ARANYA A	
CLIENT/BUILDER:-	
M G Realinfra Pvt Ltd	
PROJECT :-	
PLOT KHASRA NO.3477/2444 AT REVENUE VILLAGE- SIROLI TEH.SANGANER, JAIPUR	
DRAWING:	
TYPICAL FLOOR (2ND. TO 9TH.) DRAINAGE PLAN	
ARCHITECT :-	
SPACE GRID C-49, VIDYA APARTMENT, PARAS MARG, BAPU NAGAR, NEAR JANTA STORE CIRCLE, JAIPUR-302015 PH-09314918766, 0141-4005506 (O) Email: info.spacegrid@gmail.com	

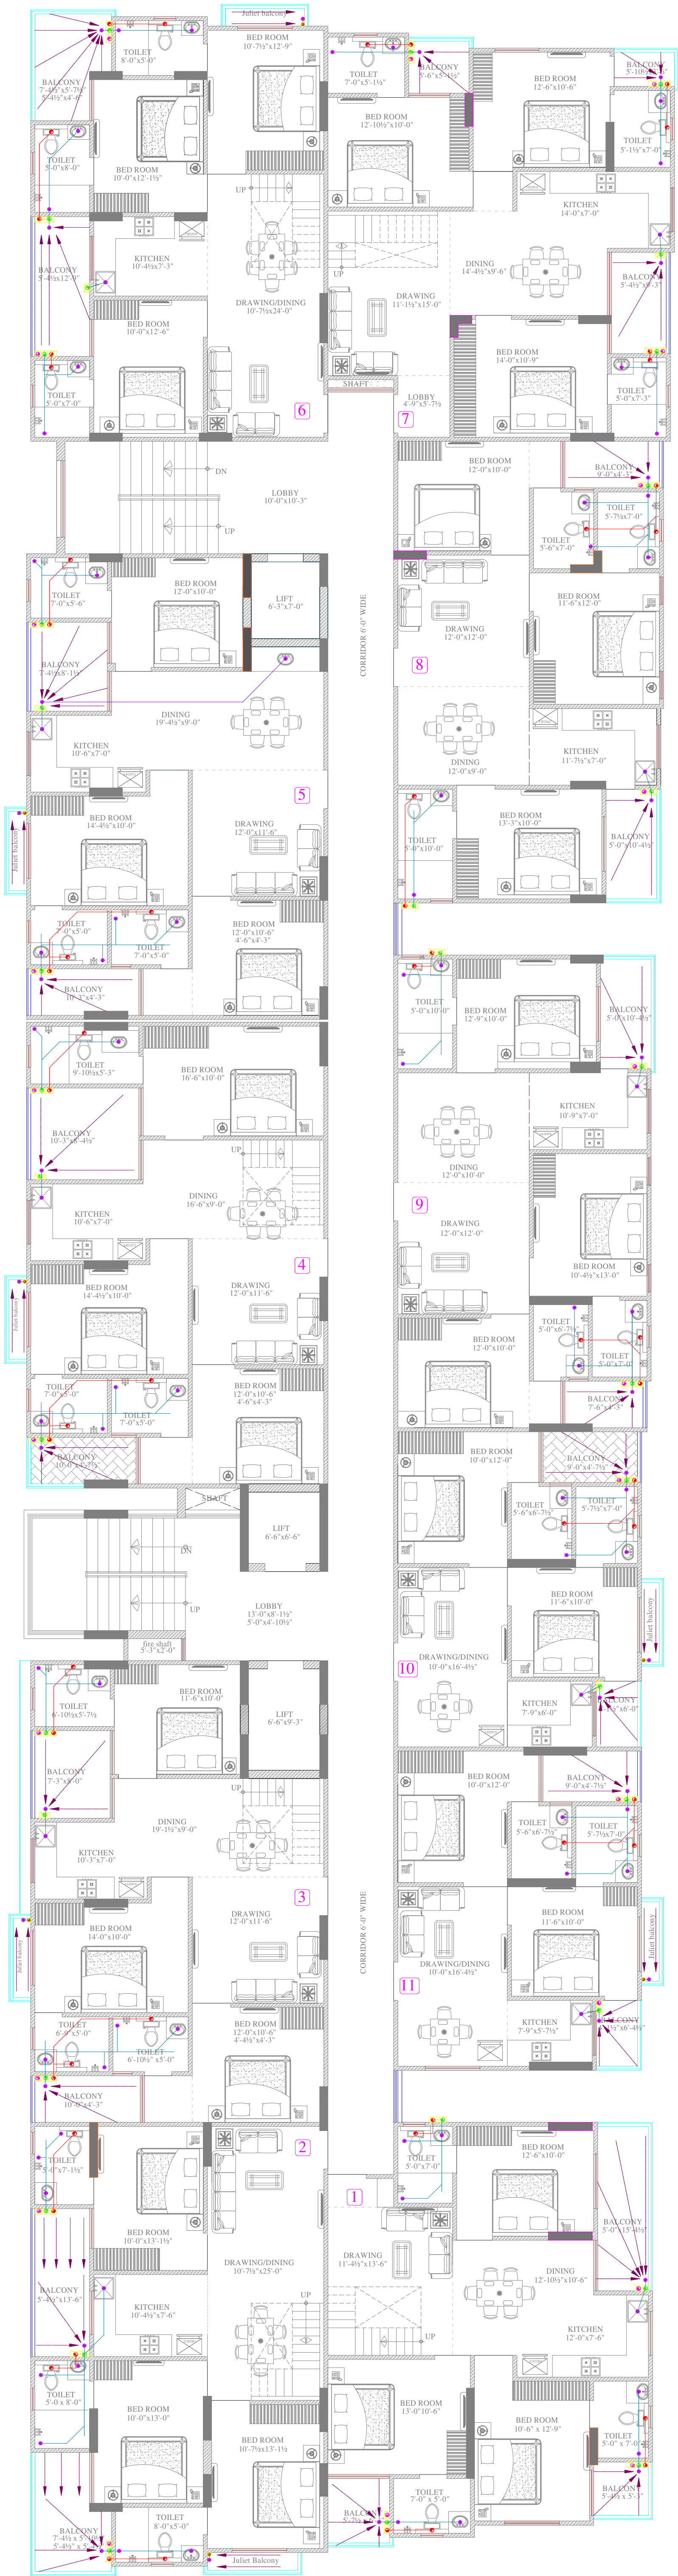

SYMBOL	DESCRIPTION
	Ø110 mm Soil Waste Water Pipe
	Ø110 mm Waste Water Pipe
	Ø110 mm Rain Water Pipe
	Ø160 mm Rain Water Pipe
	Ø110 mm Soil Waste Water Pipe Slope 1:150
	Ø110 mm Waste Water Pipe Slope 1:150
	Ø110 mm Rain Water Pipe Slope 1:200
	Ø75 mm Waste Water Pipe Internal Toilet Slope 1:150
	Ø75 mm Rain Water Pipe
	Ø40mm Waste Water Pipe Bottle Trap
	Floor Trap
	P TRAP
	Flow Direction

SERVICES CONSULTANT

ASHI ASSOCIATES
F 9 / 440 , Keshav Marg Chitrakut
Scheme,Jaipur
PH:91-0-93146-10438 ,0141-2440946
Mail:vipul8599@yahoo.com

SEAL

VIPUL AGARWAL
M.E.P. CONSULTANT
B.E. ELECTRICAL

DRAWN BY:- NITIN

CHECKED BY:- SANJAY

APPROVED BY:- VIPUL AGARWAL

DATE:- 24-07-2025

SCALE = 1:100

PROJECT NAME

ARANYA♂A

CLIENT/BUILDER:-

M G Realinfra Pvt Ltd♂

PROJECT :-


PLOT KHASRA NO.3477/2444 AT REVENUE
VILLAGE- SIROLI TEH.SANGANER, JAIPUR♂

DRAWING:

10TH. FLOOR
DRAINAGE PLAN

ARCHITECT :-

SPACE GRID
C-49,VIDYA
APARTMENT,PARAS MARG,
BAPU NAGAR,NEAR JANTA
STORE CIRCLE, JAIPUR-302015
PH-09314918766,0141-4005506 (O)
Email:-info.spacegrid@gmail.com

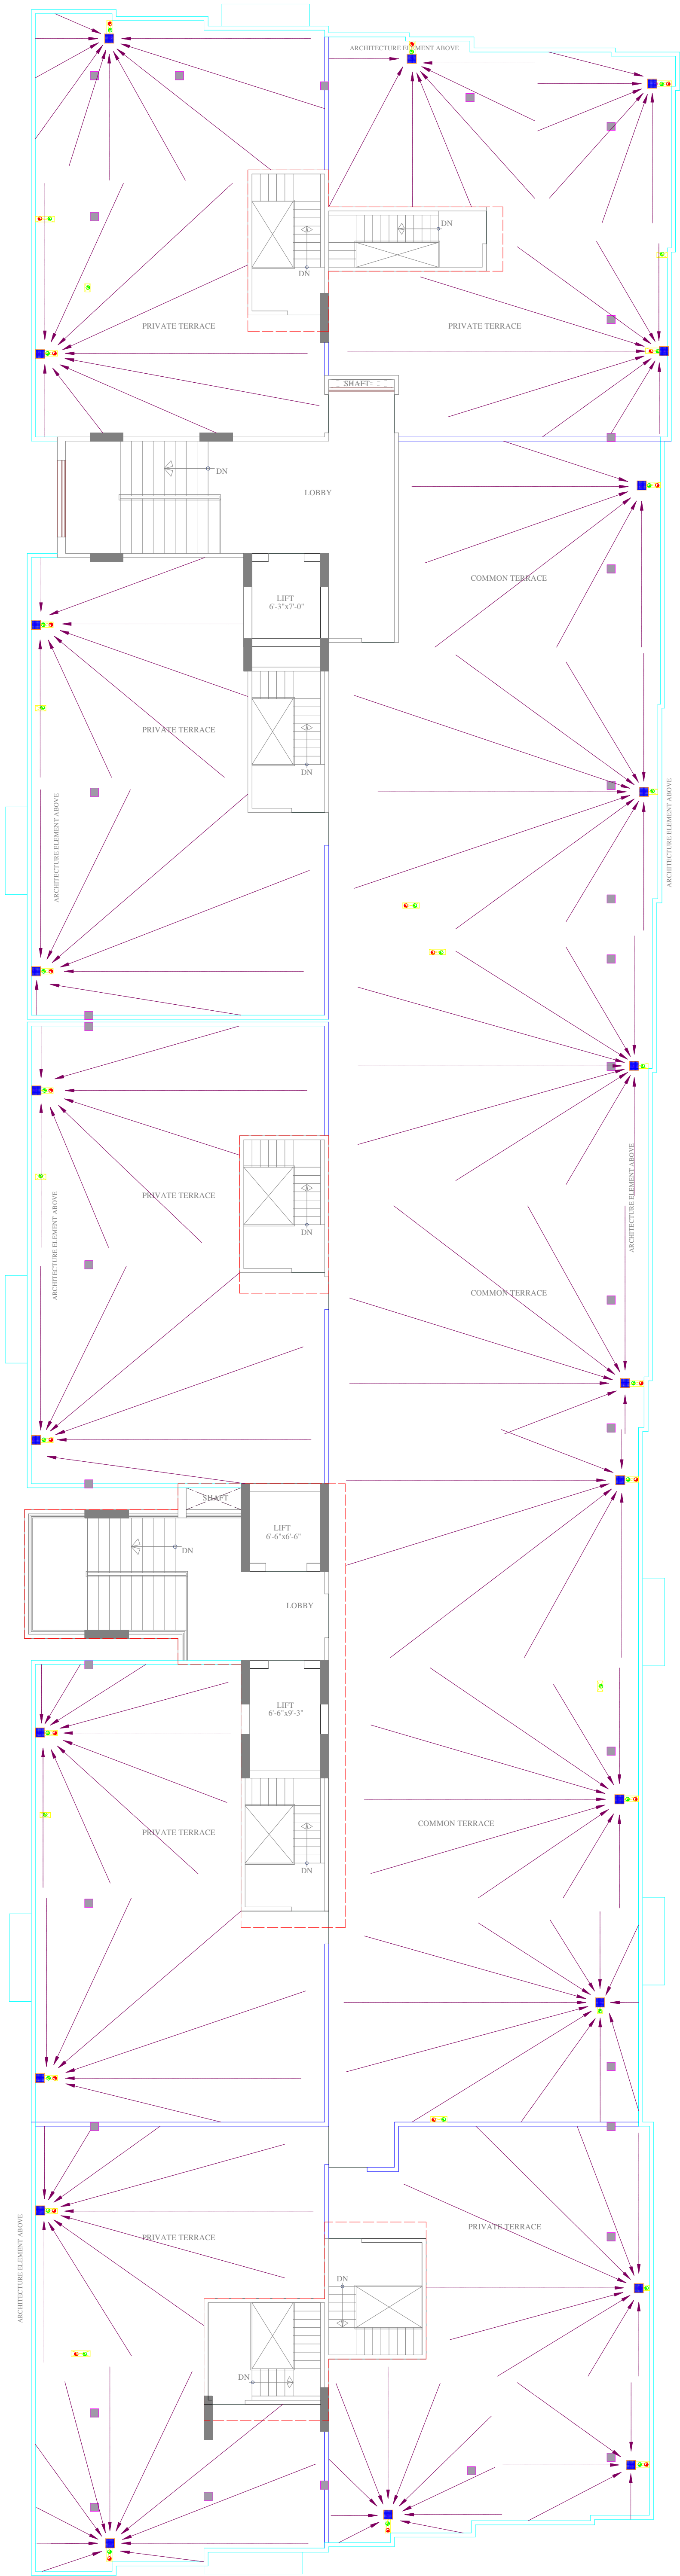

SYMBOL	DESCRIPTION
	110 mm Soil Waste Water Pipe
	110 mm Waste Water Pipe
	110 mm Rain Water Pipe
	110 mm Soil Waste Water Pipe
	110 mm Waste Water Pipe
	110 mm Rain Water Pipe
	75 mm Waste Water Pipe
	75 mm Rain Water Pipe
	50mm Waste Water Pipe Bottle Trap
	Floor Trap
	Flow Direction
	KHURRA 9"X9"

SERVICES CONSULTANT

ASHI ASSOCIATES
F 9 / 440 , Keshav Marg Chitrakut Scheme,Jaipur
PH:91-0-93146-10438 ,0141-2440946
Mail:vipul8599@yahoo.com

SEAL

VIPUL AGARWAL
M.E.P. CONSULTANT
B.E. ELECTRICAL

DRAWN BY:- NITIN

CHECKED BY:- SANJAY

APPROVED BY:- VIPUL AGARWAL

DATE:- 24-07-2025

SCALE = 1:100

PROJECT NAME

ARANYA A

CLIENT/BUILDER:-

M G Realinfra Pvt Ltd

PROJECT :-


PLOT KHASRA NO.3477/2444 AT REVENUE VILLAGE- SIROLI TEH.SANGANER, JAIPUR

DRAWING:

TERRACE FLOOR RAIN WATER SLOPE PLAN

ARCHITECT :-

SPACE GRID
C-49,VIDYA
APARTMENT,PARAS MARG,
BAPU NAGAR,NEAR JANTA
STORE CIRCLE, JAIPUR-302015
PH-09314918766,0141-4005506 (O)
Email:-info.spacegrid@gmail.com

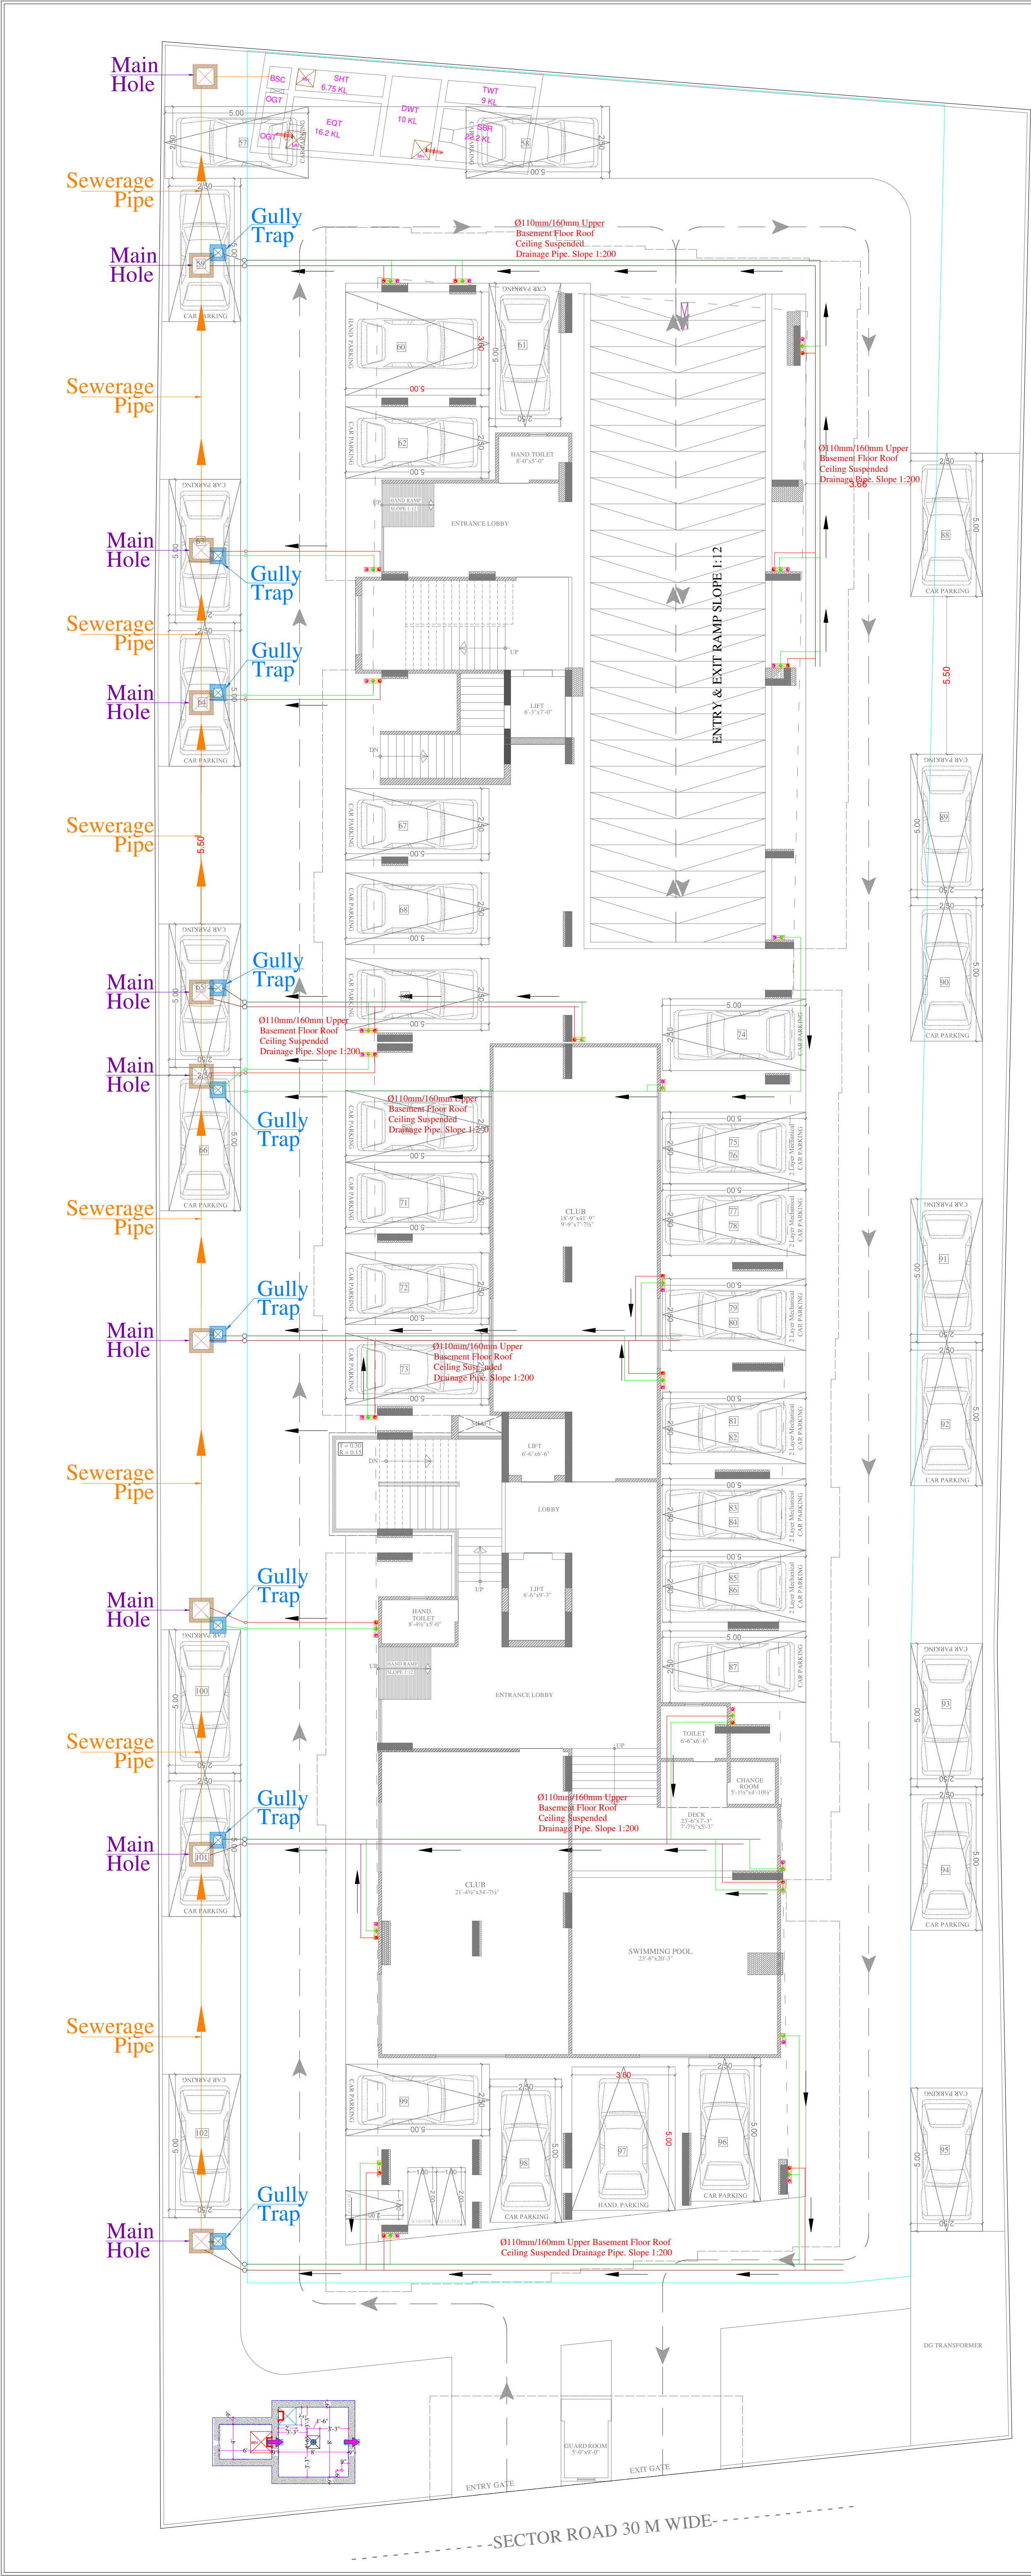

SYMBOL	DESCRIPTION
	Ø110 mm Soil Waste Water Pipe
	Ø110 mm Waste Water Pipe
	Ø110 mm Rain Water Pipe
	Ø200 mm Soil Waste Water Pipe
	Ø160 mm Soil Waste Water Pipe
	Ø160 mm Waste Water Pipe
	Ø110 mm Soil Waste Water Pipe
	Ø110 mm Waste Water Pipe
	Gully Trap
	Main Hole
	Flow Direction

SERVICES CONSULTANT	
ASHI ASSOCIATES F 9 / 440 , Keshav Marg Chitrakut Scheme,Jaipur PH:91-0-93146-10438 ,0141-2440946 Mail:vipul8599@yahoo.com	
SEAL	
DRAWN BY:- NITIN	
CHECKED BY:- SANJAY	
APPROVED BY:- VIPUL AGARWAL	
DATE:- 24-07-2025	
SCALE = 1:100	
PROJECT NAME	
ARANYA A	
CLIENT/BUILDER:-	
M G Realinfra Pvt Ltd	
PROJECT :-	
PLOT KHASRA NO.3477/2444 AT REVENUE VILLAGE- SIROLI TEH.SANGANER, JAIPUR	
DRAWING:	
EXTERNAL SEWERAGE PIPE ROUTE PLAN	
ARCHITECT :-	
SPACE GRID C-49,VIDYA APARTMENT,PARAS MARG, BAPU NAGAR,NEAR JANTA STORE CIRCLE, JAIPUR-302015 PH-09314918766,0141-4005506 (O) Email:-info.spacegrid@gmail.com	