


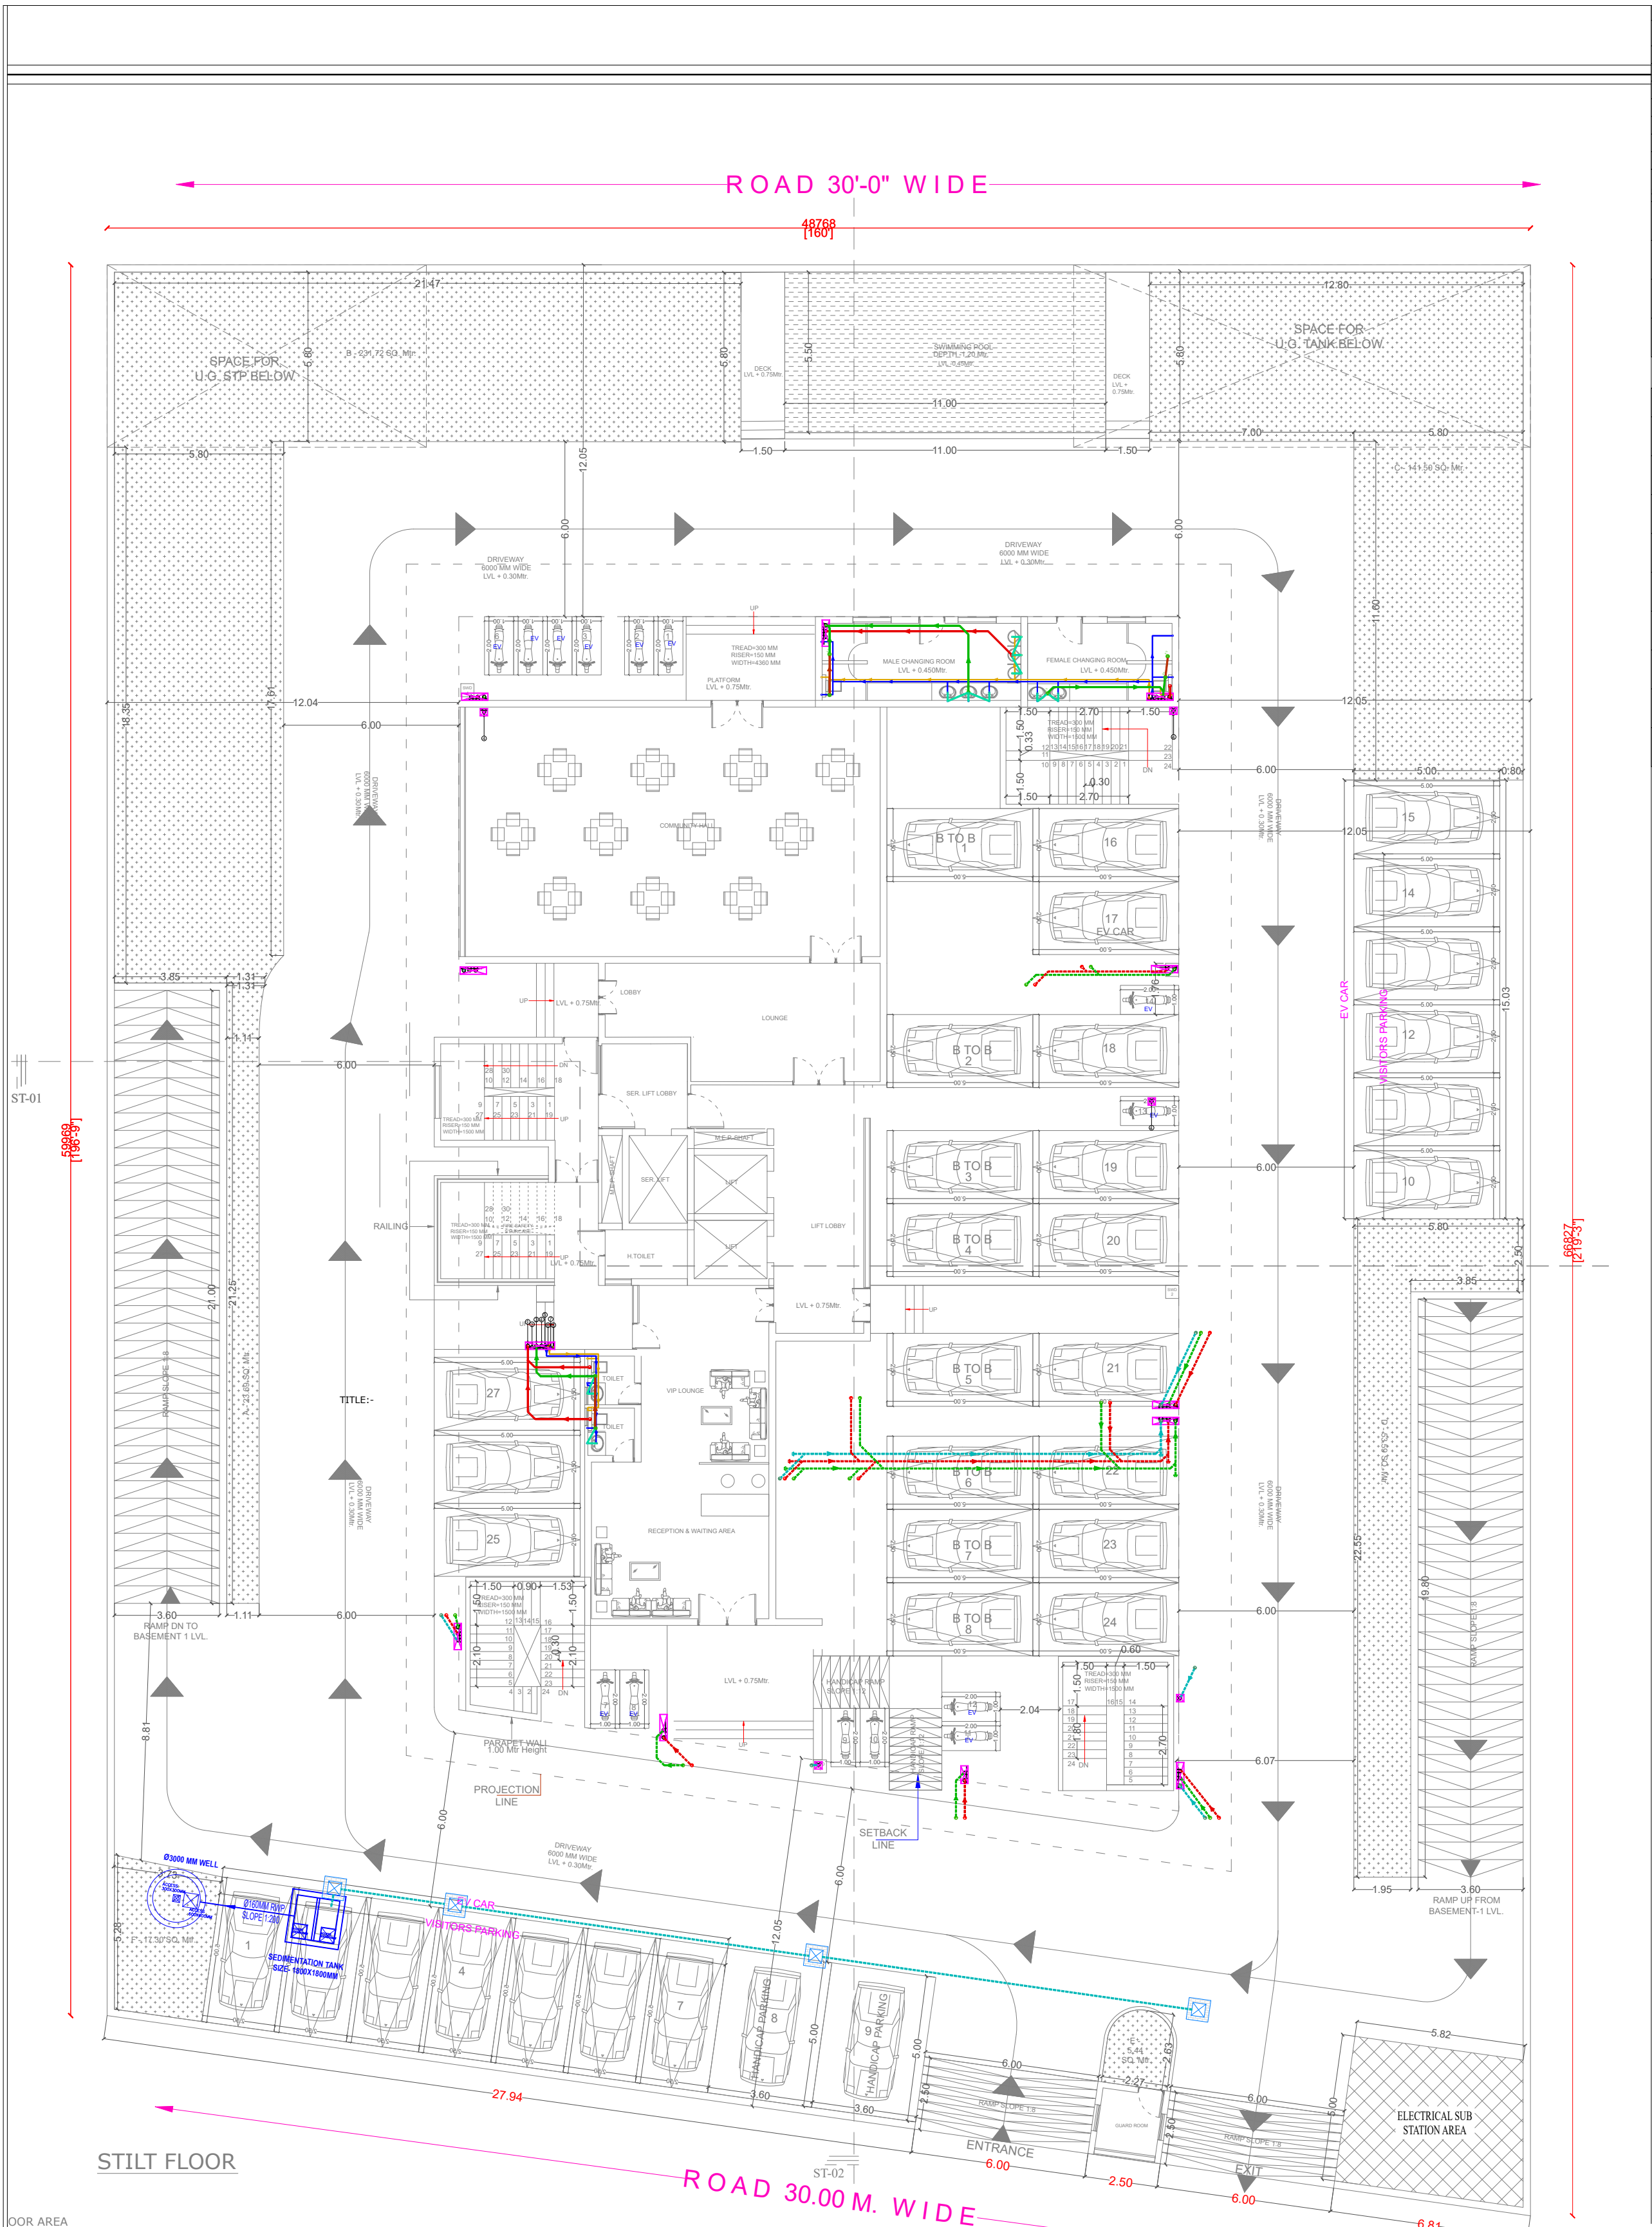




LEGENDS:			
Sr.No.	SYMBOL	NAME	DESCRIPTION
1.		CWP	COLD WATER PIPE
2.		FWP	FLUSH WATER PIPE
3.			BALL VALVE
4.		CWSP	COLD WATER PIPE LINE
5.		FWSP	FLUSH WATER PIPE LINE
6.			40MM COLD WATER LINE - INTERNAL
7.			40MM FLUSH WATER LINE - INTERNAL

Sr.No	Description	SYMBOL	Item
1.	COLD WATER SUPPLY		5
2.	FLUSH WATER SUPPLY		6
3.	COLD WATER SUPPLY		7
4.	FLUSH WATER SUPPLY		8

Sr.No	Description	SYMBOL	Item
1.	Ø110 MM SOIL WATER PIPE		1
2.	Ø75 MM VENT PIPE		2
3.	Ø110 MM WASTE WATER DRAINAGE PIPE		3
4.	Ø110 MM RAIN WATER DRAINAGE PIPE		4
5.	Ø50 MM WASTE WATER DRAINAGE PIPE		
6.	Ø75 MM WASTE WATER DRAINAGE PIPE		
7.	Ø110 MM WASTE WATER DRAINAGE PIPE		
8.	Ø110 MM SOIL WATER DRAINAGE PIPE		
9.	Ø110 MM RAIN WATER DRAINAGE PIPE		

SUDHIR MATHUR
M.E.P.F. CONSULTANT
S.E. MECHANICAL

REV. NO.	DESCRIPTION TO REVISION	REV. BY	DATE	ARCHITECT	PROJECT NAME	PROJECT ADDRESS	DWG. TITLE	DRP CONSULTANTS	DEALT BY	CHECKED BY	DIRECTION
1.					VAYU	PLOT NO. 13,14,15&16 MOHAN NAGAR VILL. MANYAWAS TEHSIL-SANGANER, JAIPUR, RAJASTHAN.	STILT FLOOR WATER SUPPLY & DRAINAGE PLAN	D-27, JANPATEL NEW SANGANER ROAD, MANYAWAS, JAIPUR, RAJ-302019 PH: 9029614281 E-MAIL: shreshthaconsultants@gmail.com www.shreshthaconsultants.com	RAKESH	JITENDRA	N
2.					SIDDHIASH DEVELOPERS LLP		FOR RERA SUBMISSION				

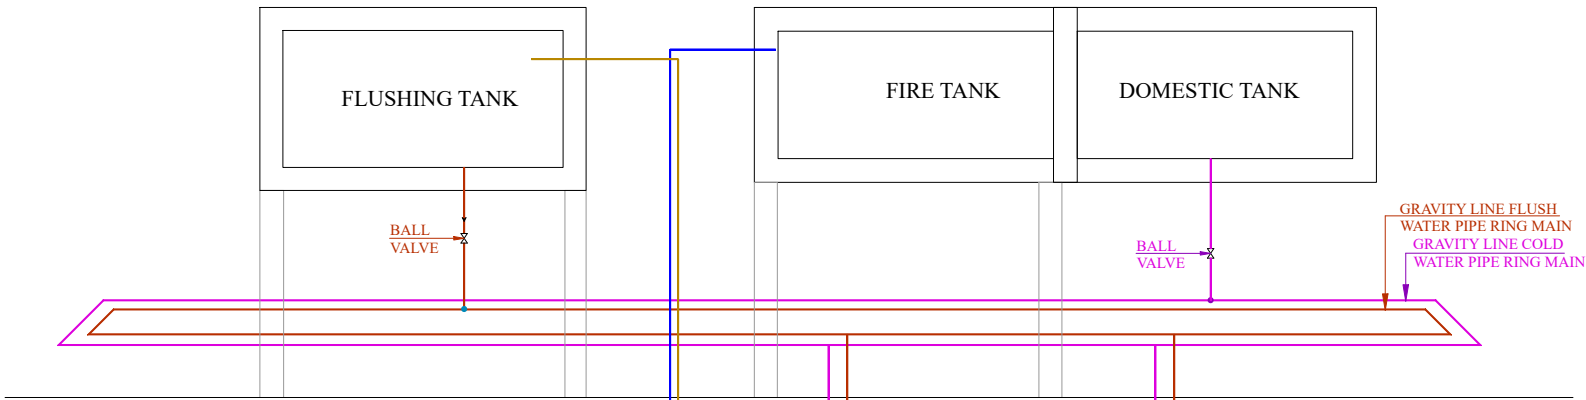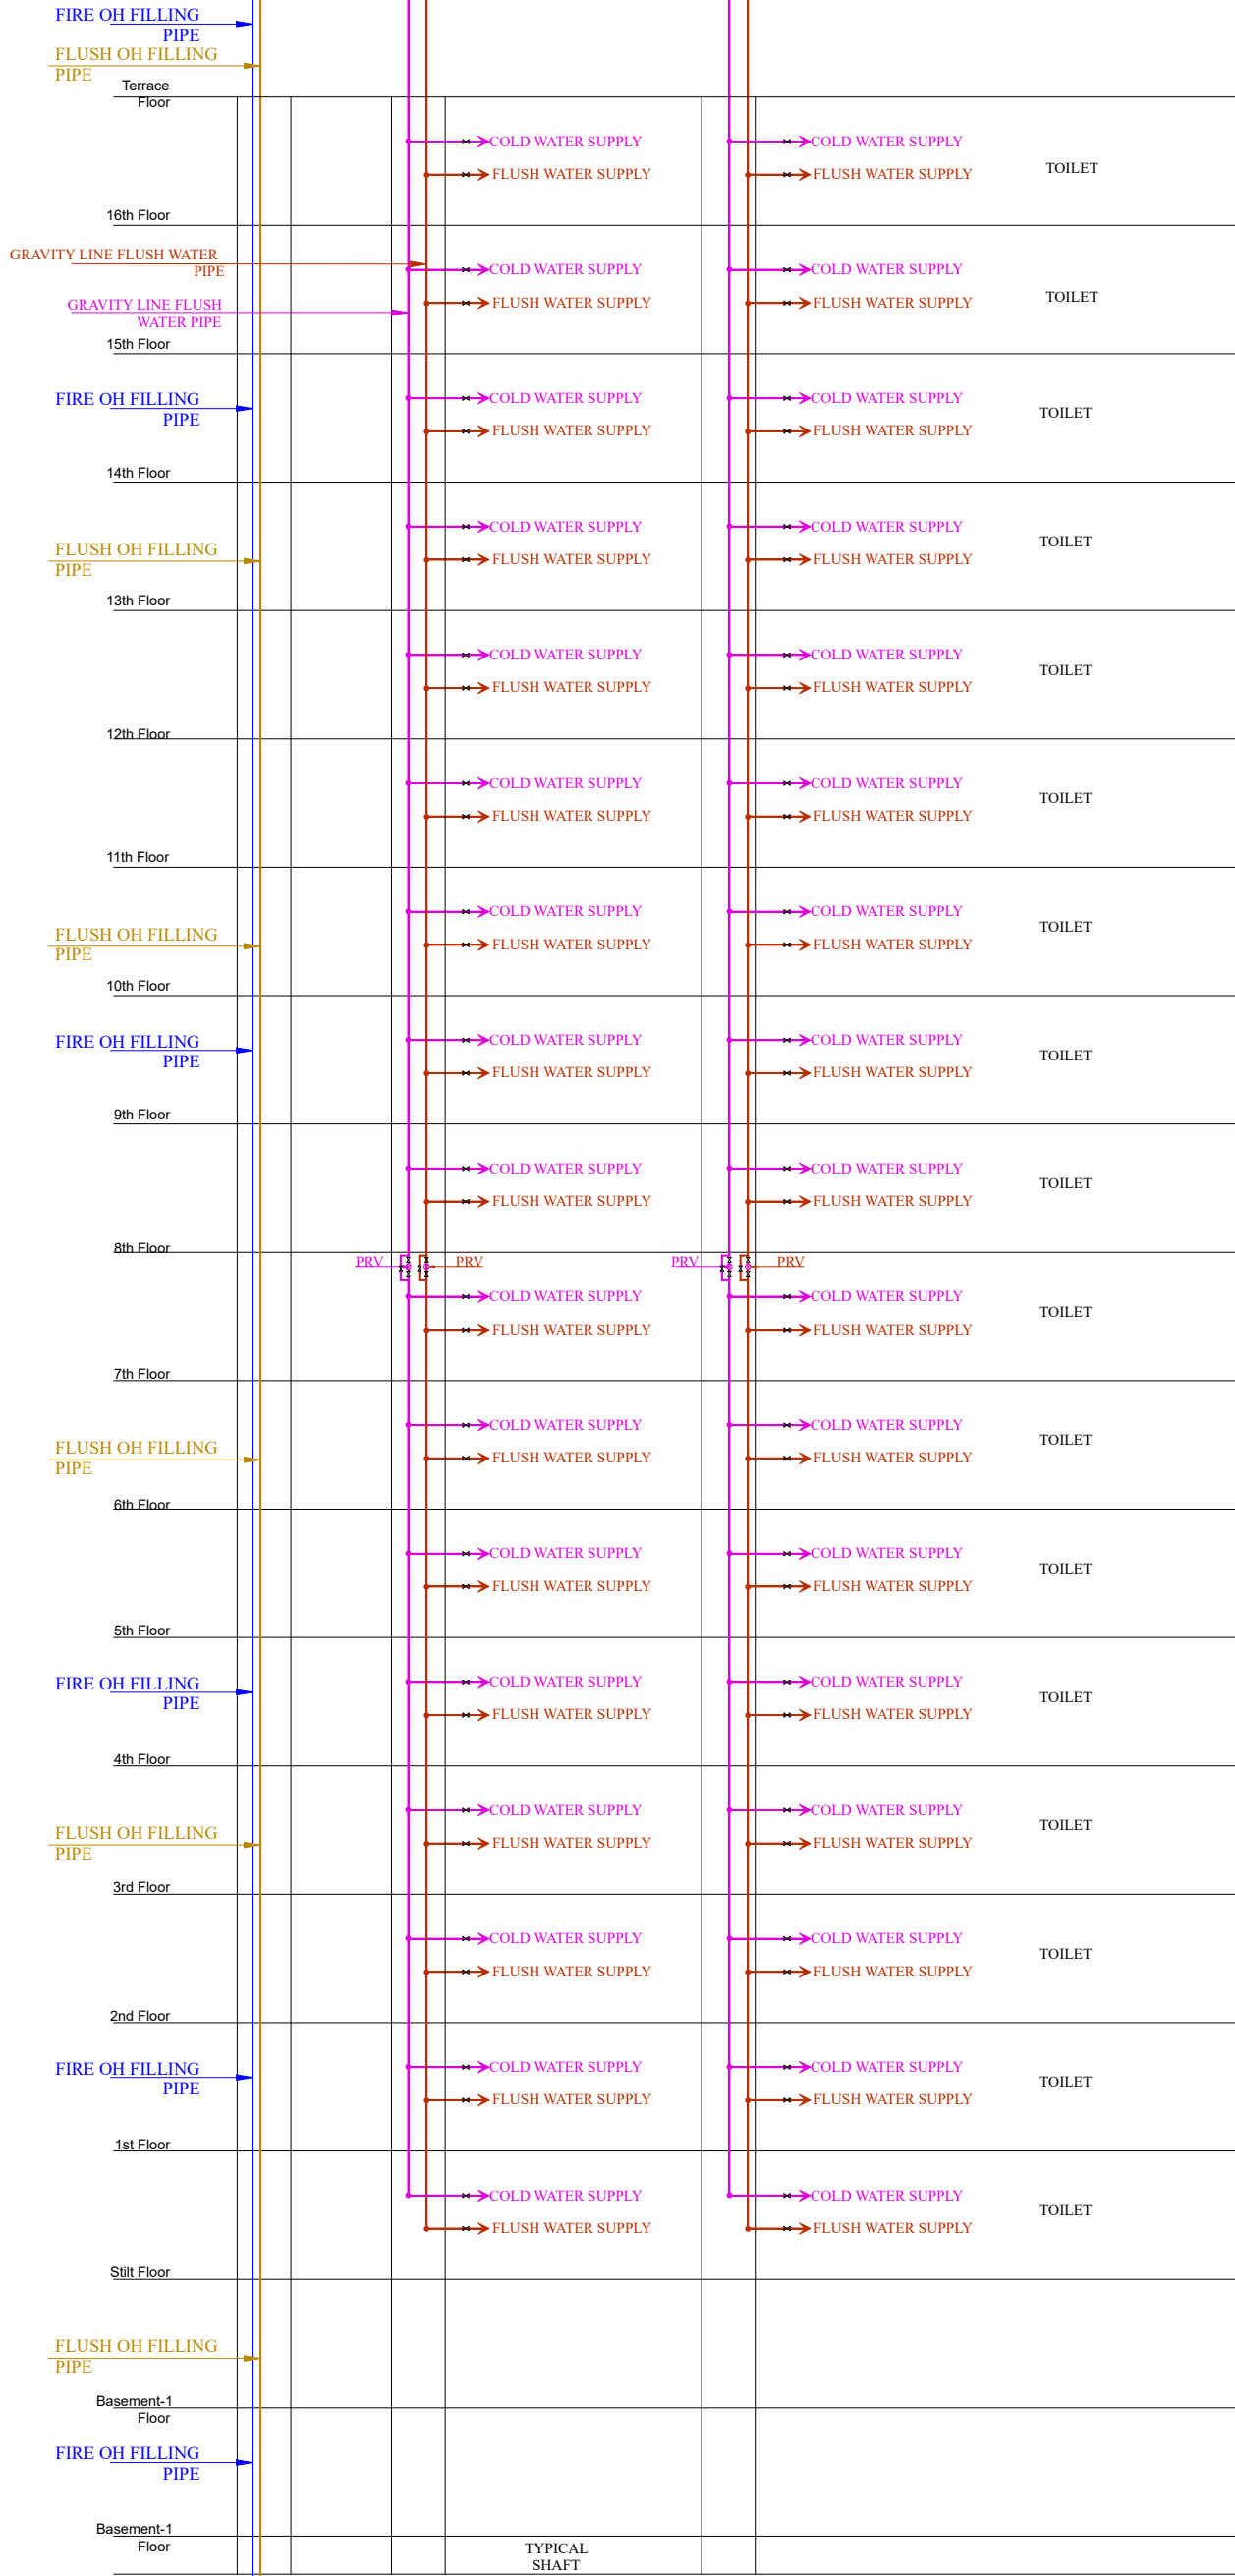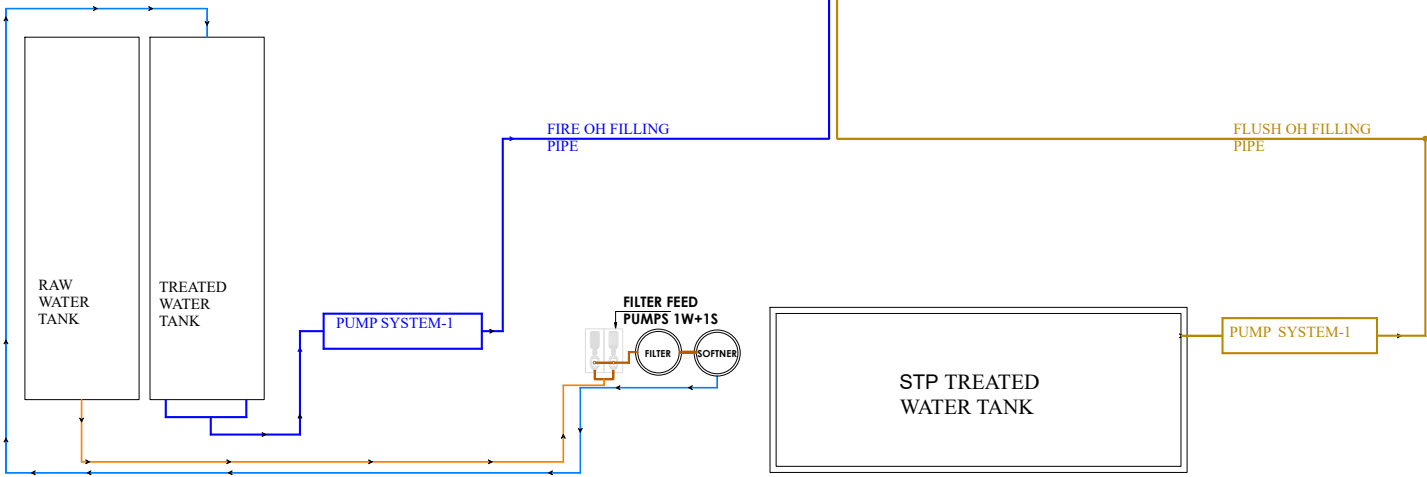

SANITATION SLD

LEGENDS:			
Sr.No.	SYMBOL	NAME	DESCRIPTION
1.		CWP	COLD WATER PIPE
2.		FWP	FLUSH WATER PIPE
3.			BALL VALVE
4.		CWSP	COLD WATER PIPE LINE
5.		FWSP	FLUSH WATER PIPE LINE
6.			420MM COLD WATER LINE - INTERNAL
7.			420MM FLUSH WATER LINE - INTERNAL

Sr.No	Description	SYMBOL	Item
1.	COLD WATER SUPPLY	5	
2.	FLUSH WATER SUPPLY	6	
3.	COLD WATER SUPPLY	7	
4.	FLUSH WATER SUPPLY	8	

SUDHIR MATHUR
M.E.P.F. CONSULTANT
S.E. MECHANICAL

REV. NO.	DESCRIPTION TO REVISION	REV. BY	DATE	ARCHITECT	PROJECT NAME	PROJECT ADDRESS	DWG TITLE	DRP/CONSULTANTS	DEALT BY	CHECKED BY	DIRECTION
1.				Tushar Sogani Designs Pvt. Ltd. architects n designers Studio : 400, F-72, "SURYODAY", Subhash Marg, Bagadaya Bazar, C-Scheme, Jaipur-302001 TEL:- +91-141-4004560, 4004537 email: studio@tsdplarch.com website : www.tsdplarch.com	VAYU	PLOT NO. 13,14,15&16 MOHAN NAGAR VILL.MANYAWAS TEHSIL-SANGANER, JAIPUR, RAJASTHAN.	SANITATION SLD	D-27, JANKYUNEW SANGANER ROAD, JANKYUNEW SANGANER NO.-107 JAIPUR, RAJ.-302019 PH. 9629614281 E-MAIL : shreshthaconsultants@gmail.com design@shreshthaconsultants.com Web : www.shreshthaconsultants.com	RAKESH	JITENDRA	N
2.					SIDDHASH DEVELOPERS LLP		FOR RERA SUBMISSION				