


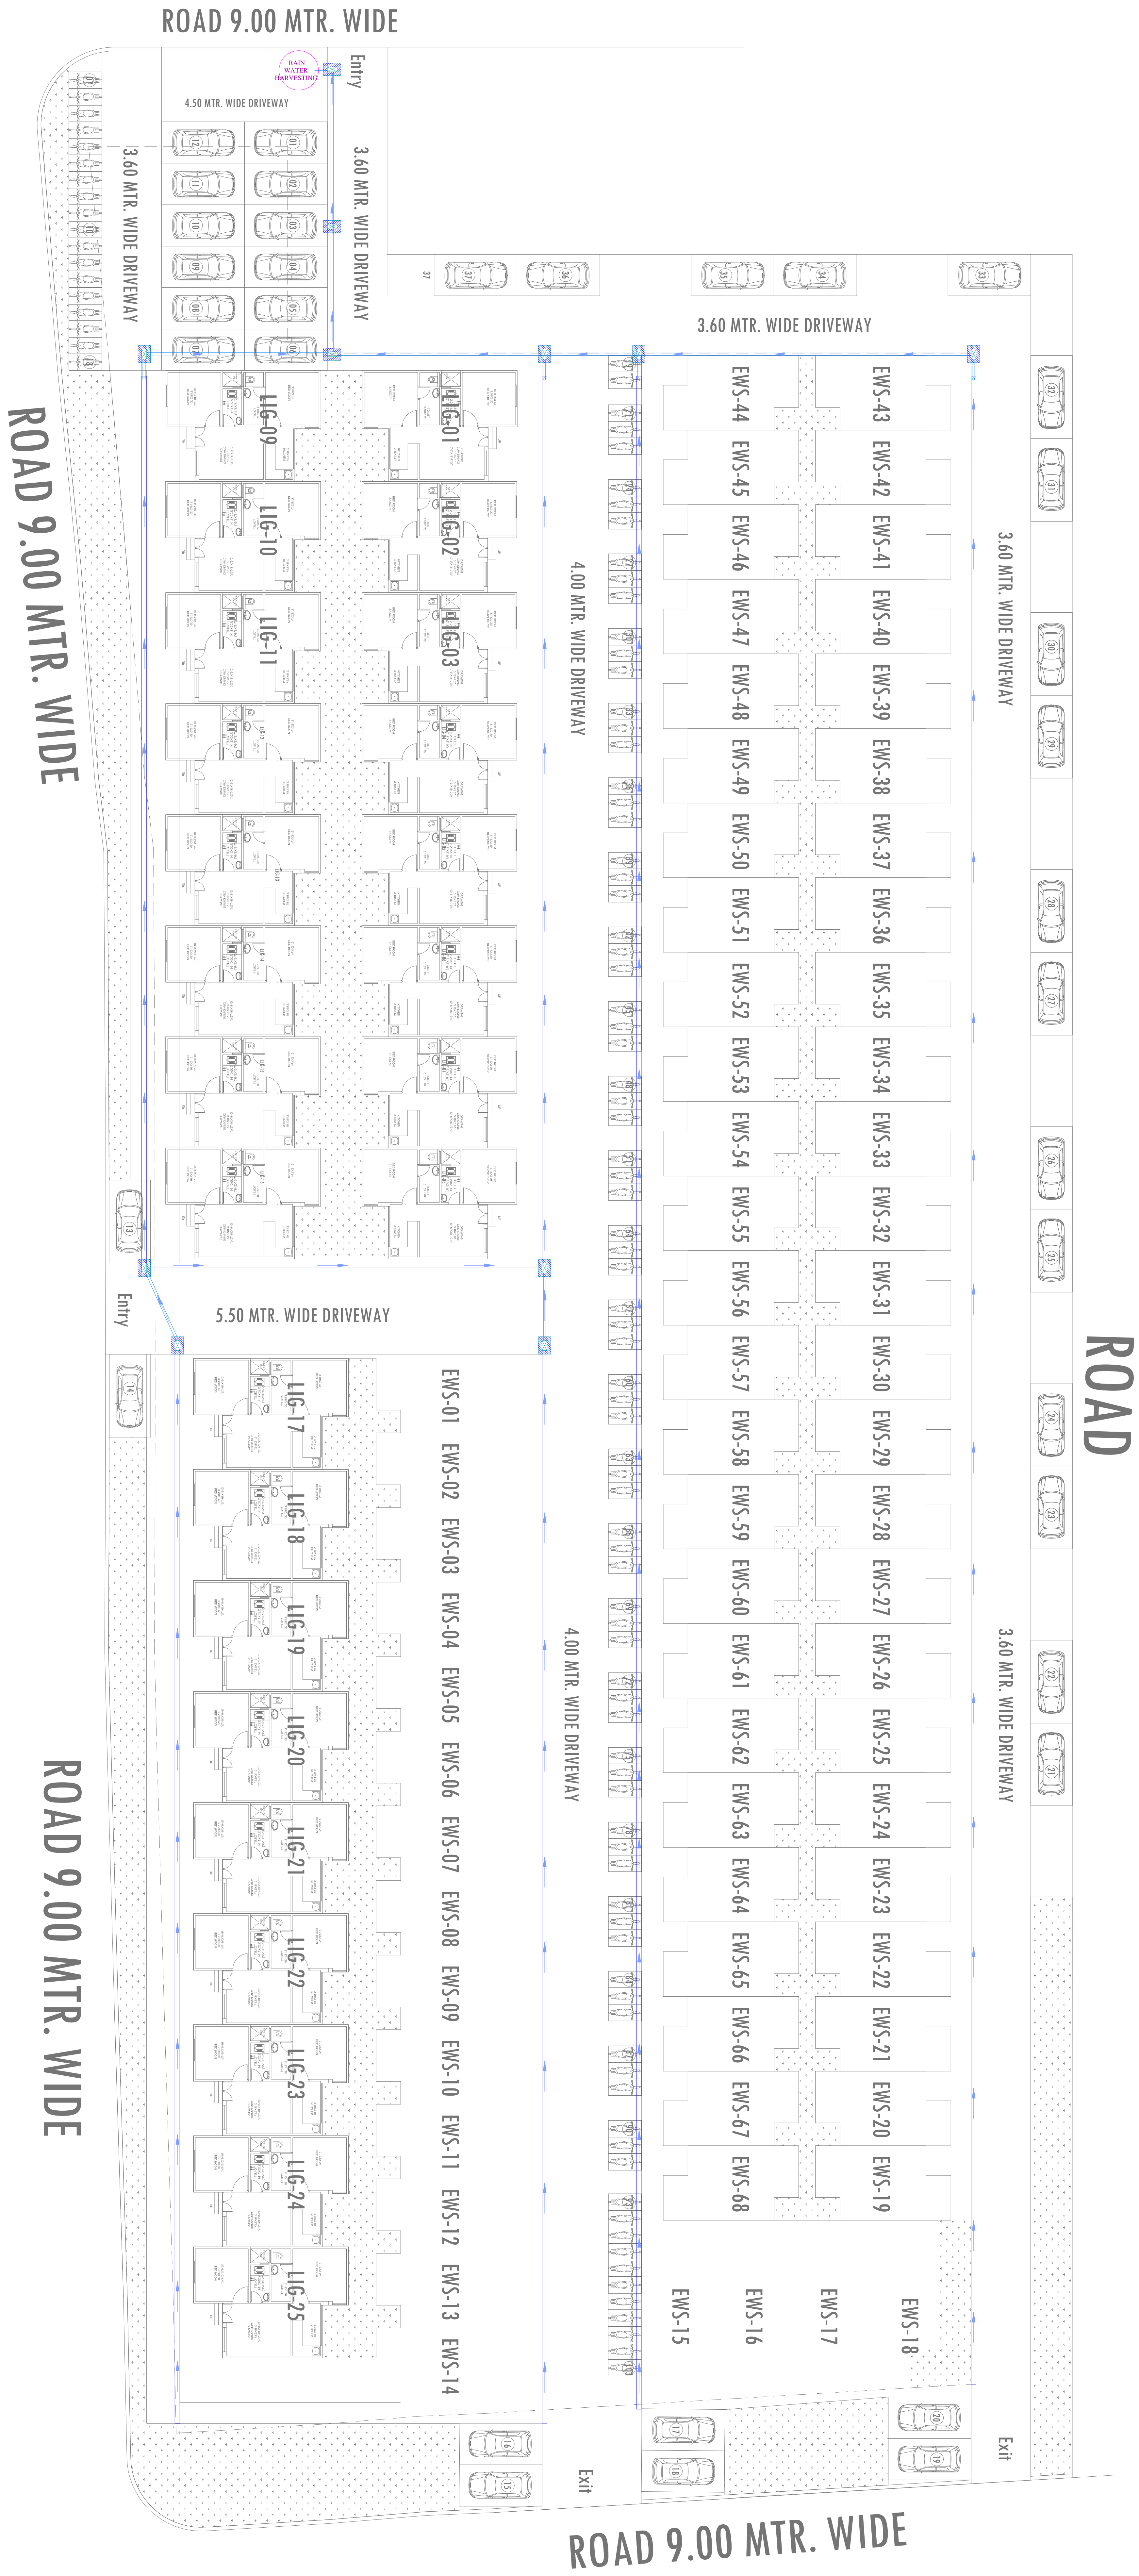

Vipul
VIPUL AGARWAL
M.E.P. CONSULTANT
B.E. ELECTRICAL

QTY	SYMBOL	DESCRIPTION
		RW GRATING CHAMBER
		RW GRATING CHAMBER
		RW GRATING CHAMBER
		RW GRATING CHAMBER
		RW GRATING CHAMBER
		150 MM RAIN WATER PIPE SLOPE 1:200
		200 MM RAIN WATER PIPE SLOPE 1:200

DRAWING TITLE	
EXTERNAL RAIN WATER PIPE ROUTE PLAN	

DATE	07-10-2025
------	------------

SERVICES CONSULTANT: ASHI ASSOCIATES F 9 / 440 , Keshav Marg Chitrakut Scheme,Jaipur PH:91-0-93146-10438 ,0141-2440946 Mail:vipul8599@yahoo.com

ADDRESS :- PROPOSED SITE PLAN OF RESIDENTIAL SCHEME:- "UNIQUE LIFE" UNDER CHIEF MINISTER JAN AAWAS YOJNA SCHEME 3B AT VILLAGE - RAMCHANDPURA, TEHSIL- SANGANER, JAIPUR.

ARCHITECT:- 35,NEMI NAGAR EXT., SHRI PATH, VAISHALI NAGAR,JAIPUR PHONE- 0141-4002369
--

SCALE -1:150	NORTH
--------------	-------

OWNER	ARCHITECT
-------	-----------