
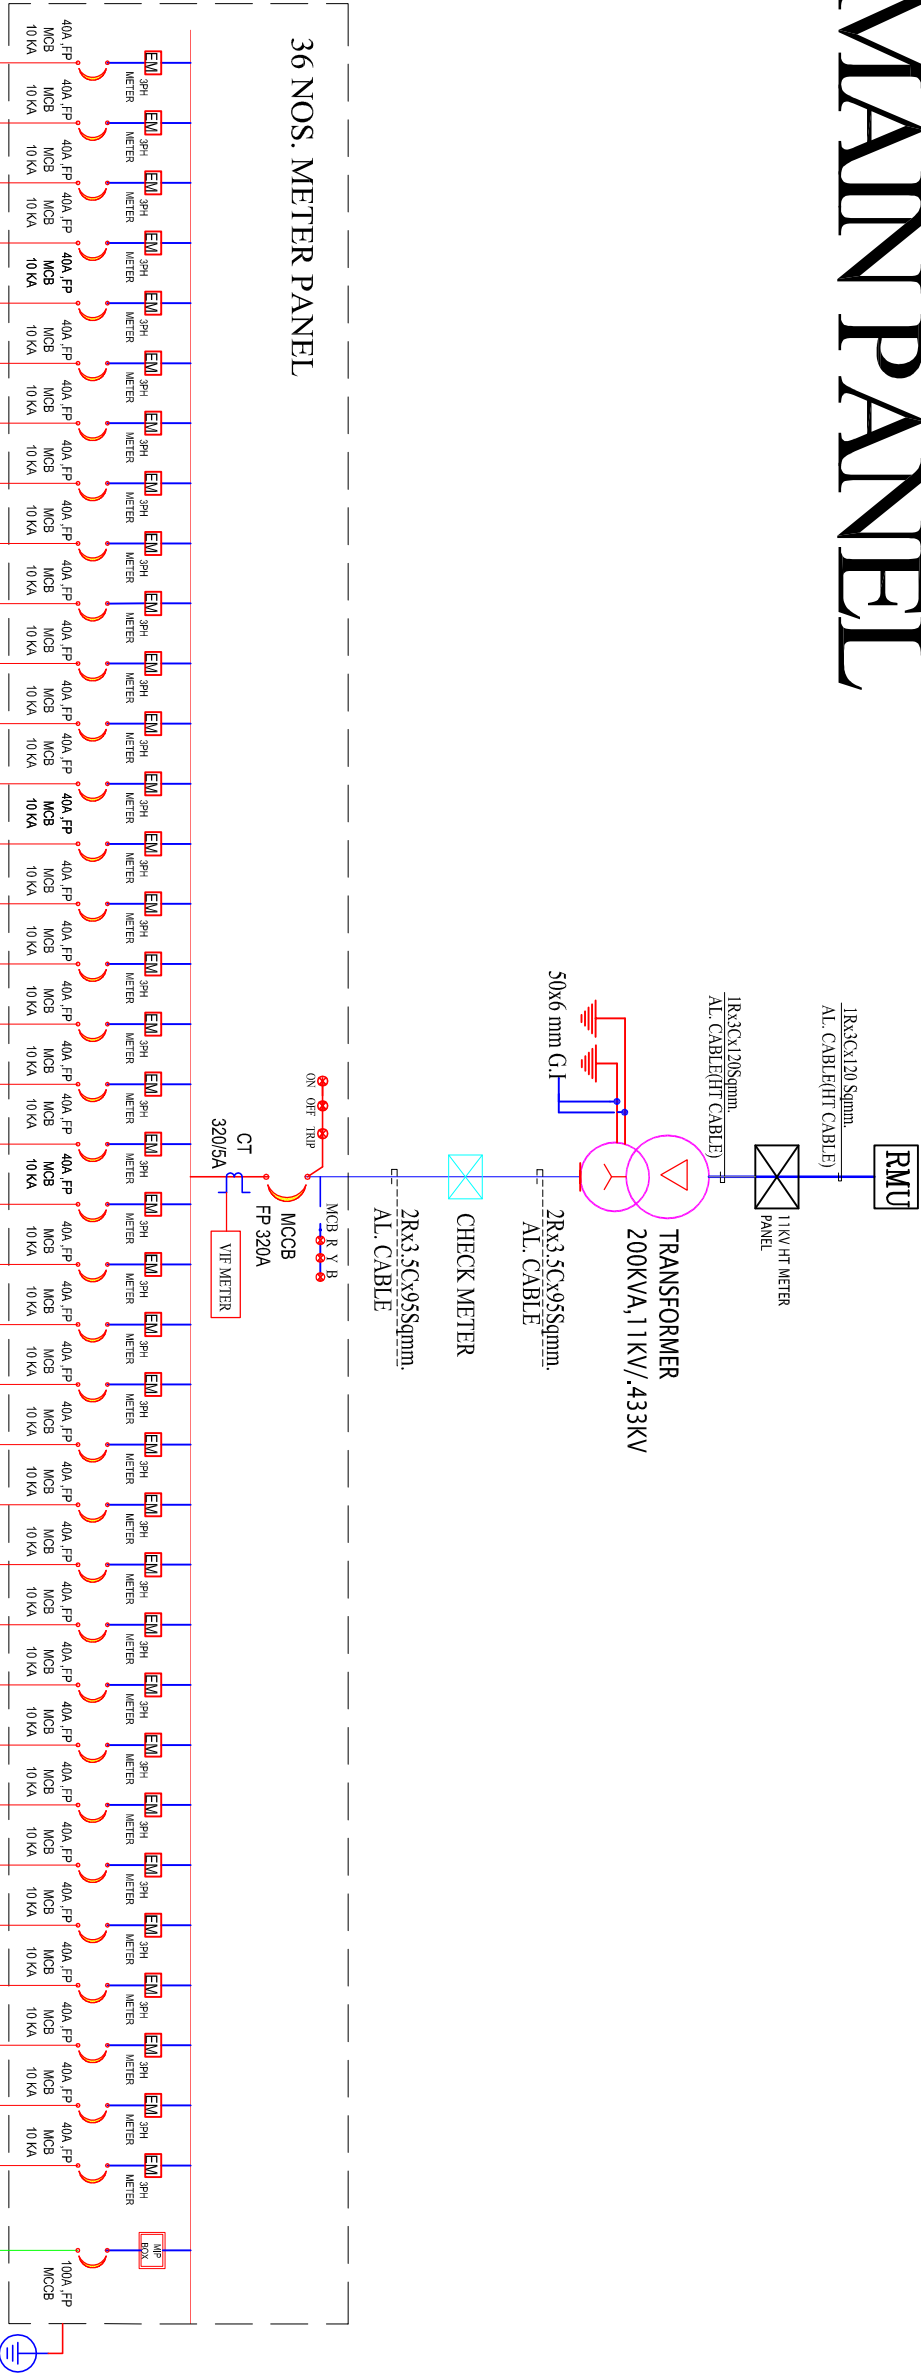


MAIN PANEL

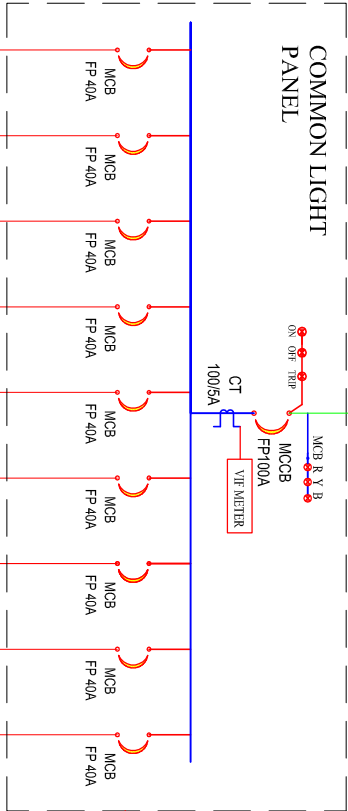

Aman Gupta
Aman Gupta
M.E.P. Consultant
B.E. Electrical

Cube Consultants
Cube Consultants
For RRP Buildcon LLP
Designated Partner

PROPOSED MAIN PANEL
SLD(SINGLE LINE DIAGRAM) LAYOUT

LEGEND:-	
SYMBOL	PARTICULARS
	SOFT STARTER
	VARIABLE FREQUENCY DRIVE
	AIR CIRCUIT BREAKER
	MCB,MCCB
	VIF METER
	METERING CT
	CAPACITOR
	CAPACITOR DUTY CONT.
	MANUAL C/O SWITCH

MEP CONSULTANT :-

cube consultant

A-8, PATH NO. 4, JAMUNA NAGAR,
SODALA, JAIPUR-302006
MAIL:- cubemep@gmail.com
PH. NO. +91 141 2221089, 9214308+30,

DEALT BY
MANISH MEWARA

REVISION

DATE:16.03.2026

DWG NO

TITLE:-

PROPOSED MAIN PANEL.

SLD(SINGLE LINE DIAGRAM) LAYOUT

WORKING DRAWINGS

SCALE:- 1= 100

DATE:

PROJECT NAME:-

THE ROYAL COURTYARD

PROJECT:-

PROPOSED RESIDENTIAL APARTMENT FOR
PLOT NO=60,61,69,70,UDAY VATIKA,
SANGANER,JAIPUR.

CLIENT NAME:-

RRP BUILDCON LLP
RAHUL GUPTA (PARTNER)

ARCHITECT

M/S AKRITI AYOJAN


ARCHITECTS, INTERIOR DESIGNERS.

E-87, THIRD FLOOR, MANGLAM TOWER, RDHISDAI,
GOPALPURA, JAIPUR-302006, RAJASTHAN. 3351154101
surajprakasharch@gmail.com ;

DATE:

NORTH :

9.0 M MAIN WIDE ROAD

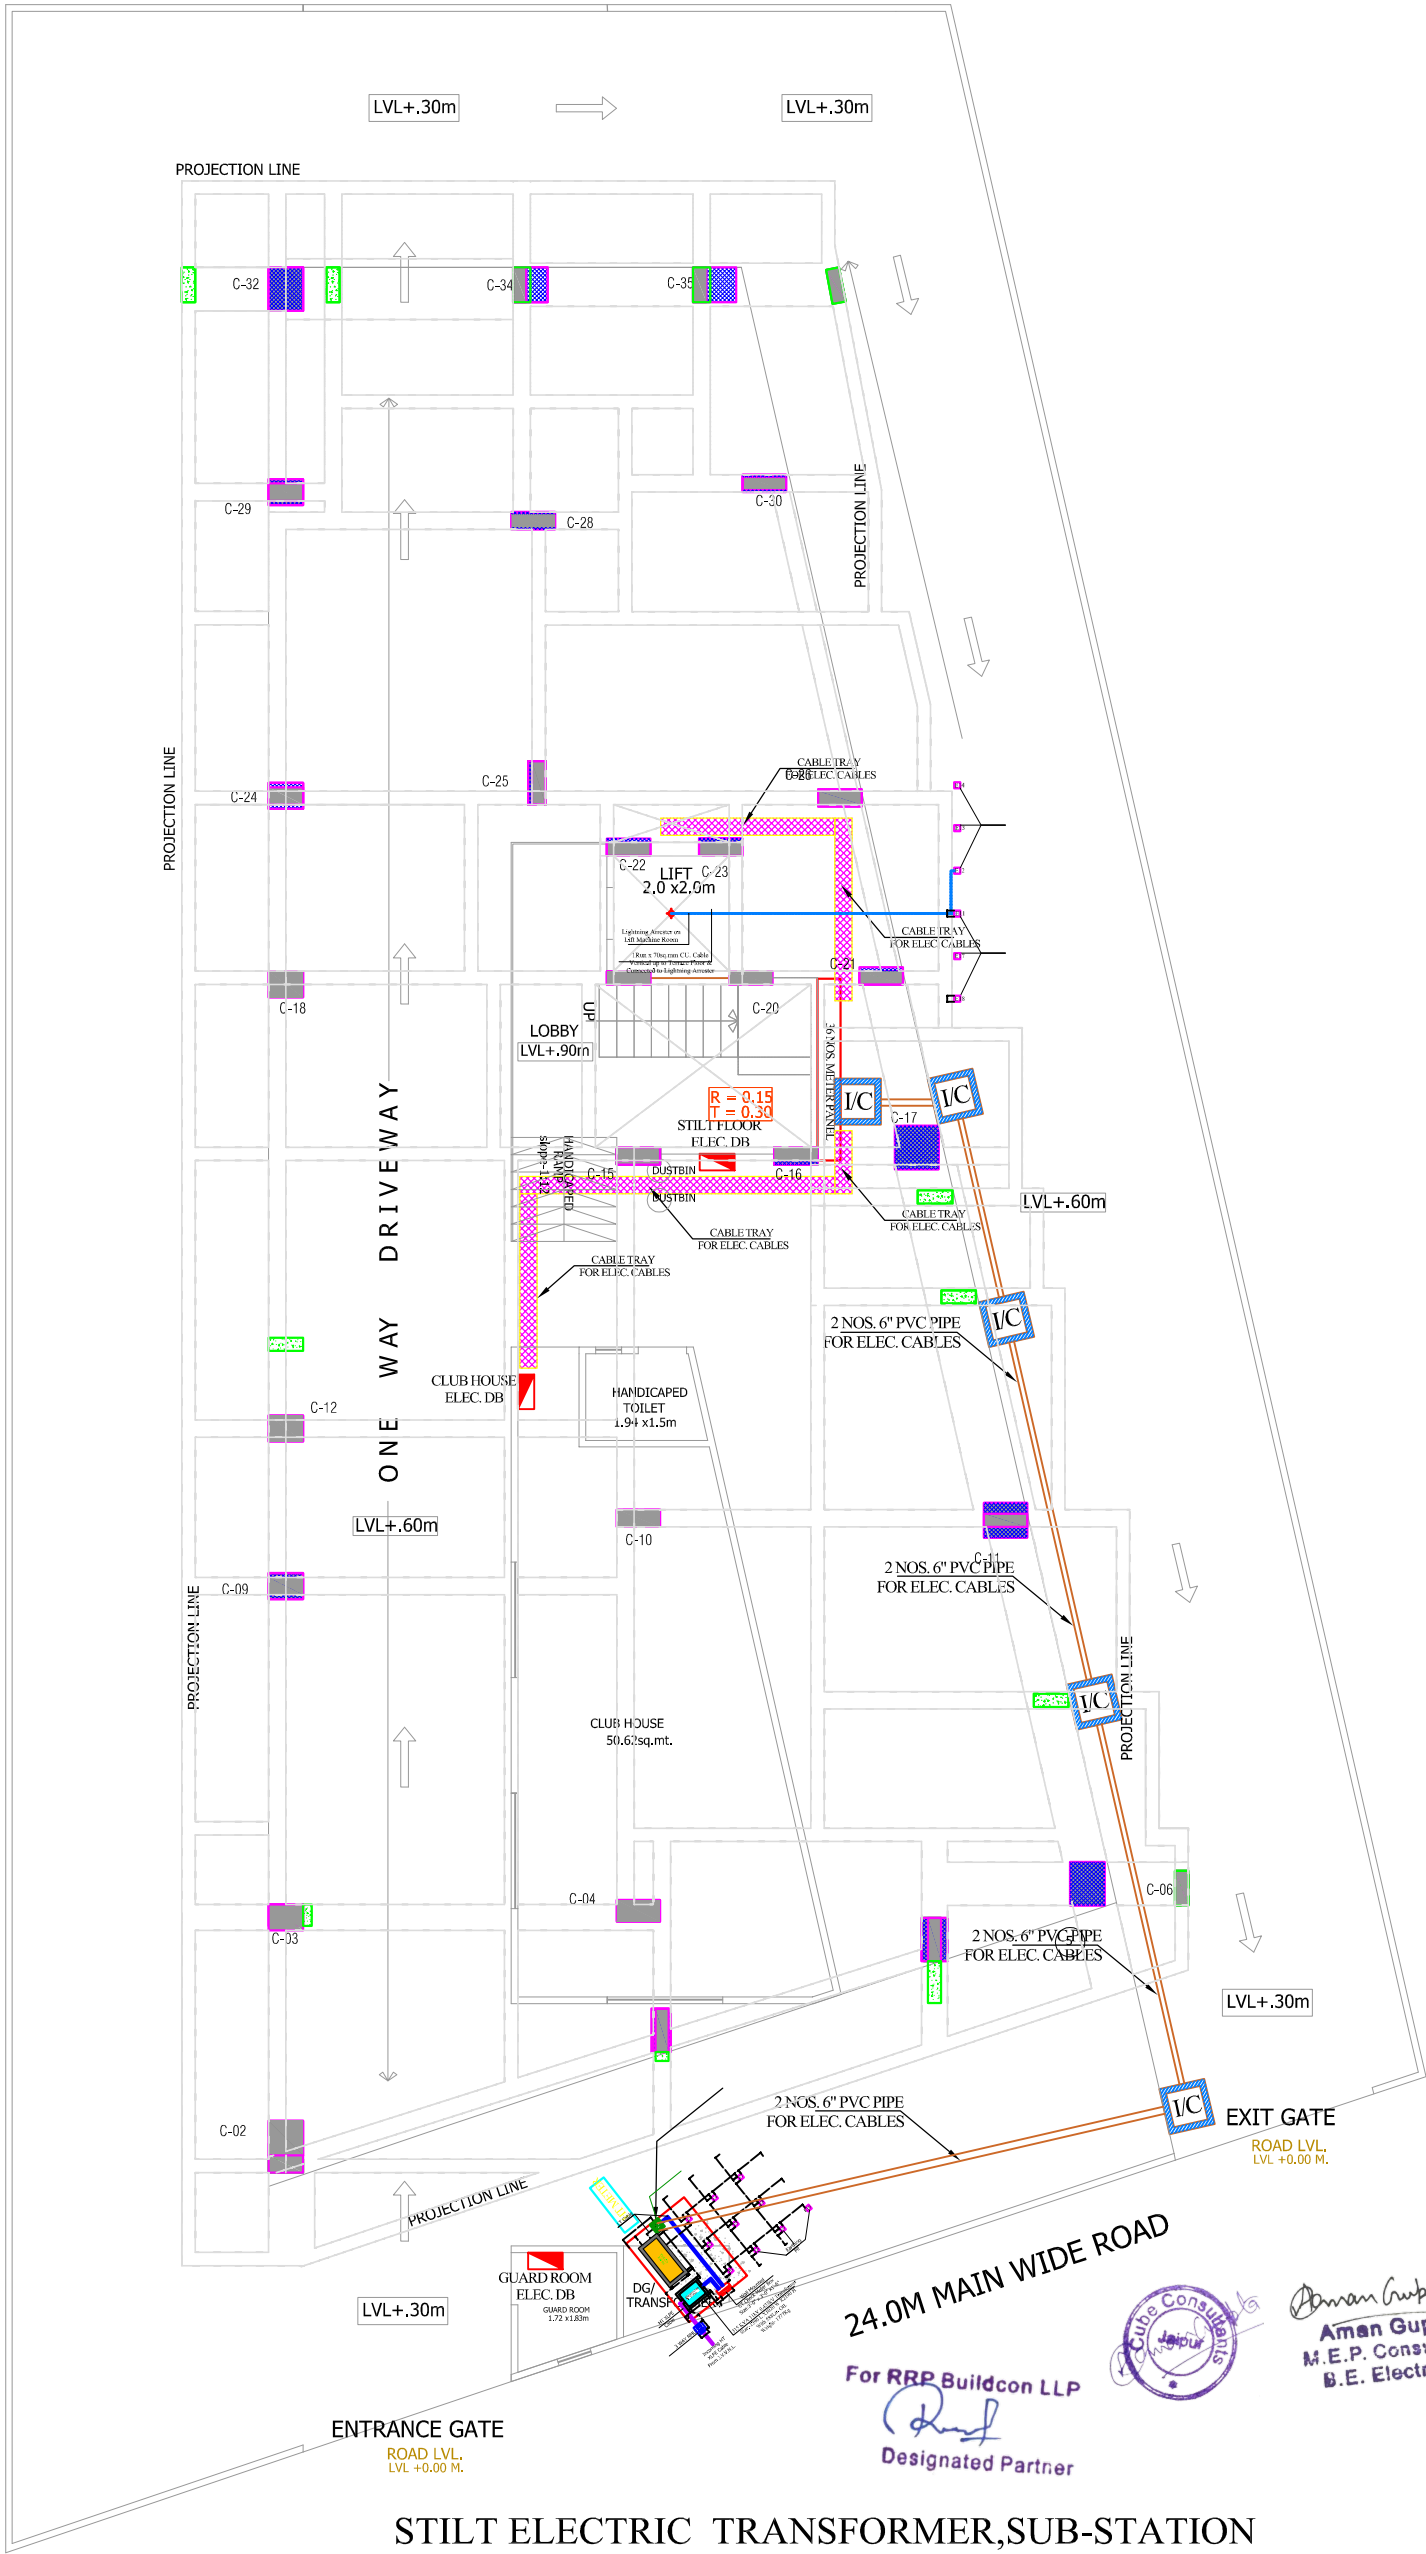

STILT ELECTRIC TRANSFORMER, SUB-STATION
CABLE ROUTE & LIGHTING
ARRESTER PLAN & EARTHING

GENERAL NOTES

1. ALL DIMENSIONS ARE IN MM, UNLESS SPECIFIED OTHERWISE.
2. THE DIMENSIONS ARE TO BE READ ONLY AND NOT TO BE MEASURED.
3. ANY DISCREPANCY IN THE DRAWING SHOULD BE BROUGHT IN THE NOTICE OF THE ARCHITECT.

LEGEND

SYMBOL	DESCRIPTION
	DISTRIBUTION BOX
	150/300MM CABLE TRAY FOR ELEC. CABLE
	150/300MM CABLE TRAY FOR LV CABLE

MEP CONSULTANT : --
cube consultant
A-8, PATH NO. 4, JAMUNA NAGAR,
SODALA, JAIPUR-302006
MAIL: - cubemep@gmail.com
PH. NO. +91 141 2221089, 9214308430,

DEALT BY MANISH MEWARA	REVISION	DATE: 16.03.2026
DWG NO		

TITLE:-
STILT ELECTRIC TRANSFORMER, SUB-STATION
CABLE ROUTE & LIGHTING
ARRESTER PLAN & EARTHING
WORKING DRAWINGS

SCALE:- 1= 100

DATE:

PROJECT NAME:-

THE ROYAL COURTYARD

PROJECT:-

PROPOSED RESIDENTIAL APARTMENT FOR
PLOT NO=60,61,69,70, UDAY VATIKA,
SANGANER, JAIPUR.

CLIENT NAME:-

RRP BUILDCON LLP
RAHUL GUPTA (PARTNER)

ARCHITECT

 
M/S AKRITI AYOJAN

ARCHITECTS. INTERIOR DESIGNERS.


E-87, THIRD FLOOR, MANGLAM TOWER, RIDHI SIKHI,
GOPALPURA, JAIPUR-06, RAJASTHAN. 9351154101
suryaprakash.arch@gmail.com ;

DATE:

NORTH :



9.0 M MAIN WIDE ROAD

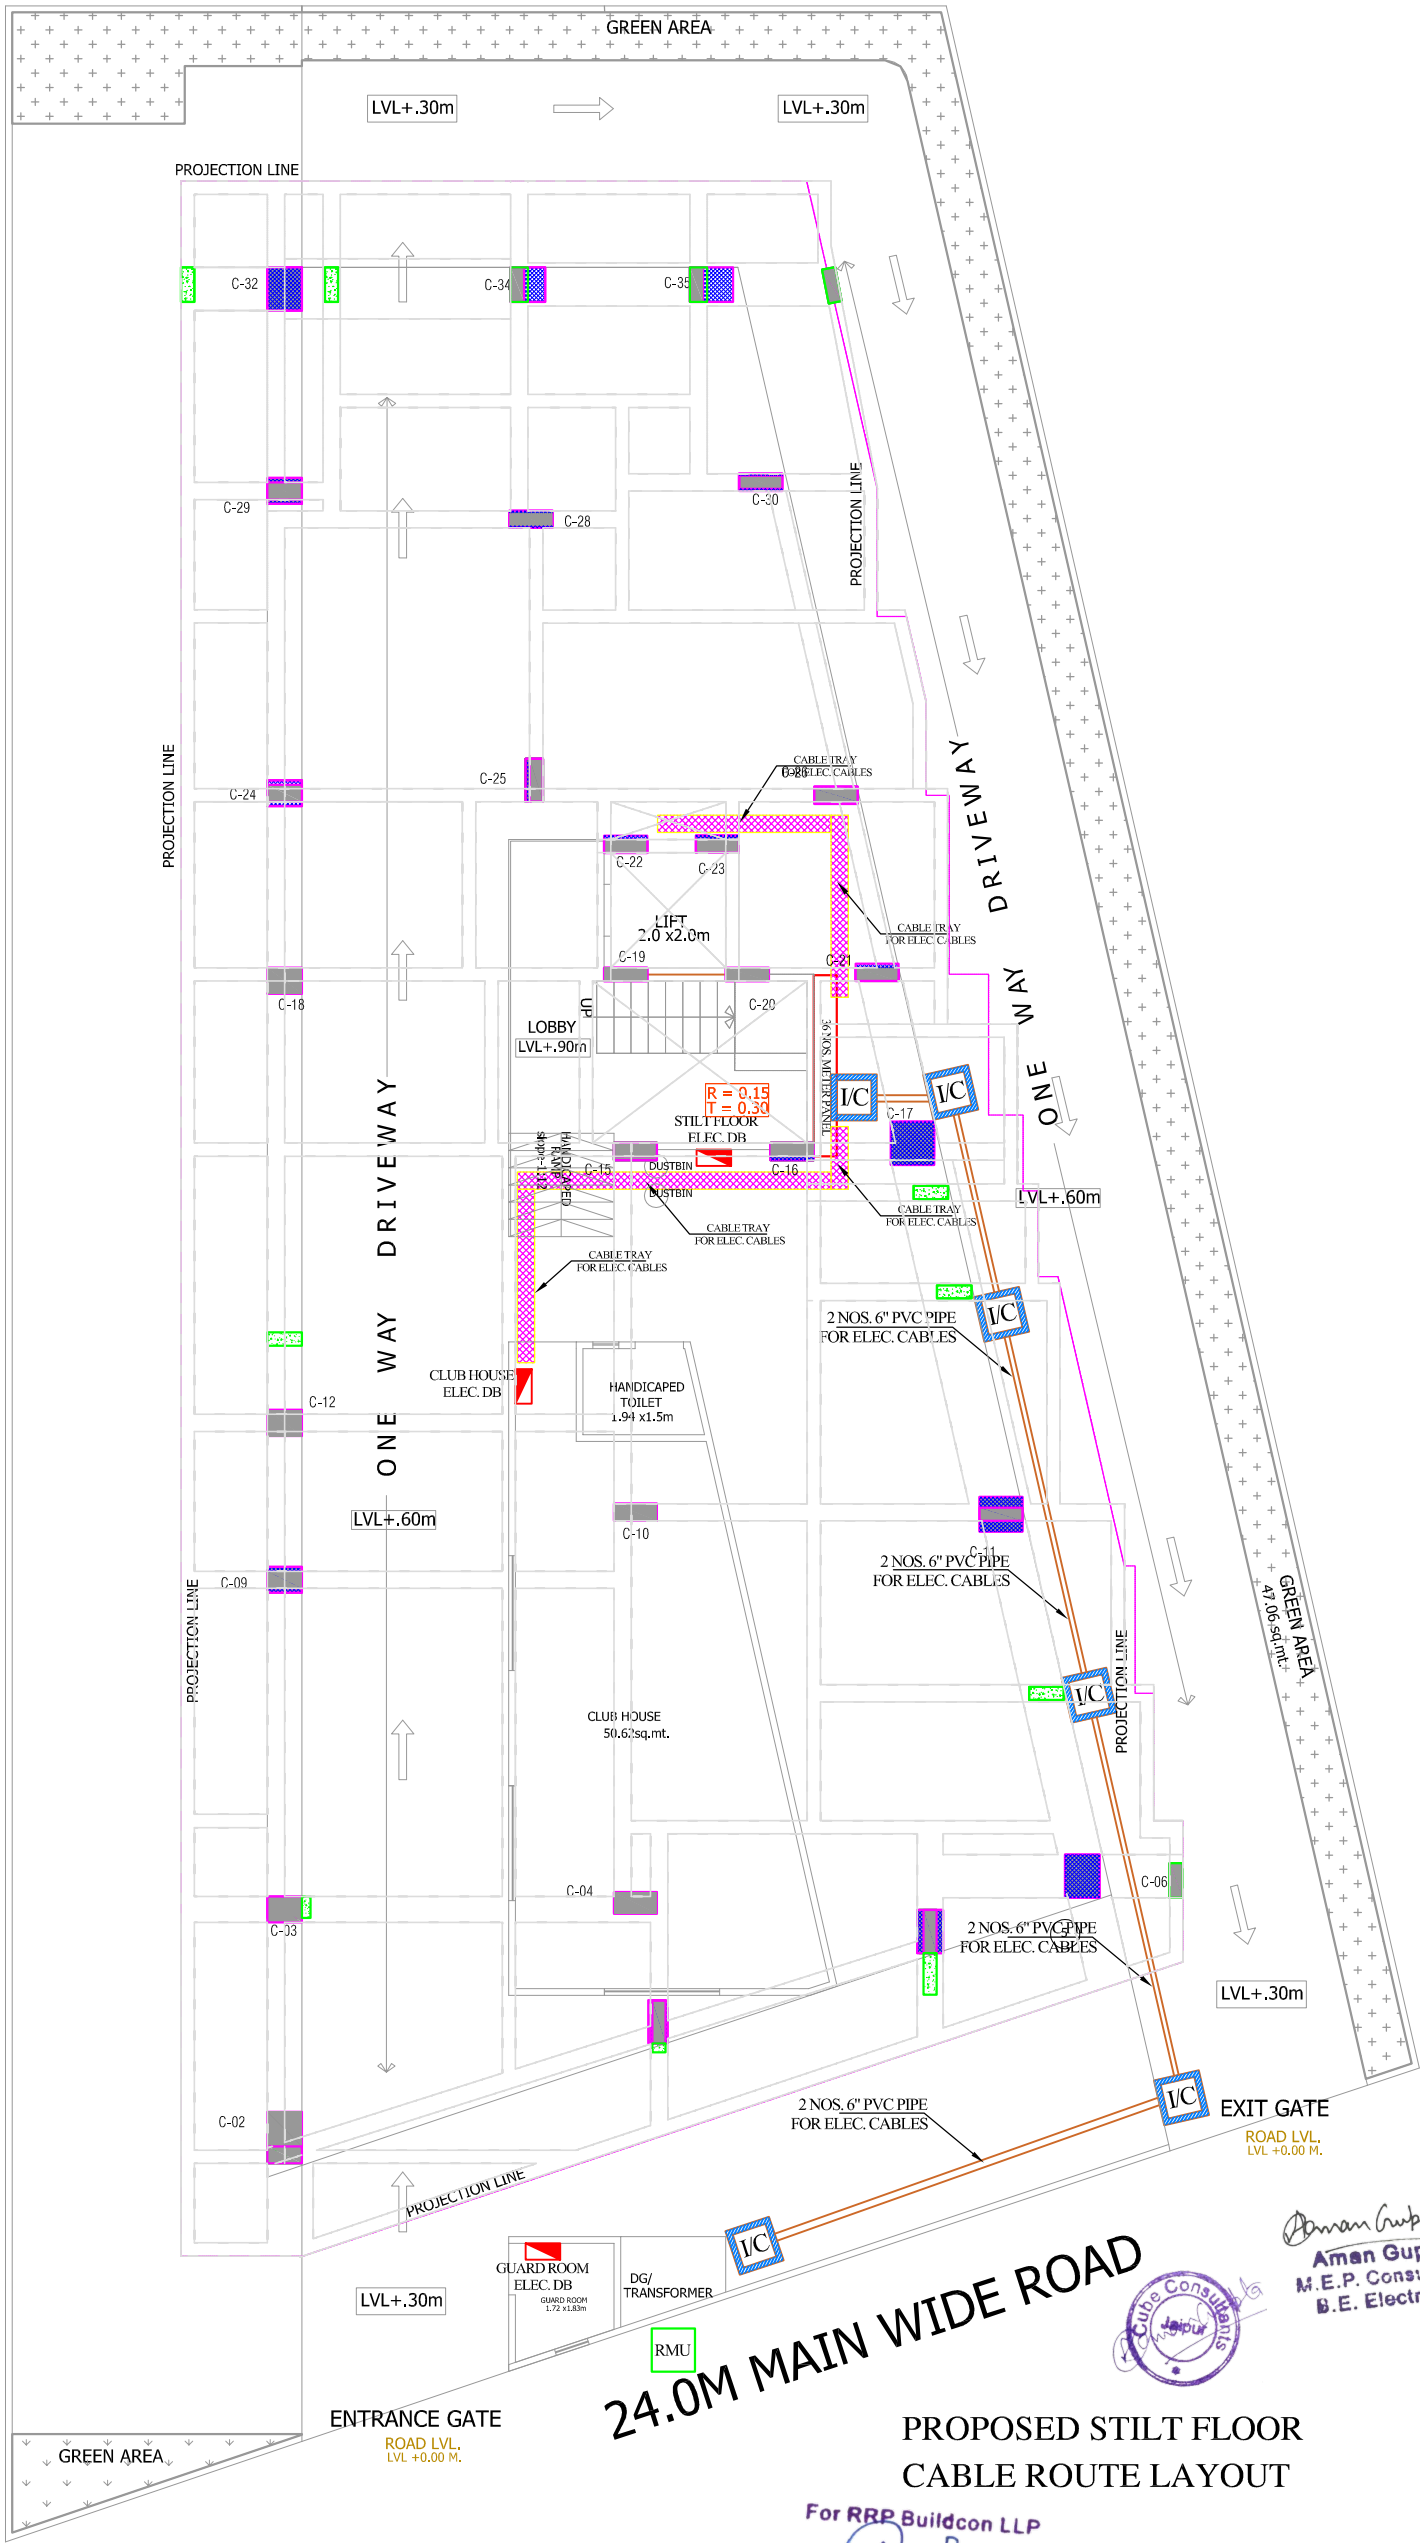

24.0M MAIN WIDE ROAD

PROPOSED STILT FLOOR
CABLE ROUTE LAYOUT

For RRP Buildcon LLP
Designated Partner

GENERAL NOTES

1. ALL DIMENSIONS ARE IN MM, UNLESS SPECIFIED OTHERWISE.
2. THE DIMENSIONS ARE TO BE READ ONLY AND NOT TO BE MEASURED.
3. ANY DISCREPANCY IN THE DRAWING SHOULD BE BROUGHT IN THE NOTICE OF THE ARCHITECT.

LEGEND

SYMBOL	DESCRIPTION
	DISTRIBUTION BOX
	150/300MM CABLE TRAY FOR ELEC. CABLE
	150/300MM CABLE TRAY FOR LV CABLE

MEP CONSULTANT : --
cube consultant
A-8, PATH NO. 4, JAMUNA NAGAR,
SODALA, JAIPUR-302006
MAIL: - cubemep@gmail.com
PH. NO. +91 141 2221089, 9214308430,

DEALT BY MANISH MEWARA	REVISION	DATE:16.03.2026
DWG NO		

TITLE:-
**PROPOSED STILT FLOOR
CABLE ROUTE LAYOUT**
WORKING DRAWINGS

SCALE:- 1= 100 DATE:

PROJECT NAME:-
THE ROYAL COURTYARD

PROJECT:-
**PROPOSED RESIDENTIAL APARTMENT FOR
PLOT NO=60,61,69,70,UDAY VATIKA,
SANGANER,JAIPUR.**

 
CLIENT NAME:-
**RRP BUILDCON LLP
RAHUL GUPTA (PARTNER)**

ARCHITECT


M/S AKRITI AYOJAN

ARCHITECTS, INTERIOR DESIGNERS,
E-87, THIRD FLOOR, MANGLAM TOWER, RIDHI SIDHI,
GOPALPURA, JAIPUR-06, RAJASTHAN. 9351154101
suryaprakash.arch@gmail.com ;

DATE: NORTH :



9.0 M MAIN WIDE ROAD

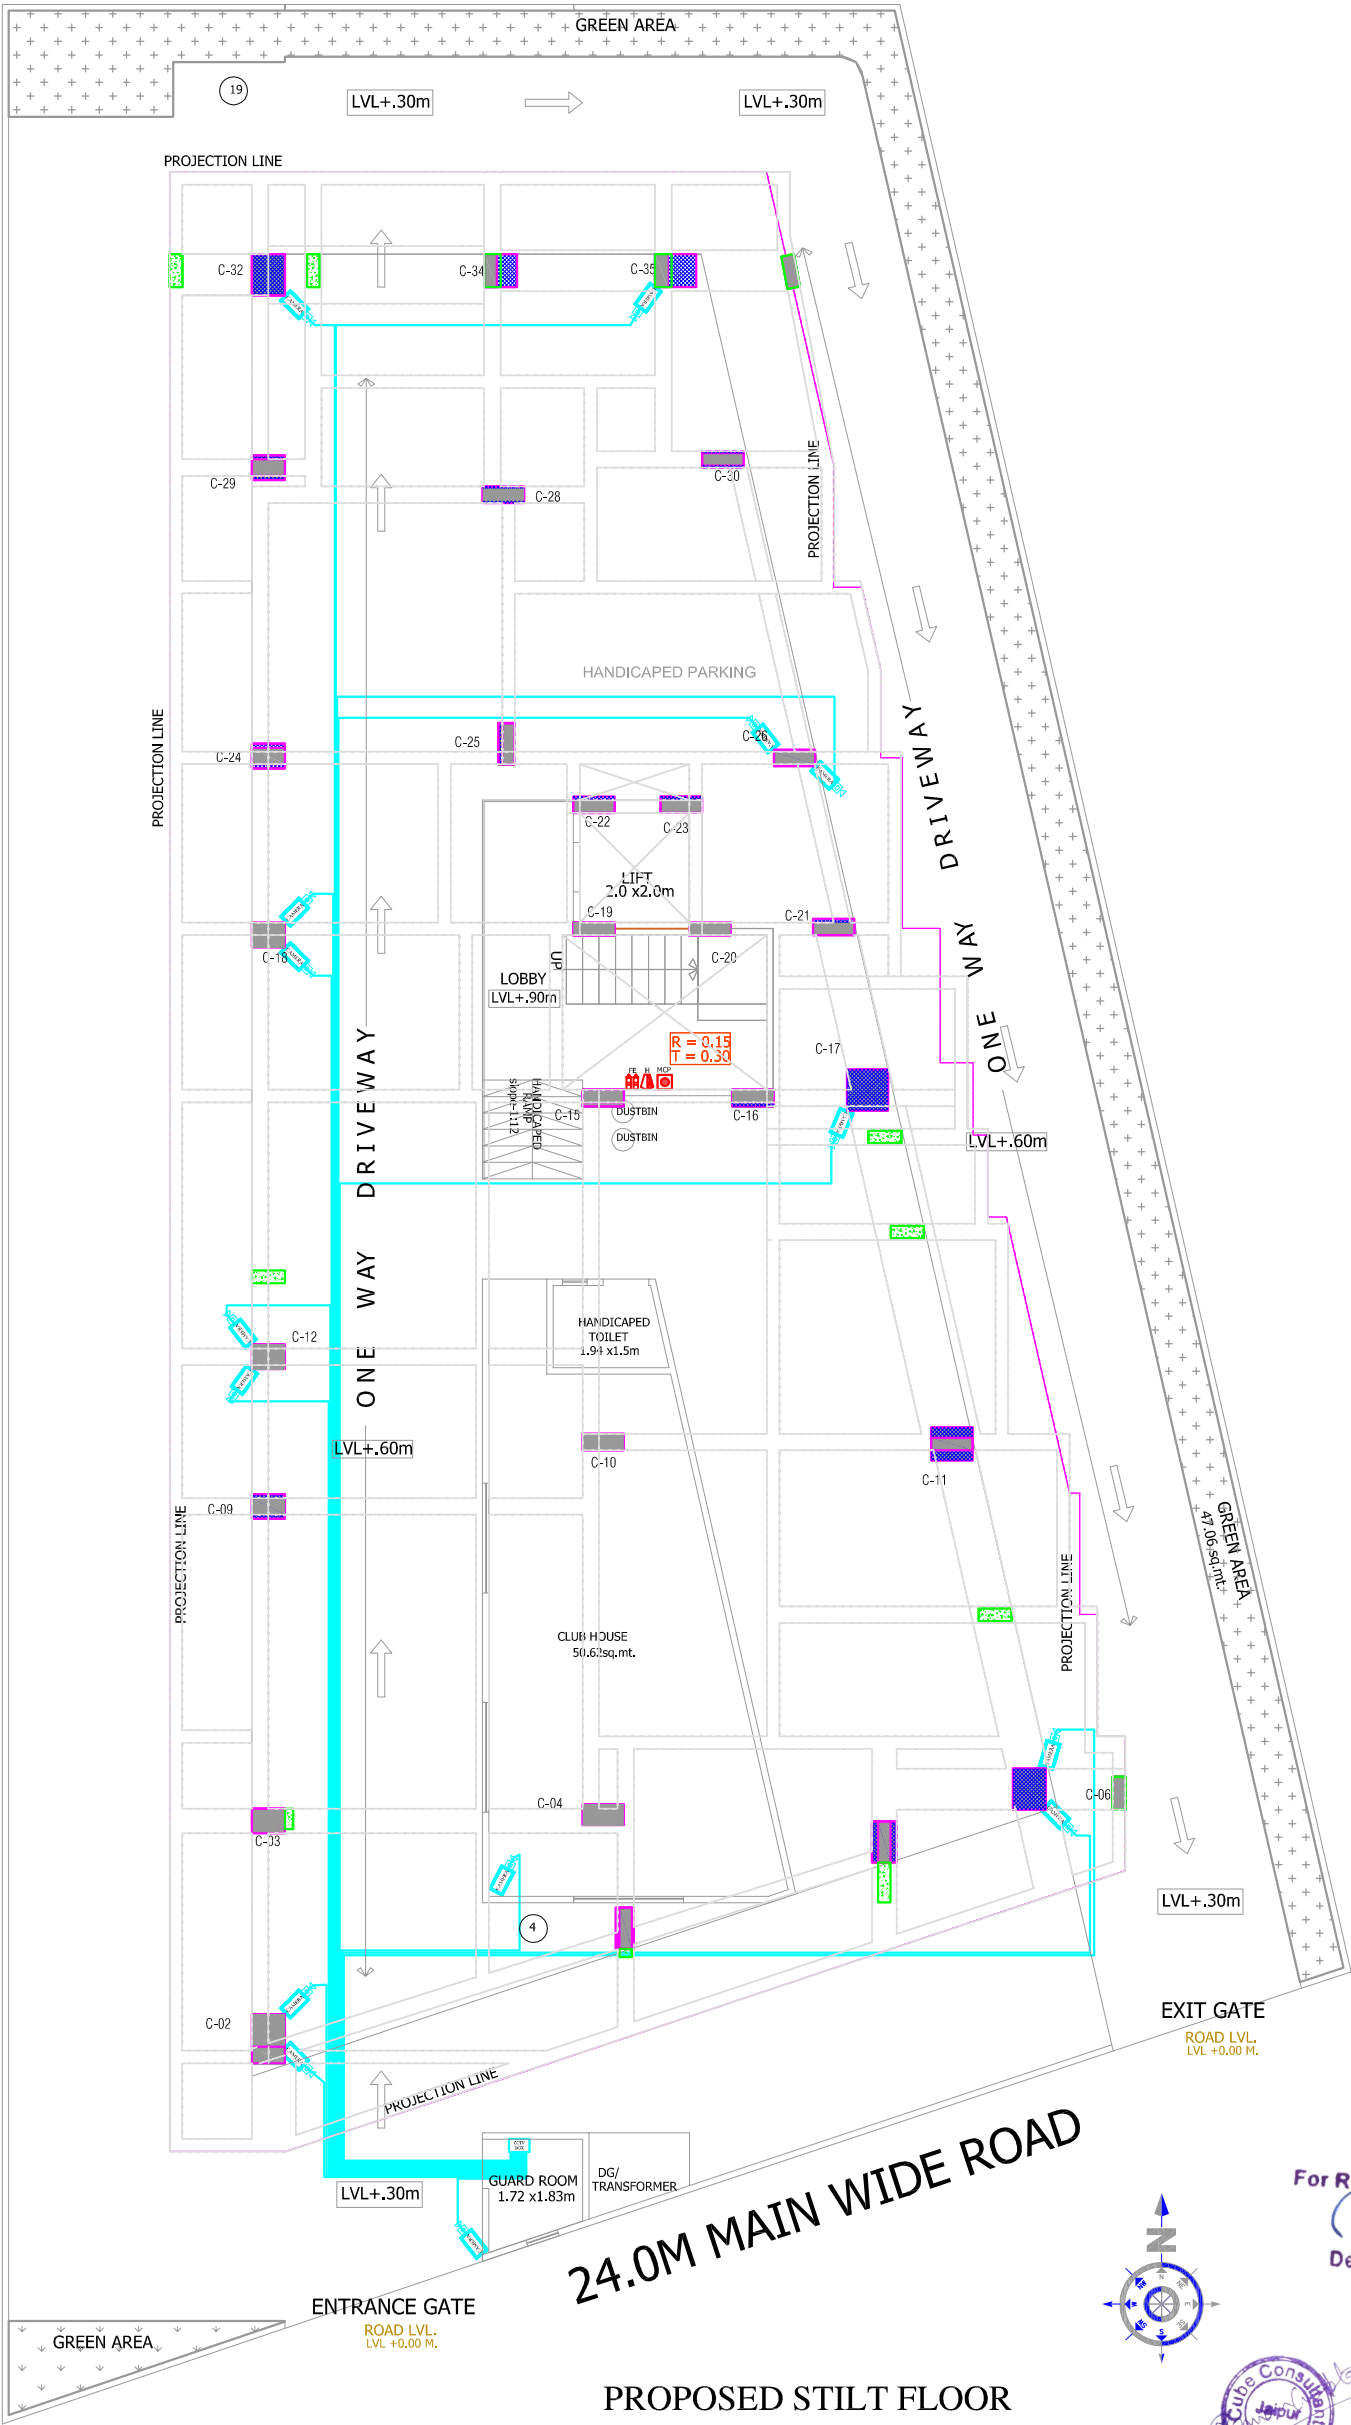

PROPOSED STILT FLOOR
CCTV & FIRE ALARM LAYOUT

GENERAL NOTES

1. ALL DIMENSIONS ARE IN MM. UNLESS SPECIFIED OTHERWISE.
2. THE DIMENSIONS ARE TO BE READ ONLY AND NOT TO BE MEASURED.
3. ANY DISCREPANCY IN THE DRAWING SHOULD BE BROUGHT IN THE NOTICE OF THE ARCHITECT.

LEGEND

SYMBOL	DESCRIPTION
	DISTRIBUTION BOX
	SWITCH BOARD (6A SOCKET & SWITCHES)
	16 A SOCKET WITH SWITCH
	6A POWER SOCKET WITH SWITCH
	CAMERA
	25A AC SWITCH@HT.4'-0"
	SPLIT AC
	6A S/S FAN REGULATOR,TL SWITCH @HT.2'-6"
	6A S/S 25 A AC @HT.2'-6"
	16A S/S FOR FRIDGE@HT 5'-6"
	6A S/S FOR CHIMNEY@HT 5'-6"
	16A S/S FOR MICROWAVE & 6A S/S FOR MIXER @HT 5'-6"
	16A S/S FOR GYSER & 6A S/S FOR RO @HT 5'-6"
	6A 2 NOS. SOCKET +1 NOS. 16A SWITCH ,TV COAXIAL SOCKET@HT 3'-6"
	TOILET MIRROR LIGHT 1x18w
	WALL FAN
	CELLING LIGHT
	TUBE LIGHT
	WALL BRACKET LED LIGHT
	900 / 1200 MM SWEEP CEILING FAN
	1 x 72 W CHANDELIER LIGHT
	2 x 5 W CONCEALED FOOT LIGHT
	EXHAUST FAN(AS PER FURNITURE)
	GYSER POINT(AS PER FURNITURE)
	3 x 1.5 SQMM LIGHT CONTROL CU. WIRE
	3 x 1.5 SQMM 2 WAY LIGHT CONTROL WIRE
	3 x 2.5 SQMM CU. WIRE FOR AC IDU
	3 x 4.0 SQMM CU. WIRE FOR POWER CIRCUIT
	3 x 2.5 SQMM CU. WIRE FOR LIGHT CIRCUIT
	CAT-6 LAN WIRE RJ-45 JACK TO LAN SWITCH
	CAT-6 TELEPHONE WIRE RJ-11 JACK TO TTB
	RG-6 TV CABLE SETUP BOX TO TV SPLITTER
	CAT-6 CCTV CABLE CCTV CAMERA TO NVR

MEP CONSULTANT : --
cube consultant
A-8, PATH NO. 4, JAMUNA NAGAR,
SODALA, JAIPUR-302006
MAIL:- cubemep@gmail.com
PH. NO. +91 141 2221089, 9214308430,

DEALT BY MANISH MEWARA	REVISION	DATE:16.03.2026
DWG NO		

TITLE:-
PROPOSED STILT FLOOR
CCTV & FIRE ALARM LAYOUT
WORKING DRAWINGS

SCALE:- 1= 100	DATE:
PROJECT NAME:- THE ROYAL COURTYARD	
PROJECT:- PROPOSED RESIDENTIAL APARTMENT FOR PLOT NO=60,61,69,70,UDAY VATIKA, SANGANER,JAIPUR.	

CLIENT NAME:-
RRP BUILDCON LLP
RAHUL GUPTA (PARTNER)


ARCHITECT

M/S AKRITI AYOJAN

ARCHITECTS. INTERIOR DESIGNERS.
E-87, THIRD FLOOR, MANGLAM TOWER, RIDHI SIDHI,
GOPALPURA, JAIPUR-06, RAJASTHAN. 9351154101
suryaprakash.arch@gmail.com ;

DATE:	NORTH :

9.0 M MAIN WIDE ROAD

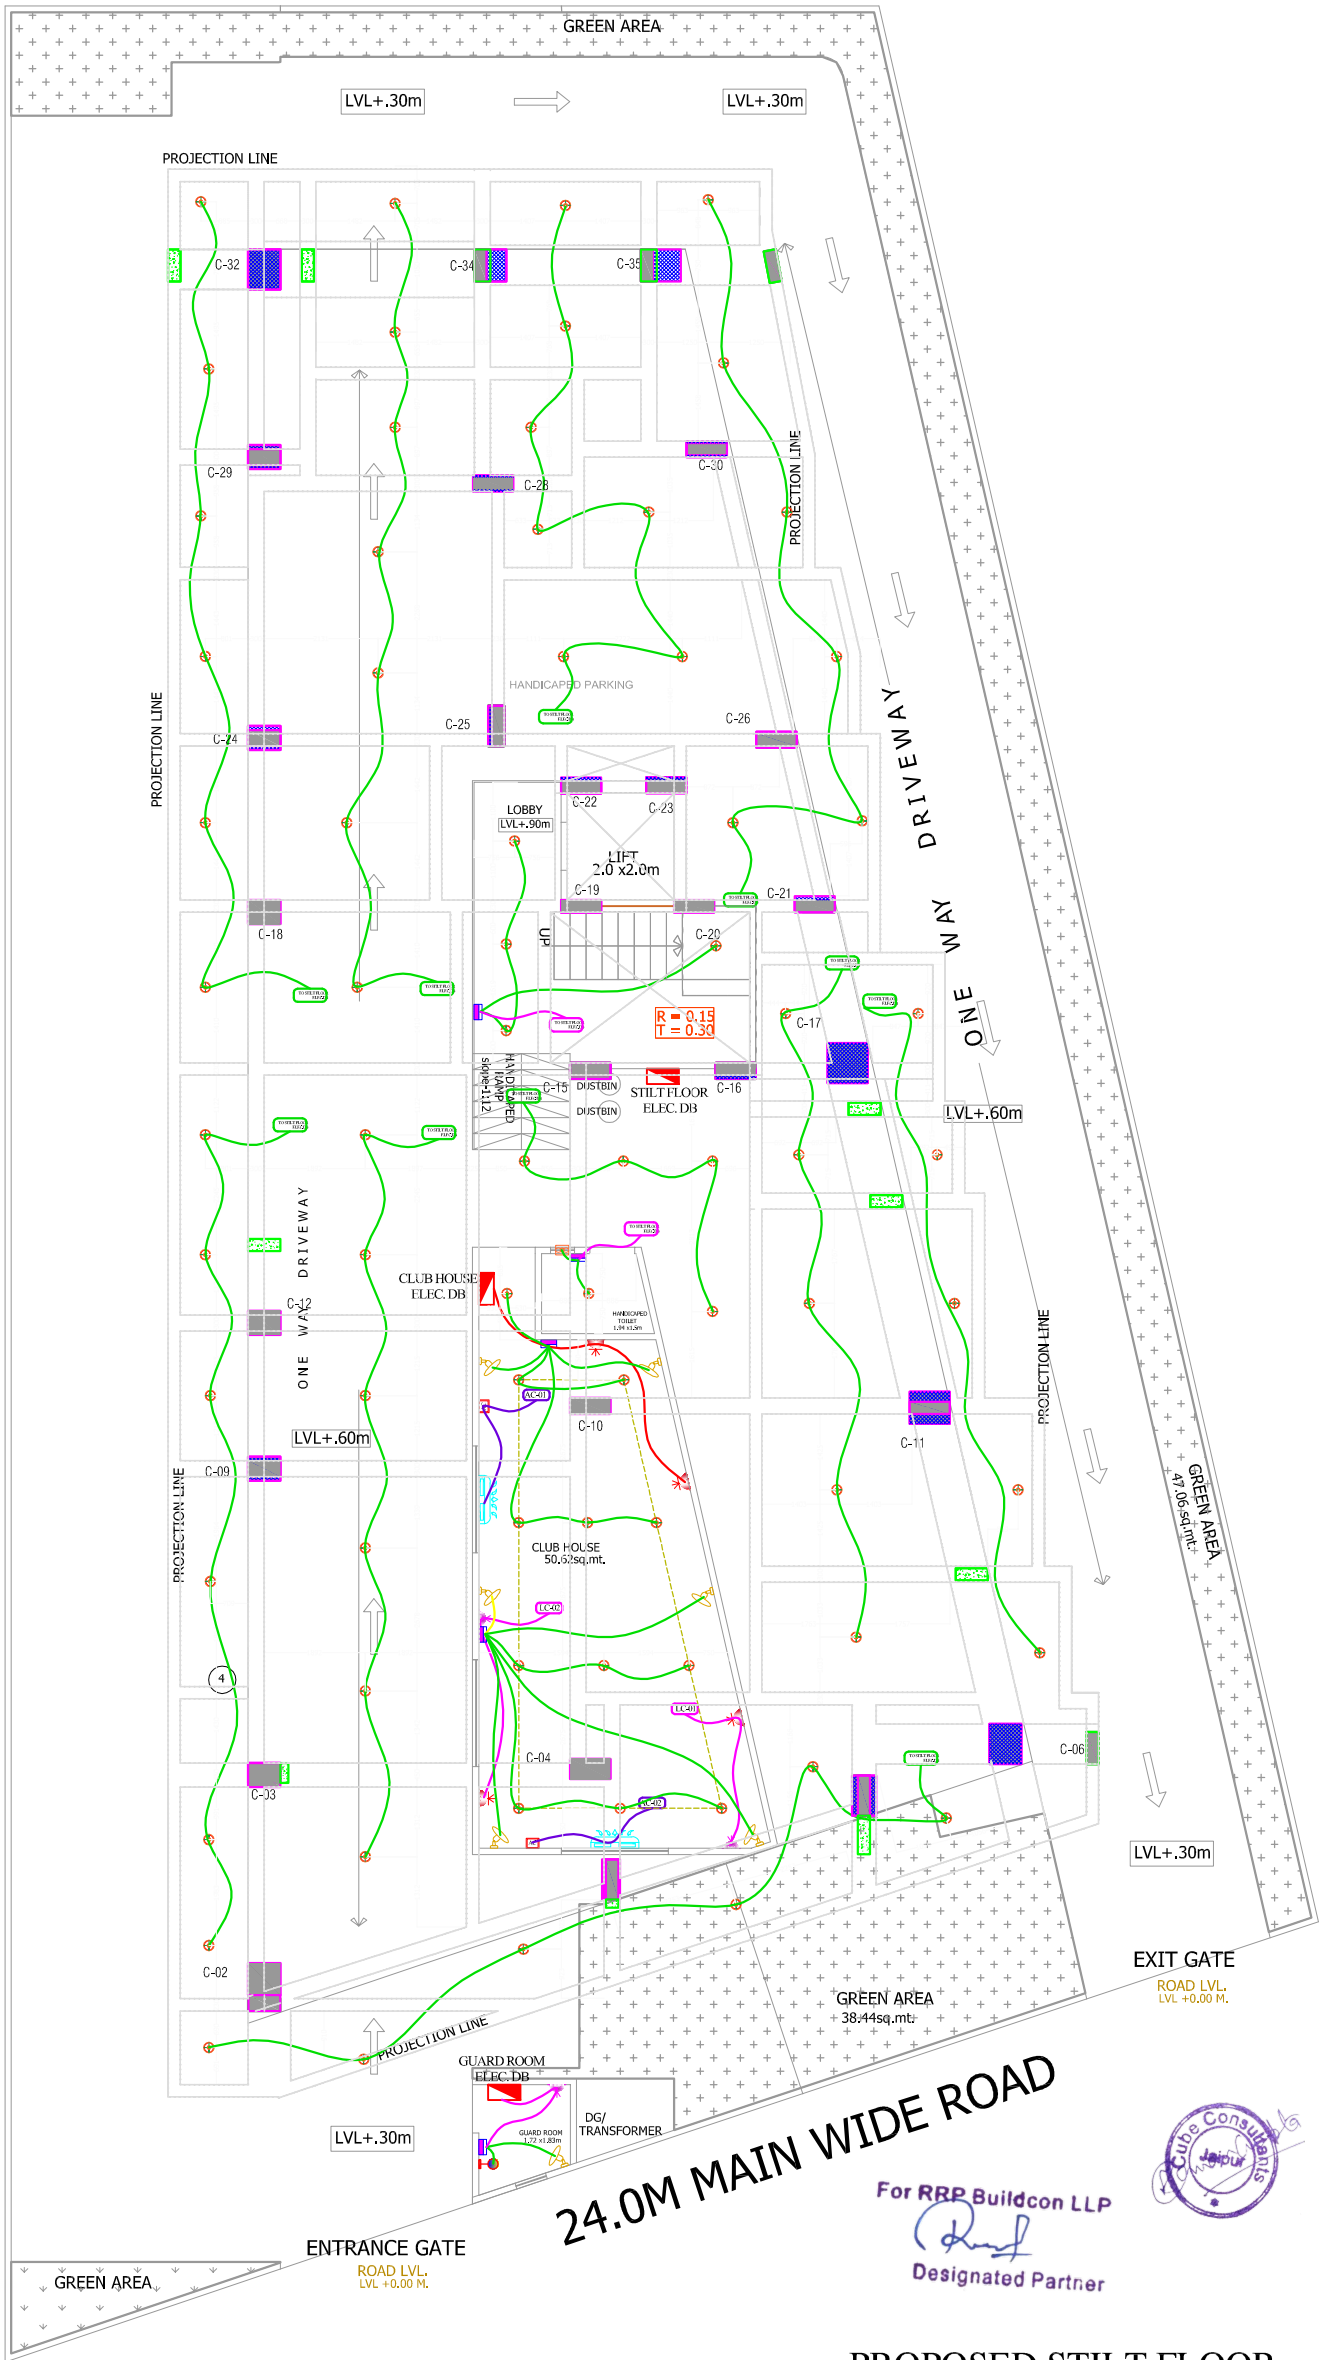

For RRP Buildcon LLP
Designated Partner

PROPOSED STILT FLOOR
ELECTRICAL LAYOUT

GENERAL NOTES

1. ALL DIMENSIONS ARE IN MM, UNLESS SPECIFIED OTHERWISE.
2. THE DIMENSIONS ARE TO BE READ ONLY AND NOT TO BE MEASURED.
3. ANY DISCREPANCY IN THE DRAWING SHOULD BE BROUGHT IN THE NOTICE OF THE ARCHITECT.


LEGEND

SYMBOL	DESCRIPTION
	DISTRIBUTION BOX
	SWITCH BOARD (6A SOCKET & SWITCHES)
	16 A SOCKET WITH SWITCH
	6A POWER SOCKET WITH SWITCH
	CAMERA
	25A AC SWITCH@HT.4'-0"
	SPLIT AC
	6A SS FAN REGULATOR,TL SWITCH @HT.2'-6"
	6A SS 25 A AC @HT.2'-6"
	16A SS FOR FRIDGE@HT 5'-6"
	6A SS FOR CHIMNEY@HT 5'-6"
	16A SS FOR MICROWAVE & 6A SS FOR MIXER @HT 5'-6"
	6A 2 NOS. SOCKET +1 NOS. 16A SWITCH ,TV COAXIAL SOCKET@HT 3'-6"
	TOILET MIRROR LIGHT 1x18w
	WALL FAN
	CEILING LIGHT
	CEILING LIGHT
	TUBE LIGHT
	WALL BRACKET LED LIGHT
	900 / 1200 MM SWEEP CEILING FAN
	1 x 72 W CHANDELIER LIGHT
	2 x 5 W CONCEALED FOOT LIGHT
	EXHAUST FAN(AS PER FURNITURE)
	GYSER POINT(AS PER FURNITURE)
	3 x 1.5 SQMM LIGHT CONTROL CU. WIRE
	3 x 1.5 SQMM 2 WAY LIGHT CONTROL WIRE
	3 x 2.5 SQMM CU. WIRE FOR AC IDU
	3 x 4.0 SQMM CU. WIRE FOR POWER CIRCUIT
	3 x 2.5 SQMM CU. WIRE FOR LIGHT CIRCUIT
	CAT-6 LAN WIRE RJ-45 JACK TO LAN SWITCH
	CAT-6 TELEPHONE WIRE RJ-11 JACK TO TTB
	RG-6 TV CABLE SETUP BOX TO TV SPLITTER
	CAT-6 CCTV CABLE CCTV CAMERA TO NVR

MEP CONSULTANT :-
cube consultant
A-8, PATH NO. 4, JAMUNA NAGAR,
SODALA, JAIPUR-302006
MAIL:- cubemep@gmail.com
PH. NO. +91 141 2221089, 9214308430,

DEALT BY MANISH MEWARA	REVISION	DATE:16.03.2026
DWG NO		

TITLE:- PROPOSED STILT FLOOR ELECTRICAL LAYOUT WORKING DRAWINGS	
SCALE:- 1= 100	DATE:
PROJECT NAME:- THE ROYAL COURTYARD	
PROJECT:- PROPOSED RESIDENTIAL APARTMENT FOR PLOT NO=60,61,69,70,UDAY VATIKA, SANGANER,JAIPUR.	
CLIENT NAME:- RRP BUILDCON LLP RAHUL GUPTA (PARTNER)	
ARCHITECT	
M/S AKRITI AYOJAN ARCHITECTS, INTERIOR DESIGNERS. E-87, THRD FLOOR, MANGLAM TOWER ,RIDHI SIDIHI, GOPALPURA, JAIPUR-06, RAJASTHAN. 9351154101 suryaprakash.arch@gmail.com ;	
DATE:	NORTH :

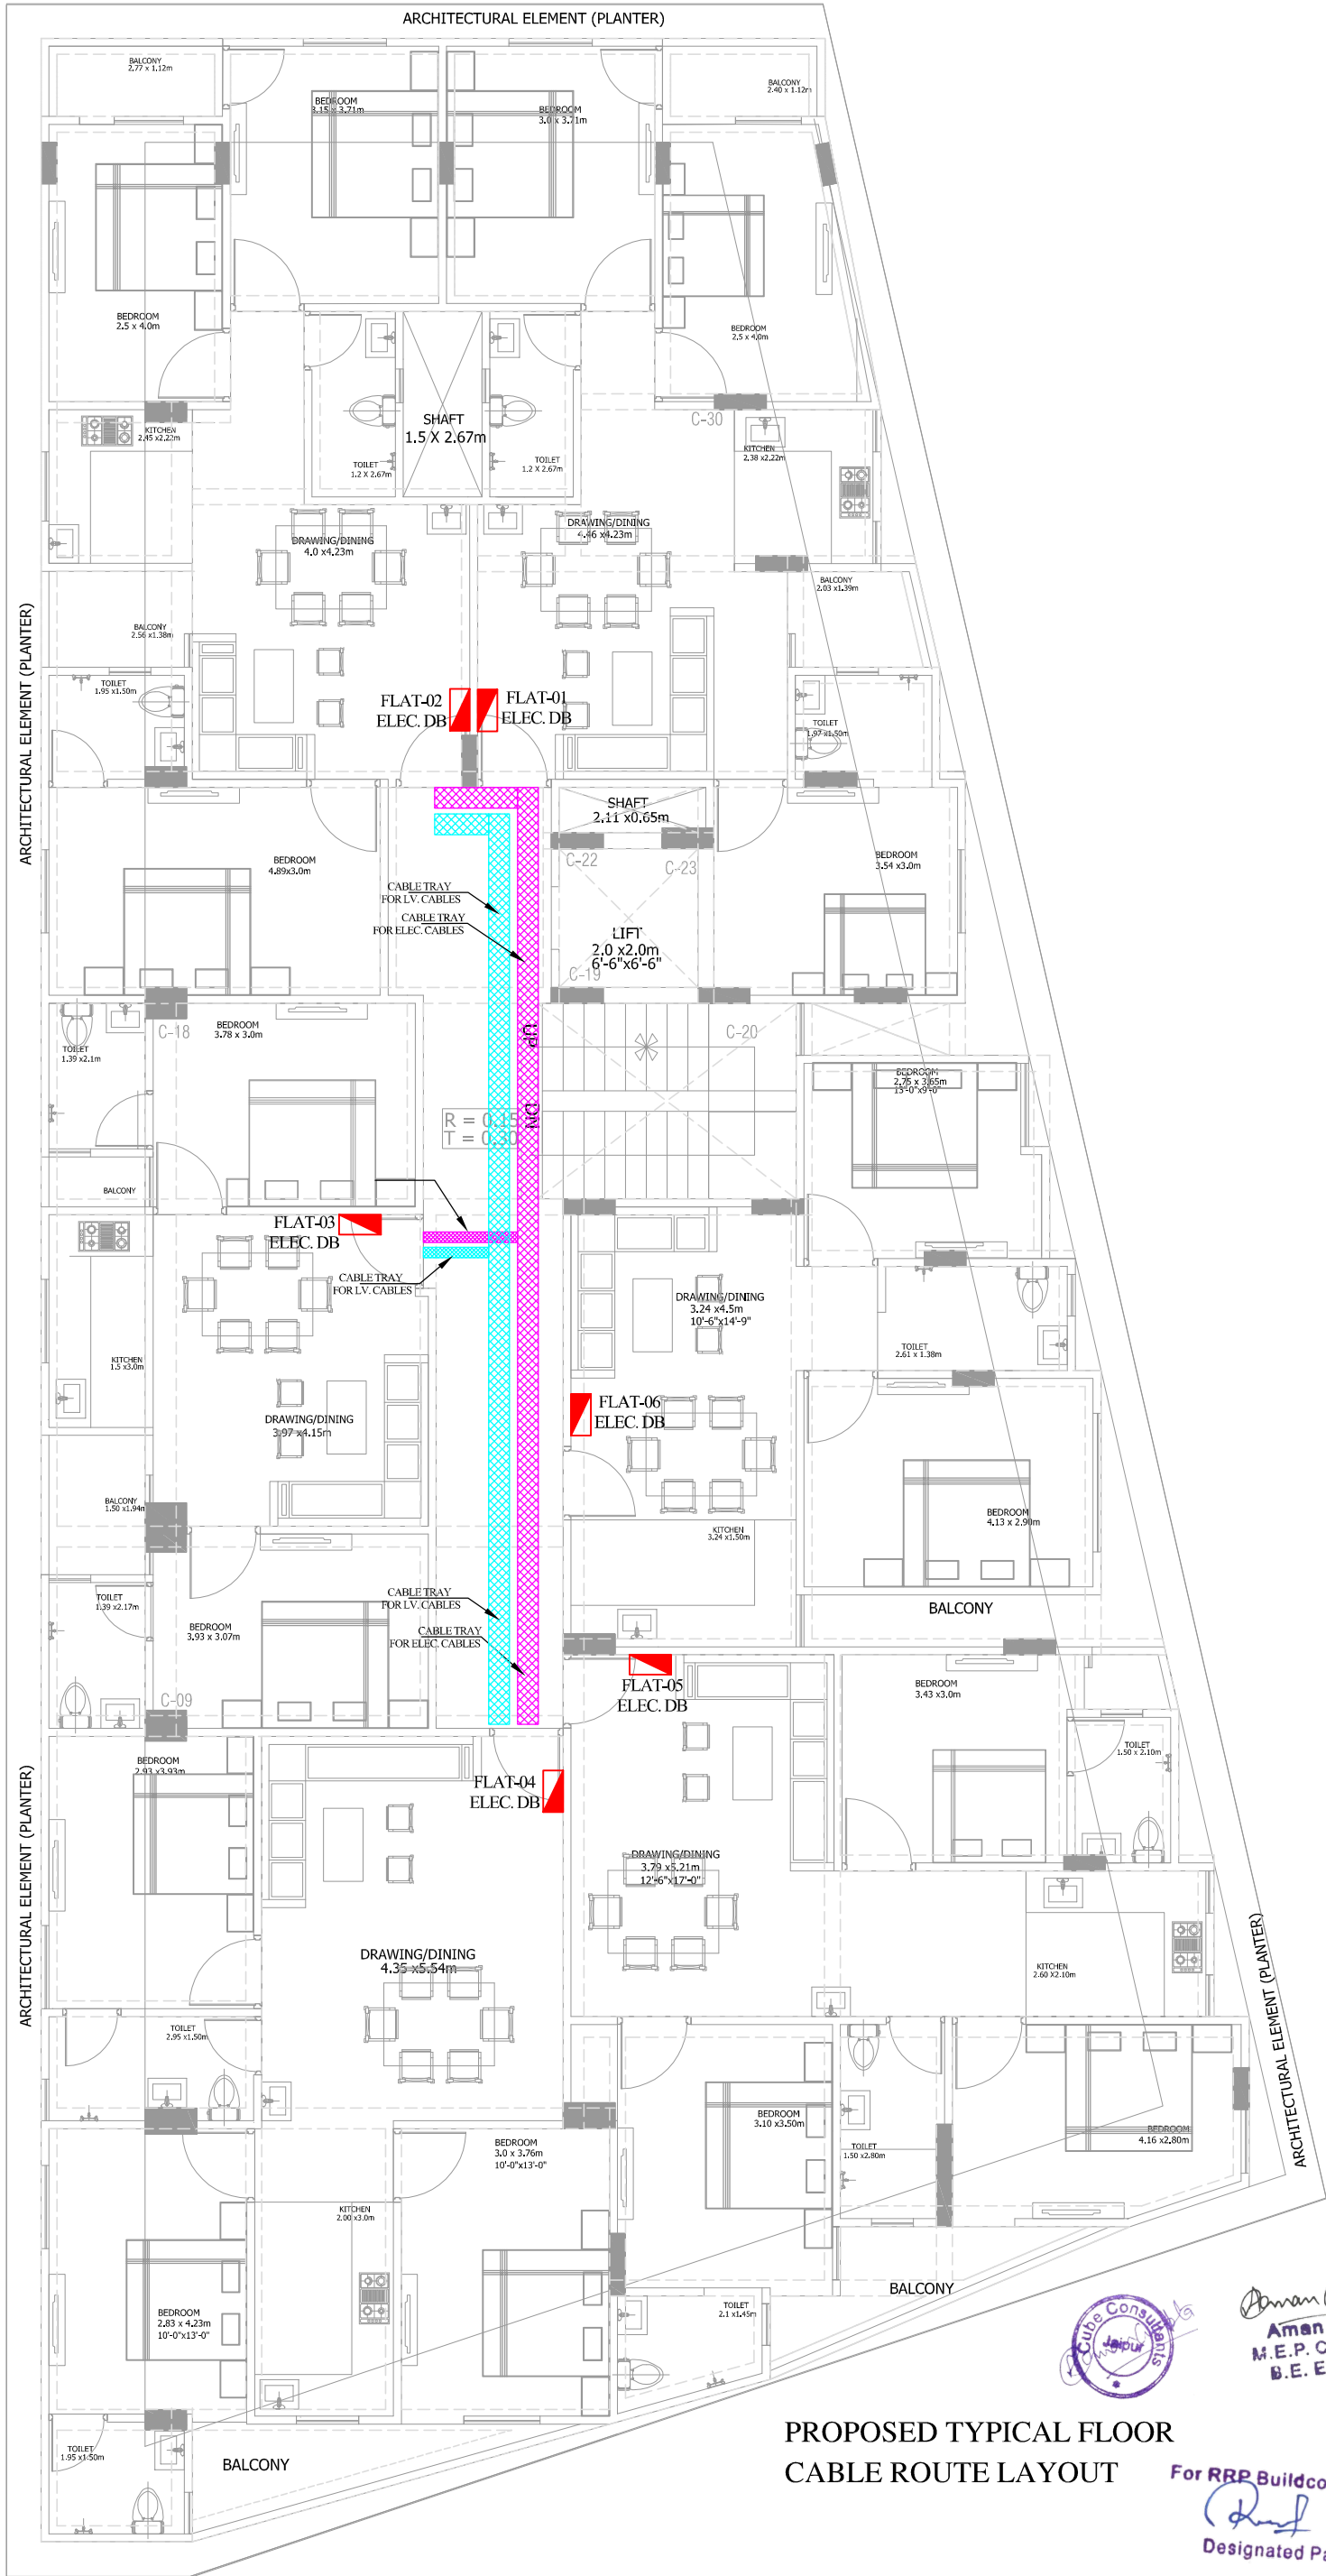

GENERAL NOTES

1. ALL DIMENSIONS ARE IN MM, UNLESS SPECIFIED OTHERWISE.
2. THE DIMENSIONS ARE TO BE READ ONLY AND NOT TO BE MEASURED.
3. ANY DISCREPANCY IN THE DRAWING SHOULD BE BROUGHT IN THE NOTICE OF THE ARCHITECT.

LEGEND

SYMBOL	DESCRIPTION
	DISTRIBUTION BOX
	SWITCH BOARD (6A SOCKET & SWITCHES)
	16 A SOCKET WITH SWITCH
	6A POWER SOCKET WITH SWITCH
	CAMERA
	25A AC SWITCH@HT.4'-0"
	SPLIT AC
	6A SS,FAN REGULATOR,TL SWITCH @HT. 2'-6"
	6A SS,25 A AC @HT. 2'-6"
	16A SS FOR FRIEDGE@HT 5'-6"
	6A SS FOR CHIMNEY@HT 5'-6"
	16A SS FOR MICROWAVE & 6A SS FOR MIXER @HT 5'-6"
	16A SS FOR GYSER & 6A SS FOR RO @HT 5'-6"
	6A 2 NOS. SOCKET +1 NOS. 16A SWITCH,TV COAXIAL SOCKET@HT 3'-6"
	TOILET MIRROR LIGHT 1x18w
	WALL FAN
	CELLING LIGHT
	CELLING LIGHT
	TUBE LIGHT
	WALL BRACKET LED LIGHT
	900 / 1200 MM SWEEP CEILING FAN
	1 x 72 W CHANDELIER LIGHT
	2 x 5 W CONCEALED FOOT LIGHT
	EXHAUST FAN(AS PER FURNITURE)
	GYSER POINT(AS PER FURNITURE)
	3 x 1.5 SQMM LIGHT CONTROL CU. WIRE
	3 x 1.5 SQMM 2 WAY LIGHT CONTROL WIRE
	3 x 2.5 SQMM CU. WIRE FOR AC IDU
	3 x 4.0 SQMM CU. WIRE FOR POWER CIRCUIT
	3 x 2.5 SQMM CU. WIRE FOR LIGHT CIRCUIT
	CAT-6 LAN WIRE RJ-45 JACK TO LAN SWITCH
	CAT-6 TELEPHONE WIRE RJ-11 JACK TO TTB
	RG-6 TV CABLE SETUP BOX TO TV SPLITTER
	CAT-6 CCTV CABLE CCTV CAMERA TO NVR

MEP CONSULTANT : --

cube consultant
A-8, PATH NO. 4, JAMUNA NAGAR,
SODALA, JAIPUR-302006
MAIL: - cubemep@gmail.com
PH. NO. +91 141 2221089, 9214308430,

DEALT BY MANISH MEWARA	REVISION	DATE:16.03.2026
DWG NO		

TITLE:-
PROPOSED TYPICAL FLOOR
CABLE ROUTE LAYOUT

SCALE:- 1= 100 DATE:

PROJECT NAME:-
THE ROYAL COURTYARD

PROJECT:-
PROPOSED RESIDENTIAL APARTMENT FOR
PLOT NO=60,61,69,70,UDAY VATIKA,
SANGANER,JAIPUR.

CLIENT NAME:-
RRP BUILDCON LLP
RAHUL GUPTA (PARTNER)

ARCHITECT
M/S AKRITI AYOJAN
ARCHITECTS, INTERIOR DESIGNERS.
E-87, THIRD FLOOR, MANGLAM TOWER, RD#8 SEKH
GOPALPURA, JAIPUR-06, RAJASTHAN. 3351154101
suryaprakash.arch@gmail.com;

DATE: NORTH :

Cube Consultant
Jaipur

Aman Gupta
M.E.P. Consultant
B.E. Electrical

For RRP Buildcon LLP
Designated Partner

PROPOSED TYPICAL FLOOR
CABLE ROUTE LAYOUT



1. ALL DIMENSIONS ARE IN MM, UNLESS SPECIFIED OTHERWISE.
2. THE DIMENSIONS ARE TO BE READ ONLY AND NOT TO BE MEASURED.
3. ANY DISCREPANCY IN THE DRAWING SHOULD BE BROUGHT IN THE NOTICE OF THE ARCHITECT.

SYMBOL	DESCRIPTION
	DISTRIBUTION BOX
	SWITCH BOARD (6A SOCKET & SWITCHES)
	16 A. SOCKET WITH SWITCH
	6A POWER SOCKET WITH SWITCH
	CAMERA
	25A AC SWITCH @HT.4-0"
	SPLIT AC
	6A SS,FAN REGULATOR,TL SWITCH @HT. 2-6"
	6A SS,25 A AC @HT. 2-6"
	16A SS FOR FRIEDGE @HT 5-6"
	6A SS FOR CHIMNEY @HT 5-6"
	16A SS FOR MICROWAVE & 6A SS FOR MIXER @HT 5-6"
	16A SS FOR GYSER & 6A SS FOR RO @HT 5-6"
	6A 2 NOS. SOCKET +1 NOS. 16A SWITCH ,TV COAXIAL. SOCKET @HT 3-6"
	TOILET MIRROR LIGHT 1x18w
	WALL FAN
	CELLING LIGHT
	CELLING LIGHT
	TUBE LIGHT
	WALL BRACKET LED LIGHT
	900 / 1200 MM SWEEP CEILING FAN
	1 x 72 W CHANDELIER LIGHT
	2 x 5 W CONCEALED FOOT LIGHT
	EXHAUST FAN(AS PER FURNITURE)
	GYSER POINT(AS PER FURNITURE)
	3 x 1.5 SQMM LIGHT CONTROL CU. WIRE
	3 x 1.5 SQMM 2 WAY LIGHT CONTROL WIRE
	3 x 2.5 SQMM CU. WIRE FOR AC IDU
	3 x 4.0 SQMM CU. WIRE FOR POWER CIRCUIT
	3 x 2.5 SQMM CU. WIRE FOR LIGHT CIRCUIT
	CAT-6 LAN WIRE RJ-45 JACK TO LAN SWITCH
	CAT-6 TELEPHONE WIRE RJ-11 JACK TO TTB
	RG-6 TV CABLE SETUP BOX TO TV SPLITTER
	CAT-6 CCTV CABLE CCTV CAMERA TO NVR

 **cube consultant**
A-8, PATH NO. 4, JAMUNA NAGAR,
SODALA, JAIPUR-302006
MAIL: - cubemep@gmail.com
PH. NO. +91 141 2221089, 9214308430,

DWG NO		
--------	--	--

SCALE:- 1= 100	DATE
----------------	------

PROJECT:-
PROPOSED RESIDENTIAL APARTMENT FOR
PLOT NO=60,61,69,70,UDAY VATIKA,
SANGANER,JAIPUR.


ARCHITECT

ARCHITECTS. INTERIOR DESIGNERS.
E-87, THIRD FLOOR, MANGLAM TOWER, RIDHI SIDHI,
GOPALPURA, JAIPUR-06, RAJASTHAN. 935115410
suryaprakash.arch@gmail.com ;

DATE:	NORTH
-------	-------

NORTH



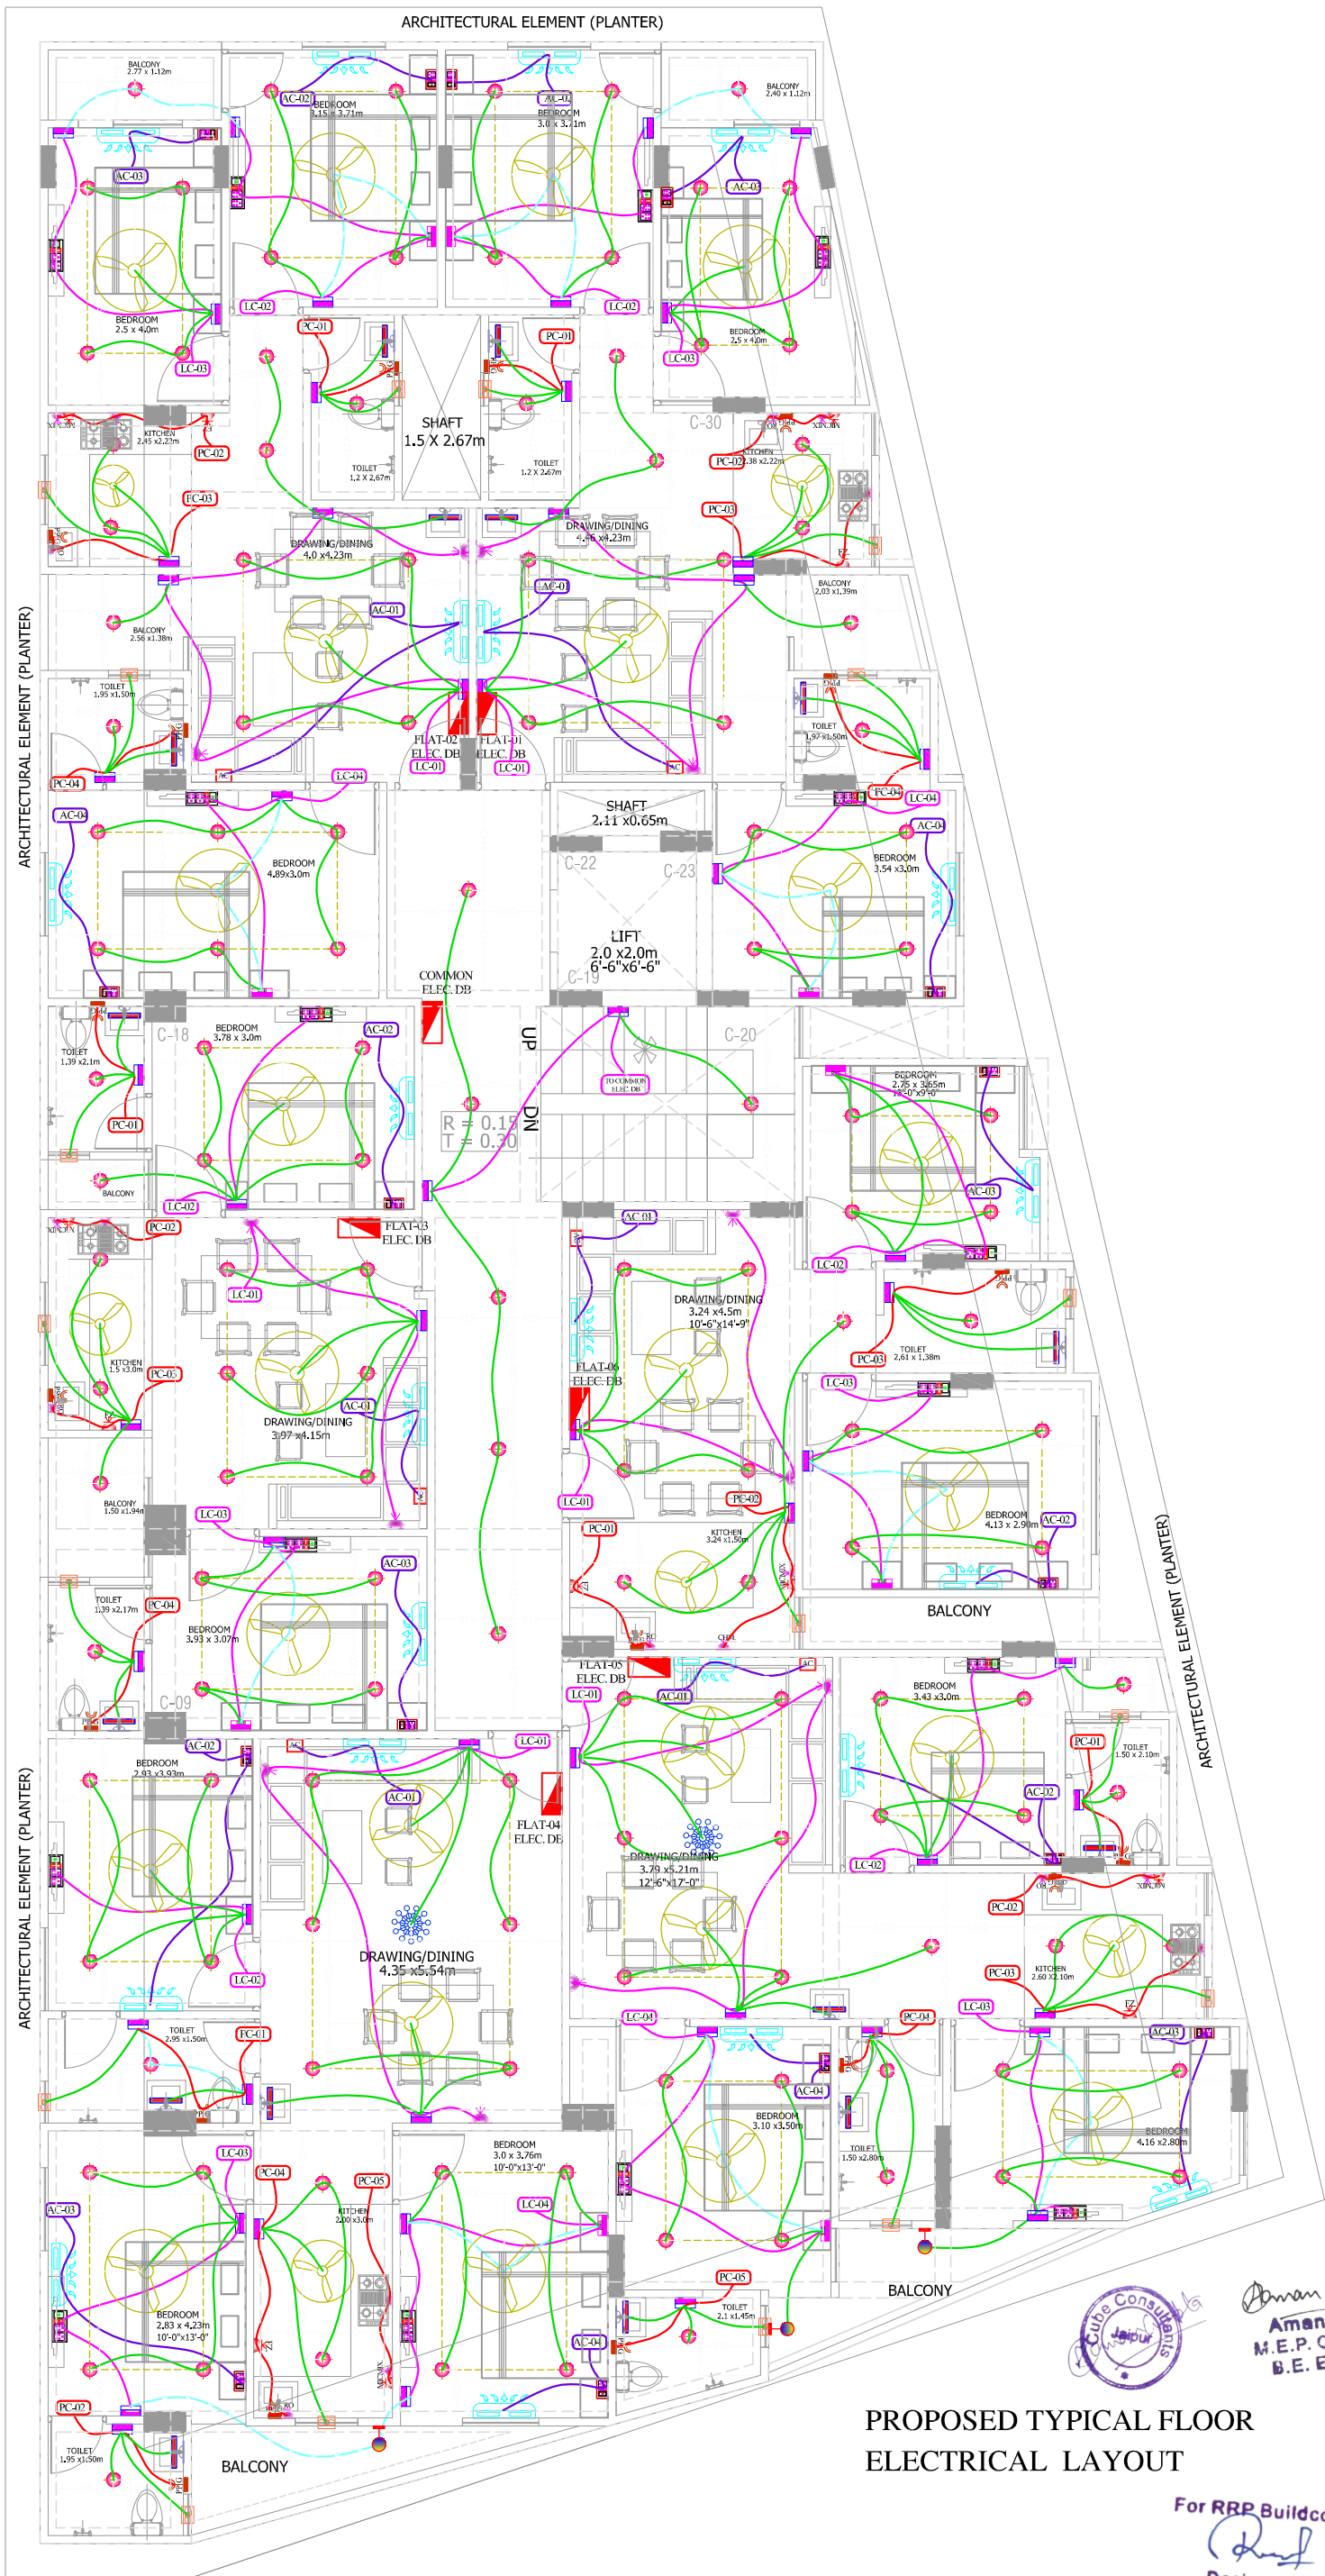

PROPOSED TYPICAL FLOOR ELECTRICAL LAYOUT

For RRP Buildcon LLP
Designated Partner

GENERAL NOTES

1. ALL DIMENSIONS ARE IN MM.
UNLESS SPECIFIED OTHERWISE.
2. THE DIMENSIONS ARE TO BE READ ONLY
AND NOT TO BE MEASURED.
3. ANY DISCREPANCY IN THE DRAWING SHOULD BE
BROUGHT IN THE NOTICE OF THE ARCHITECT.

LEGEND

SYMBOL	DESCRIPTION
	DISTRIBUTION BOX
	SWITCH BOARD (6A SOCKET & SWITCHES)
	16 A SOCKET WITH SWITCH
	6A POWER SOCKET WITH SWITCH
	CAMERA
	25A AC SWITCH@HT.4'-0"
	SPLIT AC
	6A SS FAN REGULATOR,TL SWITCH @HT. 2'-6"
	6A SS 25 A AC @HT. 2'-6"
	16A SS FOR FRIDGE@HT 5'-6"
	6A SS FOR CHIMNEY@HT 5'-6"
	16A SS FOR MICROWAVE & 6A SS FOR MIXER @HT 5'-6"
	16A SS FOR GEYSER & 6A SS FOR RO @HT 5'-6"
	6A 2 NOS. SOCKET +1 NOS. 16A SWITCH,TV COAXIAL SOCKET@HT 3'-6"
	TOILET MIRROR LIGHT 1x18w
	WALL FAN
	CEILING LIGHT
	CEILING LIGHT
	TUBE LIGHT
	WALL BRACKET LED LIGHT
	900 / 1200 MM SWEEP CEILING FAN
	1 x 72 W CHANDELIER LIGHT
	2 x 5 W CONCEALED FOOT LIGHT
	EXHAUST FAN(AS PER FURNITURE)
	GEYSER POINT(AS PER FURNITURE)
	3 x 1.5 SQMM LIGHT CONTROL CU. WIRE
	3 x 1.5 SQMM 2 WAY LIGHT CONTROL WIRE
	3 x 2.5 SQMM CU. WIRE FOR AC IDU
	3 x 4.0 SQMM CU. WIRE FOR POWER CIRCUIT
	3 x 2.5 SQMM CU. WIRE FOR LIGHT CIRCUIT
	CAT-6 LAN WIRE RJ-45 JACK TO LAN SWITCH
	CAT-6 TELEPHONE WIRE RJ-11 JACK TO TTB
	RG-6 TV CABLE SETUP BOX TO TV SPLITTER
	CAT-6 CCTV CABLE CCTV CAMERA TO NVR

MEP CONSULTANT : --

cube consultant
A-8, PATH NO. 4, JAMUNA NAGAR,
SODALA, JAIPUR-302006
MAIL: - cubemep@gmail.com
PH. NO. +91 141 2221089, 9214308430,

DEALT BY MANISH MEWARA	REVISION	DATE:16.03.2026
DWG NO		

TITLE:-

TYPICAL FLOOR
ELECTRICAL LAYOUT

SCALE:- 1= 100	DATE:
----------------	-------

PROJECT NAME:-

THE ROYAL COURTYARD

PROJECT:-

PROPOSED RESIDENTIAL APARTMENT FOR
PLOT NO=60,61,69,70,UDAY VATIKA,
SANGANER,JAIPUR.

CLIENT NAME:-

RRP BUILDCON LLP
RAHUL GUPTA (PARTNER)


ARCHITECT

M/S AKRITI AYOJAN

ARCHITECTS, INTERIOR DESIGNERS.

E-87, THRD FLOOR, MANGLAM TOWER, RDH SIKHI,
GOPALPURA, JAIPUR-302006, RAJASTHAN. 9351154101
suryaprakash.arch@gmail.com ;

DATE:	NORTH :

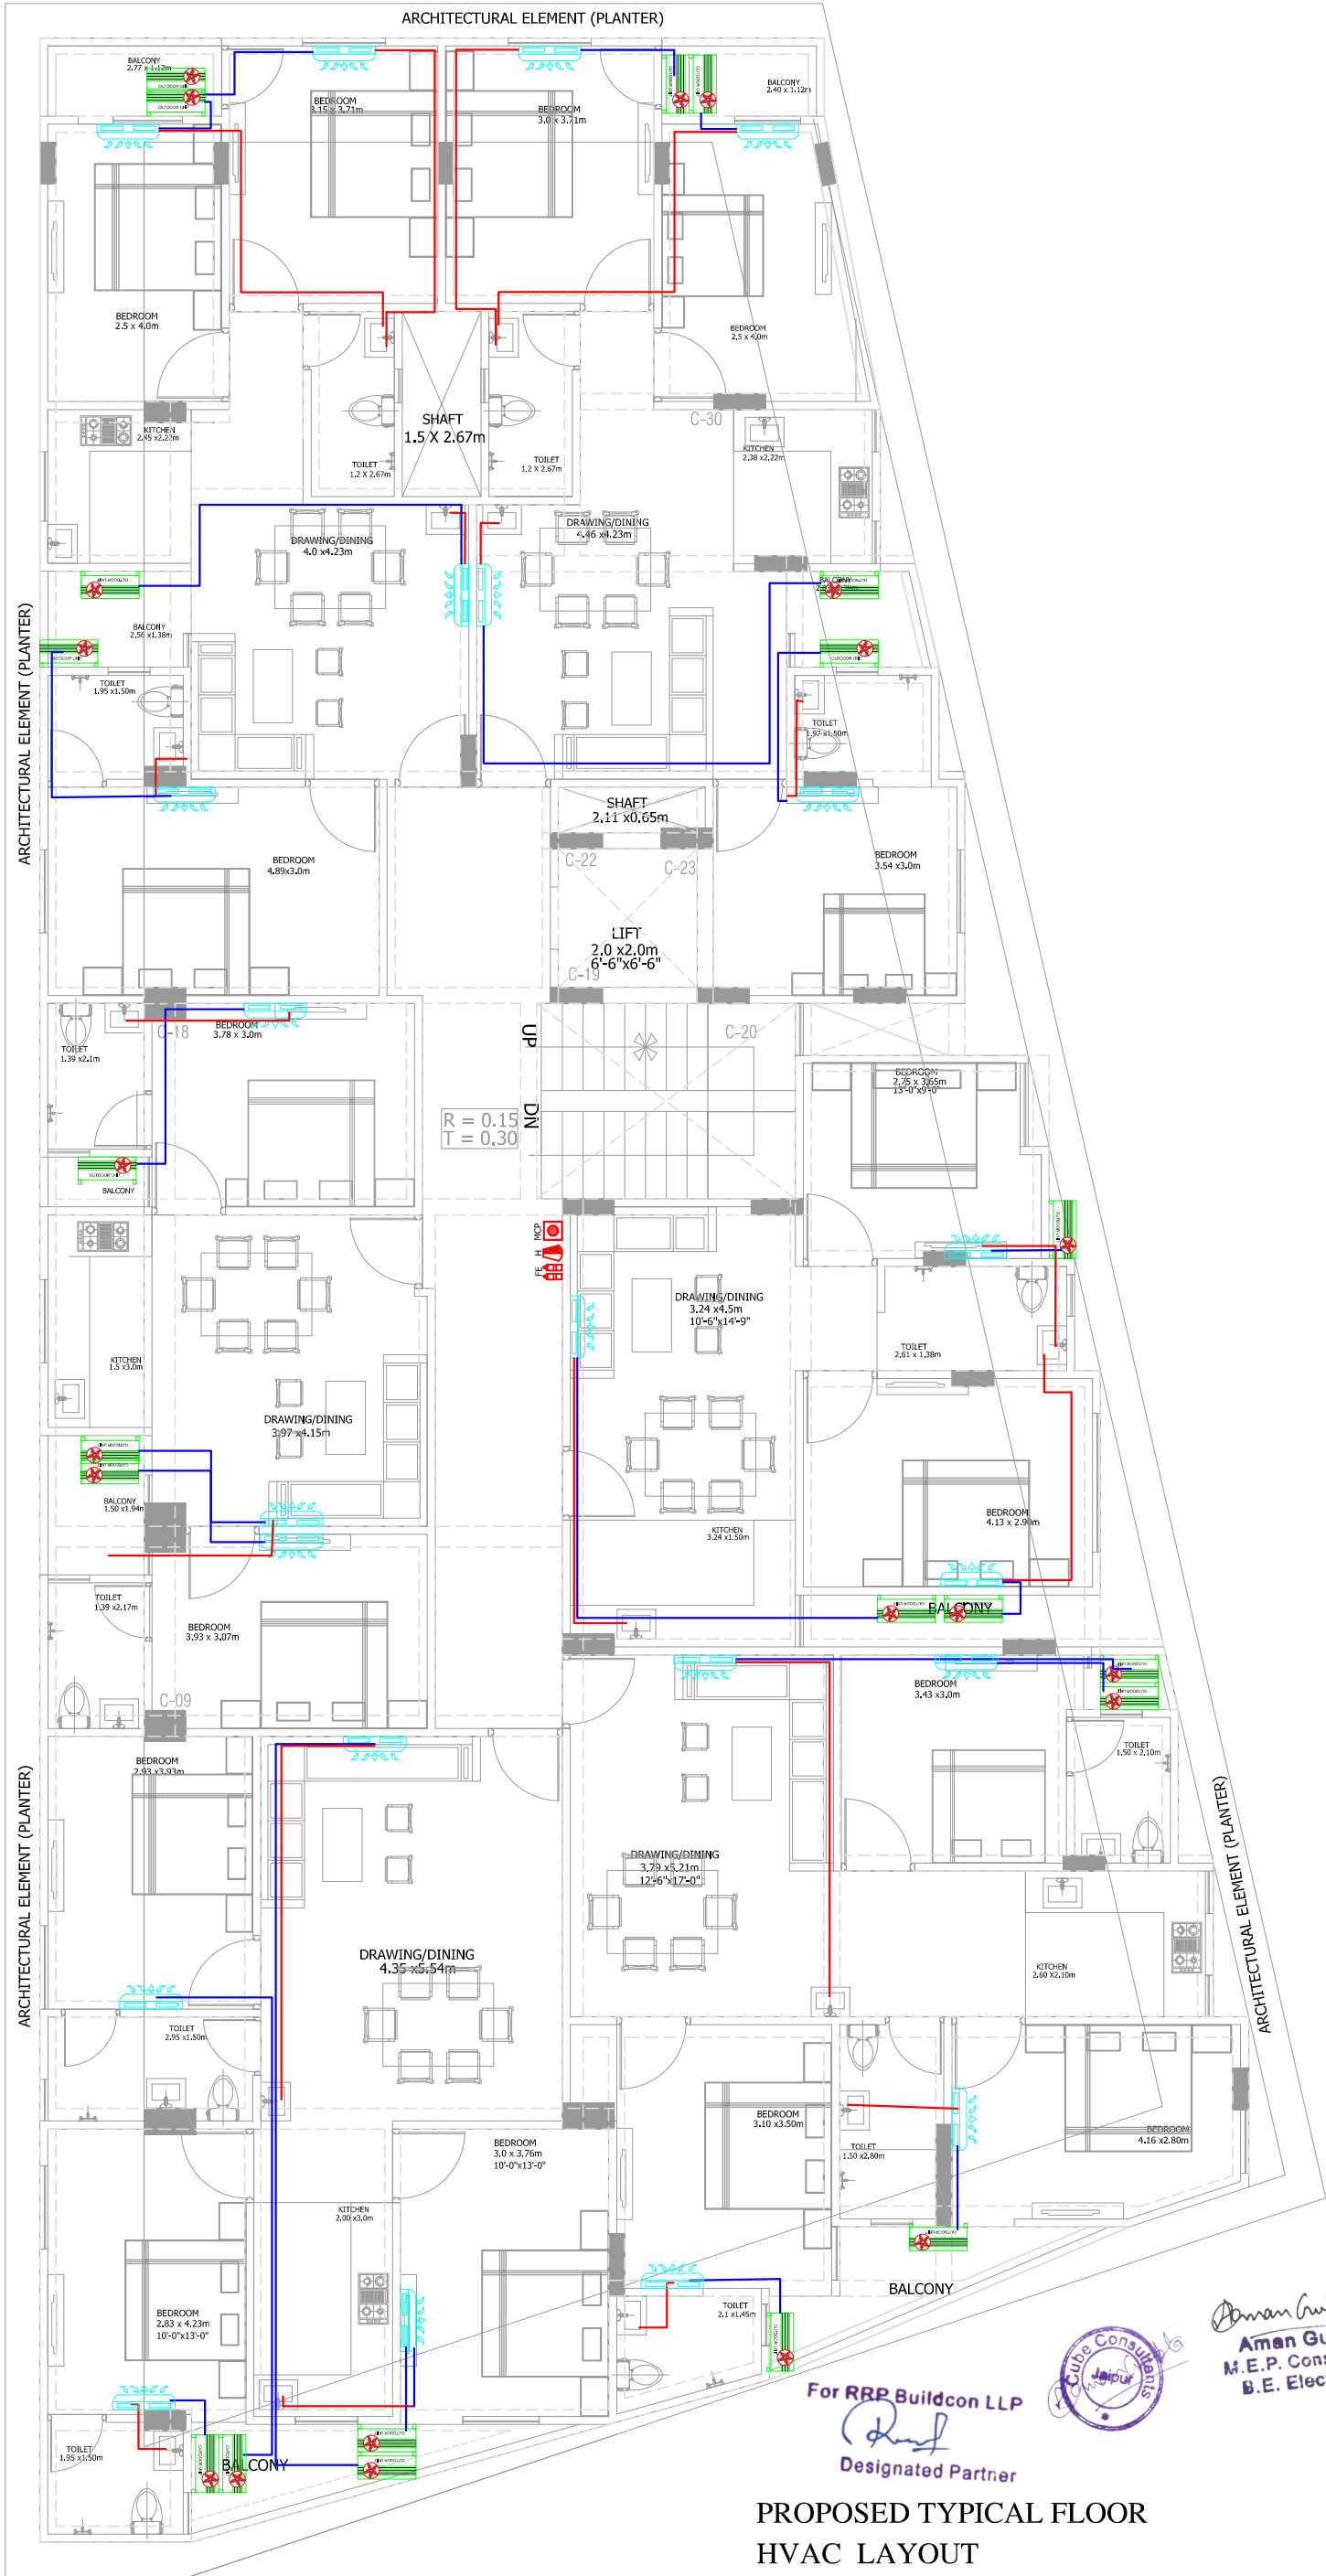

GENERAL NOTES

1. ALL DIMENSIONS ARE IN MM, UNLESS SPECIFIED OTHERWISE.
2. THE DIMENSIONS ARE TO BE READ ONLY AND NOT TO BE MEASURED.
3. ANY DISCREPANCY IN THE DRAWINGS SHOULD BE BROUGHT IN THE NOTICE OF THE ARCHITECT.

LEGEND

SYMBOL	DESCRIPTION
	DISTRIBUTION BOX
	SWITCH BOARD (6A SOCKET & SWITCHES)
	16 A SOCKET WITH SWITCH
	6A POWER SOCKET WITH SWITCH
	CAMERA
	25A AC SWITCH@HT.4'-0"
	SPLIT AC
	6A SS FAN REGULATOR, TL SWITCH @HT. 2'-6"
	6A SS 25 A AC @HT. 2'-6"
	16A SS FOR FRIDGE@HT 5'-6"
	6A SS FOR CHIMNEY@HT 5'-6"
	16A SS FOR MICROWAVE & 6A SS FOR MIXER @HT 5'-6"
	16A SS FOR GEYSER & 6A SS FOR RO @HT 5'-6"
	6A 2 NOS. SOCKET +1 NOS. 16A SWITCH, TV COAXIAL SOCKET@HT 3'-6"
	TOILET MIRROR LIGHT 1x18w
	WALL FAN
	CEILING LIGHT
	CEILING LIGHT
	TUBE LIGHT
	WALL BRACKET LED LIGHT
	900 / 1200 MM SWEEP CEILING FAN
	1 x 72 W CHANDELIER LIGHT
	2 x 5 W CONCEALED FOOT LIGHT
	EXHAUST FAN (AS PER FURNITURE)
	GEYSER POINT (AS PER FURNITURE)
	3 x 1.5 SQMM LIGHT CONTROL CU. WIRE
	3 x 1.5 SQMM 2 WAY LIGHT CONTROL WIRE
	3 x 2.5 SQMM CU. WIRE FOR AC IDU
	3 x 4.0 SQMM CU. WIRE FOR POWER CIRCUIT
	3 x 2.5 SQMM CU. WIRE FOR LIGHT CIRCUIT
	CAT-6 LAN WIRE RJ-45 JACK TO LAN SWITCH
	CAT-6 TELEPHONE WIRE RJ-11 JACK TO TTB
	RG-6 TV CABLE SETUP BOX TO TV SPLITTER
	CAT-6 CCTV CABLE CCTV CAMERA TO NVR

MEP CONSULTANT :-

cube consultant
A-8, PATH NO. 4, JAMUNA NAGAR,
SODALA, JAIPUR-302006
MAIL:- cubemep@gmail.com
PH. NO. +91 141 2221089, 9214308430,

DEALT BY MANISH MEWARA	REVISION	DATE:16.03.2026
DWG NO		

TITLE:-
PROPOSED TYPICAL FLOOR
HVAC LAYOUT

SCALE:- 1= 100

DATE:

PROJECT NAME:-

THE ROYAL COURTYARD

PROJECT:-

PROPOSED RESIDENTIAL APARTMENT FOR
PLOT NO=60,61,69,70,UDAY VATIKA,
SANGANER,JAIPUR.

CLIENT NAME:-

RRP BUILDCON LLP
RAHUL GUPTA (PARTNER)

ARCHITECT

M/S AKRITI AYOJAN

ARCHITECTS. INTERIOR DESIGNERS.

E-87, THIRD FLOOR, MANGLAM TOWER, RDH SIDHI,
GOPALPURA, JAIPUR-302006, RAJASTHAN 935154101
suryaprakash.arch@gmail.com ;

DATE:

NORTH :

