


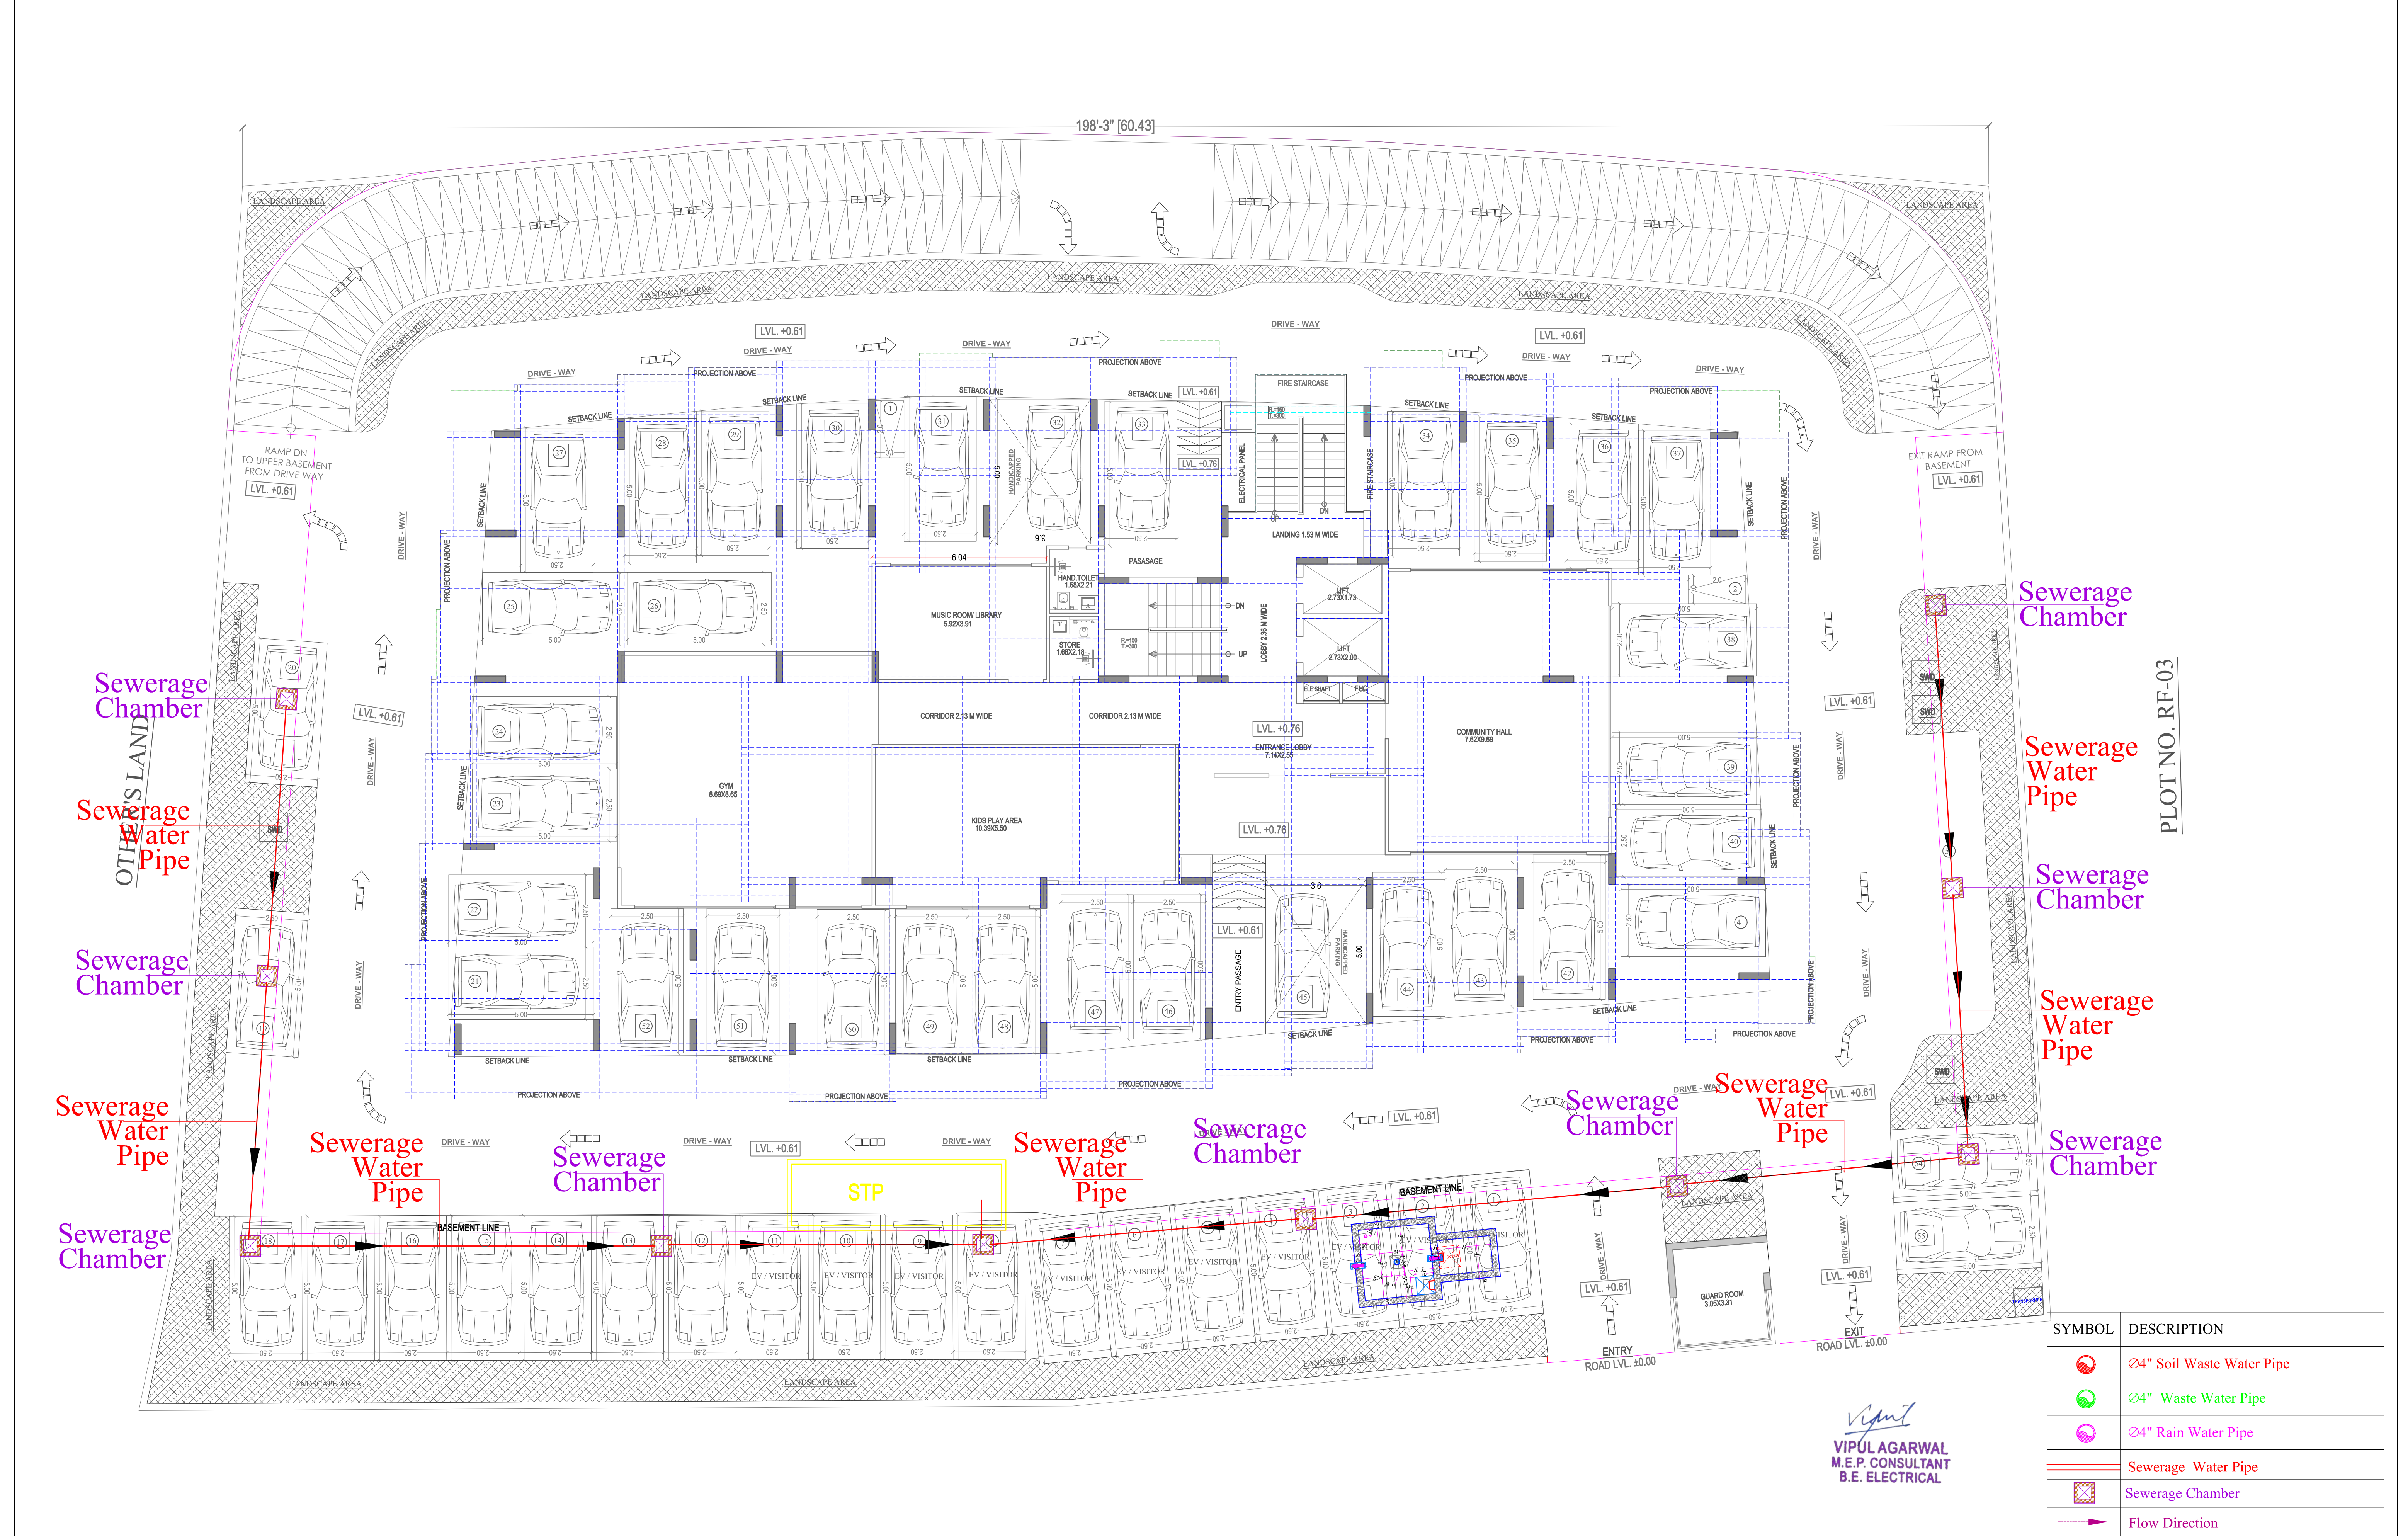

PLOT NO. RF-03

SYMBOL	DESCRIPTION
	Ø4" Soil Waste Water Pipe
	Ø4" Waste Water Pipe
	Ø4" Rain Water Pipe
	Sewerage Water Pipe
	Sewerage Chamber
	Flow Direction

PROJECT:-

PROPOSED RESIDENTIAL BUILDING AT
KH. 721/1,721,722,742,742/1,743/1, 743,744 ,
VILLAGE-JAISINGHPURA,
TEH.- SANGANER, JAIPUR

SCALE:-

1:100

DATE:-

17-11-2025

NORTH:-

PROMOTER NAME:-

ARD BUILDHOME PVT.LTD.

PROJECT NAME -

VANTARA LL

DRAWING TITLE :-

EXTERNAL SEWERAGE
WATER PIPE ROUTE PLAN


ARCHITECT:-

B-6, GANESH KRIPA, MOTI MARG,
BAPU NAGAR JAIPUR - 302015.
TEL. 9314510603, 0141-4062903

SERVICES CONSULTANT:

ASHI ASSOCIATES
F 9 / 440 , Keshav Marg Chitrakut Scheme,Jaipur
PH:91-0-93146-10438 ,0141-2440946 Mail:vipul8599@yahoo.com


SYMBOL	DESCRIPTION
	Ø110 mm Soil Waste Water Pipe
	Ø110 mm Waste Water Pipe
	110 mm Soil Waste Water Pipe
	110 mm Waste Water Pipe
	75 mm Waste Water Pipe
	Floor Trap

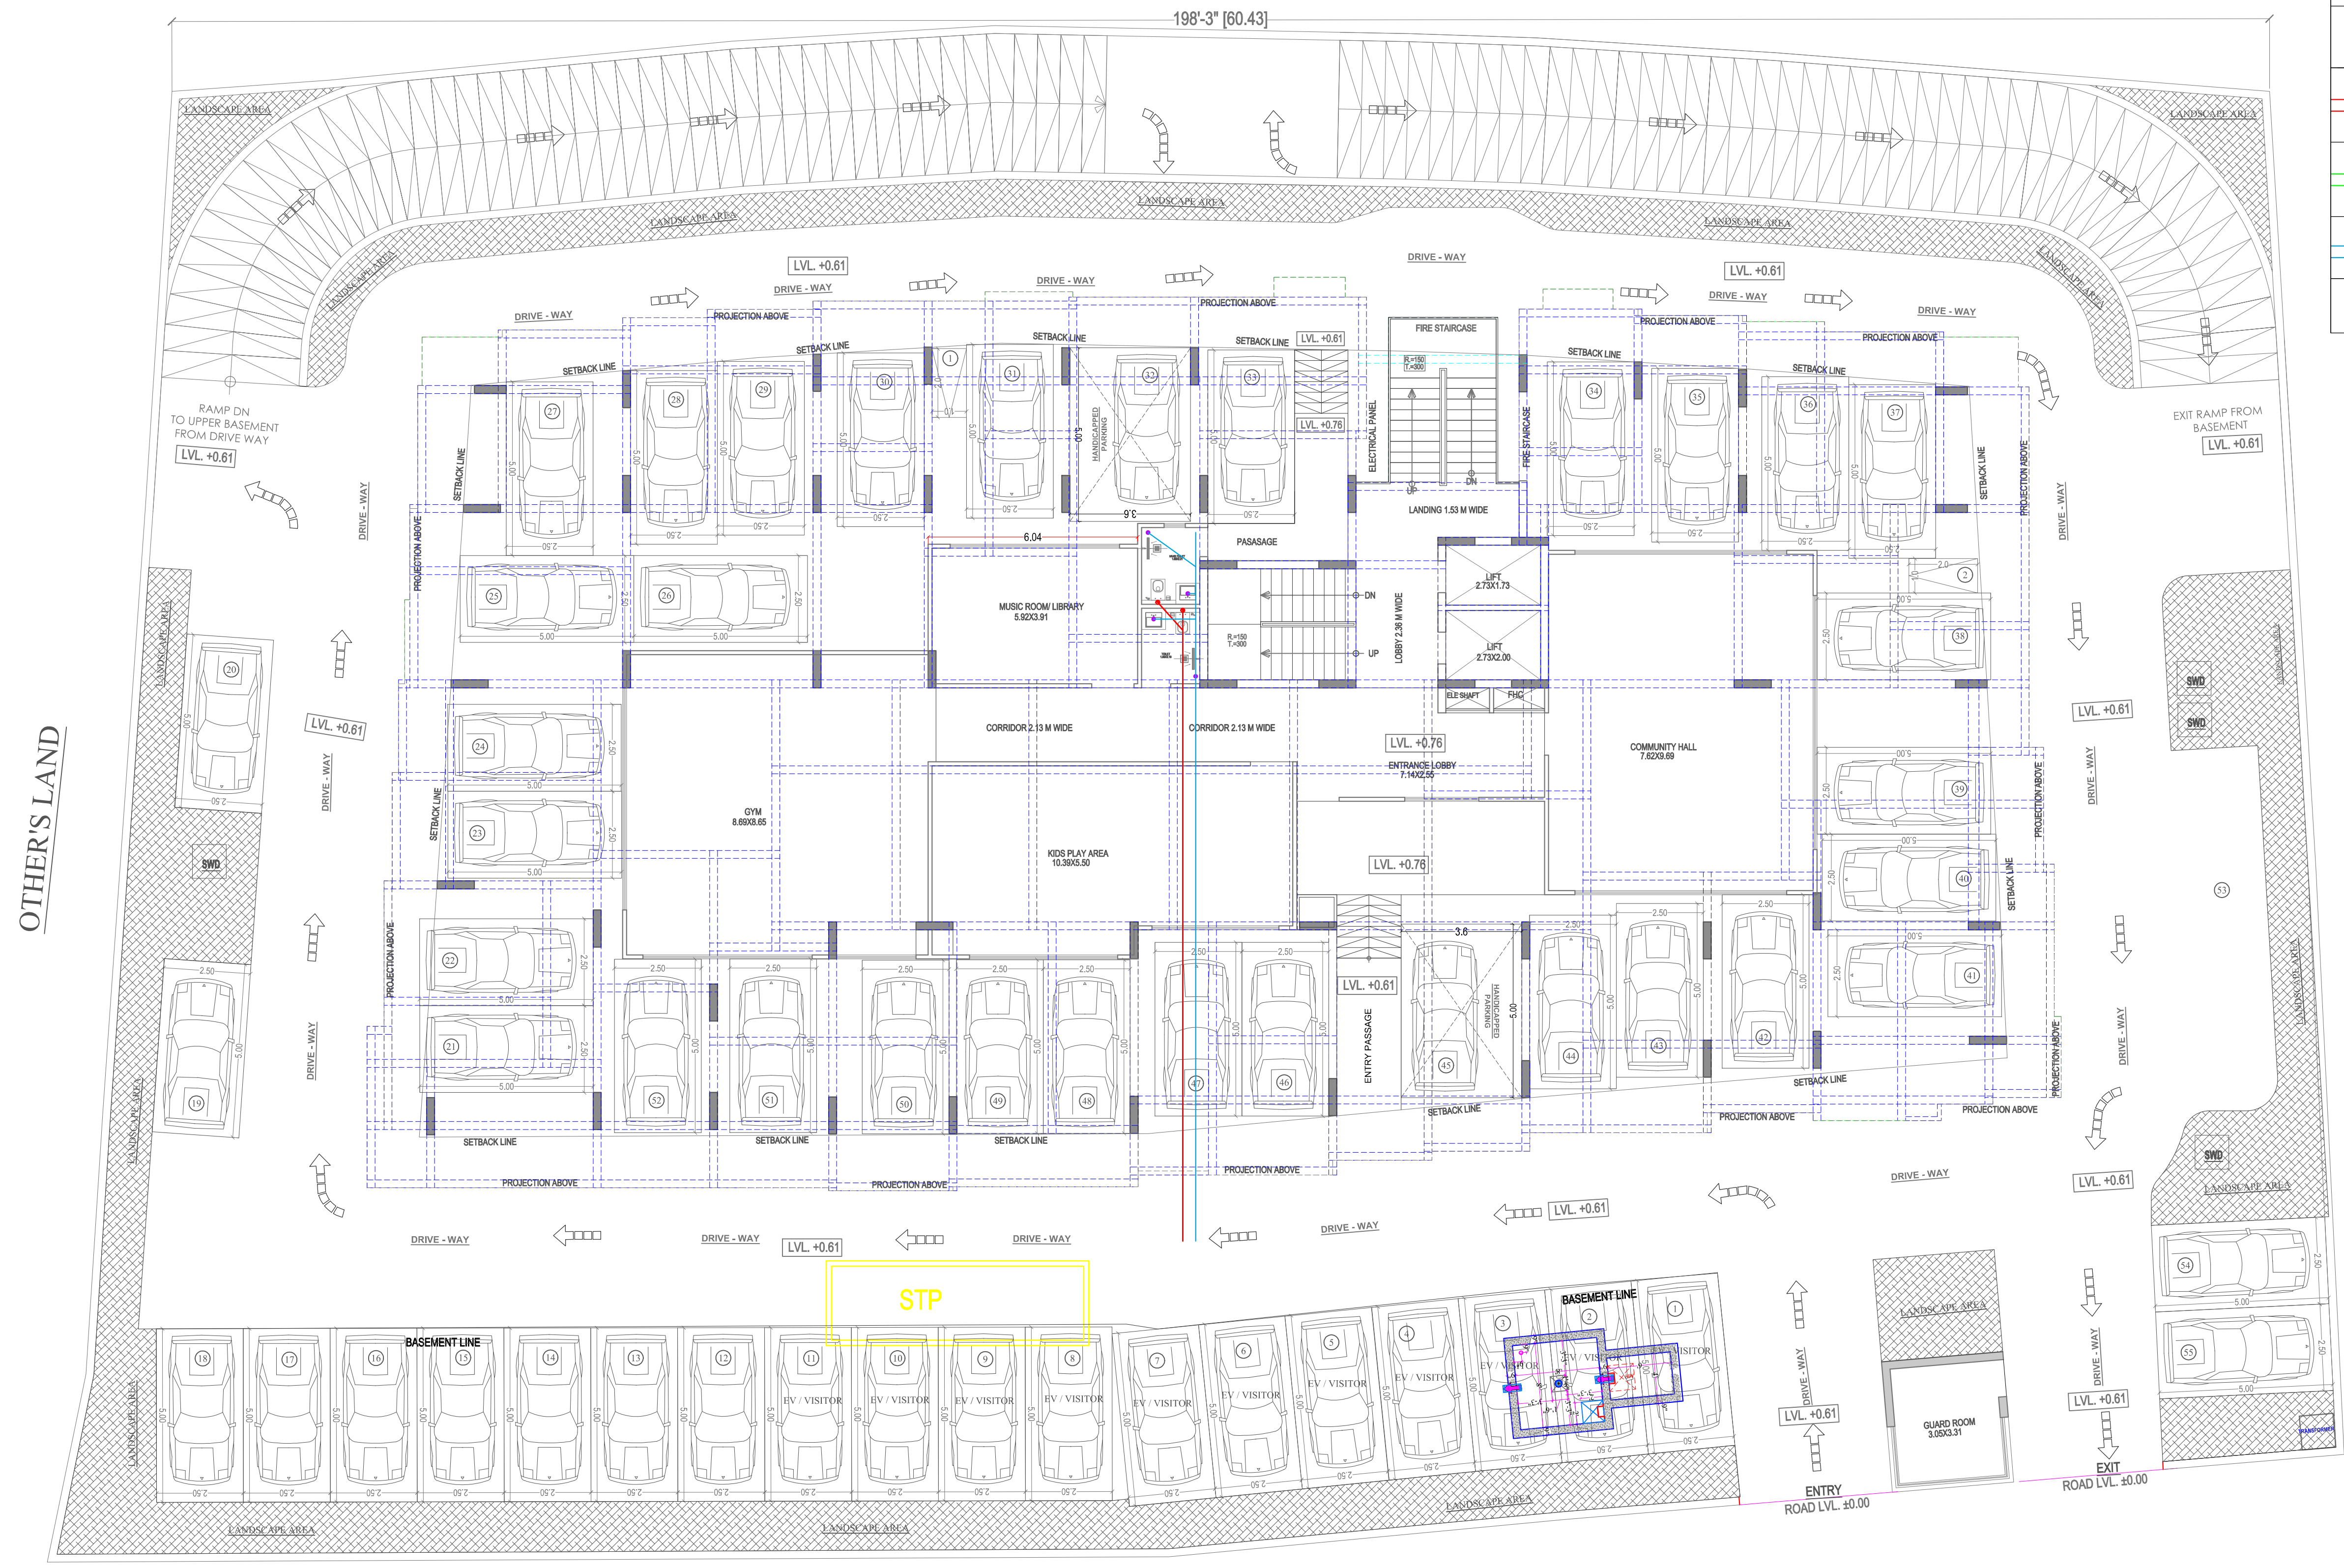

PLOT NO. RF-03

Vipul
VIPUL AGARWAL
M.E.P. CONSULTANT
B.E. ELECTRICAL

PROJECT:- PROPOSED RESIDENTIAL BUILDING AT KH. 721/1,721,722,742,742/1,743/1, 743,744 , VILLAGE-JAISINGHPURA, TEH.- SANGANER, JAIPUR	SCALE:- 1:100 DATE:- 17-11-2025	NORTH:- 	PROMOTER NAME:- ARD BUILDHOME PVT.LTD. PROJECT NAME - VANTARA LL DRAWING TITLE :- STILT FLOOR COMMON TOILET DRAINAGE PLAN	ARCHITECT:- B-6, GANESH KRIPA, MOTI MARG, BAPU NAGAR JAIPUR - 302015. TEL. 9314510603, 0141-4062903	SERVICES CONSULTANT: ASHI ASSOCIATES F 9 / 440 , Keshav Marg Chitrakut Scheme,Jaipur PH:91-0-93146-10438 ,0141-2440946 Mail:vipul8599@yahoo.com
--	--	-------------	--	--	---

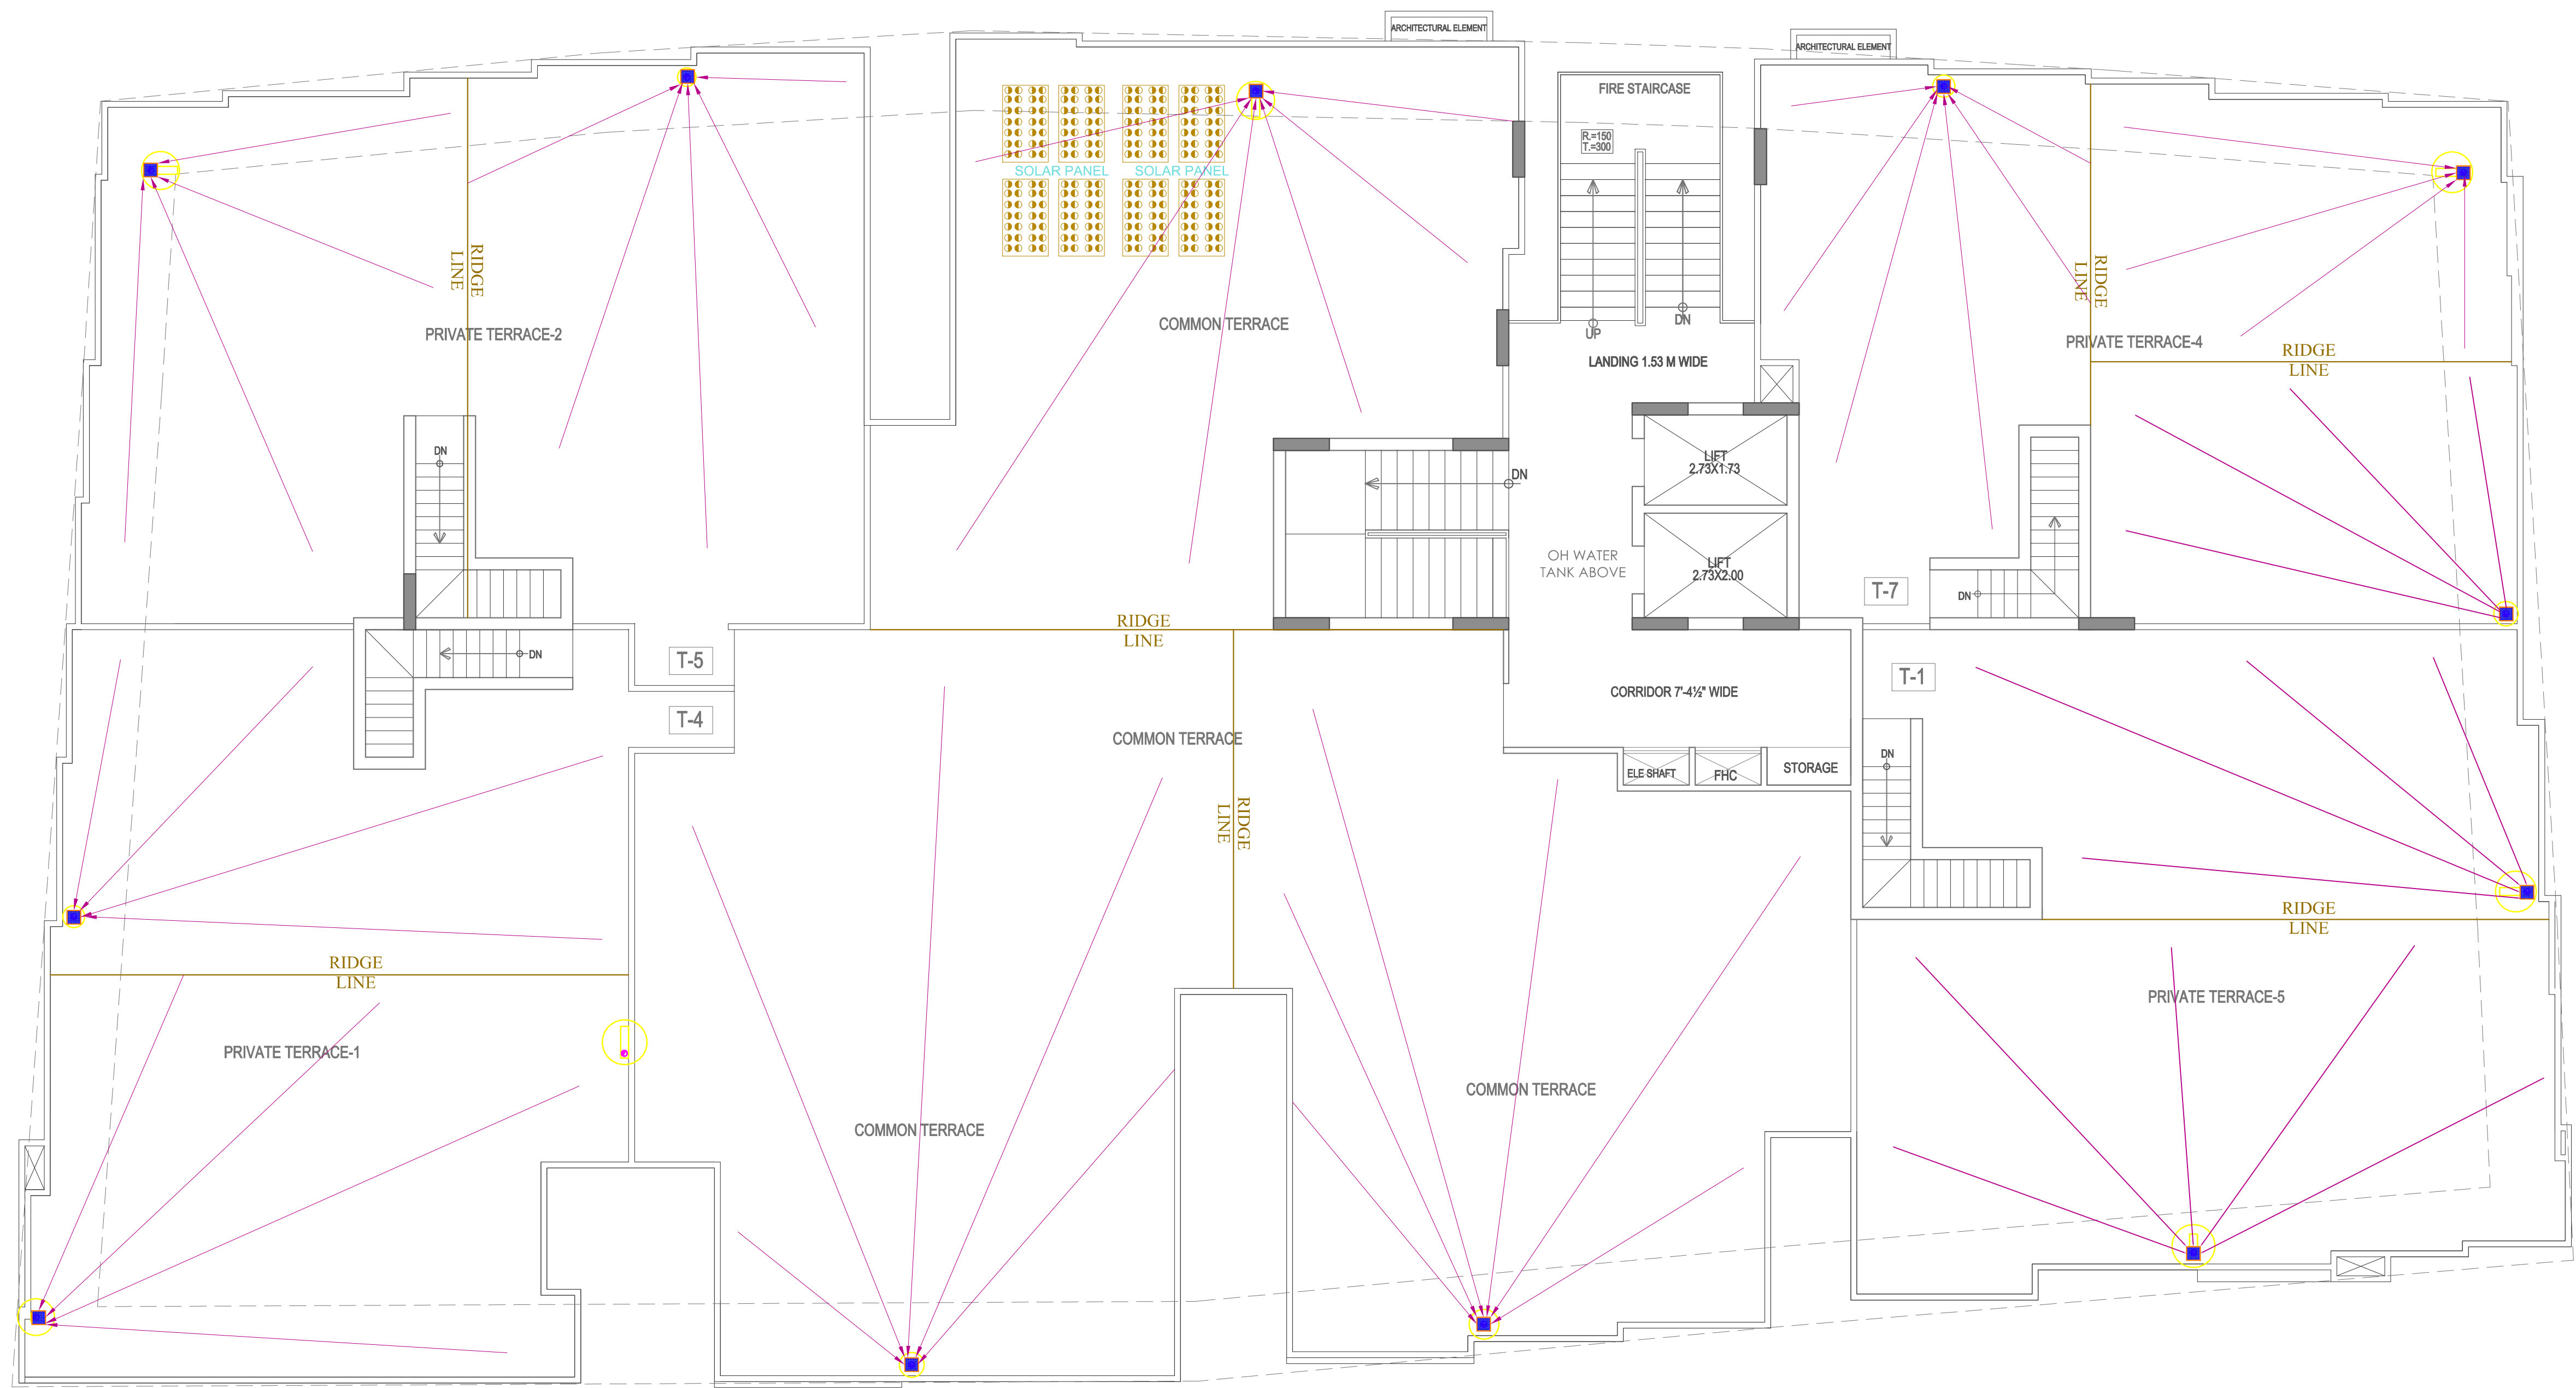


TERRACE FLOOR PLAN

SYMBOL	DESCRIPTION
	Ø110 mm Soil Waste Water Pipe
	Ø110 mm Waste Water Pipe
	Ø110 mm Rain Water Pipe
	Flow Direction
	TYPICAL SHAFT
	DROPAGE SHAFT
	110 mm Soil Waste Water Pipe
	110 mm Waste Water Pipe
	110 mm Rain Water Pipe
	75 mm Waste Water Pipe
	75 mm Rain Water Pipe
	50mm Waste Water Pipe Bottle Trap
	Floor Trap
	Rain Water Slope
	KHURRA 9"X9"
	Ridge Line

Vipul
VIPUL AGARWAL
M.E.P. CONSULTANT
B.E. ELECTRICAL

PROJECT:-
PROPOSED RESIDENTIAL BUILDING AT
KH. 721/1,721,722,742,742/1,743/1, 743,744 ,
VILLAGE-JAISINGHPURA,
TEH.- SANGANER, JAIPUR

SCALE:- 1:100
DATE:- 17-11-2025

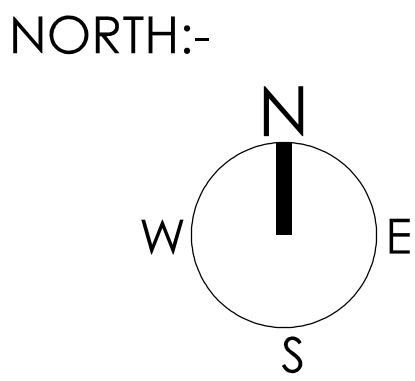

PROMOTER NAME:- ARD BUILDHOME PVT.LTD.
PROJECT NAME - VANTARA LL
DRAWING TITLE -: TERRACE FLOOR RAIN WATER
DRAINAGE PLAN

ARCHITECT:-

B-6, GANESH KRIPA, MOTI MARG,
BAPU NAGAR JAIPUR - 302015.
TEL. 9314510603, 0141-4062903

SERVICES CONSULTANT:
ASHI ASSOCIATES
F 9 / 440 , Keshav Marg Chitrakut Scheme,Jaipur
PH:91-0-93146-10438 ,0141-2440946 Mail:vipul8599@yahoo.com