


LEGENDS		
S.NO.	SYMBOL	DESCRIPTION
1.		SDR-11 Cold Water Pipe
2.		SDR-11 Hot Water Pipe
3.		Rain Water Pipe (R.W.P.)
4.		Waste Water Pipe (W.W.P.)
5.		Soil Pipe (S.P.)
6.		Butter Fly Valve (B.F.V.)
7.		Isolation Valve
8.		Angle Valve
9.		F.O. (F.O. Outlets)
10.		F.O. (F.O. Inlets)
11.		Tap (Water Point)
12.		Waste Water Vertical pipe
13.		Rain Water Vertical pipe
14.		Sewer Vertical pipe
15.		Domestic Water vertical pipe
16.		Rain Water Chamber
17.		Sewer Chamber
18.		Gully trap (GT)
19.		
20.		

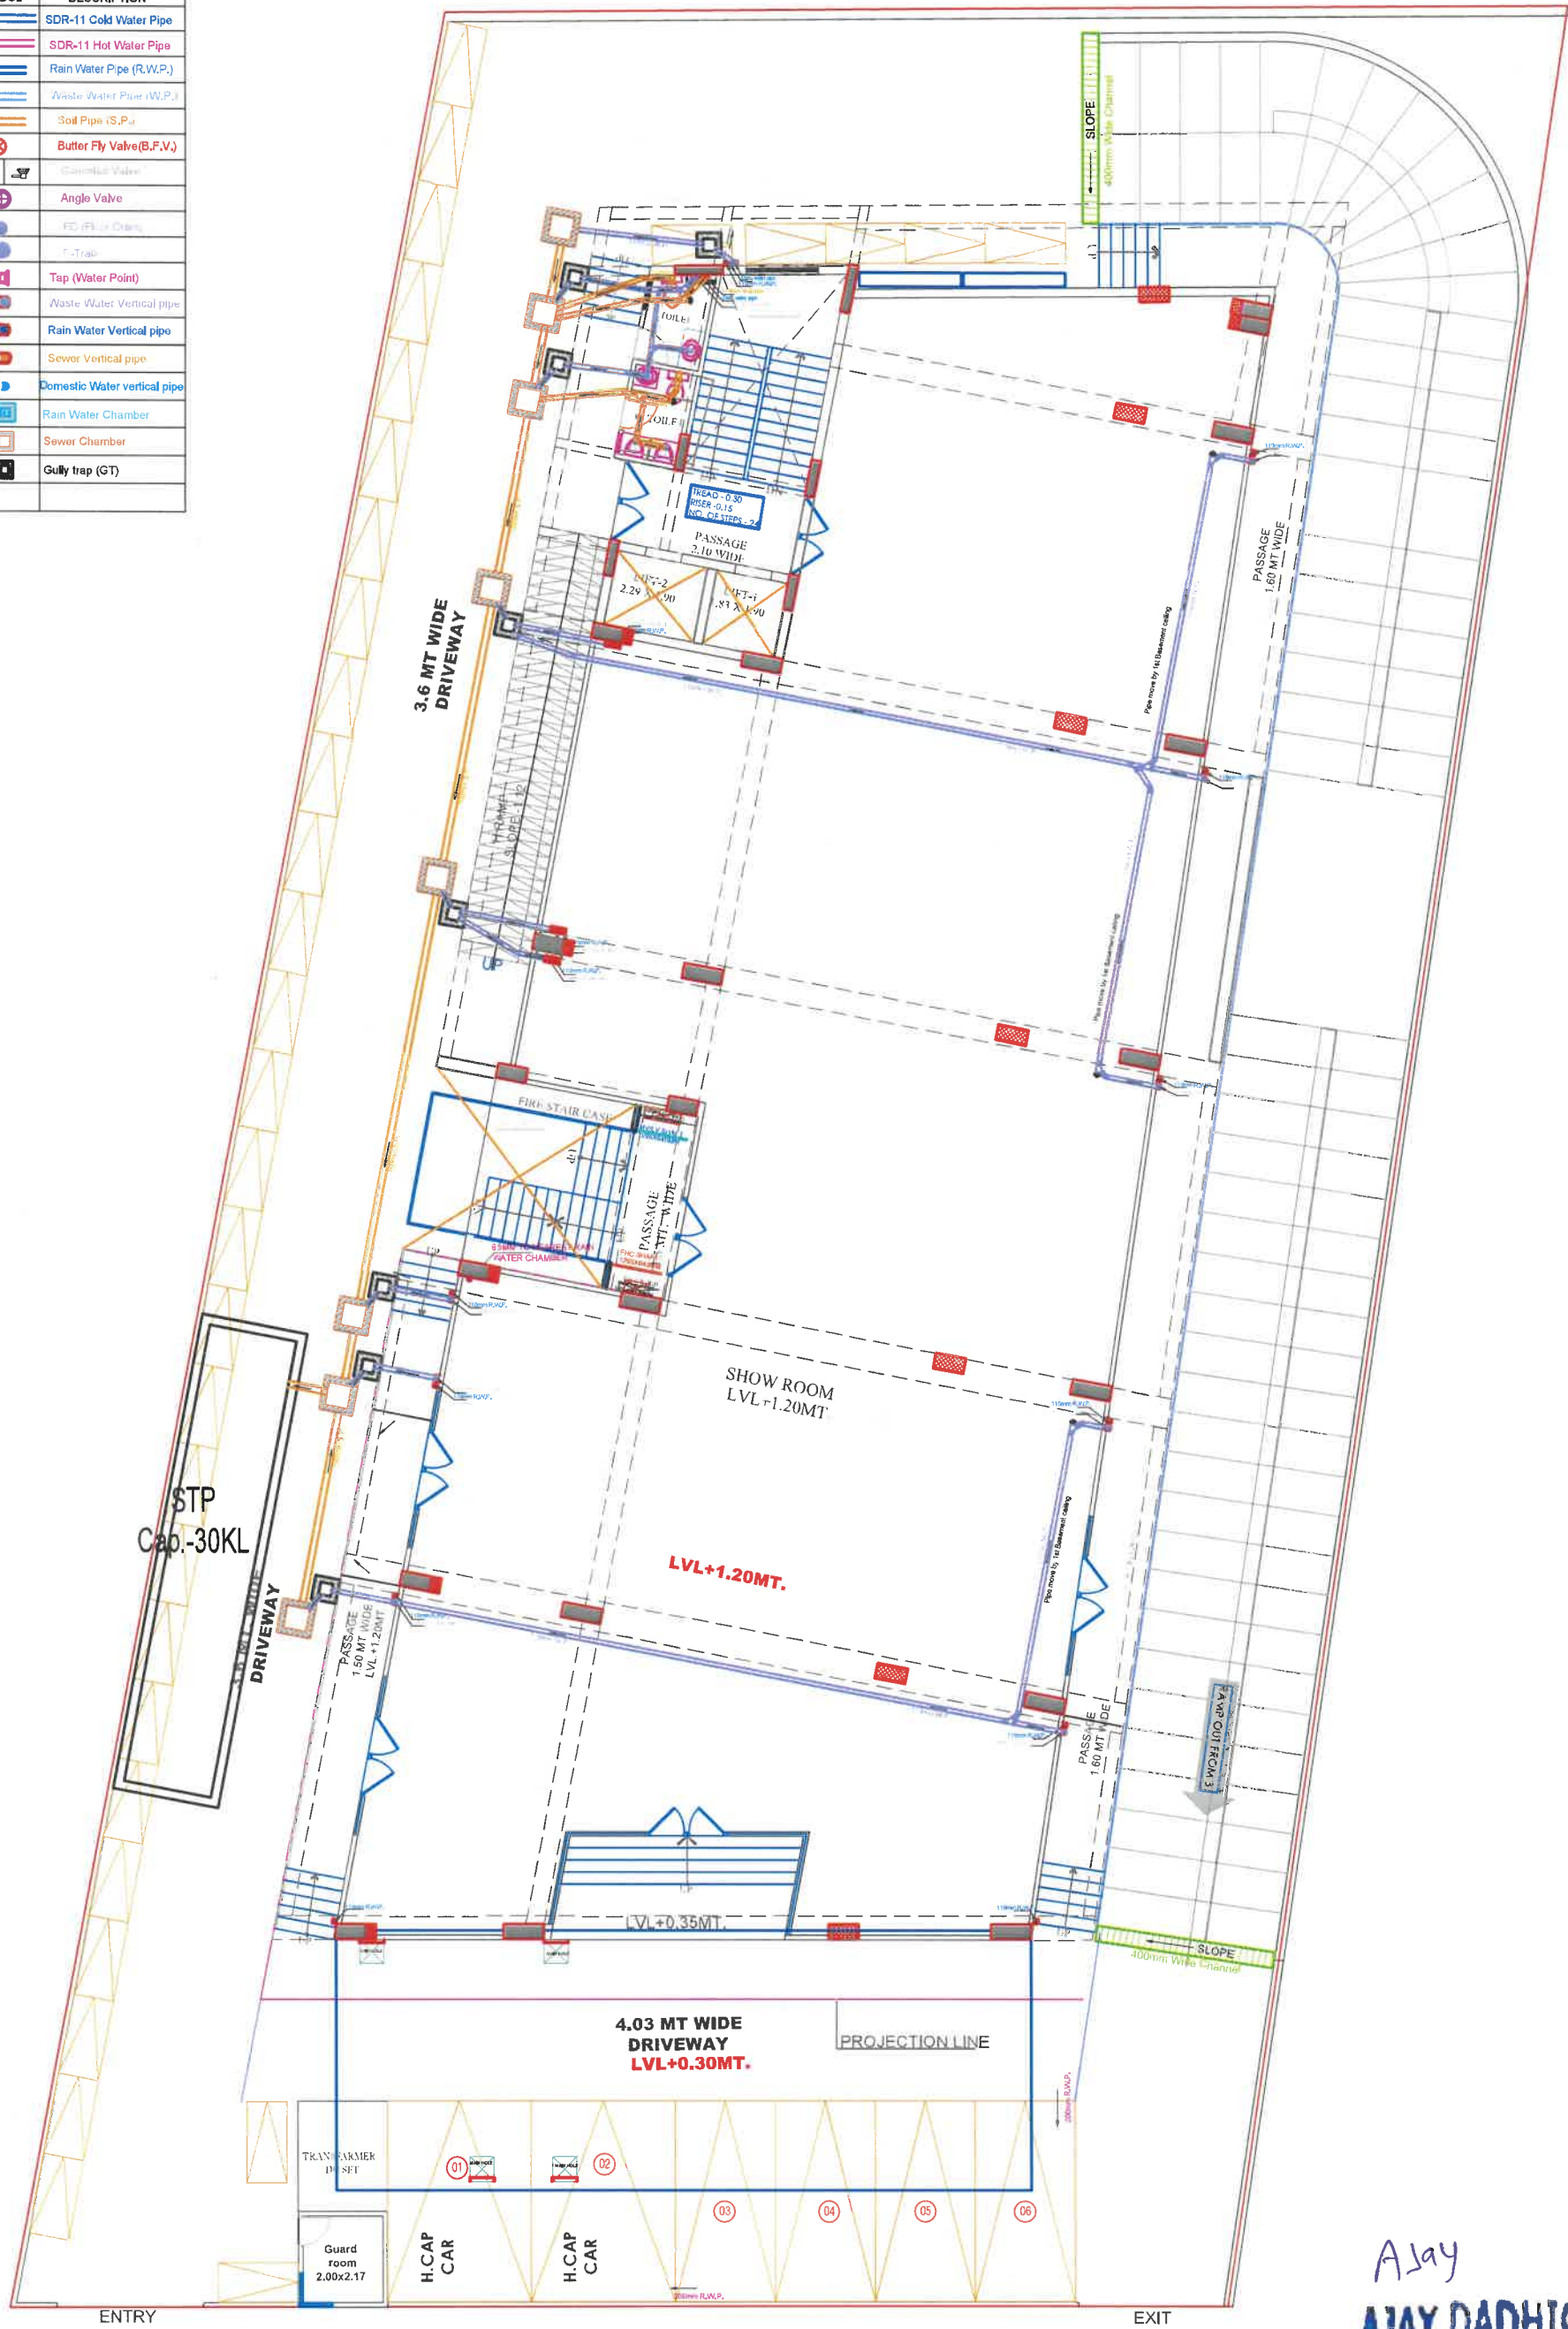

GROUND FLOOR PLAN

Ajay
AJAY DADHICH
BTECH ELECT)

PROJECT TITLE

CLIENT: SHIV VILLASREAL HOME PRIVATE LTD.
P.N-07,DR RAJENDRA P. NAGAR-E

DRAWING TITLE

NORTH



SHEET NO.

02

DATE:- 14/10/2025

DEALT BY:-

CHECKED BY:-

GROUND FLOOR SANITARY
FOR RERA SUBMISSION

SERVICES CONSULTANTS:

MEHTA ASSOCIATES

PLUMBING-FIRE FIGHTING-
ELECTRICAL-HVAC SYSTEM

22-23 Block-B, Narayan Vihar, Jaipur

E-Mail- mehta.mep@gmail.com

M.- 9001904980, 9799827471

DEVPRATIK

DEVELOPERS PVT.LTD.


E-66 HANUMAN PATH,NEW SANGANER ROAD

BEHIND SANJEEVANI HOSPITAL,SHYAM NAGAR EXT.

JAIPUR (RAJ.)


PH. 4062953

info@ddplindia.com

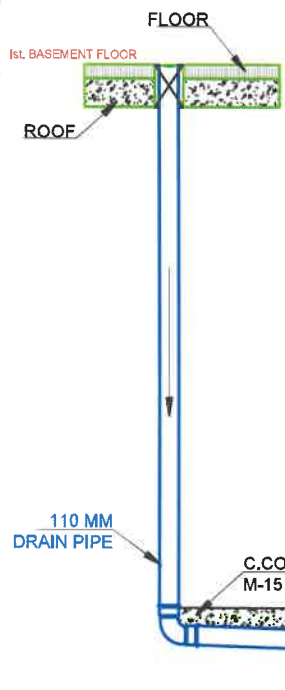


DETAIL-B


LEGENDS		
S.NO.	SYMBOL	DESCRIPTION
1.		SDR-11 Cold Water Pipe
2.		SDR-11 Hot Water Pipe
3.		Rain Water Pipe (R.W.P.)
4.		Waste Water Pipe (W.W.P.)
5.		Soil Pipe (S.P.)
6.		Butter Fly Valve(B.F.V.)
7.		Isolated Valve
8.		Angle Valve
9.		PT (Half or Cross)
10.		2-Trap
11.		Tap (Water Point)
12.		Waste Water Vertical pipe
13.		Rain Water Vertical pipe
14.		Sewer Vertical pipe
15.		Domestic Water vertical pipe
17.		Rain Water Chamber
18.		Sewer Chamber
19.		Gully trap (GT)
20.		

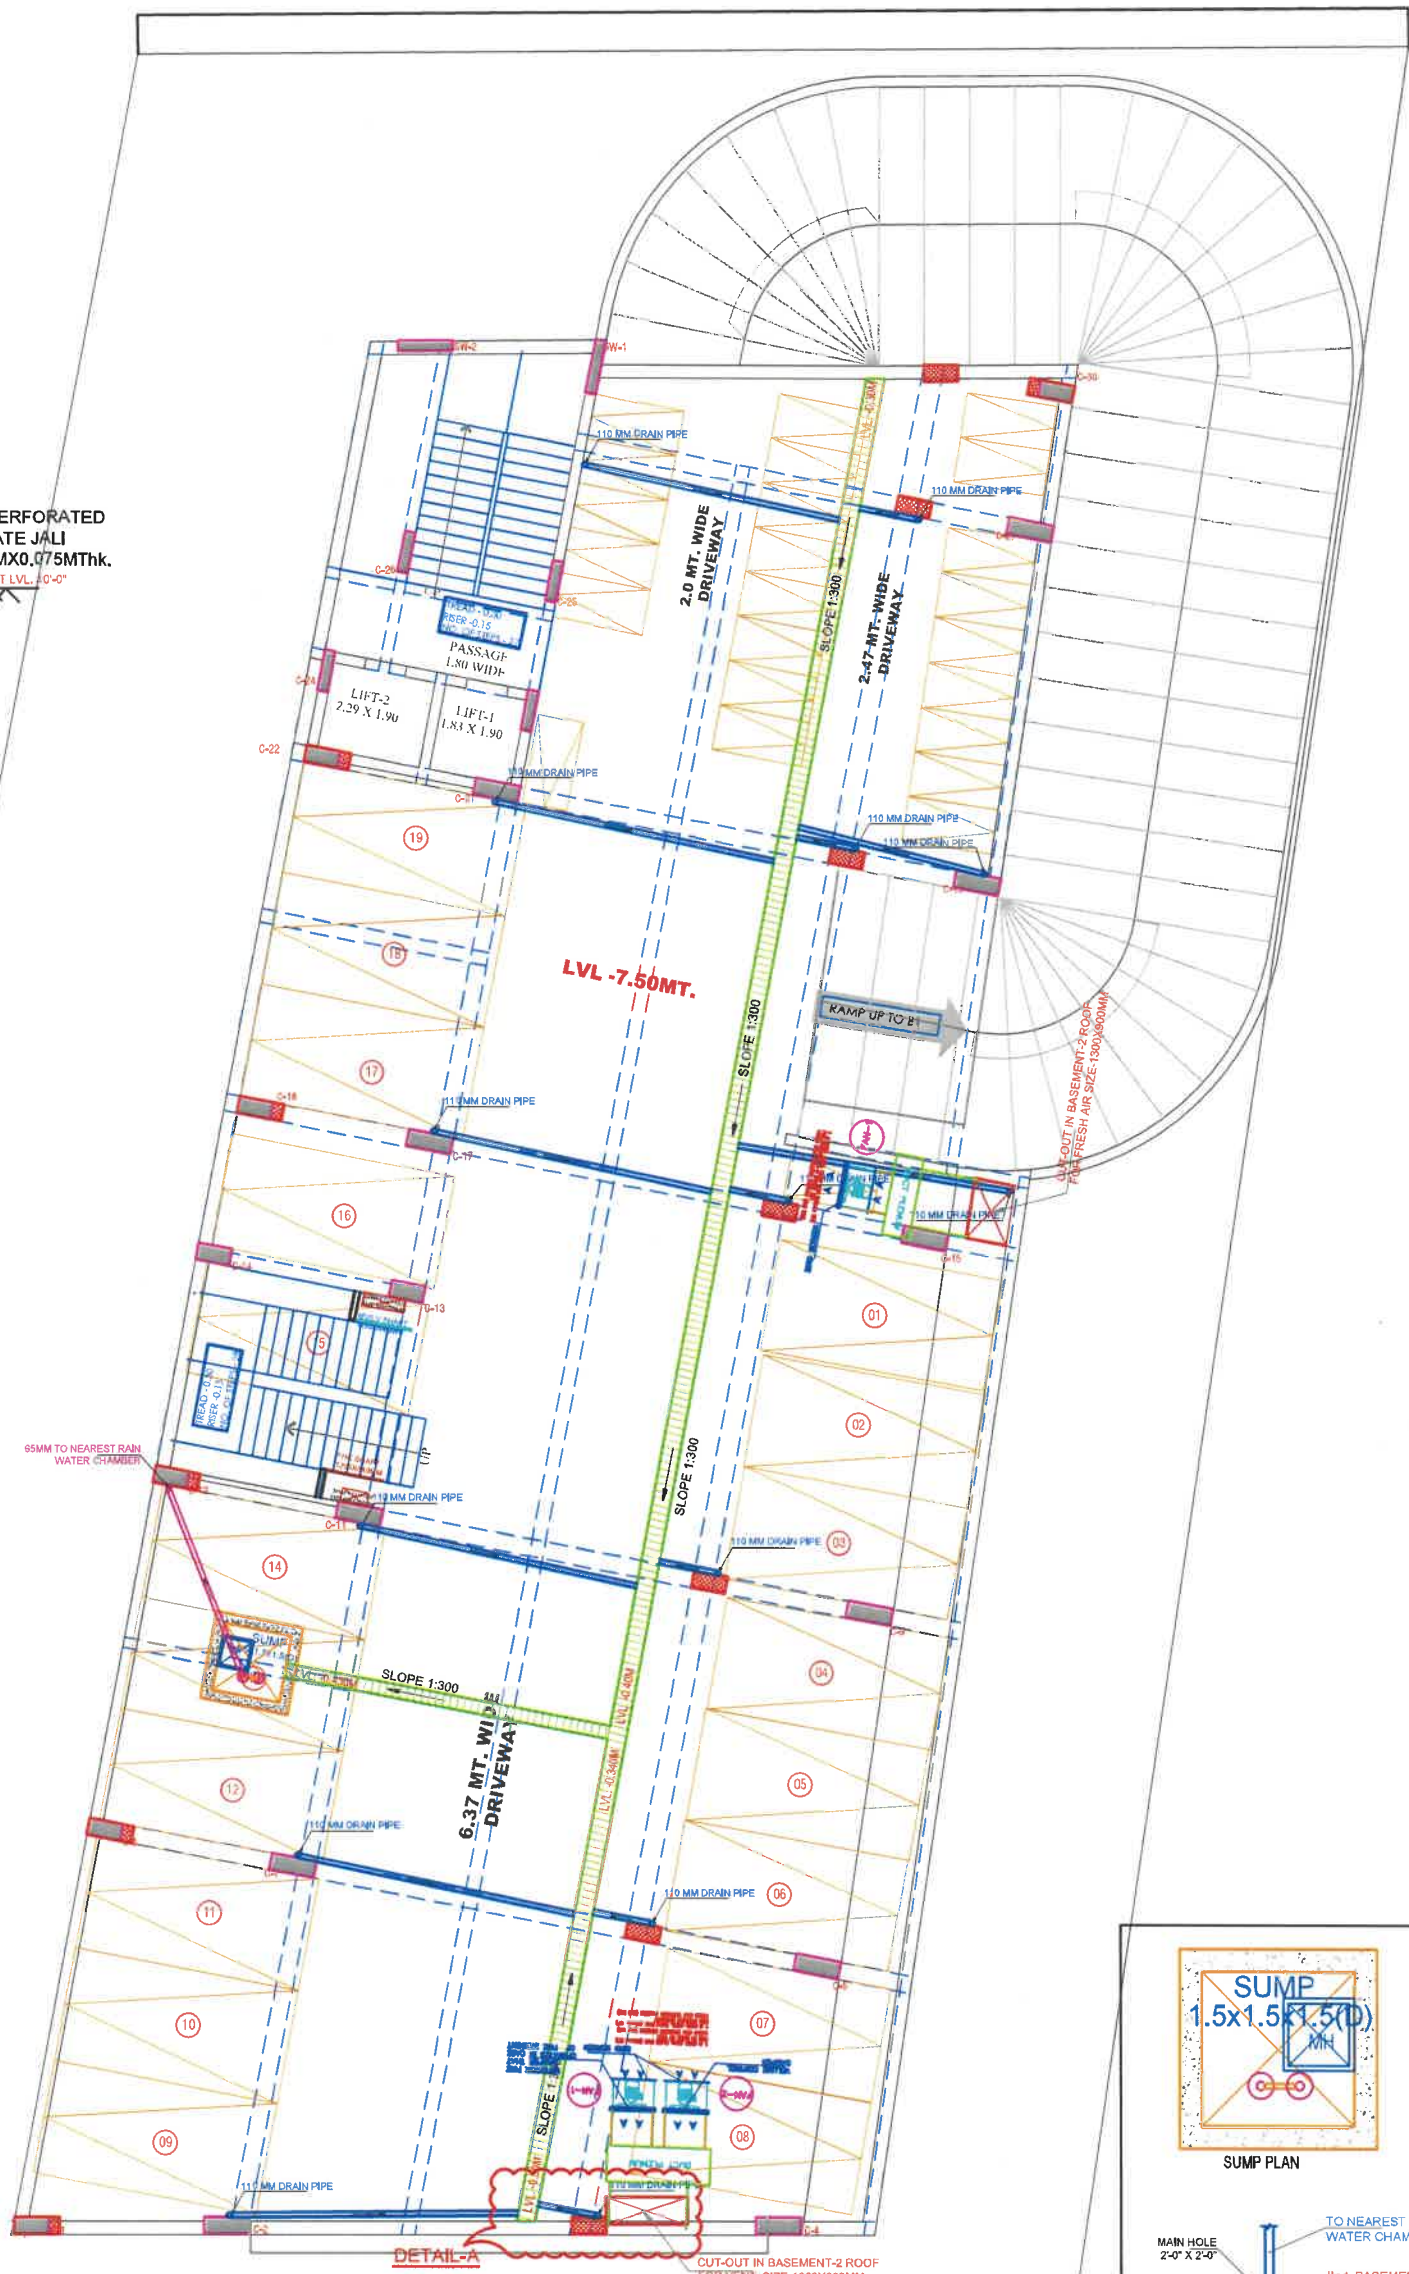

DETAIL-A

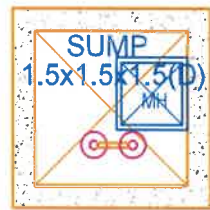

SUMP PLAN

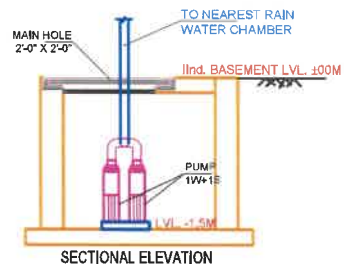

SECTIONAL ELEVATION

BASMENT FLOOR-B2

Ajay
AJAY DADHICH
BTECH ELECT

PROJECT TITLE

DRAWING TITLE

**BASEMENT-2 FLOOR
PLUMBING LAYOUT
FOR RERA SUBMISSION**

CLIENT: SHIV VILLASREAL HOME PRIVATE LTD.
P.N-07,DR RAJENDRA P. NAGAR-E

NORTH



SHEET NO. 03

DATE:- 14/10/2025

DEALT BY:-

CHECKED BY:-

SERVICES CONSULTANTS:
MEHTA ASSOCIATES
PLUMBING-FIRE FIGHTING-
ELECTRICAL-HVAC SYSTEM
22-23 Block-B, Narayan Vihar, Jaipur
E-Mail- mehta.mep@gmail.com
M.- 9001904980, 9799627471

DEVPRATIK


DEVELOPERS PVT.LTD.

E-66 HANUMAN PATH,NEW SANGANER ROAD
BEHIND SANJEEVANI HOSPITAL,SHYAM NAGAR EXT.

JAIPUR (RAJ.)
PH. 4062953

info@ddplindia.com

LEGENDS		
S.NO.	SYMBOL	DESCRIPTION
1.		SDR-11 Cold Water Pipe
2.		SDR-11 Hot Water Pipe
3.		Rain Water Pipe (R.W.P.)
4.		Waste Water Pipe (W.W.P.)
5.		Soil Pipe (S.P.)
6.		Butter Fly Valve(B.F.V.)
7.		Controlling valve
8.		Angle Valve
9.		FD (Floor Drains)
10.		Soil trap
11.		Tap (Water Point)
12.		Waste Water Vertical pipe
13.		Rain Water Vertical pipe
14.		Sewer vertical pipe
15.		Domestic Water vertical pipe
17.		Rain Water Chamber
18.		Sewer Chamber
19.		Gully trap (GT)
20.		

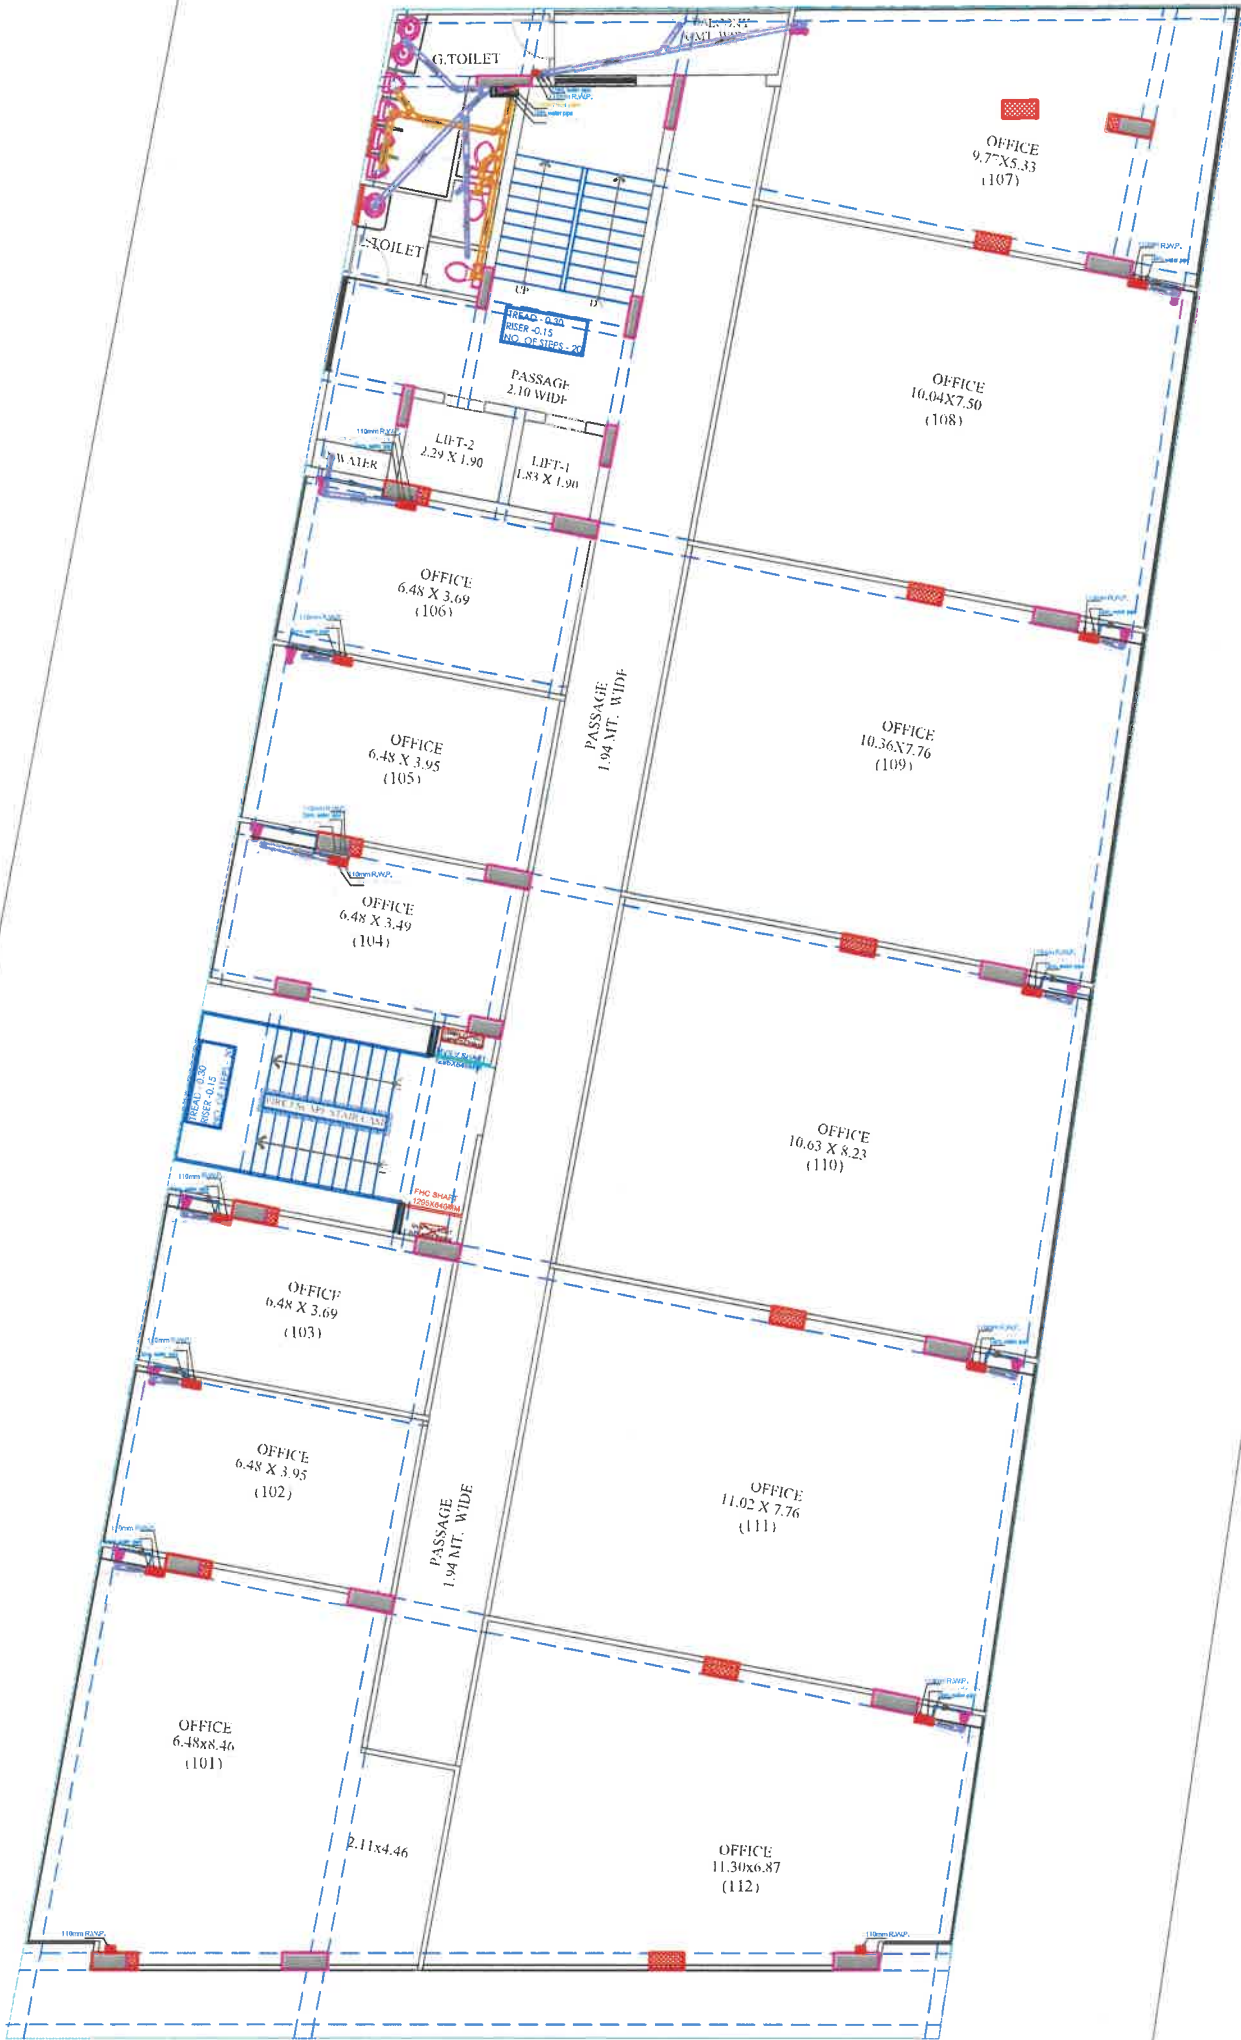

FIRST FLOOR PLAN

ASAY
AJAY DADHICH
BTECH ELECT)

PROJECT TITLE		DRAWING TITLE		SERVICES CONSULTANTS:		DEVPRATIK	
		FIRST FLOOR PLUMBING LAYOUT FOR RERA SUBMISSION		MEHTA ASSOCIATES		DEVELOPERS PVT.LTD.	
CLIENT: SHIV VILLASREAL HOME PRIVATE LTD. P.N-07,DR RAJENDRA P. NAGAR-E		NORTH		PLUMBING-FIRE FIGHTING- ELECTRICAL-HVAC SYSTEM 22-23 Block-B, Narayan Vihar, Jaipur E-Mail- mehta.mep@gmail.com M.- 9001904980, 9799627471		E-66 HANUMAN PATH,NEW SANGANER ROAD BEHIND SANJEEVANI HOSPITAL,SHYAM NAGAR EXT.	
		SHEET NO. 05		DEALT BY:-		JAIPUR (RAJ.)	
		DATE:- 14/10/2025		CHECKED BY:-		PH. 4062953	
						info@ddplindia.com	



LEGENDS		
S.NO.	SYMBOL	DESCRIPTION
1.		SDR-11 Cold Water Pipe
2.		SDR-11 Hot Water Pipe
3.		Rain Water Pipe (R.W.P.)
4.		Waste Water Pipe (W.P.)
5.		Soil Pipe (S.P.)
6.		Butter Fly Valve(B.F.V.)
7.		Gate Valve
8.		Angle Valve
9.		FC (Floor Drains)
10.		W.Trap
11.		Tap (Water Point)
12.		Waste Water Vertical pipe
13.		Rain Water Vertical pipe
14.		Sewer Vertical pipe
15.		Domestic Water vertical pipe
16.		Rain Water Chamber
17.		Sewer Chamber
18.		Gully trap (GT)
19.		
20.		



SECOND TO FIFTH FLOOR PLAN

Ajay
AJAY DADHICH
BTECH ELECT)


PROJECT TITLE	DRAWING TITLE	2ND TO 5TH FLOOR PLUMBING LAYOUT FOR RERA SUBMISSION		SERVICES CONSULTANTS:	DEVPRATIK
CLIENT:	NORTH	SHEET NO.	DEALT BY:-	MEHTA ASSOCIATES	DEVELOPERS PVT.LTD.
SHIV VILLASREAL HOME PRIVATE LTD. P.N-07,DR RAJENDRA P. NAGAR-E		06	DATE:- 14/10/2025	PLUMBING-FIRE FIGHTING- ELECTRICAL-HVAC SYSTEM 22-23 Block-B, Narayan Vihar, Jaipur E-Mail- mehta.mep@gmail.com M.- 9001904980, 9799627471	E-66 HANUMAN PATH,NEW SANGANER ROAD BEHIND SANJEEVANI HOSPITAL,SHYAM NAGAR EXT.
			CHECKED BY:-	JAI PUR (RAJ.) PH. 4062953	info@ddplindia.com

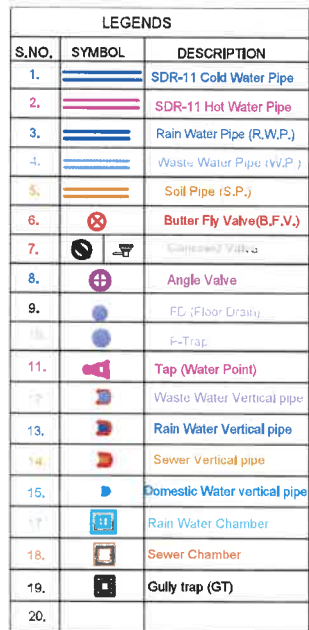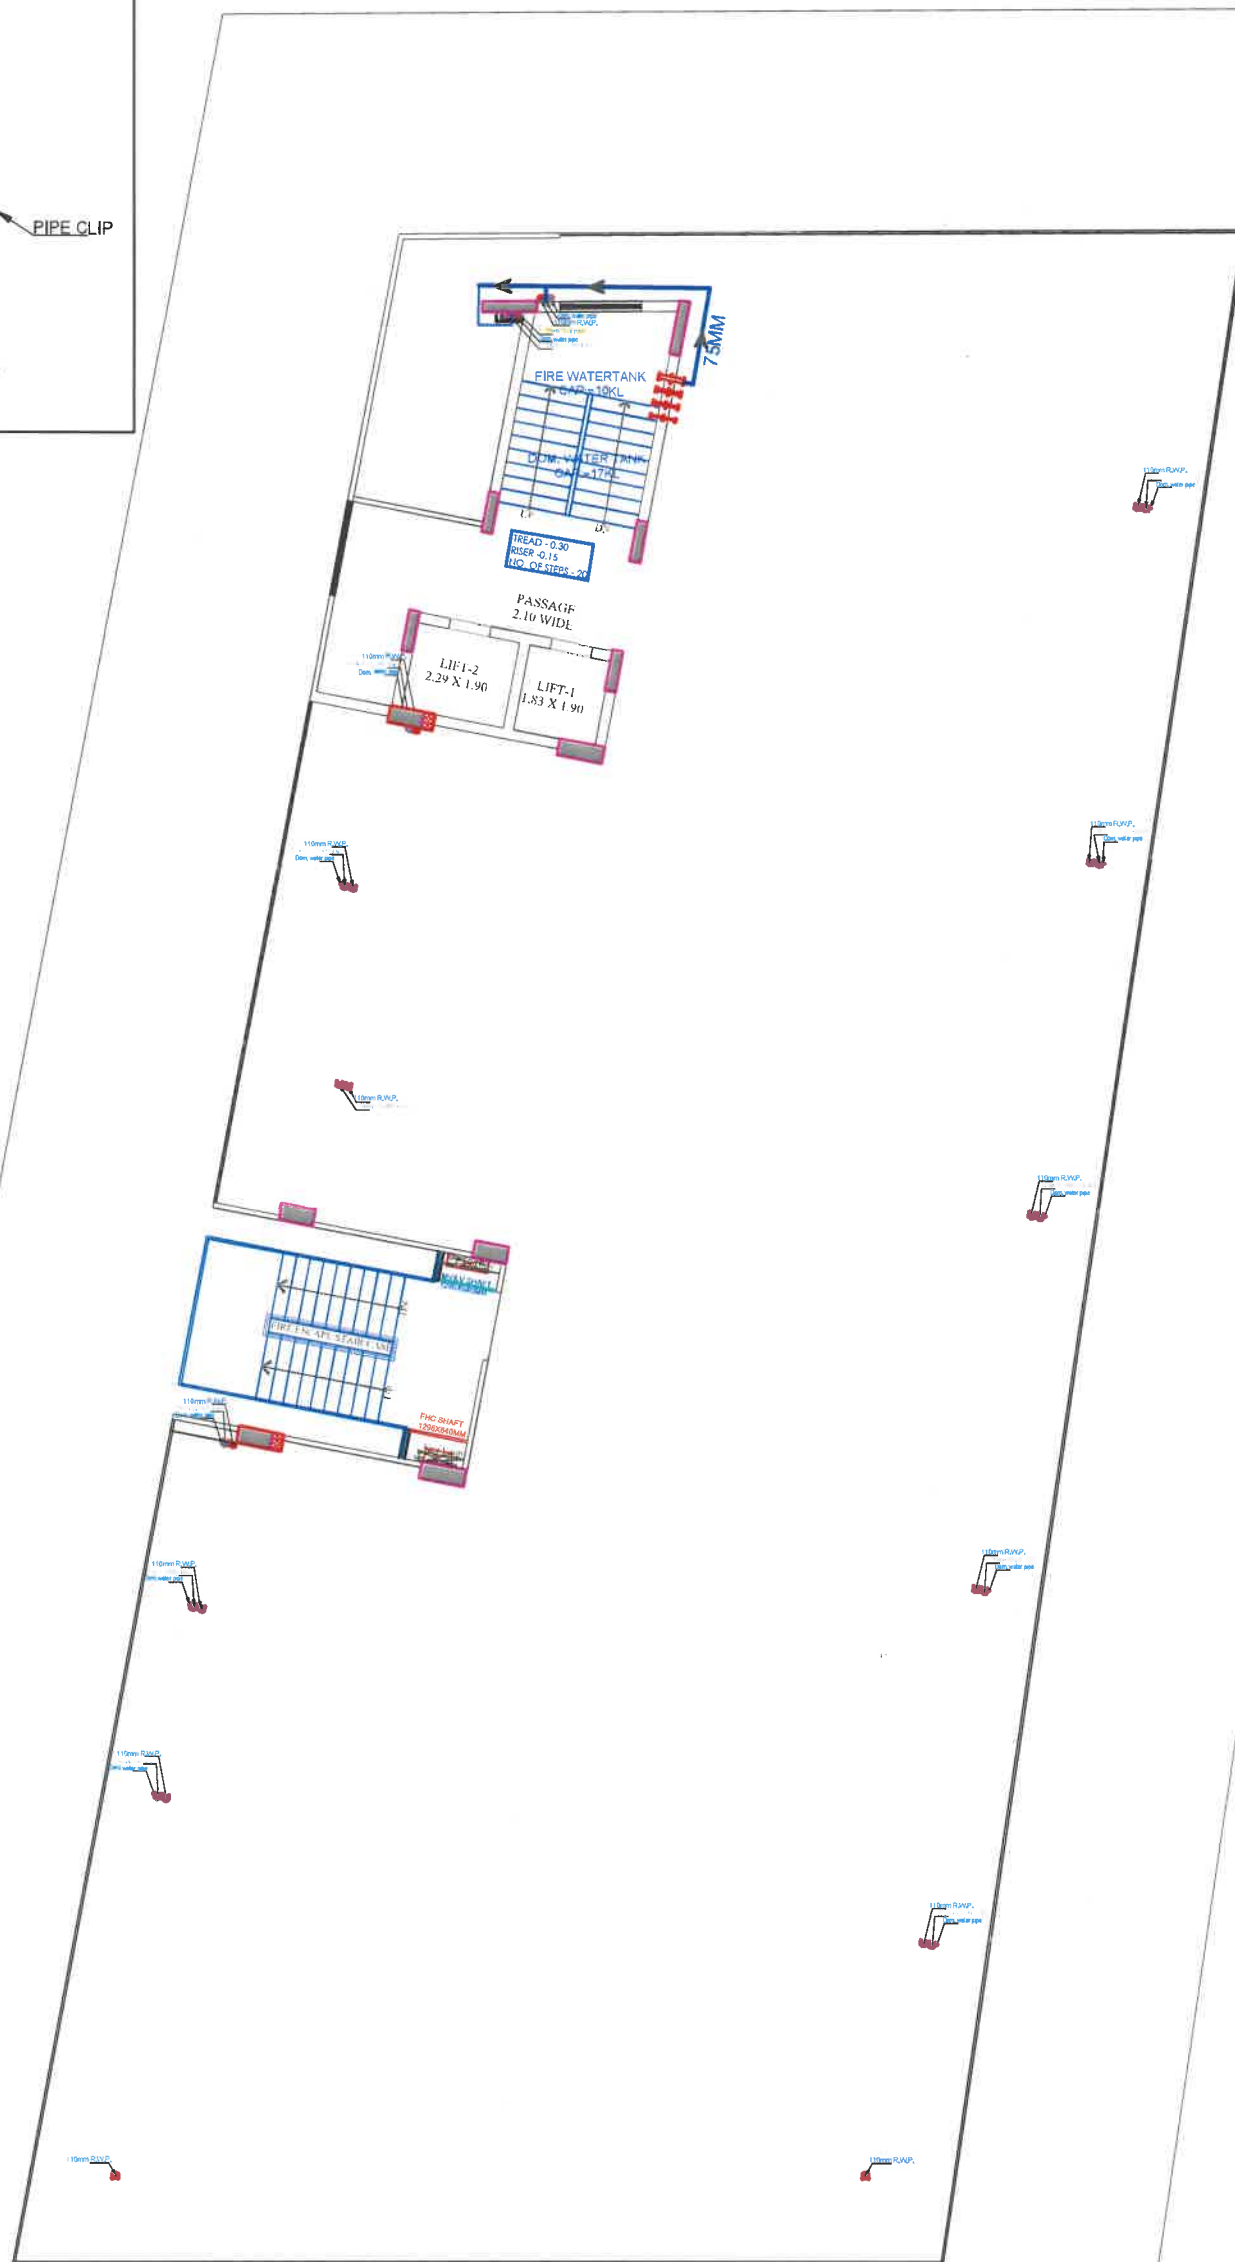

TERRACE FLOOR PLAN

Ajay
AJAY DADHICH
BTECH ELECT)

PROJECT TITLE		DRAWING TITLE		SERVICES CONSULTANTS:		DEVPRATIK	
		<u>TERRACE FLOOR SANITARY & WATER SUPPLY RING DETAIL FOR RERA SUBMISSION</u>		MEHTA ASSOCIATES		<u>DEVELOPERS PVT.LTD.</u>	
CLIENT: SHIV VILLASREAL HOME PRIVATE LTD. P.N-07,DR RAJENDRA P. NAGAR-E		NORTH 	SHEET NO. 07	DEALT BY:-		PLUMBING-FIRE FIGHTING- ELECTRICAL-HVAC SYSTEM 22-23 Block-B, Narayan Vihar, Jaipur E-Mail- mehta.mep@gmail.com M.- 9001904980, 9799627471	
			DATE:- 14/10/2025	CHECKED BY:-		E-66 HANUMAN PATH,NEW SANGANER ROAD BEHIND SANJEEVANI HOSPITAL,SHYAM NAGAR EXT. JAIPUR (RAJ.) PH. 4062953 info@ddplndia.com	

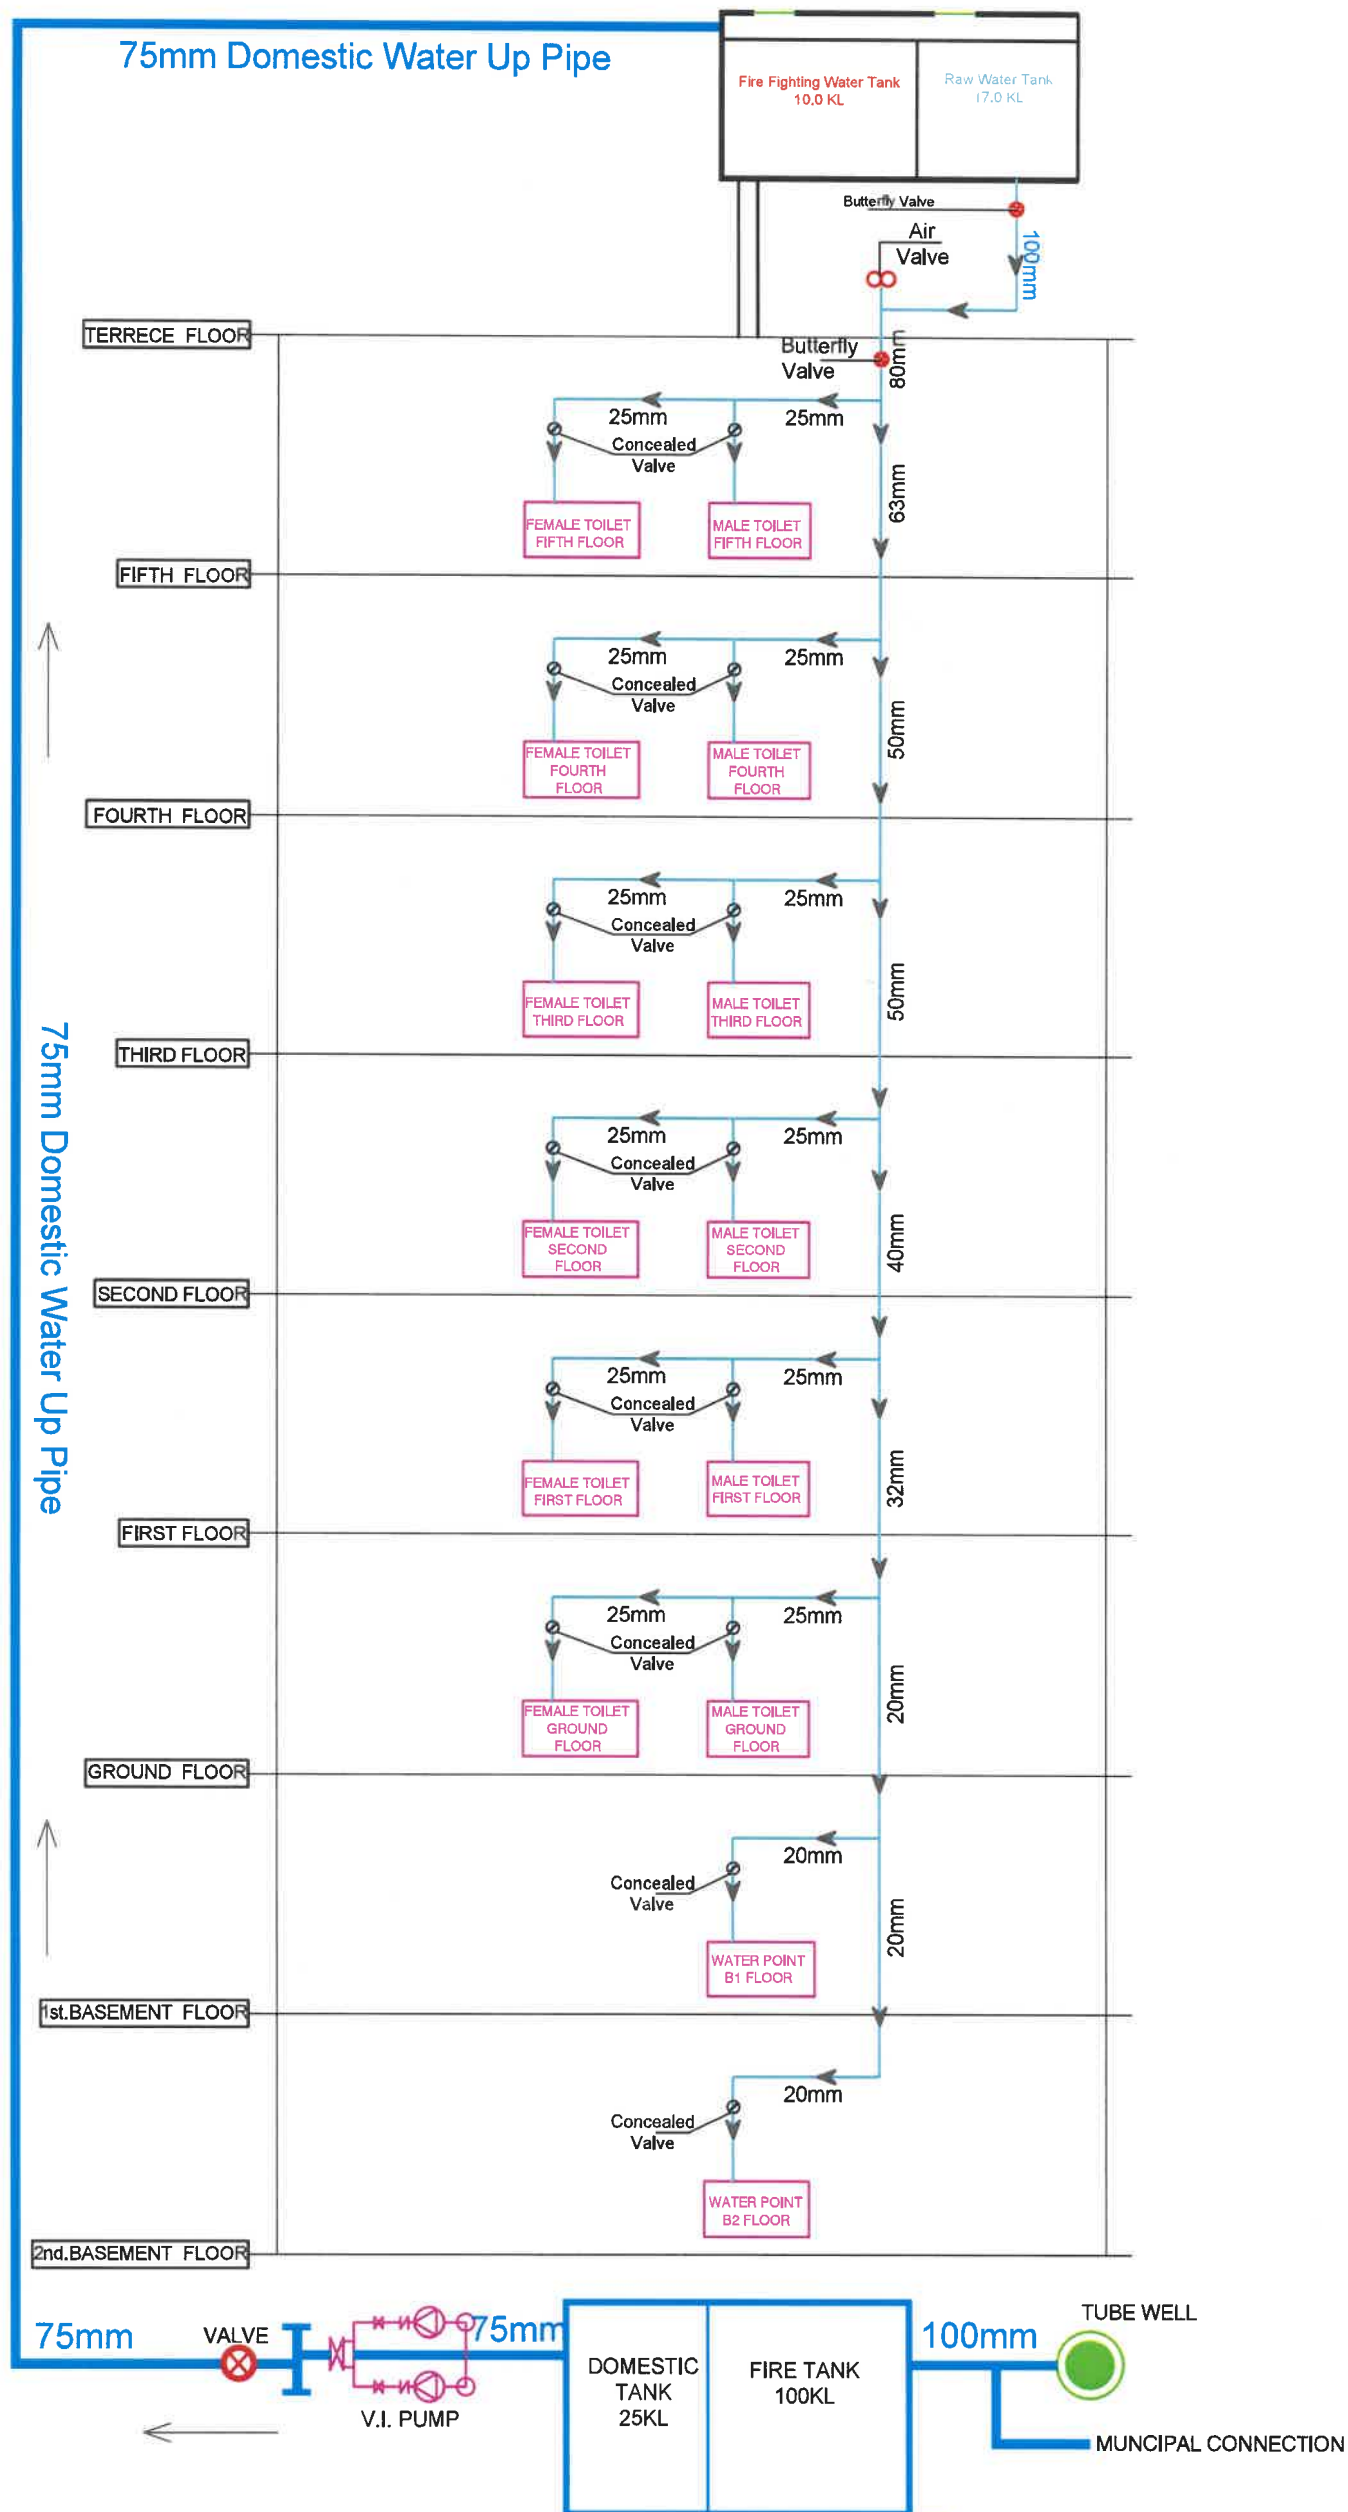

WATER SUPPLY VERTICAL STACK DETAIL

Ajay
AJAY DADHICH
BTECH (ELECT)

PROJECT TITLE	DRAWING TITLE WATER SUPPLY VERTICAL STACK DETAIL FOR RERA SUBMISSION			SERVICES CONSULTANTS: MEHTA ASSOCIATES PLUMBING-FIRE FIGHTING-ELECTRICAL-HVAC SYSTEM 22-23 Block-B, Narayan Vihar, Jaipur E-Mail- mehta.mep@gmail.com M.- 9001904980, 9799627471	DEVPRATIK DEVELOPERS PVT.LTD. E-66 HANUMAN PATH,NEW SANGANER ROAD BEHIND SANJEEVANI HOSPITAL,SHYAM NAGAR EXT., JAIPUR (RAJ.) PH. 4062953 info@ddplindia.com
CLIENT: SHIV VILLASREAL HOME PRIVATE LTD. P.N-07,DR RAJENDRA P. NAGAR-E	NORTH 	SHEET NO. 09	DEALT BY:-		
		DATE:- 14/10/2025	CHECKED BY:-		