

REVISION

GENERAL NOTES :

1. ALL THE DIMENSIONS ON THE DRAWING ARE IN METERS.
2. ONLY WRITTEN DIMENSIONS ARE TO BE FOLLOWED. DRAWING SHOULD NOT BE SCALED IN ANY CIRCUMSTANCES.
3. ALL MEASUREMENTS MUST BE CHECKED AND VERIFIED BY THE CONTRACTOR PRIOR TO EXECUTION OF WORK ON THE SITE.
4. THIS DRAWING IS TO BE READ IN CONJUNCTION WITH ALL RELEVANT STRUCTURAL, ARCHITECTURAL & ELECTRICAL PLANNING DRAWINGS.
5. ANY DISCREPANCIES MUST BE BROUGHT TO THE NOTICE OF THE ENGINEER IMMEDIATELY & PRIOR TO EXECUTION OF WORK ON THE SITE.
6. CO-ORDINATION WITH SERVICES SUCH AS HVAC, PLUMBING & ELECTRICAL, ETC. IS THE RESPONSIBILITY OF THE CONTRACTOR.
7. FOR DETAILS, REFER RELEVANT LARGE SCALE DRAWINGS AS INDICATED.

LIGHTING LEGEND

SR NO	SYMBOL	DESCRIPTION	HIGHT FROM FFL
1		CEILING FAN	Ceiling
2		LED CEILING LIGHT POINT	Ceiling
3		CHANDELIER LIGHT	Ceiling
4		LED WALL BRACKET LIGHT POINT AT WALL	+2'-4"
5		SWITCH BOARD GENERAL	+0'-0"
6		DISTRIBUTION BOARD	+0'-0"
8		MIRROR LIGHT	+0'-0"
9		EXHAUST FAN	Vent. HL
10		CEILING ROSE	+0'-0"
11		BELL PUSHER	+0'-0"
12		BELL BUZZER	+2'-0"
13		25A AC SOCKET	+0'-0"
14		AC UNIT	+0'-0"
15		CO AXIAL POINT	+0'-0"
16		2NO. 6A SOCKET WITH SWITCH FOR TV	+2'-0"
17		TELEPHONE	+0'-0"
18		6A SOCKET WITH SWITCH	+2'-4"/+0'-0"
19		18A SOCKET WITH SWITCH FOR FRIDGE	+0'-0"
20		16A SOCKET WITH SWITCH FOR MICROWAVE	+0'-0"
21		16A SOCKET WITH SWITCH FOR MIXER	+0'-0"
22		16A SOCKET FOR GEYSER (KITCHEN)	+0'-0"
23		16A SOCKET FOR GEYSER (TOILET)	+0'-0"
24		6A SOCKET WITH SWITCH FOR NO	+0'-0"
25		SOCKET FOR CHIMNEY POINT	+0'-0"
26		CCTV	+0'-0"
27		2X1.5+1X1.5 POINT WIRE	Ceiling
28		2X2.5+1X1.5 LIGHT CIRCUIT WIRE	Ceiling
29		2X4+1X2.5 POWER CIRCUIT WIRE	Ceiling

ARCHITECT :-

PROJECT :-

PROPOSED LUXURY APARTMENTS
AT PLOT NO. D-243, DEVI MARG, BANI PARK, JAIPUR.

DRAWING TITLE:-


STILT FLOOR ELE. POINTS &
WIRING LAYOUT

SUBMITTED FOR :-

PRELIMINARY	☐	APPROVAL	☒
PROPOSAL	☐	GFC	☐
DATE :-	13-06-2024	NORTH	
DRAWN :-	KHUSHI MO.	SCALE :-	N.T.S.
APPROVED :-	NARESH		
DRAWING NO. :-			

CONSULTANT

AMP INFRA SERVICES
VILLA NO 16, SHUBHASIS CEETA
JAISINGHPURA, BHANKROTA &
CHIMANPURA, JAIPUR 302026
EMAIL ID- ampinfrajpr@gmail.com
CONTACT NO. :- 9462866389

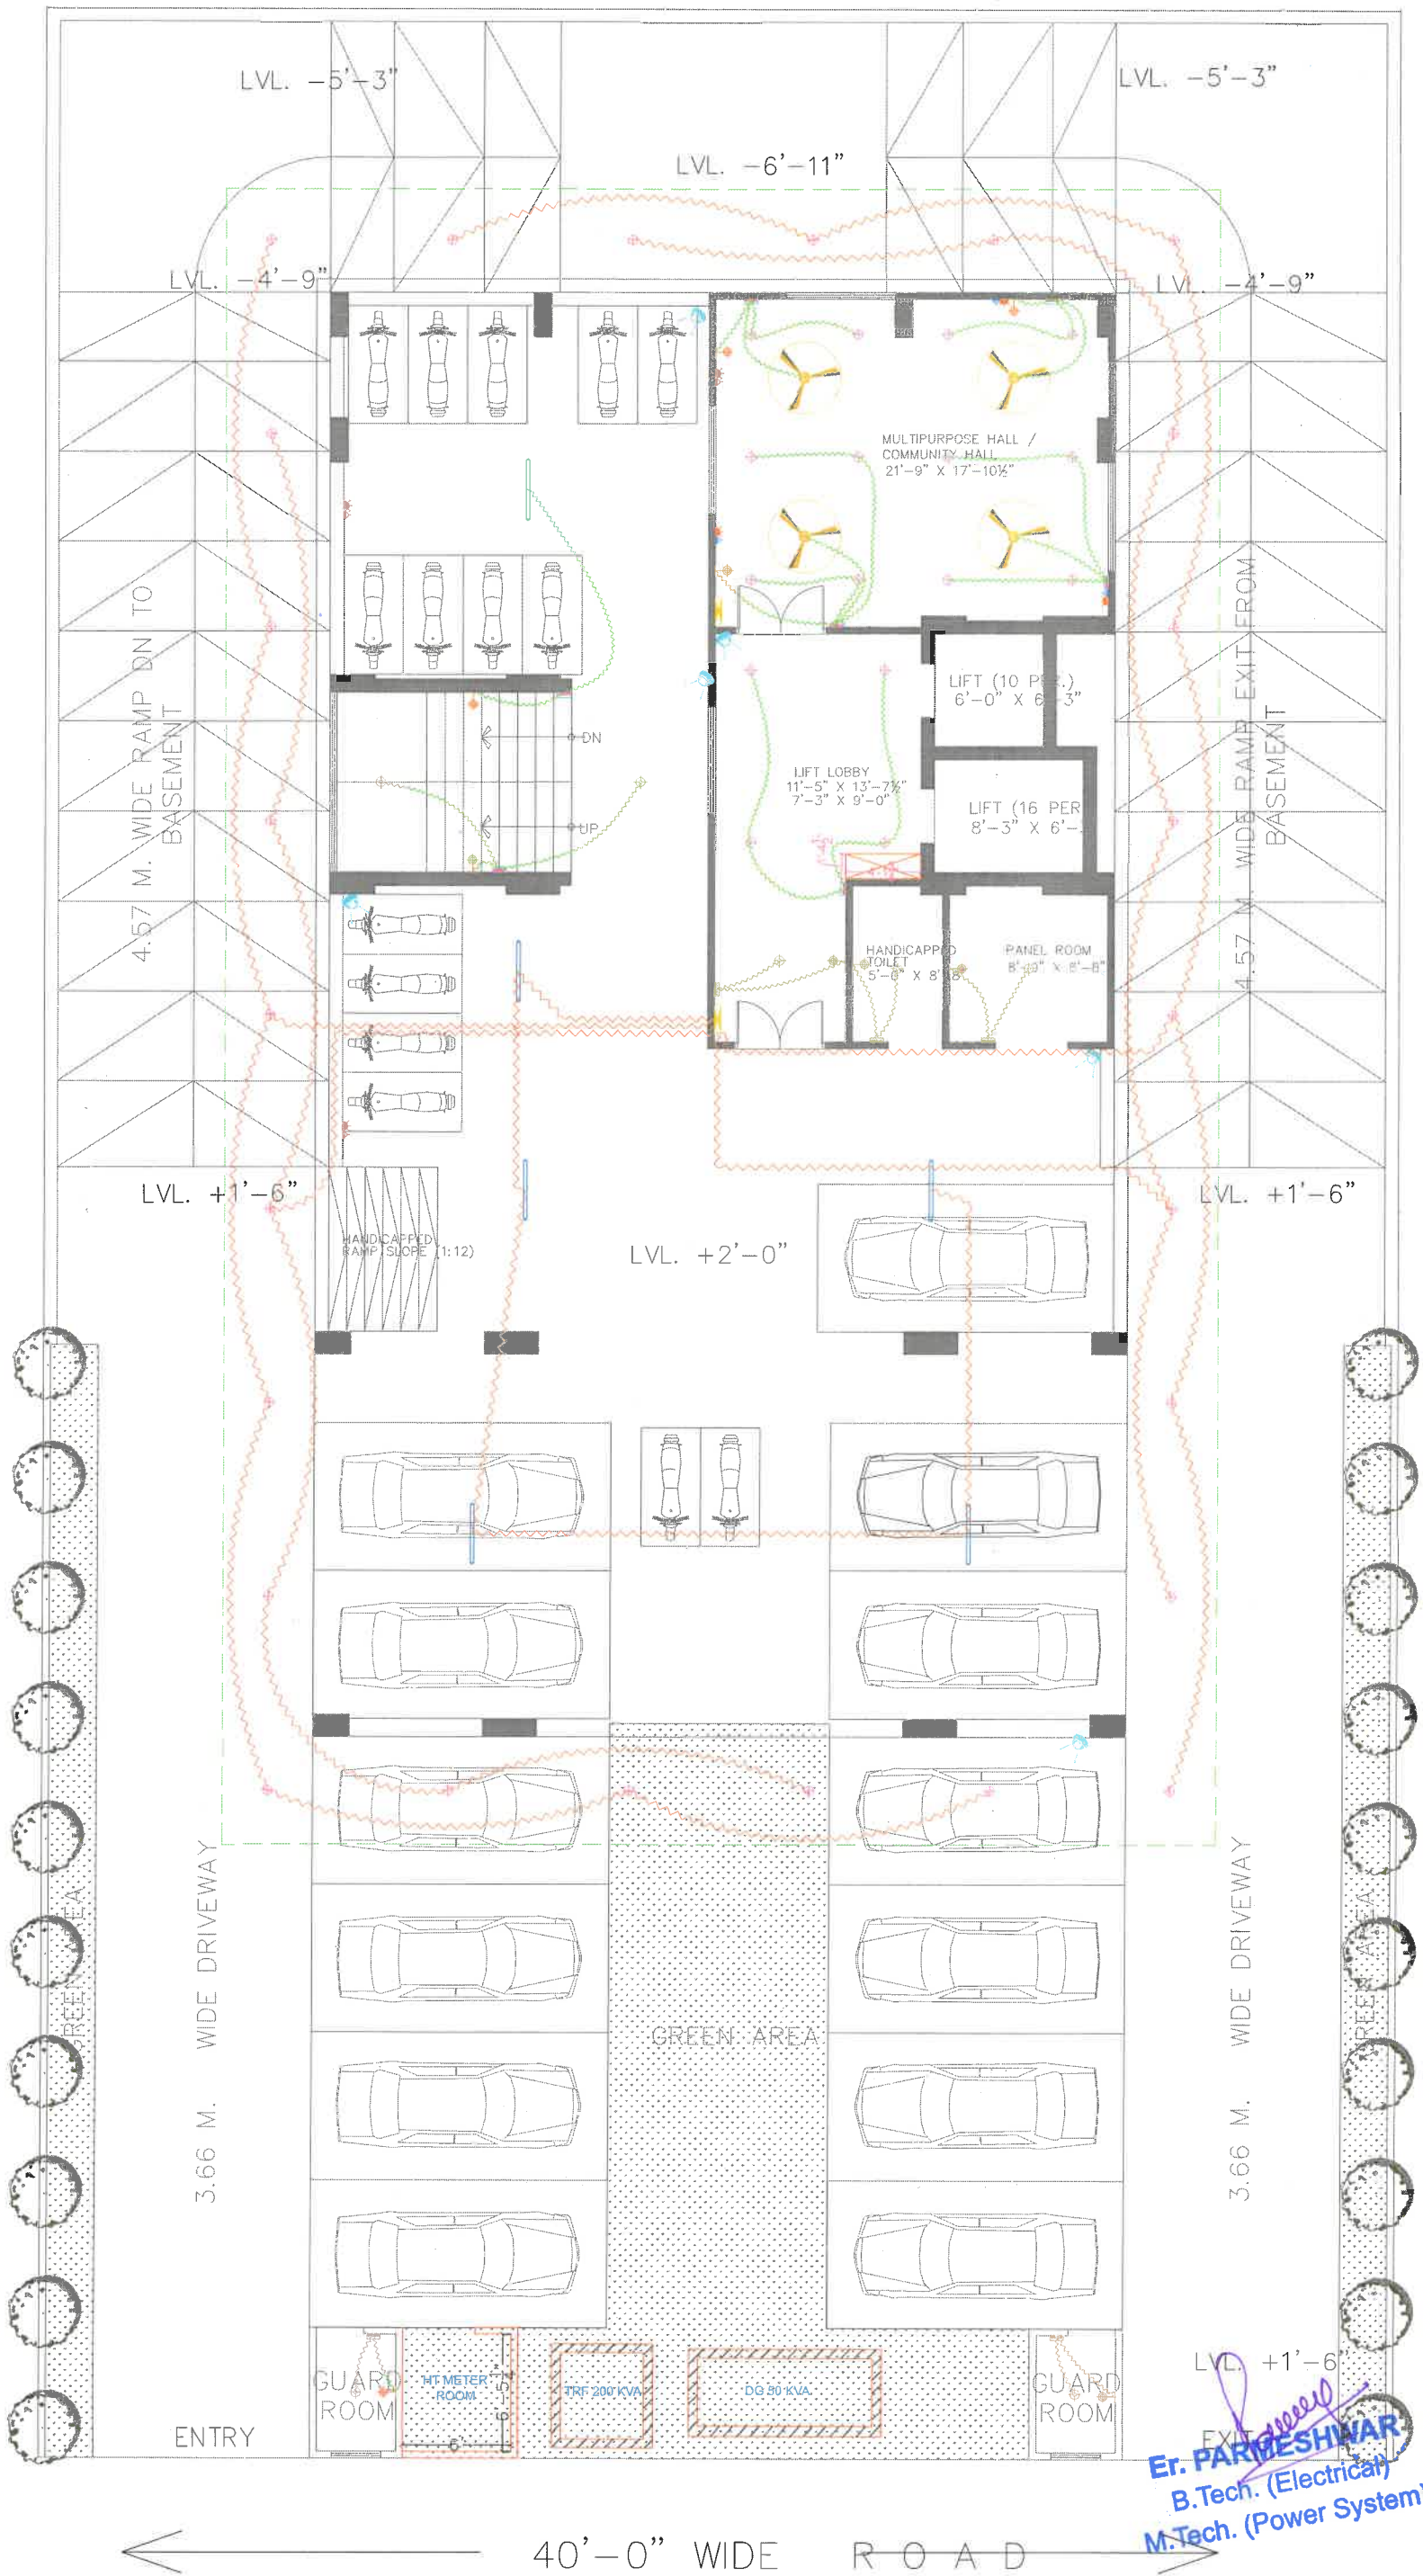

REVISION

GENERAL NOTES :

1. ALL THE DIMENSIONS ON THE DRAWING ARE IN WRITTEN.
2. ONLY WRITTEN DIMENSIONS ARE TO BE FOLLOWED, DRAWING SHOULD NOT BE SCALED IN ANY CIRCUMSTANCES.
3. ALL MEASUREMENTS MUST BE CHECKED AND VERIFIED BY THE CONTRACTORS PRIOR TO EXECUTION OF WORK AT THE SITE.
4. THIS DRAWING IS TO BE READ IN CONJUNCTION WITH ALL RELEVANT STRUCTURAL, ARCHITECTURAL & FACILITY PLANNING DRAWINGS.
5. ANY DISCREPANCIES MUST BE BROUGHT TO THE NOTICE OF THE ENGINEER IMMEDIATELY & PRIOR TO EXECUTION AT SITE.
6. CO-ORDINATION WITH SERVICES SUCH AS HVAC, PLUMBING & ELECTRICAL, ETC. IS THE RESPONSIBILITY OF THE CONTRACTORS.
7. FOR DETAILS, REFER RELEVANT LARGE SCALE DETAIL DRGS. AS INDICATED.

LIGHTING LEGEND

SR.NO	SYMBOL	DESCRIPTION	HIGHT FROM FFL
1		CEILING FAN	Ceiling
2		LED CEILING LIGHT POINT	Ceiling
3		CHANDELIER LIGHT	Ceiling
4		LED WALL BRACKET LIGHT POINT AT WALL	+7'-4"
5		SWITCH BOARD GENERAL	+4'-0"
6		DISTRIBUTION BOARD	+5'-1"
8		MIRROR LIGHT	+6'-5"
9		EXHAUST FAN	Vent. Ht.
10		CEILING ROSE	+7'-5"
11		BELL PUSHER	+4'-0"
12		BELL BUZZER	+7'-5"
13		25A AC SOCKET	+7'-0"
14		AC UNIT	+8'-0"
15		CO AXIAL POINT	+2'-0"
16		2ND. 6A SOCKET WITH SWITCH FOR TV	+2'-0"
17		TELEPHONE	+2'-0"
18		6A SOCKET WITH SWITCH	+2'-0" to +4'-0"
19		16A SOCKET WITH SWITCH FOR FRIDGE	+4'-0"
20		16A SOCKET WITH SWITCH FOR MICROWAVE	+4'-0"
21		16A SOCKET WITH SWITCH FOR MIXER	+4'-0"
22		16A SOCKET FOR GEYSER (KITCHEN)	+5'-0"
22		16A SOCKET FOR GEYSER (TOILET)	+7'-0"
23		6A SOCKET WITH SWITCH FOR RO	+4'-0"
24		SOCKET FOR CHIMNEY POINT	+7'-0"
25		CCTV	+8'-0"
26		2X1.5-1X1 POINT WIRE	Ceiling
27		2X2.5-1X1.5 LIGHT CIRCUIT WIRE	Ceiling
28		2X4-1X2.5 POWER CIRCUIT WIRE	Ceiling

ARCHITECT :-

PROJECT :-

PROPOSED LUXURY APARTMENTS
AT PLOT NO. D- 243, DEVI MARG, BANI PARK, JAIPUR.

DRAWING TITLE:-

6TH FLOOR 1ST TO 5TH
ELE.POINTS & WIRING
LAYOUT

SUBMITTED FOR :-

PRELIMINARY	☐	APPROVAL	☒
PROPOSAL	☐	GFC	☐
DATE :-	13-06-2024	NORTH	
DRAWN :-	KHUSHI MO.	APPROVED :-	NARESH
DRAWING NO.:-		SCALE :-	N.T.S.

CONSULTANT

AMP INFRA SERVICES
VILLA NO 16. SHUBHASIS GEETA
JAISINGHPURA, BHANKROTA &
CHIMANPURA. JAIPUR 302026
EMAIL ID- ampinfrajpr@gmail.com
CONTACT NO. :- 9462866389

Parmeshwar
Er. PARMESHWAR
B.Tech. (Electrical)
M.Tech. (Power System)

REVISION

GENERAL NOTES :

1. ALL THE DIMENSIONS ON THE DRAWING ARE IN WRITTEN.
2. ONLY WRITTEN DIMENSIONS ARE TO BE FOLLOWED, DRAWING SHOULD NOT BE SCALED IN ANY CIRCUMSTANCES.
3. ALL MEASUREMENTS MUST BE CHECKED AND VERIFIED BY THE CONTRACTORS PRIOR TO EXECUTION OF WORK AT THE SITE.
4. THIS DRAWING IS TO BE READ IN CONJUNCTION WITH ALL RELEVANT STRUCTURAL, ARCHITECTURAL & FACILITY PLANNING DRAWINGS.
5. ANY DISCREPANCIES MUST BE BROUGHT TO THE NOTICE OF THE ENGINEER IMMEDIATELY & PRIOR TO EXECUTION AT SITE.
6. CO-ORDINATION WITH SERVICES SUCH AS HVAC, PLUMBING & ELECTRICAL, ETC. IS THE RESPONSIBILITY OF THE CONTRACTORS.
7. FOR DETAILS, REFER RELEVANT LARGE SCALE DETAIL DROS AS INDICATED.

LIGHTING LEGEND

SR.NO	SYMBOL	DESCRIPTION	HIGHT FROM FFL
1		CEILING FAN	Ceiling
2		LED CEILING LIGHT POINT	Ceiling
3		CHANDELIER LIGHT	Ceiling
4		LED WALL BRACKET LIGHT POINT AT WALL	+7'-4"
5		SWITCH BOARD GENERAL	+6'-0"
6		DISTRIBUTION BOARD	+5'-1"
8		MIRROR LIGHT	+6'-8"
9		EXHAUST FAN	Vert. HL
10		CEILING ROSE	+7'-0"
11		BELL PUSHER	+6'-0"
12		BELL BUZZER	+7'-0"
13		25A AC SOCKET	+7'-0"
14		AC UNIT	+8'-0"
15		CO AXIAL POINT	+2'-0"
16		2NO. 6A SOCKET WITH SWITCH FOR TV	+2'-0"
17		TELEPHONE	+2'-0"
18		6A SOCKET WITH SWITCH	+2'-0"/+4'-0"
19		16A SOCKET WITH SWITCH FOR FRIDGE	+4'-0"
20		16A SOCKET WITH SWITCH FOR MICROWAVE	+4'-0"
21		16A SOCKET WITH SWITCH FOR MIXER	+4'-0"
22		16A SOCKET FOR GEYSER (KITCHEN)	+5'-8"
23		16A SOCKET FOR GEYSER (TOILET, ETC.)	+7'-8"
24		6A SOCKET WITH SWITCH FOR RO	+4'-0"
25		SOCKET FOR CHIMNEY POINT	+7'-8"
26		CCTV	+8'-0"
27		2X1.5+1X1.5 POINT WIRE	Ceiling
28		2X2.5+1X1.5 LIGHT CIRCUIT WIRE	Ceiling
29		2X4+1X2.5 POWER CIRCUIT WIRE	Ceiling

ARCHITECT :-

PROJECT :-

PROPOSED LUXURY APARTMENTS
AT PLOT NO. D-243, DEVI MARG, BANI PARK, JAIPUR.

DRAWING TITLE:-

TYPICAL FLOOR 1ST TO 5TH
ELE.POINTS & WIRING
LAYOUT

SUBMITTED FOR :-

PRELIMINARY	☐	APPROVAL	☒
PROPOSAL	☐	GFC	☐
DATE :-	13-06-2024	NORTH :-	
DRAWN :-	KHUSHI MO.		
APPROVED :-	NARESH		
DRAWING NO.:-		SCALE :-	N.T.S.

CONSULTANT

AMP INFRA SERVICES
VILLA NO 16. SHUBHASIS GEETA
JAISINGHPURA, BHANKROTA &
CHIMANPURA, JAIPUR 302026
EMAIL ID- ampinfrajpr@gmail.com
CONTACT NO. :- 9462866389

Er. PARMESHWAR
B.Tech. (Electrical)
M.Tech. (Power System)

REVISION

GENERAL NOTES :

1. ALL THE DIMENSIONS ON THE DRAWING ARE IN WRITTEN.
2. ONLY WRITTEN DIMENSIONS ARE TO BE FOLLOWED, DRAWING SHOULD NOT BE SCALED IN ANY CIRCUMSTANCES.
3. ALL MEASUREMENTS MUST BE CHECKED AND VERIFIED BY THE CONTRACTORS PRIOR TO EXECUTION OF WORK AT THE SITE.
4. THIS DRAWING IS TO BE READ IN CONJUNCTION WITH ALL RELEVANT STRUCTURAL, ARCHITECTURAL & FACILITY PLANNING DRAWINGS.
5. ANY DISCREPANCIES MUST BE BROUGHT TO THE NOTICE OF THE ENGINEER IMMEDIATELY & PRIOR TO EXECUTION AT SITE.
6. CO-ORDINATION WITH SERVICES SUCH AS HVAC, PLUMBING & ELECTRICAL, ETC. IS THE RESPONSIBILITY OF THE CONTRACTORS.
7. FOR DETAILS, REFER RELEVANT LARGE SCALE DETAIL DRGS AS INDICATED.

LIGHTING LEGEND

SR.NO	SYMBOL	DESCRIPTION	HIGHT FROM FFL
1		CEILING FAN	Ceiling
2		LED CEILING LIGHT POINT	Ceiling
3		CHANDELLER LIGHT	Ceiling
4		LED WALL BRACKET LIGHT POINT AT WALL	+7'-4"
5		SWITCH BOARD GENERAL	+4'-0"
6		DISTRIBUTION BOARD	+5'-1"
8		MIRROR LIGHT	+6'-5"
9		EXHAUST FAN	Vent. Ht.
10		CEILING ROSE	+7'-6"
11		BELL PUSHER	+4'-0"
12		BELL BUZZER	+7'-6"
13		25A AC SOCKET	+7'-0"
14		AC UNIT	+8'-0"
15		CO AXIAL POINT	+2'-0"
16		2NO. 6A SOCKET WITH SWITCH FOR TV	+2'-0"
17		TELEPHONE	+2'-0"
18		6A SOCKET WITH SWITCH	+2'-0"/>+4'-0"
19		16A SOCKET WITH SWITCH FOR FRIDGE	+4'-0"
20		16A SOCKET WITH SWITCH FOR MICROWAVE	+4'-0"
21		16A SOCKET WITH SWITCH FOR MIXER	+4'-0"
22		16A SOCKET FOR GEYSER (KITCHEN)	+5'-0"
23		16A SOCKET FOR GEYSER (TOILET)	+7'-0"
24		6A SOCKET WITH SWITCH FOR RO	+4'-0"
25		SOCKET FOR CHIMNEY POINT	+7'-0"
26		CCTV	+6'-0"
27		2X1.5-1X1 POINT WIRE	Ceiling
28		2X2.5-1X1.5 LIGHT CIRCUIT WIRE	Ceiling
29		2X4-1X2.5 POWER CIRCUIT WIRE	Ceiling

ARCHITECT :-

PROJECT :-

PROPOSED LUXURY APARTMENTS
AT PLOT NO. D- 243, DEVI MARG, BANI PARK, JAIPUR.


DRAWING TITLE:-

BASEMENT FLOOR ELE.POINTS
& WIRING LAYOUT

SUBMITTED FOR :-			
PRELIMINARY	☐	APPROVAL	☒
PROPOSAL	☐	GFC	☐
DATE :-	13-06-2024		<div>NORTH :- </div>
DRAWN :-	KHUSHI MO.		
APPROVED :-	NARESH		
DRAWING NO.:-			
			SCALE :- N.T.S.

CONSULTANT

AMP INFRA SERVICES
VILLA NO 16. SHUBHASIS GEETA
JAISINGHPURA, BHANKROTA &
CHIMANPURA,JAIPUR 302026
EMAIL ID- ampinfrajpr@gmail.com
CONTACT NO. :- 9462866389

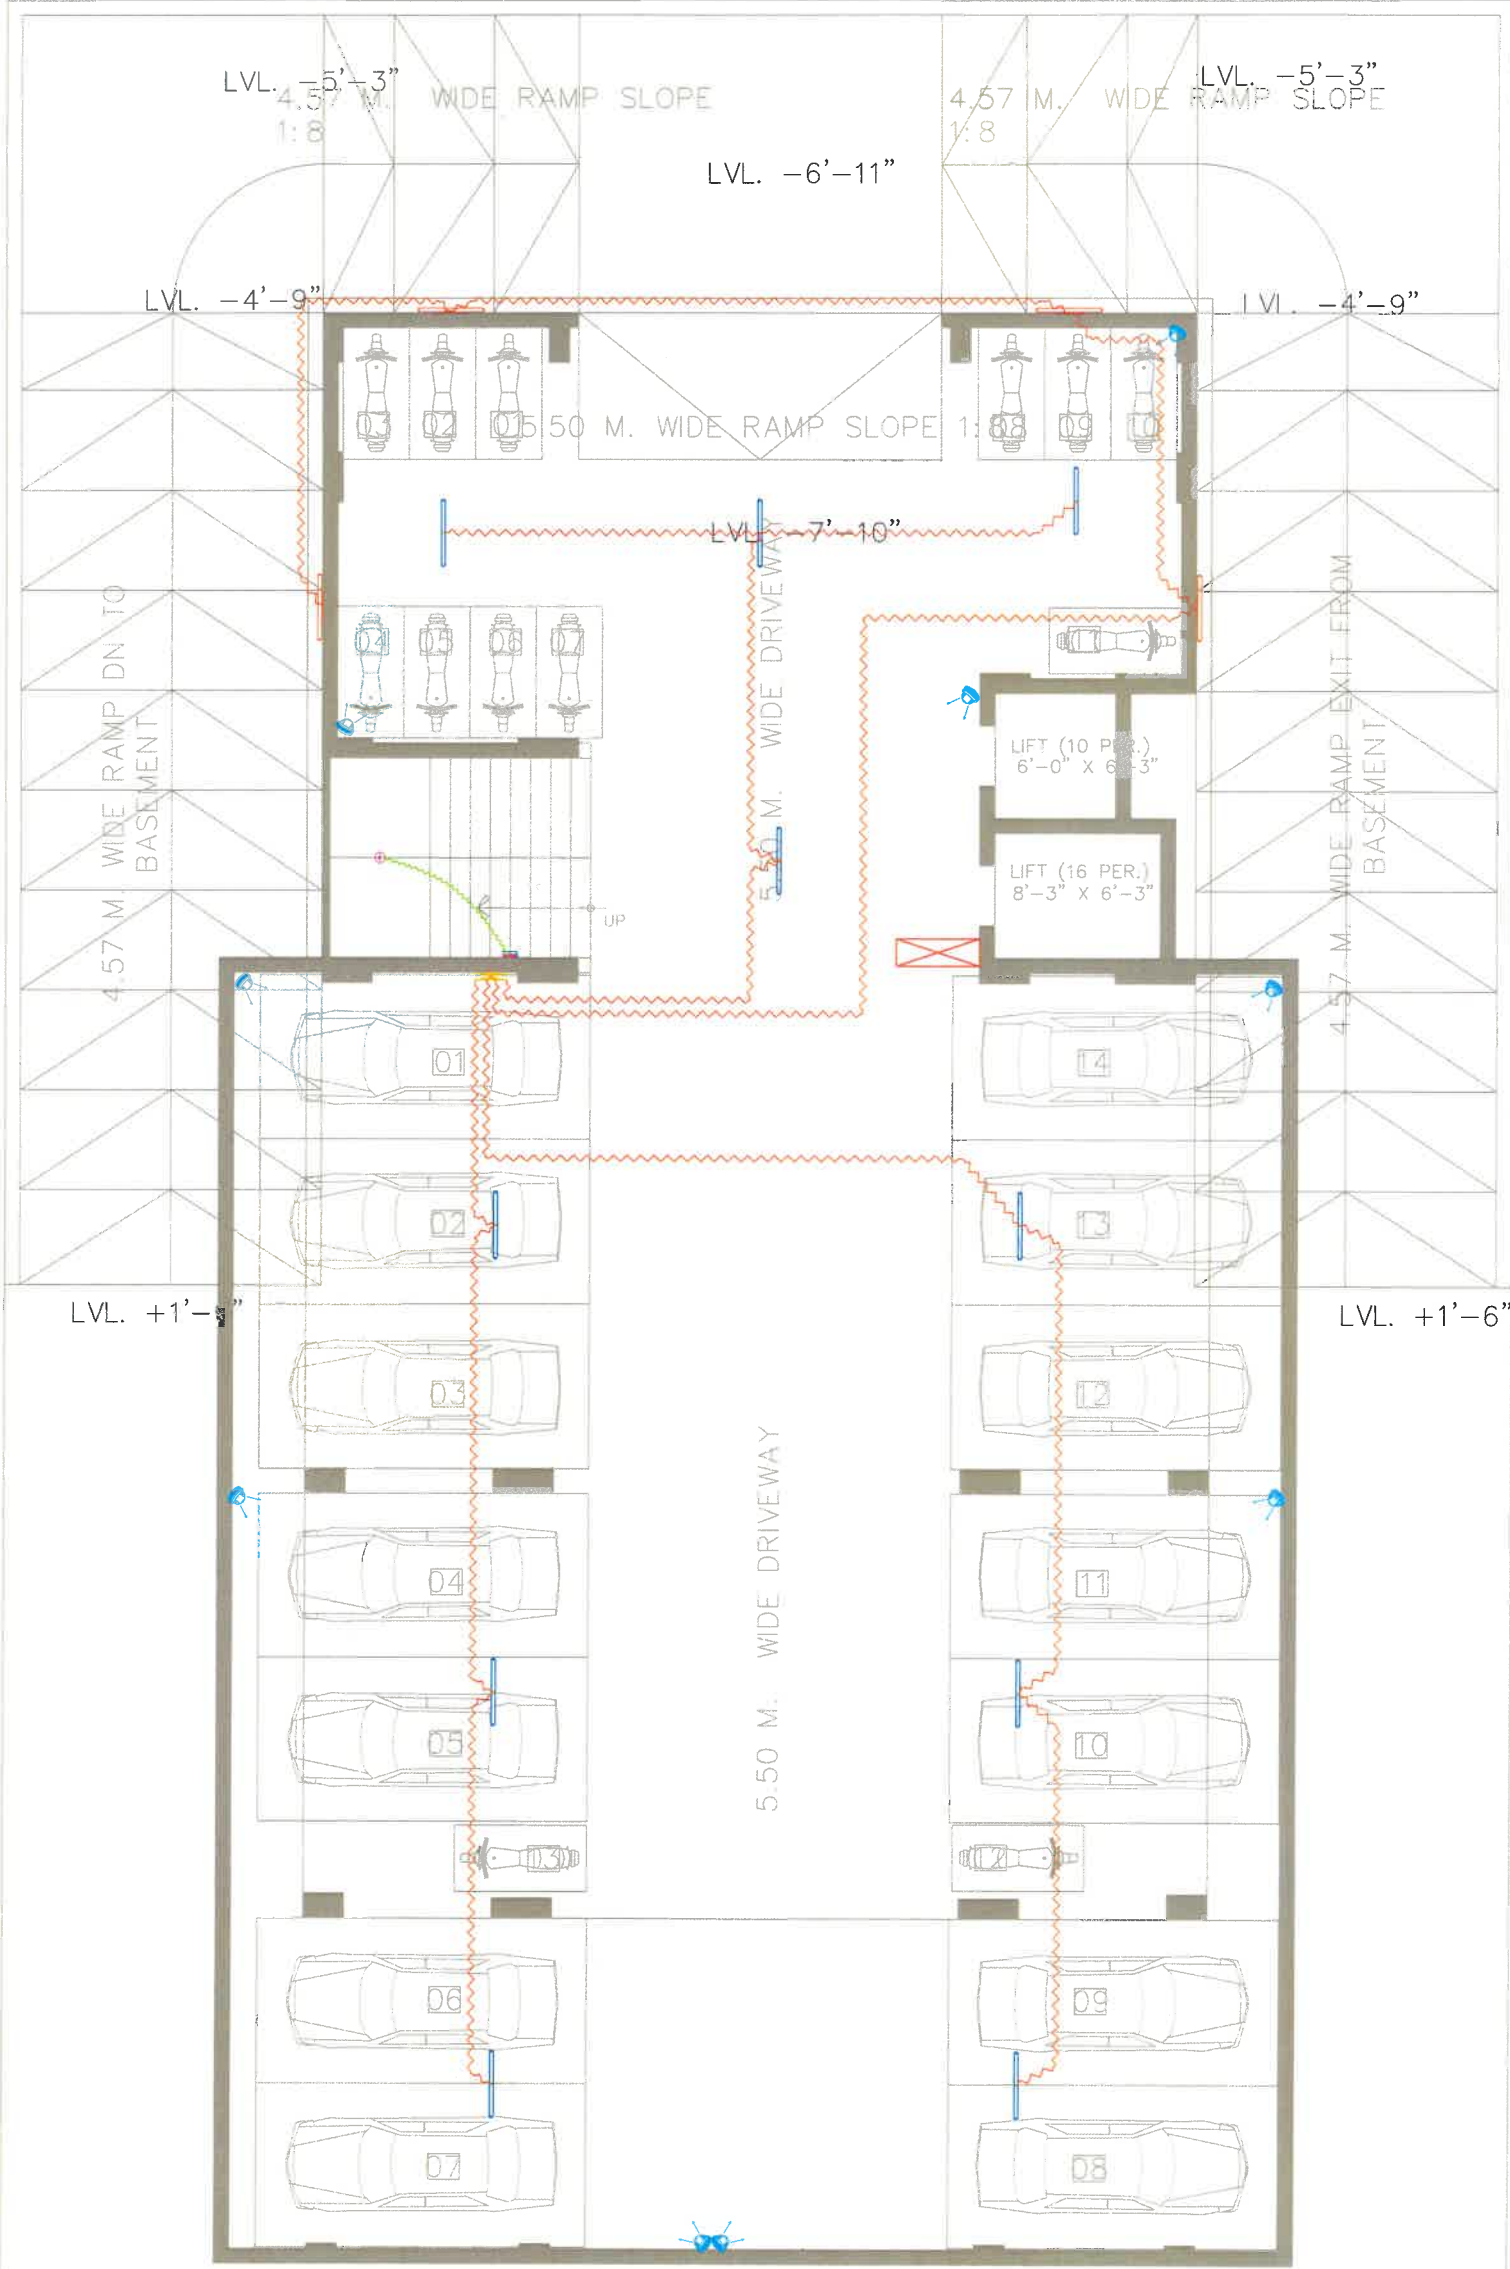

Er. PARMESHWAR
B.Tech. (Electrical)
M.Tech. (Power System)