




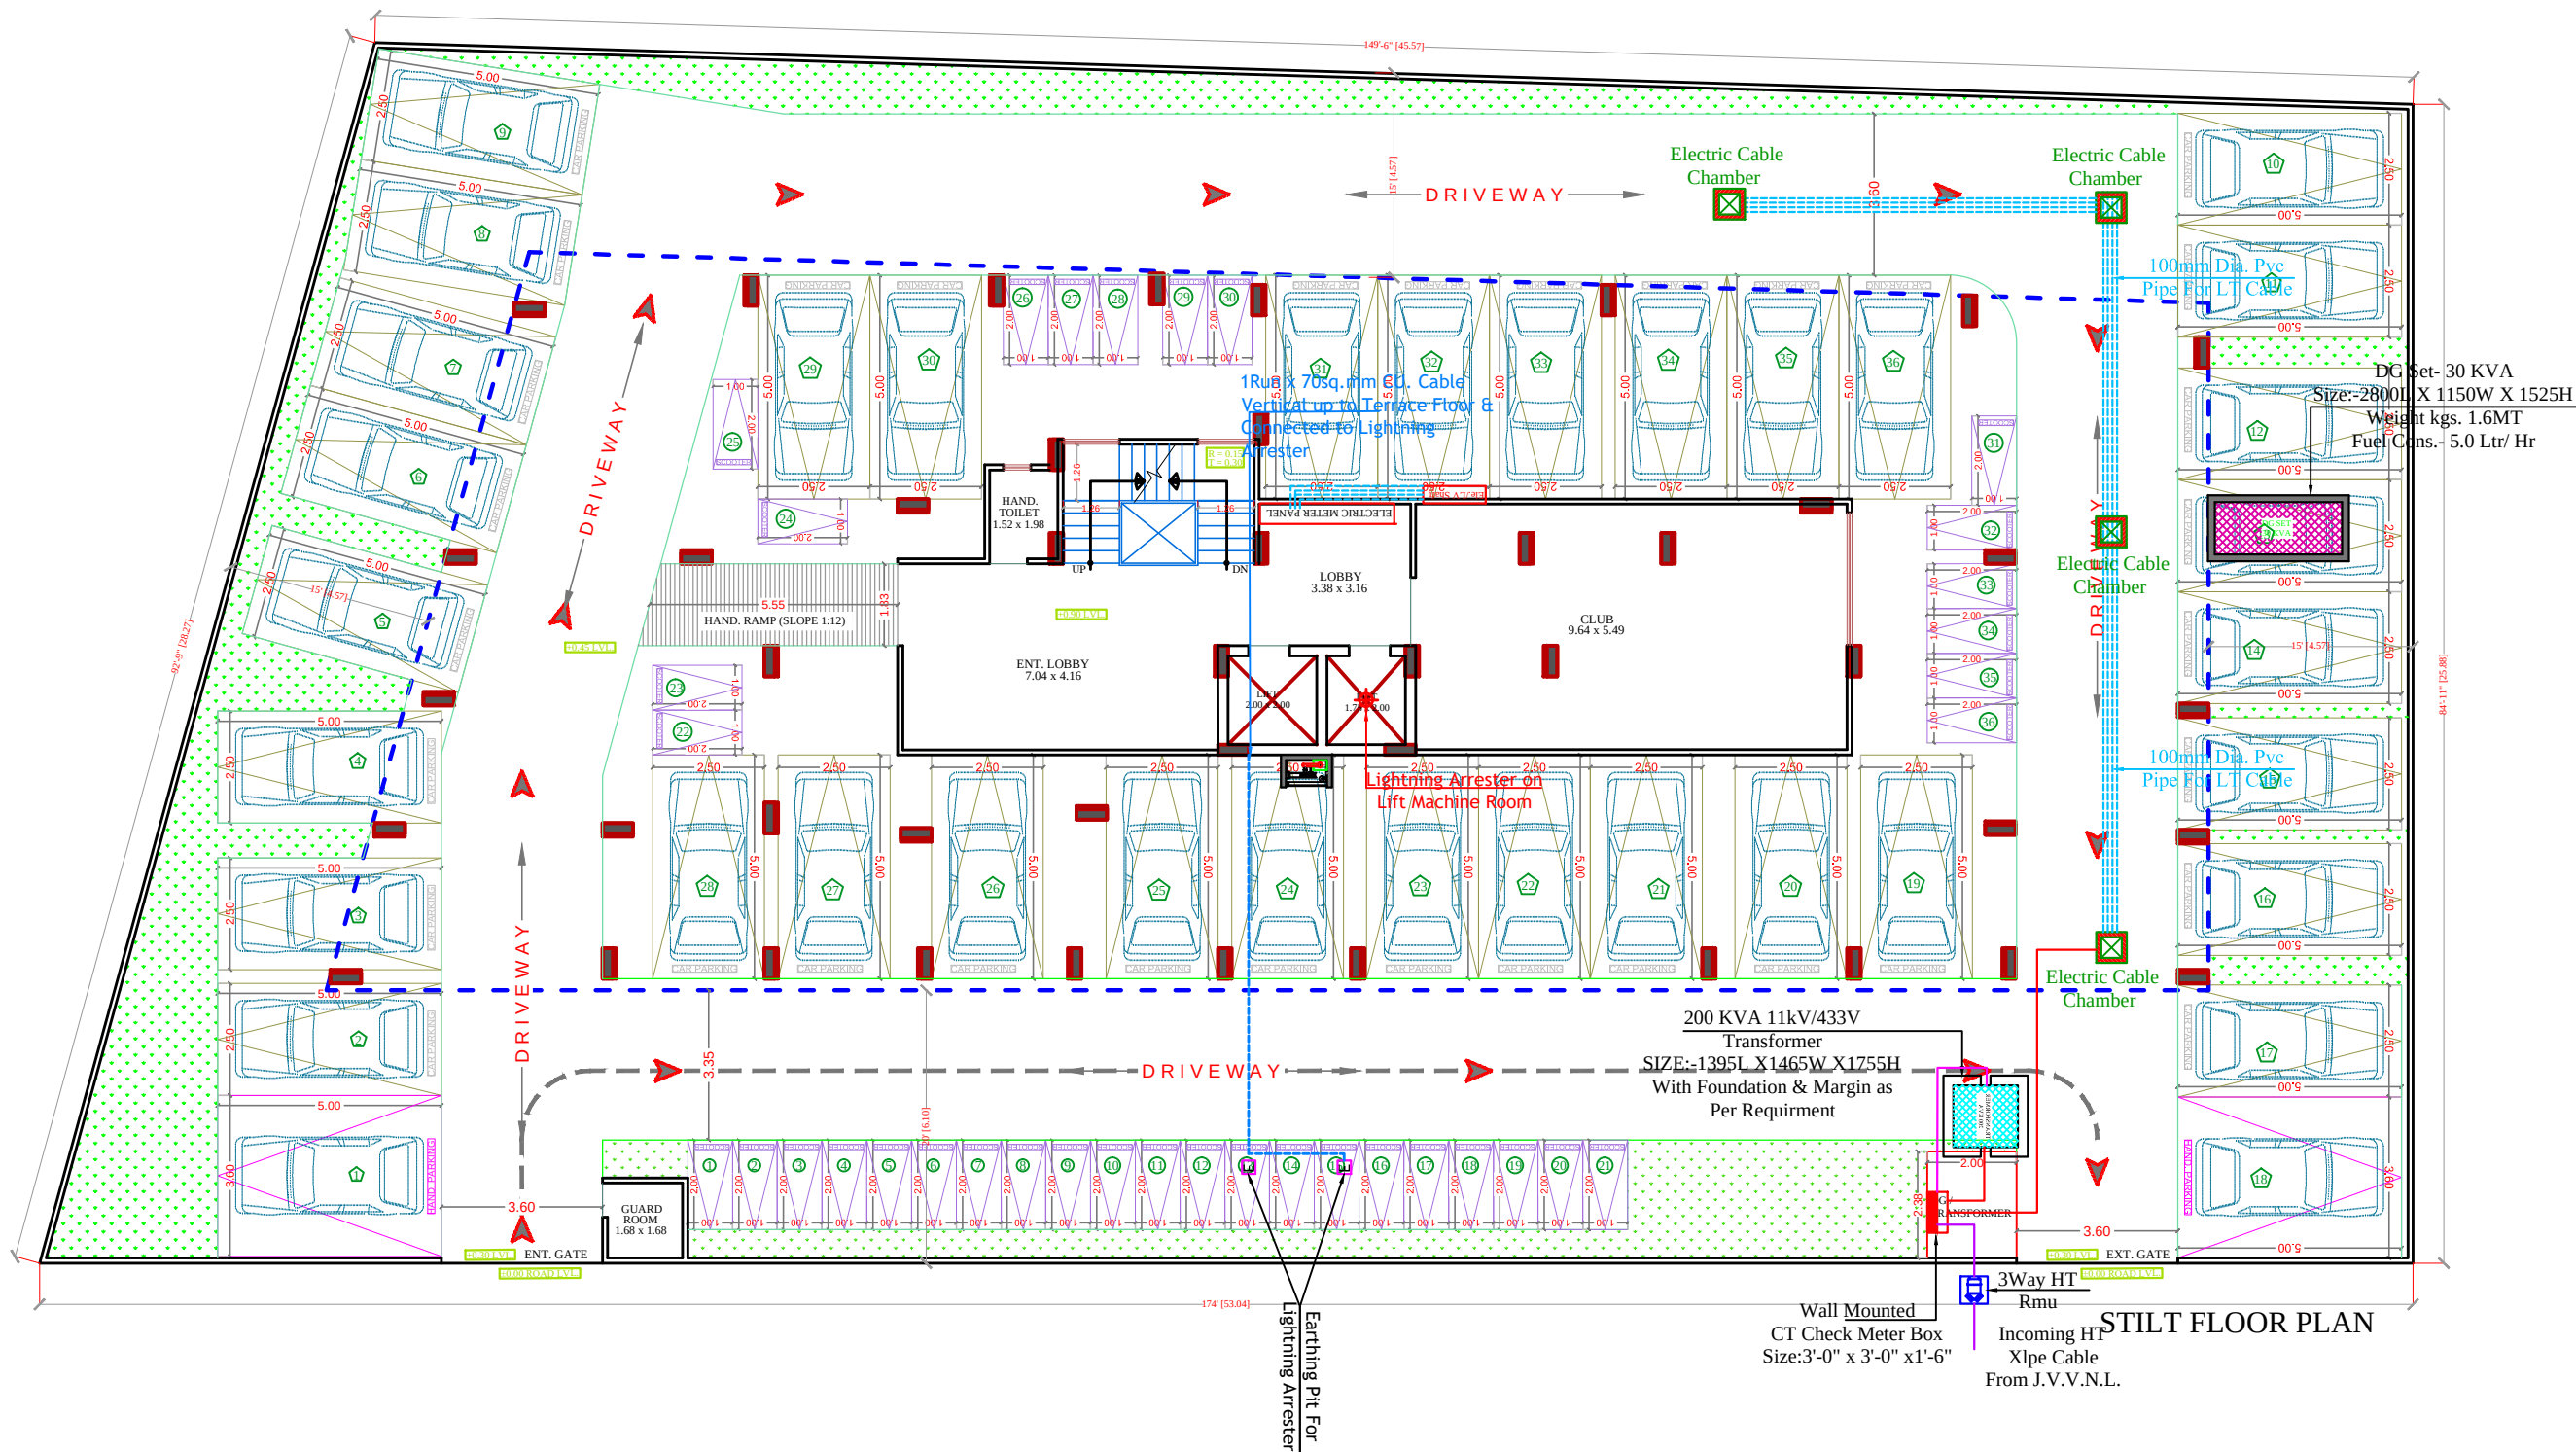

STILT FLOOR PLAN

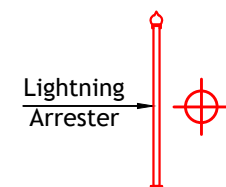

Model: Stormaster – ESE
- 30 (Level 2/Medium Protection)
(Protection radius - 25M, Mast Height -2 Mtr)

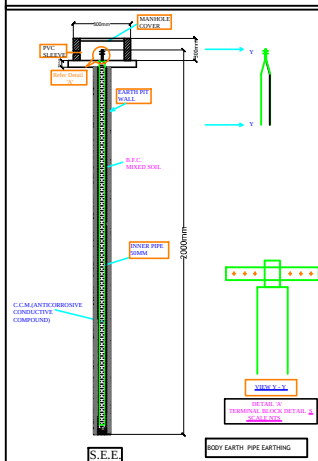

SPACE CONSULTANT

PLOT-A-173, JAGDAMBA NAGAR, HEERAPURA
POWER HOUSE, JAIPUR (RAJ) 302024

ARCHITECT :-

FRANK SQUARE
ARCHITECTURE | PLANNER | DESIGNER
C-49 VIDYA APARTMENT PARAS MARG,
BAPU NAGAR JAIPUR, (RAJ.)
Email-afranksquare@gmail.com
Mobile-9461302542

PROJECT :-


PROPOSED BUILDING AT PLOT
NO-13, 14, 15 & 16, RAGHU
VIHAR VISTAR
(GRAM-MANPURA DEVRI URF
GOLYAWAS), JAIPUR

BUILDING NAME SATYAM RESIDENCY II

DEVELOPER NAME SATYAM BUILDERS
BAJRANG LAL

DRAWING: STILT FLOOR
ELECTRIC SUB STATION,
CABLE ROUTE &
LIGHTNING ARRESTER FOR
RERA SUBMISSION PLAN

DATE
SCALE:- N.T.S.

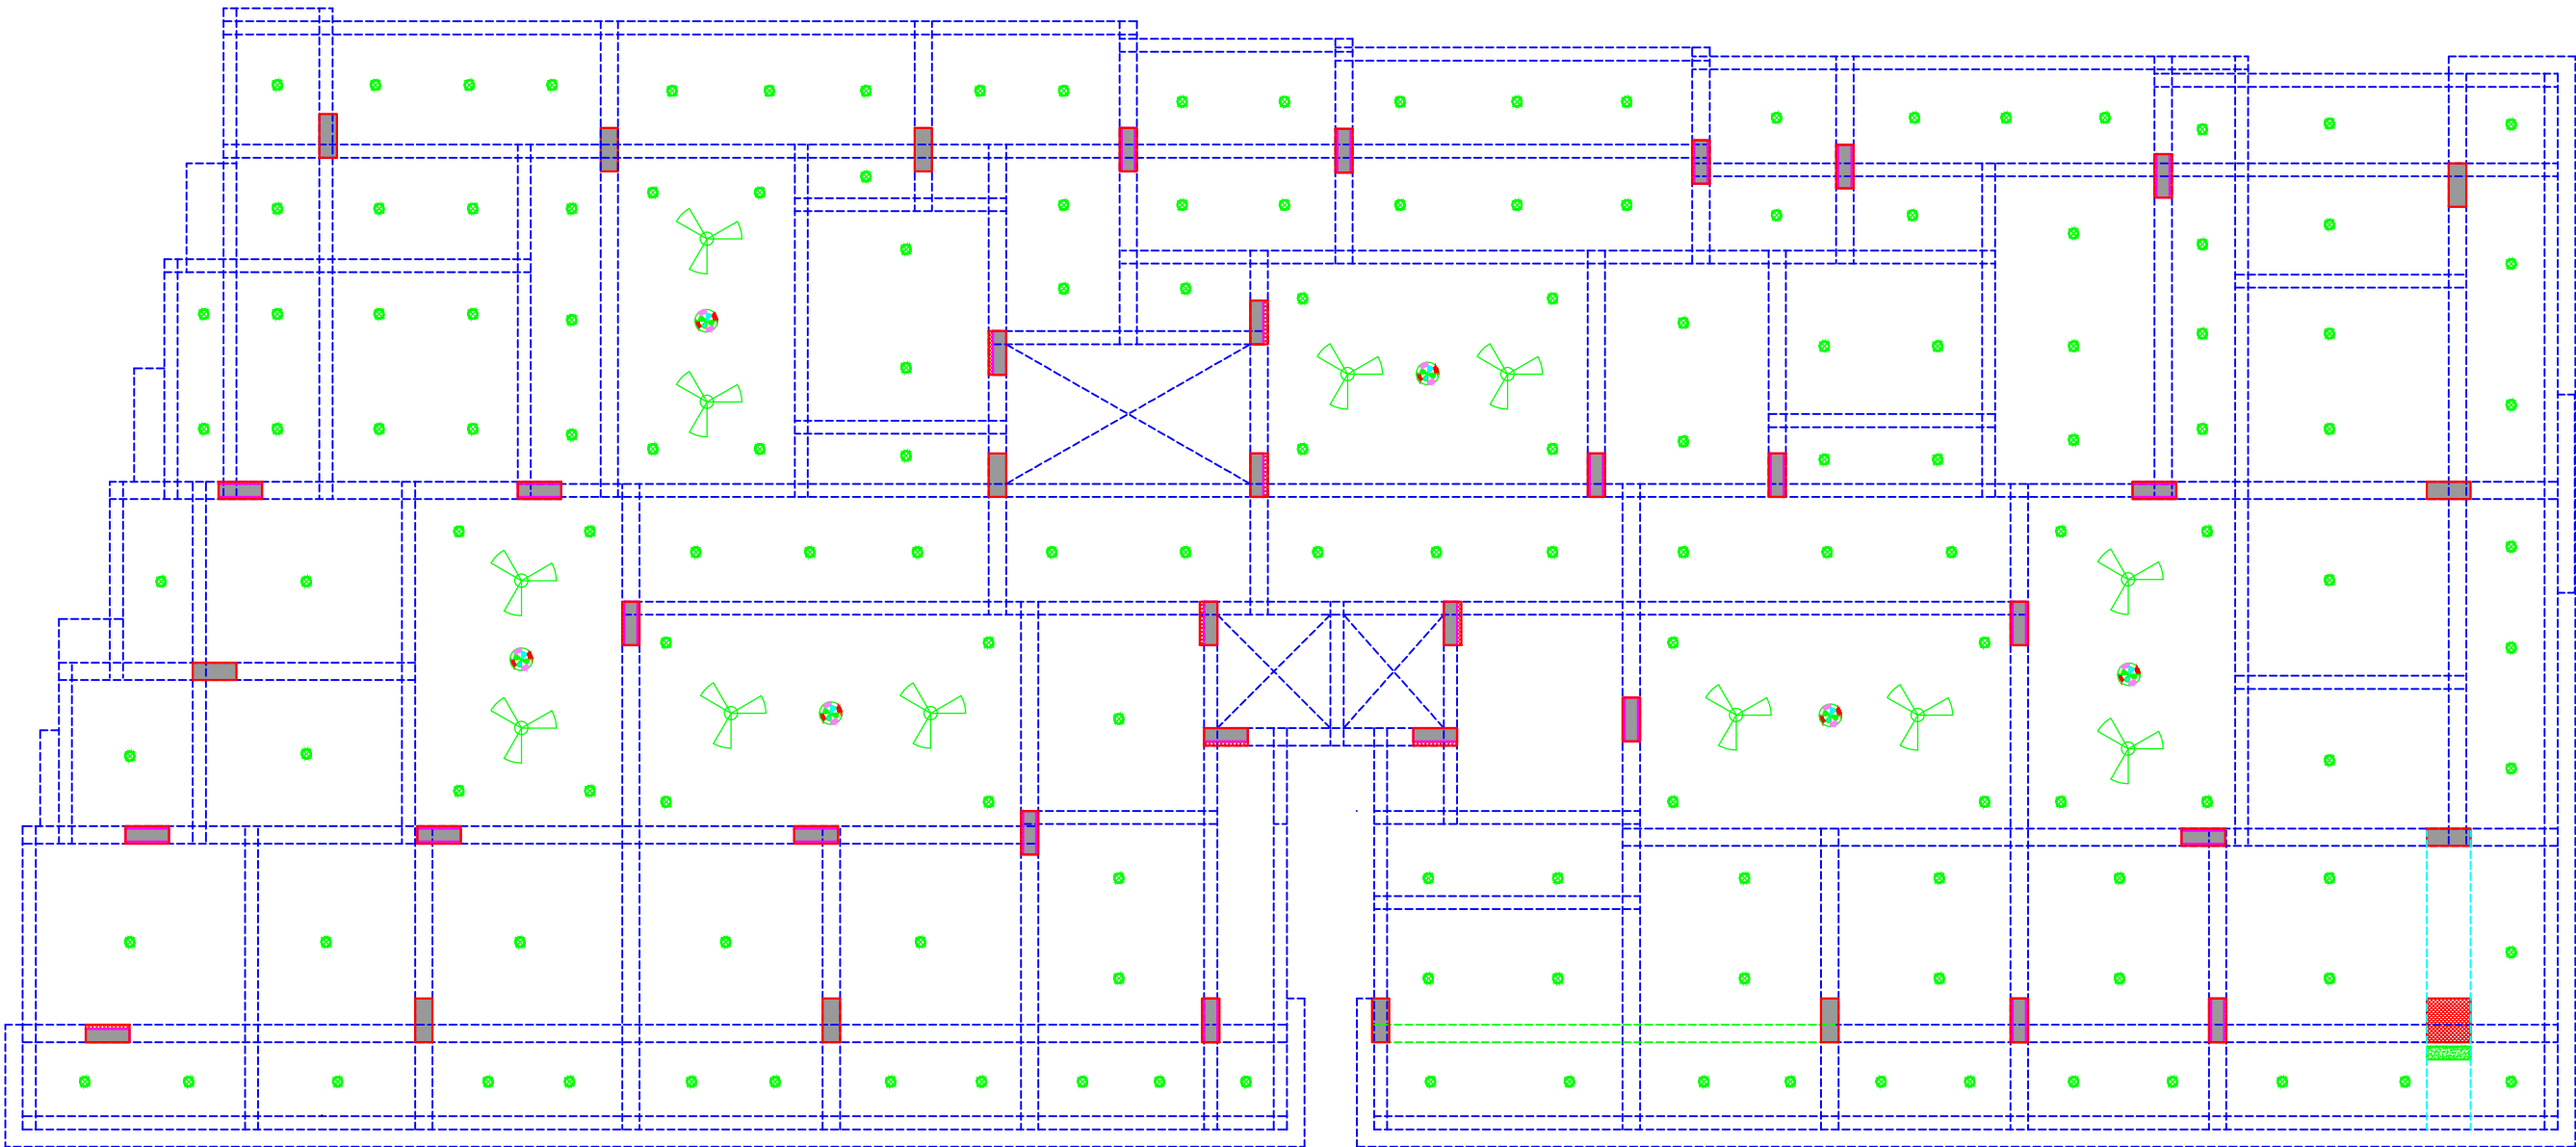

NO	ITEM	SYMBOL
1	CEILING FAN	 ROOF
2	TUBE LIGHT	 +8'6"
3	BULB	 +8'6"
4	POWER POINT	 +1'6"
5	BED POINT	 +4'3"
6	CEILING LIGHT	 ROOF
7	A.C.POINT	 +6'6"
8	SWITCH BOARD	 +4'3"
9	EXHAUST	 VENT
10	TELEPHONE	 +1'6"
11	GYSER	 +6'0"
12	BELL POINT	 +8'6"
13	T.V.	 +1'6"
14	M.BOX	 +6'6"
15	M.C.B.	 +6'6"
16	FANCY LIGHT	 +8'6"
17	HANGING LIGHT	 ROOF

PROJECT TITLE :-

PROPOSED BUILDING AT PLOT
NO-13, 14, 15 & 16, RAGHU
VIHAR VISTAR
(GRAM-MANPURA DEVRI URF
GOLYAWAS), JAIPUR

BUILDING NAME

SATYAM RESIDENCY II

DEVELOPER NAME

SATYAM BUILDERS
BAJRANG LAL

DRAWING TITLE :-

STILT FLOOR
ELECTRIC PLAN

SPACE CONSULTANT

PLOT-A-173, JAGDAMBA NAGAR, HEERAPURA
POWER HOWER, JAIPUR (RAJ) 302024



DRN. BY


APPD. BY

SCALE

DATE

REVISION

NORTH

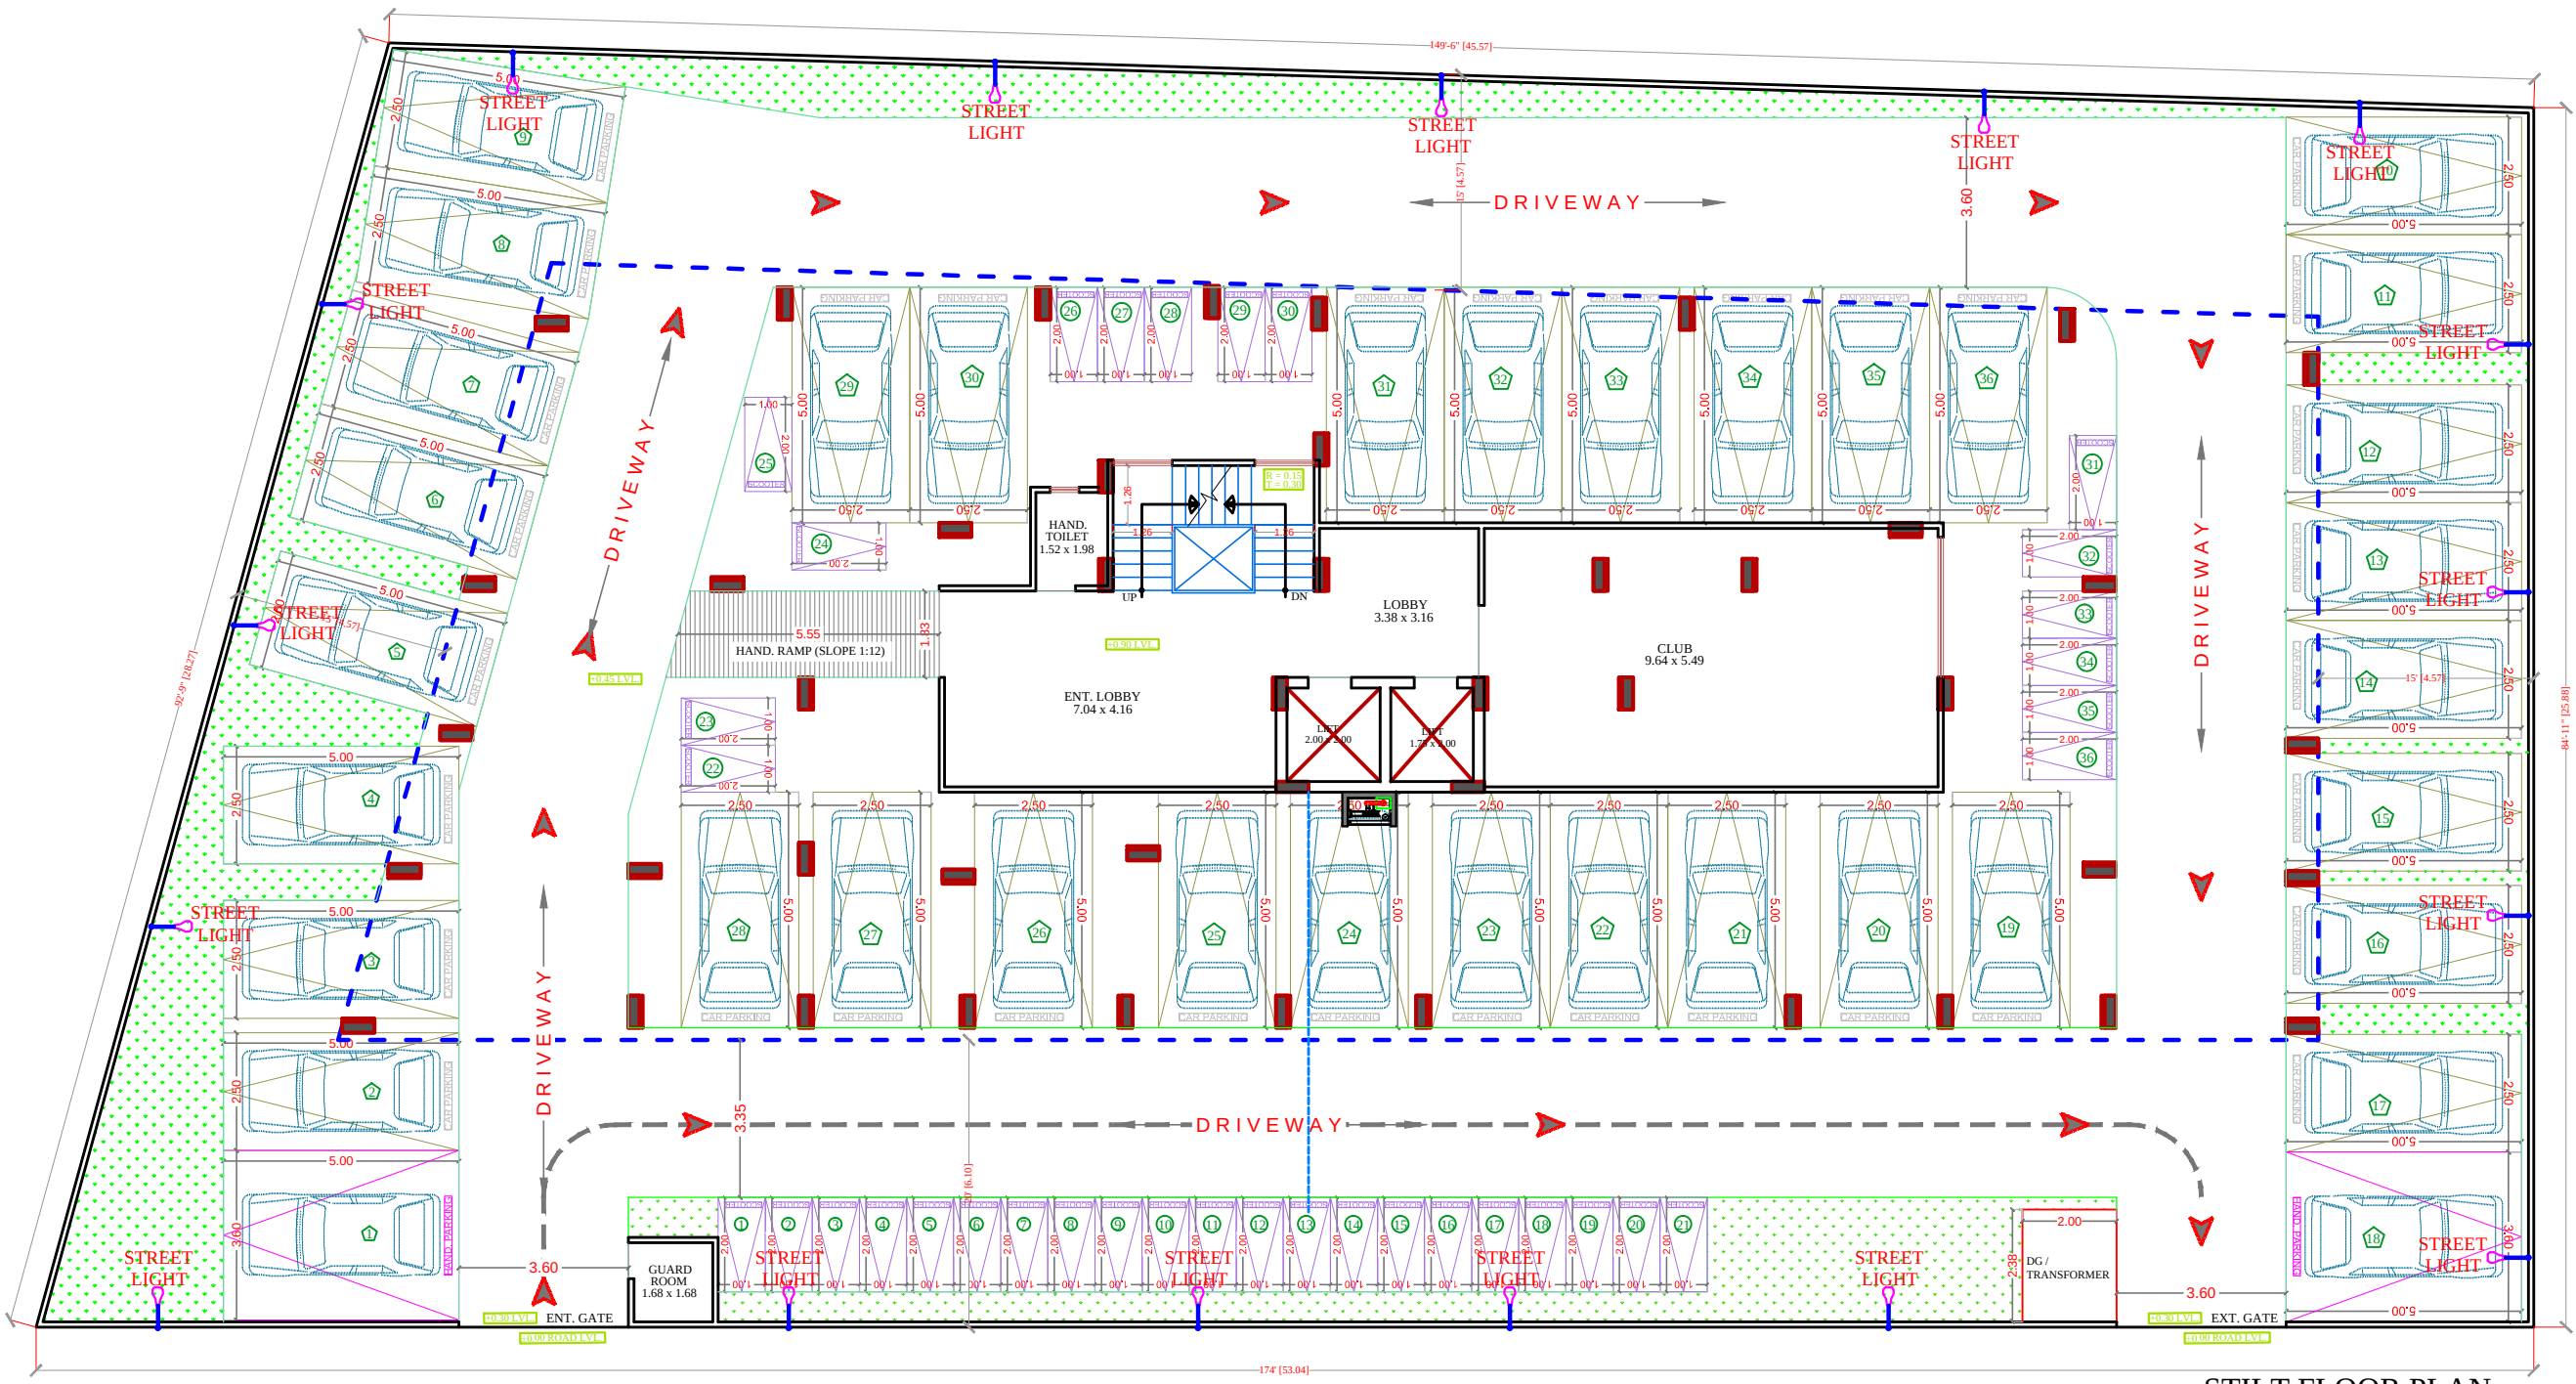

STILT FLOOR PLAN

LEGENDS:

Qty.	ID	Symbol	Description
14	PL		STREET LIGHT

SIGN:-



SPACE CONSULTANT

PLOT-A-173, JAGDAMBA NAGAR, HEERAPURA
POWER HOWER, JAIPUR (RAJ) 302024

ARCHITECT :-

FRANK SQUARE

ARCHITECTURE | PLANNER | DESIGNER
C-49 VIDYA APARTMENT PARAS MARG,
BAPU NAGAR JAIPUR, (RAJ.)
Email-afranksquare@gmail.com
Mobile-9461302542

PROJECT :-

PROPOSED BUILDING AT PLOT
NO-13, 14, 15 & 16, RAGHU
VIHAR VISTAR
(GRAM-MANPURA DEVRI URF
GOLYAWAS), JAIPUR

BUILDING NAME


SATYAM RESIDENCY II

DEVELOPER NAME

SATYAM BUILDERS
BAJRANG LAL

DRAWING: STILT FLOOR
EXTERNAL STREET LIGHT
FOR RERA SUBMISSION PLAN

DATE
SCALE:- N.T.S.

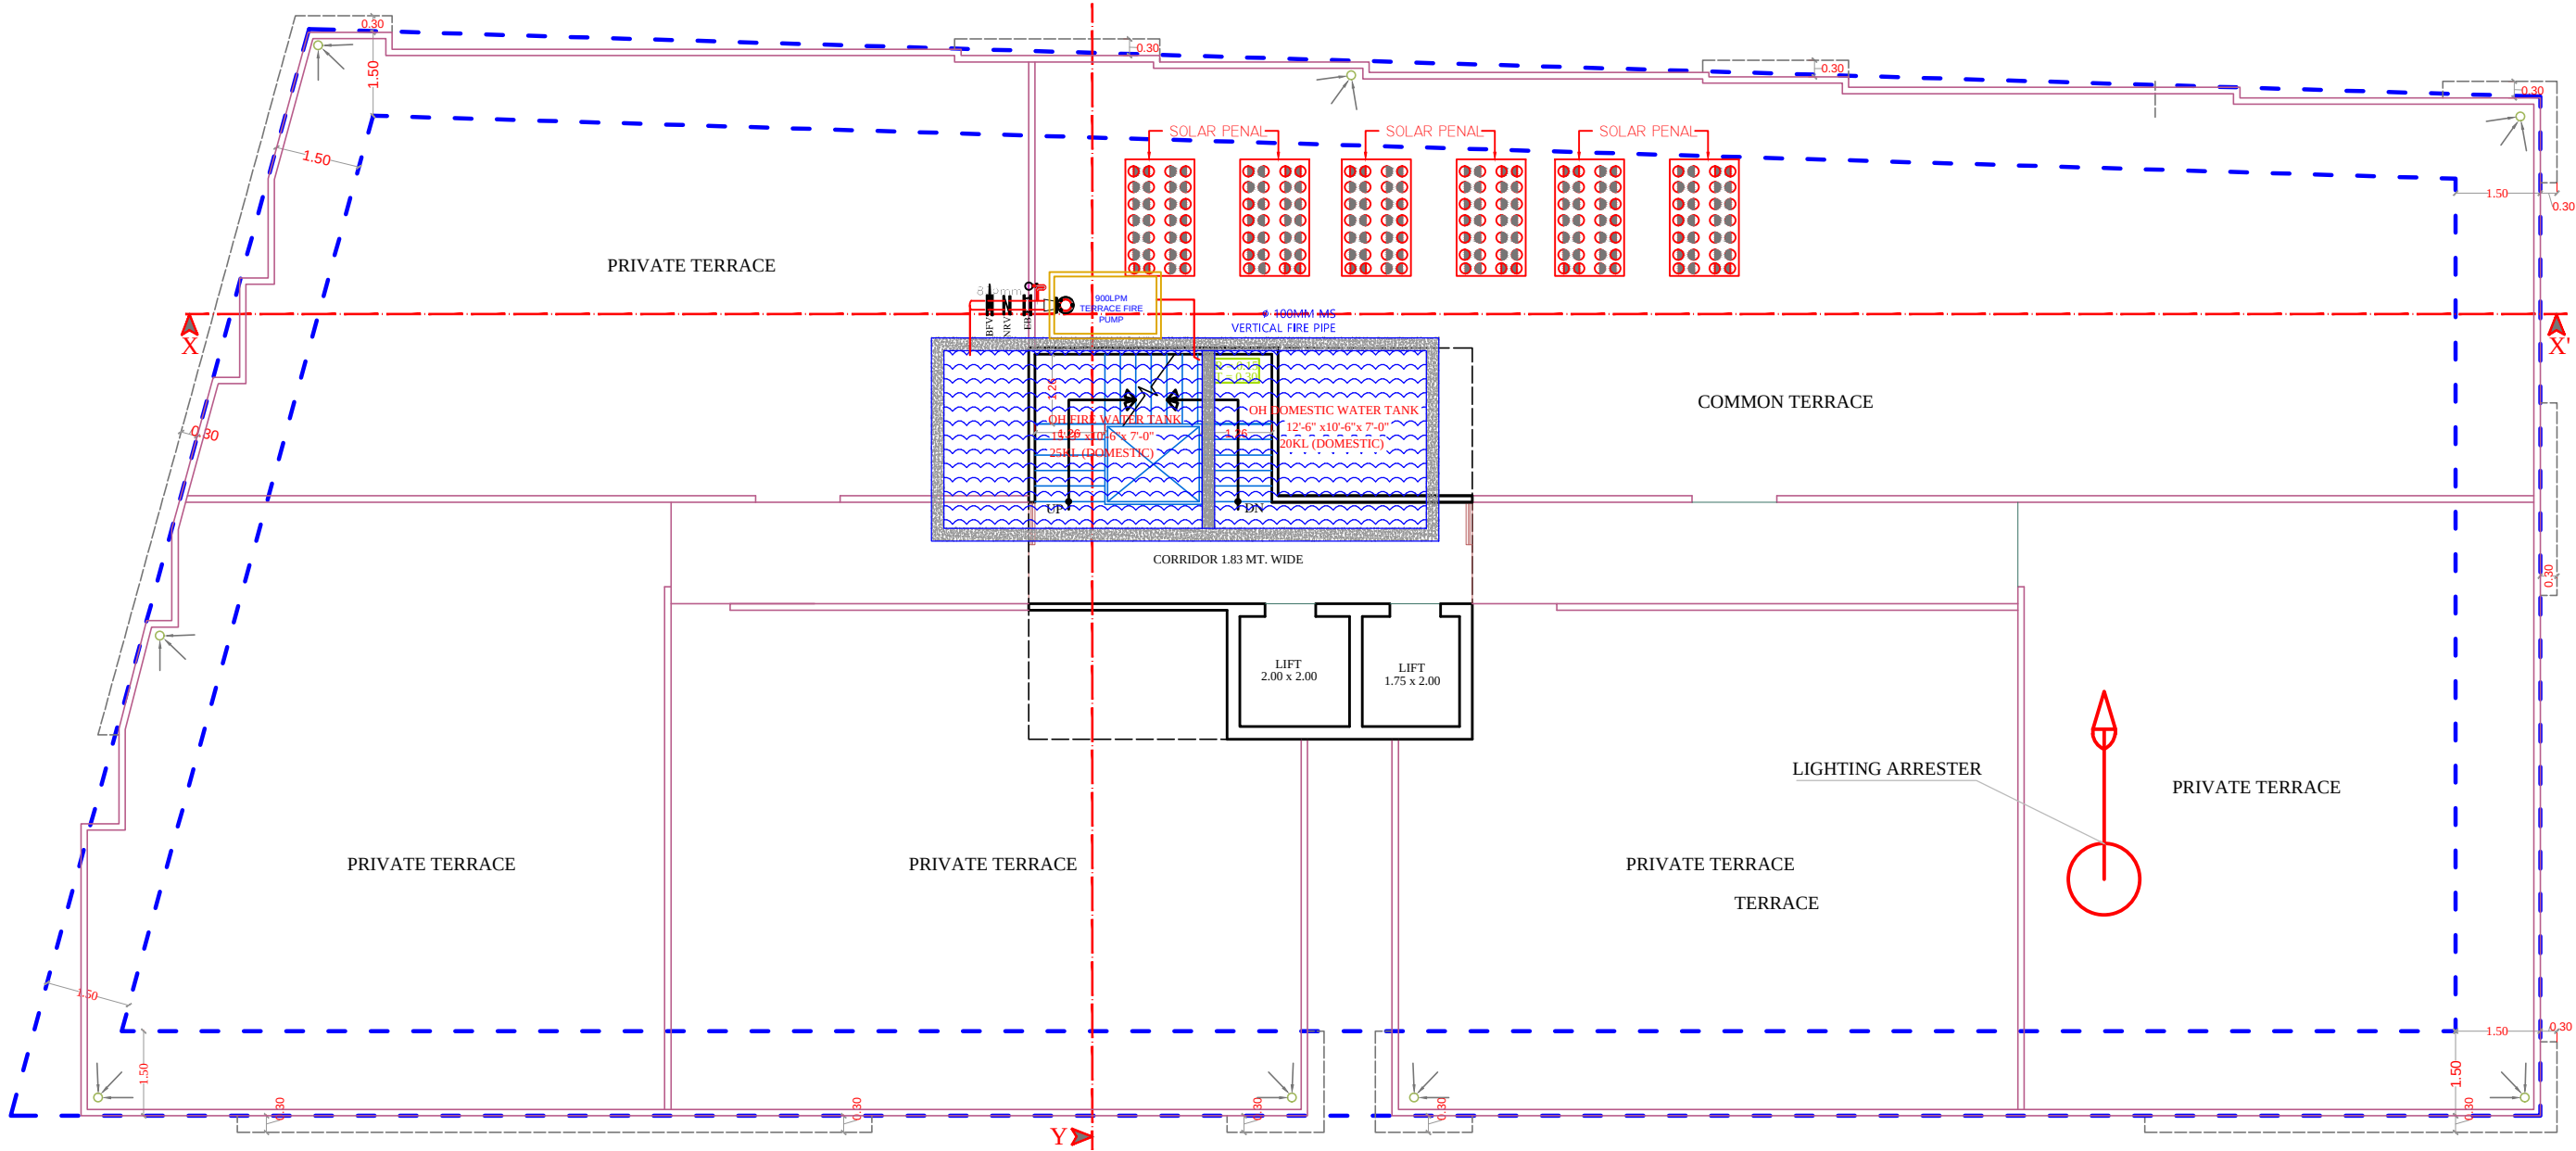

TERRACE FLOOR PLAN

----- R O A D 40' WIDE -----

LEGEND		
	Symbole	DESCRIPTION
1.		HOSEREEL
2.		FIRE PIPE
3.		FIRE PIPE
4.		FIRE EXTINGUISHER
5.		EXTERNAL YARD HYDRANT

PROJECT TITLE :- PROPOSED BUILDING AT PLOT NO-13, 14, 15 & 16, RAGHU VIHAR VISTAR (GRAM-MANPURA DEVRI URF GOLYAWAS), JAIPUR	BUILDING NAME SATYAM RESIDENCY II		DRAWING TITLE :- TARRACE FLOOR LIGHTING ARRESTER LOCATION	<div><div>SPACE CONSULTANT</div><div>PLOT-A-173, JAGDAMBA NAGAR, HEERAPURA POWER HOWER, JAIPUR (RAJ) 302024</div><div></div></div>	DRN. BY			NORTH
	DEVELOPER NAME SATYAM BUILDERS BAJRANG LAL				APPD. BY		DATE	
					REVISION			
					SCALE			