


PROJECT NAME :


The Royal Green I

DEVELOPER NAME :

BALAJI CONSTRUCTION

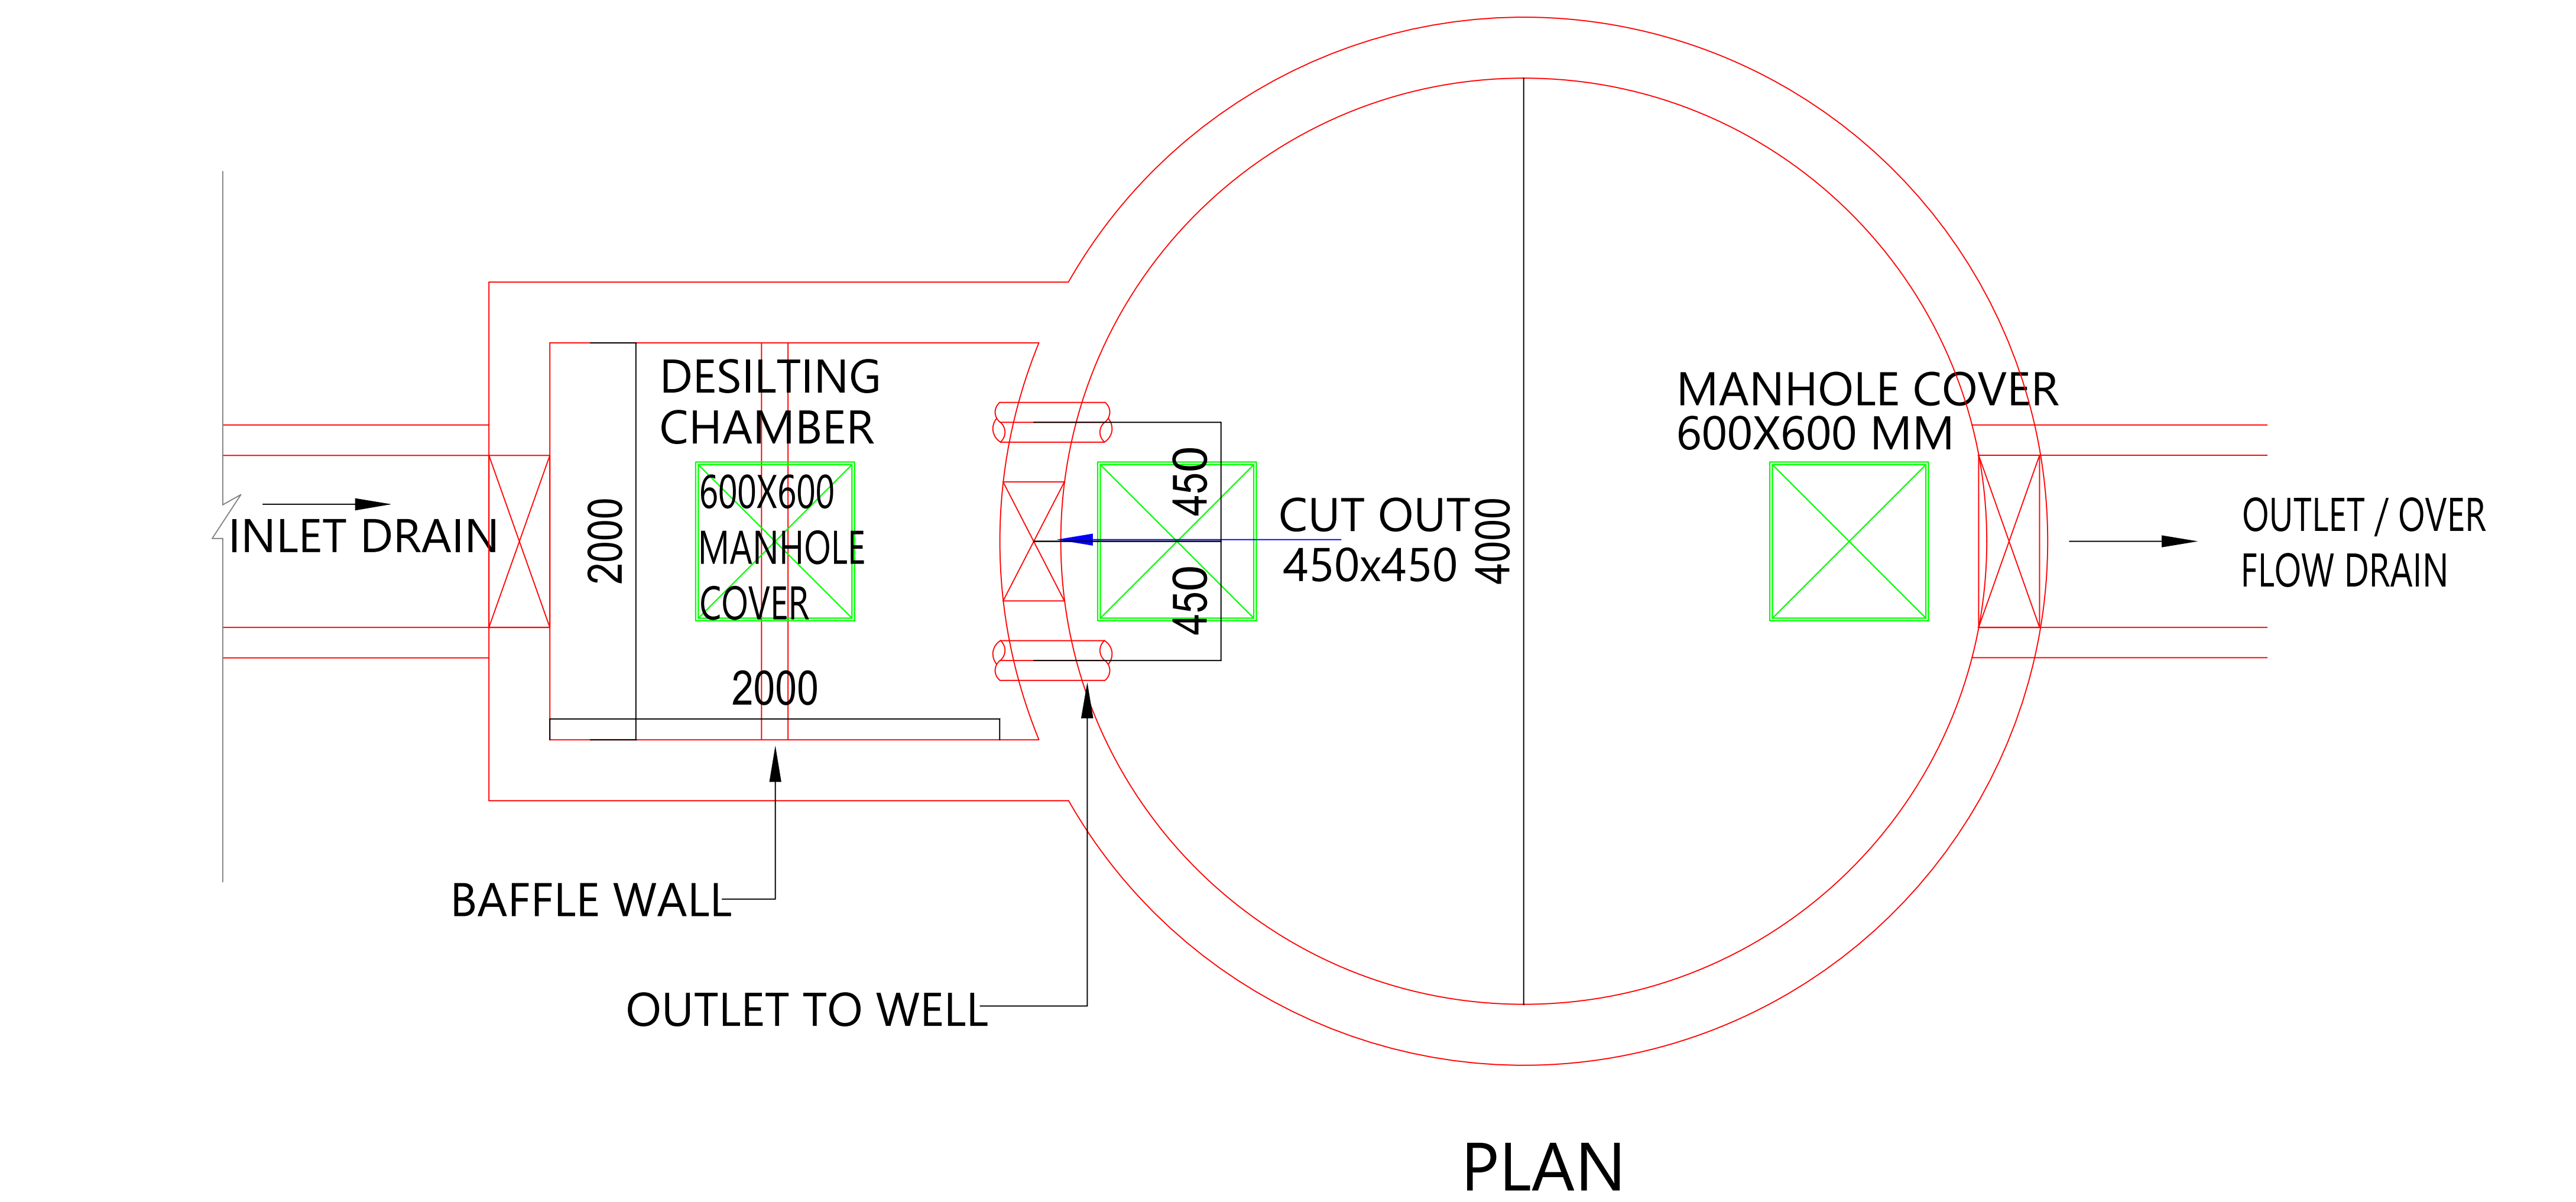

PLAN

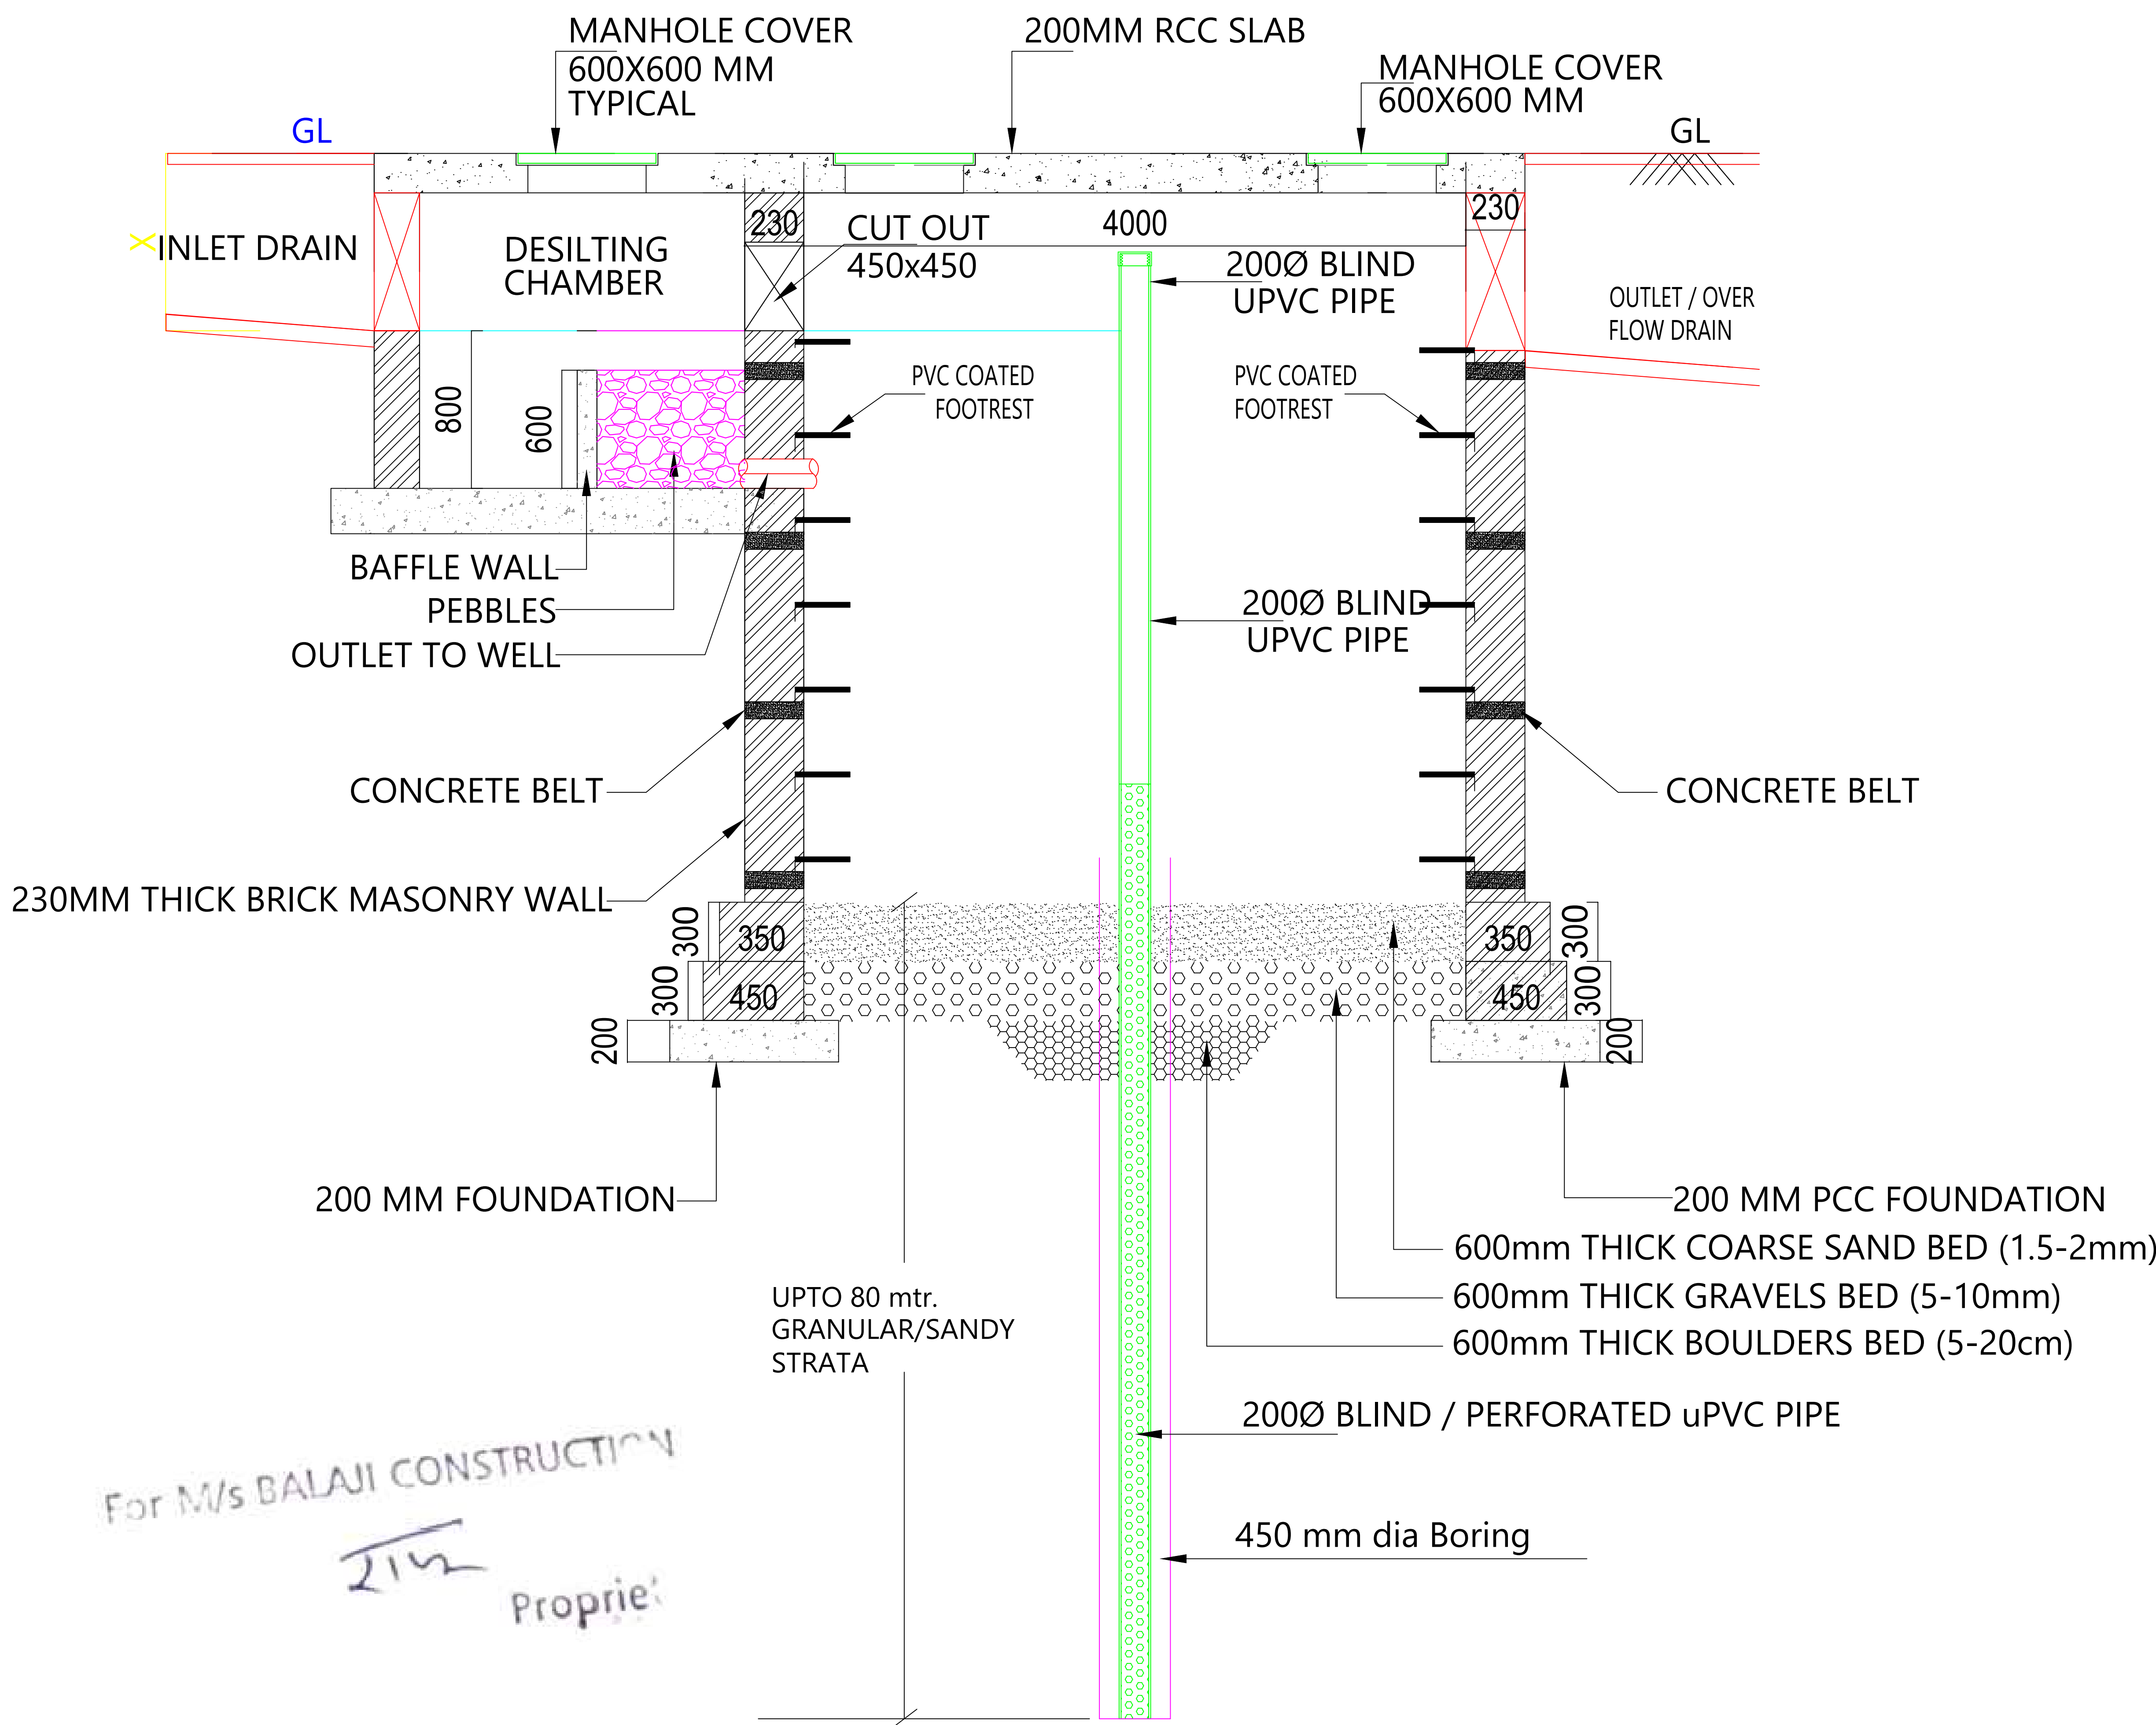

RAIN WATER HARVESTING/ RECHARGING

NOTES:

- ALL DIMENSIONS ARE IN MM. AND INDICATIVE ONLY. SUITABLE AMENDMENTS MAY BE DONE AS PER ACTUAL SITE CONDITIONS.
- THE DIMENSION OF STRUCTURAL ELEMENTS (FOUNDATION, WALL, SLAB ETC.) ARE ONLY INDICATIVE. THESE SHALL BE AS PER STRUCTURAL DRAWINGS.
- THE DIMENSION 'X' SHALL BE CALCULATED ON THE BASIS OF INVERT OF UPSTREAM DRAIN

LEGEND:-

①	SOIL PIPE	
②	WASTE PIPE	
③	VENT PIPE	
④	COLD WATER SUPPLY (CWS)	
⑤	HOT WATER SUPPLY (HWS)	
	RAIN WATER PIPE	
SW	SEWER LINE- EXTERNAL	
RW	STORM WATER DRAINAGE PIPE	
	SEWERAGE MANHOLE (2' x 2')	M.H.
	STORM WATER MANHOLE (2' x 2')	M.H.
GT	GULLY TRAP	
BV	BALL VALVE	
FT	FLOOR TRAP	
FD	FLOOR FLOOR DRAIN	
	RAIN WATER COLLECTION CHAMBER 450X450MM	
	KHURRA	

S.No	DATE	REVISION DESCRIPTION
1.		GENERAL NOTES : All dimension on this drawing are in MKS System Only written dimensions are to be followed. drawing should not be scaled. All measurements must be checked and verified by the contractors prior to execution of work at the site. The drawing is to be read in conjunction with all relevant structural, services & facility drawing. Architectural drawings are to be followed for the location of all structural members & masonry walls. for sizes & reinforcement details of structural members, relevant structural drawings are to be referred. Any modification to the structural, structural and services drawings must be brought to the notice of the architect immediately & prior to execution at site. Co-ordination with services such as hvac, plumbing & electrical, etc. is the responsibility of the contractor. All masonry walls should be aligned with the columns as indicated on the plan, irrespective of the position as indicated with the dimensionary. For details, refer relevant large scale detail drawings as indicated.

PROJECT:

PROPOSED RESIDENTIAL FLATS ON PLOT NO.-1,2,3,4 & 5 N.P SCHEME, SCHEME NO.12B-II (MOTI BHAWAN G.N.S.S , JAIPUR

NAME OF DRAWING:

RAIN WATER HARVESTING PIT SECTION DETAILS PLAN

DRAWING	NORTH:
WORKING DRAWING	
PROJECT NO. :	DATE :
	11, June - 2025
SCALE :	REV NO. :
NTS	R-0

DRAWING NO.:

PROJECT	CATEGORY	BLOCK	FLOOR	TYPE	NUMBER
---------	----------	-------	-------	------	--------

A-201

Er. SANJEEV SHARMA
B.E (Electrical)

