


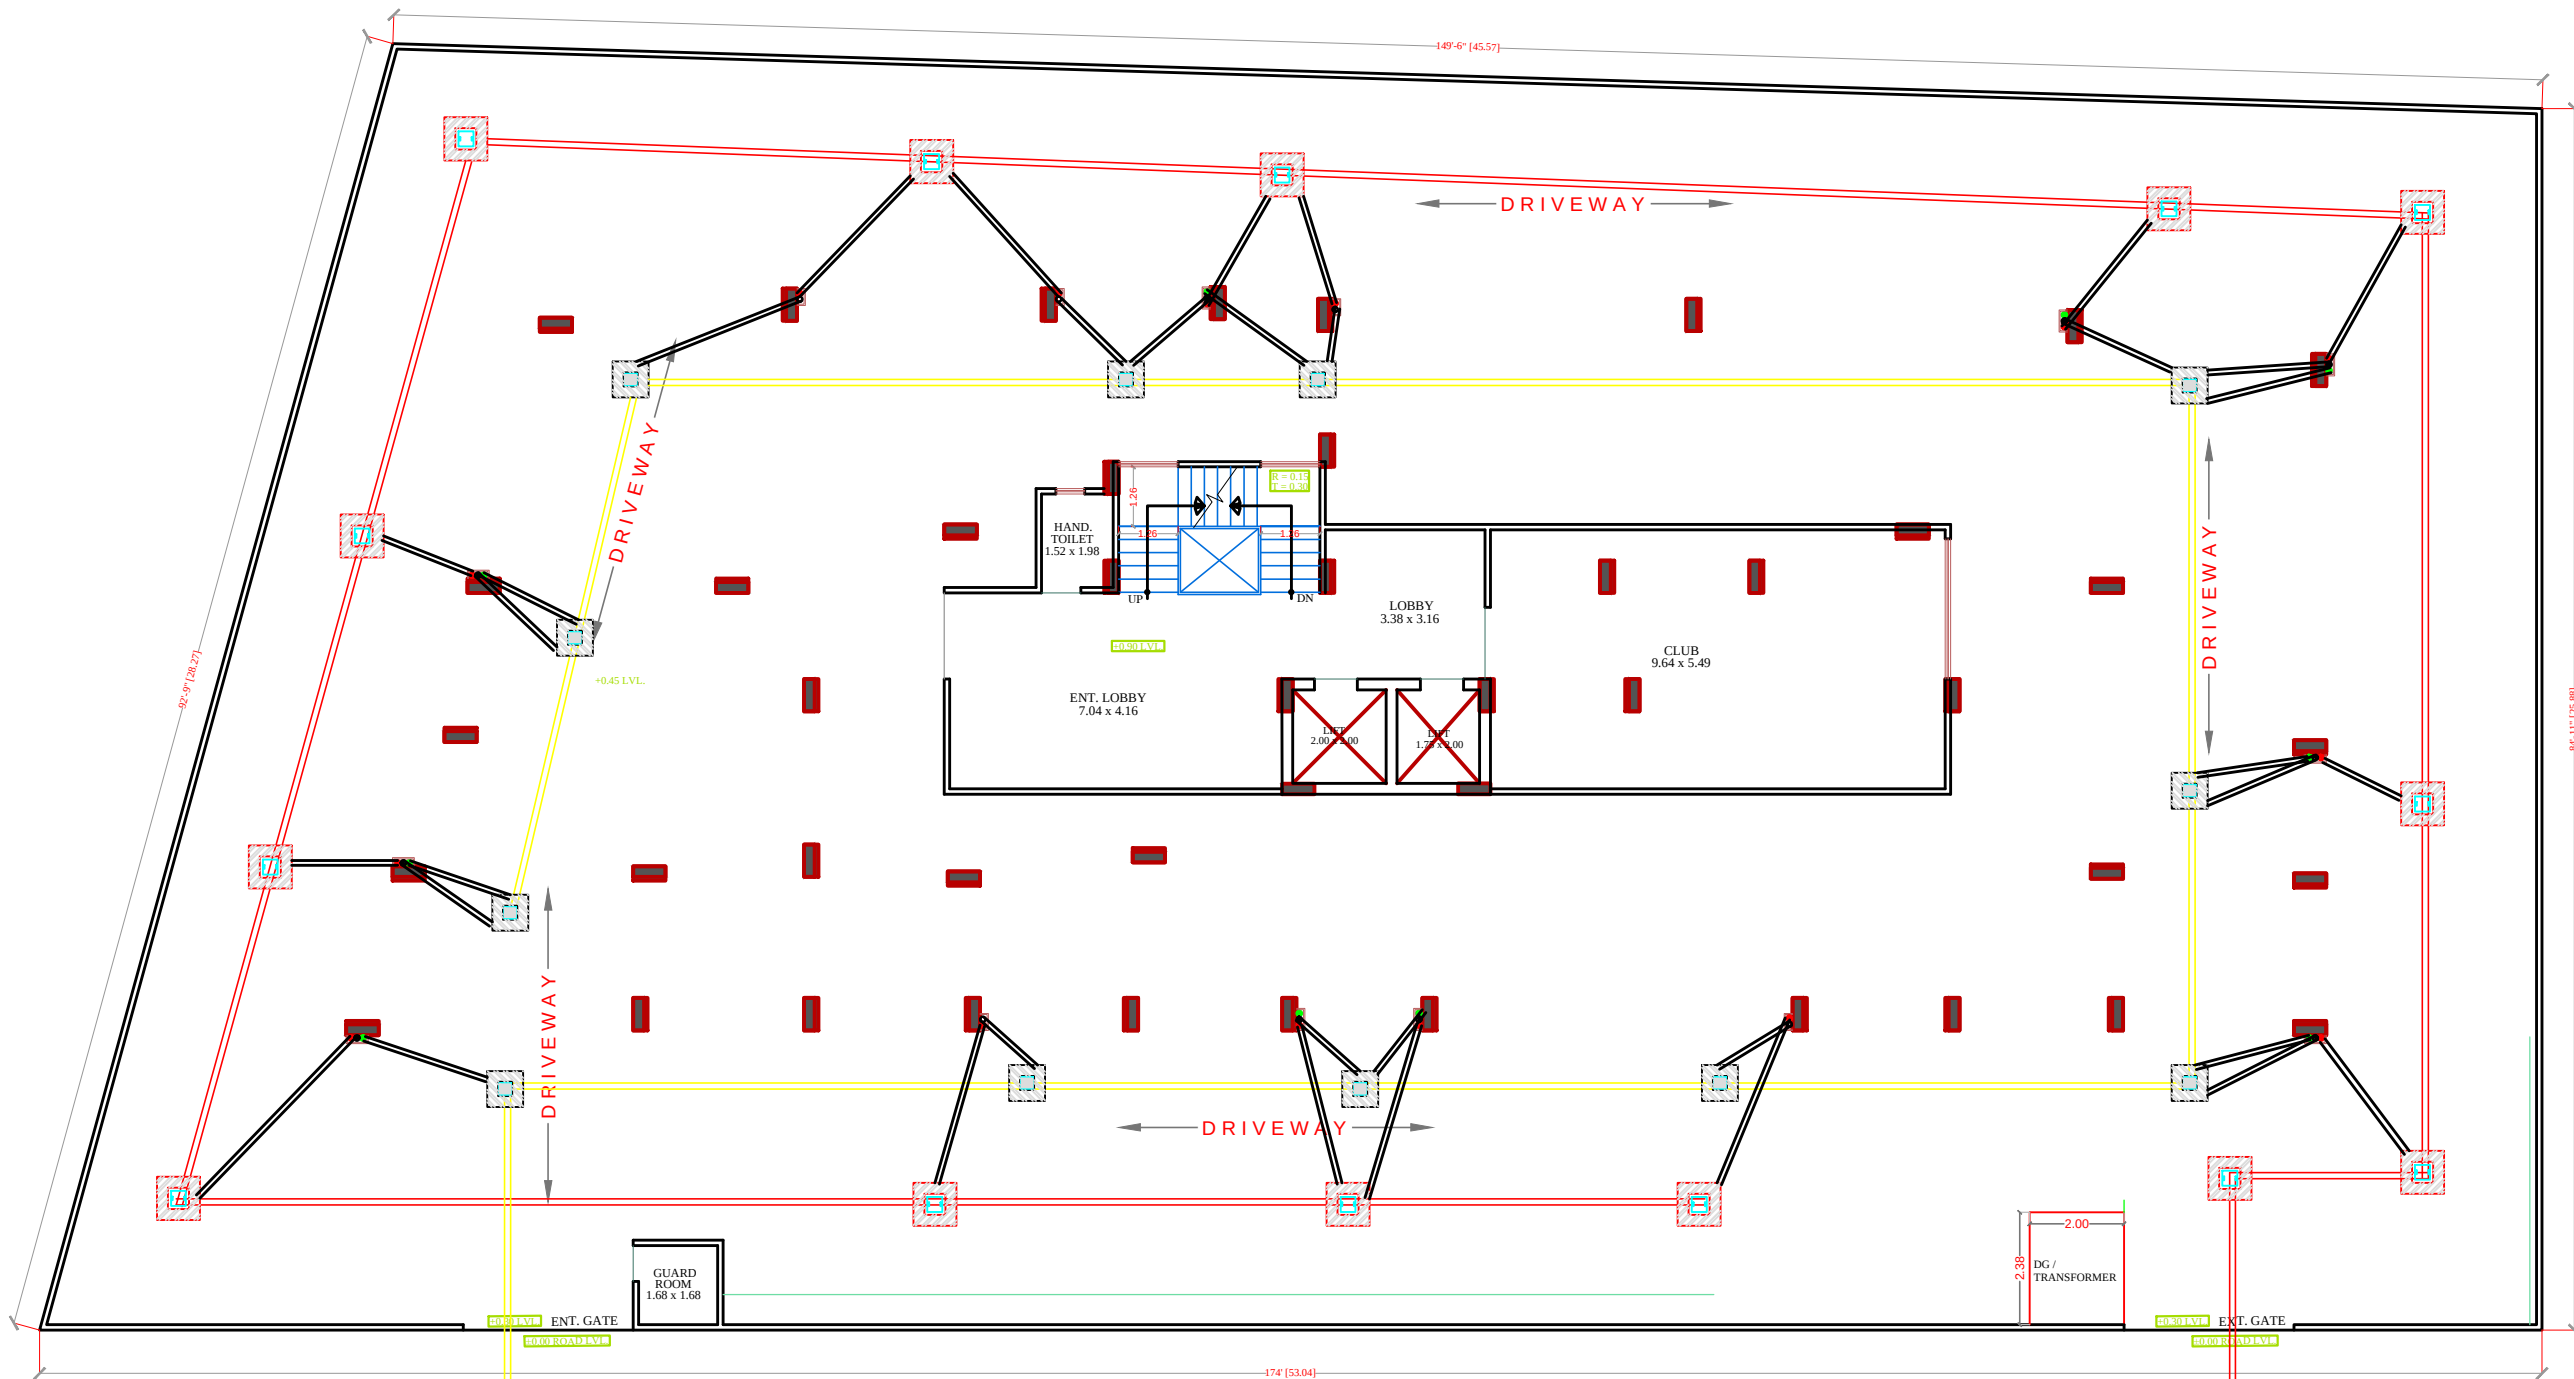

STILT FLOOR PLAN

MAIN SEWER LINE

RAIN WATER LINE

SYMBOL	DESCRIPTION
	Ø 110 mm Soil Waste Water Pipe
	Ø 110 mm Waste Water Pipe
	Ø 110 mm Rain Water Pipe
	Ø 160 mm Rain Water Pipe Slope 1:200
	Ø 110 mm Rain Water Pipe Slope 1:200
	RC-12"X12" Depth According to Slope
	RC-18"X18" Depth According to Slope
	RC-24"X24" Depth According to Slope
	Flow Direction

PROJECT TITLE :- PROPOSED BUILDING AT PLOT NO-13, 14, 15 & 16, RAGHU VIHAR VISTAR (GRAM-MANPURA DEVRI URF GOLYAWAS), JAIPUR	BUILDING NAME SATYAM RESIDENCY II	DRAWING TITLE :- STILT FLOOR WATER SUPPLY	<div><div></div><div>SPACE CONSULTANT PLOT-A-173, JAGDAMBA NAGAR, HEERAPURA POWER HOWER, JAIPUR (RAJ) 302024</div></div>	DRN. BY			NORTH	
	DEVELOPER NAME SATYAM BUILDERS BAJRANG LAL					DATE		
				APPD. BY				REVISION
				SCALE				

SERVICES CONSULTANT:
PLOT-A-173, JAGDAMBA NAGAR ,HEERAPURA
POWER HOWER ,JAIPUR (RAJ) 302024

ARCHITECTS:-

FRANK SQUARE

ARCHITECTURE | PLANNER | DESIGNER
C-49 VIDYA APARTMENT PARAS MARG,
BAPU NAGAR JAIPUR, (RAJ.)
Email-afranksquare@gmail.com
Mobile-9461302542

Project:PROPOSED BUILDING AT PLOT
NO-13, 14, 15 & 16, RAGHU
VIHAR VISTAR
(GRAM-MANPURA DEVRI URF
GOLYAWAS), JAIPUR

BUILDING NAME
SATYAM RESIDENCY II

DEVELOPER NAME
SATYAM BUILDERS
BAJRANG LAL


Drawing:
WATER SUPPLY SCHEMATIC
DIAGRAM


DRN BY :
CHCKD BY :

APPRVD BY :
DATE.-:



WATER SUPPLY SCHEMATIC DIAGRAM

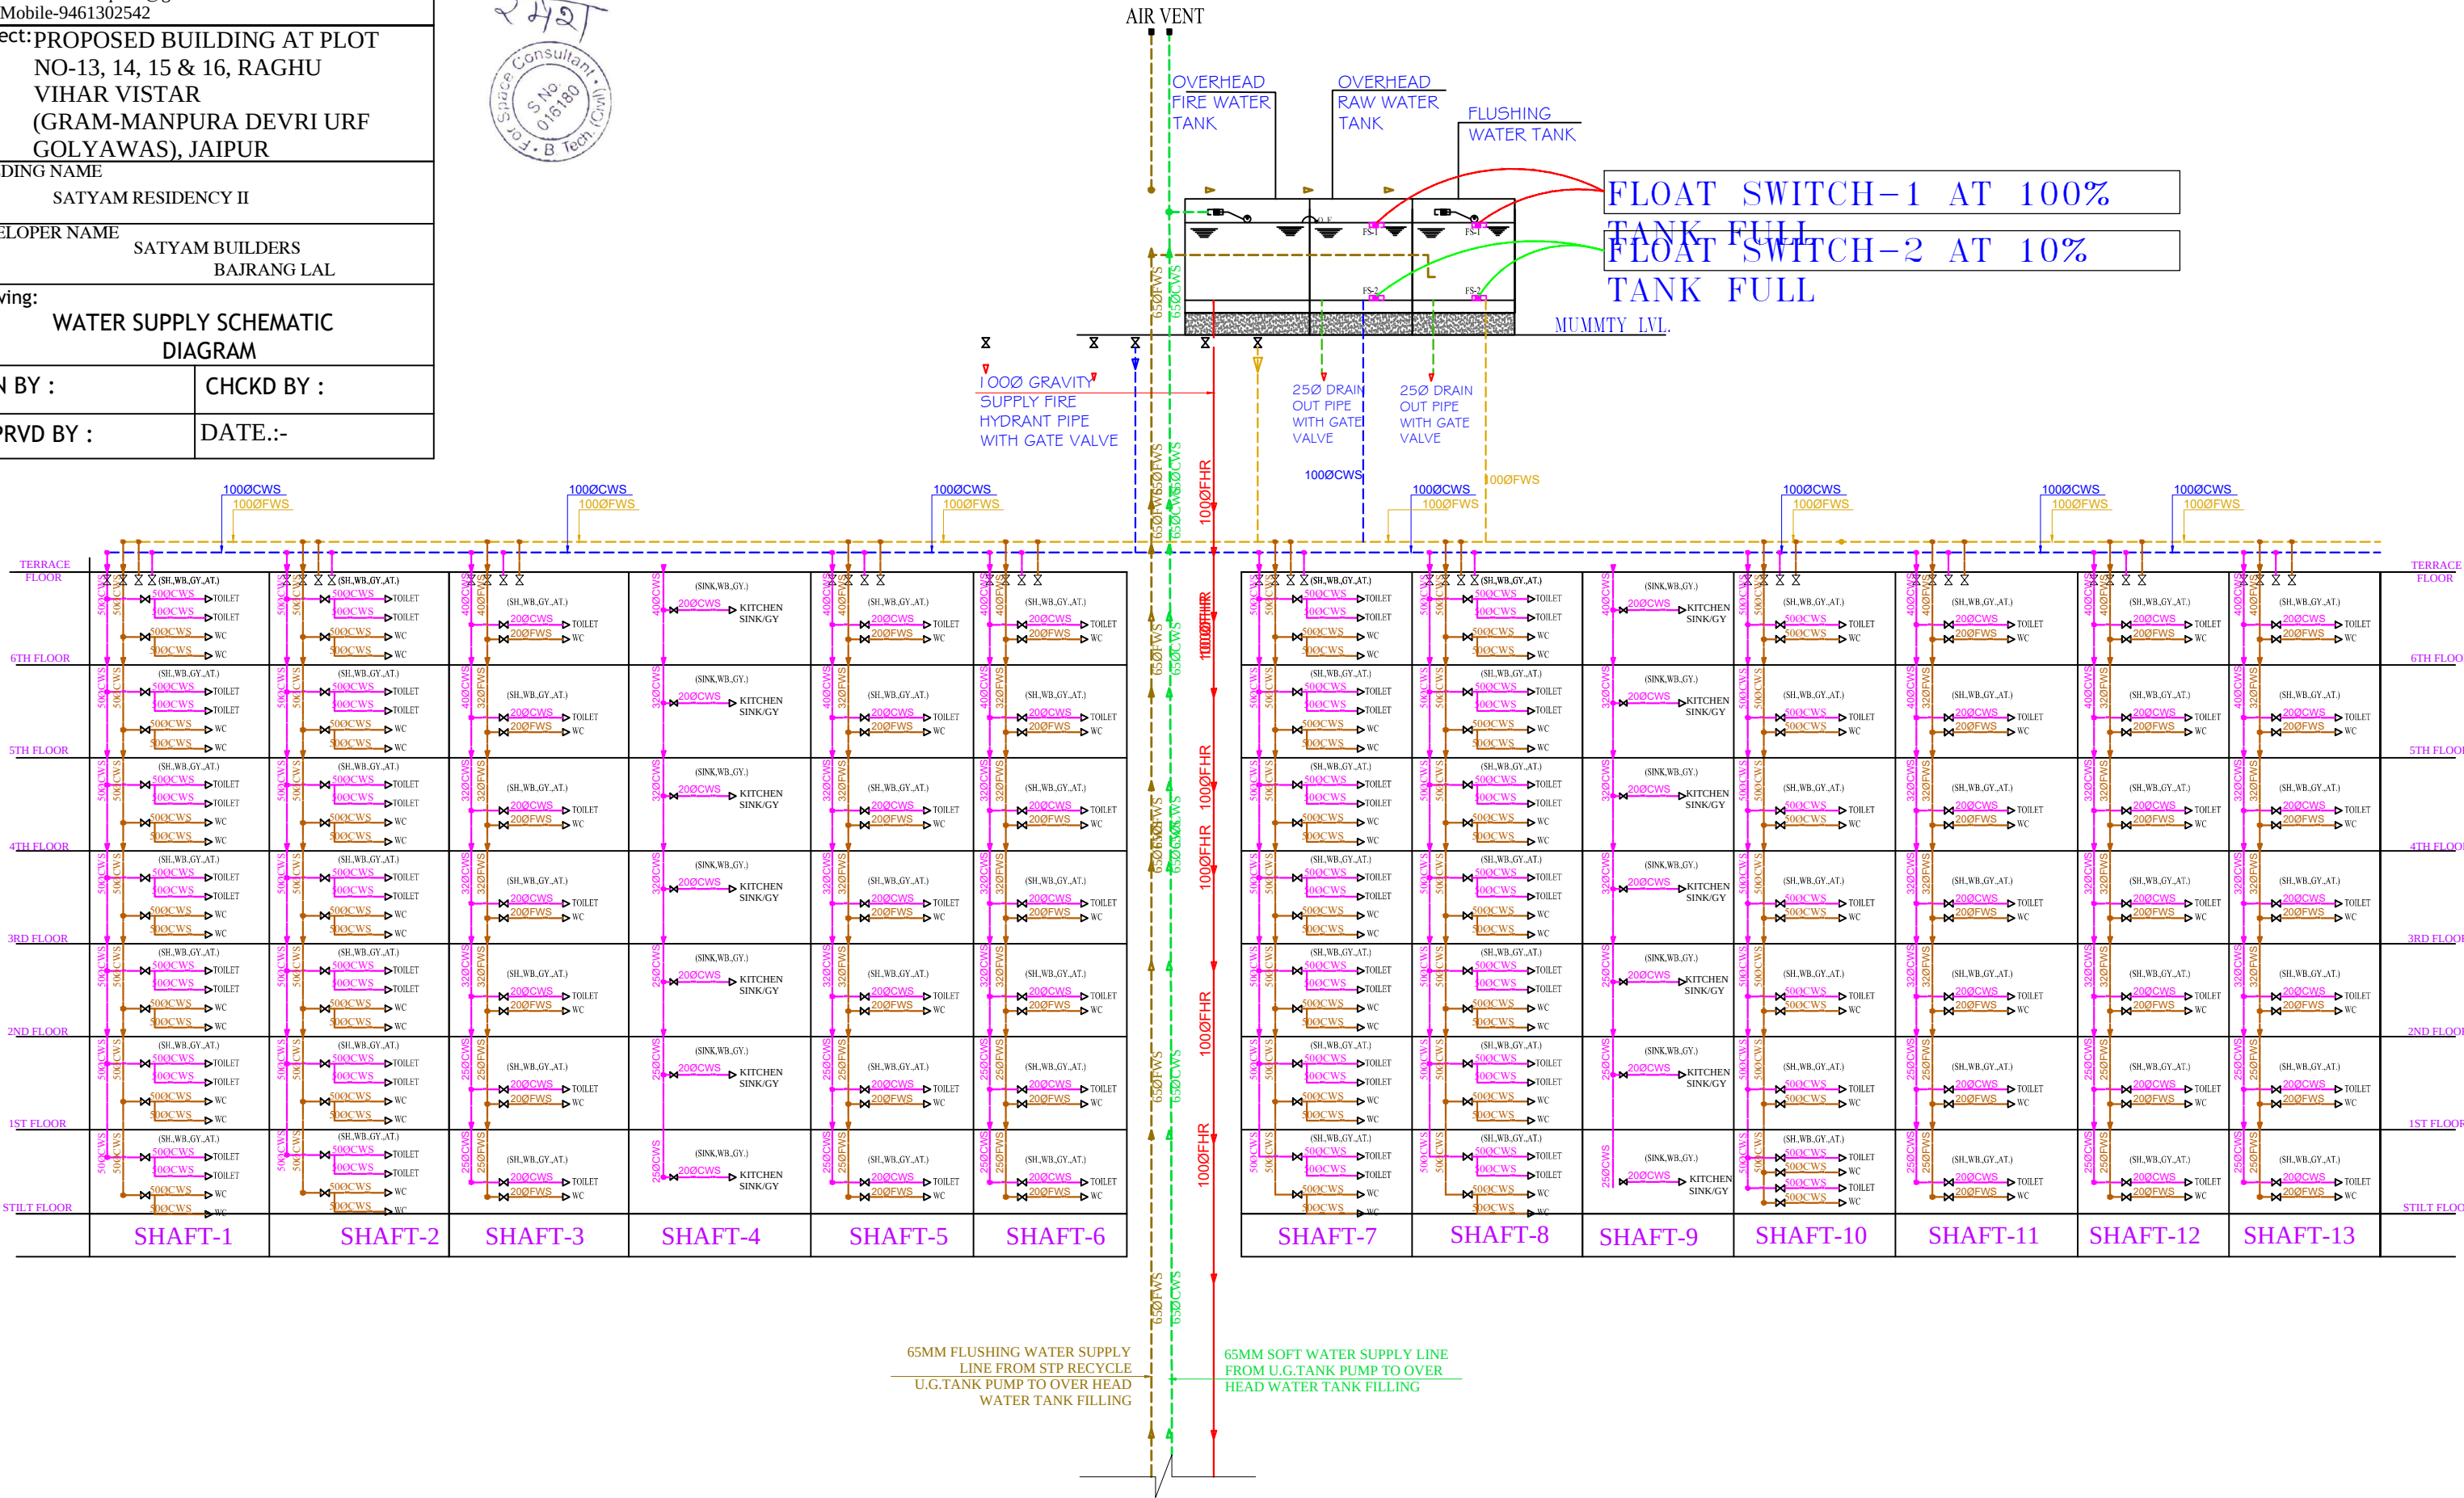

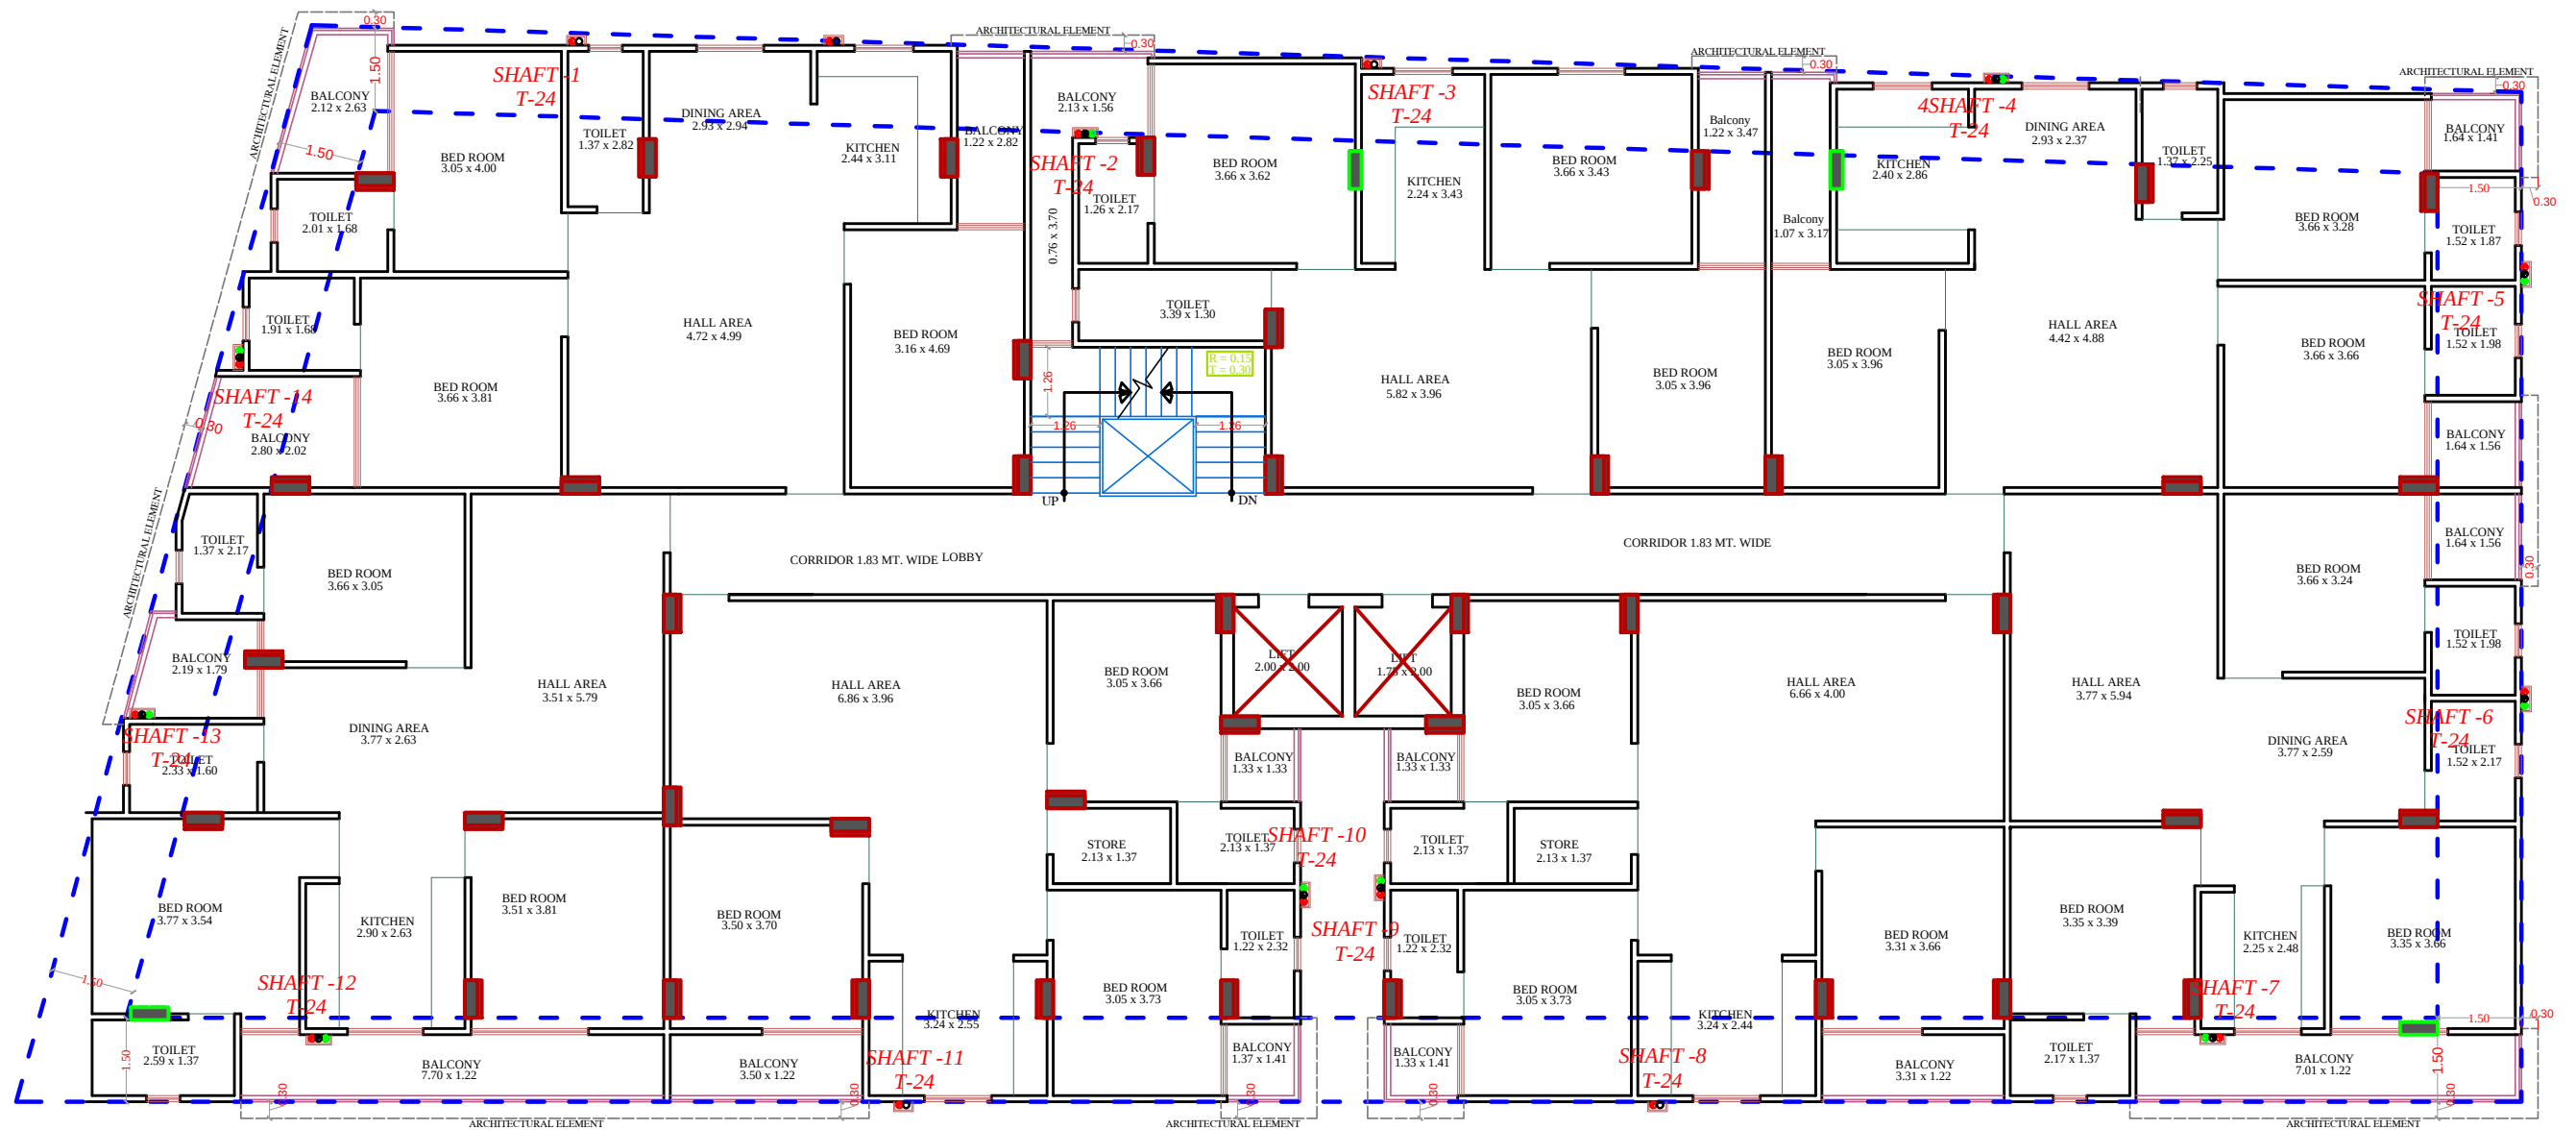

SHAFT MARKING KEY PLAN



SERVICES CONSULTANT:
PLOT-A-173, JAGDAMBA NAGAR ,HEERAPURA
POWER HOWER ,JAIPUR (RAJ) 302024

ARCHITECTS:-
FRANK SQUARE
ARCHITECTURE | PLANNER | DESIGNER
C-49 VIDYA APARTMENT PARAS MARG,
BAPU NAGAR JAIPUR, (RAJ.)
Email-afranksquare@gmail.com
Mobile-9461302542

Project: PROPOSED BUILDING AT PLOT
NO-13, 14, 15 & 16, RAGHU
VIHAR VISTAR
(GRAM-MANPURA DEVRI URF
GOLYAWAS), JAIPUR

BUILDING NAME
SATYAM RESIDENCY II

DEVELOPER NAME
SATYAM BUILDERS
BAJRANG LAL

Drawing:
WATER SUPPLY SCHEMATIC
DIAGRAM

DRN BY : CHCKD BY :

APPRVD BY : DATE:-