


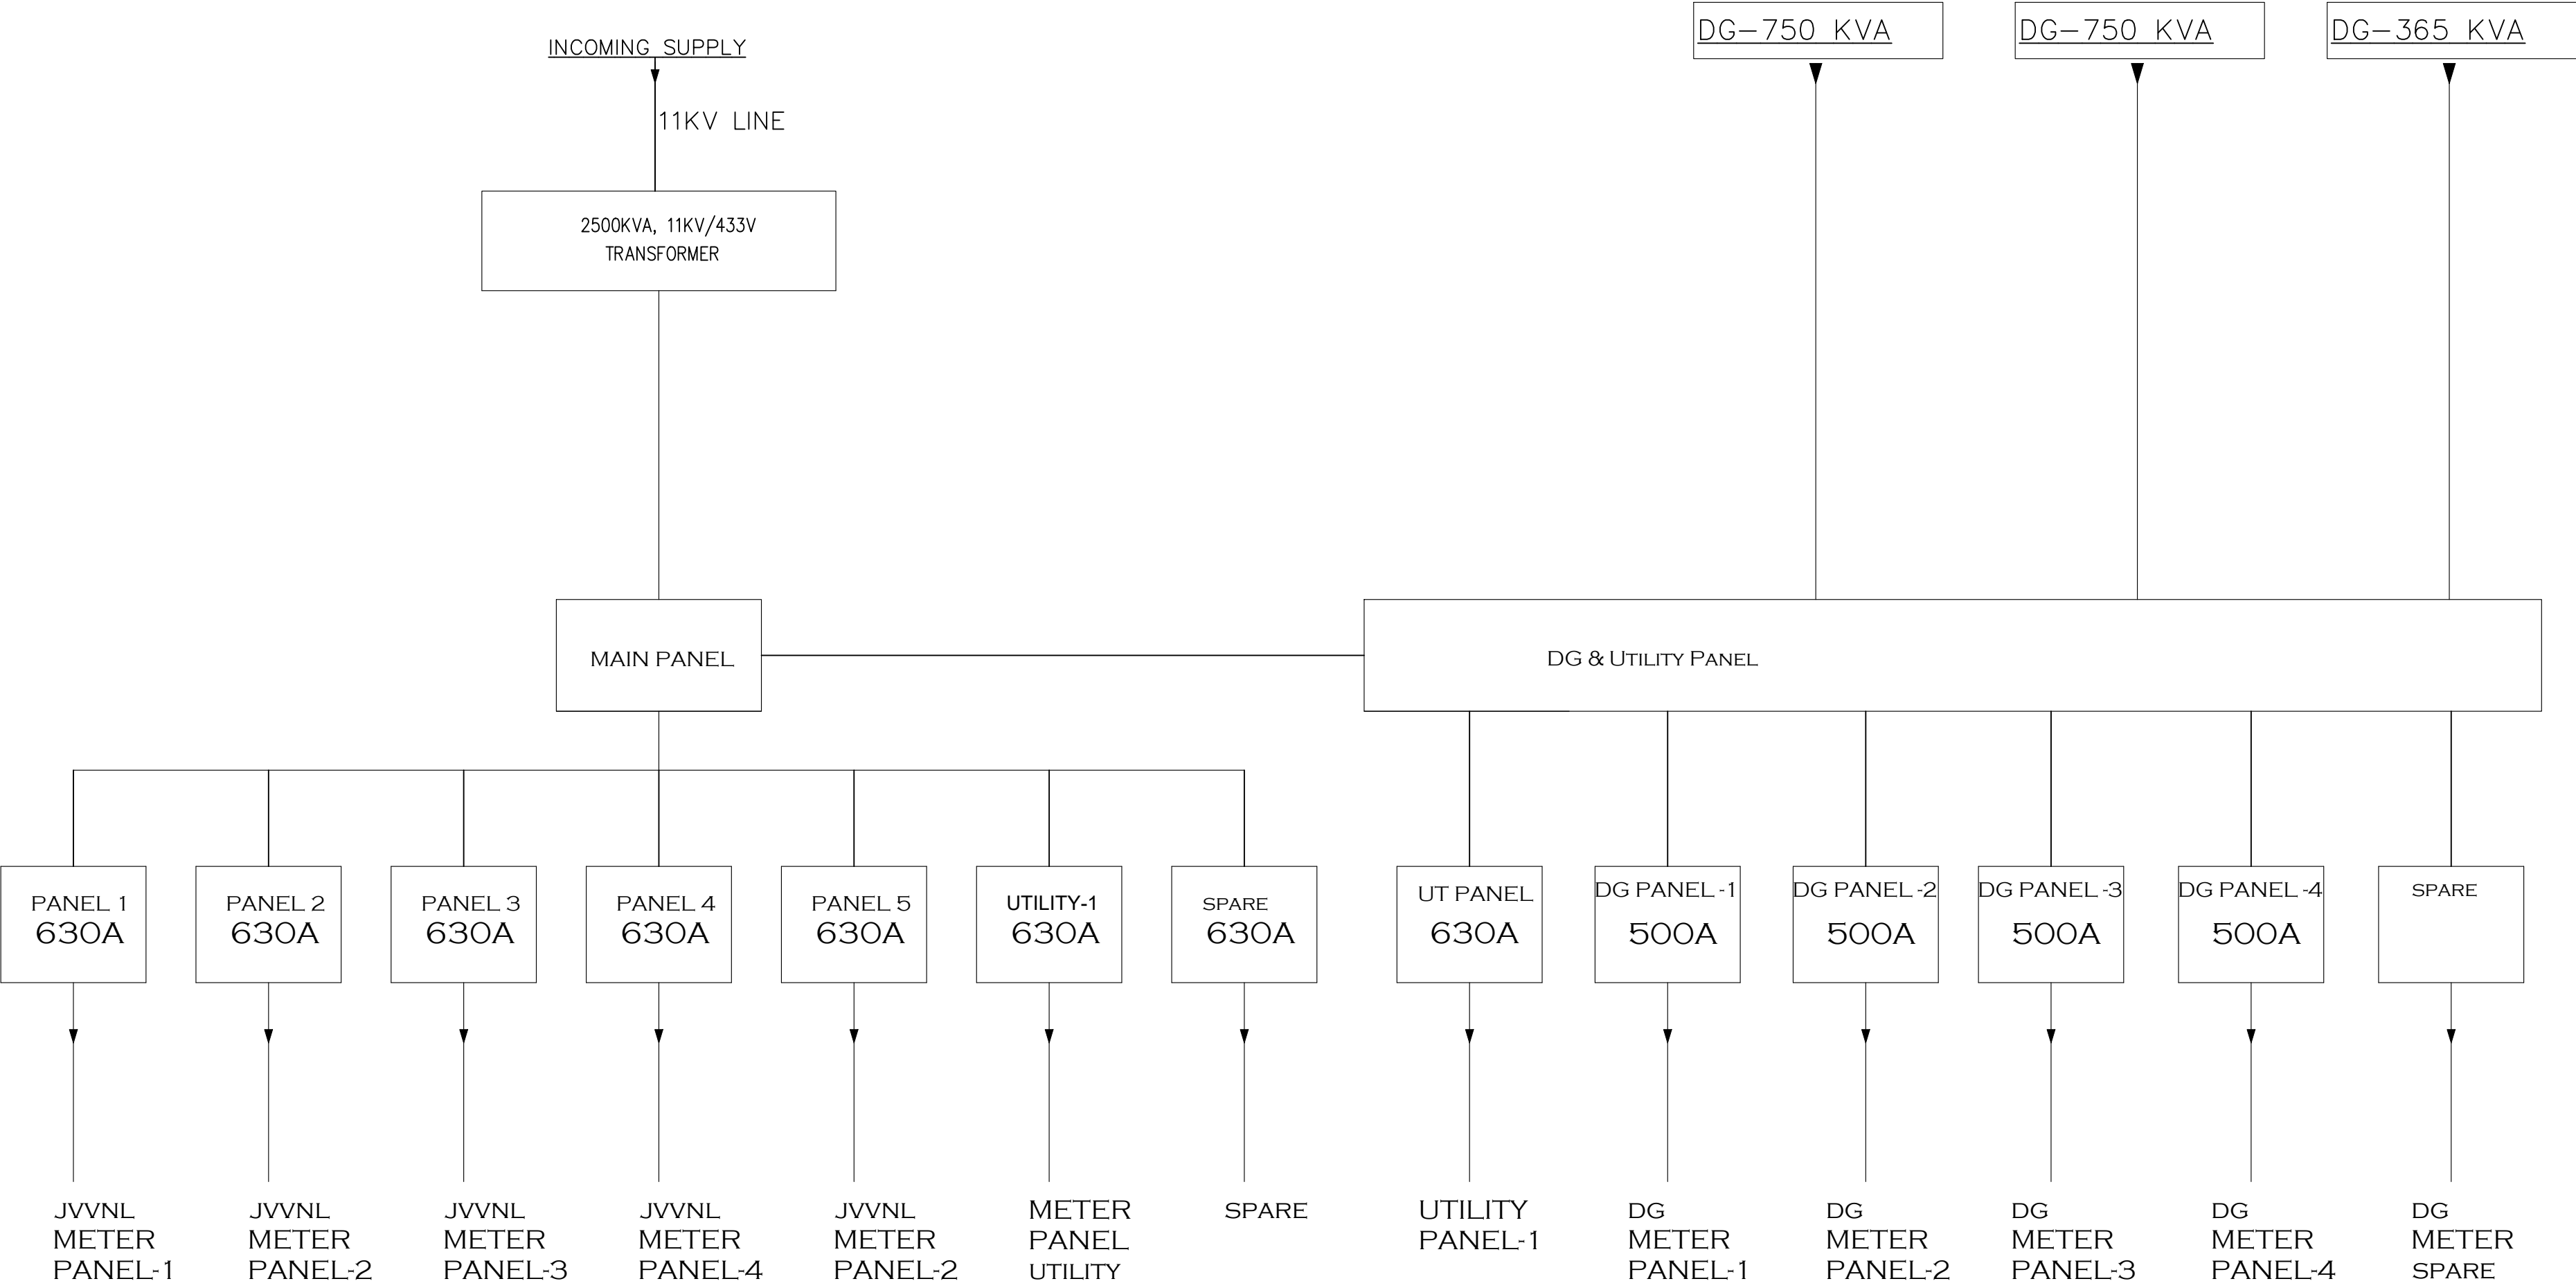

NOTE
1. GA DRAWING OF THE PANEL SHOULD BE GOT APPROVED FROM THE CONSULTANT BEFORE EXECUTION.
2. FOR MCCB ALL BREAKING VALUE ARE Ics VALUES.

Praveen
PRAVEEN KUMAR
BTECH (ELECT)

**PROPOSED COMMERCIAL BUILDING
AT PLOT NO. 26 .
SCHEME FATEH TIBA INDUSTRIAL
AREA, ADARSH NAGAR**

SUBMISSION DRAWING
SCALE :- 1 : 100

NORTH-

**DRAWING TITLE -
ELECTRICAL SLD LAYOUT**

OWNER

ARCHITECT

ROAD 40'-0" WIDE


ROAD 60'-0" WIDE



ROAD 100'-0" WIDE

LOWER BASEMENT FLOOR PLAN

TOTAL AVAILABLE NO. OF CAR PARKING = 87 SURFACE +21 MECHANICAL
TOTAL AVAILABLE TW. PARKING = 81 TWO WHEELERS

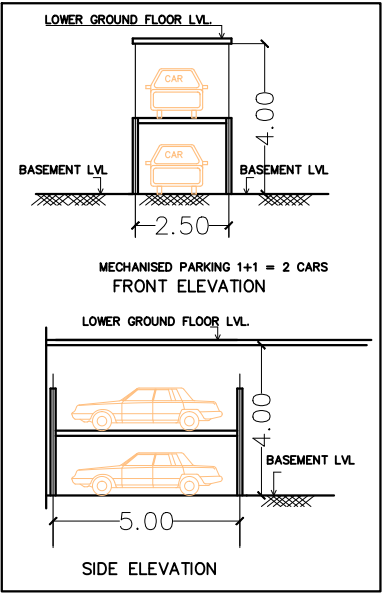

LEGEND			
NO	DESCRIPTION	SYMBOL	FROM FFL
1.	CEILING LIGHT		CEILING
2.	SWITCH BOARD WITH OUT 6 AMP POINT		4'-0"
3.	40W TUBE LIGHT ON CEILING		CEILING
4.	16 AMP POWER PLUG POINT(GENERAL)		AS PER SITE
5.	BULKHEAD FOR RAMP		2'-6"

Praveen
PRAVEEN KUMAR
BTECH (ELECT)

PROPOSED COMMERCIAL BUILDING
AT PLOT NO. 26.
SCHEME FATEH TIBA INDUSTRIAL
AREA, ADARSH NAGAR

SUBMISSION DRAWING
SCALE :- 1 : 100



NORTH:-



DRAWING TITLE -
LOWER BASEMENT ELECTRICAL LAYOUT

OWNER

ARCHITECT

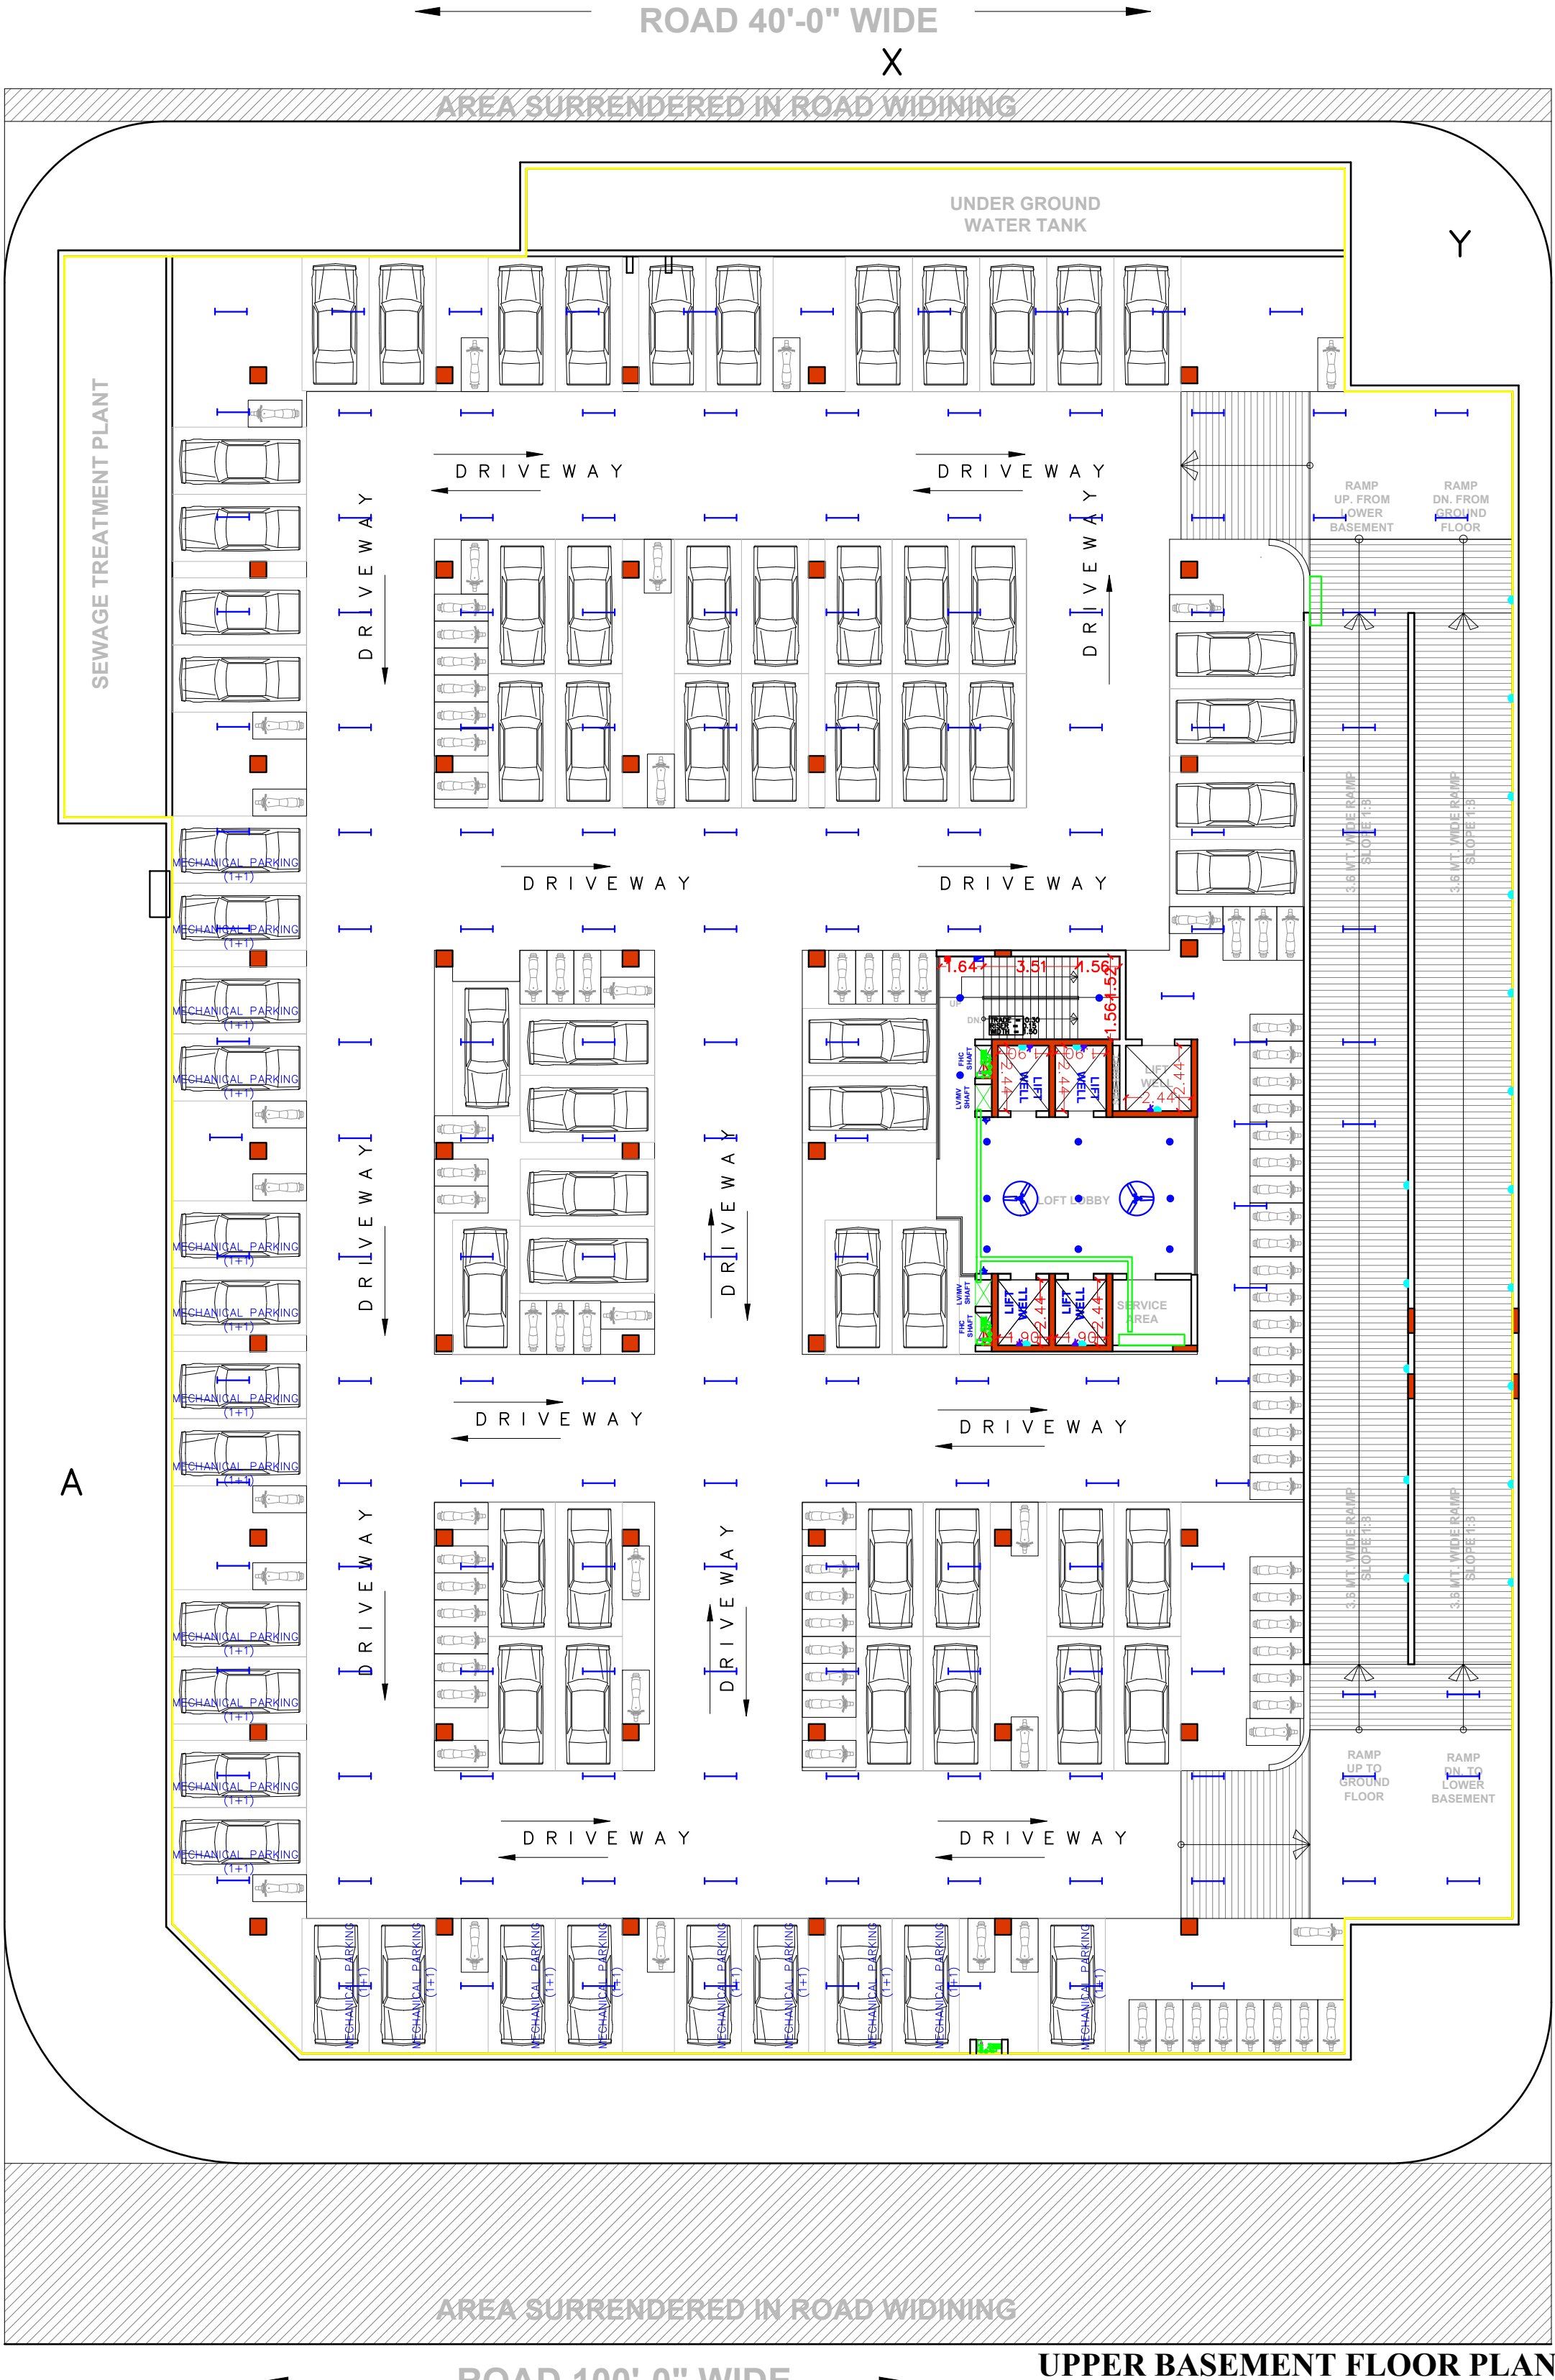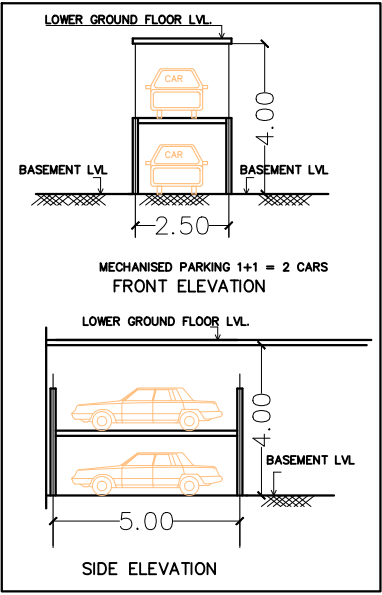

LEGEND			
NO	DESCRIPTION	SYMBOL	FROM FFL
1.	CEILING LIGHT		CEILING
2.	SWITCH BOARD WITH OUT 6 AMP POINT		4'-0"
3.	40W TUBE LIGHT ON CEILING		CEILING
4.	16 AMP POWER PLUG POINT(GENERAL)		AS PER SITE
5.	BULKHEAD FOR RAMP		2'-6"

Praveen
PRAVEEN KUMAR
BTECH (ELECT)

PROPOSED COMMERCIAL BUILDING
AT PLOT NO. 26.
SCHEME FATEH TIBA INDUSTRIAL
AREA, ADARSH NAGAR

SUBMISSION DRAWING
SCALE :- 1 : 100

NORTH:-


DRAWING TITLE -
UPPER BASEMENT ELECTRICAL LAYOUT

OWNER

ARCHITECT

TOTAL AVAILABLE TW. PARKING = 99 TWO WHEELERS

PROPOSED OVERHEAD
WATER TANK@ MUMTY LVL.
FIRE WATER TANK – 20 KL
DOM. WATER TANK – 25 KL
FLU. WATER TANK – 20 KL

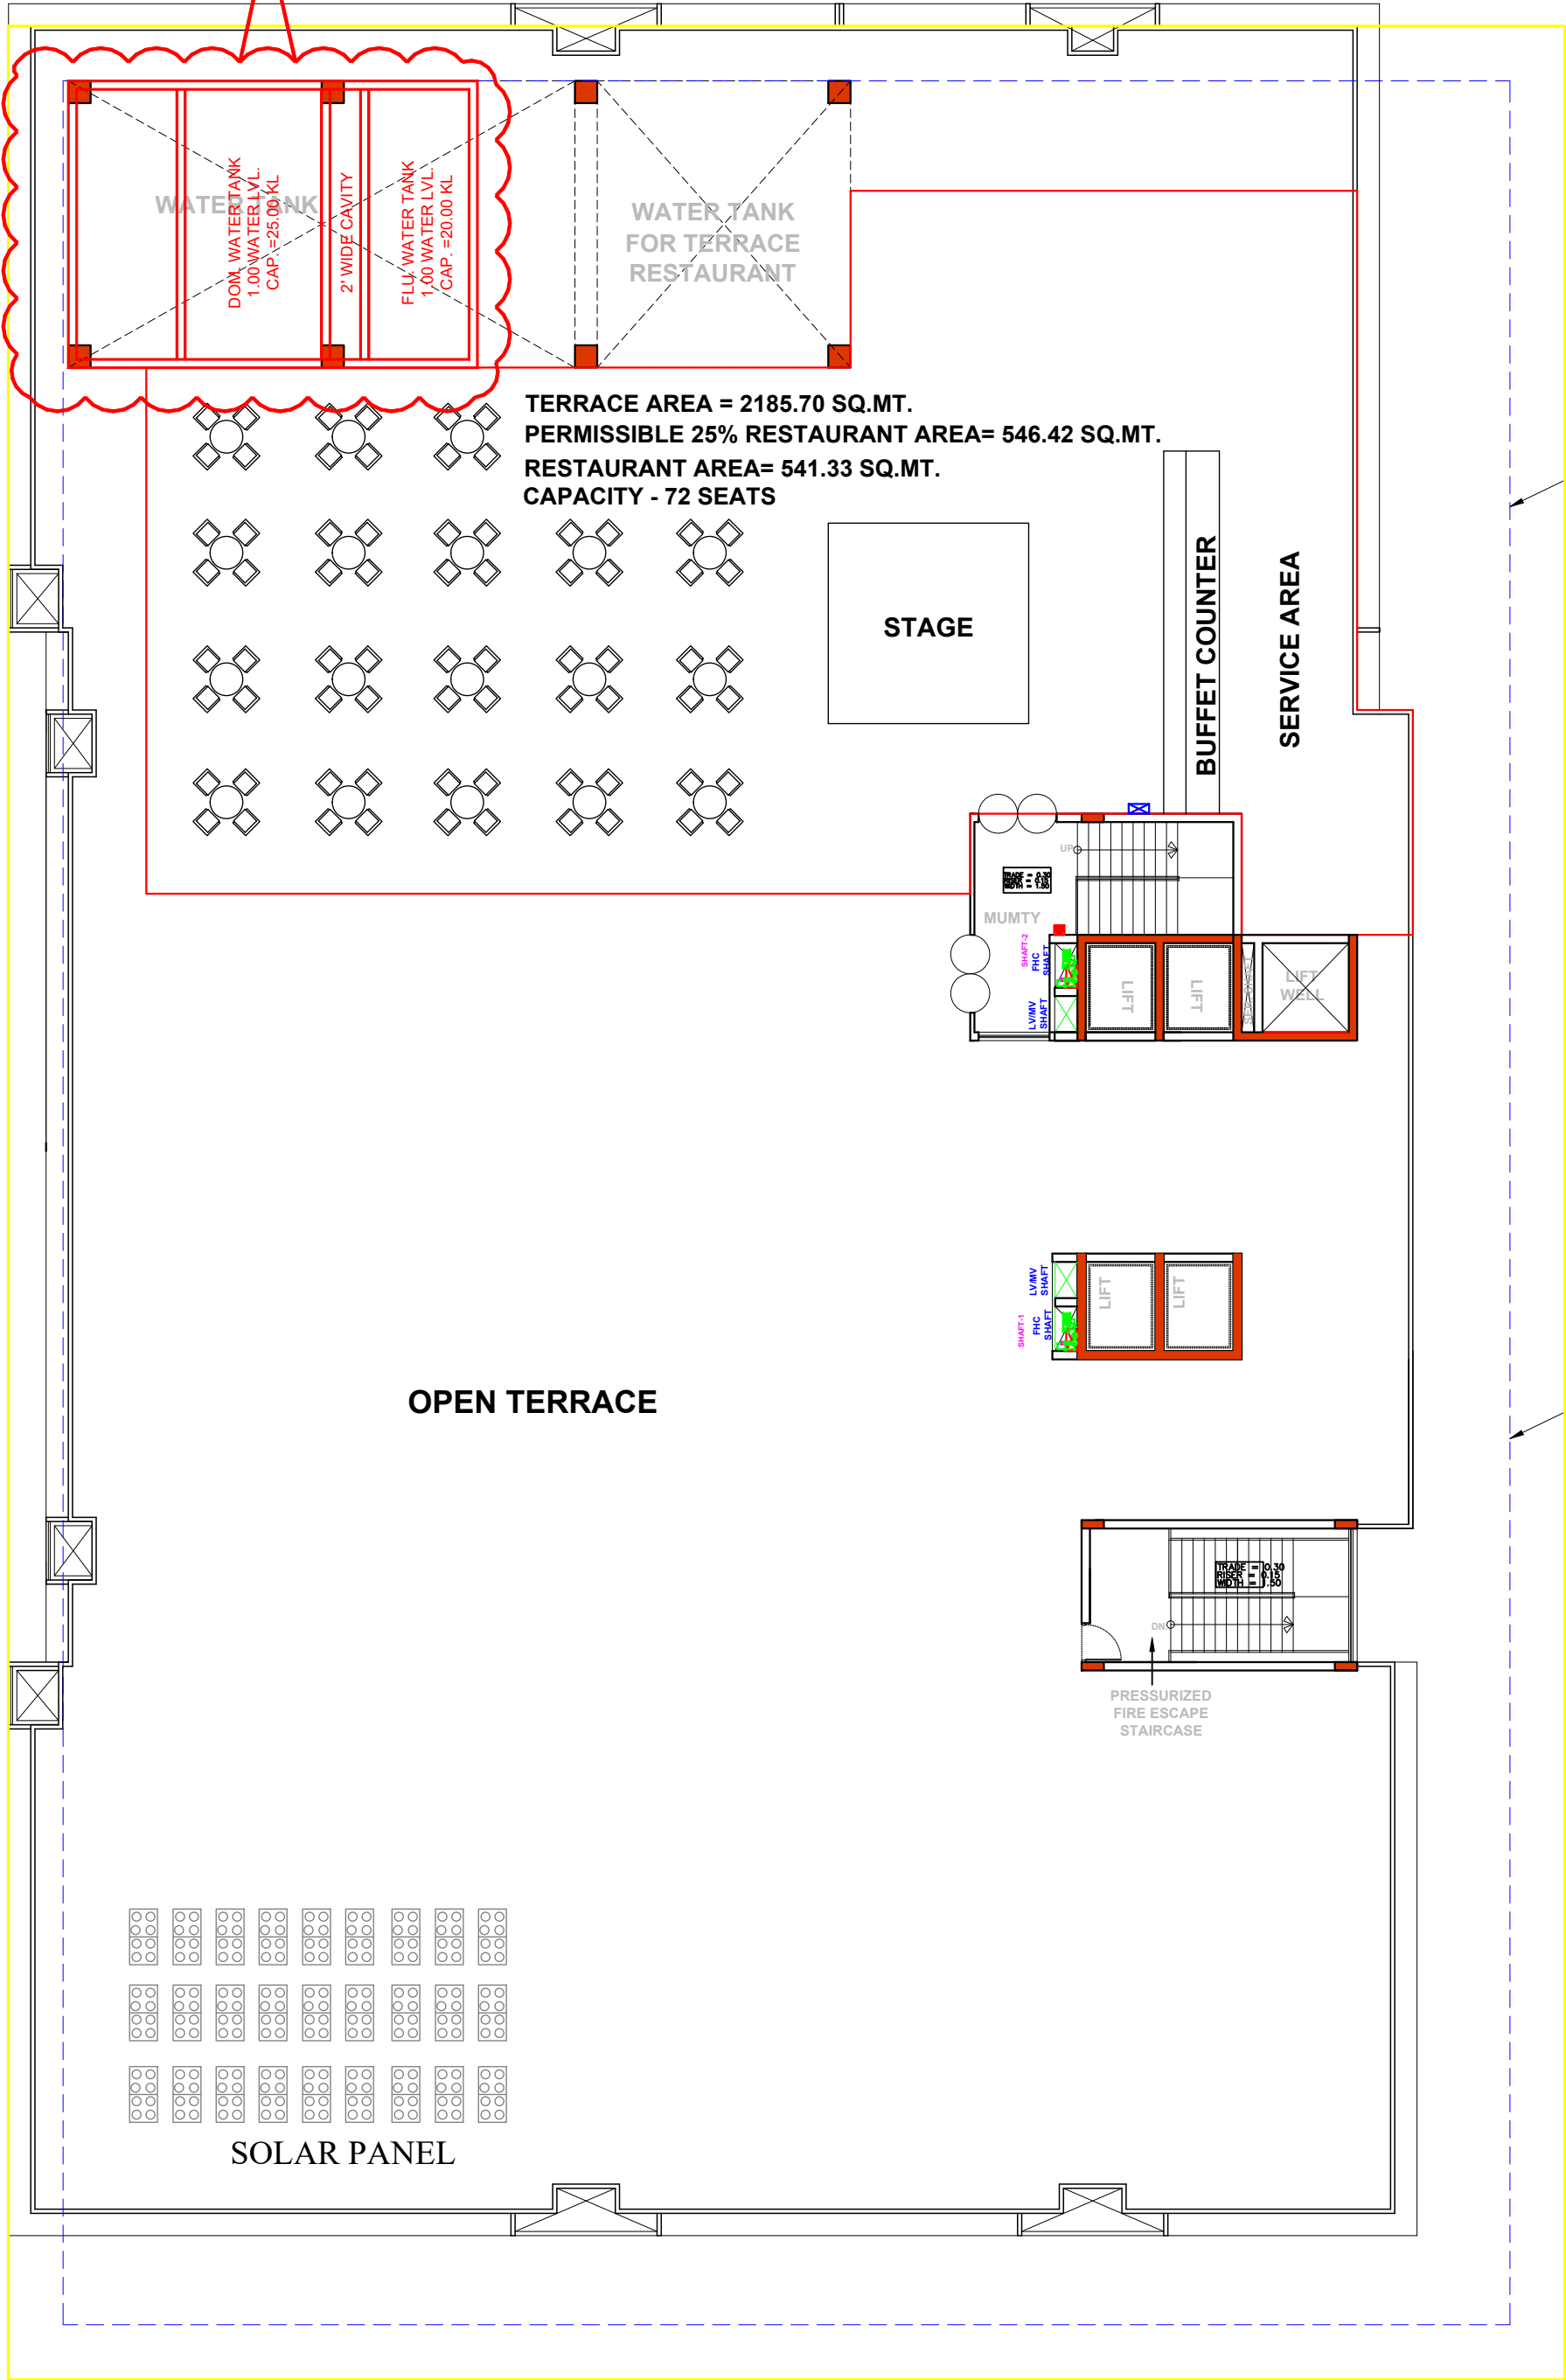

TERRACE FLOOR PLAN

LEGEND			
NO	DESCRIPTION	SYMBOL	FROM FFL
1.	CEILING FAN		CEILING
2.	A C POINT(WINDOW AC)		1'-0"
3.	25A POINT		AS PER SITE
4.	3 PHASE POINT		AS PER SITE
5.	A C SOCKET		AS PER SITE
6.	16 AMP POWER PLUG POINT(GENERAL)		1'-0"
7.	2 NOS 6 AMP POWER PLUG POINT (FOR TV)		1'-6"/4'-6"
8.	6 AMP PLUG POINT (GENERAL)		1'-0"
9.	SWITCH BOARD WITH OUT 6 AMP POINT		4'-0"
10.	SWITCH BOARD WITH 6 AMP POINT		4'-0"
11.	TELEPHONE POINT (GENERAL)		1'-0"
12.	LAN POINT		2'-6"
13.	40W TUBE LIGHT ON CEILING		CEILING
14.	BULB HOLDER ON SIDE WALL		7'-0"
15.	TUBE LIGHT ON WALL		7'-0"
16.	BULKHEAD FOR RAMP		2'-6"
17.	DISTRIBUTION BOX		5'-0"
18.	MANUAL CALL POINT	MCP	01 Nos
19.	HOOTER	HOOTER	01 Nos

Praveen
PRAVEEN KUMAR
BTECH (ELECT)

PROPOSED COMMERCIAL BUILDING
AT PLOT NO. 26 .
SCHEME FATEH TIBA INDUSTRIAL
AREA, ADARSH NAGAR

SUBMISSION DRAWING
SCALE :- 1 : 100

NORTH:-



DRAWING TITLE -
TERRACE FLOOR ELECTRICAL LAYOUT

OWNER

ARCHITECT